


**BNPM/NCB/389/CISF
INFRA-BUILDINGS
/2025-26 Dtd
26.11.2025**

**Bank Note Paper Mill India Private Limited (BNPM)
PMC : M/s Kulkarni Associates, Bangalore
Project: Construction of Infrastructural Buildings for
CISF at Note Mudran Nagar, Mysore.**

Volume -4

VOLUME-4 (Drawings)



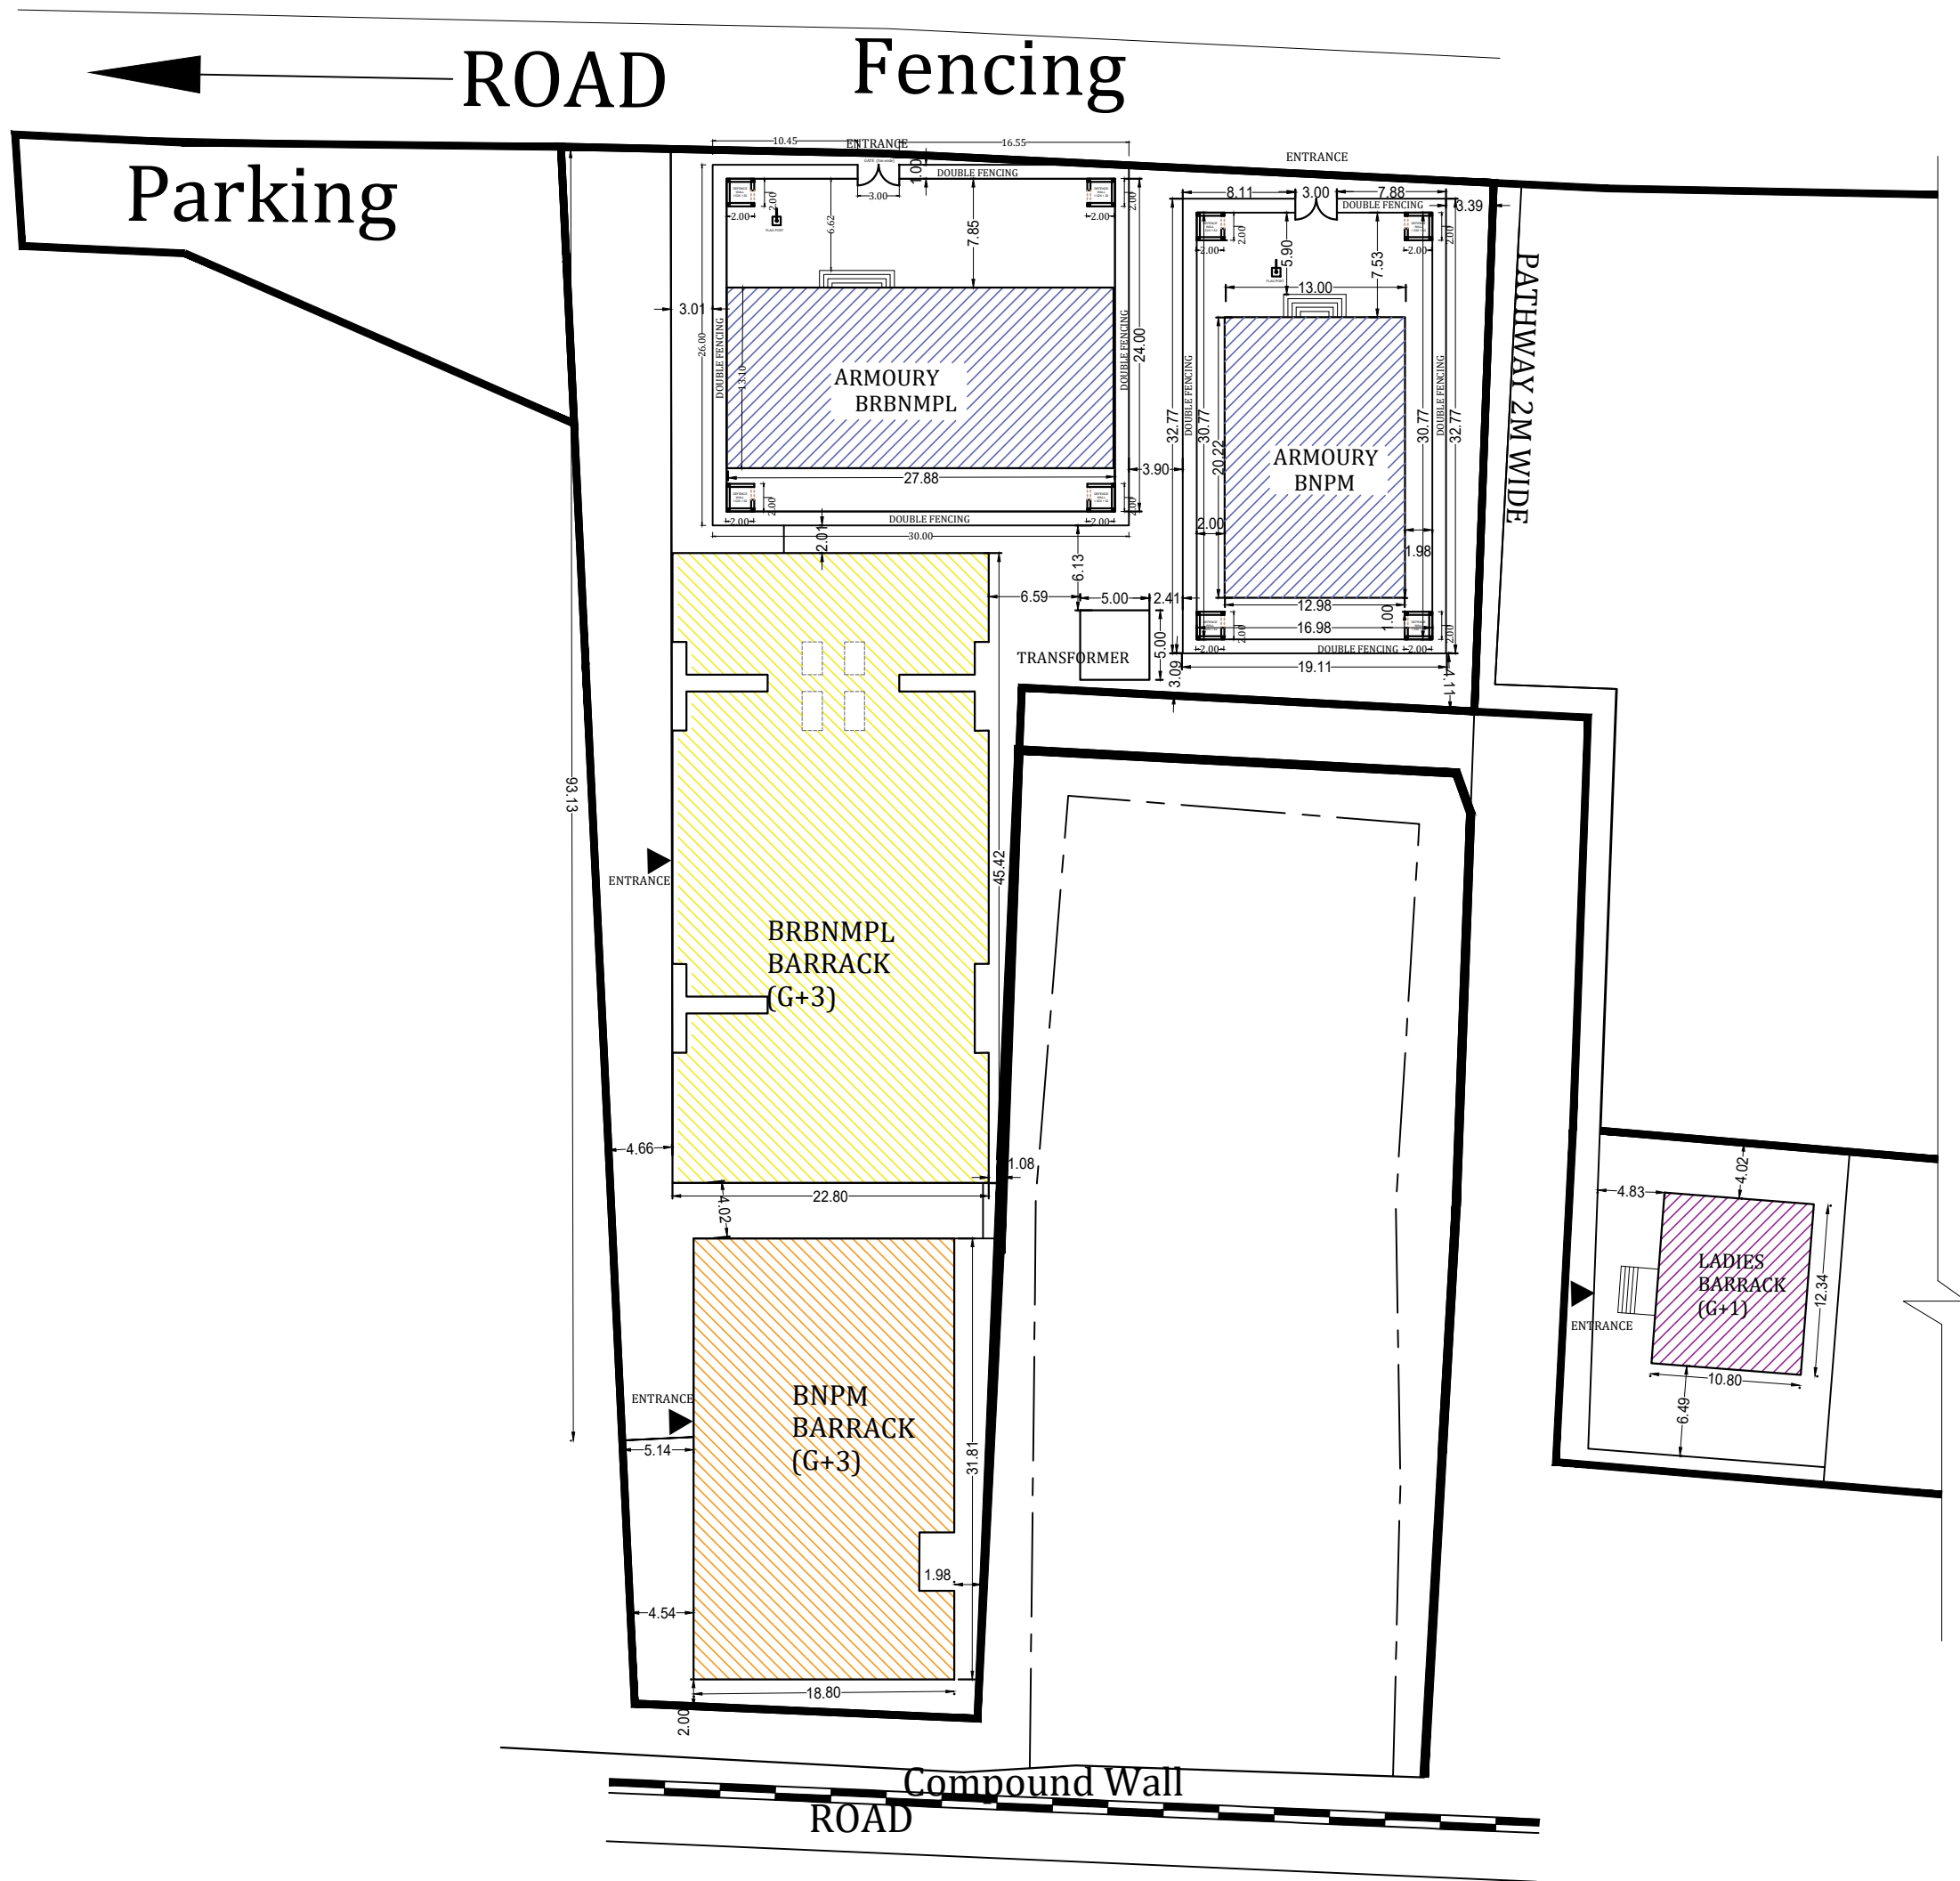

NOTE : ALL DIMENSION IN METERS


PROJECT :
PROVIDING COMPREHENSIVE PROJECT
MANAGEMENT CONSULTANCY SERVICES FOR
PROPOSED CONSTRUCTION OF CISF
INFRASTRUCTURE BUILDINGS
AT NOTE MUDRAN NAGAR MYSORE

SITE LAYOUT (WITH FLOOR PLAN)
TENDER DRAWING


Date : 10-10-2025	Drawn by: LAKSHMI
Scale : NTS	Checked by: Ar. Kavitha
Rev Date:	




ARCHITECTS :
KULKARNI ASSOCIATES
Surya Prema Building, next to Adiga's Restaurant, Kanakapura Road
No-203, 2nd floor, Above Canara bank Raghuvahalli Branch
Raghuvahalli Village, Uttarahalli hobli Bangalore-560062
Email Id : kulkarniassociates@yahoo.com

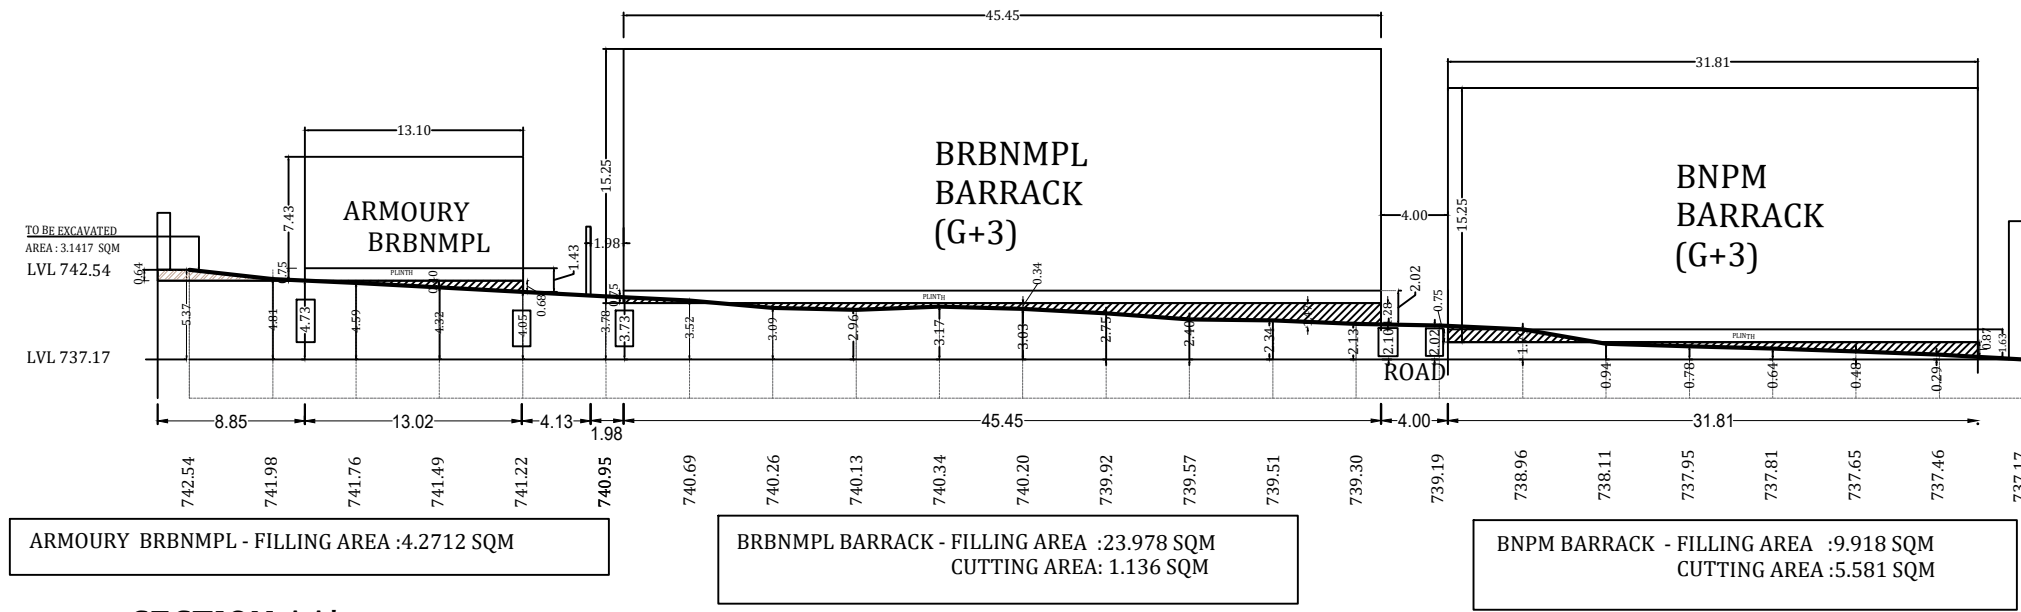


SECTION AA'

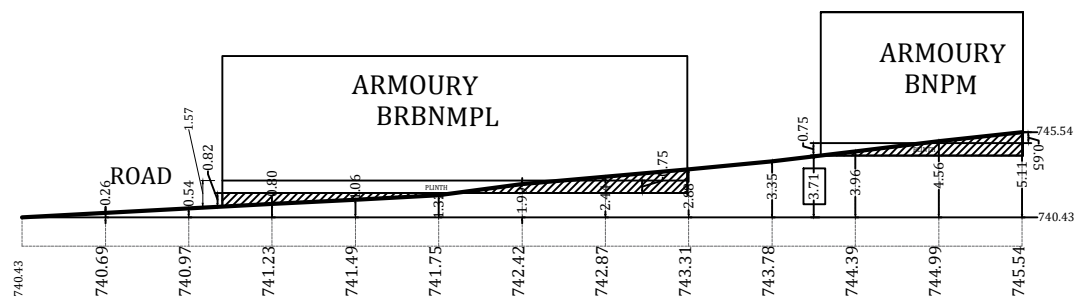


SECTION 01 01'

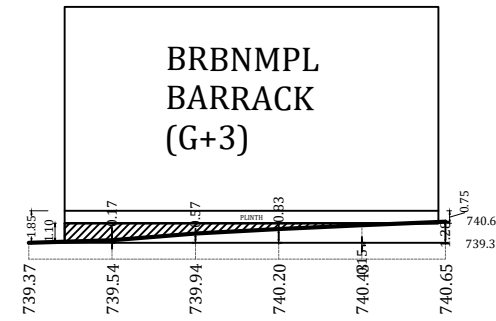


SECTION 02 02'

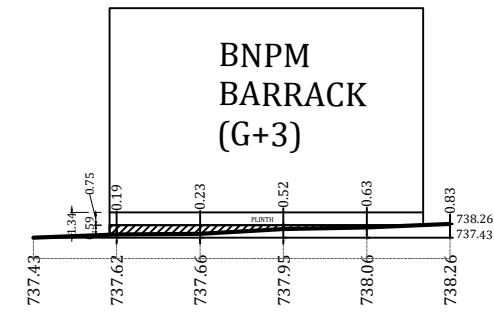


SECTION 03 03'

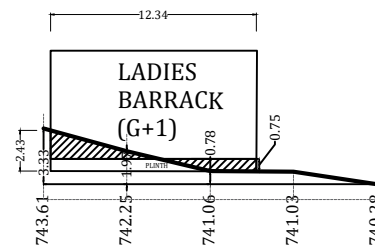


SECTION CC'

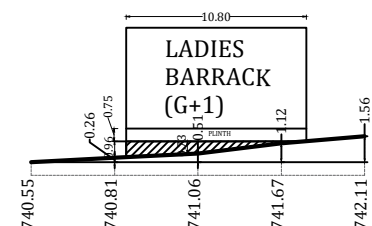


SECTION 04 04'

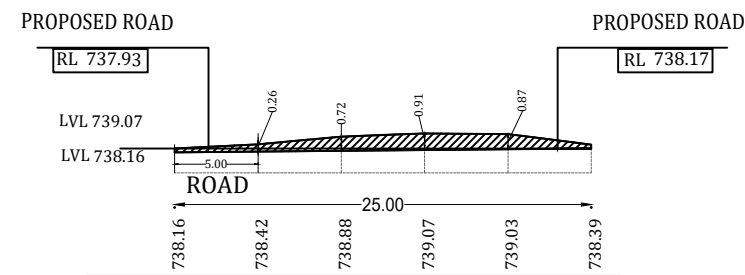


ROAD SECTION 05 05'

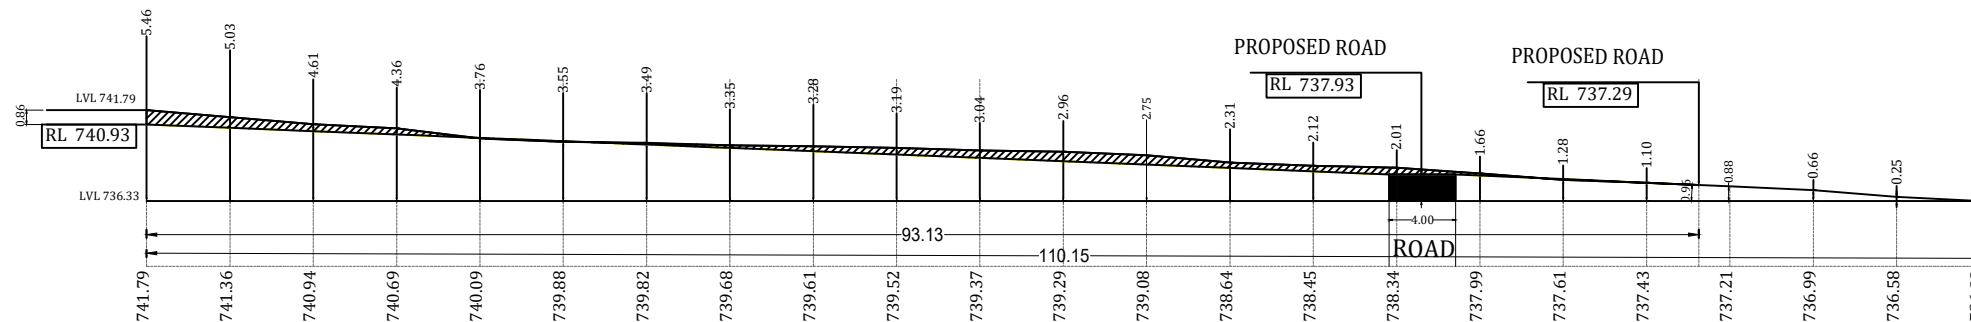

Road section BB'

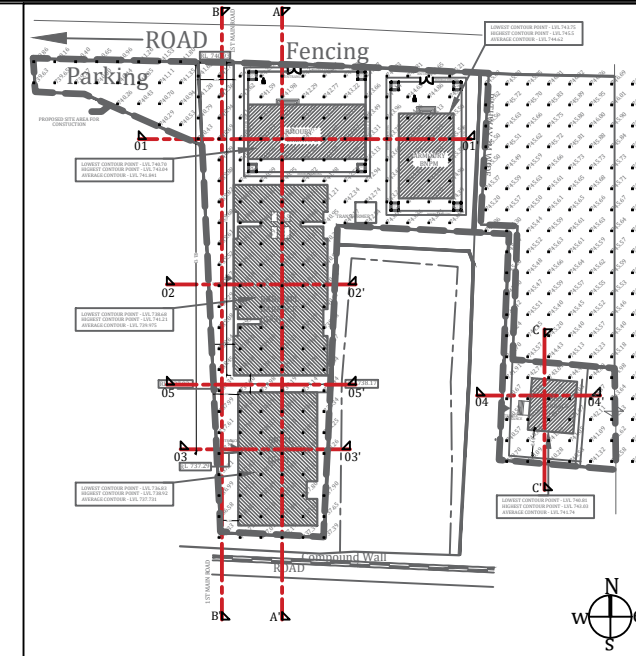

NOTE : ALL DIMENSION IN METERS

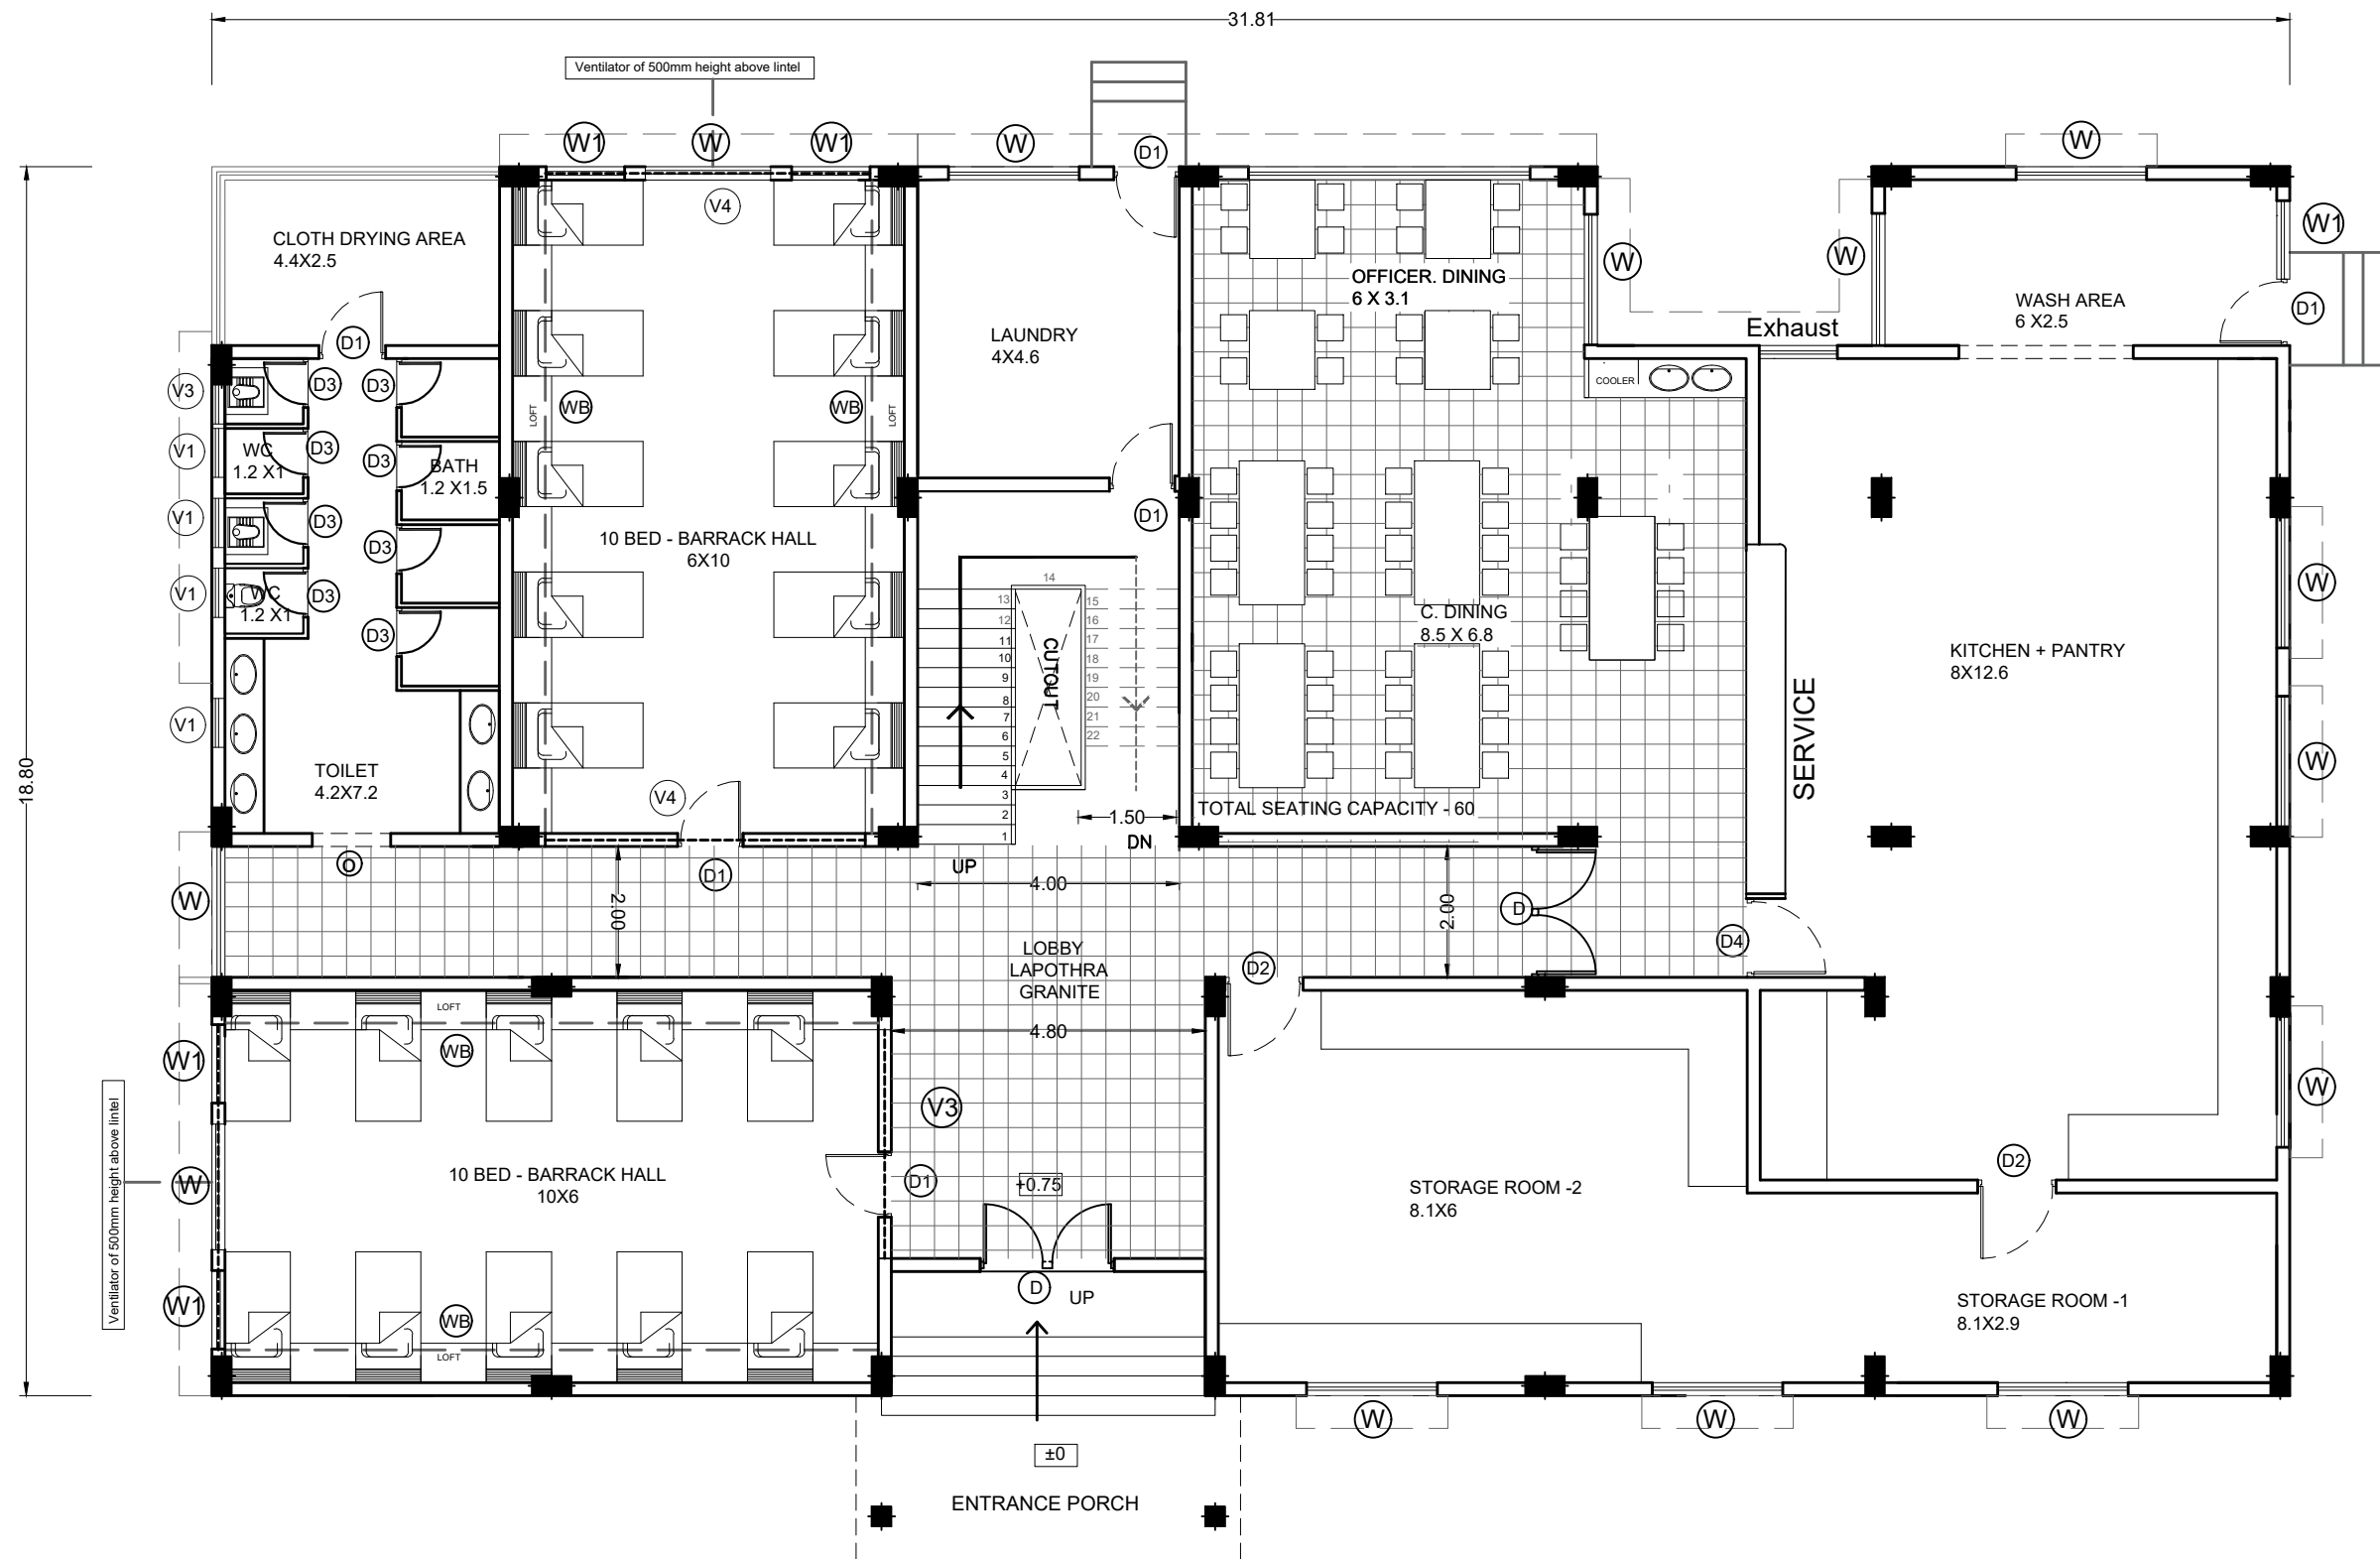

GROUND FLOOR PLAN

TOILET PROPORTION 1:5

LEGEND:
GROUND FLOOR BUILT UP - 589SQM
LIST OF FACILITIES
1. ENTRANCE LOBBY
2. STORAGE ROOM
3. KITCHEN
4. WASH AREA
5. DINING AREA - 60 SEATING
6. BARRACK HALL - 2X10 =20 BEDS
7. WASHROOM - 1X4 TOILET +1X4 BATH
8. STAIRCASE
9. LAUNDRY
10. CLOTH DRYING AREA

NOTE : ALL DIMENSION IN METERS

PROJECT :
PROVIDING COMPREHENSIVE PROJECT
MANAGEMENT CONSULTANCY SERVICES FOR
PROPOSED CONSTRUCTION OF CISF
INFRASTRUCTURE BUILDINGS
AT NOTE MUDRAN NAGAR MYSORE

TENDER DRAWING

Page 5 of 129

BNPM - BARRACK FLOOR PLAN

Date : 10-10-2025

Drawn by: AMRUTHA

Checked by: Ar. Kavitha


Rev Date: -----



ARCHITECTS :
KULKARNI ASSOCIATES

Surya Prema Building, next to Adiga's Restaurant, Kanakapura Road
No-203, 2nd floor, Above Canara bank Raghuvahalli Branch
Raghuvahalli Village, Uttarahalli hobli Bangalore-560062

Email Id : kulkarni.associates@yahoo.com

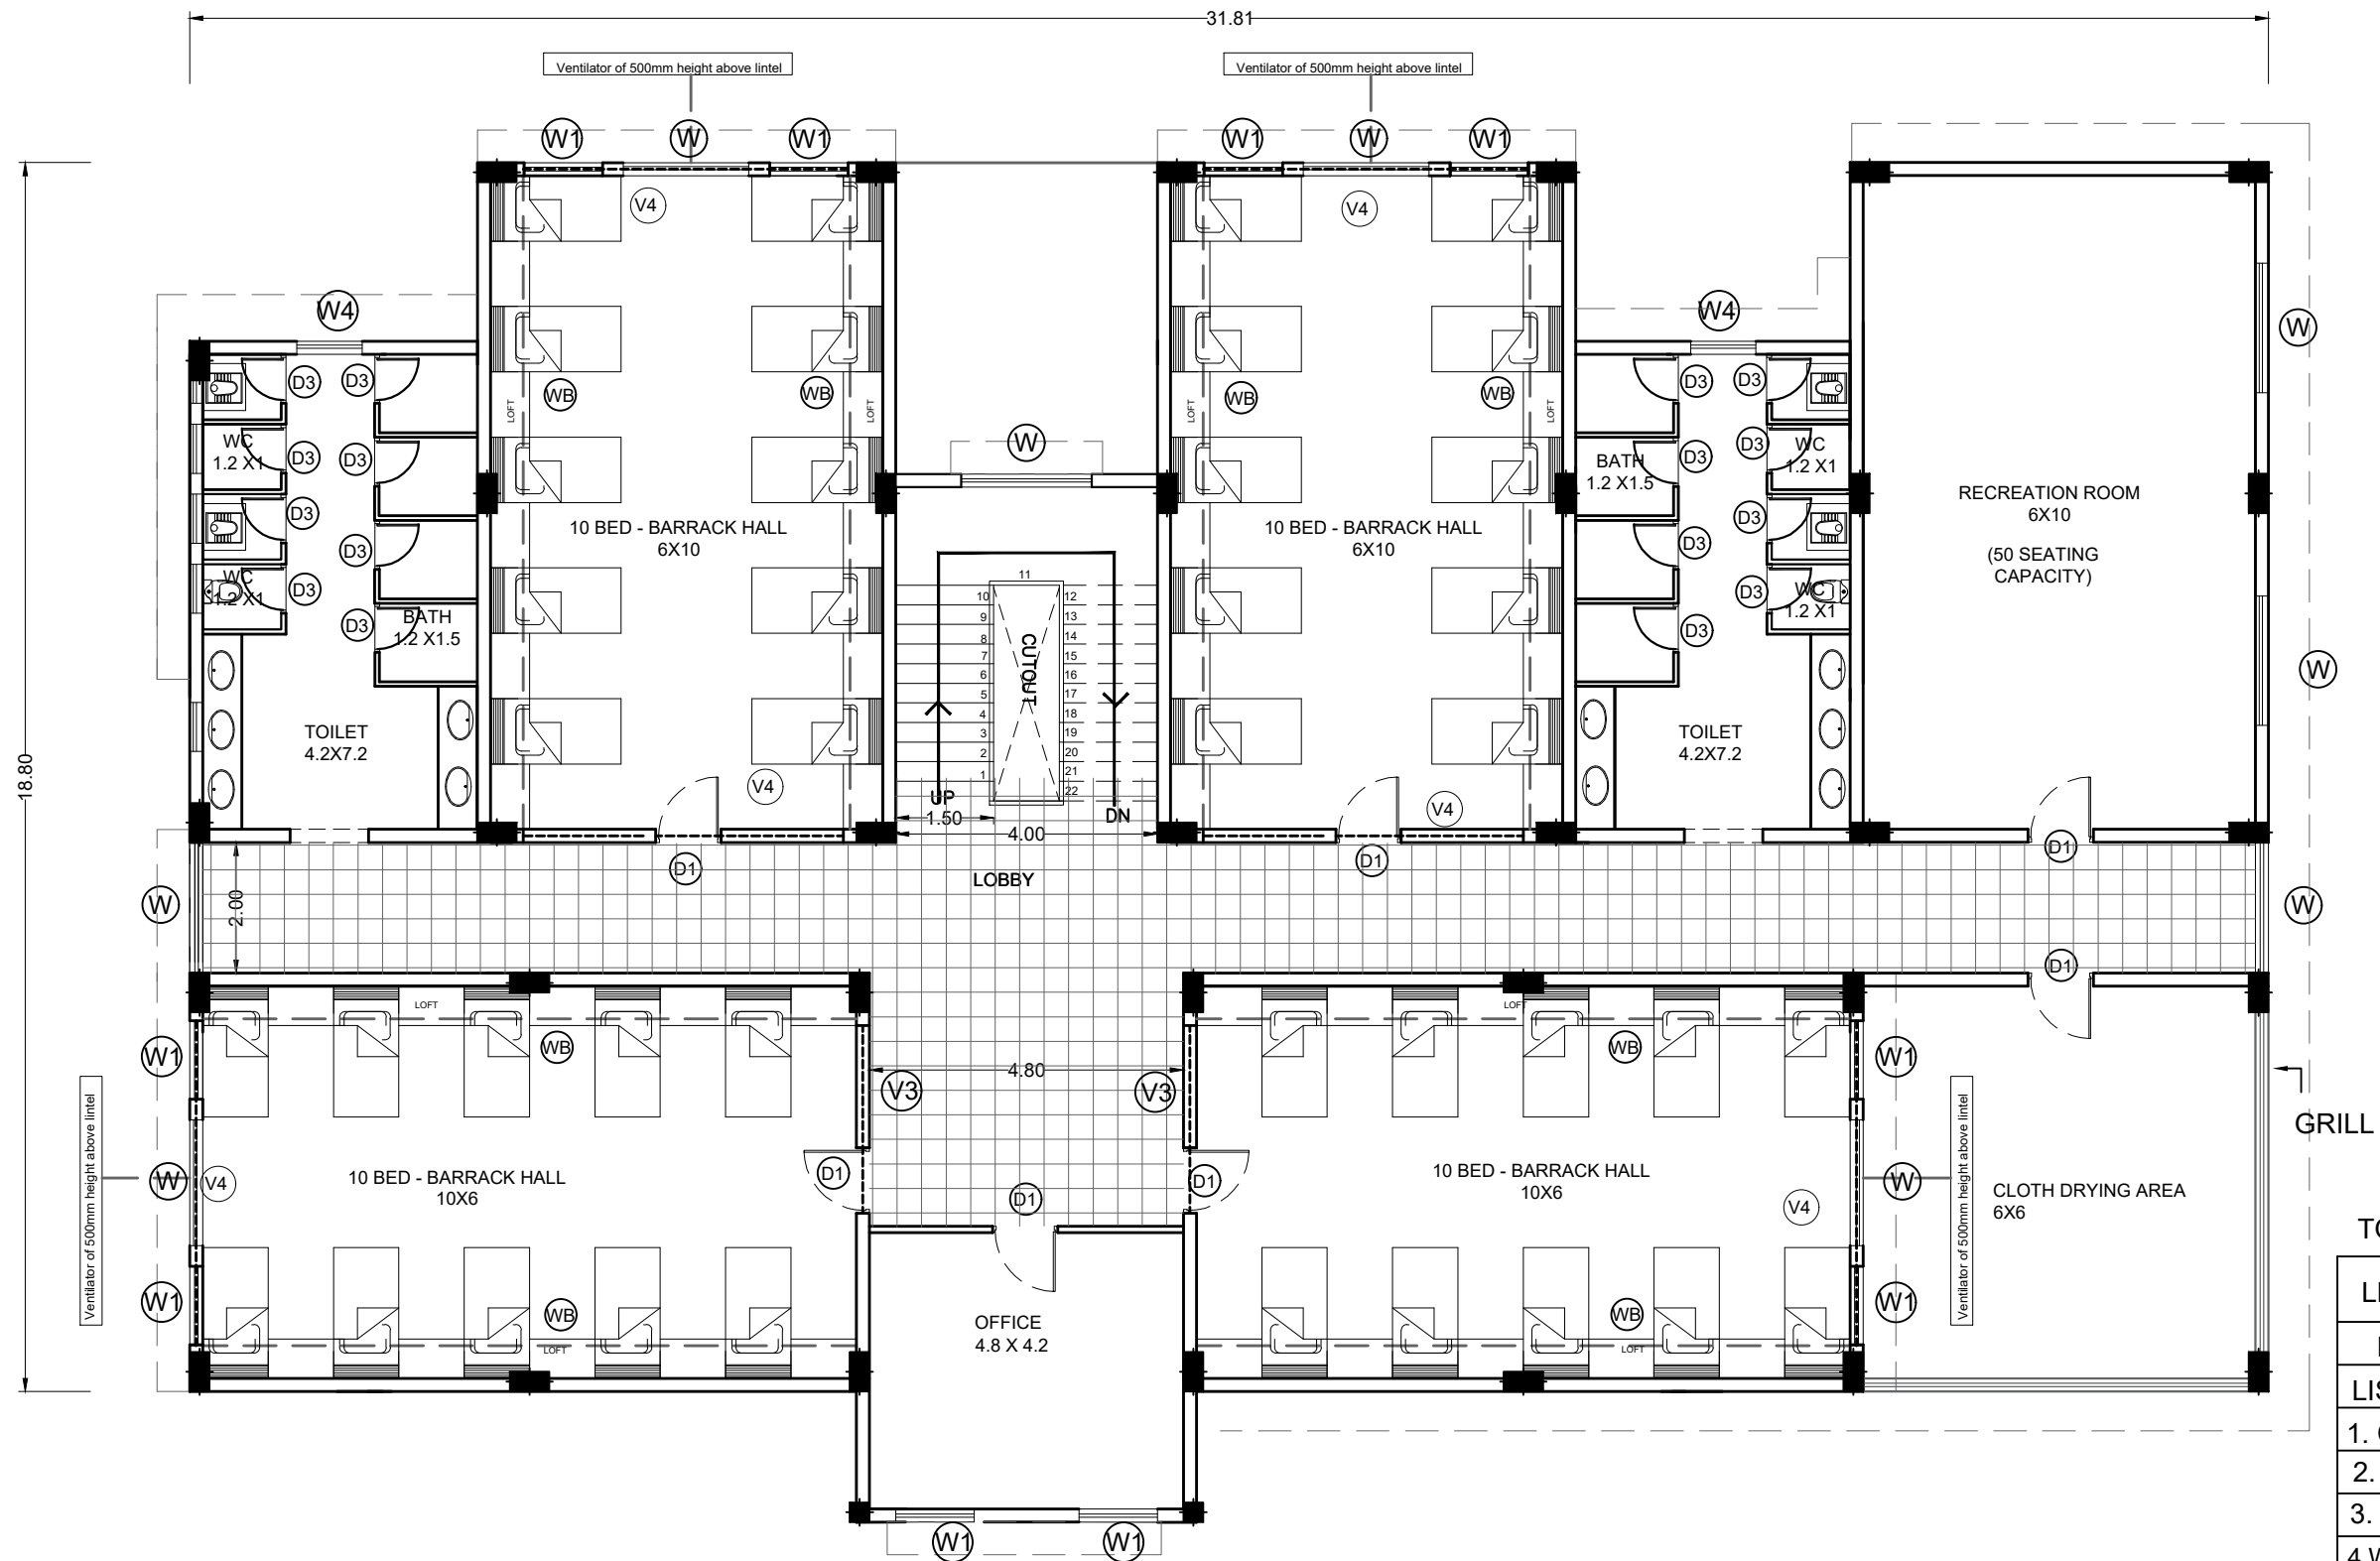

FIRST FLOOR PLAN

TOILET PROPORTION 1:5

LEGEND:

FIRST FLOOR BUILT UP -567SQM
LIST OF FACILITIES
1. COMMON LOBBY
2. OFFICE ROOM
3. BARRACK HALL - 4X10= 40 BEDS
4.WASHROOM - 2X4 TOILET + 2X4 BATH
5. STAIRCASE
6. CLOTH DRYING AREA
7. RECREATION ROOM - 50 SEATING

NOTE : ALL DIMENSION IN METERS

PROJECT :
PROVIDING COMPREHENSIVE PROJECT
MANAGEMENT CONSULTANCY SERVICES FOR
PROPOSED CONSTRUCTION OF CISF
INFRASTRUCTURE BUILDINGS
AT NOTE MUDRAN NAGAR MYSORE

TENDER DRAWING

Page 6 of 129

BNPM - BARRACK FLOOR PLAN

Date : 10-10-2025

Drawn by: AMRUTHA

Scale : NTS

Checked by: Ar. Kavitha


Rev Date: -----



ARCHITECTS :
KULKARNI ASSOCIATES

Surya Prema Building, next to Adiga's Restaurant, Kanakapura Road
No-203, 2nd floor, Above Canara bank Raghuvahalli Branch
Raghuvahalli Village, Uttarahalli hobli Bangalore-560062

Email Id : kulkarni.associates@yahoo.com

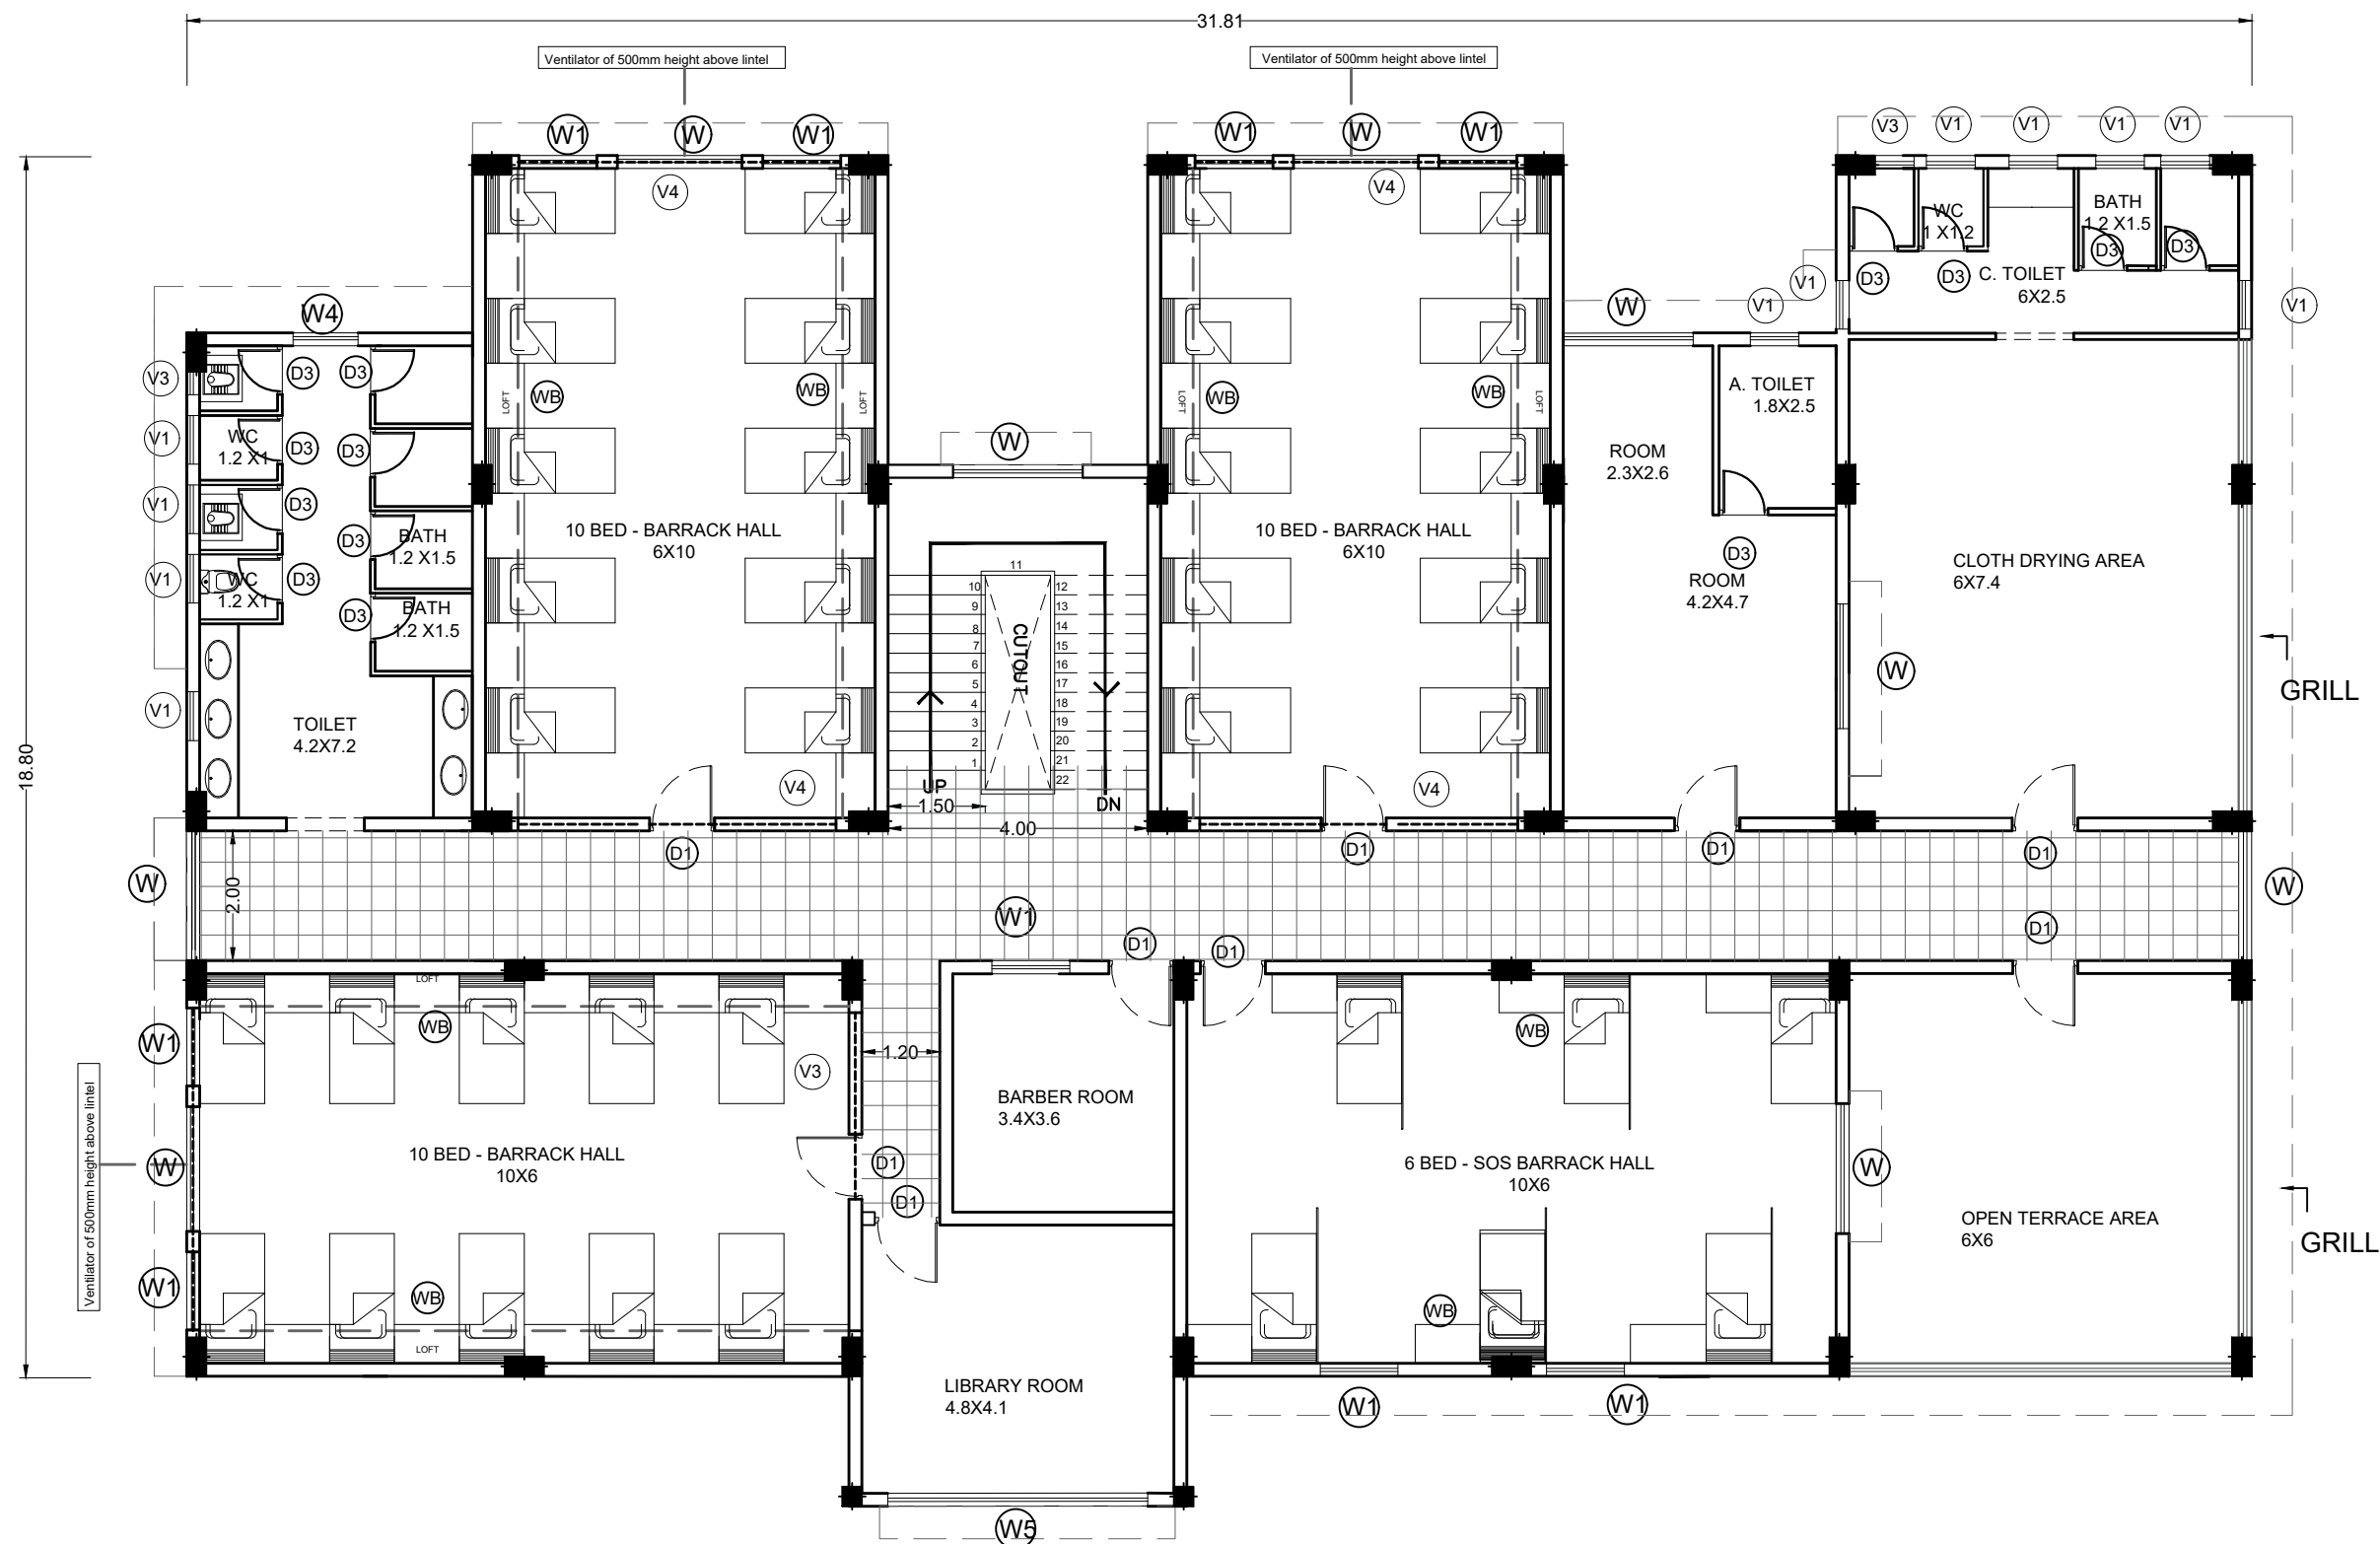

SECOND FLOOR PLAN

TOILET PROPORTION 1:6

LEGEND:

SECOND FLOOR BUILT UP -529SQM

LIST OF FACILITIES

1. COMMON LOBBY
2. LIBRARY ROOM
3. 10 BED BARRACK HALL - 30 BEDS
4. 6 BED SOS BARRACK HALL - 6 BEDS
5. ROOM + A. TOILET
6. WASHROOM - 4 TOILET + 4 BATH
7. STAIRCASE
8. BARBER ROOM
9. CLOTH DRYING AREA
10. WASHROOM - 2 TOILET + 2 BATH

NOTE : ALL DIMENSION IN METERS

PROJECT :
PROVIDING COMPREHENSIVE PROJECT
MANAGEMENT CONSULTANCY SERVICES FOR
PROPOSED CONSTRUCTION OF CISF
INFRASTRUCTURE BUILDINGS
AT NOTE MUDRAN NAGAR MYSORE

TENDER DRAWING

Page 7 of 129

BNPM - BARRACK FLOOR PLAN

Date :10-10-2025

Drawn by: AMRUTHA

Scale: 1:100

Checked by: Ar. Kavitha


Rev Date: -----



ARCHITECTS :
KULKARNI ASSOCIATES

Surya Prema Building, next to Adiga's Restaurant, Kanakapura Road
No-203, 2nd floor, Above Canara bank Raghuvahalli Branch
Raghuvahalli Village, Uttarahalli hobli Bangalore-560062

Email Id : kulkarni.associates@yahoo.com

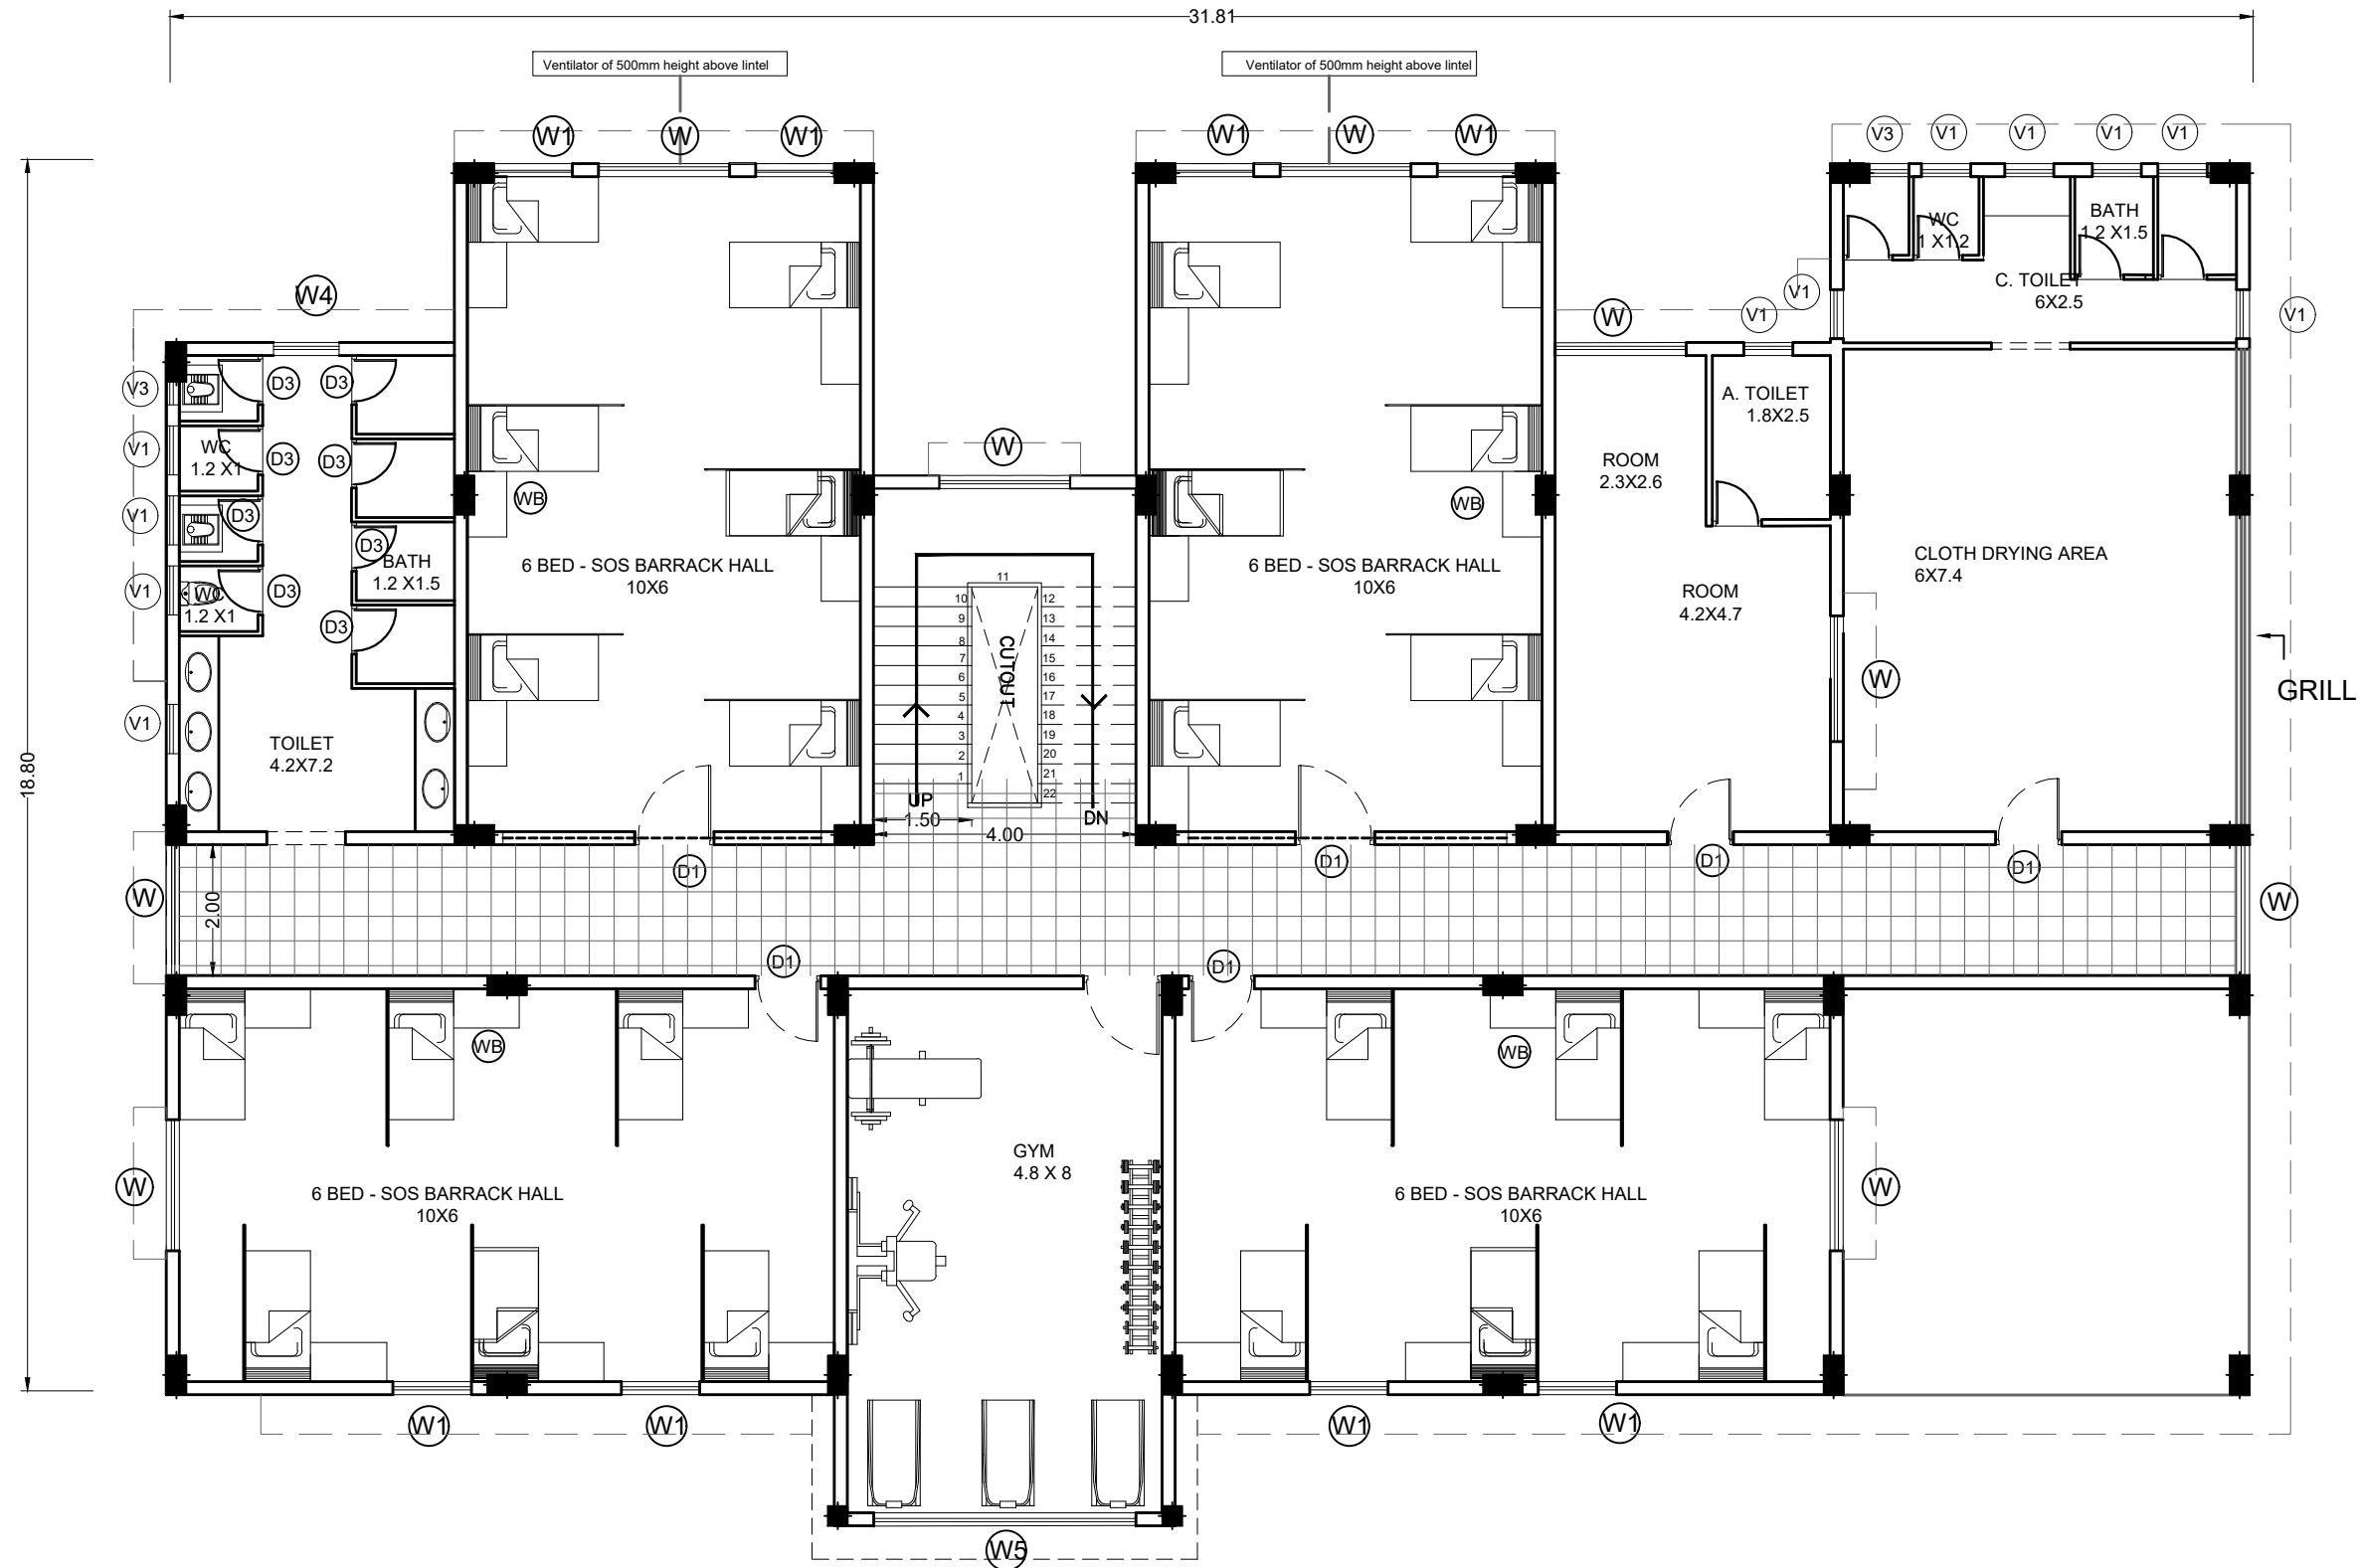

THIRD FLOOR PLAN

TOILET PROPORTION 1:4

LEGEND:

THIRD FLOOR BUILT UP -529SQM

LIST OF FACILITIES

1. COMMON LOBBY
2. GYM ROOM
- 3.6 BED SOS BARRACK HALL - 24 BEDS
- 5.ROOM + A. TOILET
- 6.WASHROOM - 4 TOILET + 4 BATH
7. STAIRCASE
8. CLOTH DRYING AREA
9. WASHROOM - 2 TOILET + 2 BATH

NOTE : ALL DIMENSION IN METERS

PROJECT :
PROVIDING COMPREHENSIVE PROJECT
MANAGEMENT CONSULTANCY SERVICES FOR
PROPOSED CONSTRUCTION OF CISF
INFRASTRUCTURE BUILDINGS
AT NOTE MUDRAN NAGAR MYSORE

TENDER DRAWING

Page 8 of 129

BNPM - BARRACK FLOOR PLAN

Date : 10-10-2025

Drawn by: AMRUTHA

Rev Date: -----


Checked by: Ar. Kavitha



ARCHITECTS :
KULKARNI ASSOCIATES

Surya Prema Building, next to Adiga's Restaurant, Kanakapura Road
No-203, 2nd floor, Above Canara bank Raghuvahalli Branch
Raghuvahalli Village, Uttarahalli hobli Bangalore-560062


Email Id : kulkarni.associates@yahoo.com

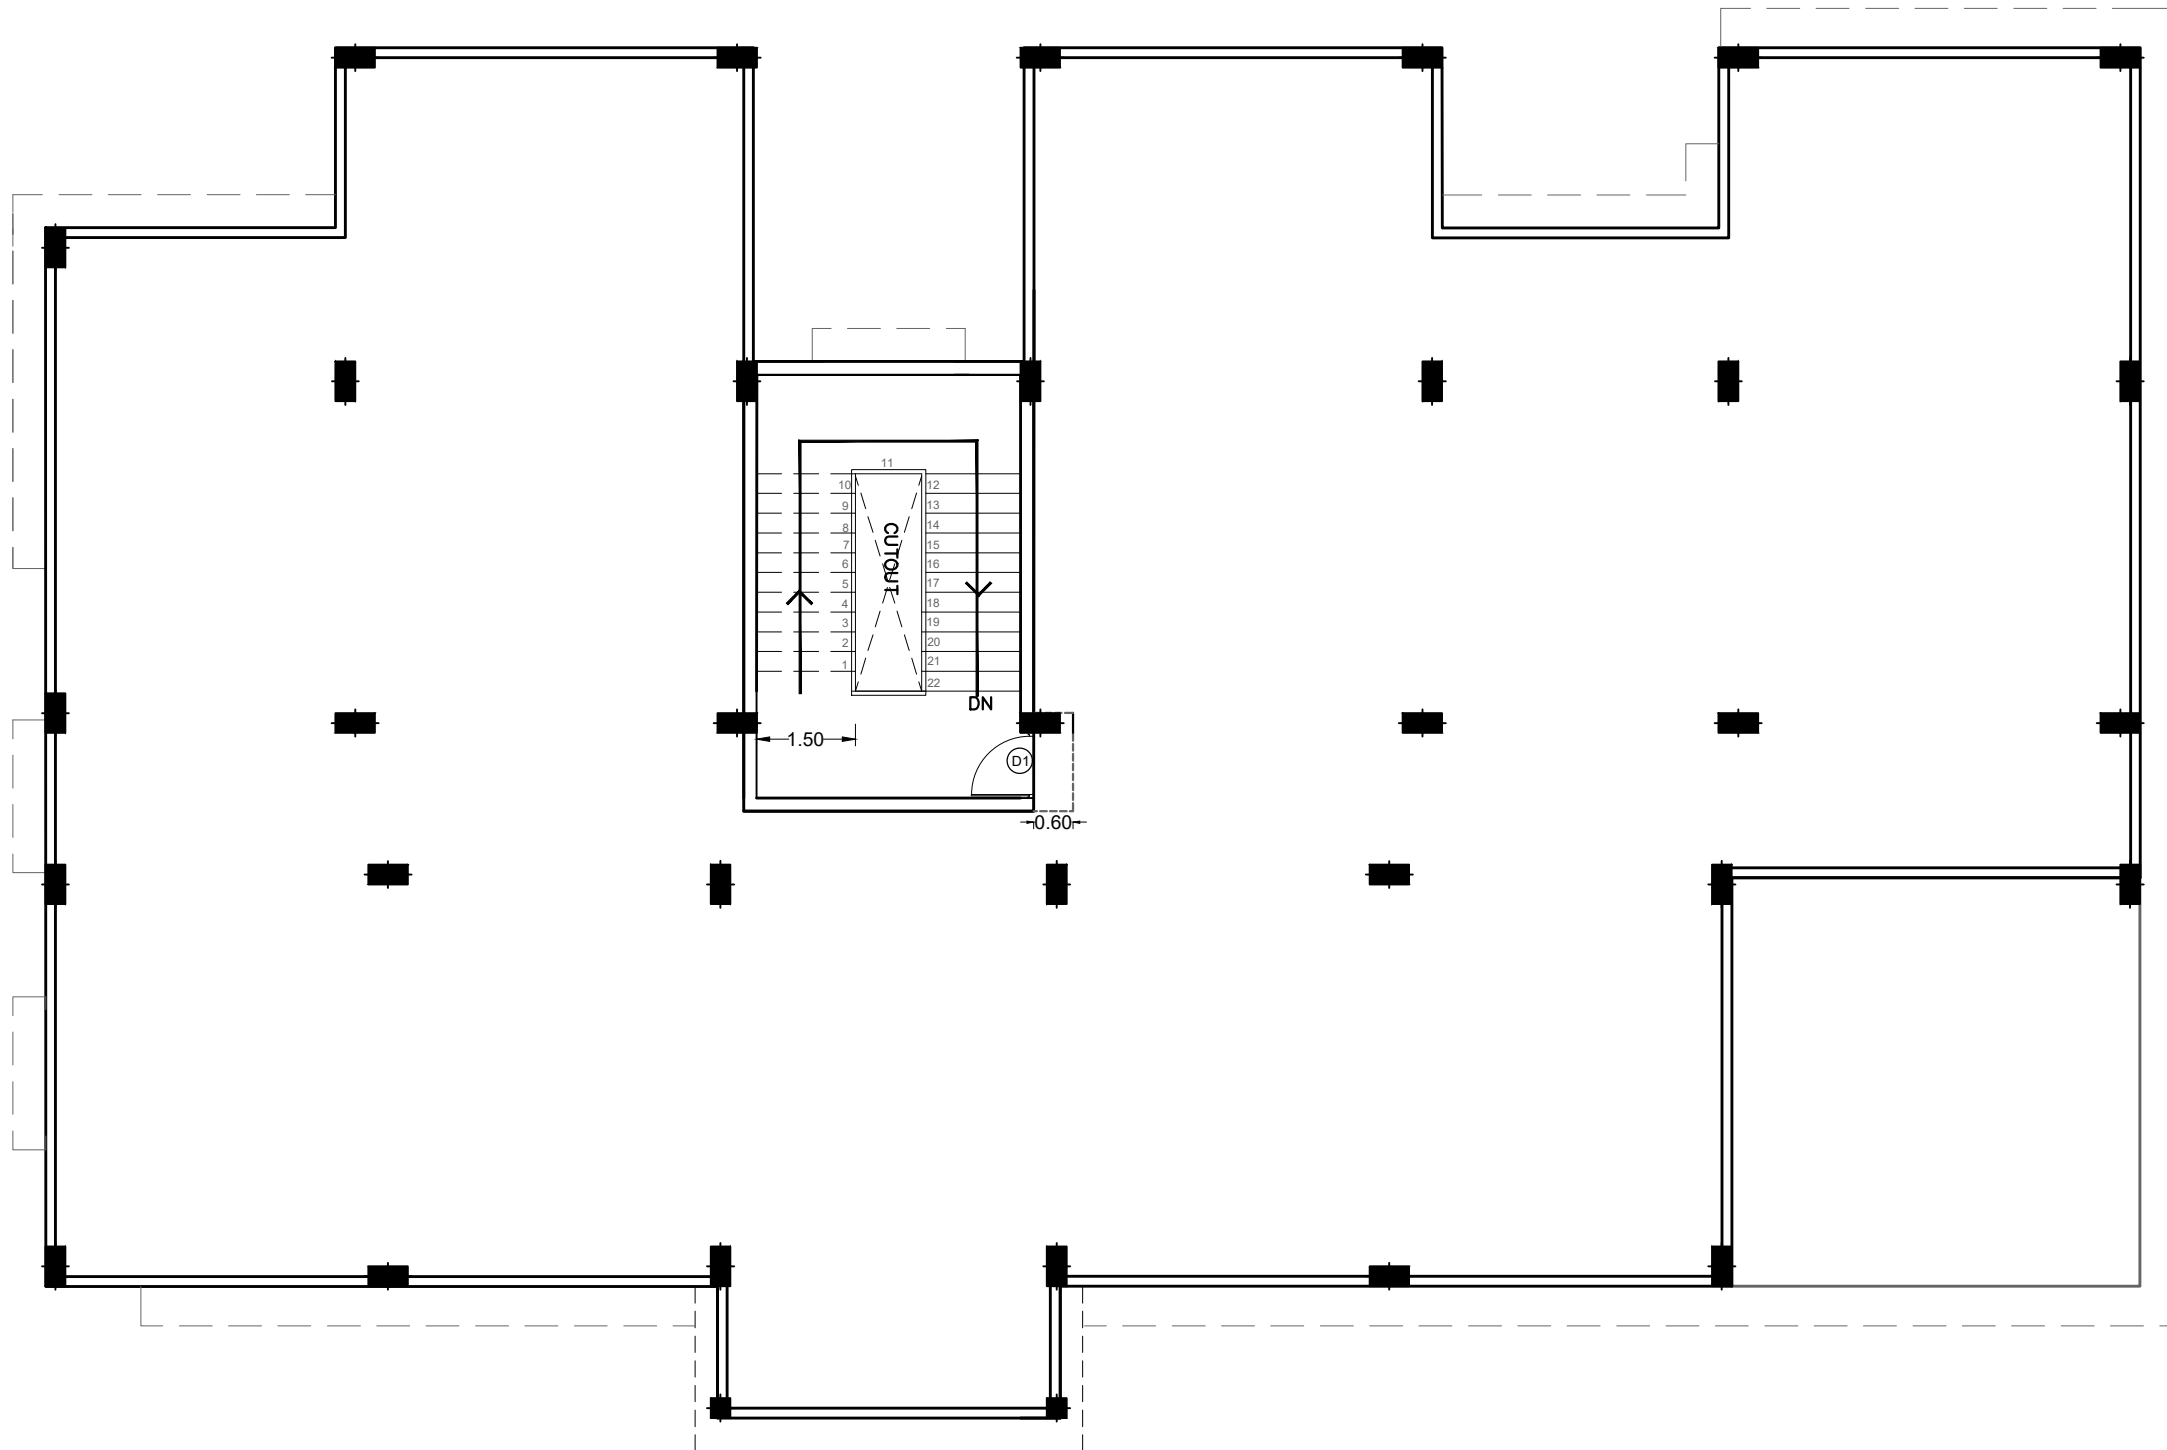


TERRACE FLOOR PLAN

NOTE : ALL DIMENSION IN METERS

PROJECT : PROVIDING COMPREHENSIVE PROJECT MANAGEMENT CONSULTANCY SERVICES FOR PROPOSED CONSTRUCTION OF CISF INFRASTRUCTURE BUILDINGS AT NOTE MUDRAN NAGAR MYSORE	TENDER DRAWING	BNPM - BARRACK FLOOR PLAN Date : 10-10-2025 Scale: 1:129 Rev Date: ----- Drawn by: AMRUTHA Checked by: Ar. Kavitha	N 	ARCHITECTS : KULKARNI ASSOCIATES Surya Prema Building,next to Adiga's Restaurant,Kanakapura Road No-203,2nd floor,Above Canara bank Raghuvahalli Branch Raghuvahalli Village,Uttarahalli hobli Bangalore-560062 Email Id : kulkarni.associates@yahoo.com
--	---------------------------	---	---	---

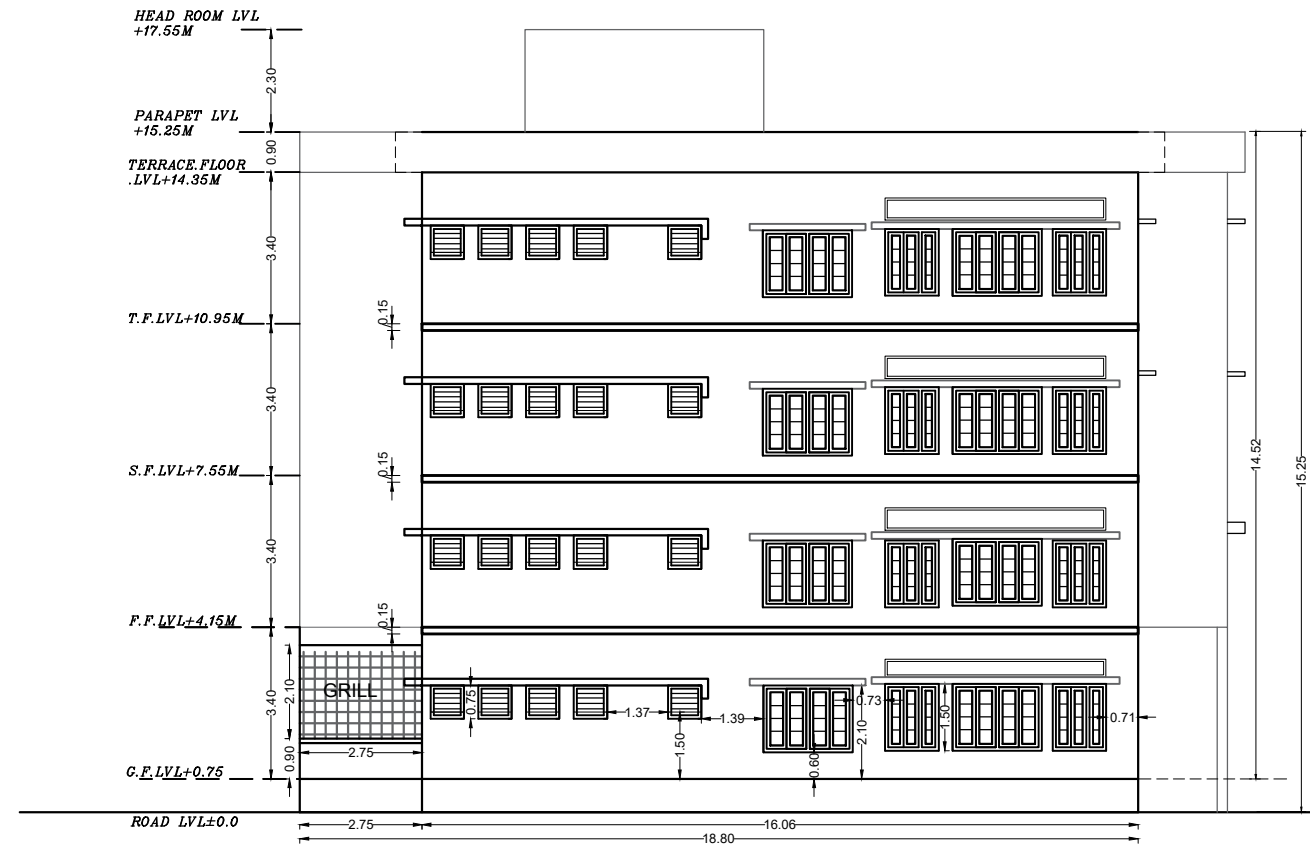


NORTH SIDE ELEVATION (LEFT SIDE)

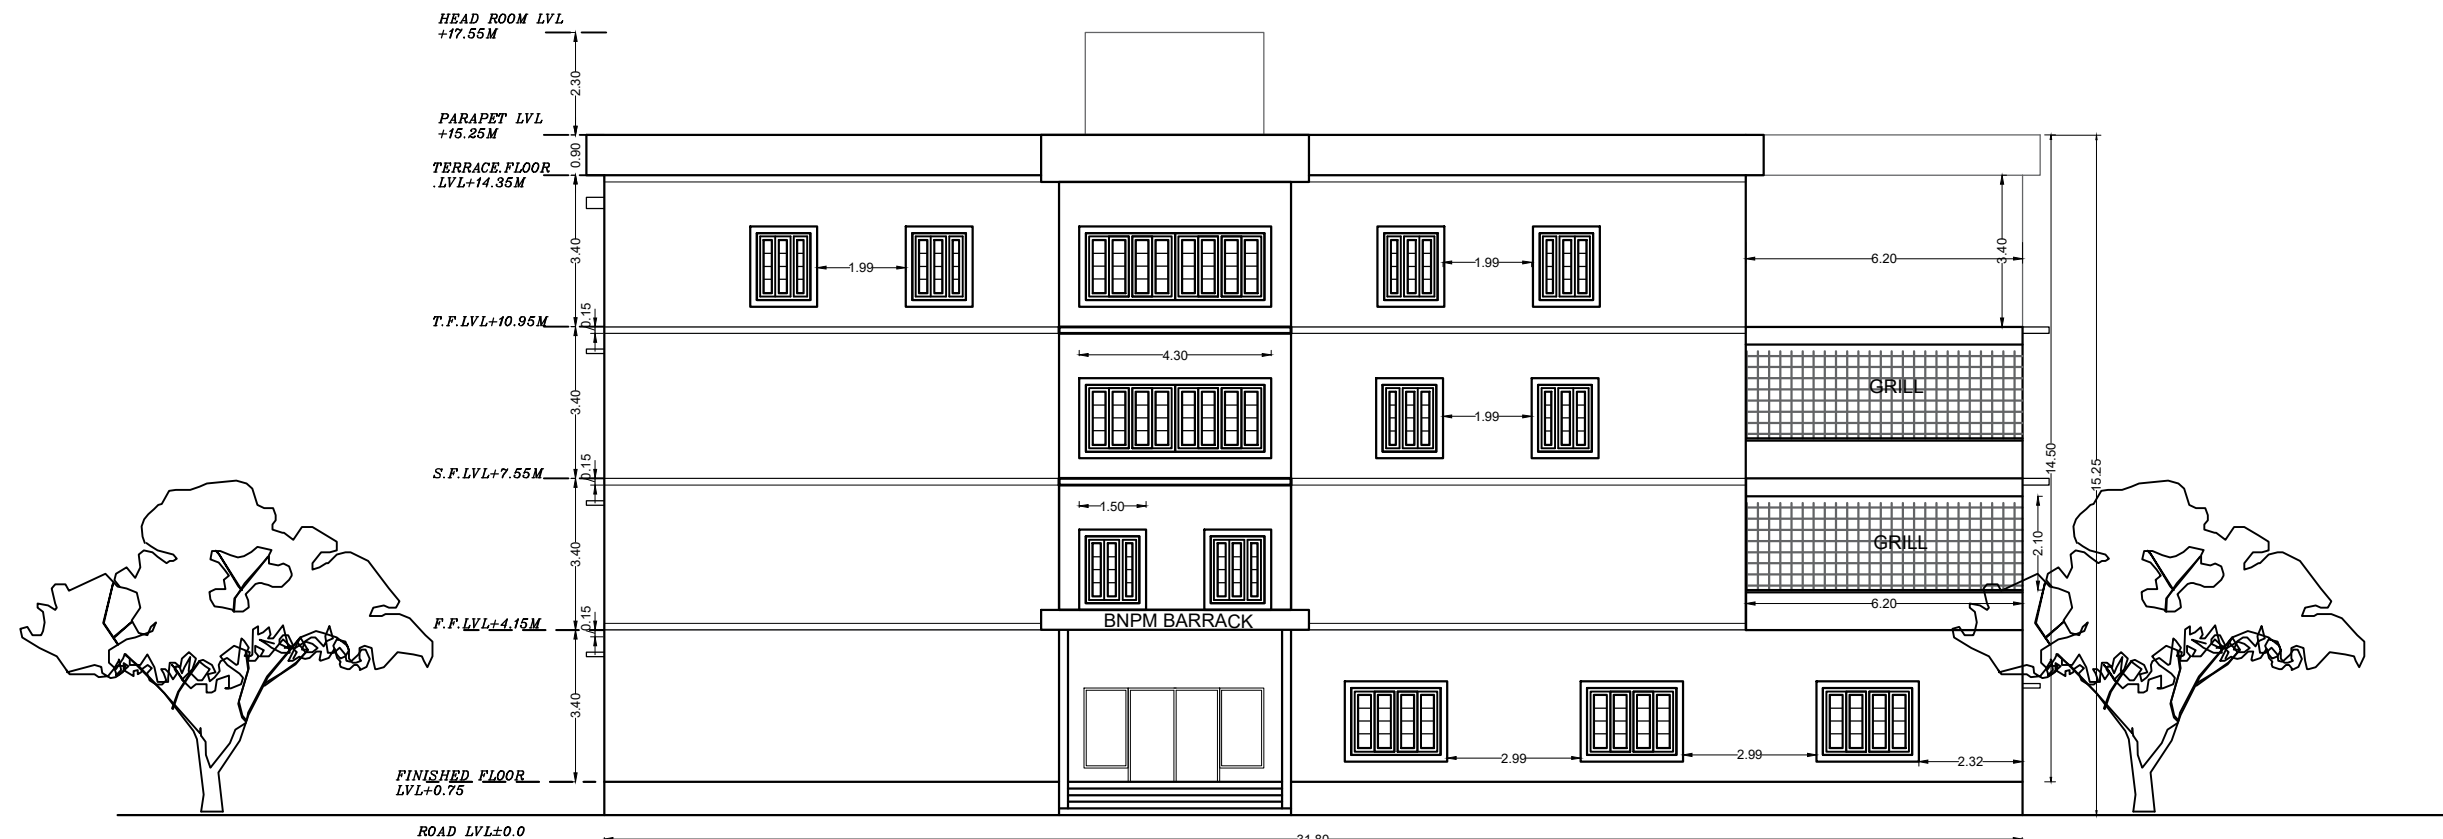

WEST SIDE ELEVATION (FRONT SIDE)

NOTE : ALL DIMENSION IN METERS

PROJECT : PROVIDING COMPREHENSIVE PROJECT MANAGEMENT CONSULTANCY SERVICES FOR PROPOSED CONSTRUCTION OF CISF INFRASTRUCTURE BUILDINGS AT NOTE MUDRAN NAGAR MYSORE	TENDER DRAWING	BNPM - BARRACK ELEVATION		ARCHITECTS : KULKARNI ASSOCIATES Surya Prema Building,next to Adiga's Restaurant,Kanakapura Road No-203,2nd floor,Above Canara bank Raghuvahalli Branch Raghuvanhalli Village,Uttarahalli hobli Bangalore-560062 Email Id : kulkarni.associates@yahoo.com
		Date : 30-10-2025	Drawn by: AMRUTHA	
		Scale: 1:1250	Checked by: Ar. Kavitha	
		Rev Date: -----		
		Page 10 of 129		

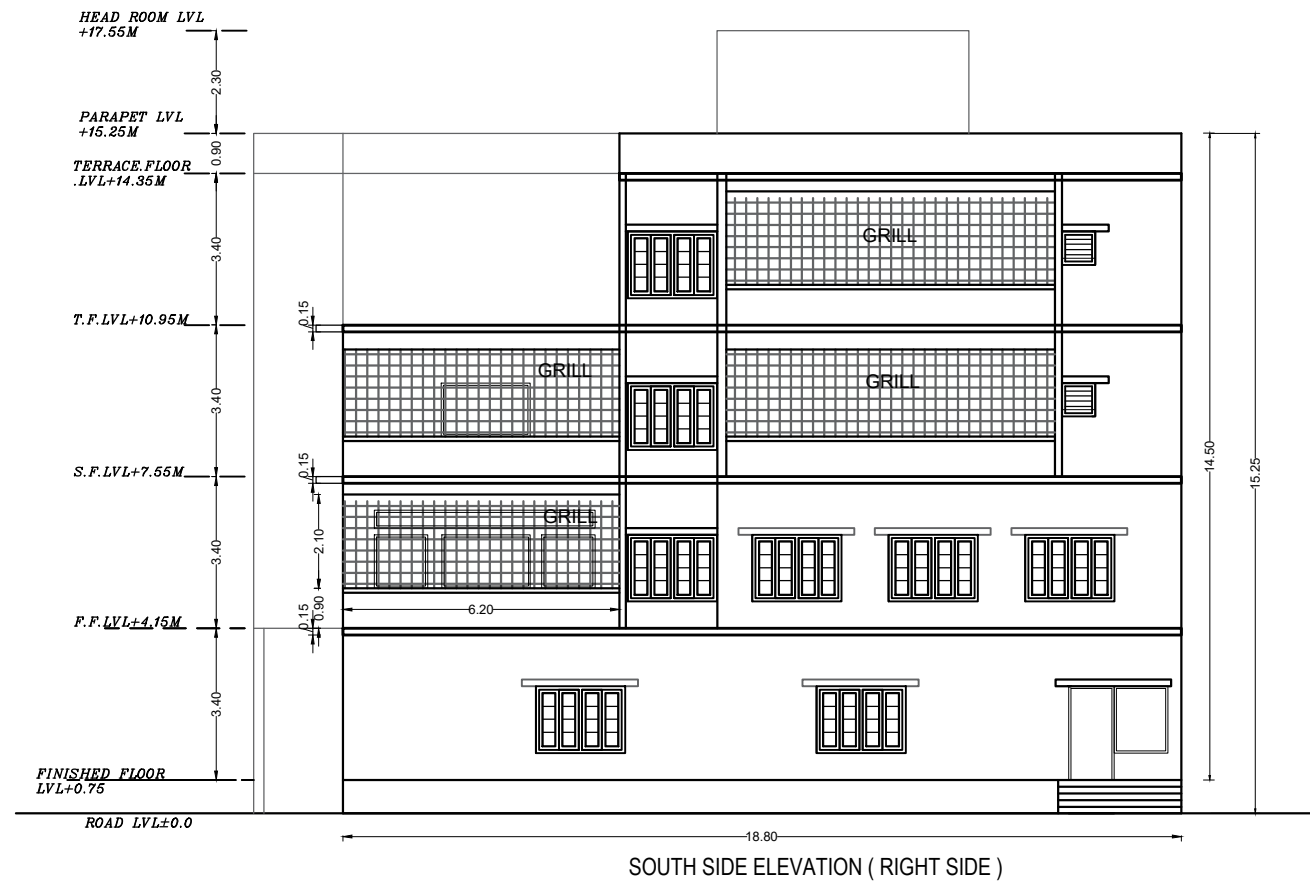

NOTE : ALL DIMENSION IN METERS

PROJECT :
PROVIDING COMPREHENSIVE PROJECT
MANAGEMENT CONSULTANCY SERVICES FOR
PROPOSED CONSTRUCTION OF CISF
INFRASTRUCTURE BUILDINGS
AT NOTE MUDRAN NAGAR MYSORE

TENDER DRAWING

Page 11 of 129

BNPM - BARRACK ELEVATION

Date : 30-10-2025

Drawn by: AMRUTHA


Checked by: Ar. Kavitha

Rev Date: -----


ARCHITECTS :
KULKARNI ASSOCIATES

Surya Prema Building, next to Adiga's Restaurant, Kanakapura Road
No-203, 2nd floor, Above Canara bank Raghuvahalli Branch
Raghuvahalli Village, Uttarahalli hobli Bangalore-560062


Email Id : kulkarni.associates@yahoo.com

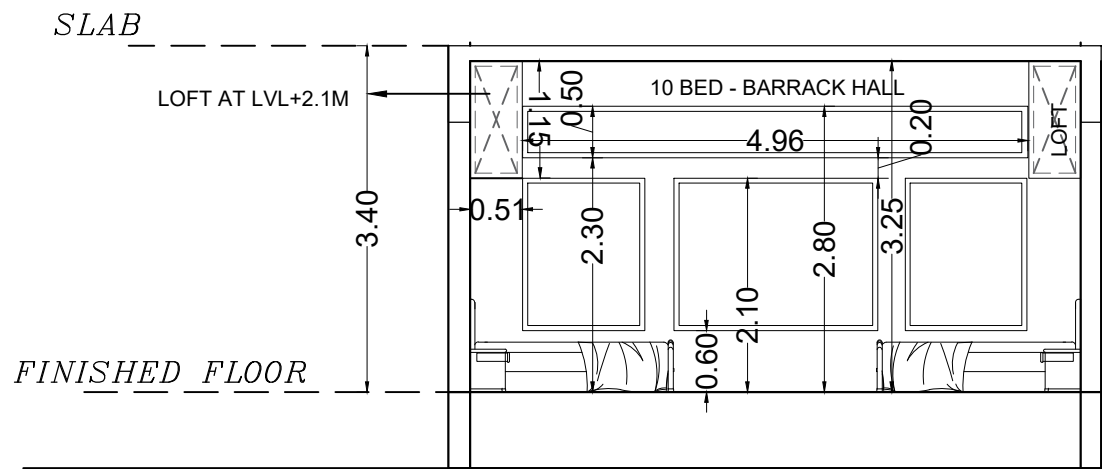

TYPICAL 10 BED BARRACK
ROOM SECTION

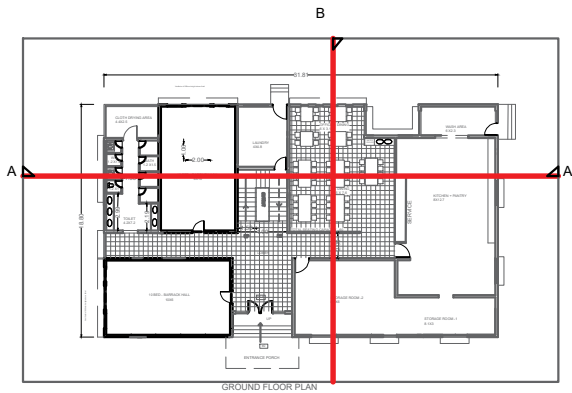

KEY PLAN

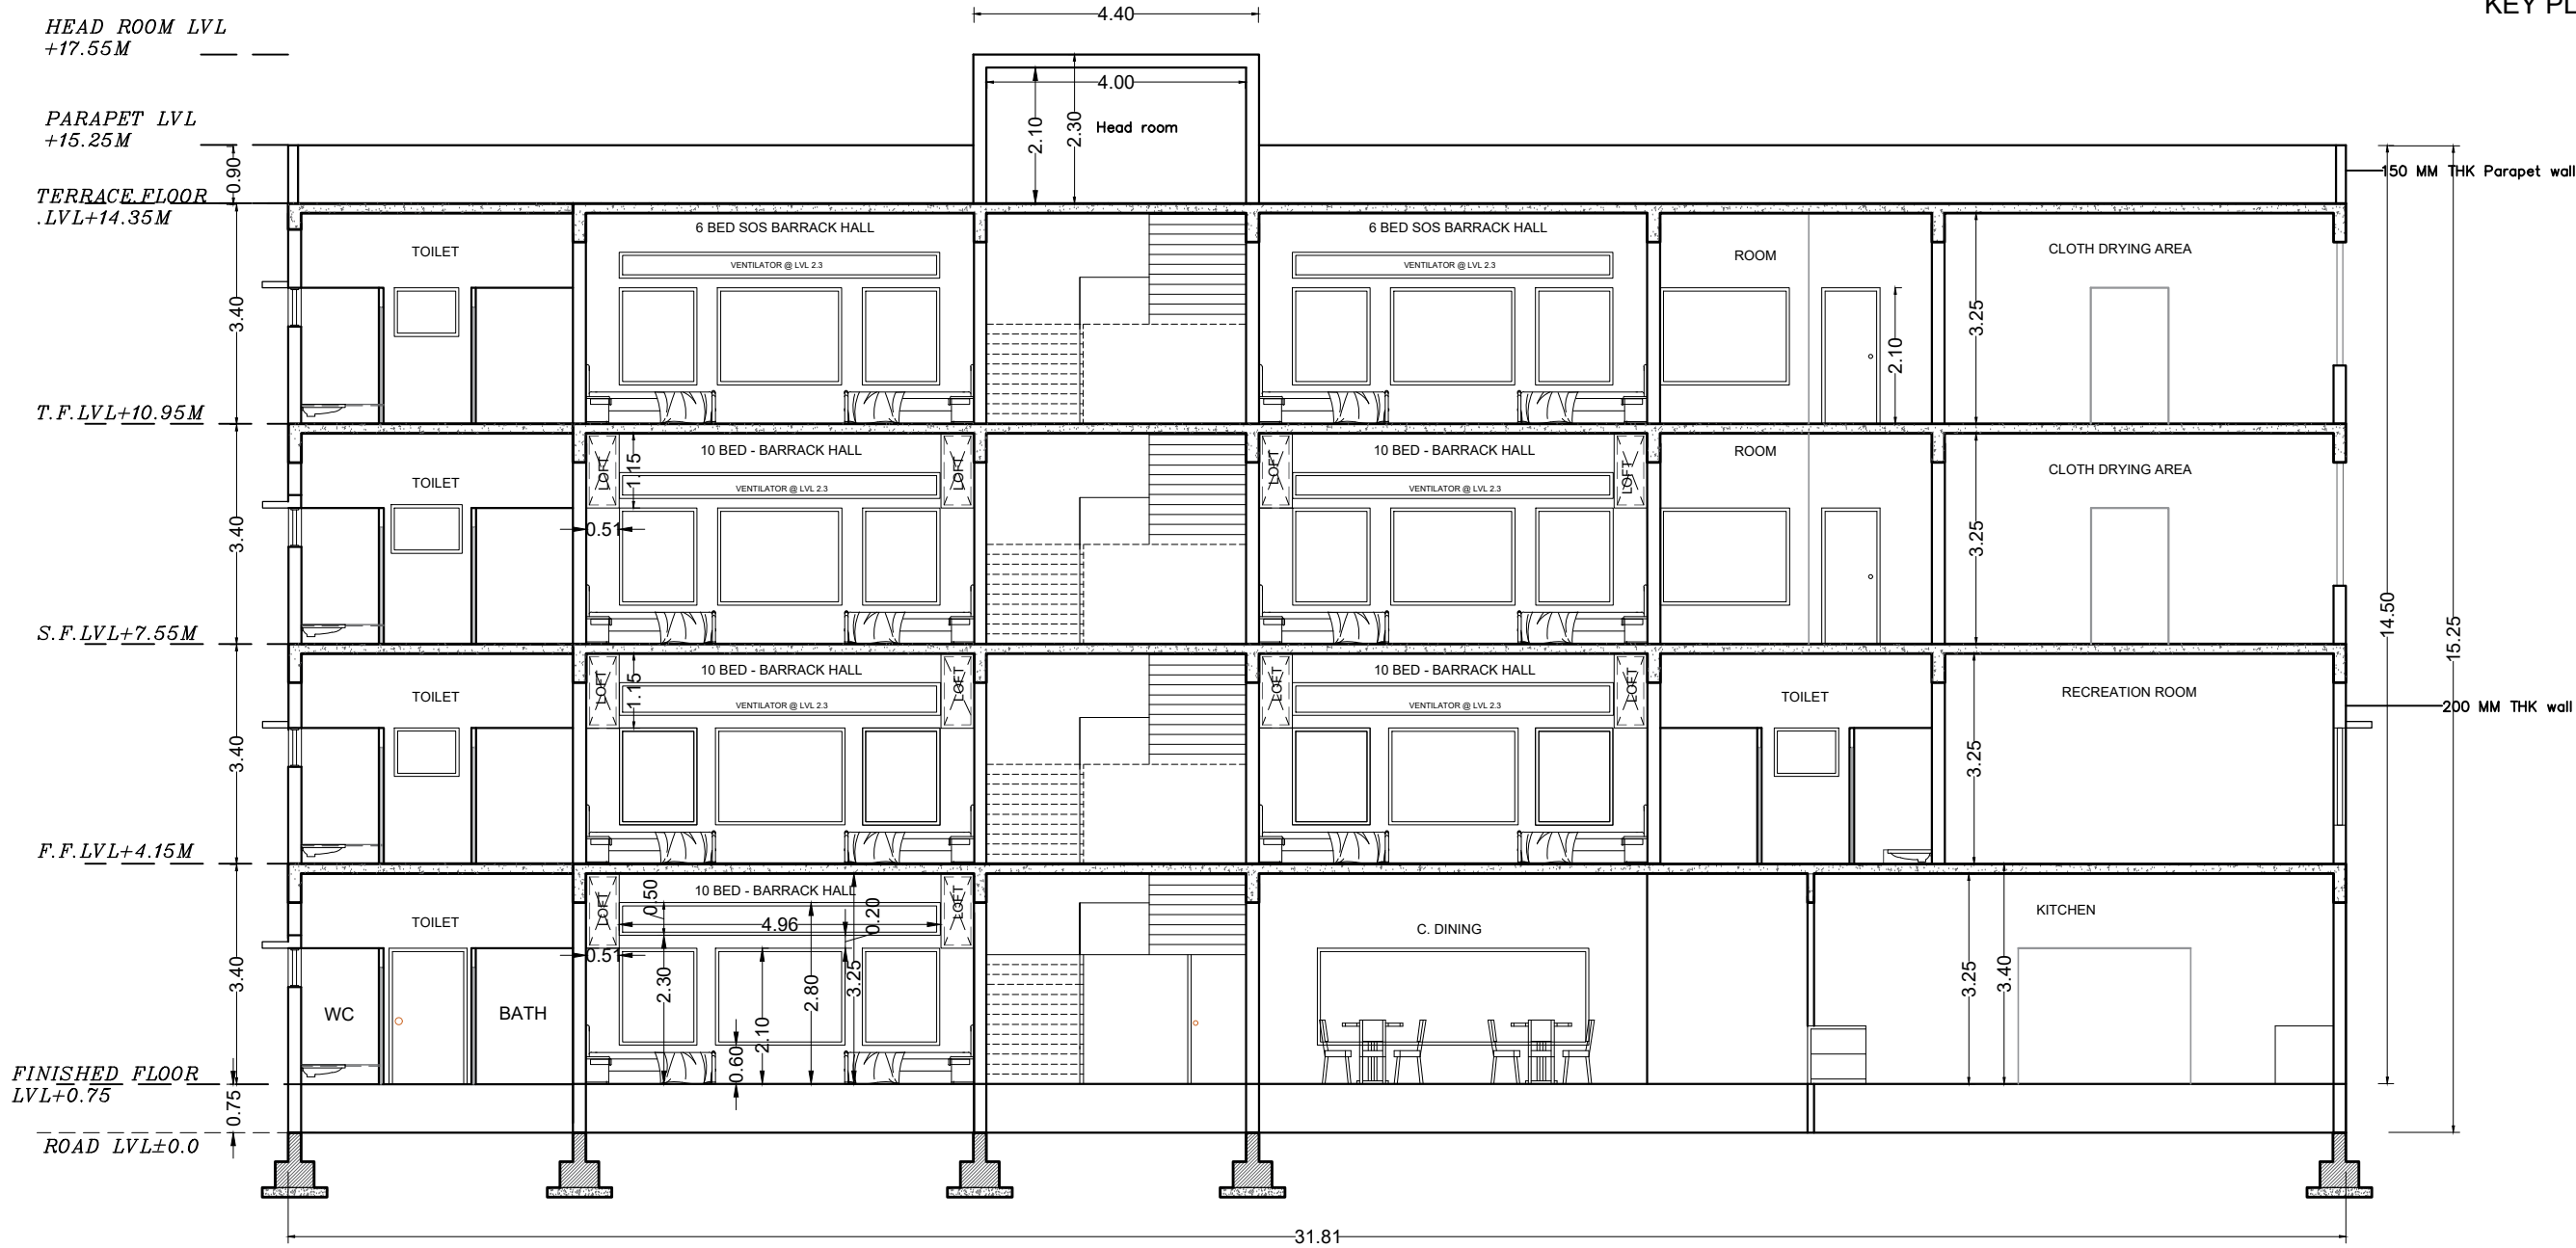

SECTION AA'

NOTE : ALL DIMENSION IN METERS

PROJECT :
PROVIDING COMPREHENSIVE PROJECT
MANAGEMENT CONSULTANCY SERVICES FOR
PROPOSED CONSTRUCTION OF CISF
INFRASTRUCTURE BUILDINGS
AT NOTE MUDRAN NAGAR MYSORE

TENDER DRAWING

BNPM - BARRACK SECTION

Date : 30-10-2025

Drawn by: AMRUTHA

Scale: 1/20




Checked by: Ar. Kavitha

Rev Date: -----

ARCHITECTS :
KULKARNI ASSOCIATES

Surya Prema Building, next to Adiga's Restaurant, Kanakapura Road
No-203, 2nd floor, Above Canara bank Raghuvahalli Branch
Raghuvahalli Village, Uttarahalli hobli Bangalore-560062

Email Id : kulkarni.associates@yahoo.com

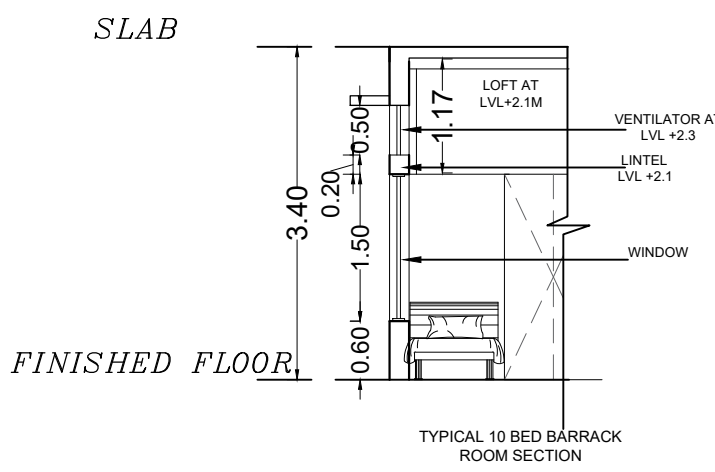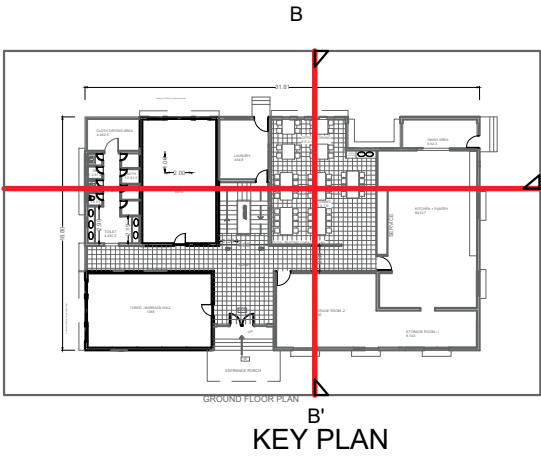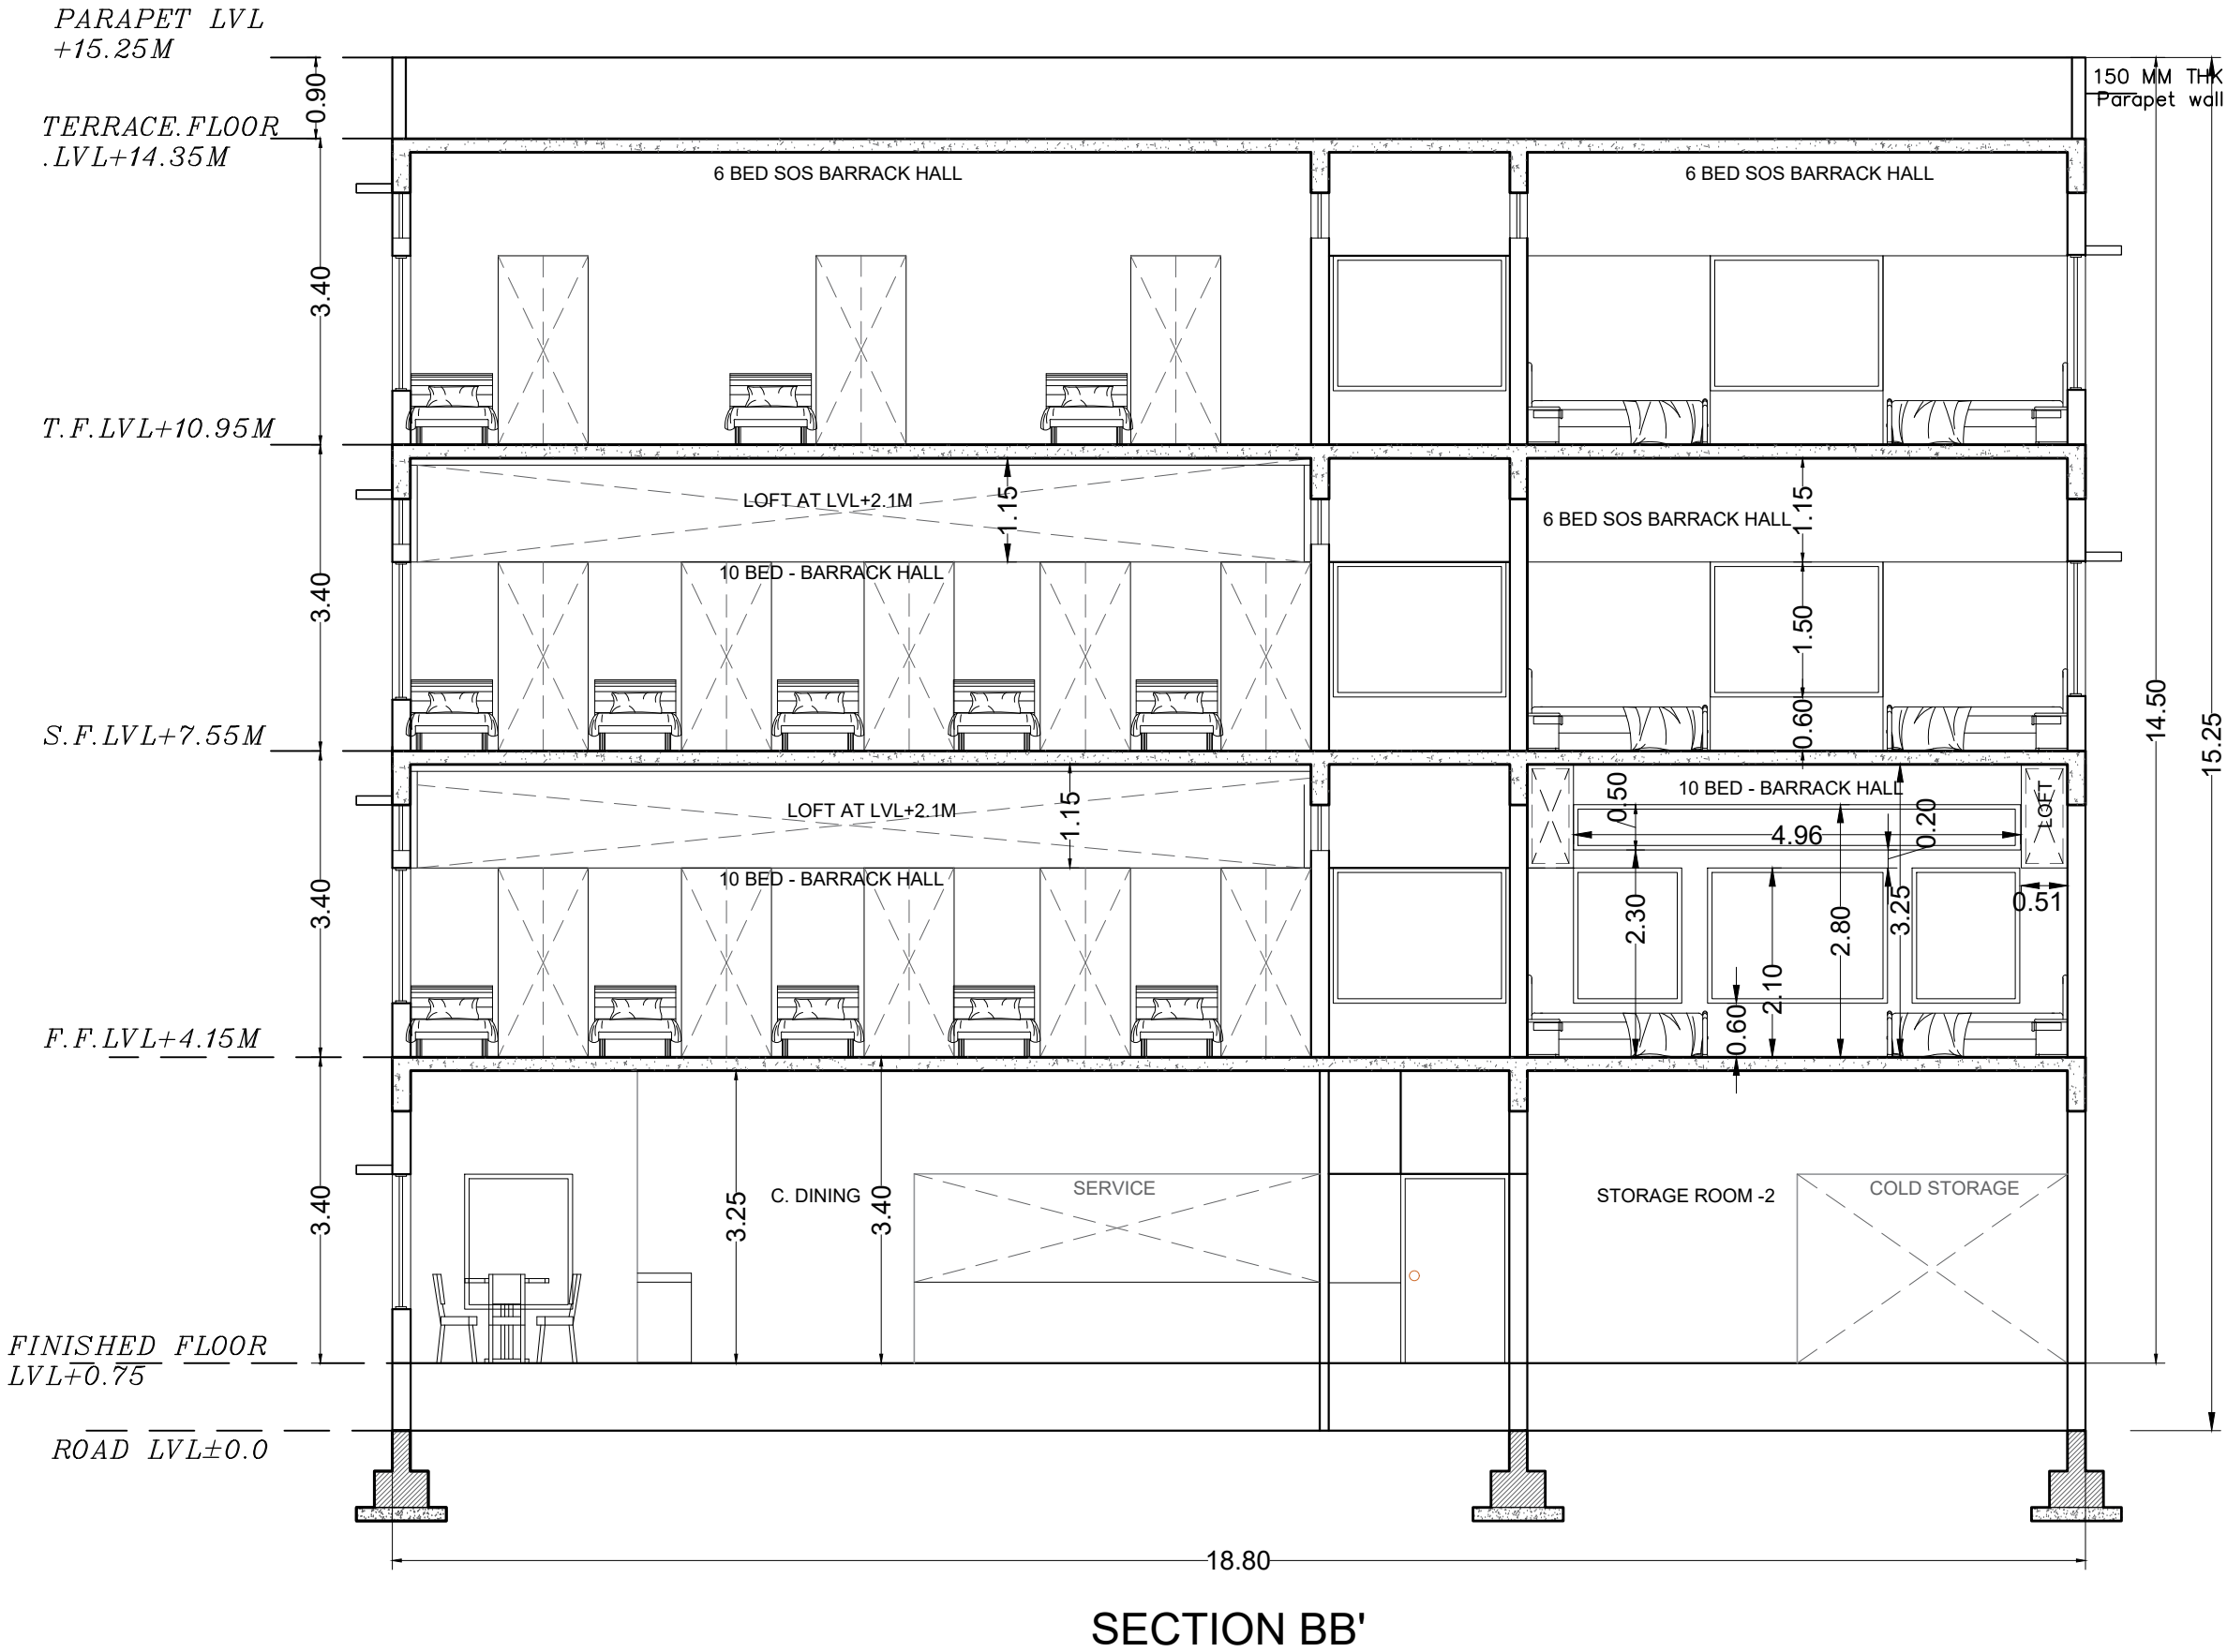

NOTE : ALL DIMENSION IN METERS

PROJECT :
PROVIDING COMPREHENSIVE PROJECT
MANAGEMENT CONSULTANCY SERVICES FOR
PROPOSED CONSTRUCTION OF CISF
INFRASTRUCTURE BUILDINGS
AT NOTE MUDRAN NAGAR MYSORE


TENDER DRAWING

BNPM - BARRACK SECTION

Date : 30-10-2025	Drawn by: AMRUTHA
Scale : NTS	Checked by: Ar. Kavitha
Rev Date: -----	

ARCHITECTS :
KULKARNI ASSOCIATES

Surya Prema Building, next to Adiga's Restaurant, Kanakapura Road
No-203, 2nd floor, Above Canara bank Raghuvahalli Branch
Raghuvahalli Village, Uttarahalli hobli Bangalore-560062
Email Id : kulkarni.associates@yahoo.com

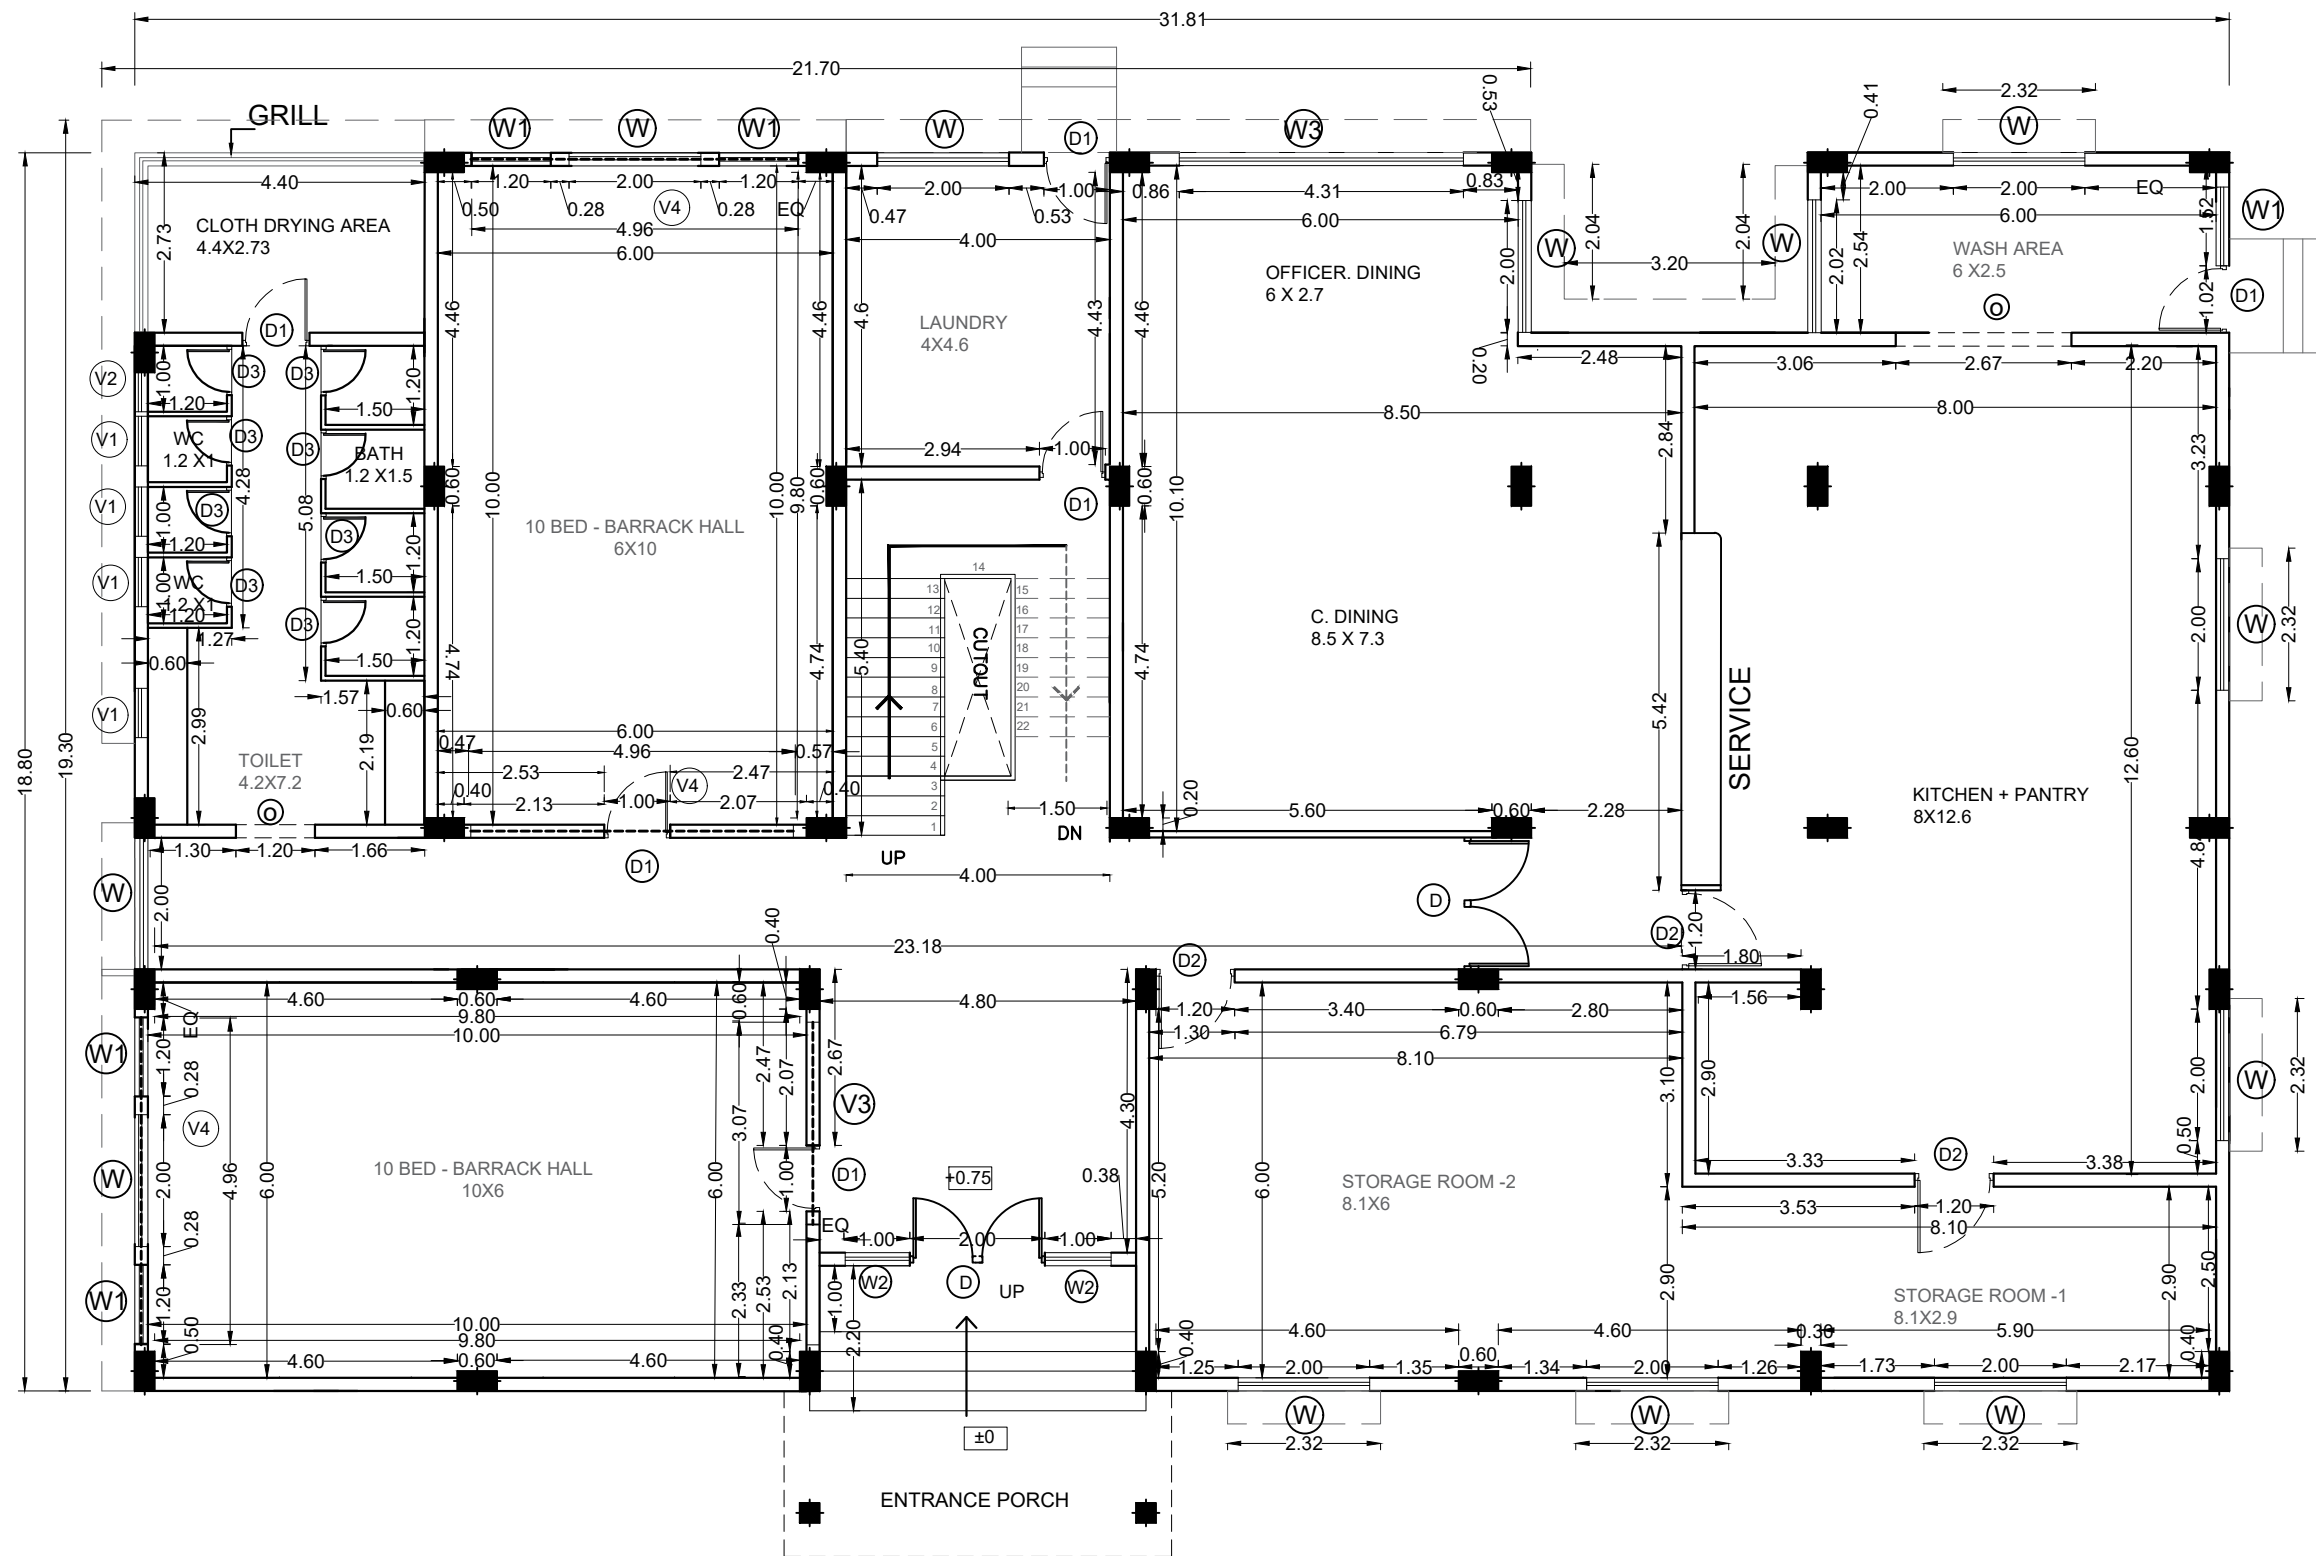

GROUND FLOOR PLAN

SCHEDULE OF OPENINGS

DOORS		
	SIZE IN M	Nos
D	2.00 X 2.10	2
D1	1.00 X 2.10	6
D2	1.20 X 2.10	3
D3	0.75 X 2.10	8
WINDOWS		
W	2.00 X 1.50	12
W1	1.20 X 1.50	5
W3	4.31 X 1.50	1
VENTILATORS		
V1	0.75X 0.75	4
V2	0.60X 0.75	1
V3	3.07X 0.5	1
V4	4.96 X 0.5	3
OPENING		
O	1.2X2.1	1

NOTE : ALL Chajja projection is 0.6m deep

TOILET PROPORTION 1:5

LEGEND:

GROUND FLOOR BUILT UP - 589SQM

LIST OF FACILITIES

1. ENTRANCE LOBBY
2. STORAGE ROOM
3. KITCHEN
4. WASH AREA
5. DINING AREA - 60 SEATING
6. BARRACK HALL - 2X10 =20 BEDS
7. WASHROOM - 1X4 TOILET +1X4 BATH
8. STAIRCASE
9. LAUNDRY
10. CLOTH DRYING AREA

NOTE : ALL DIMENSION IN METERS

PROJECT :
PROVIDING COMPREHENSIVE PROJECT
MANAGEMENT CONSULTANCY SERVICES FOR
PROPOSED CONSTRUCTION OF CISF
INFRASTRUCTURE BUILDINGS
AT NOTE MUDRAN NAGAR MYSORE

TENDER DRAWING

Page 14 of 129

BNPM - BARRACK FLOOR PLAN
WORKING DRAWING

Date : 30-10-2025

Drawn by: AMRUTHA

Rev Date: -----


Checked by: Ar. Kavitha



ARCHITECTS :
KULKARNI ASSOCIATES

Surya Prema Building, next to Adiga's Restaurant, Kanakapura Road
No-203, 2nd floor, Above Canara bank Raghuvahalli Branch
Raghuvahalli Village, Uttarahalli hobli Bangalore-560062

Email Id : kulkarni.associates@yahoo.com

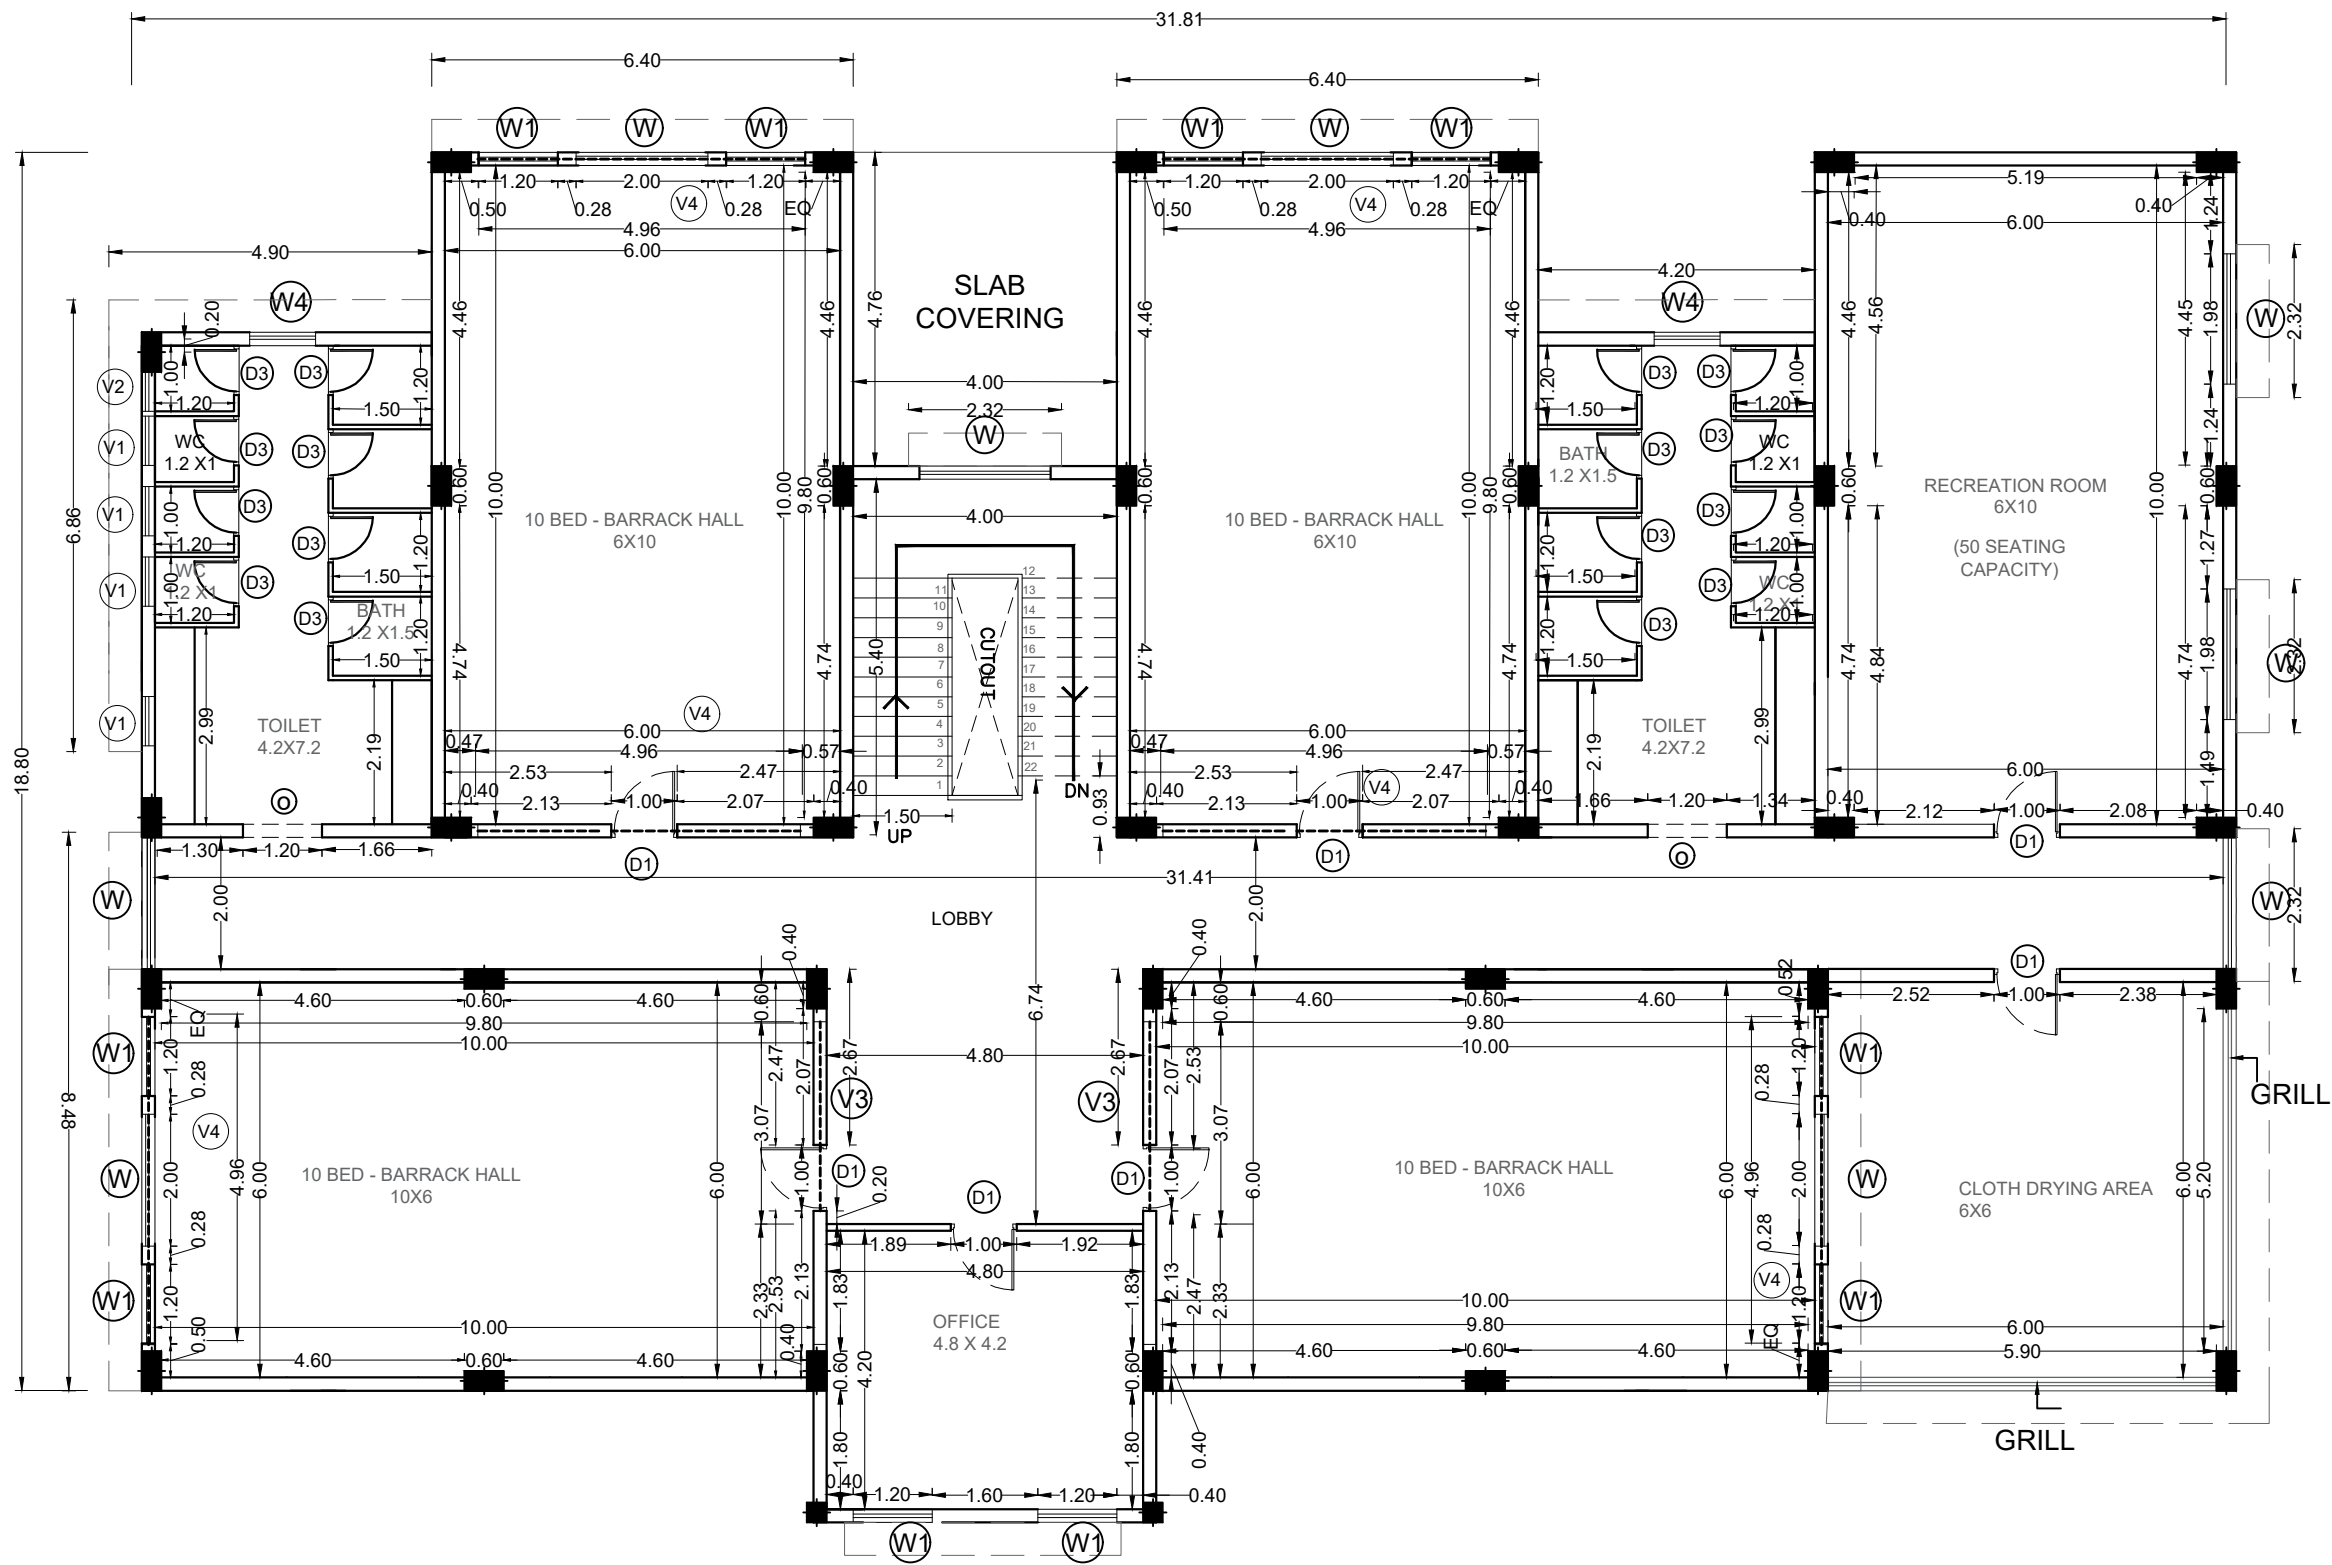

FIRST FLOOR PLAN

SCHEDULE OF OPENINGS		
DOORS		
	SIZE IN M	Nos
D1	1.00 X 2.10	7
D3	0.75 X 2.10	16
WINDOWS		
W	2.00 X 1.50	9
W1	1.20 X 1.50	8
W4	1.00 X 0.75	2
VENTILATORS		
V1	0.75X 0.75	5
V2	0.60X 0.75	1
V3	3.07X 0.5	2
V4	4.96 X 0.5	6
OPENING		
O	1.2X2.1	2

NOTE : ALL Chajja projection is 0.6m deep

TOILET PROPORTION 1:5

LEGEND:

FIRST FLOOR BUILT UP -567SQM
LIST OF FACILITIES
1. COMMON LOBBY
2. OFFICE ROOM
3. BARRACK HALL - 4X10= 40 BEDS
4.WASHROOM - 2X4 TOILET + 2X4 BATH
5. STAIRCASE
6. CLOTH DRYING AREA
7. RECREATION ROOM - 50 SEATING

NOTE : ALL DIMENSION IN METERS

PROJECT :
PROVIDING COMPREHENSIVE PROJECT
MANAGEMENT CONSULTANCY SERVICES FOR
PROPOSED CONSTRUCTION OF CISF
INFRASTRUCTURE BUILDINGS
AT NOTE MUDRAN NAGAR MYSORE

TENDER DRAWING

Page 15 of 129

BNPM - BARRACK FLOOR PLAN
WORKING DRAWING

Date : 30-10-2025

Drawn by: AMRUTHA

Rev Date: -----


Checked by: Ar. Kavitha



ARCHITECTS :
KULKARNI ASSOCIATES

Surya Prema Building, next to Adiga's Restaurant, Kanakapura Road
No-203, 2nd floor, Above Canara bank Raghuvahalli Branch
Raghuvahalli Village, Uttarahalli hobli Bangalore-560062

Email Id : kulkarni.associates@yahoo.com

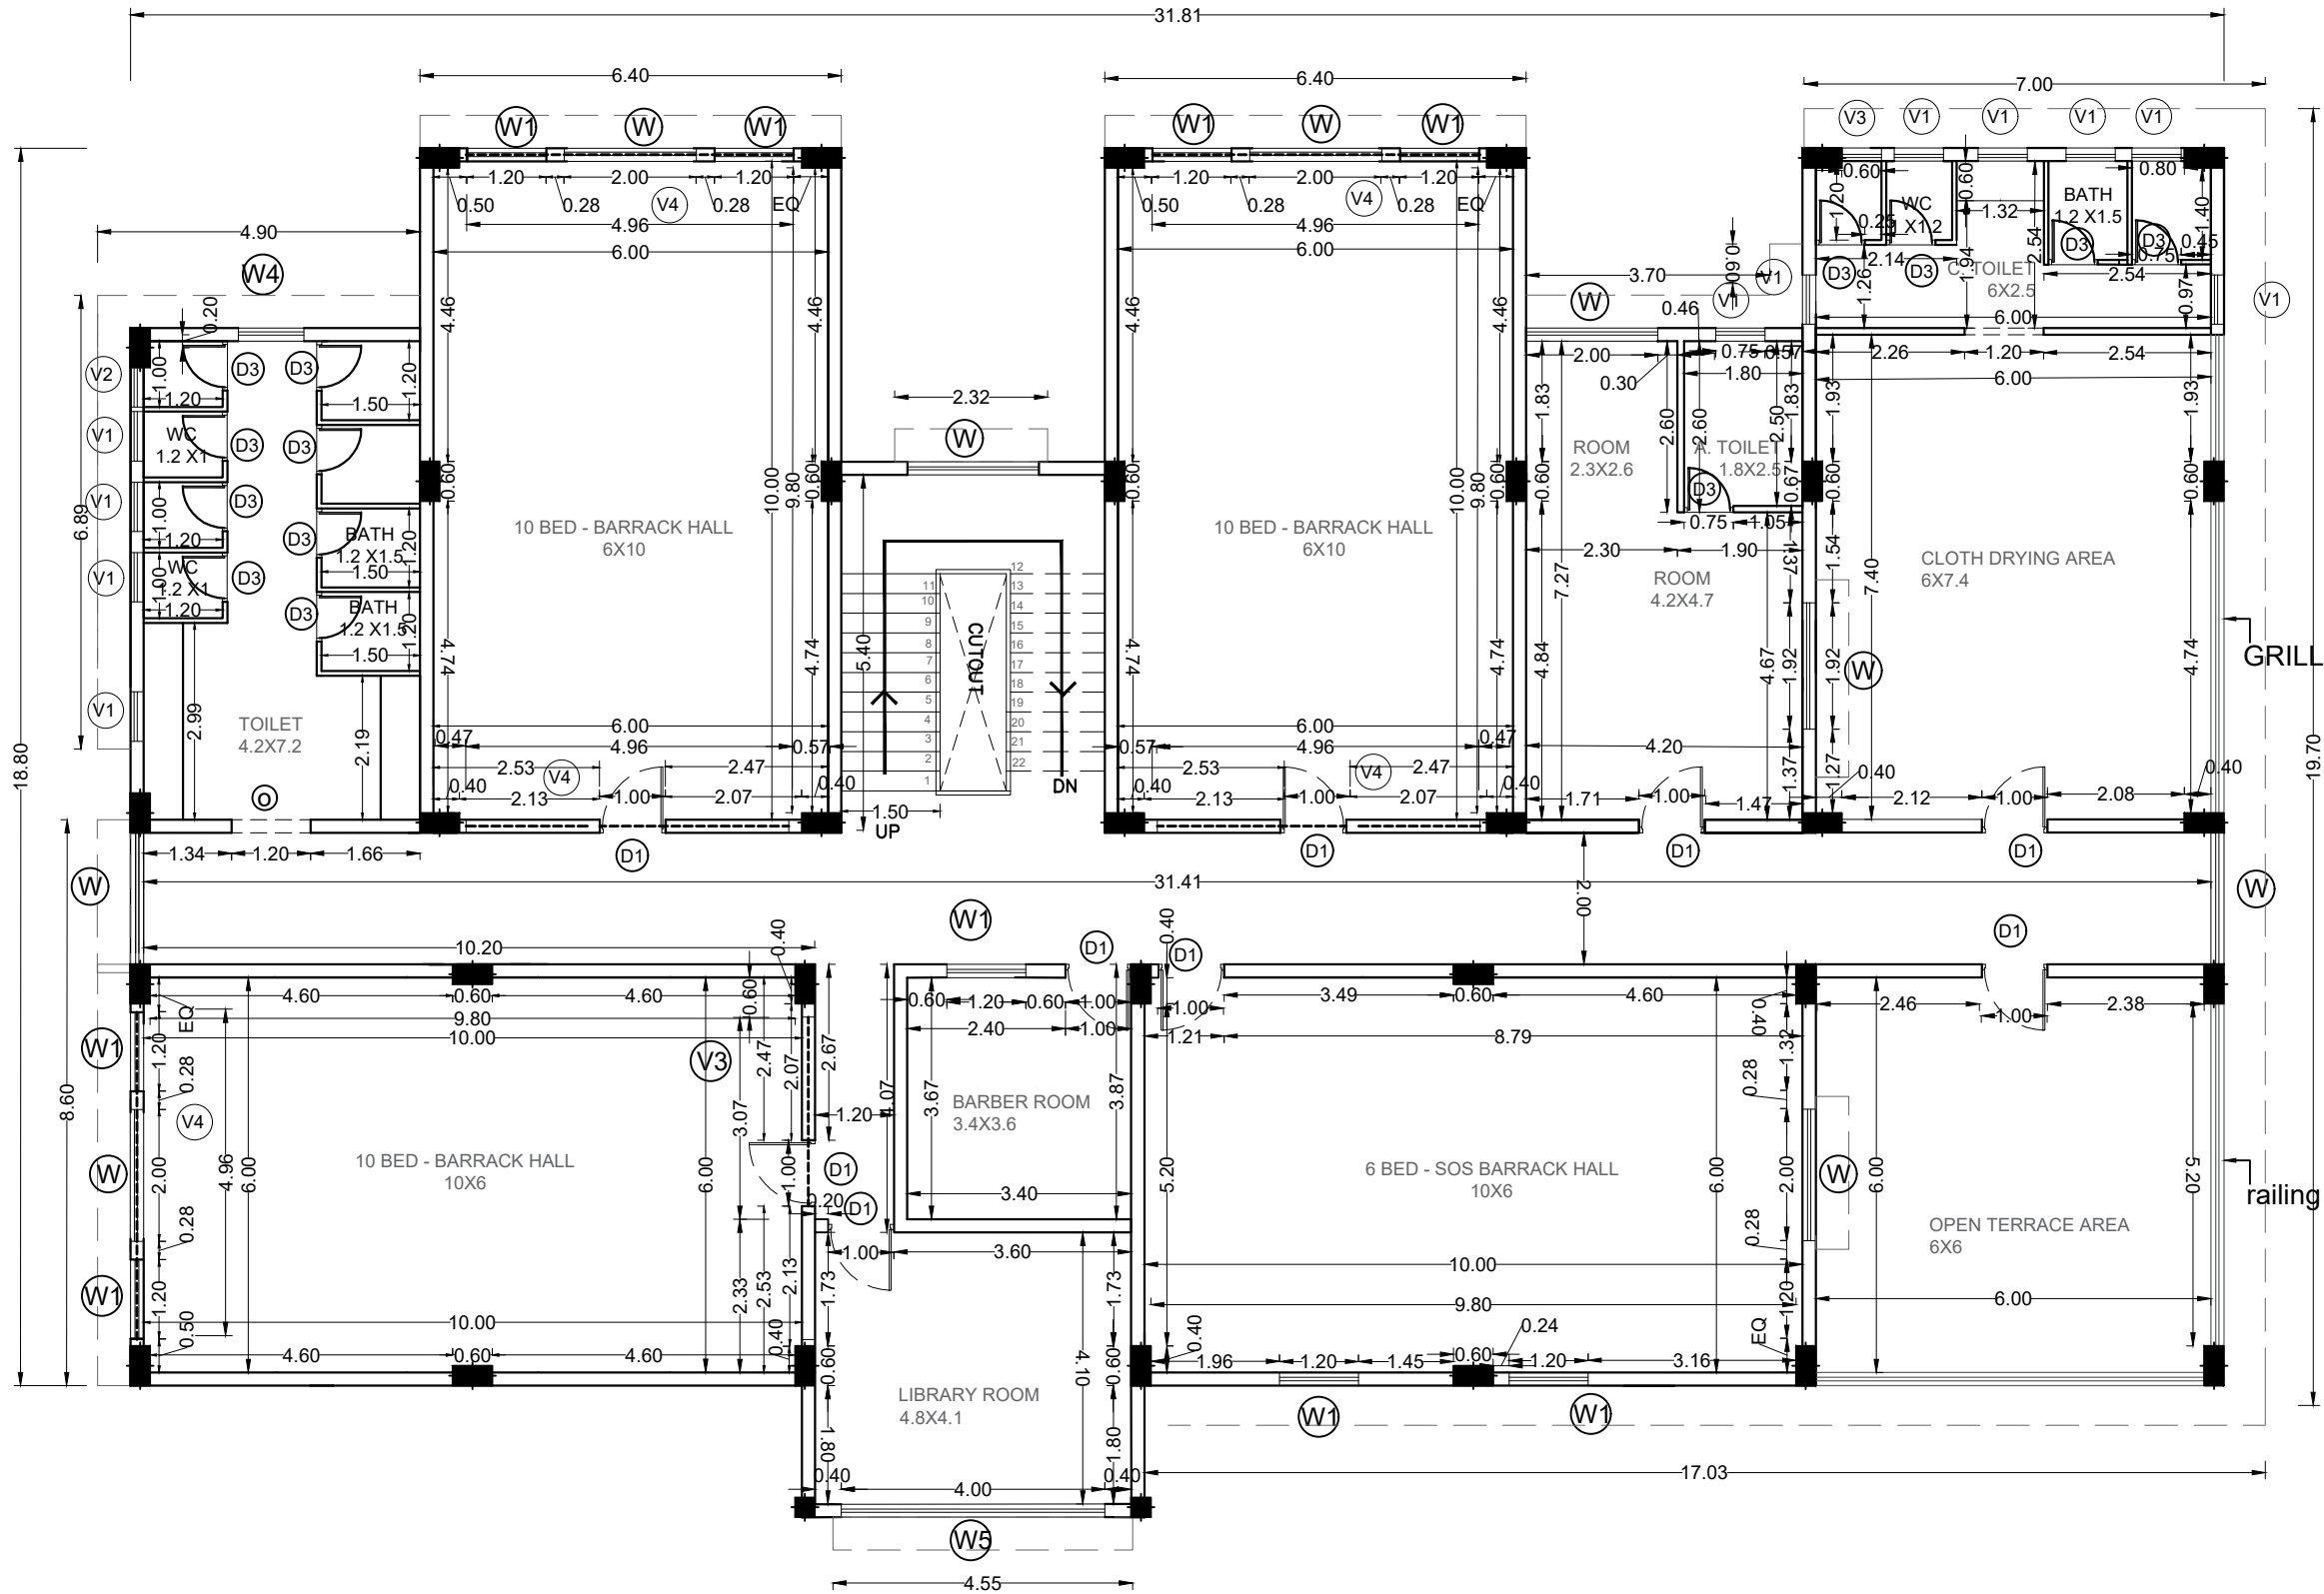

SECOND FLOOR PLAN

SCHEDULE OF OPENINGS		
DOORS		
	SIZE IN M	Nos
D1	1.00 X 2.10	9
D3	0.75 X 2.10	13
WINDOWS		
W	2.00 X 1.50	9
W1	1.20 X 1.50	9
W4	1.00 X 0.75	1
W5	4.00 X 1.50	1
VENTILATORS		
V1	0.75X 0.75	11
V2	0.60X 0.75	2
V3	3.07X 0.5	1
V4	4.96 X 0.5	5
OPENING		
O	1.2X2.1	2

NOTE : ALL Chajja projection is 0.6m deep

TOILET PROPORTION 1:6

LEGEND:

SECOND FLOOR BUILT UP -529SQM

LIST OF FACILITIES

1. COMMON LOBBY
2. LIBRARY ROOM
- 3.10 BED BARRACK HALL - 30 BEDS
- 4.6 BED SOS BARRACK HALL - 6 BEDS
- 5.ROOM + A. TOILET
- 6.WASHROOM - 4 TOILET + 4 BATH
7. STAIRCASE
8. BARBER ROOM
9. CLOTH DRYING AREA
10. WASHROOM - 2 TOILET + 2 BATH

NOTE : ALL DIMENSION IN METERS

PROJECT :
PROVIDING COMPREHENSIVE PROJECT
MANAGEMENT CONSULTANCY SERVICES FOR
PROPOSED CONSTRUCTION OF CISF
INFRASTRUCTURE BUILDINGS
AT NOTE MUDRAN NAGAR MYSORE

TENDER DRAWING

Page 16 of 129

BNPM - BARRACK FLOOR PLAN
WORKING DRAWING

Date : 30-10-2025

Drawn by: AMRUTHA

Rev Date: -----


Checked by: Ar. Kavitha



ARCHITECTS :
KULKARNI ASSOCIATES

Surya Prema Building, next to Adiga's Restaurant, Kanakapura Road
No-203, 2nd floor, Above Canara bank Raghuvahalli Branch
Raghuvahalli Village, Uttarahalli hobli Bangalore-560062

Email Id : kulkarni.associates@yahoo.com

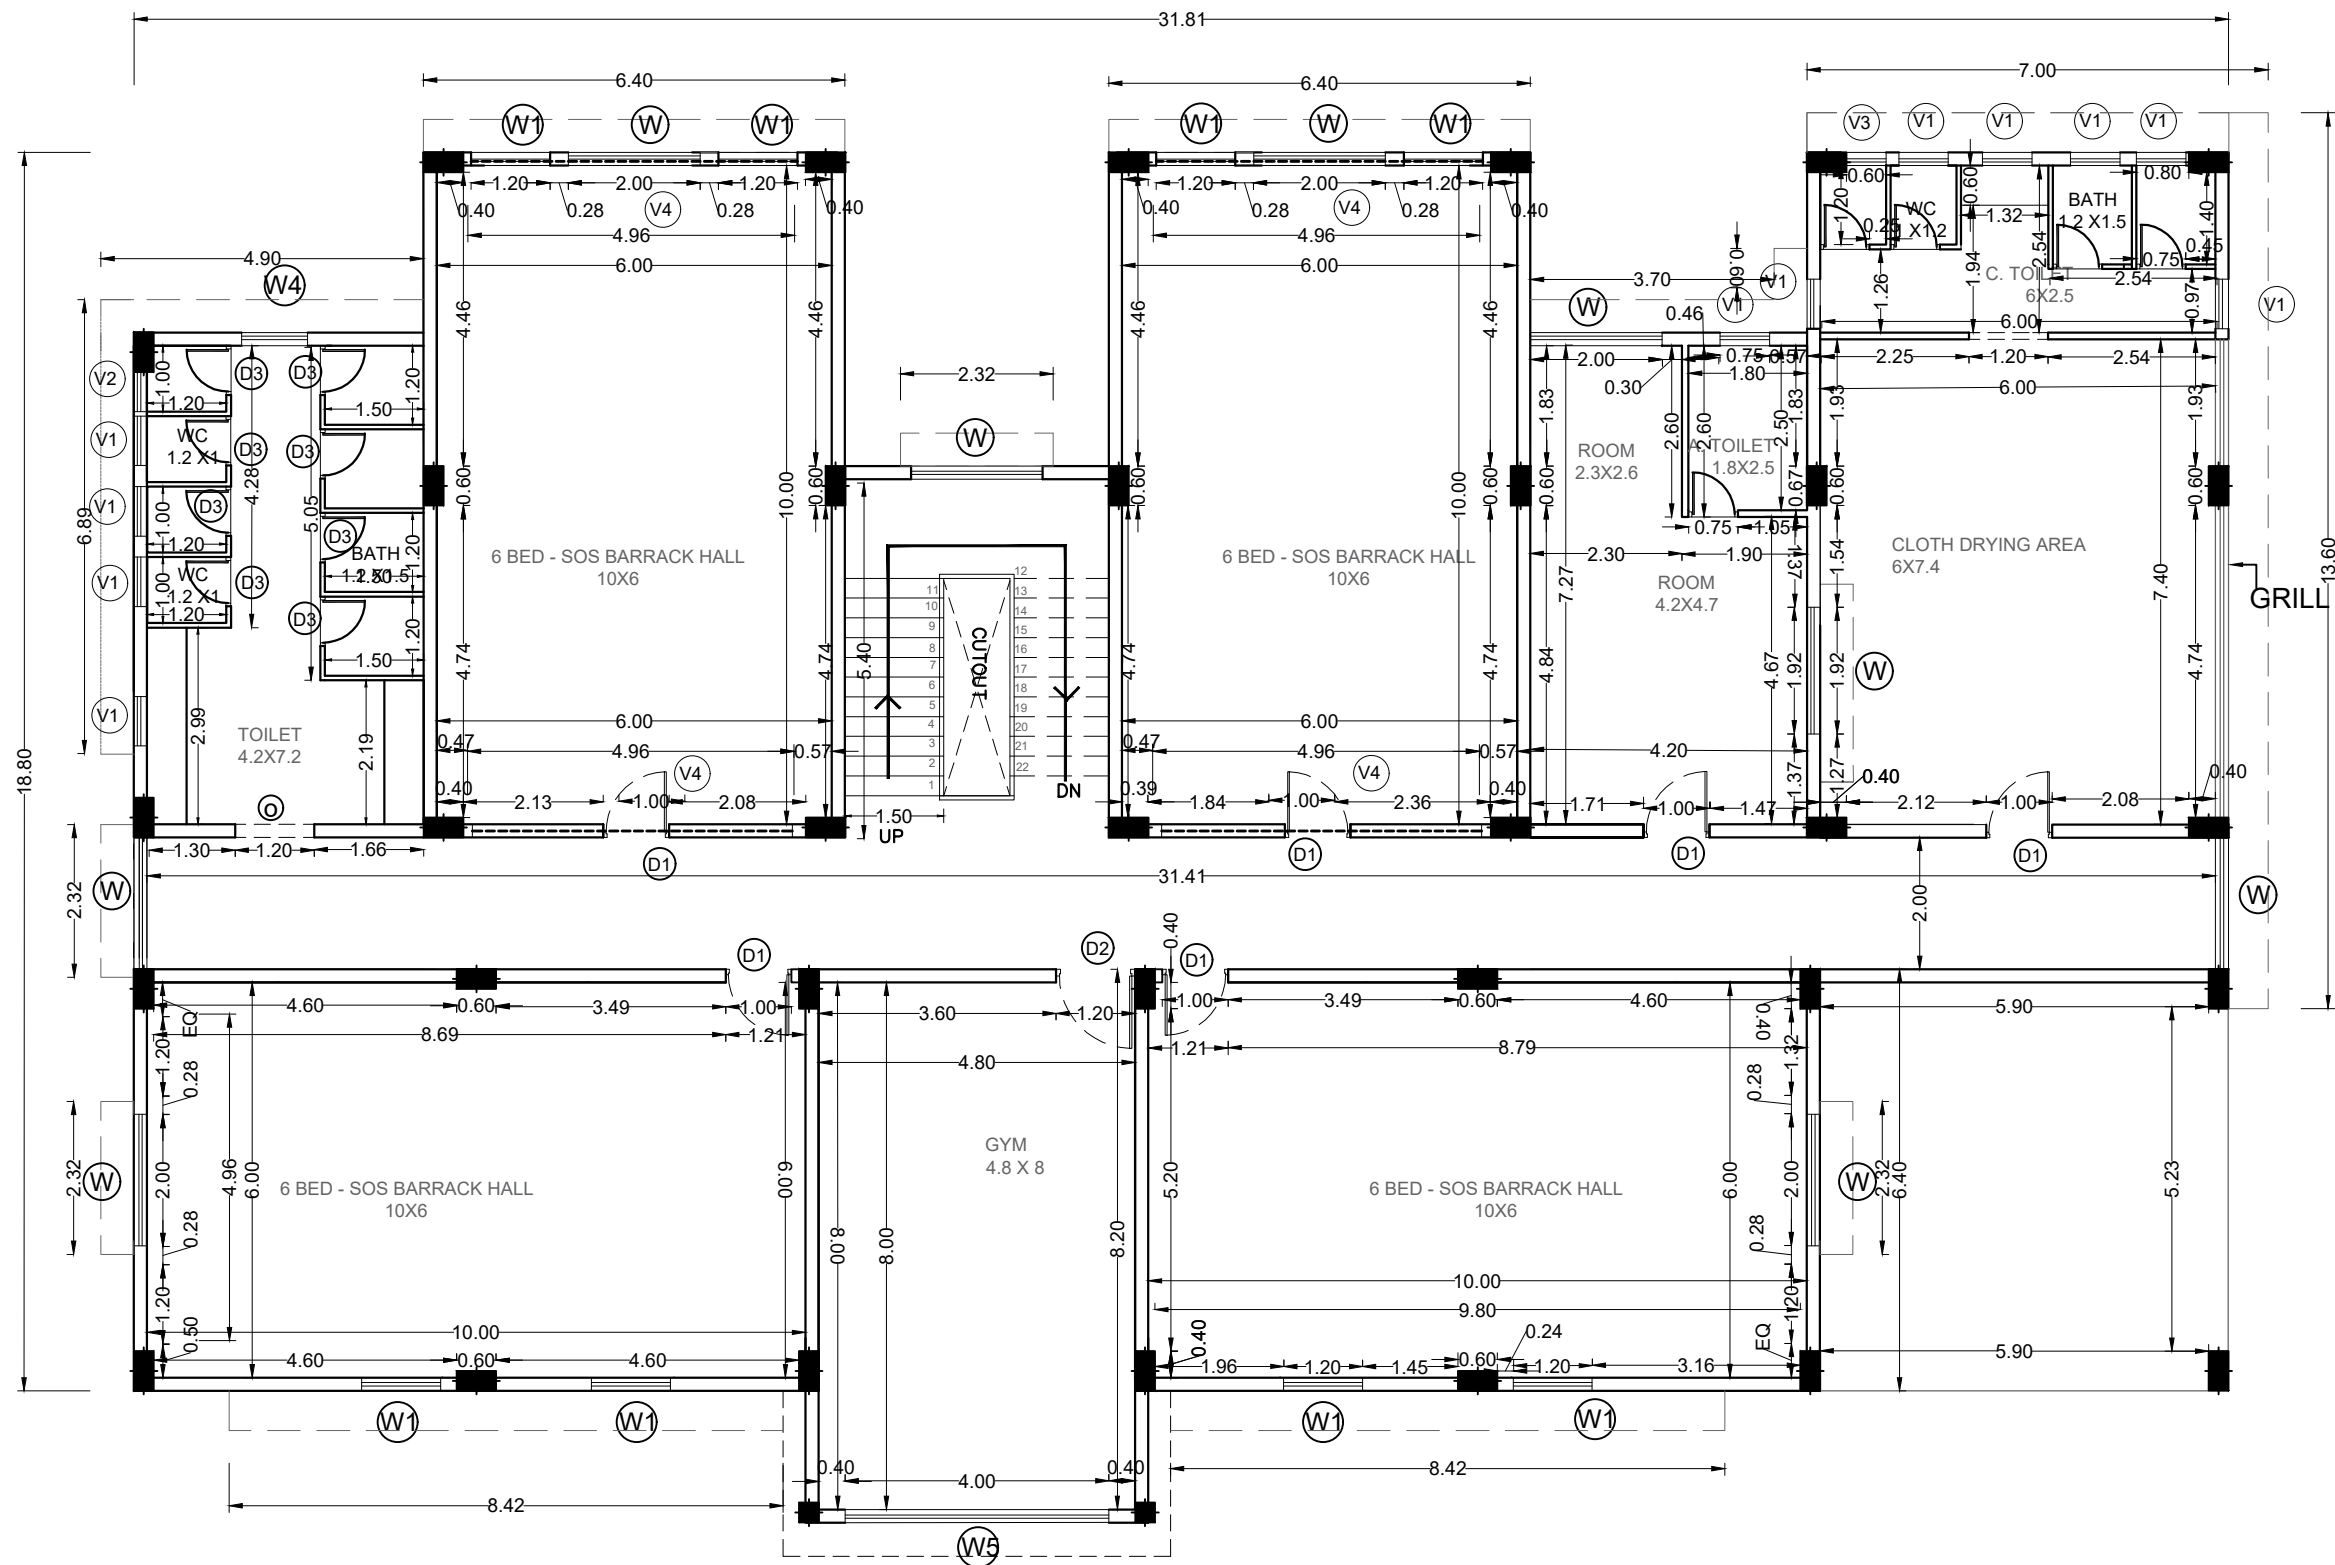

THIRD FLOOR PLAN

SCHEDULE OF OPENINGS		
DOORS		
	SIZE IN M	Nos
D1	1.00 X 2.10	6
D2	1.20 X 2.10	1
D3	0.75 X 2.10	13
WINDOWS		
W	2.00 X 1.50	9
W1	1.20 X 1.50	8
W4	1.00 X 0.75	1
W5	4.00 X 1.50	1
VENTILATORS		
V1	0.75X 0.75	11
V2	0.60X 0.75	2
V4	4.96 X 0.5	4
OPENING		
O	1.2X2.1	2

NOTE : ALL Chajja projection is 0.6m deep

TOILET PROPORTION 1:4

LEGEND:

THIRD FLOOR BUILT UP -529SQM
LIST OF FACILITIES
1. COMMON LOBBY
2. GYM ROOM
3.6 BED SOS BARRACK HALL - 24 BEDS
5.ROOM + A. TOILET
6.WASHROOM - 4 TOILET + 4 BATH
7. STAIRCASE
8. CLOTH DRYING AREA
9. WASHROOM - 2 TOILET + 2 BATH

NOTE : ALL DIMENSION IN METERS

PROJECT :
PROVIDING COMPREHENSIVE PROJECT
MANAGEMENT CONSULTANCY SERVICES FOR
PROPOSED CONSTRUCTION OF CISF
INFRASTRUCTURE BUILDINGS
AT NOTE MUDRAN NAGAR MYSORE

TENDER DRAWING

Page 17 of 129

BNPM - BARRACK FLOOR PLAN
WORKING DRAWING

Date : 30-10-2025

Drawn by: AMRUTHA

Rev Date: -----


Checked by: Ar. Kavitha



ARCHITECTS :
KULKARNI ASSOCIATES

Surya Prema Building, next to Adiga's Restaurant, Kanakapura Road
No-203, 2nd floor, Above Canara bank Raghuvahalli Branch
Raghuvahalli Village, Uttarahalli hobli Bangalore-560062

Email Id : kulkarni.associates@yahoo.com

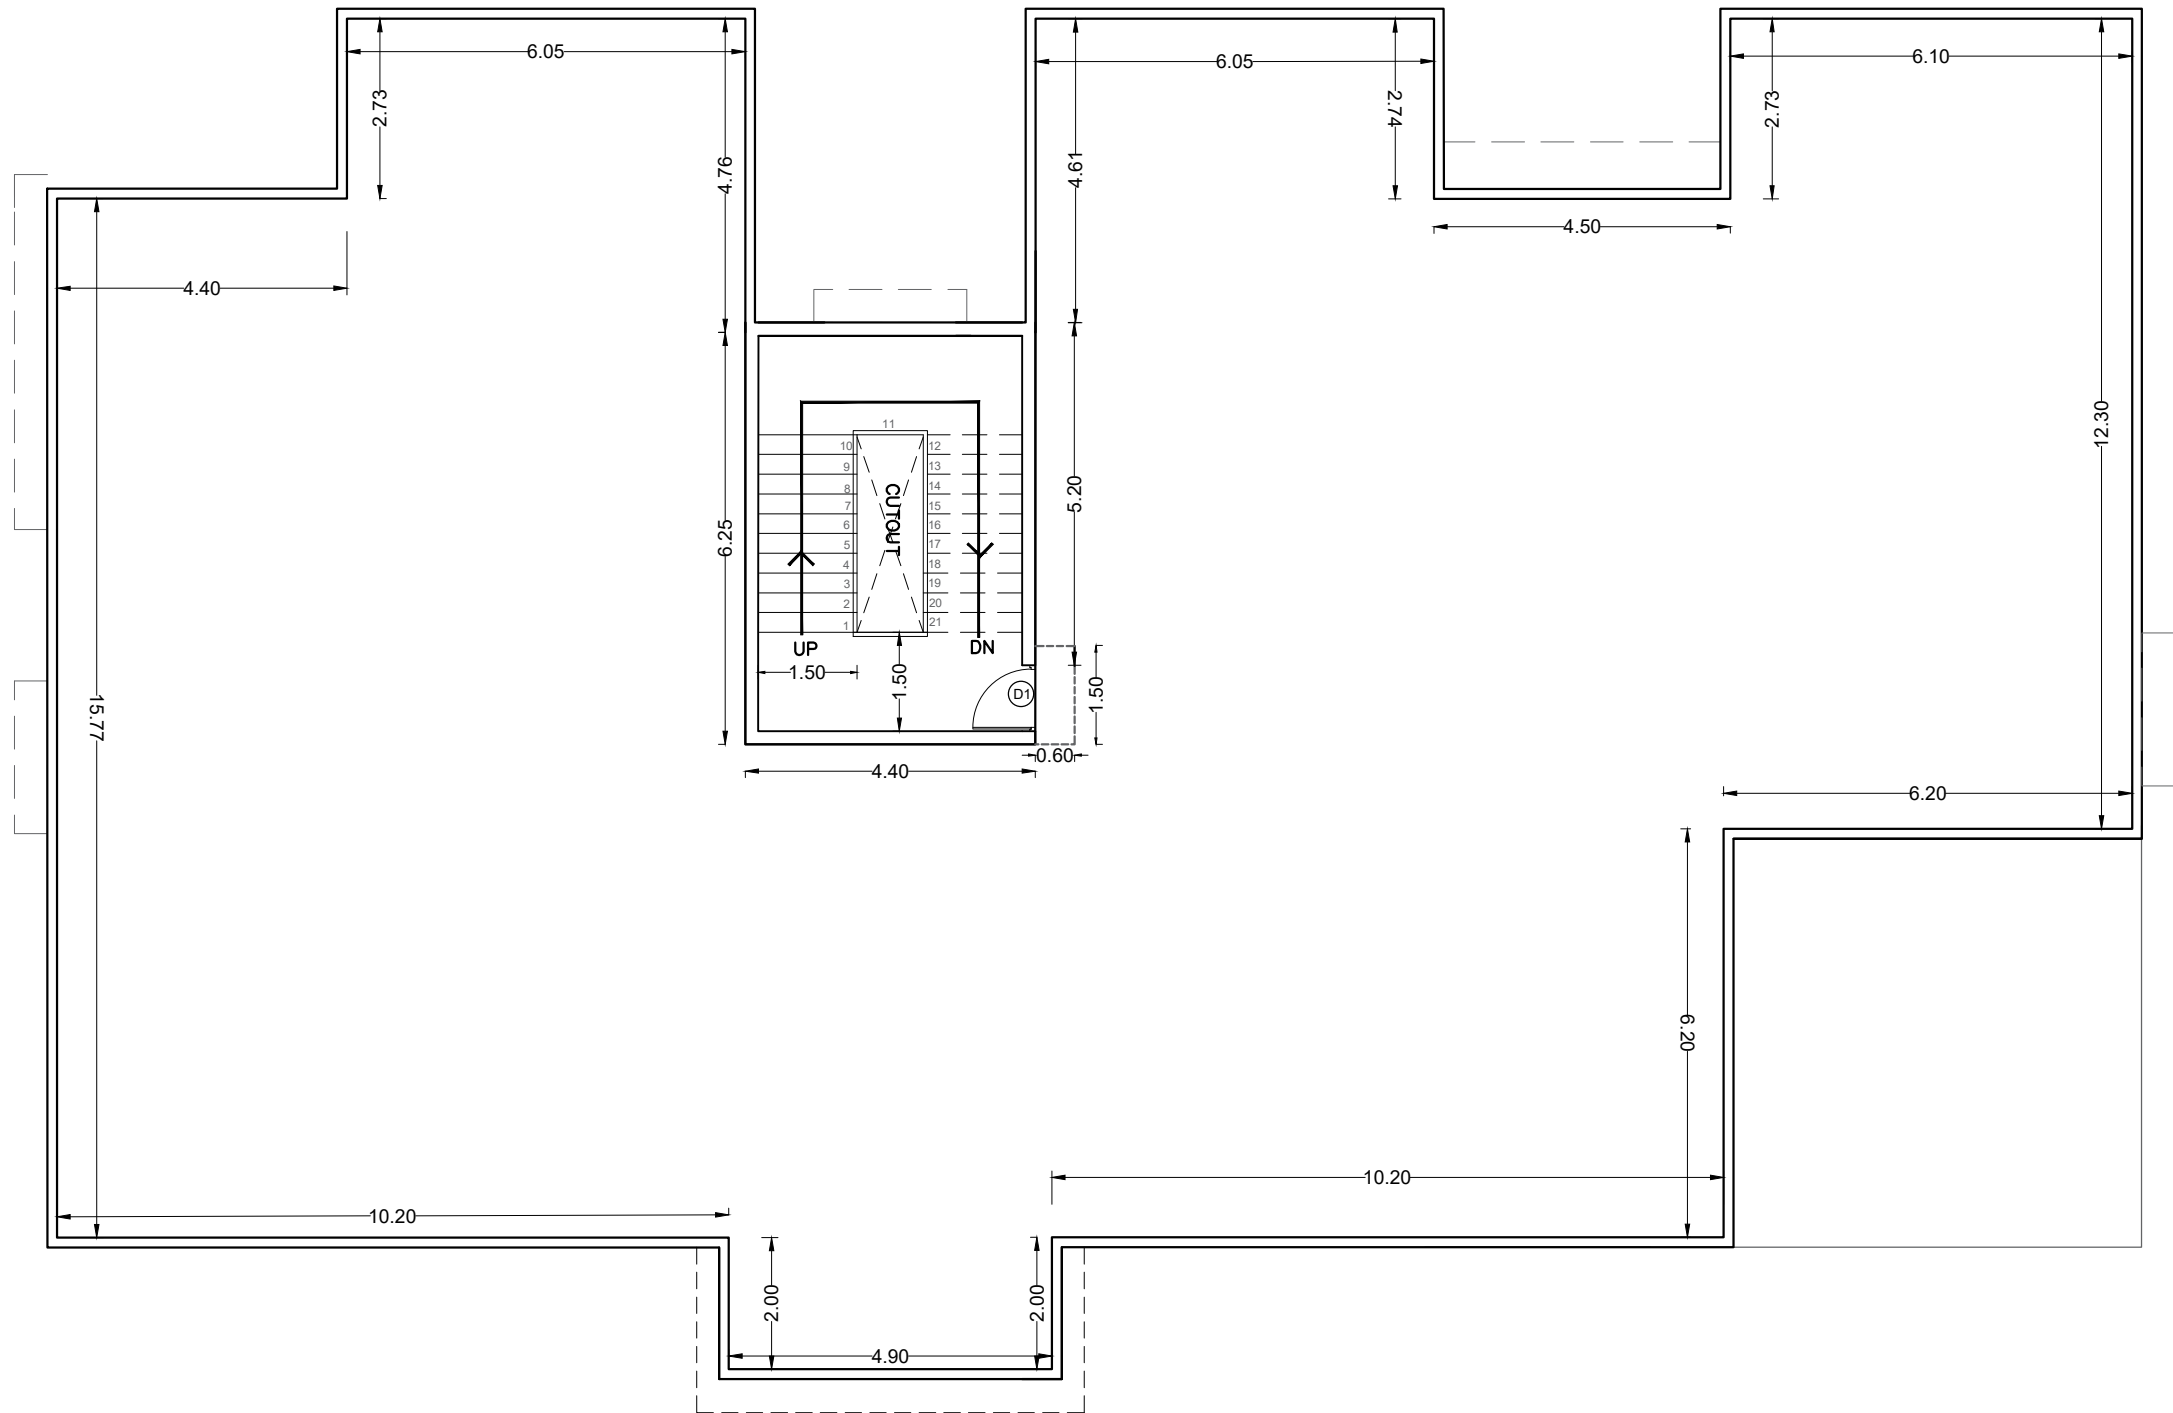

TERRACE FLOOR PLAN

SCHEDULE OF OPENINGS		
DOORS		
	SIZE IN M	Nos
D1	1.00 X 2.25	1
WINDOWS		
VENTILATORS		

NOTE : ALL DIMENSION IN METERS

PROJECT :
PROVIDING COMPREHENSIVE PROJECT
MANAGEMENT CONSULTANCY SERVICES FOR
PROPOSED CONSTRUCTION OF CISF
INFRASTRUCTURE BUILDINGS
AT NOTE MUDRAN NAGAR MYSORE

TENDER DRAWING

BNPM - BARRACK FLOOR PLAN
WORKING DRAWING

Date : 30-10-2025

Drawn by: AMRUTHA

Rev Date: -----


Checked by: Ar. Kavitha



ARCHITECTS :
KULKARNI ASSOCIATES

Surya Prema Building,next to Adiga's Restaurant,Kanakapura Road
No-203,2nd floor,Above Canara bank Raghuvahalli Branch
Raghuvanhalli Village,Uttarahalli hobli Bangalore-560062

Email Id : kulkarni.associates@yahoo.com

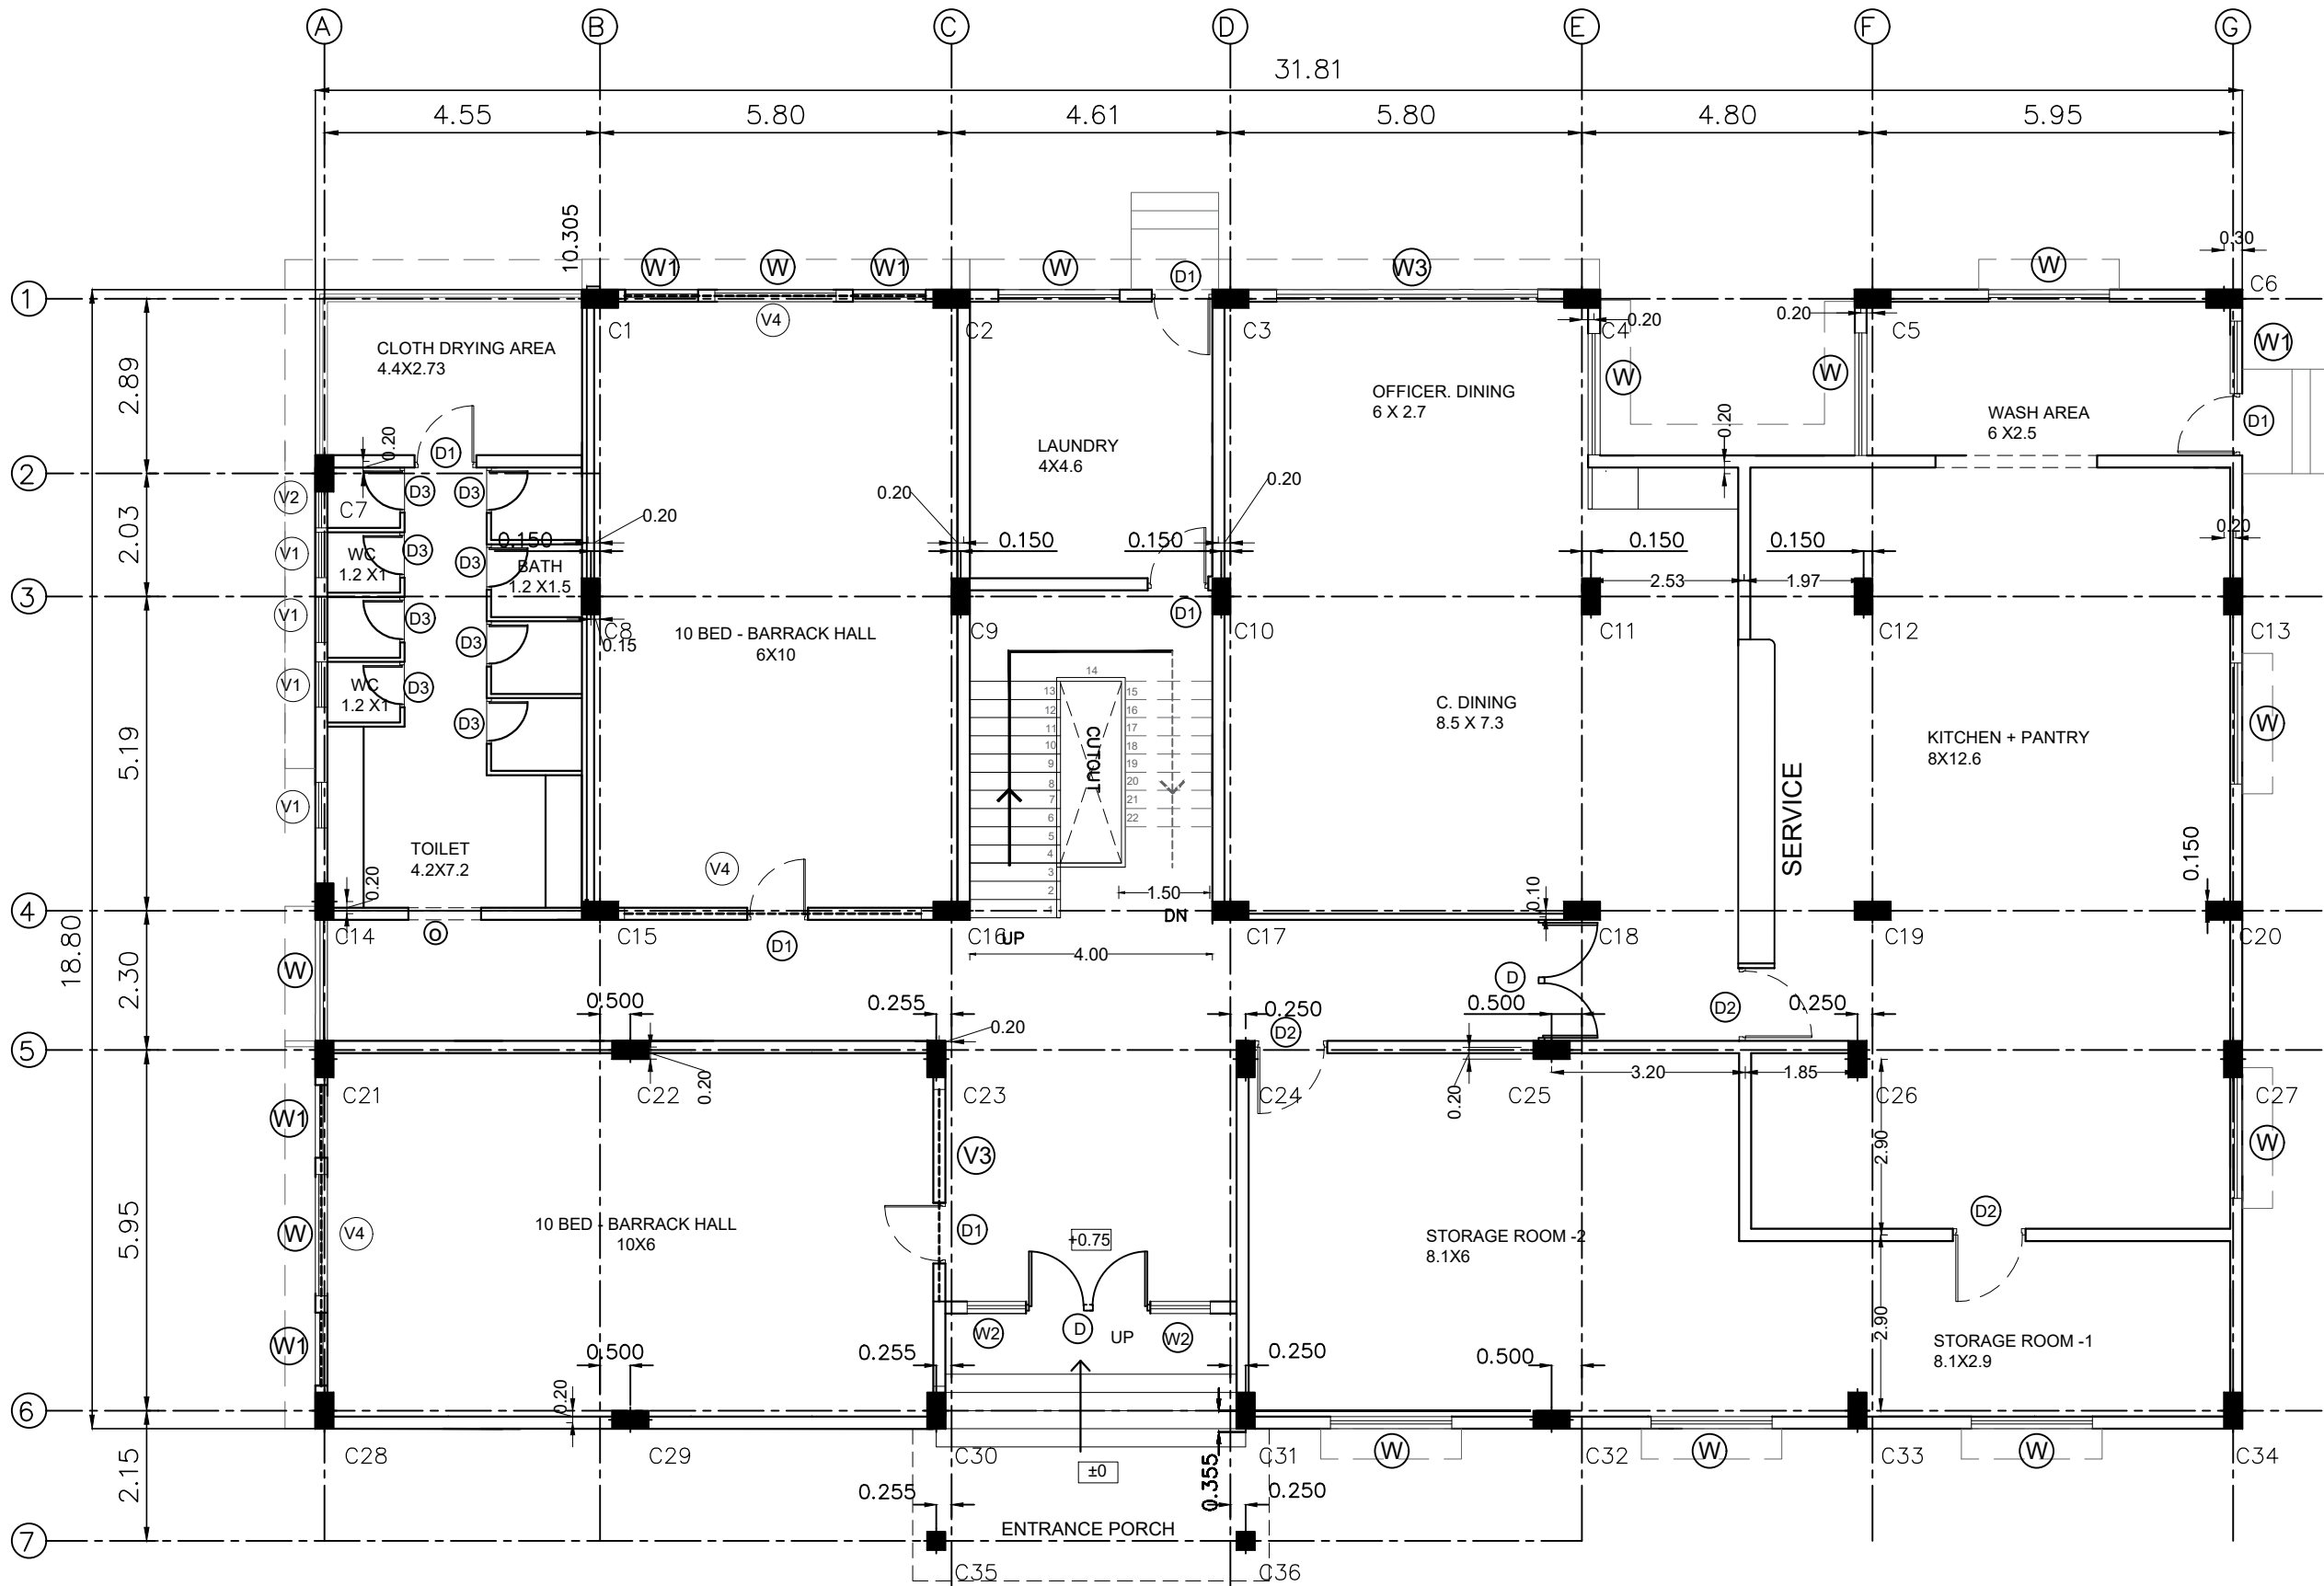

GROUND FLOOR PLAN

SCHEDULE OF OPENINGS		
DOORS		
	SIZE IN M	Nos
D	2.00 X 2.10	2
D1	1.00 X 2.10	6
D2	1.20 X 2.10	3
D3	0.75 X 2.10	8
WINDOWS		
W	2.00 X 1.50	12
W1	1.20 X 1.50	5
W3	4.31 X 1.50	1
VENTILATORS		
V1	0.75X 0.75	4
V2	0.60X 0.75	1
V3	3.07X 0.5	1
V4	4.96 X 0.5	3
OPENING		
O	1.2X2.1	1

TOILET PROPORTION 1:5

LEGEND:
GROUND FLOOR BUILT UP - 589SQM
LIST OF FACILITIES
1. ENTRANCE LOBBY
2. STORAGE ROOM
3. KITCHEN
4. WASH AREA
5. DINING AREA - 60 SEATING
6. BARRACK HALL - 2X10 =20 BEDS
7. WASHROOM - 1X4 TOILET +1X4 BATH
8. STAIRCASE
9. LAUNDRY
10. CLOTH DRYING AREA

NOTE : ALL DIMENSION IN METERS

PROJECT :
PROVIDING COMPREHENSIVE PROJECT
MANAGEMENT CONSULTANCY SERVICES FOR
PROPOSED CONSTRUCTION OF CISF
INFRASTRUCTURE BUILDINGS
AT NOTE MUDRAN NAGAR MYSORE


TENDER DRAWING

BNPM - BARRACK FLOOR PLAN
CENTER LINE PLAN

Date : 30-10-2025	Drawn by: AMRUTHA
Rev Date:	Checked by: Ar. Kavitha



ARCHITECTS :
KULKARNI ASSOCIATES
Surya Prema Building, next to Adiga's Restaurant, Kanakapura Road
No-203, 2nd floor, Above Canara bank Raghuvahalli Branch
Raghuvahalli Village, Uttarahalli hobli Bangalore-560062
Email Id : kulkarni.associates@yahoo.com

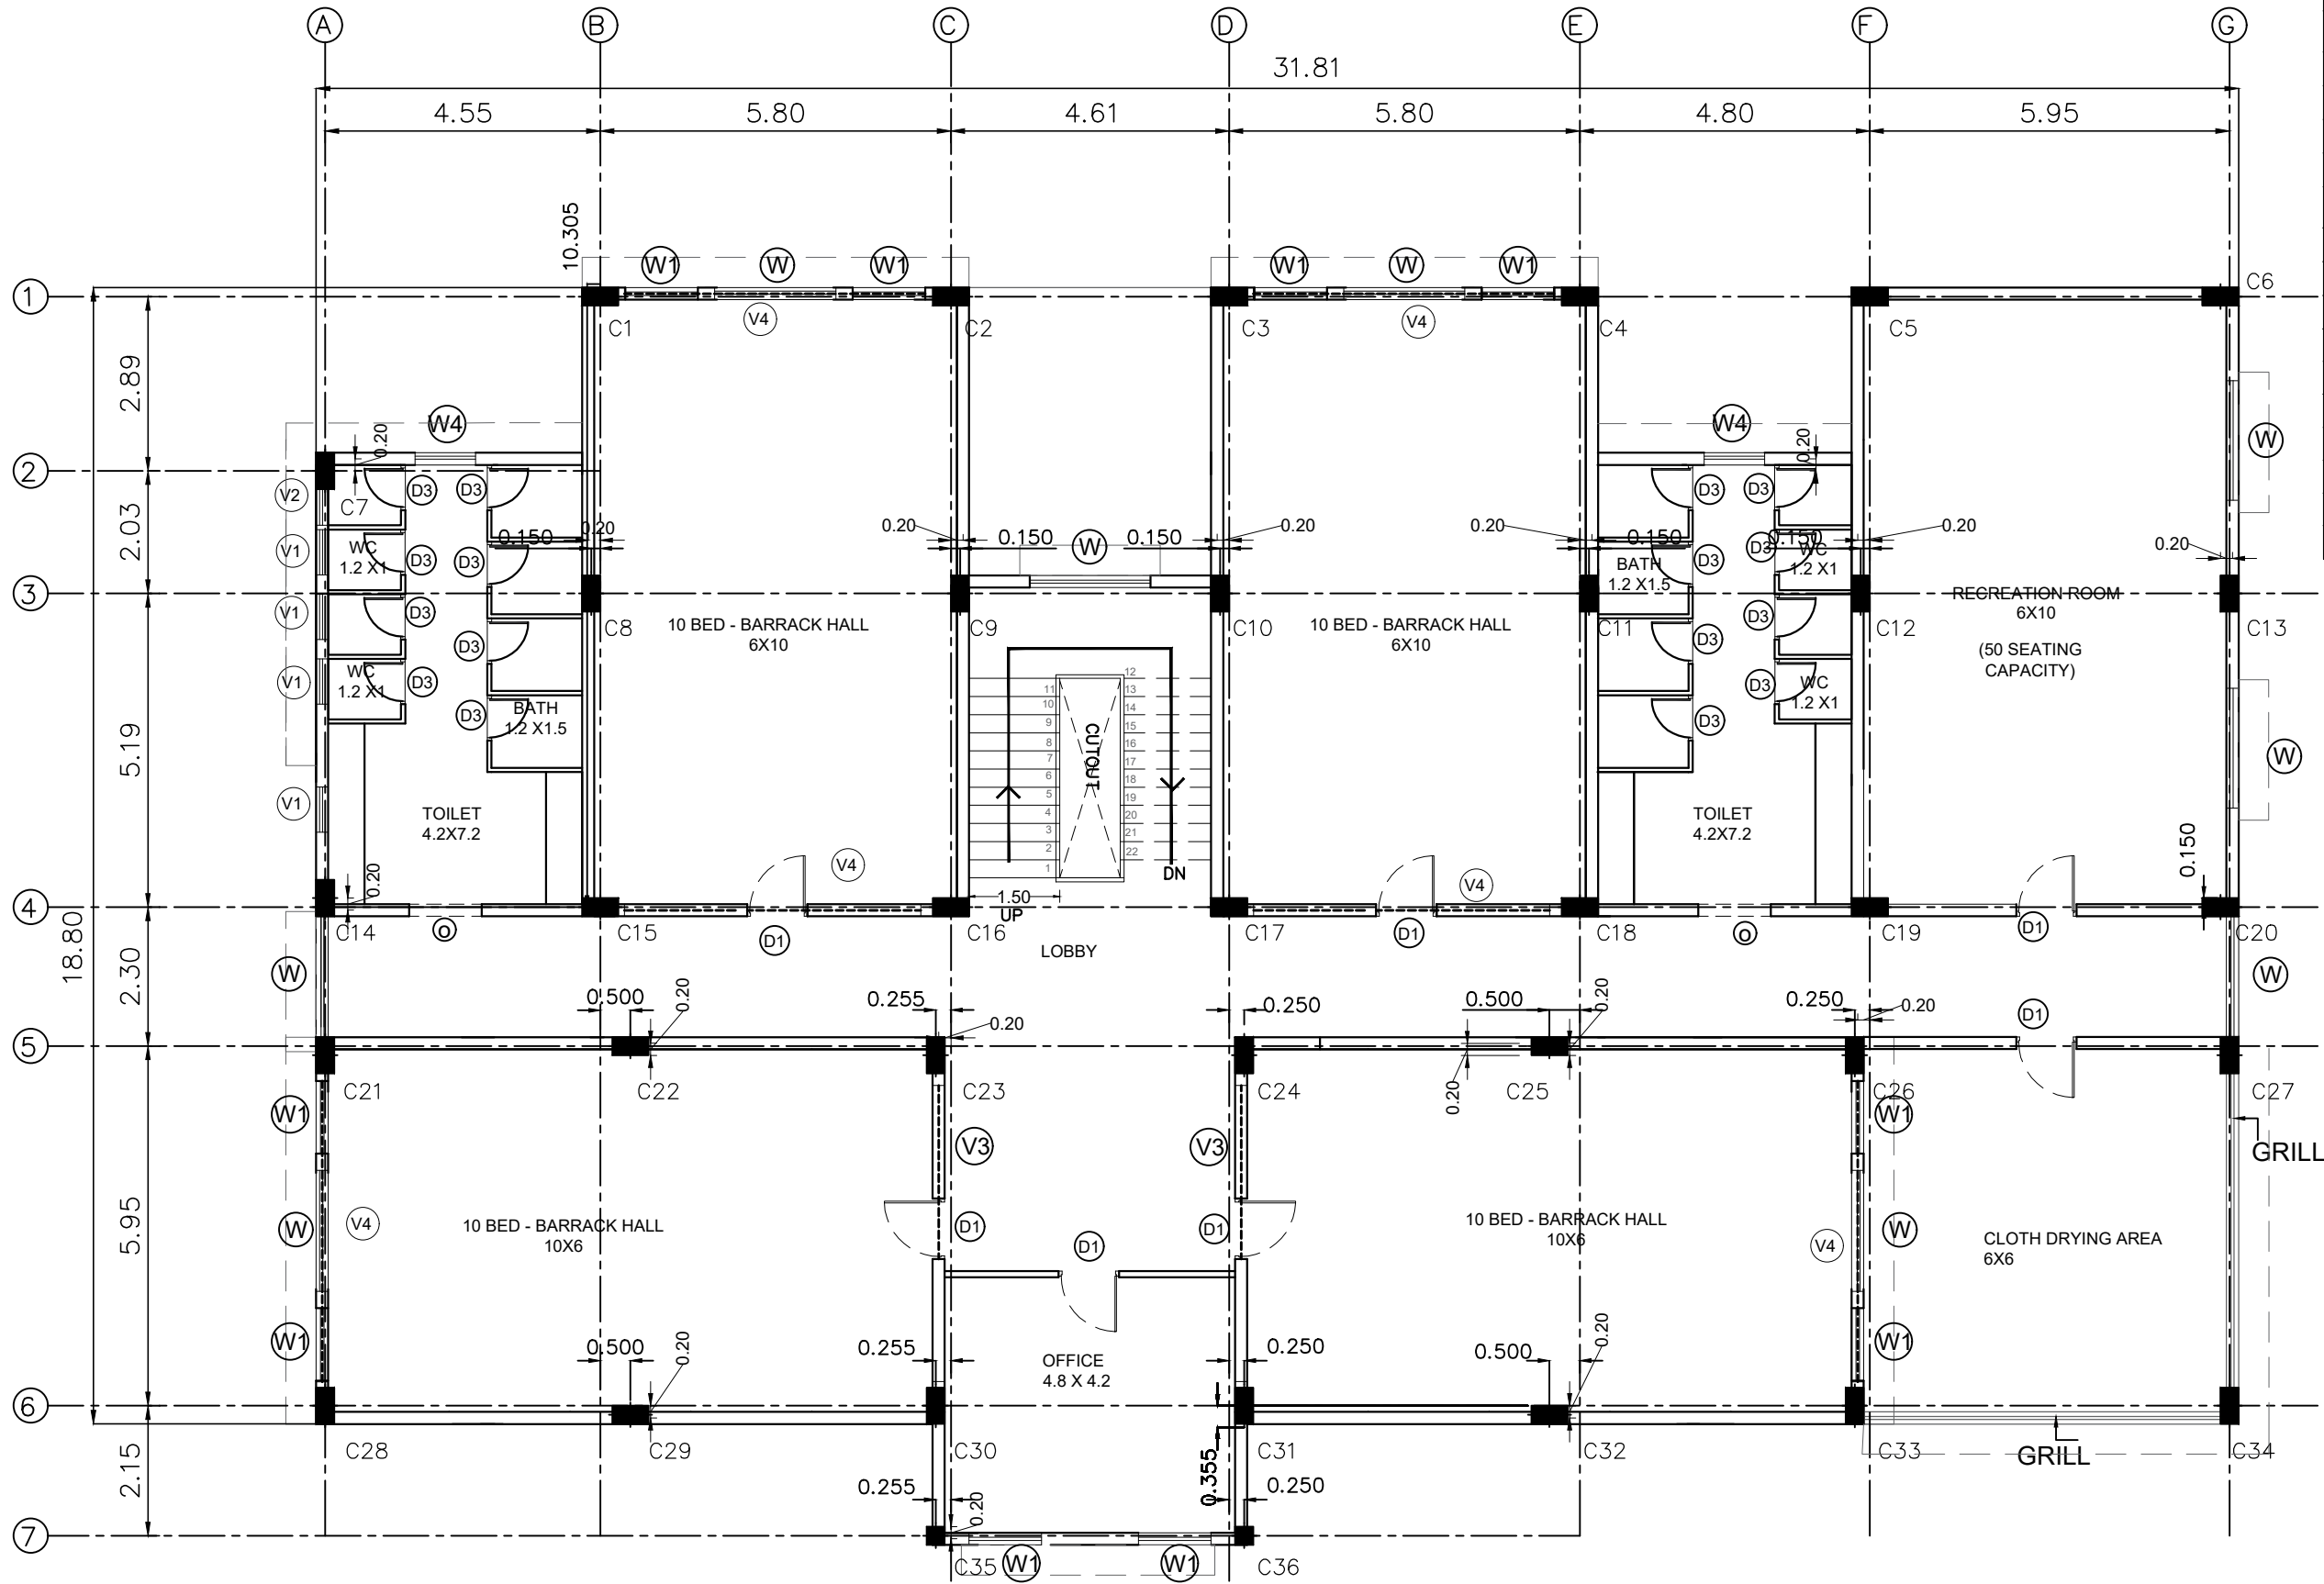

FIRST FLOOR PLAN

SCHEDULE OF OPENINGS		
DOORS		
	SIZE IN M	Nos
D1	1.00 X 2.10	7
D3	0.75 X 2.10	16
WINDOWS		
W	2.00 X 1.50	9
W1	1.20 X 1.50	8
W4	1.00 X 0.75	2
VENTILATORS		
V1	0.75X 0.75	5
V2	0.60X 0.75	1
V3	3.07X 0.5	2
V4	4.96 X 0.5	6
OPENING		
O	1.2X2.1	2

TOILET PROPORTION 1:5

LEGEND:

FIRST FLOOR BUILT UP -567SQM

LIST OF FACILITIES

1. COMMON LOBBY

2. OFFICE ROOM

3. BARRACK HALL - 4X10= 40 BEDS

4.WASHROOM - 2X4 TOILET + 2X4 BATH

5. STAIRCASE

6. CLOTH DRYING AREA

7. RECREATION ROOM - 50 SEATING

NOTE : ALL DIMENSION IN METERS

PROJECT :
PROVIDING COMPREHENSIVE PROJECT
MANAGEMENT CONSULTANCY SERVICES FOR
PROPOSED CONSTRUCTION OF CISF
INFRASTRUCTURE BUILDINGS
AT NOTE MUDRAN NAGAR MYSORE

TENDER DRAWING

Page 20 of 129

BNPM - BARRACK FLOOR PLAN
CENTER LINE PLAN

Date : 30-10-2025

Drawn by: AMRUTHA

Checked by: Ar. Kavitha


Rev Date:



ARCHITECTS :
KULKARNI ASSOCIATES

Surya Prema Building, next to Adiga's Restaurant, Kanakapura Road
No-203, 2nd floor, Above Canara bank Raghuvahalli Branch
Raghuvahalli Village, Uttarahalli hobli Bangalore-560062

Email Id : kulkarni.associates@yahoo.com

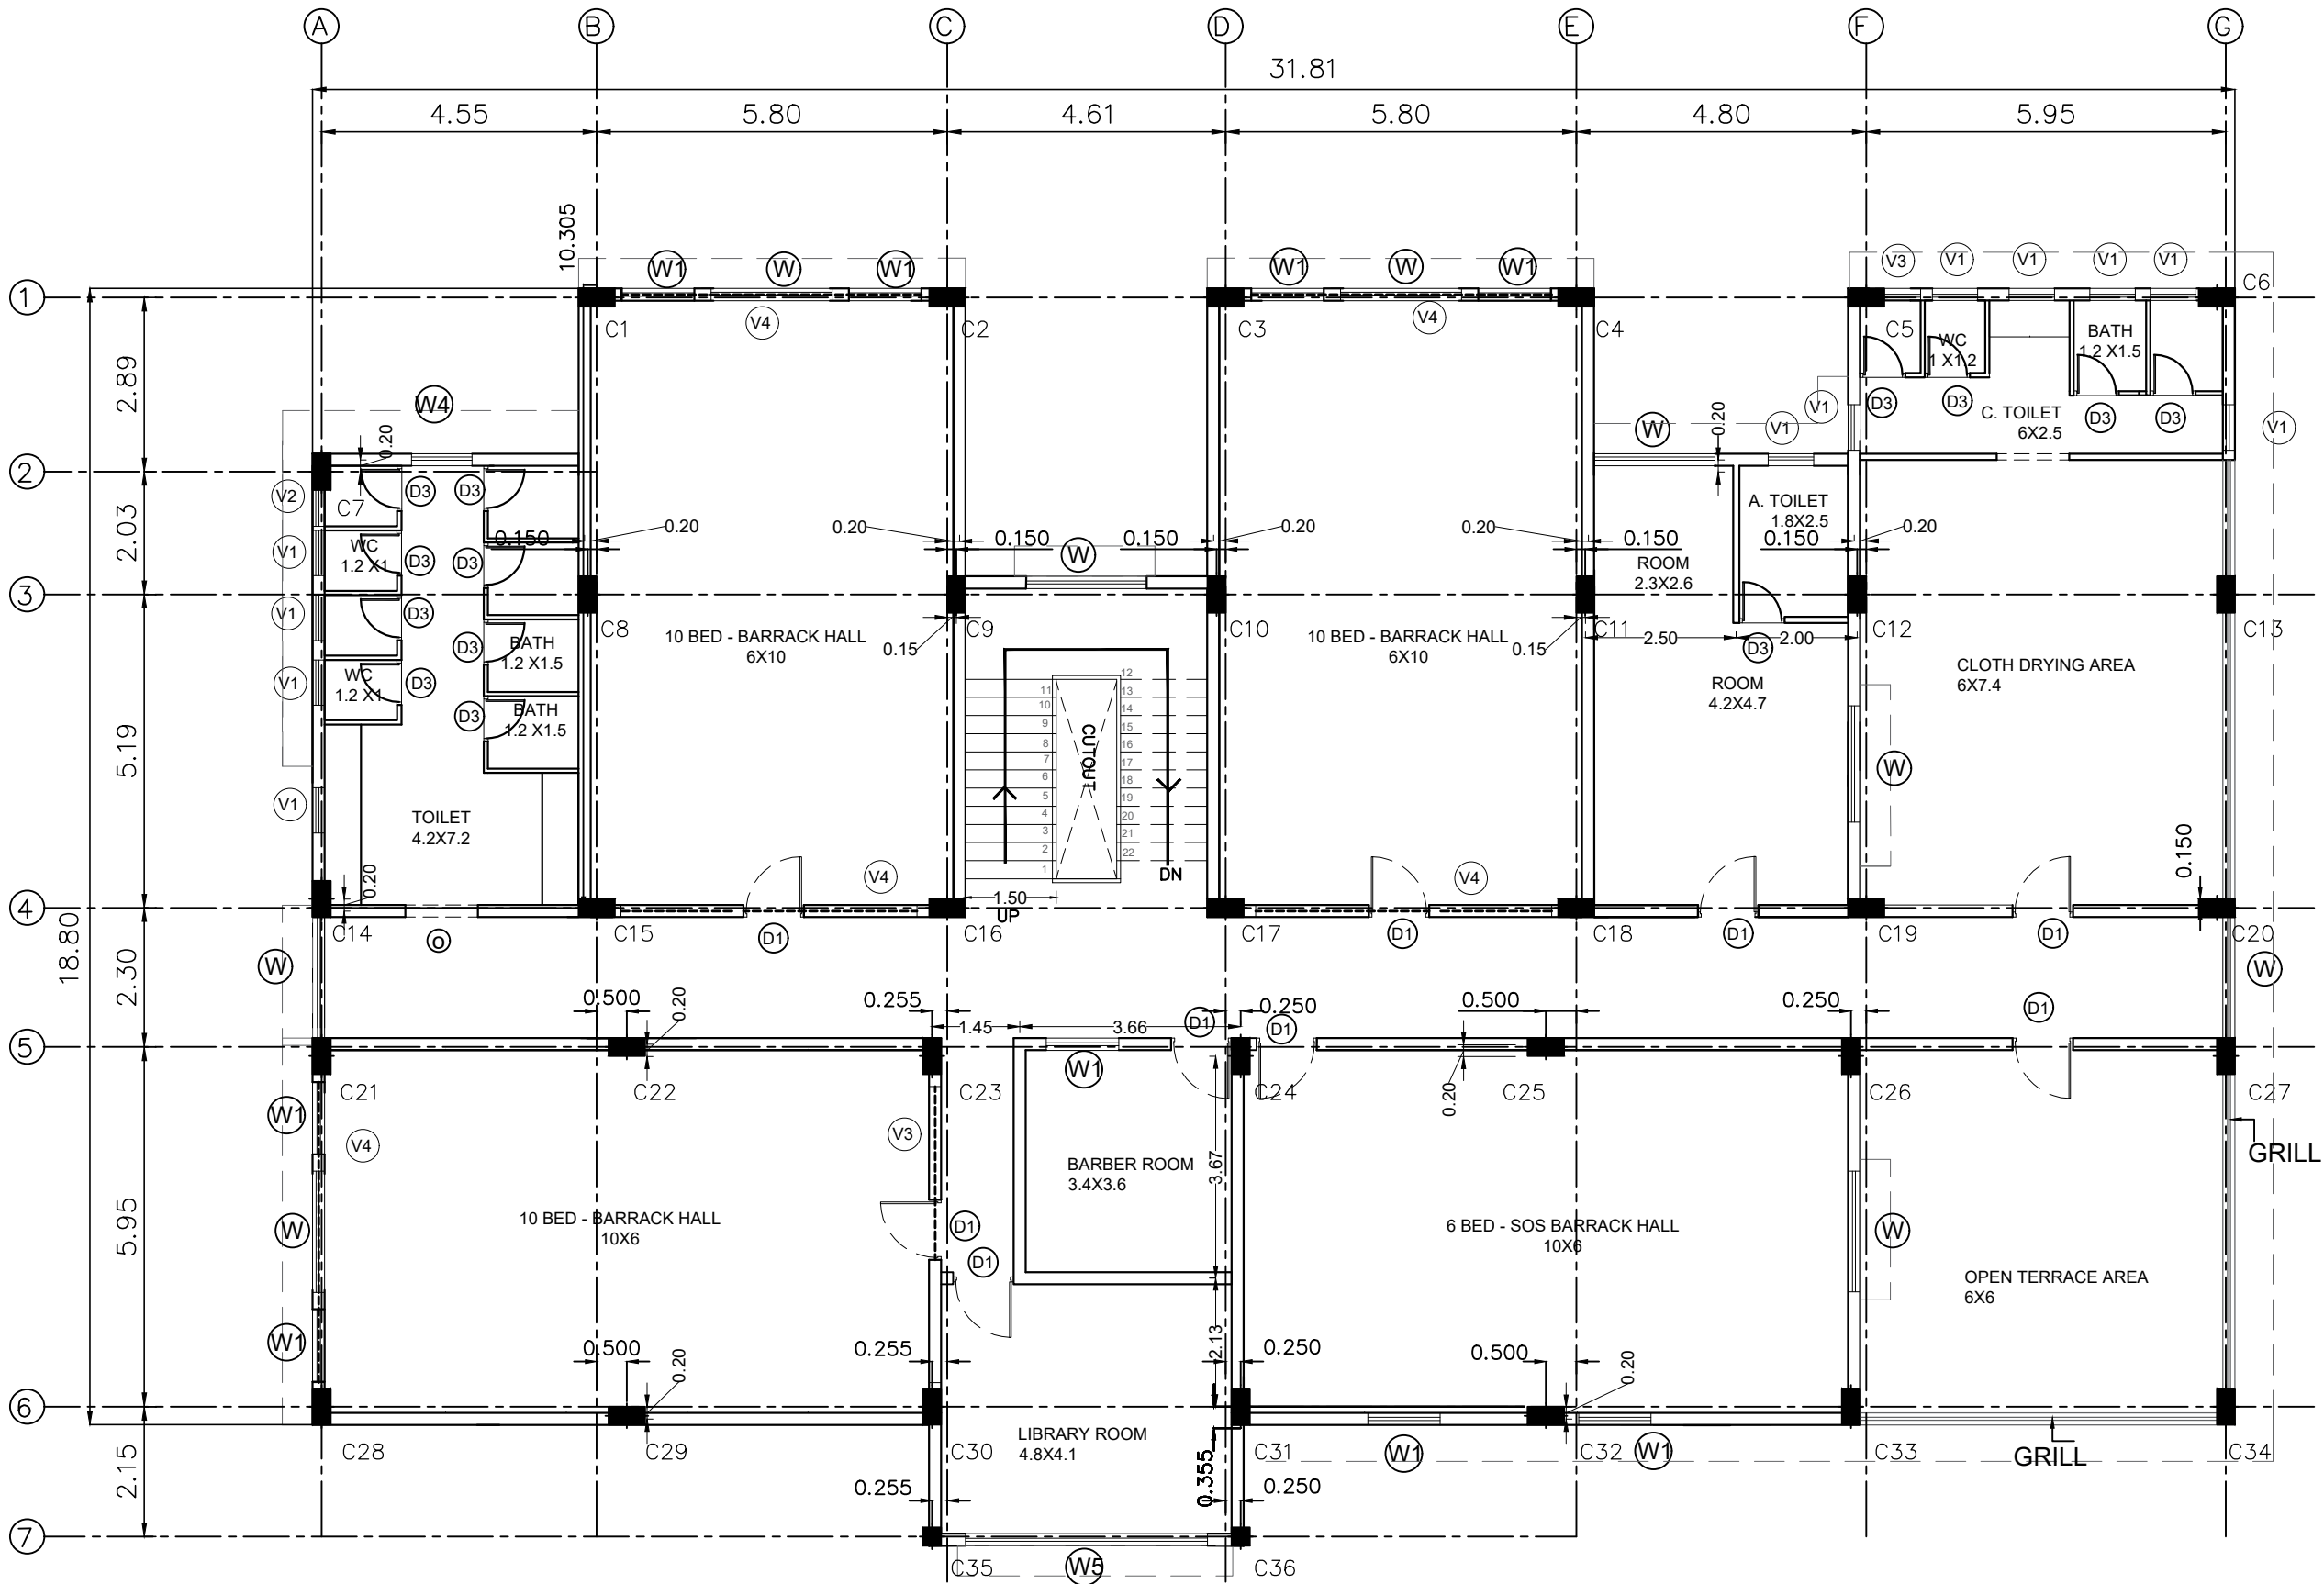

SECOND FLOOR PLAN

SCHEDULE OF OPENINGS		
DOORS		
	SIZE IN M	Nos
D1	1.00 X 2.10	9
D3	0.75 X 2.10	13
WINDOWS		
W	2.00 X 1.50	9
W1	1.20 X 1.50	9
W4	1.00 X 0.75	1
W5	4.00 X 1.50	1
VENTILATORS		
V1	0.75X 0.75	11
V2	0.60X 0.75	2
V3	3.07X 0.5	1
V4	4.96 X 0.5	5
OPENING		
O	1.2X2.1	2

TOILET PROPORTION 1:6

LEGEND:

SECOND FLOOR BUILT UP -529SQM

LIST OF FACILITIES

1. COMMON LOBBY
2. LIBRARY ROOM
3. 10 BED BARRACK HALL - 30 BEDS
4. 6 BED SOS BARRACK HALL - 6 BEDS
5. ROOM + A. TOILET
6. WASHROOM - 4 TOILET + 4 BATH
7. STAIRCASE
8. BARBER ROOM
9. CLOTH DRYING AREA
10. WASHROOM - 2 TOILET + 2 BATH

NOTE : ALL DIMENSION IN METERS

PROJECT :
PROVIDING COMPREHENSIVE PROJECT
MANAGEMENT CONSULTANCY SERVICES FOR
PROPOSED CONSTRUCTION OF CISF
INFRASTRUCTURE BUILDINGS
AT NOTE MUDRAN NAGAR MYSORE

TENDER DRAWING

BNPM - BARRACK FLOOR PLAN
CENTER LINE PLAN

Date : 30-10-2025

Drawn by: AMRUTHA

Rev Date: -----


Checked by: Ar. Kavitha



ARCHITECTS :
KULKARNI ASSOCIATES

Surya Prema Building, next to Adiga's Restaurant, Kanakapura Road
No-203, 2nd floor, Above Canara bank Raghuvahalli Branch
Raghuvahalli Village, Uttarahalli hobli Bangalore-560062

Email Id : kulkarni.associates@yahoo.com

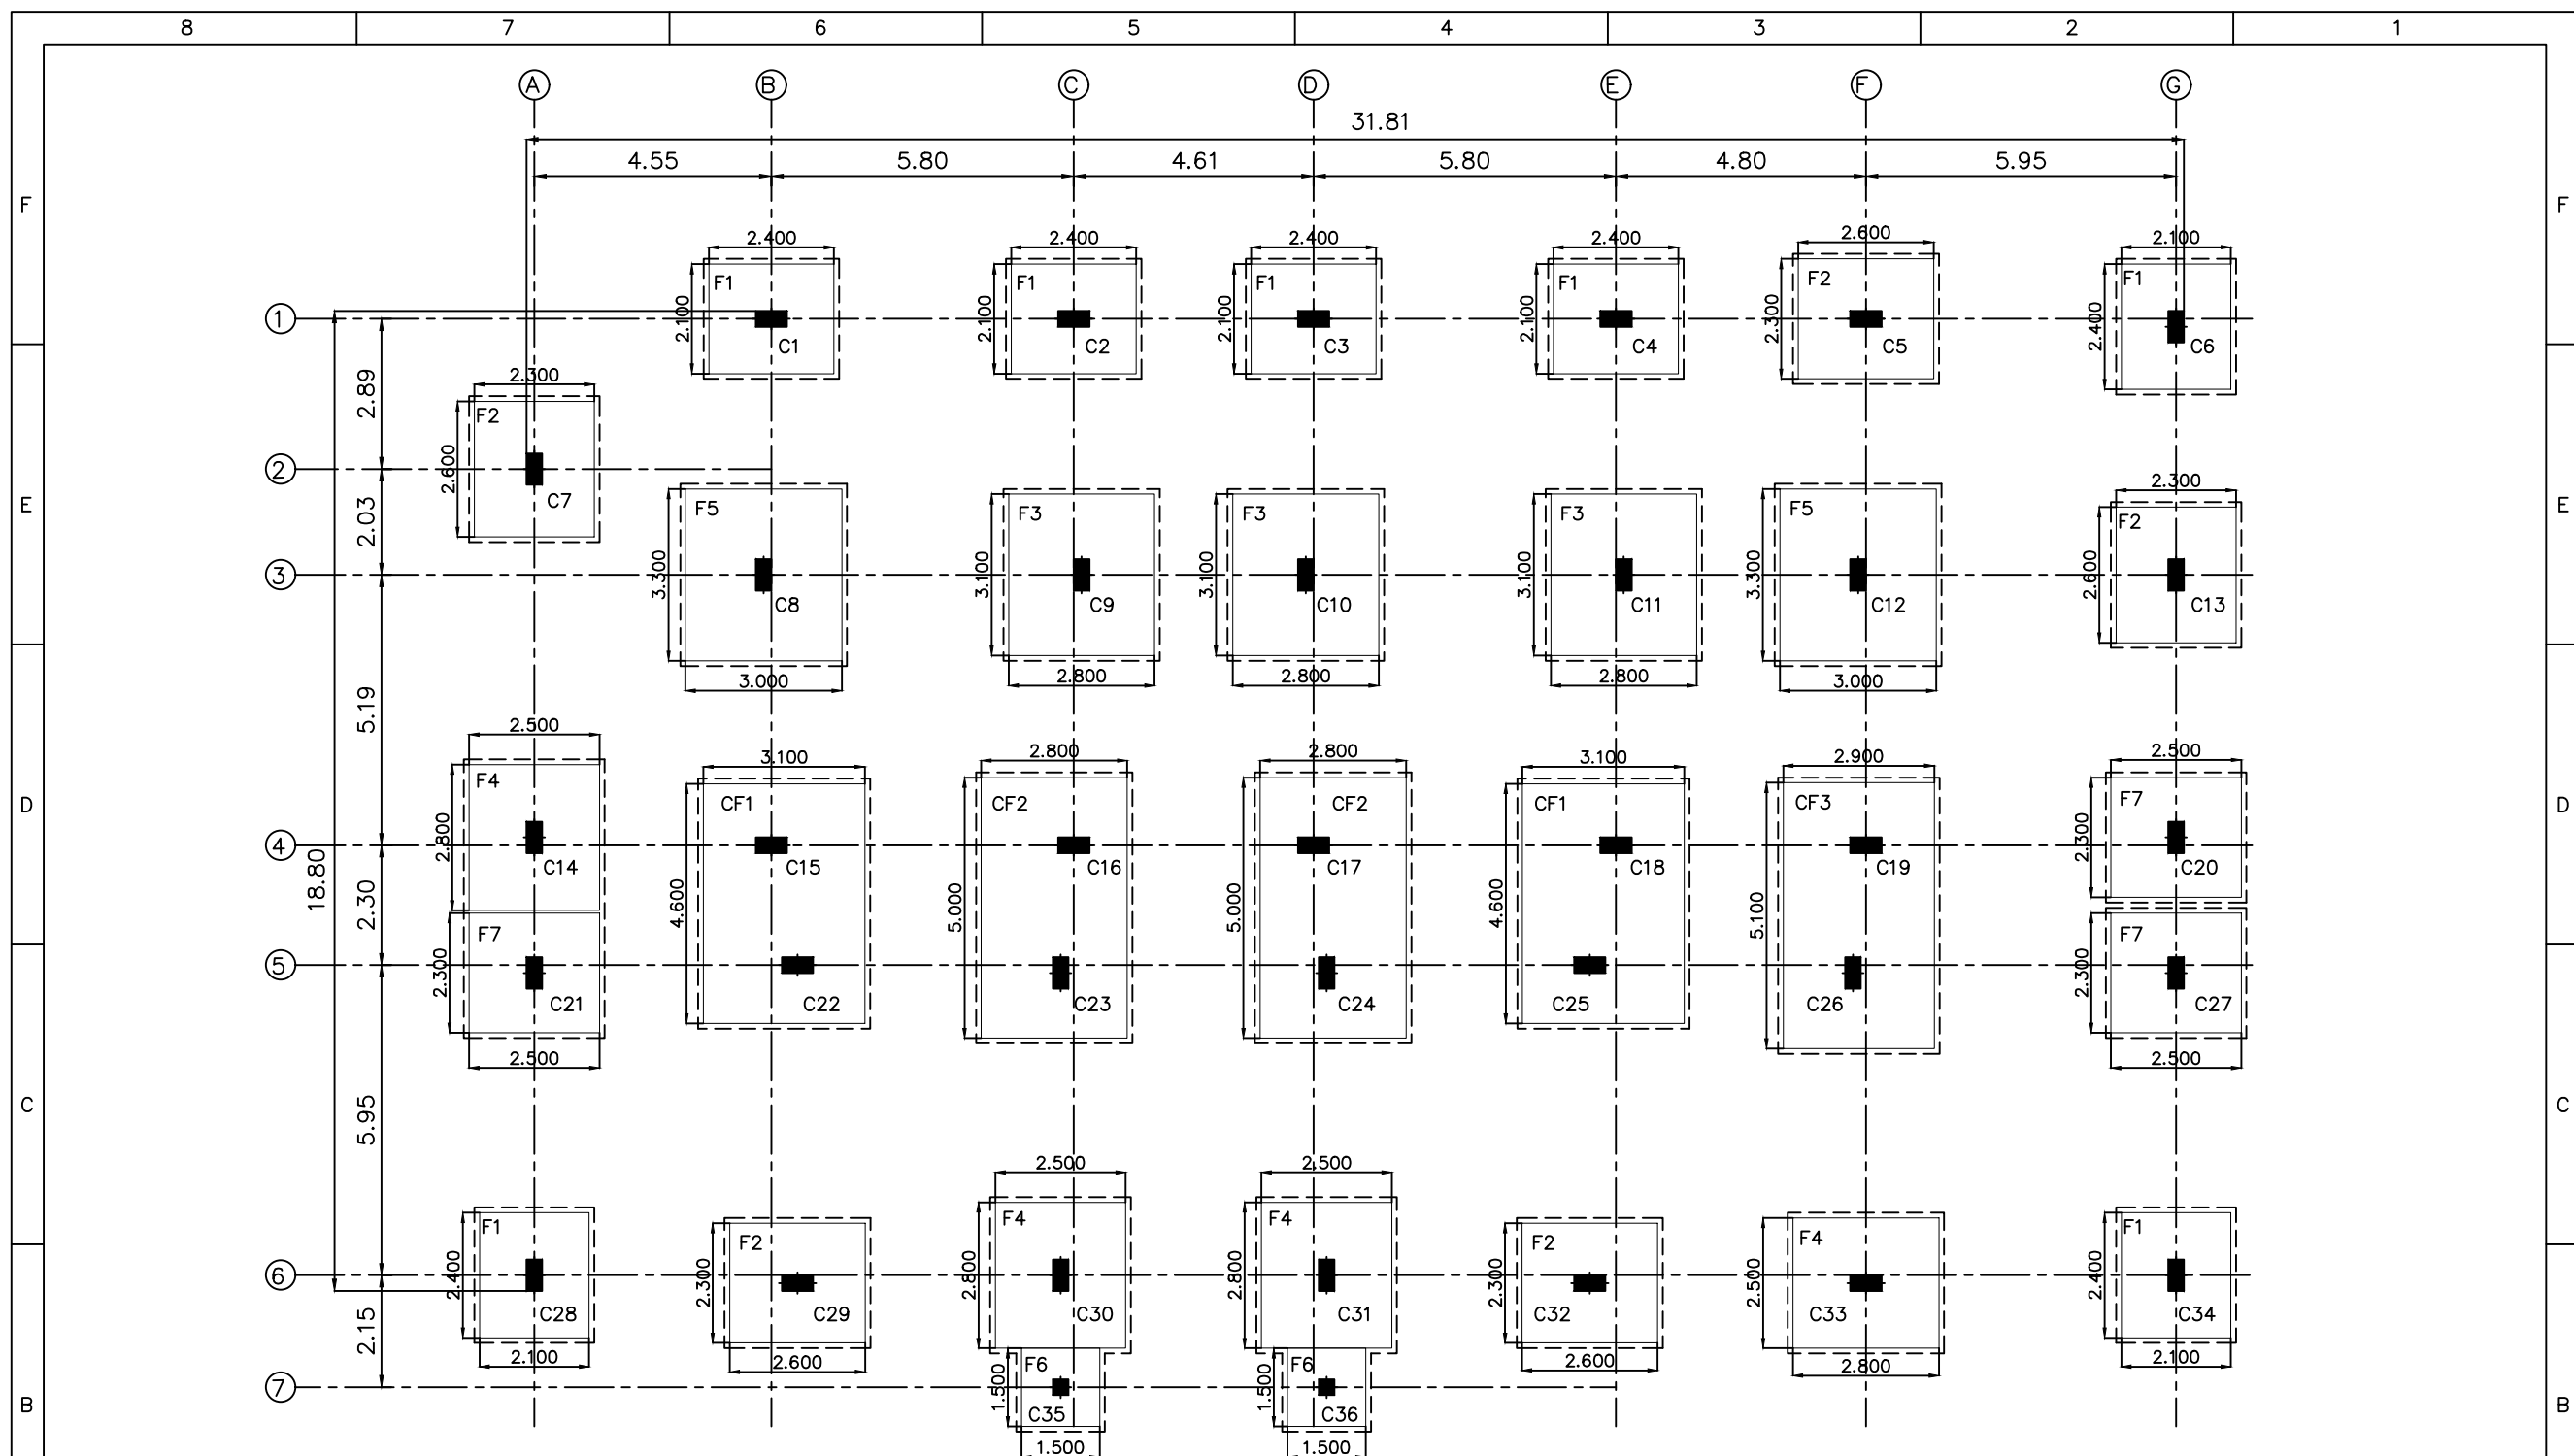

EXCAVATION LAYOUT OF FOOTINGS
EXCAVATION SHALL BE 100 MM ALL ROUND FOOTINGS

ARCHITECT
KULKARNI ASSOCIATES
Surya Prema Building, next to Adiga's Restaurant, Kanakapura Road
No-203, 2nd floor, Above Canara bank Raghuvahalli Branch
Raghuvahalli Village, Uttarahalli hobli Bangalore-560062
Email Id : kulkarni.associates@yahoo.com



TITLE
**EXCAVATION LAYOUT
OF FOOTINGS
(BNPM-MENS BARRACK)**


PROJECT
PROVIDING COMPREHENSIVE PROJECT MANAGEMENT
CONSULTANCY SERVICES FOR PROPOSED CONSTRUCTION OF
CISF INFRASTRUCTURE BUILDINGS AT NOTE MUDRAN NAGAR MYSORE


TENDER DRAWING


SCALE: N.T.S	DRAWN: GM	APPD:
PLOT SIZE: A3	DESIGNED: SSN	SHEET NO.: 01 OF 01
DATE: 30.10.2025	CHECKED: DG	REV. NO.: R0
STATUS ☐ APPROVAL ☐ PERUSAL ☒ FOR QUANTITY PURPOSE ☐ GOOD FOR CONSTRUCTION		JOB NO. ECPL-D/10-2025/131 DRAWING No. ECPL/KA/BNPM-MENS BARRACK/ST-02

NOTES:-
1. ALL DIMENSIONS ARE IN METERS.
2. FOLLOW FIGURED DIMENSION ONLY.
3. GRADE OF CONCRETE - M30.
4. GRADE OF STEEL-FE500.
5. CLEAR COVER TO MAIN REINF.
FOR FOOTING -50MM, FOR COLUMNS -40MM.
6. ANY DISCREPANCY IN DRAWING SHALL BE
BROUGHT TO THE NOTICE OF STRUCTURAL
CONSULTANTS BEFORE PROCEEDING WITH WORK.
7. SBC OF SOIL IS CONSIDERED AS 25T/SQM AT
A DEPTH OF 2.0M FROM NGL.

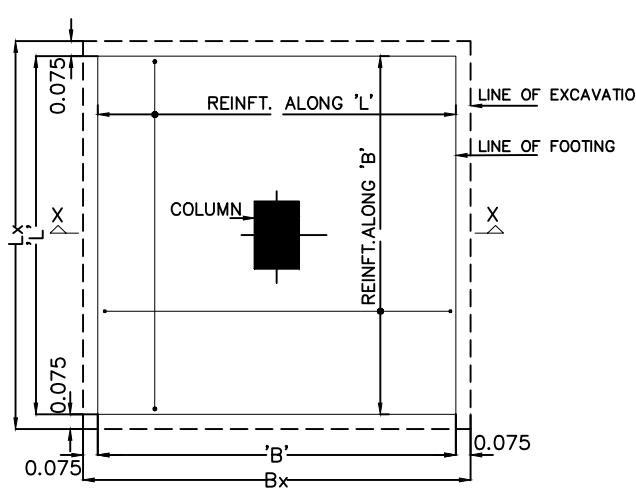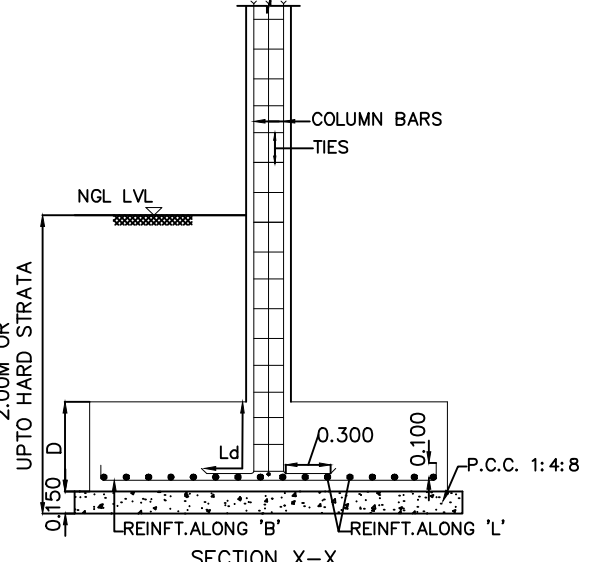8		7		6		5		4		3		2		1			
F	SCHEDULE OF FOOTING										SCHEDULE OF FOOTING REINFORCEMENT						
	FOOTING NAME	NO OF FOOTING	EXCAVATION SIZE		FOOTING SIZE		DEPTH	BOTTOM REINFORCEMENT									
			Bx'	Lx'	Bx	Lx		X-Direction		Y-Direction							
	F1	07	2.300	2.600	2.100	2.400	0.600	10ø@ 0.100m C/C		10ø@ 0.100m C/C							
	F2	06	2.500	2.800	2.300	2.600	0.650	12ø@ 0.125m C/C		12ø@ 0.125m C/C							
	F3	03	3.000	3.300	2.800	3.100	0.800	12ø@ 0.100m C/C		12ø@ 0.100m C/C							
	F4	04	2.700	3.000	2.500	2.800	0.725	12ø@ 0.100m C/C		12ø@ 0.100m C/C							
	F5	02	3.200	3.500	3.000	3.300	0.850	12ø@ 0.100m C/C		12ø@ 0.100m C/C							
	F6	02	1.700	1.700	1.500	1.500	0.450	10ø@ 0.150m C/C		10ø@ 0.150m C/C							
	F7	03	2.500	2.700	2.300	2.500	0.600	10ø@ 0.100m C/C		10ø@ 0.100m C/C							
D	CF1	02	3.300	4.800	3.100	4.600	REFER SEPARATE DETAILS										
	CF2	02	3.000	5.200	2.800	5.000											
	CF3	01	3.100	5.300	2.900	5.100											
C	SCHEDULE OF COLUMNS																
	COLUMN NAME		NO OF COLUMN	SIZE													
	C1,C2,C3,C4,C5,C6,C7,C8,C9,C10,C11,C12,C13,C14,C15,C16,C17,C18,C19,C20,C21,C22,C23,C24,C25,C26,C27,C28,C29,C30,C31,C32,C33,C34,		34	0.300X0.600													
B	C35,C36.		02	0.300X0.300													
	 PLAN-TYPICAL COLUMN FOOTING DETAILS  SECTION X-X																
A	ARCHITECT		TITLE		TENDER DRAWING					SCALE: N.T.S		DRAWN: GM		APPD:		NOTES:- 1. ALL DIMENSIONS ARE IN METERS. 2. FOLLOW FIGURED DIMENSION ONLY. 3. GRADE OF CONCRETE - M30. 4. GRADE OF STEEL-FE500. 5. CLEAR COVER TO MAIN REINF. FOR BEAM -30MM FOR SLAB -25MM, FOR COLUMNS -40MM. 6. ANY DISCREPANCY IN DRAWING SHALL BE BROUGHT TO THE NOTICE OF STRUCTURAL CONSULTANTS BEFORE PROCEEDING WITH WORK.	
	KULKARNI ASSOCIATES		FOOTING DETAILS (BNPM-MENS BARRACK)							PLOT SIZE: A3		DESIGNED:SSN		SHEET NO.: 01 OF 01			
	Surya Prema Building,next to Adiga's Restaurant,Kanakapura Road No-203,2nd floor,Above Canara bank Raghuvahalli Branch Raghuvahalli Village,Uttarahalli hobli Bangalore-560062 Email Id : kulkarni.associates@yahoo.com									DATE:30.10.2025		CHECKED: DG		REV. NO.: R0			
	PROJECT									STATUS ☐ APPROVAL ☐ PERUSAL ☒ FOR QUANTITY PURPOSE ☐ GOOD FOR CONSTRUCTION		JOB NO. ECPL-D/10-2025/131		DRAWING No. ECPL/KA/BNPM-MENS BARRACK/ST-03			
	PROVIDING COMPREHENSIVE PROJECT MANAGEMENT CONSULTANCY SERVICES FOR PROPOSED CONSTRUCTION OF CISF INFRASTRUCTURE BUILDINGS AT NOTE MUDRAN NAGAR MYSORE																
8		7		6		5		4		3		2		1			

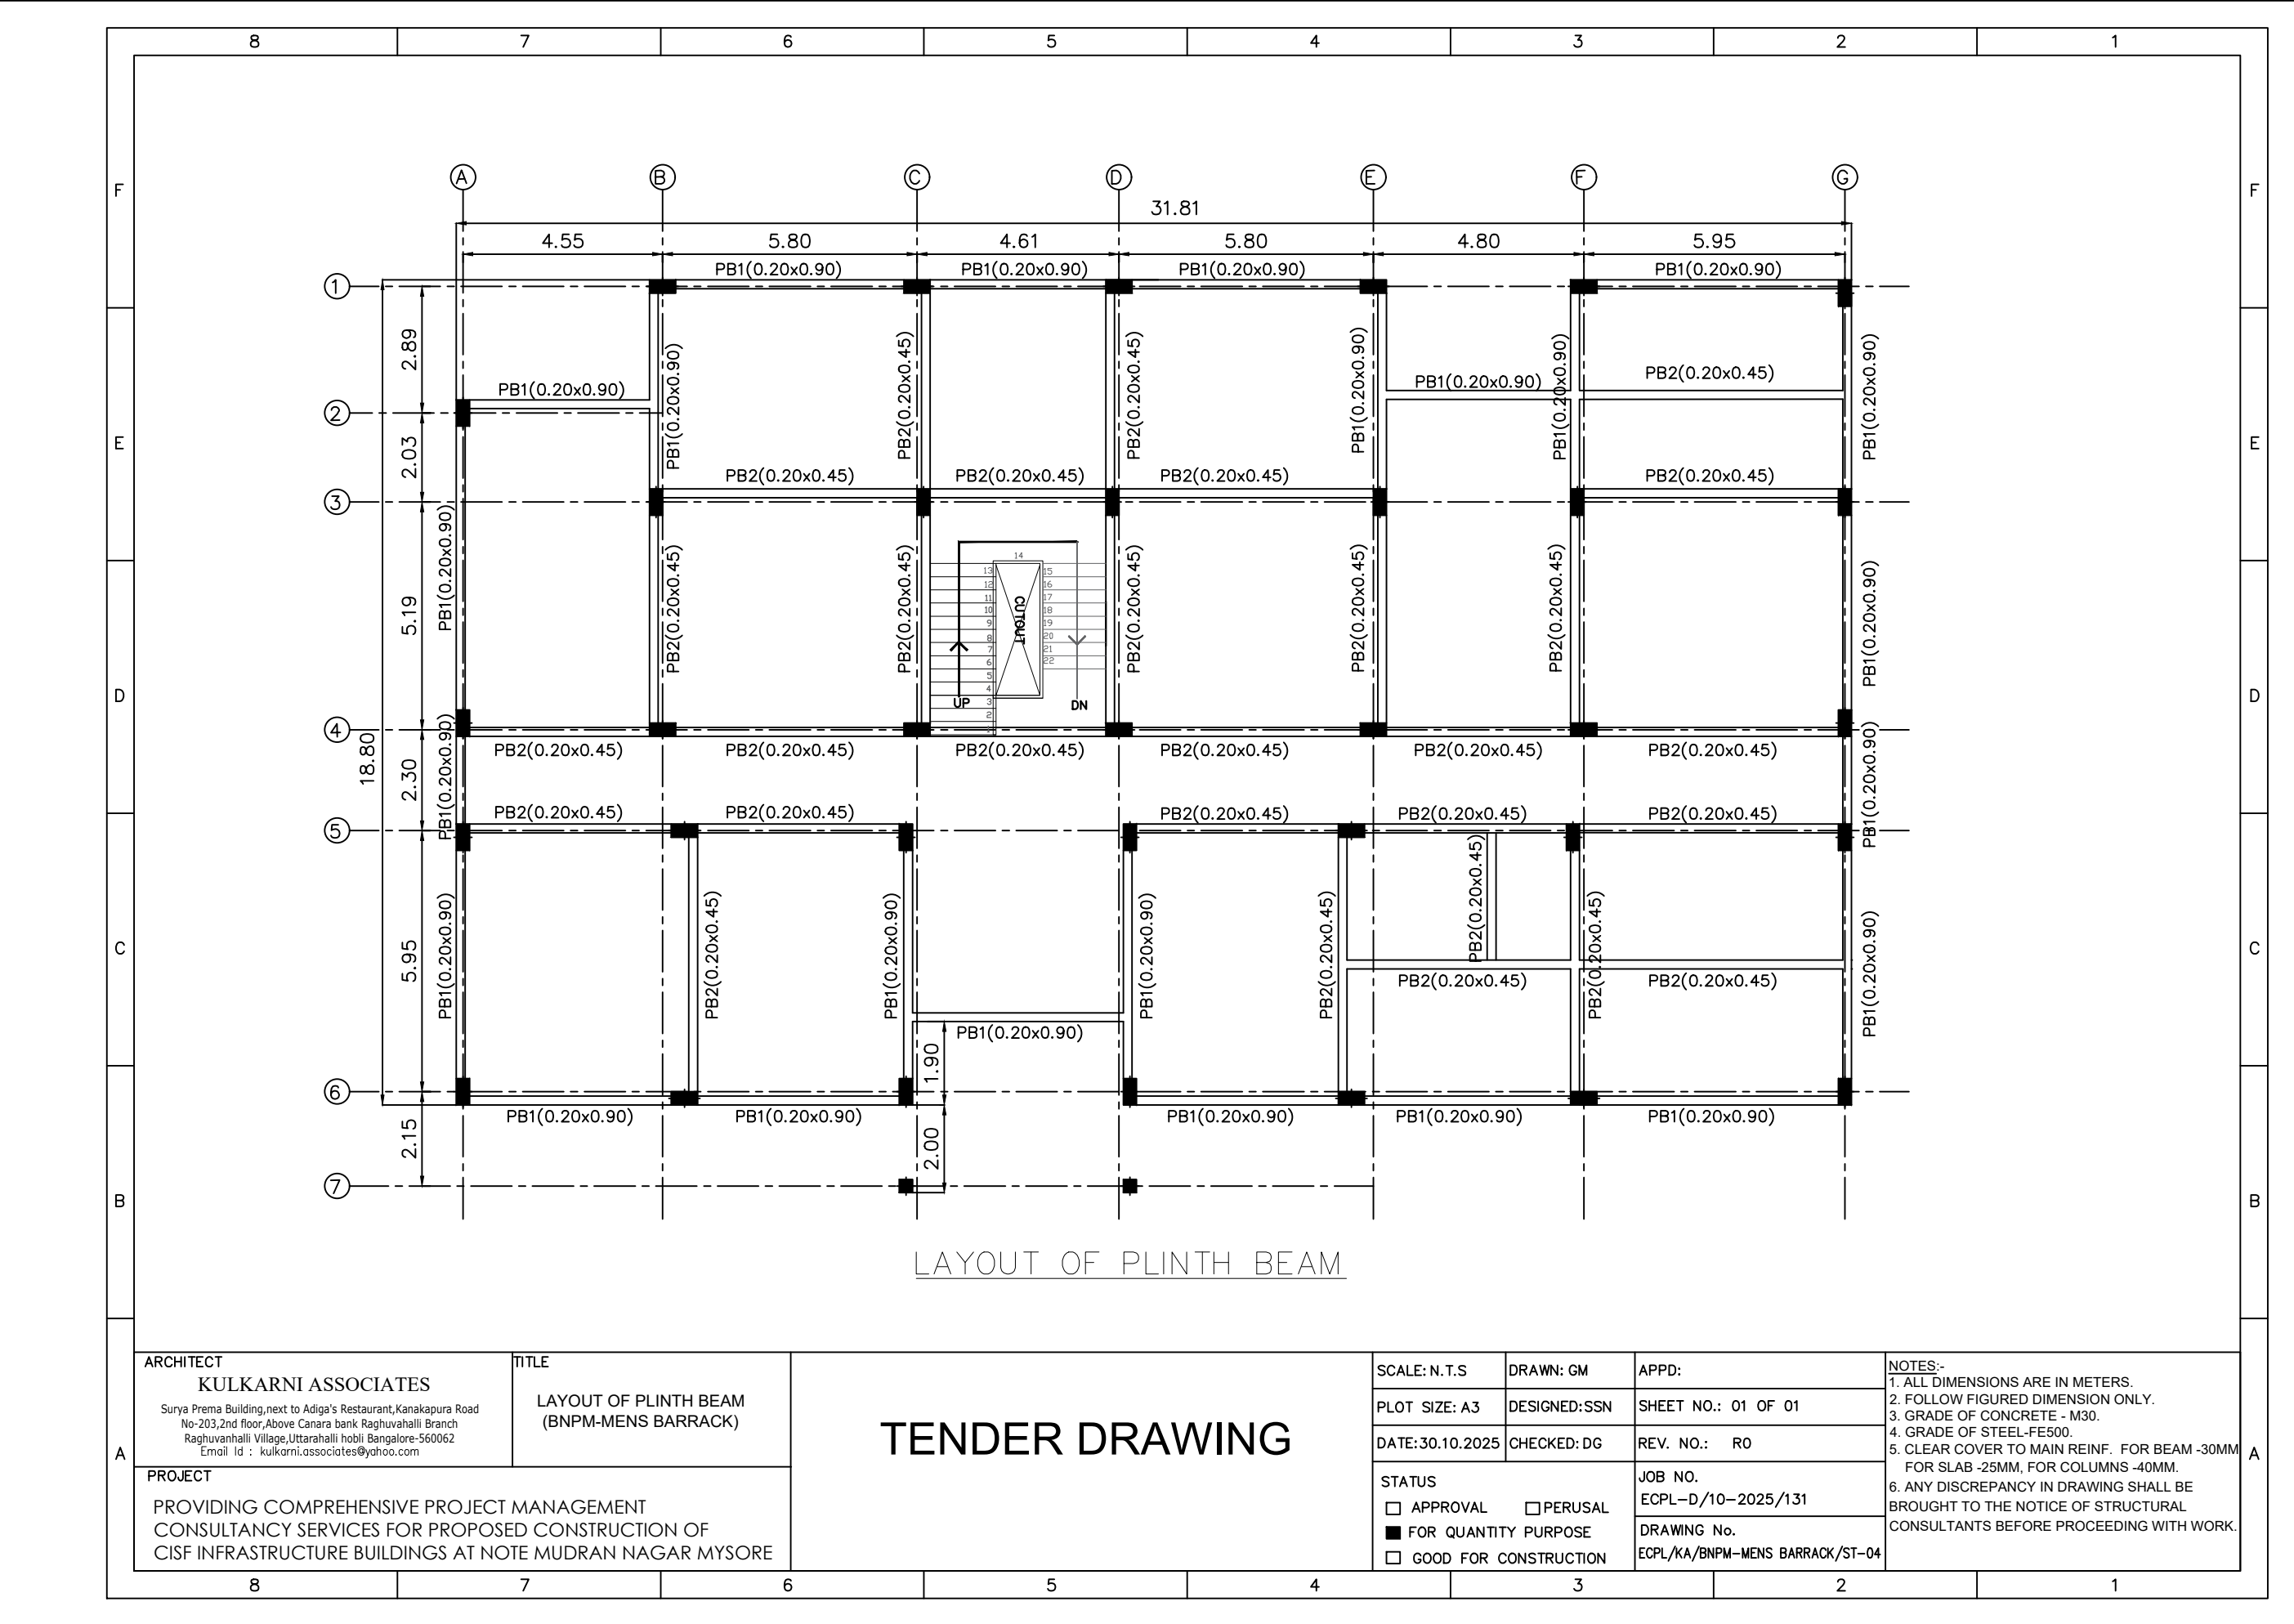


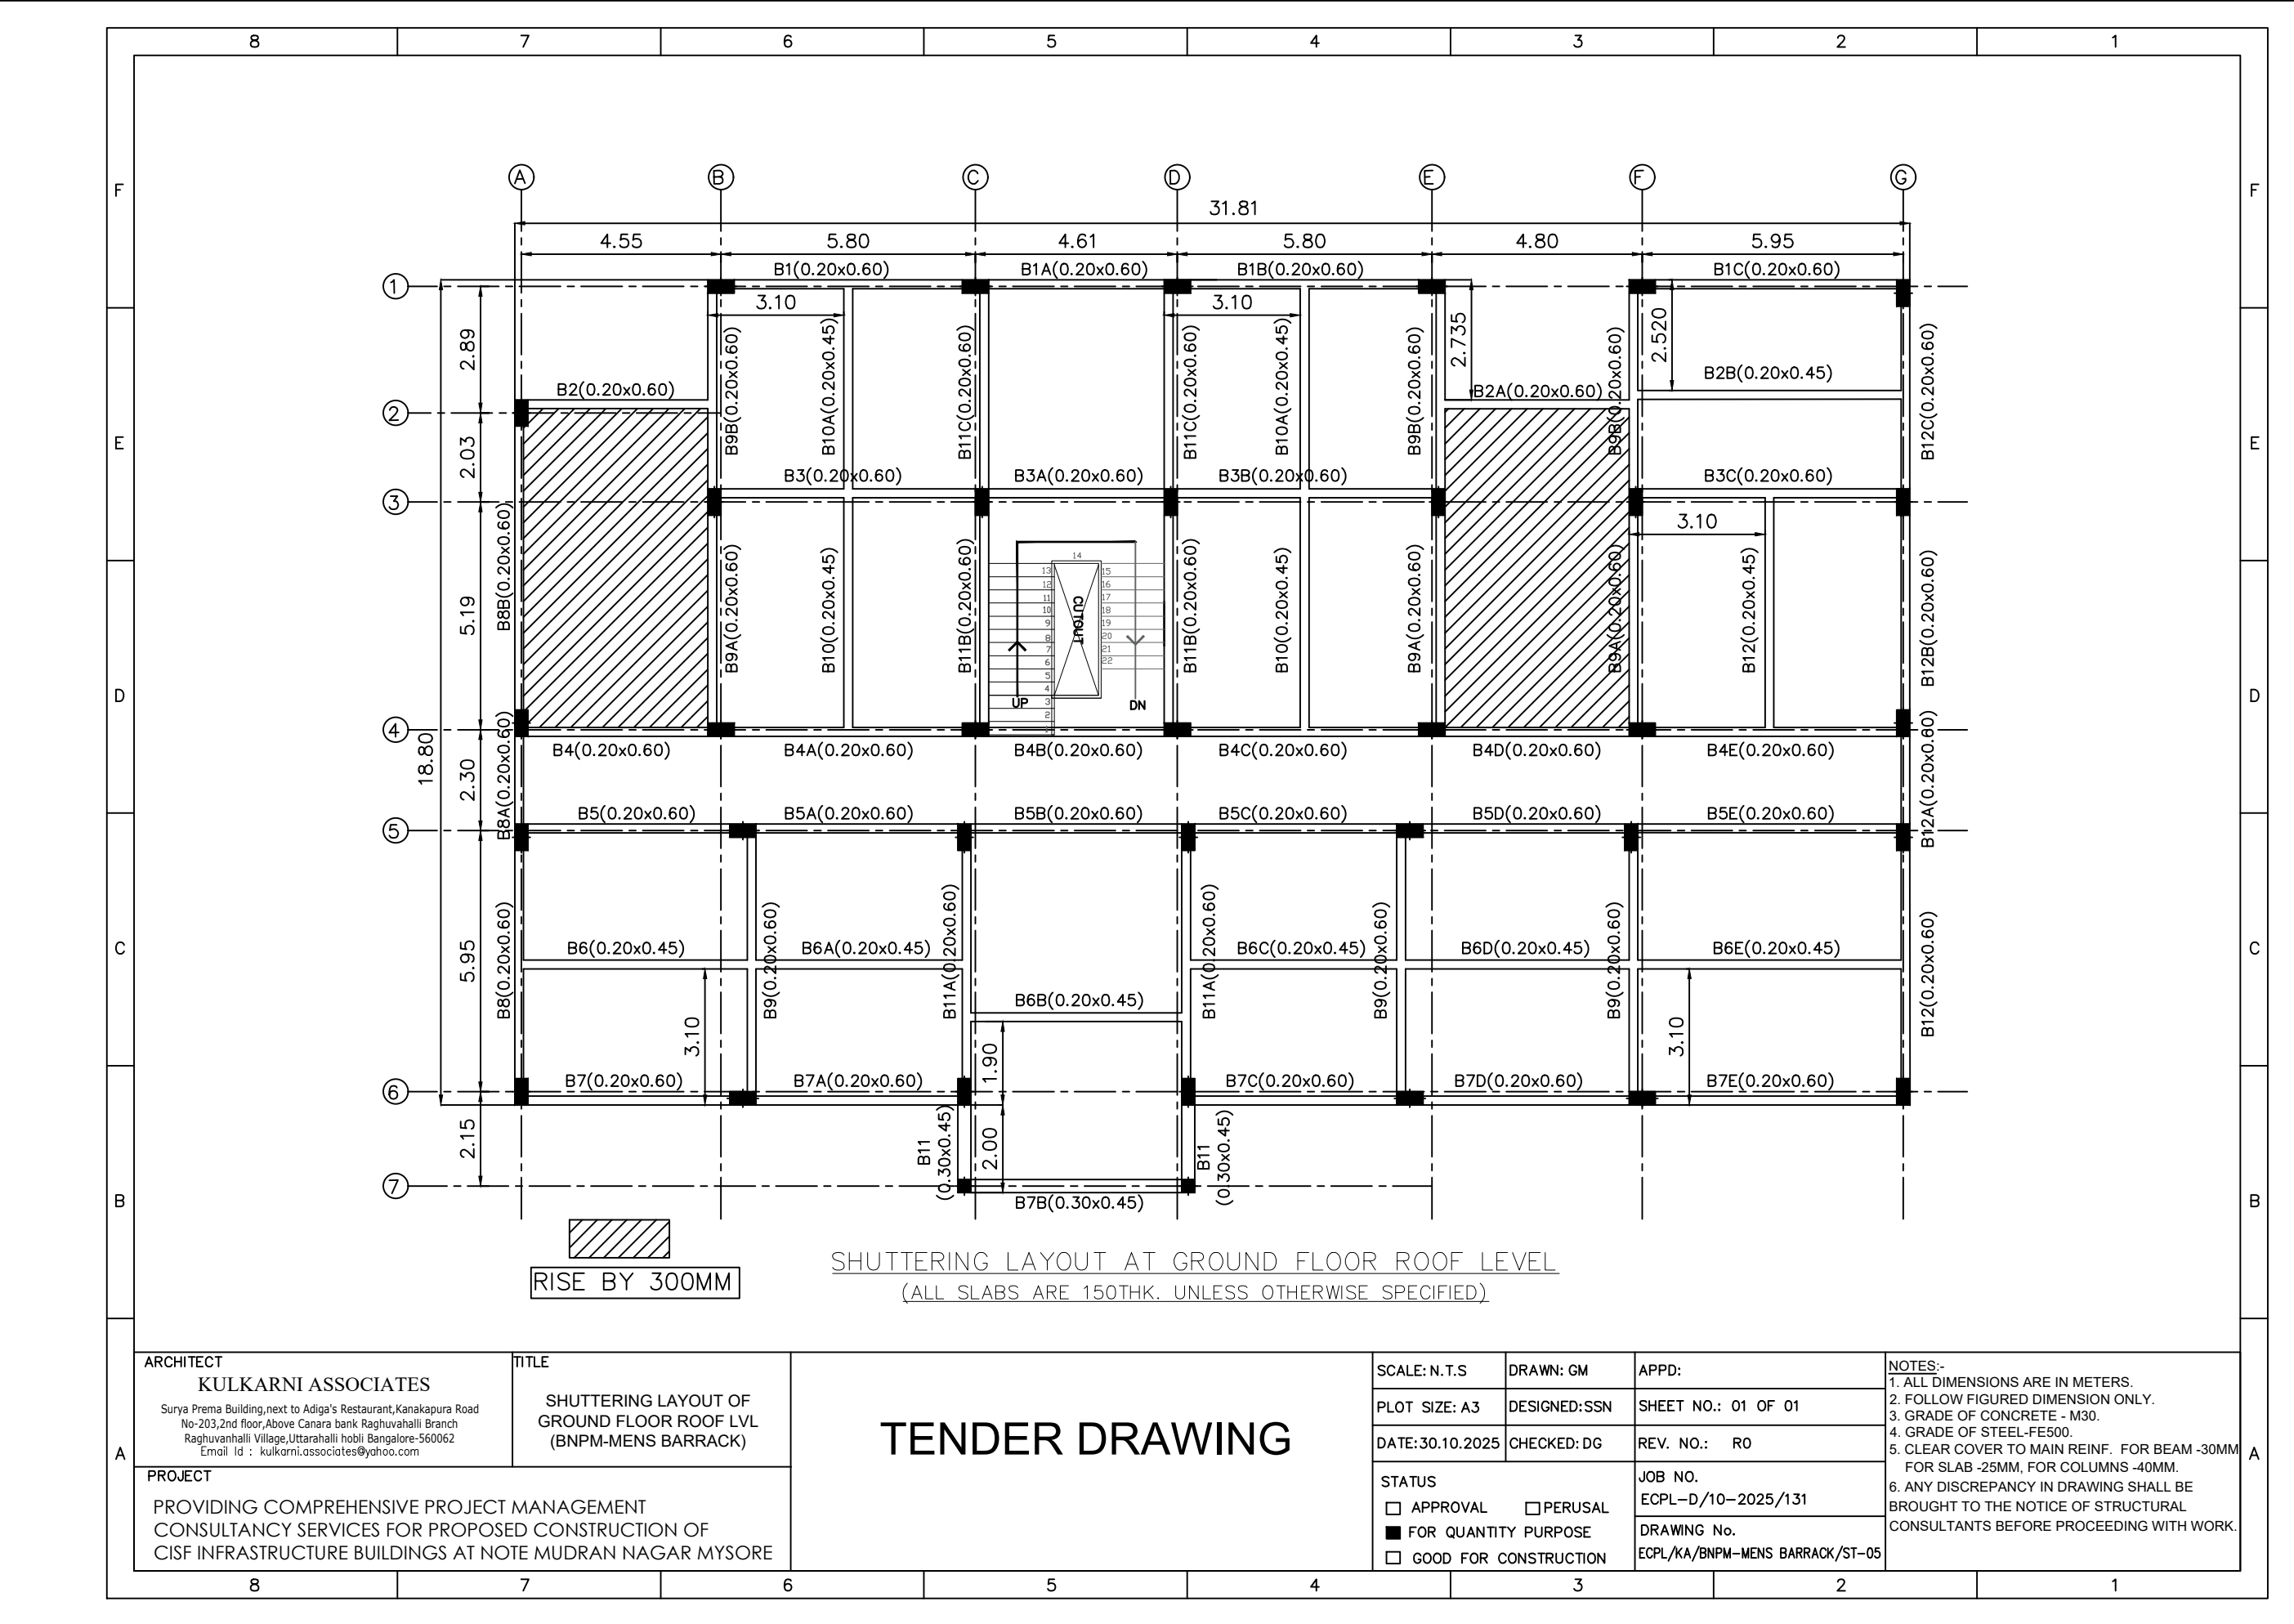


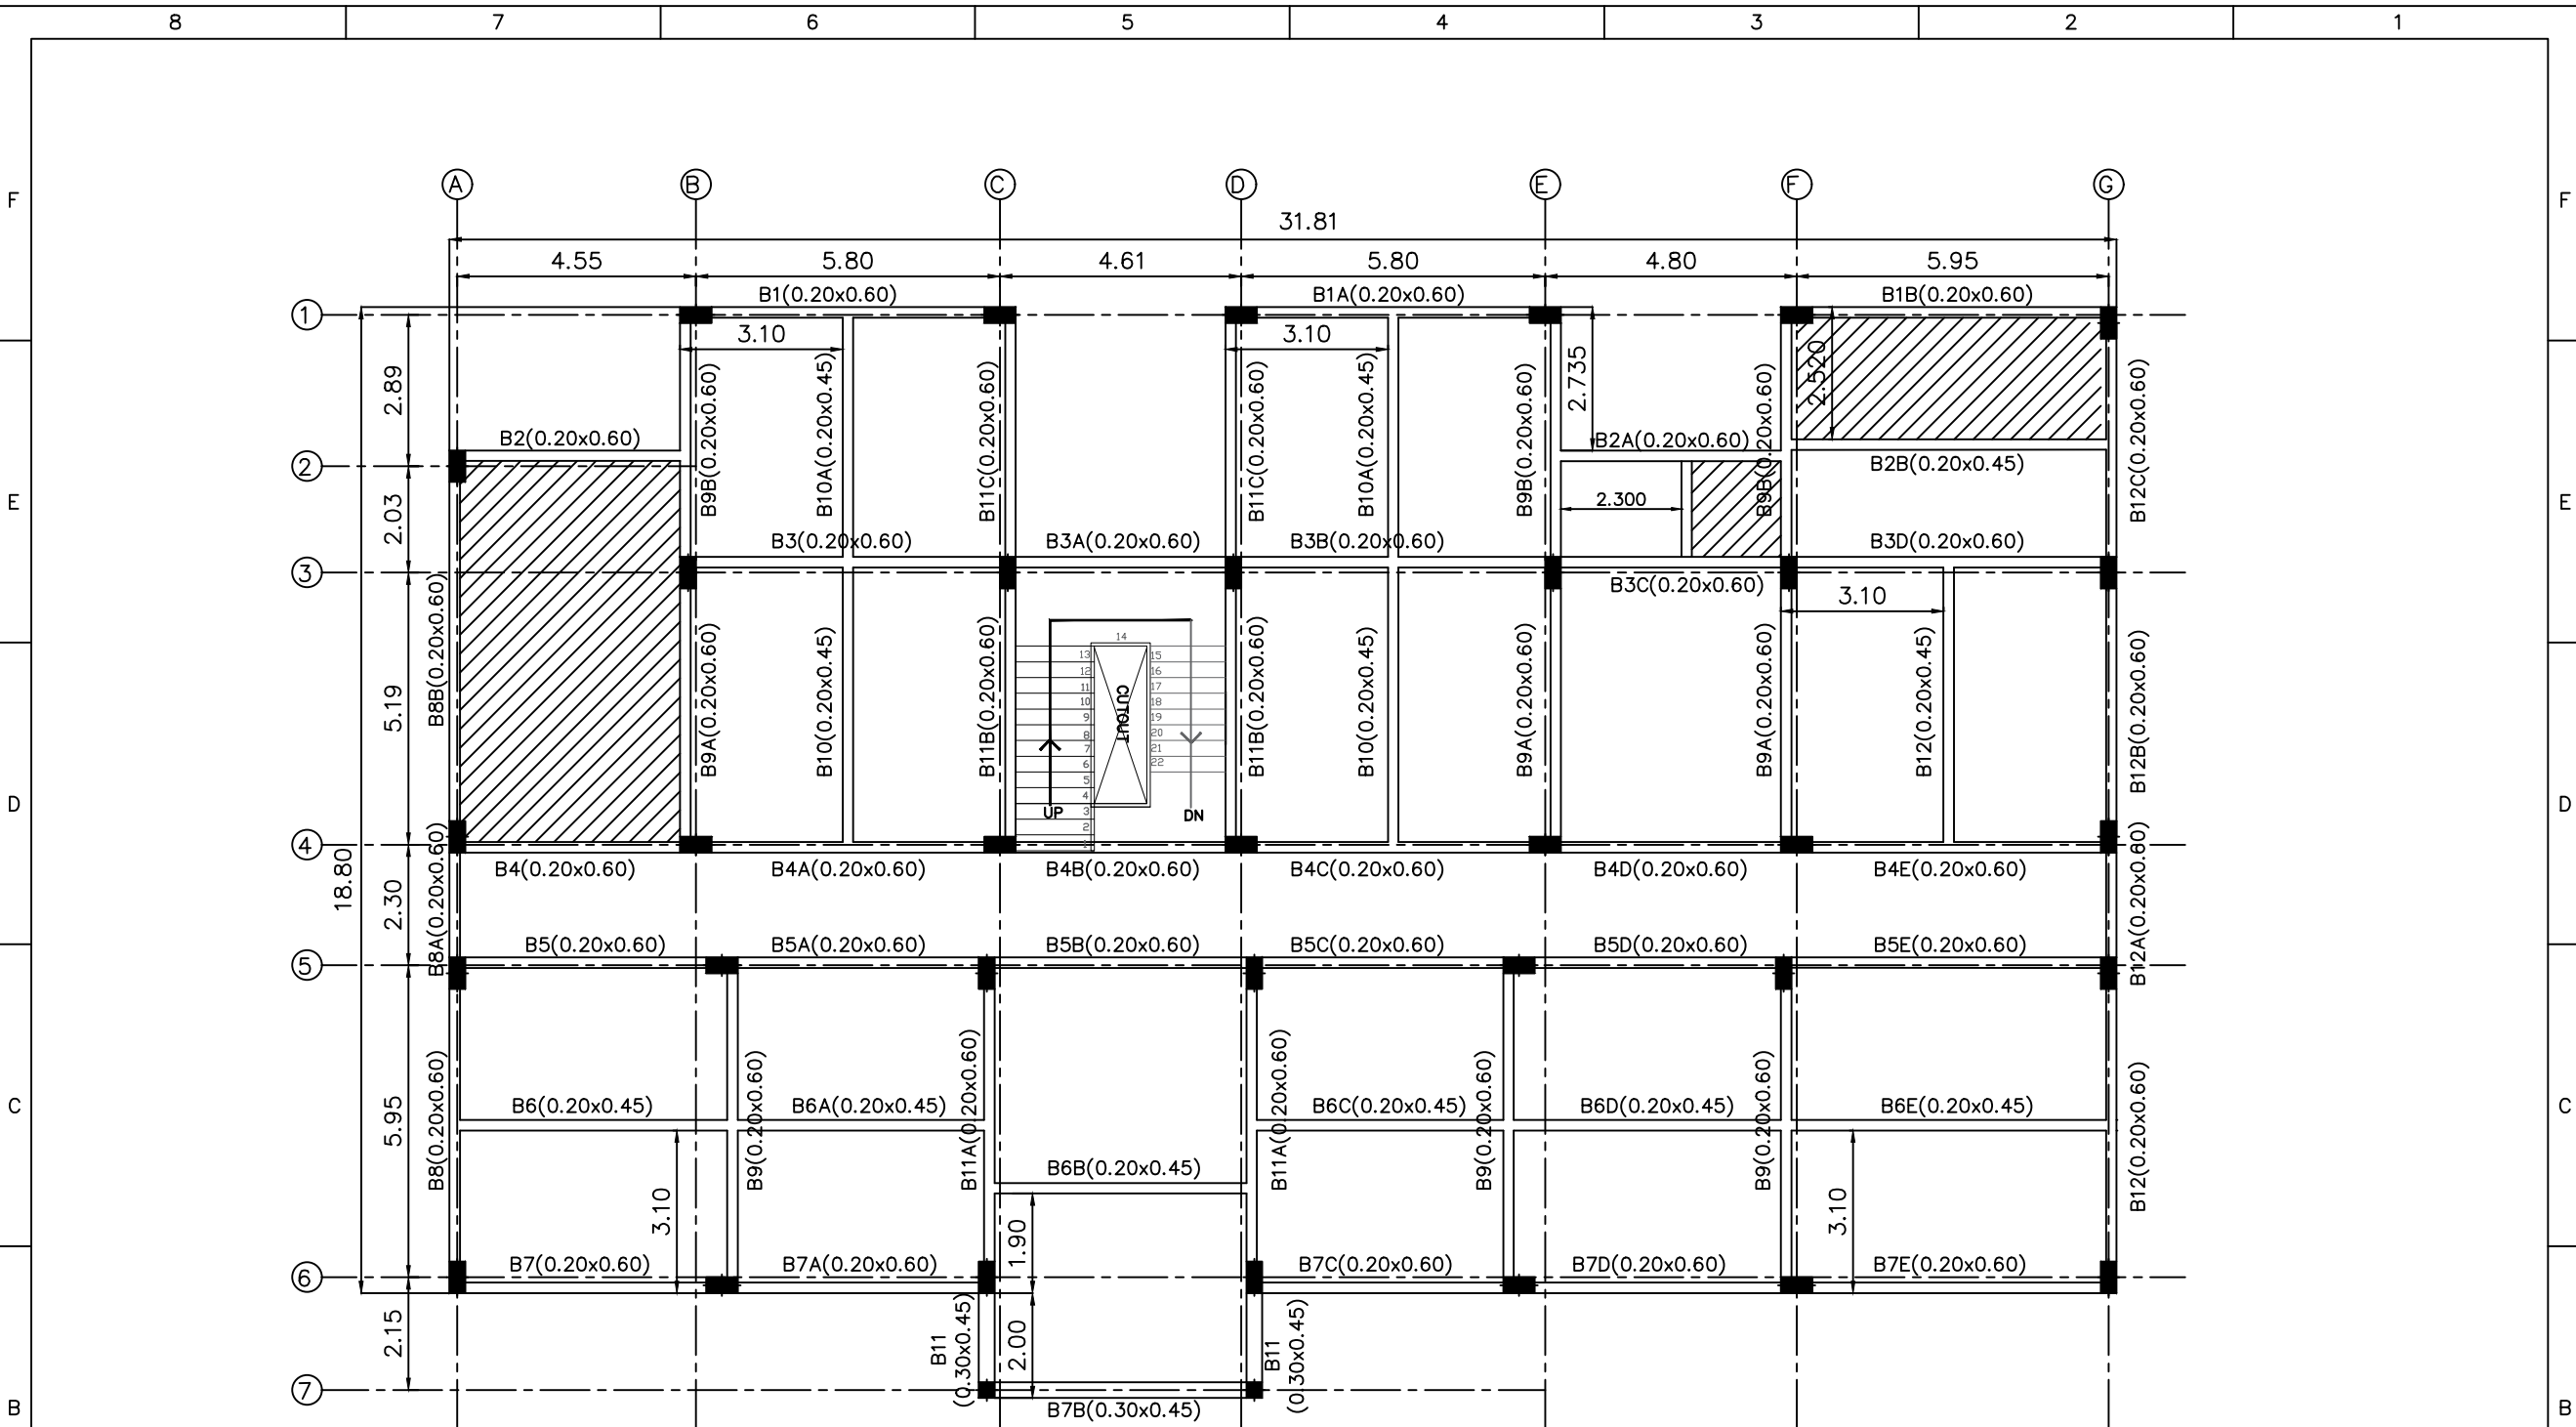

SHUTTERING LAYOUT AT FIRST FLOOR ROOF LEVEL
(ALL SLABS ARE 150THK. UNLESS OTHERWISE SPECIFIED)

ARCHITECT KULKARNI ASSOCIATES Surya Prema Building, next to Adiga's Restaurant, Kanakapura Road No-203, 2nd floor, Above Canara bank Raghuvahalli Branch Raghuvahalli Village, Uttarahalli hobli Bangalore-560062 Email Id : kulkarni.associates@yahoo.com PROJECT PROVIDING COMPREHENSIVE PROJECT MANAGEMENT CONSULTANCY SERVICES FOR PROPOSED CONSTRUCTION OF CISF INFRASTRUCTURE BUILDINGS AT NOTE MUDRAN NAGAR MYSORE	TITLE SHUTTERING LAYOUT OF FIRST FLOOR ROOF LVL (BNPM-MENS BARRACK)	TENDER DRAWING	SCALE: N.T.S	DRAWN: GM	APPD:	NOTES:- 1. ALL DIMENSIONS ARE IN METERS. 2. FOLLOW FIGURED DIMENSION ONLY. 3. GRADE OF CONCRETE - M30. 4. GRADE OF STEEL-FE500. 5. CLEAR COVER TO MAIN REINF. FOR BEAM -30MM FOR SLAB -25MM, FOR COLUMNS -40MM. 6. ANY DISCREPANCY IN DRAWING SHALL BE BROUGHT TO THE NOTICE OF STRUCTURAL CONSULTANTS BEFORE PROCEEDING WITH WORK.
			PLOT SIZE: A3	DESIGNED:SSN	SHEET NO.: 01 OF 01	
			DATE:30.10.2025	CHECKED: DG	REV. NO.: R0	
			STATUS ☐ APPROVAL ☐ PERUSAL ☒ FOR QUANTITY PURPOSE ☐ GOOD FOR CONSTRUCTION		JOB NO. ECPL-D/10-2025/131 DRAWING No. ECPL/KA/BNPM-MENS BARRACK/ST-06	

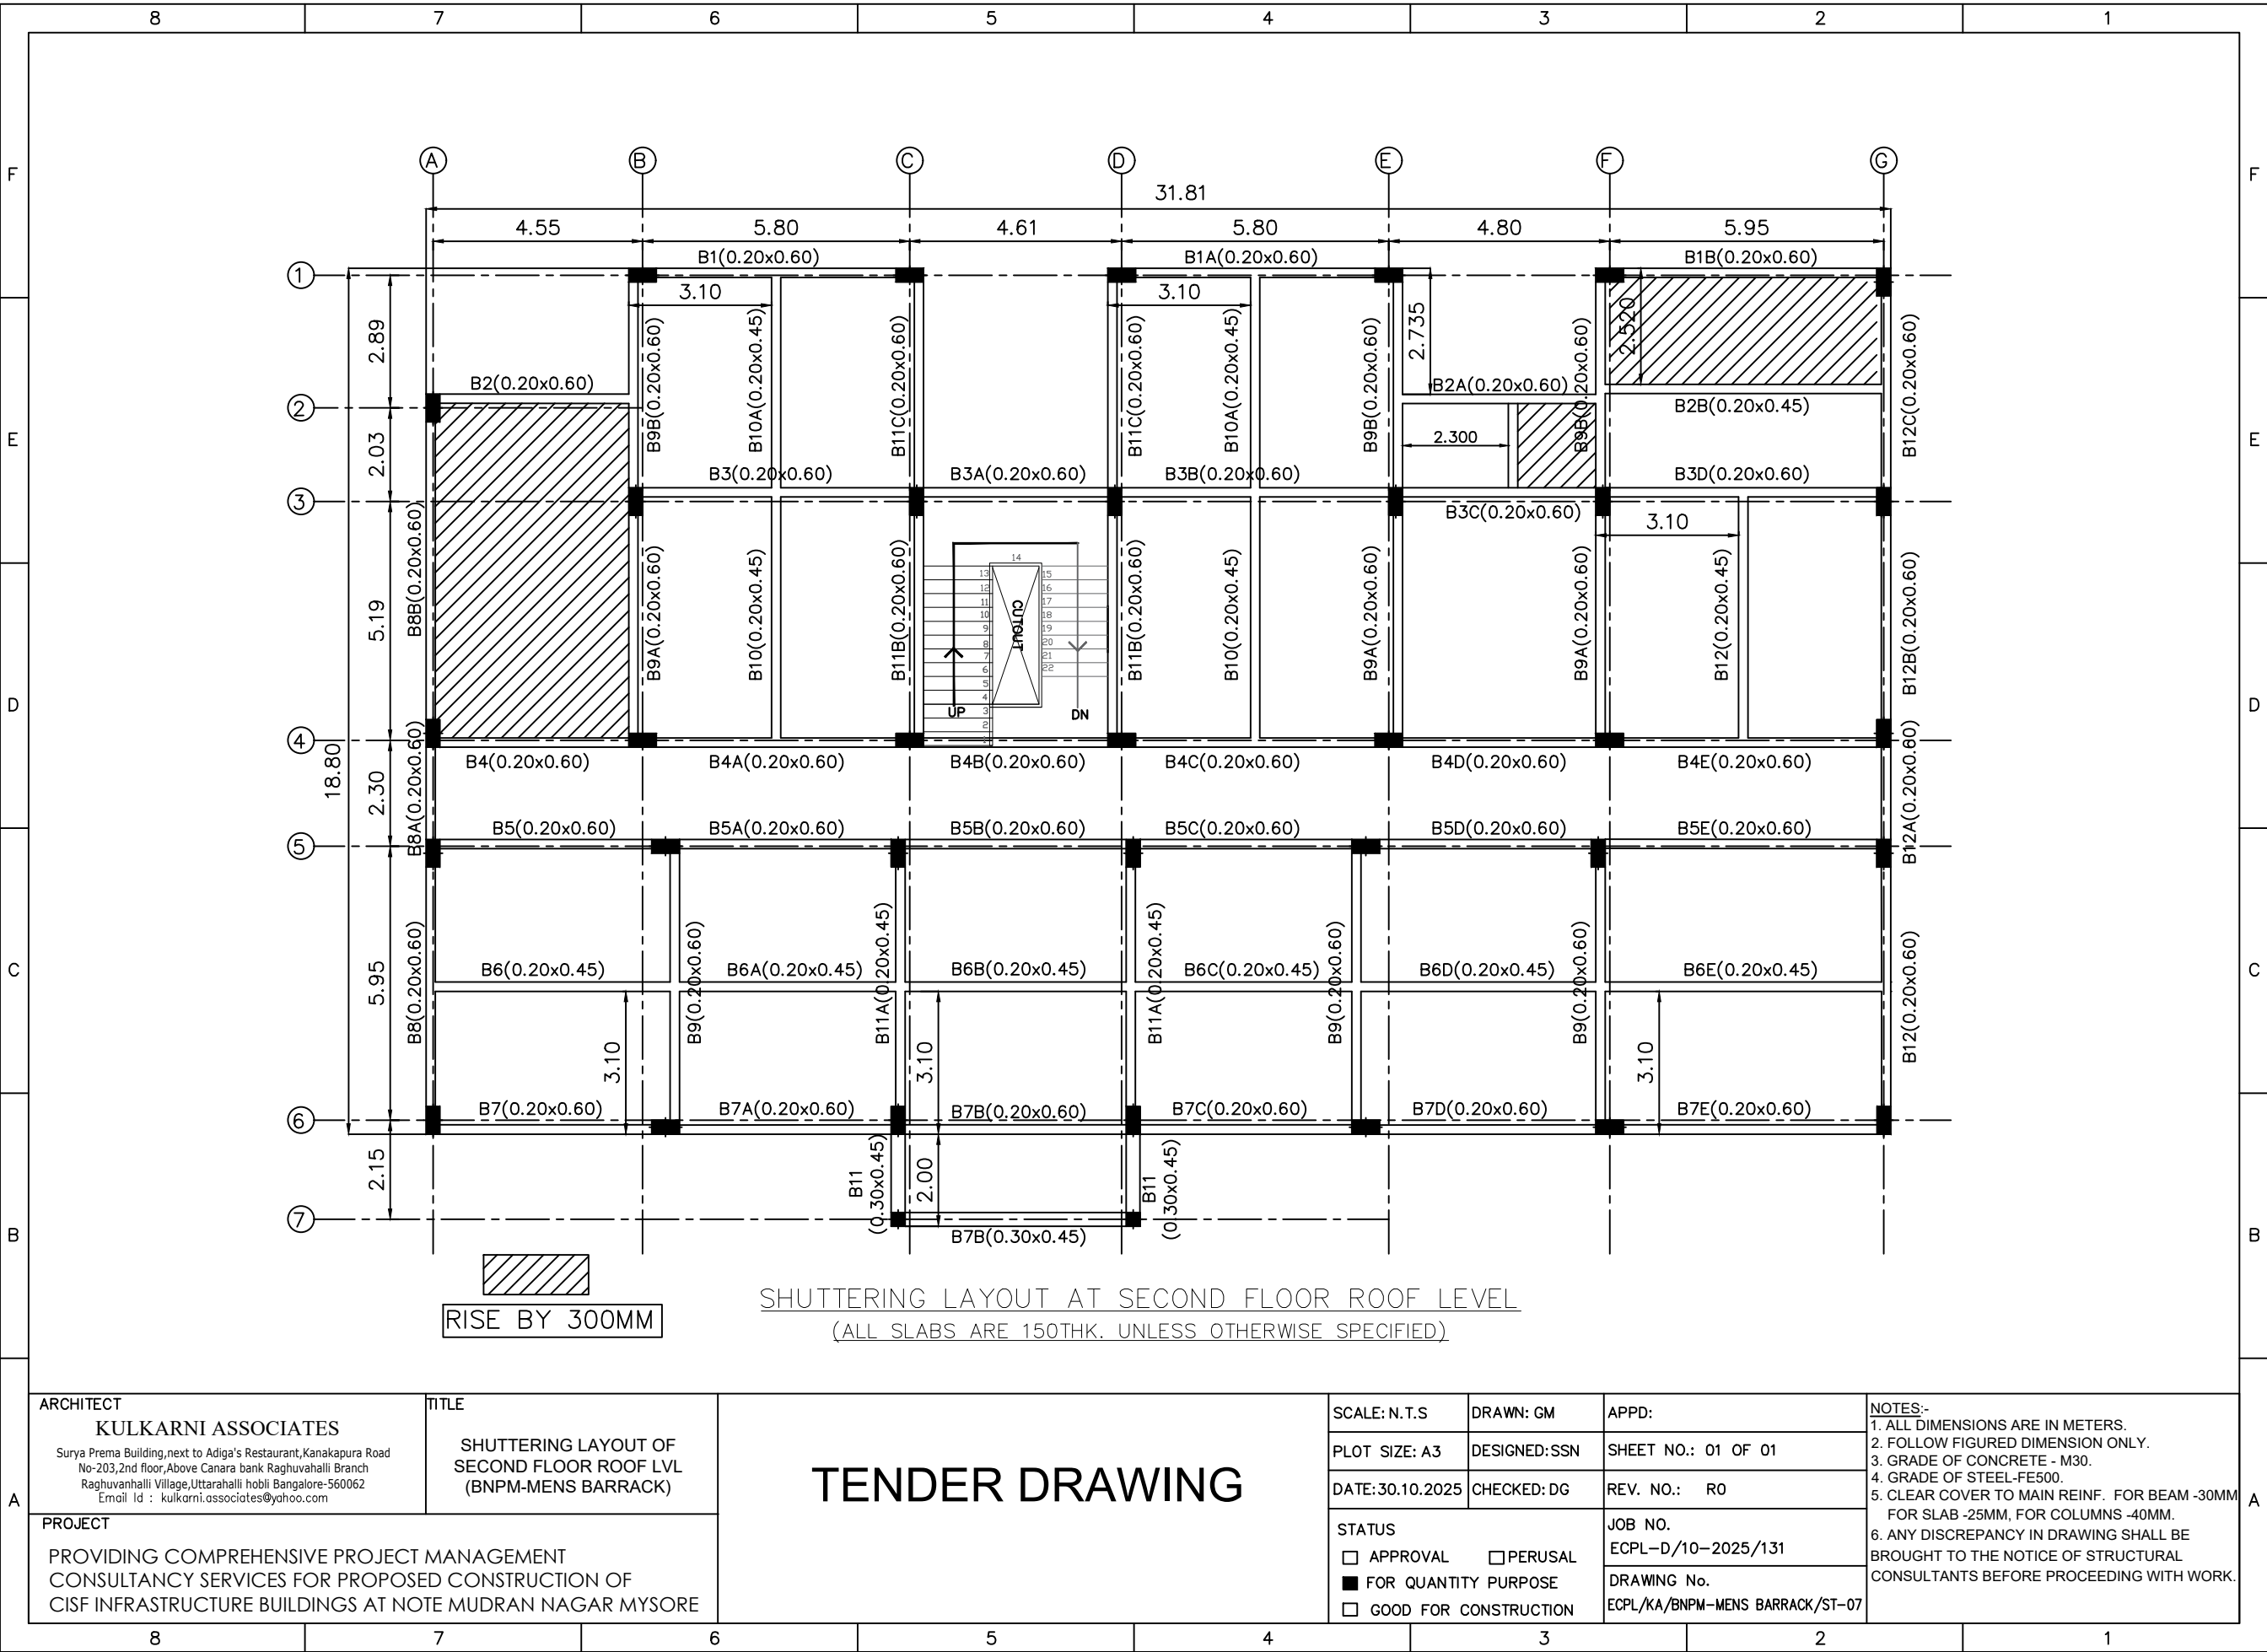

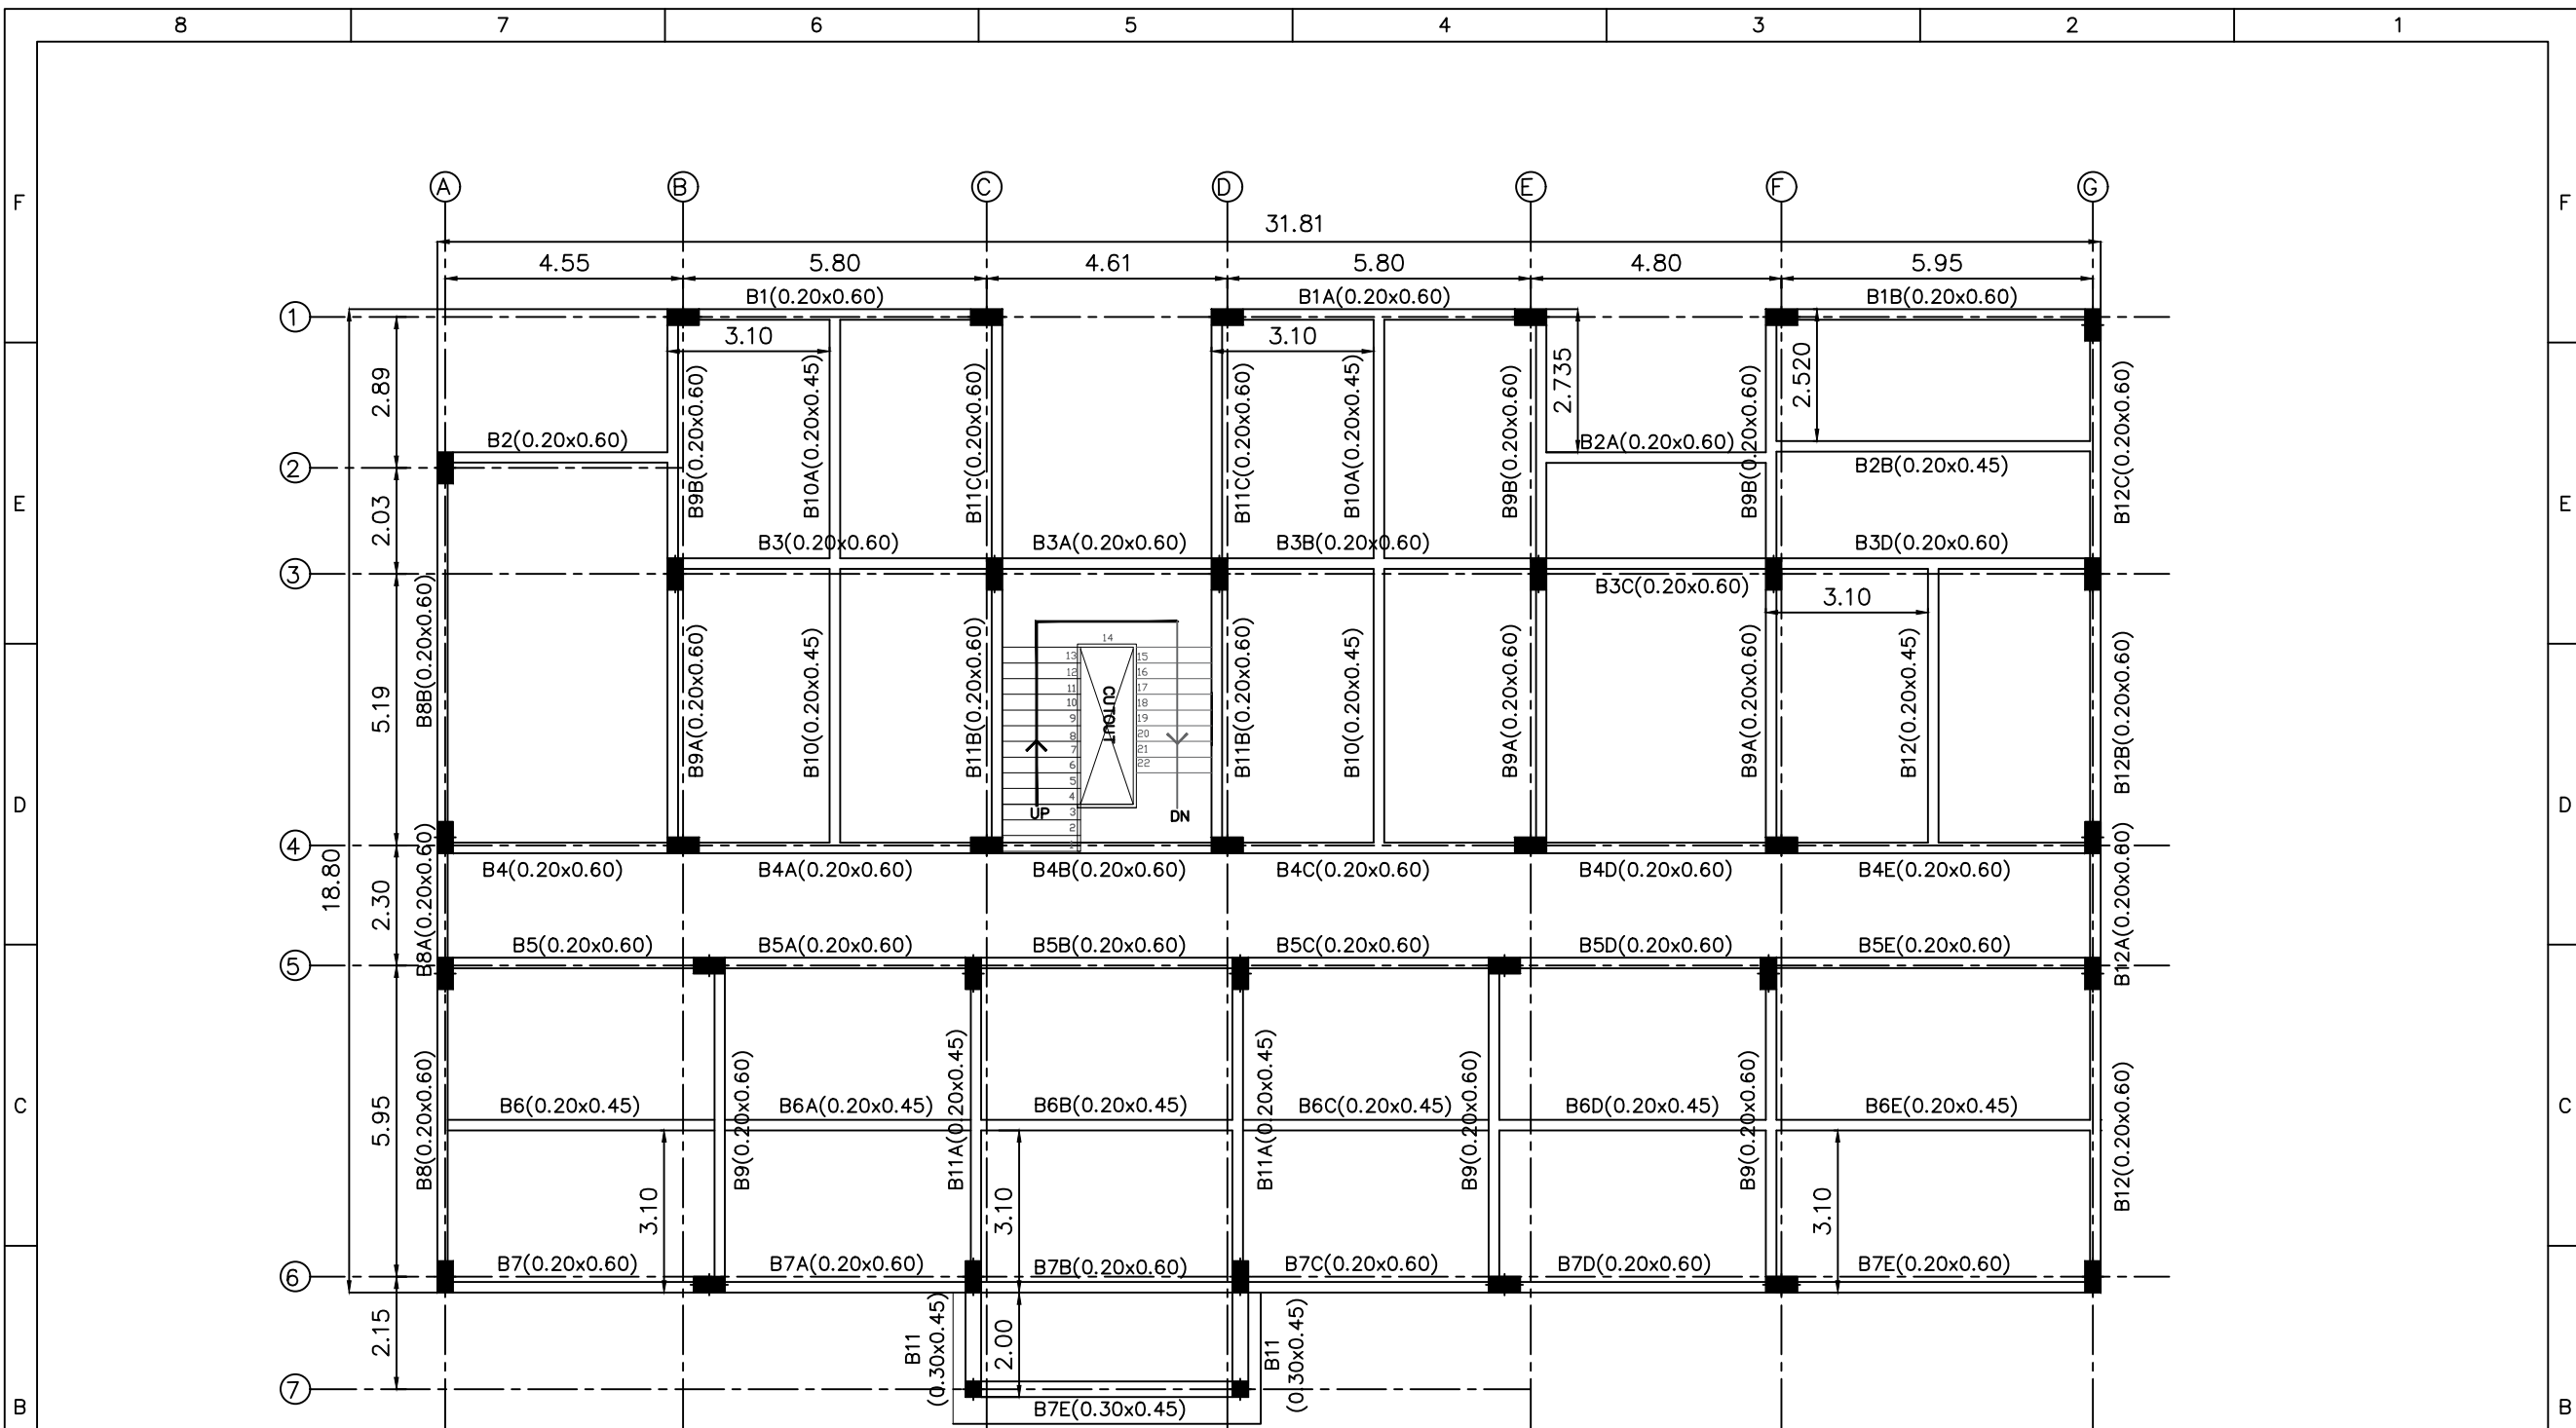

SHUTTERING LAYOUT AT TERRACE FLOOR LEVEL
(ALL SLABS ARE 150THK. UNLESS OTHERWISE SPECIFIED)

ARCHITECT

KULKARNI ASSOCIATES

Surya Prema Building,next to Adiga's Restaurant,Kanakapura Road
No-203,2nd floor,Above Canara bank Raghuvahalli Branch
Raghuvahalli Village,Uttarahalli hobli Bangalore-560062
Email Id : kulkarni.associates@yahoo.com

PROJECT

PROVIDING COMPREHENSIVE PROJECT MANAGEMENT
CONSULTANCY SERVICES FOR PROPOSED CONSTRUCTION OF
CISF INFRASTRUCTURE BUILDINGS AT NOTE MUDRAN NAGAR MYSORE

TITLE

SHUTTERING LAYOUT OF
TERRACE FLOOR LVL
(BNPM-MENS BARRACK)

TENDER DRAWING

SCALE: N.T.S

PLOT SIZE: A3

DATE:30.10.2025

DRAWN: GM

DESIGNED:SSN

CHECKED: DG

APPD:

SHEET NO.: 01 OF 01

REV. NO.: R0

STATUS

☐ APPROVAL

☐ PERUSAL

☒ FOR QUANTITY PURPOSE

☐ GOOD FOR CONSTRUCTION

JOB NO.


ECPL-D/10-2025/131

DRAWING No.

ECPL/KA/BNPM-MENS BARRACK/ST-08

NOTES:-

1. ALL DIMENSIONS ARE IN METERS.
2. FOLLOW FIGURED DIMENSION ONLY.
3. GRADE OF CONCRETE - M30.
4. GRADE OF STEEL-FE500.
5. CLEAR COVER TO MAIN REINF. FOR BEAM -30MM
FOR SLAB -25MM, FOR COLUMNS -40MM.
6. ANY DISCREPANCY IN DRAWING SHALL BE
BROUGHT TO THE NOTICE OF STRUCTURAL
CONSULTANTS BEFORE PROCEEDING WITH WORK.

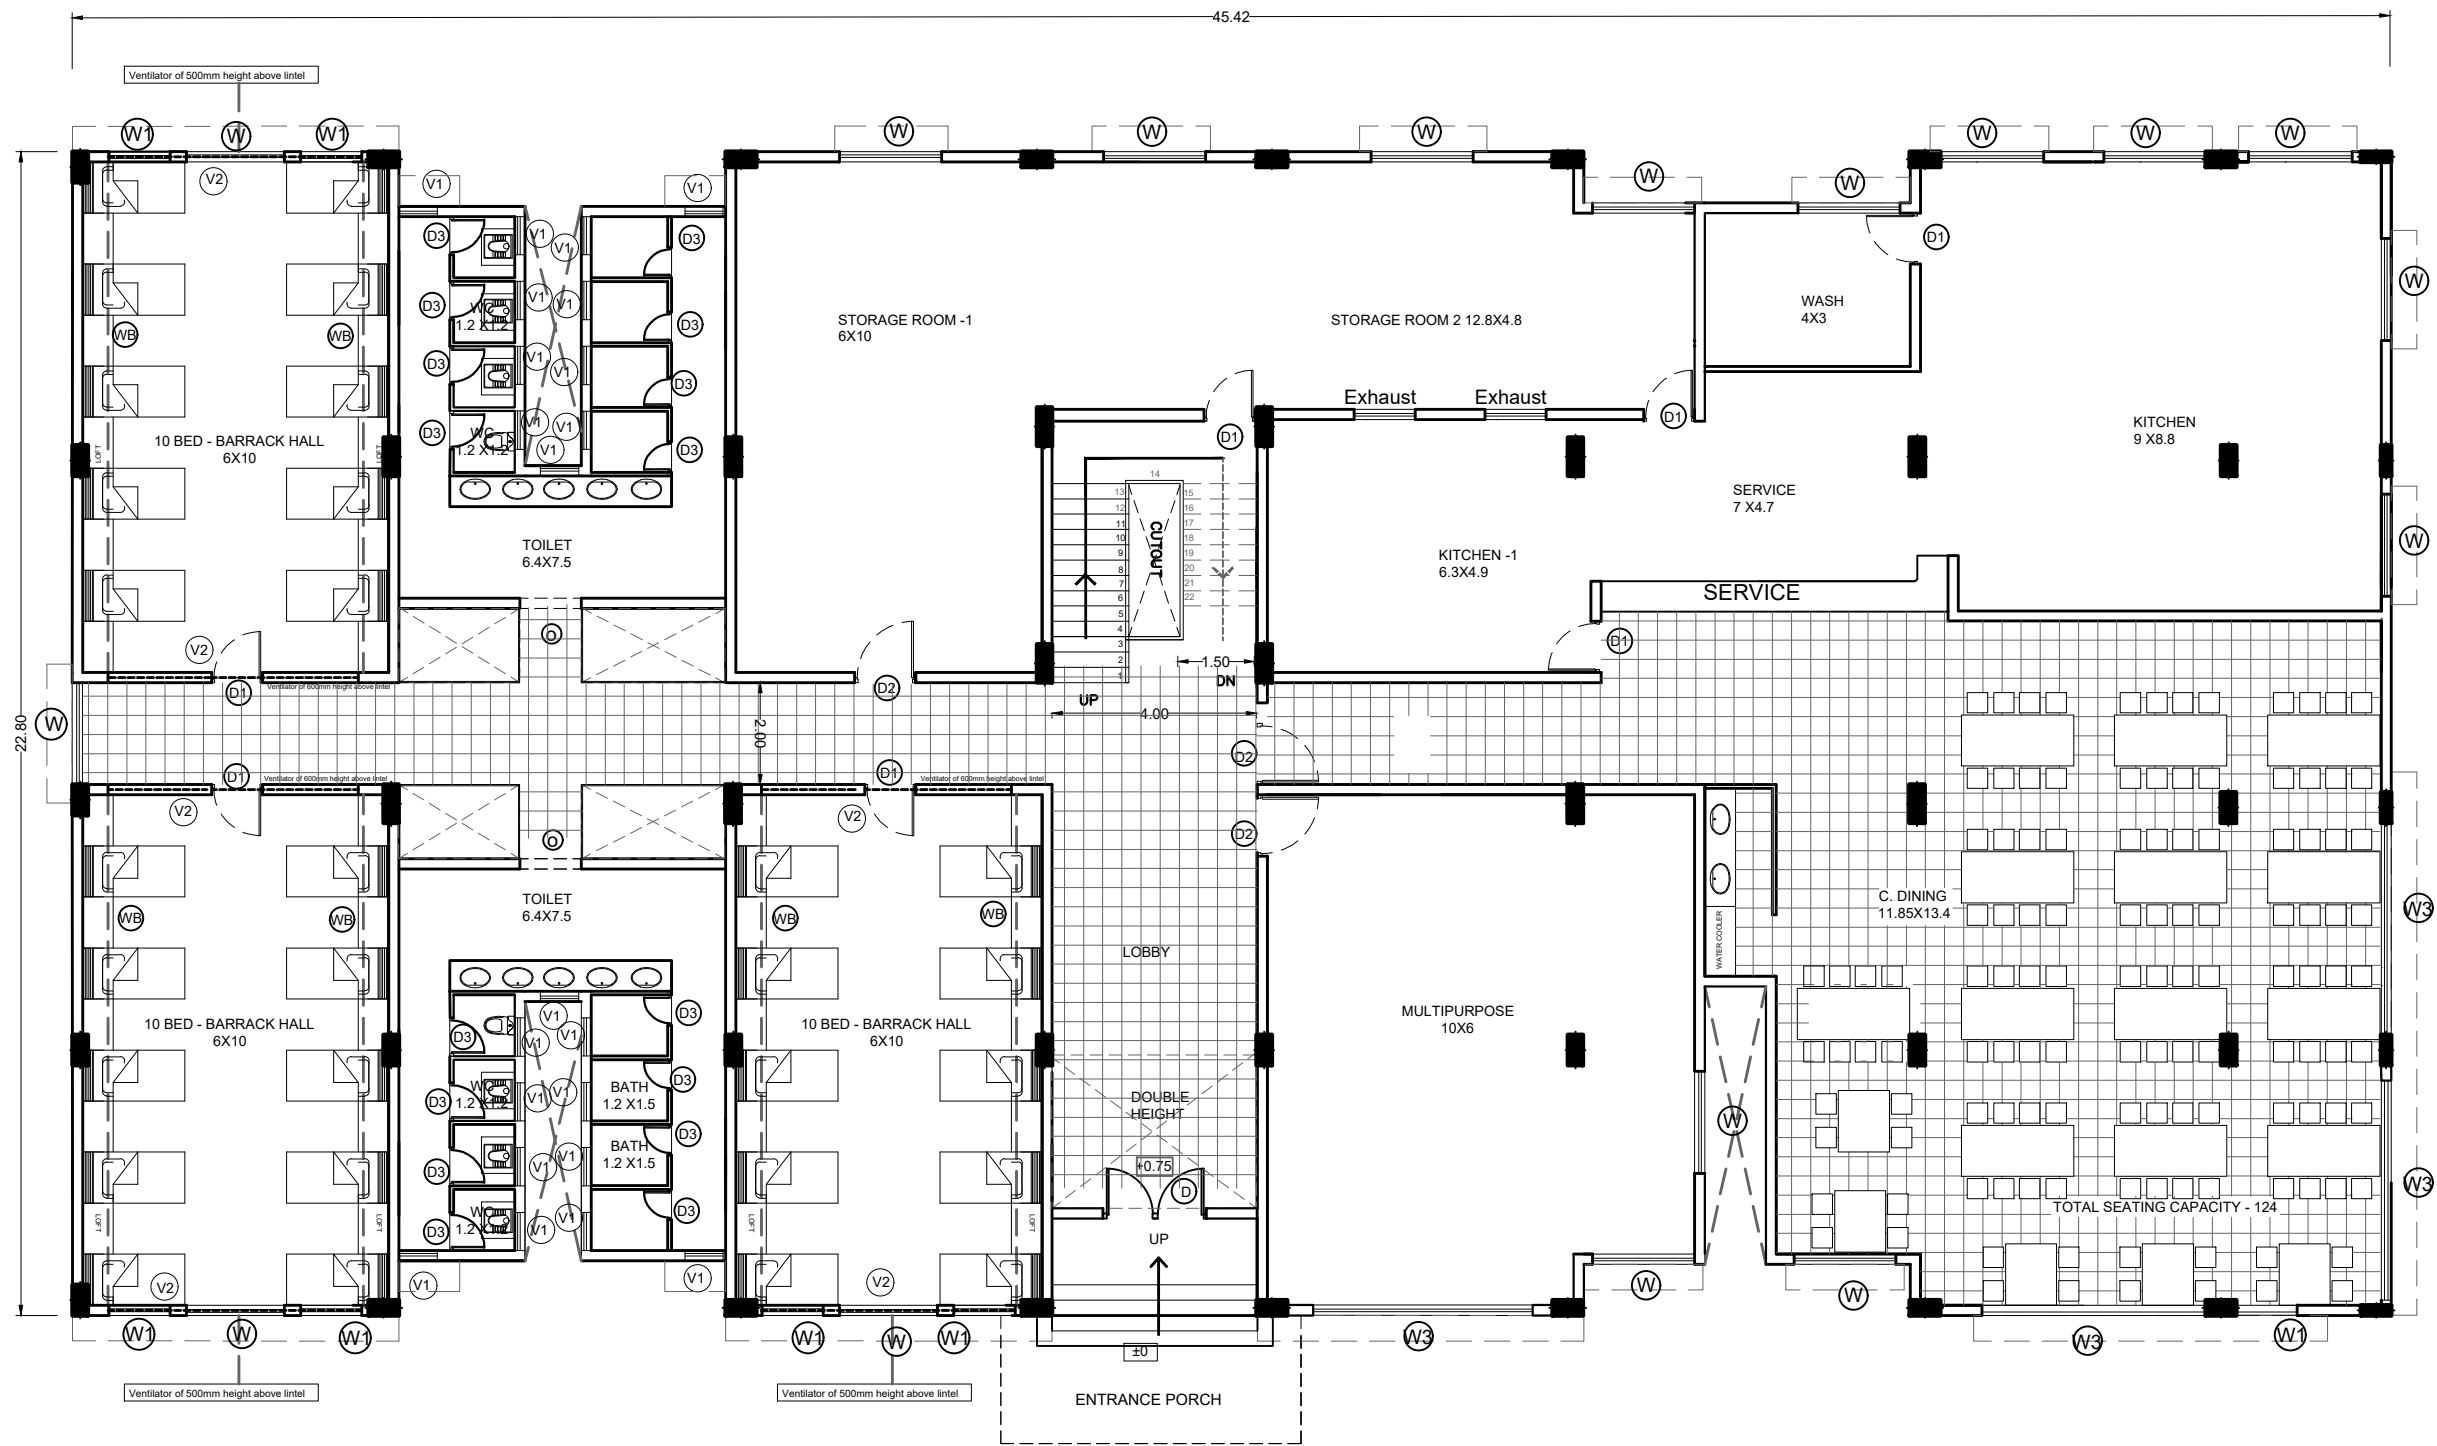

GROUND FLOOR PLAN

TOILET PROPORTION 1:4

LEGEND:

GROUND FLOOR BUILT UP - 977 SQM

LIST OF FACILITIES

1. ENTRANCE LOBBY
2. MULTIPURPOSE HALL - 50 SEATING
3. STORAGE ROOM
4. KITCHEN
5. WASH AREA
6. DINING AREA - 124 SEATING
7. BARRACK HALL - 3X10=30 BEDS
8. WASHROOM - 2X4 TOILET + 2X4 BATH
9. STAIRCASE

NOTE : ALL DIMENSION IN METERS

PROJECT :
PROVIDING COMPREHENSIVE PROJECT
MANAGEMENT CONSULTANCY SERVICES FOR
PROPOSED CONSTRUCTION OF CISF
INFRASTRUCTURE BUILDINGS
AT NOTE MUDRAN NAGAR MYSORE

TENDER DRAWING

Page 31 of 129

BRBNMPL - BARRACK FLOOR PLAN

Date :10-10-2025

Drawn by: AMRUTHA

Scale: 1:100

Checked by: Ar. Kavitha


Rev Date: -----



ARCHITECTS :
KULKARNI ASSOCIATES

Surya Prema Building, next to Adiga's Restaurant, Kanakapura Road
No-203, 2nd floor, Above Canara bank Raghuvahalli Branch
Raghuvahalli Village, Uttarahalli hobli Bangalore-560062

Email Id : kulkarni.associates@yahoo.com

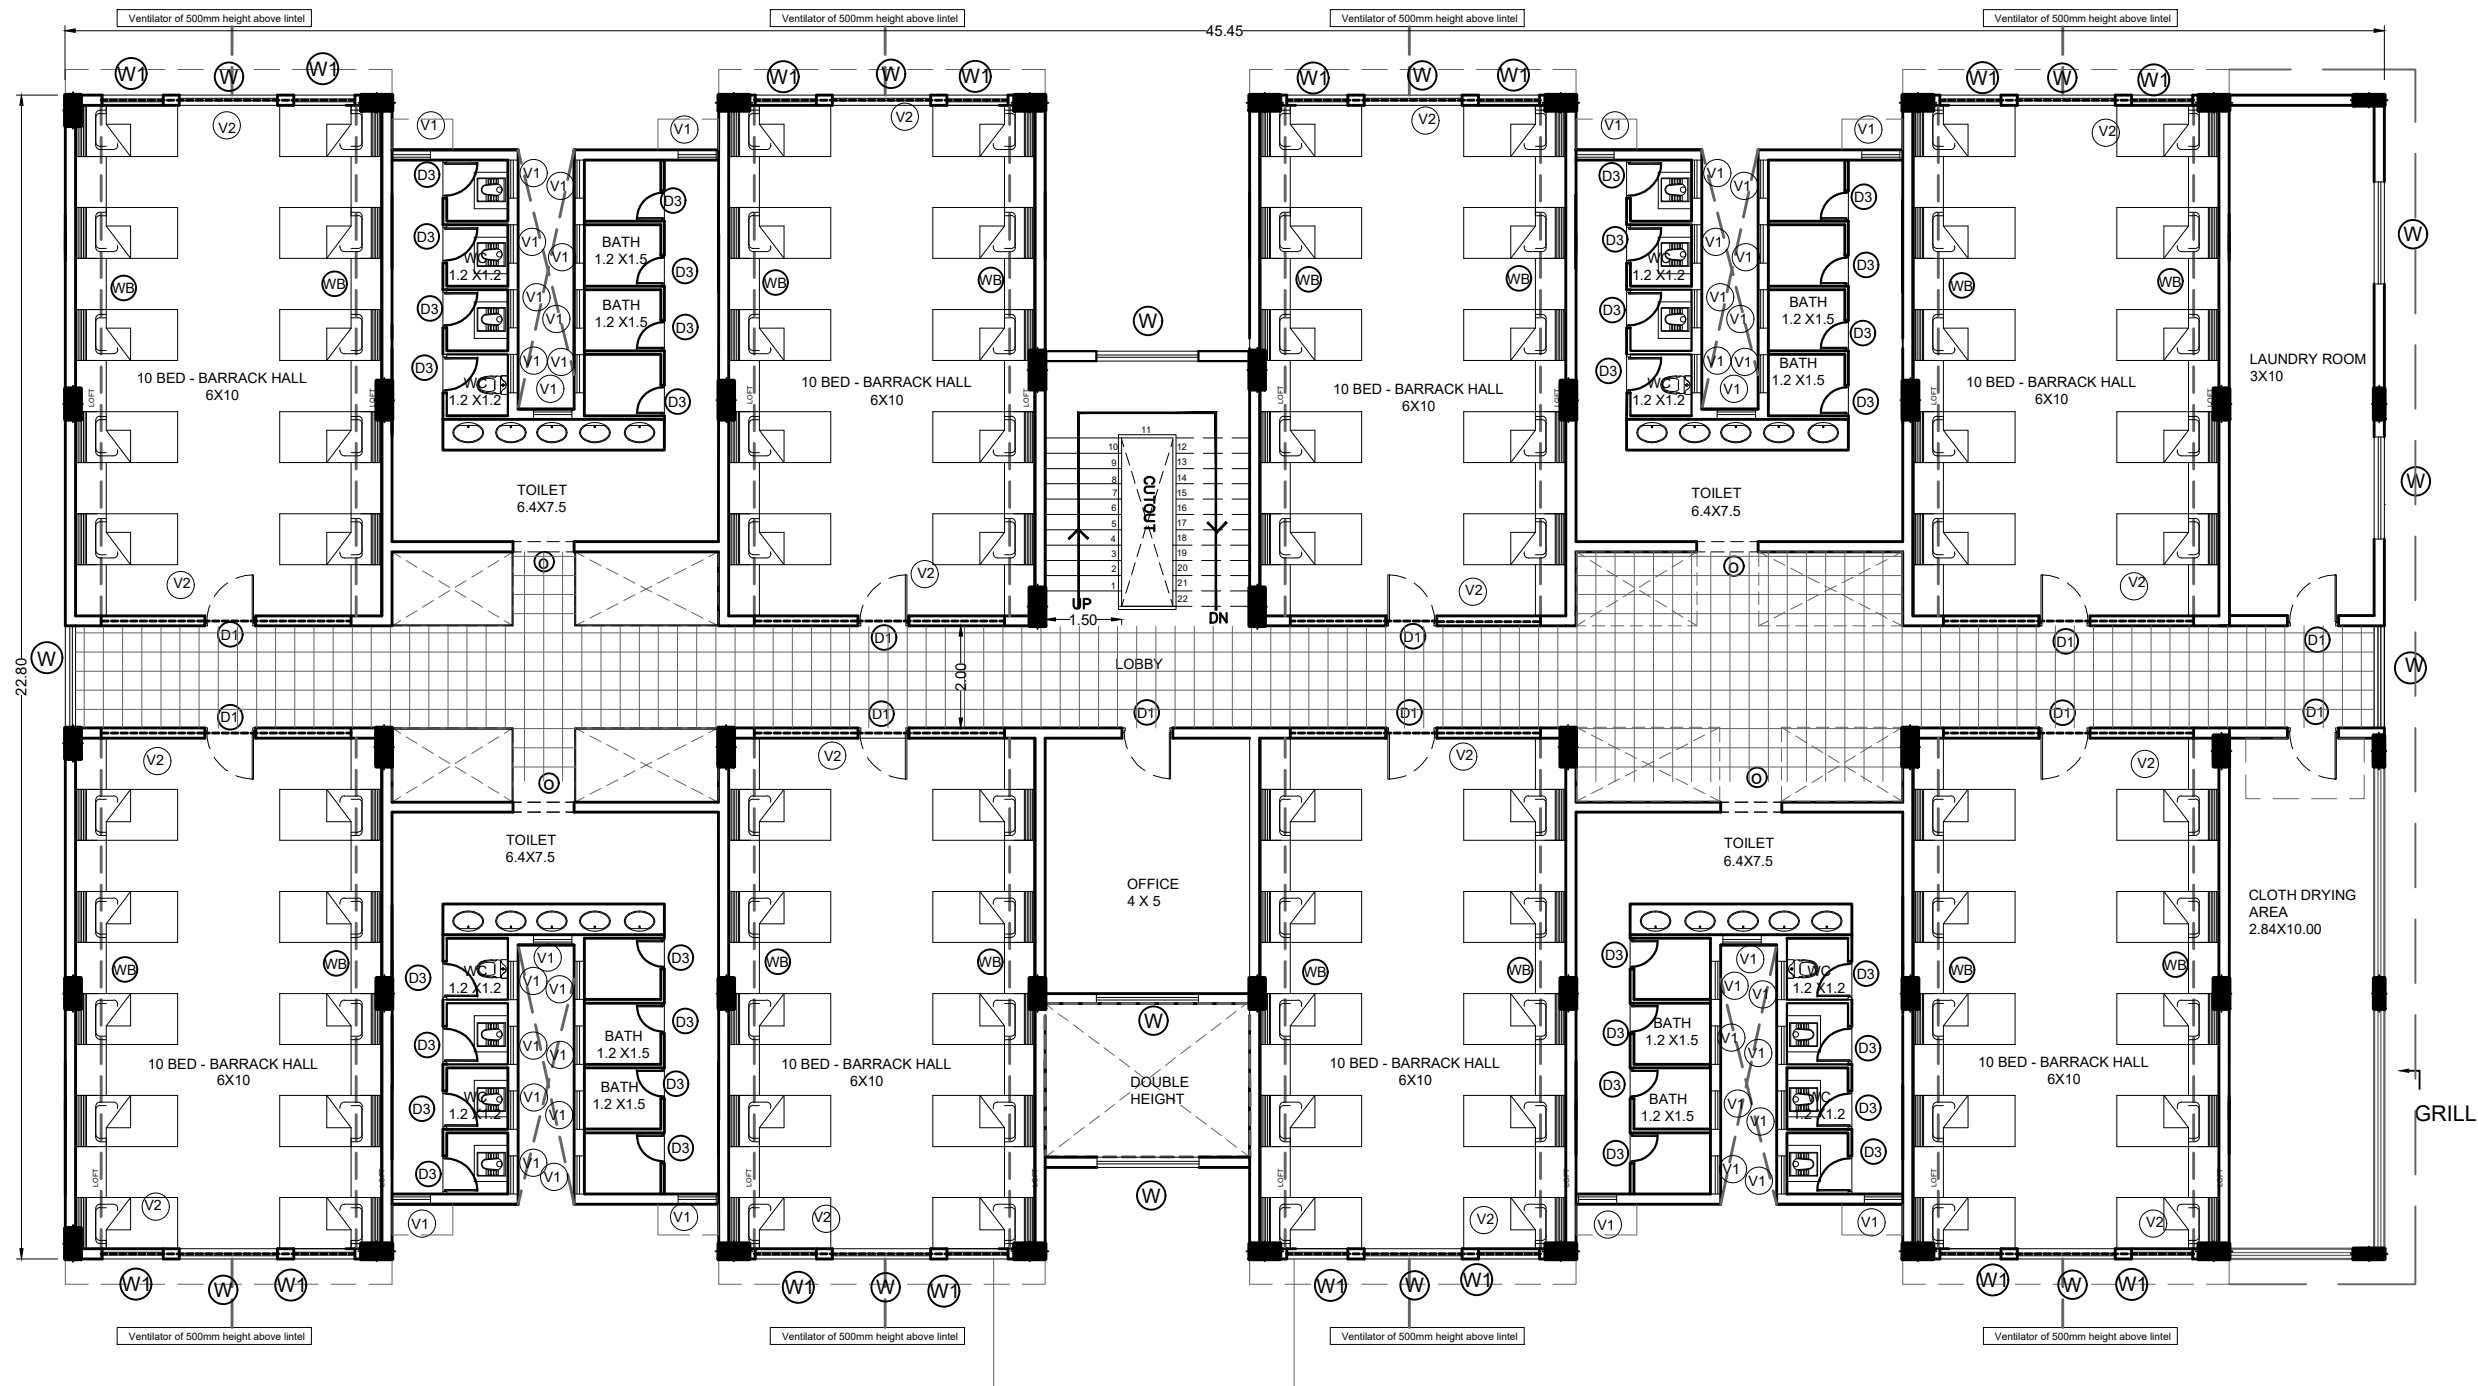

FIRST FLOOR PLAN

TOILET PROPORTION 1:5

LEGEND:

FIRST FLOOR BUILT UP - 944SQM

LIST OF FACILITIES

1. COMMON LOBBY
2. OFFICE
3. BARRACK HALL - 8X10= 80 BEDS
4. WASHROOM - 4X4 TOILET + 4X4BATH
5. STAIRCASE
6. CLOTH DRYING AREA
7. LAUNDRY

NOTE : ALL DIMENSION IN METERS

PROJECT :
PROVIDING COMPREHENSIVE PROJECT
MANAGEMENT CONSULTANCY SERVICES FOR
PROPOSED CONSTRUCTION OF CISF
INFRASTRUCTURE BUILDINGS
AT NOTE MUDRAN NAGAR MYSORE

TENDER DRAWING

Page 32 of 129

BRBNMPL - BARRACK FLOOR PLAN

Date : 10-10-2025

Drawn by: AMRUTHA

Rev Date: -----


Checked by: Ar. Kavitha



ARCHITECTS :
KULKARNI ASSOCIATES

Surya Prema Building, next to Adiga's Restaurant, Kanakapura Road
No-203, 2nd floor, Above Canara bank Raghuvahalli Branch
Raghuvahalli Village, Uttarahalli hobli Bangalore-560062

Email Id : kulkarni.associates@yahoo.com

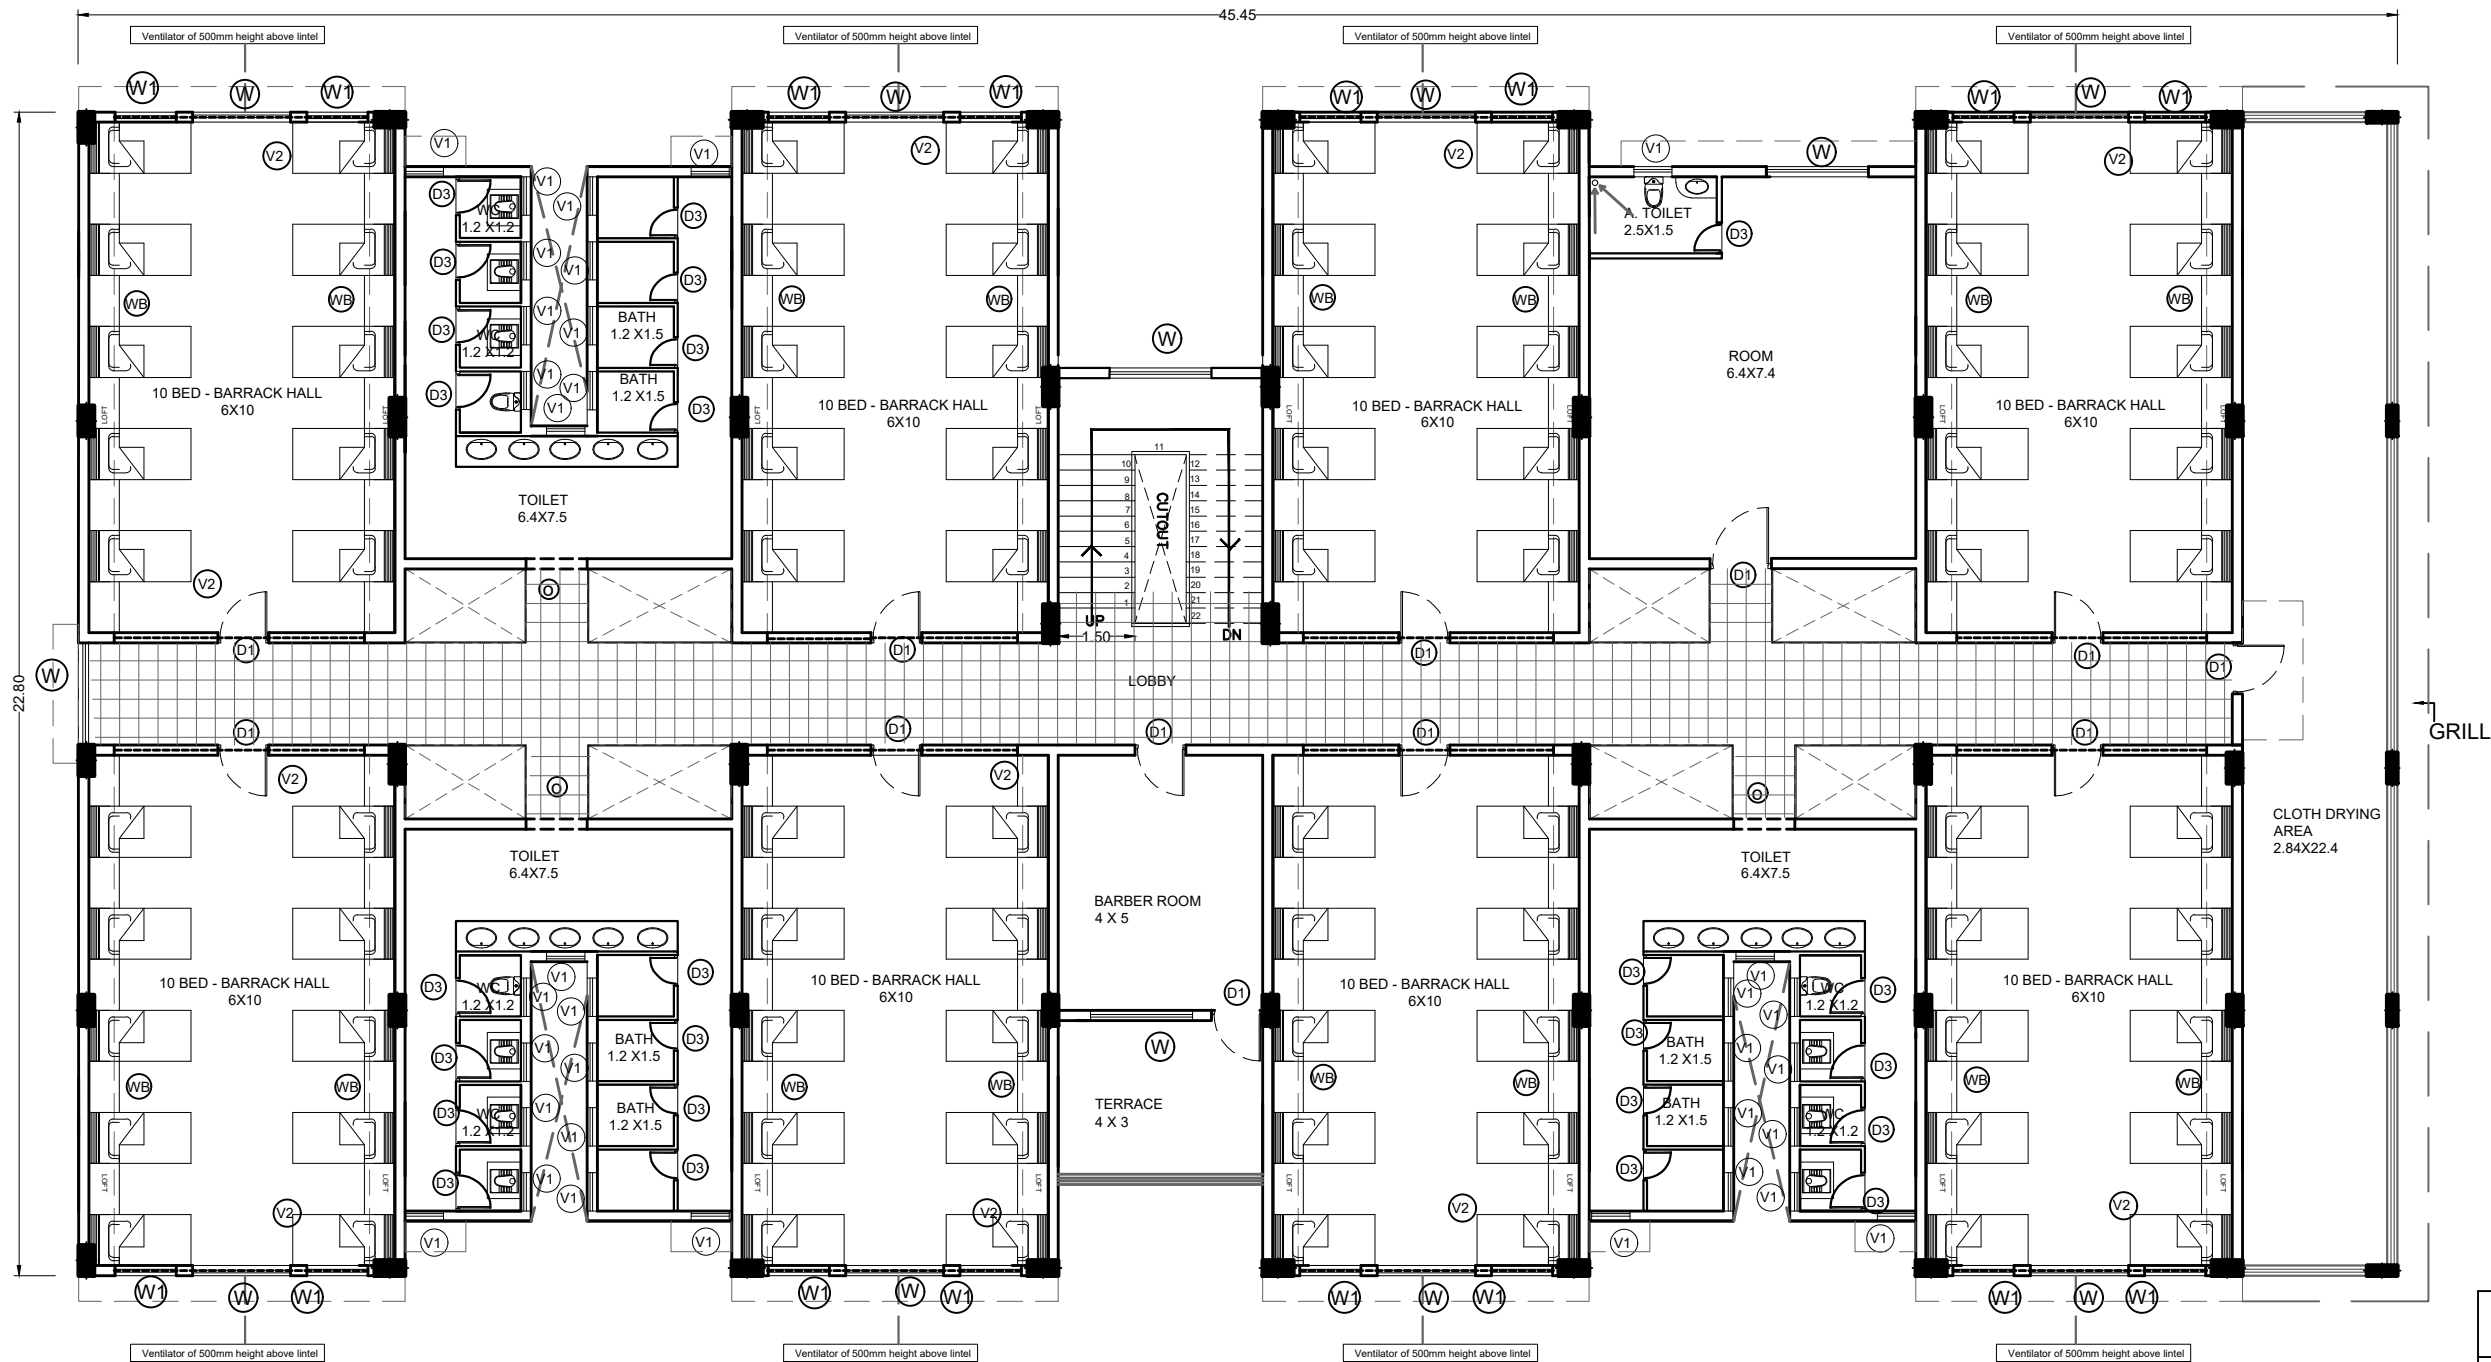

SECOND FLOOR PLAN

TOILET PROPORTION 1:7

LEGEND:
SECOND FLOOR BUILT UP - 935 SQM
LIST OF FACILITIES
1. COMMON LOBBY
2. BARBER ROOM
3. BARRACK ROOM - 8X10= 80 BEDS
4.ROOM + A. TOILET
5. WASHROOM - 3X5 TOILET+3X5 BATH
6. STAIRCASE
7. CLOTH DRYING AREA
NOTE : ALL DIMENSION IN METERS

PROJECT :
PROVIDING COMPREHENSIVE PROJECT
MANAGEMENT CONSULTANCY SERVICES FOR
PROPOSED CONSTRUCTION OF CISF
INFRASTRUCTURE BUILDINGS
AT NOTE MUDRAN NAGAR MYSORE

TENDER DRAWING

Page 33 of 129

BRBNMPL - BARRACK FLOOR PLAN

Date : 10-10-2025

Drawn by: AMRUTHA

Rev Date: -----


Checked by: Ar. Kavitha



ARCHITECTS :
KULKARNI ASSOCIATES

Surya Prema Building, next to Adiga's Restaurant, Kanakapura Road
No-203, 2nd floor, Above Canara bank Raghuvahalli Branch
Raghuvahalli Village, Uttarahalli hobli Bangalore-560062


Email Id : kulkarni.associates@yahoo.com

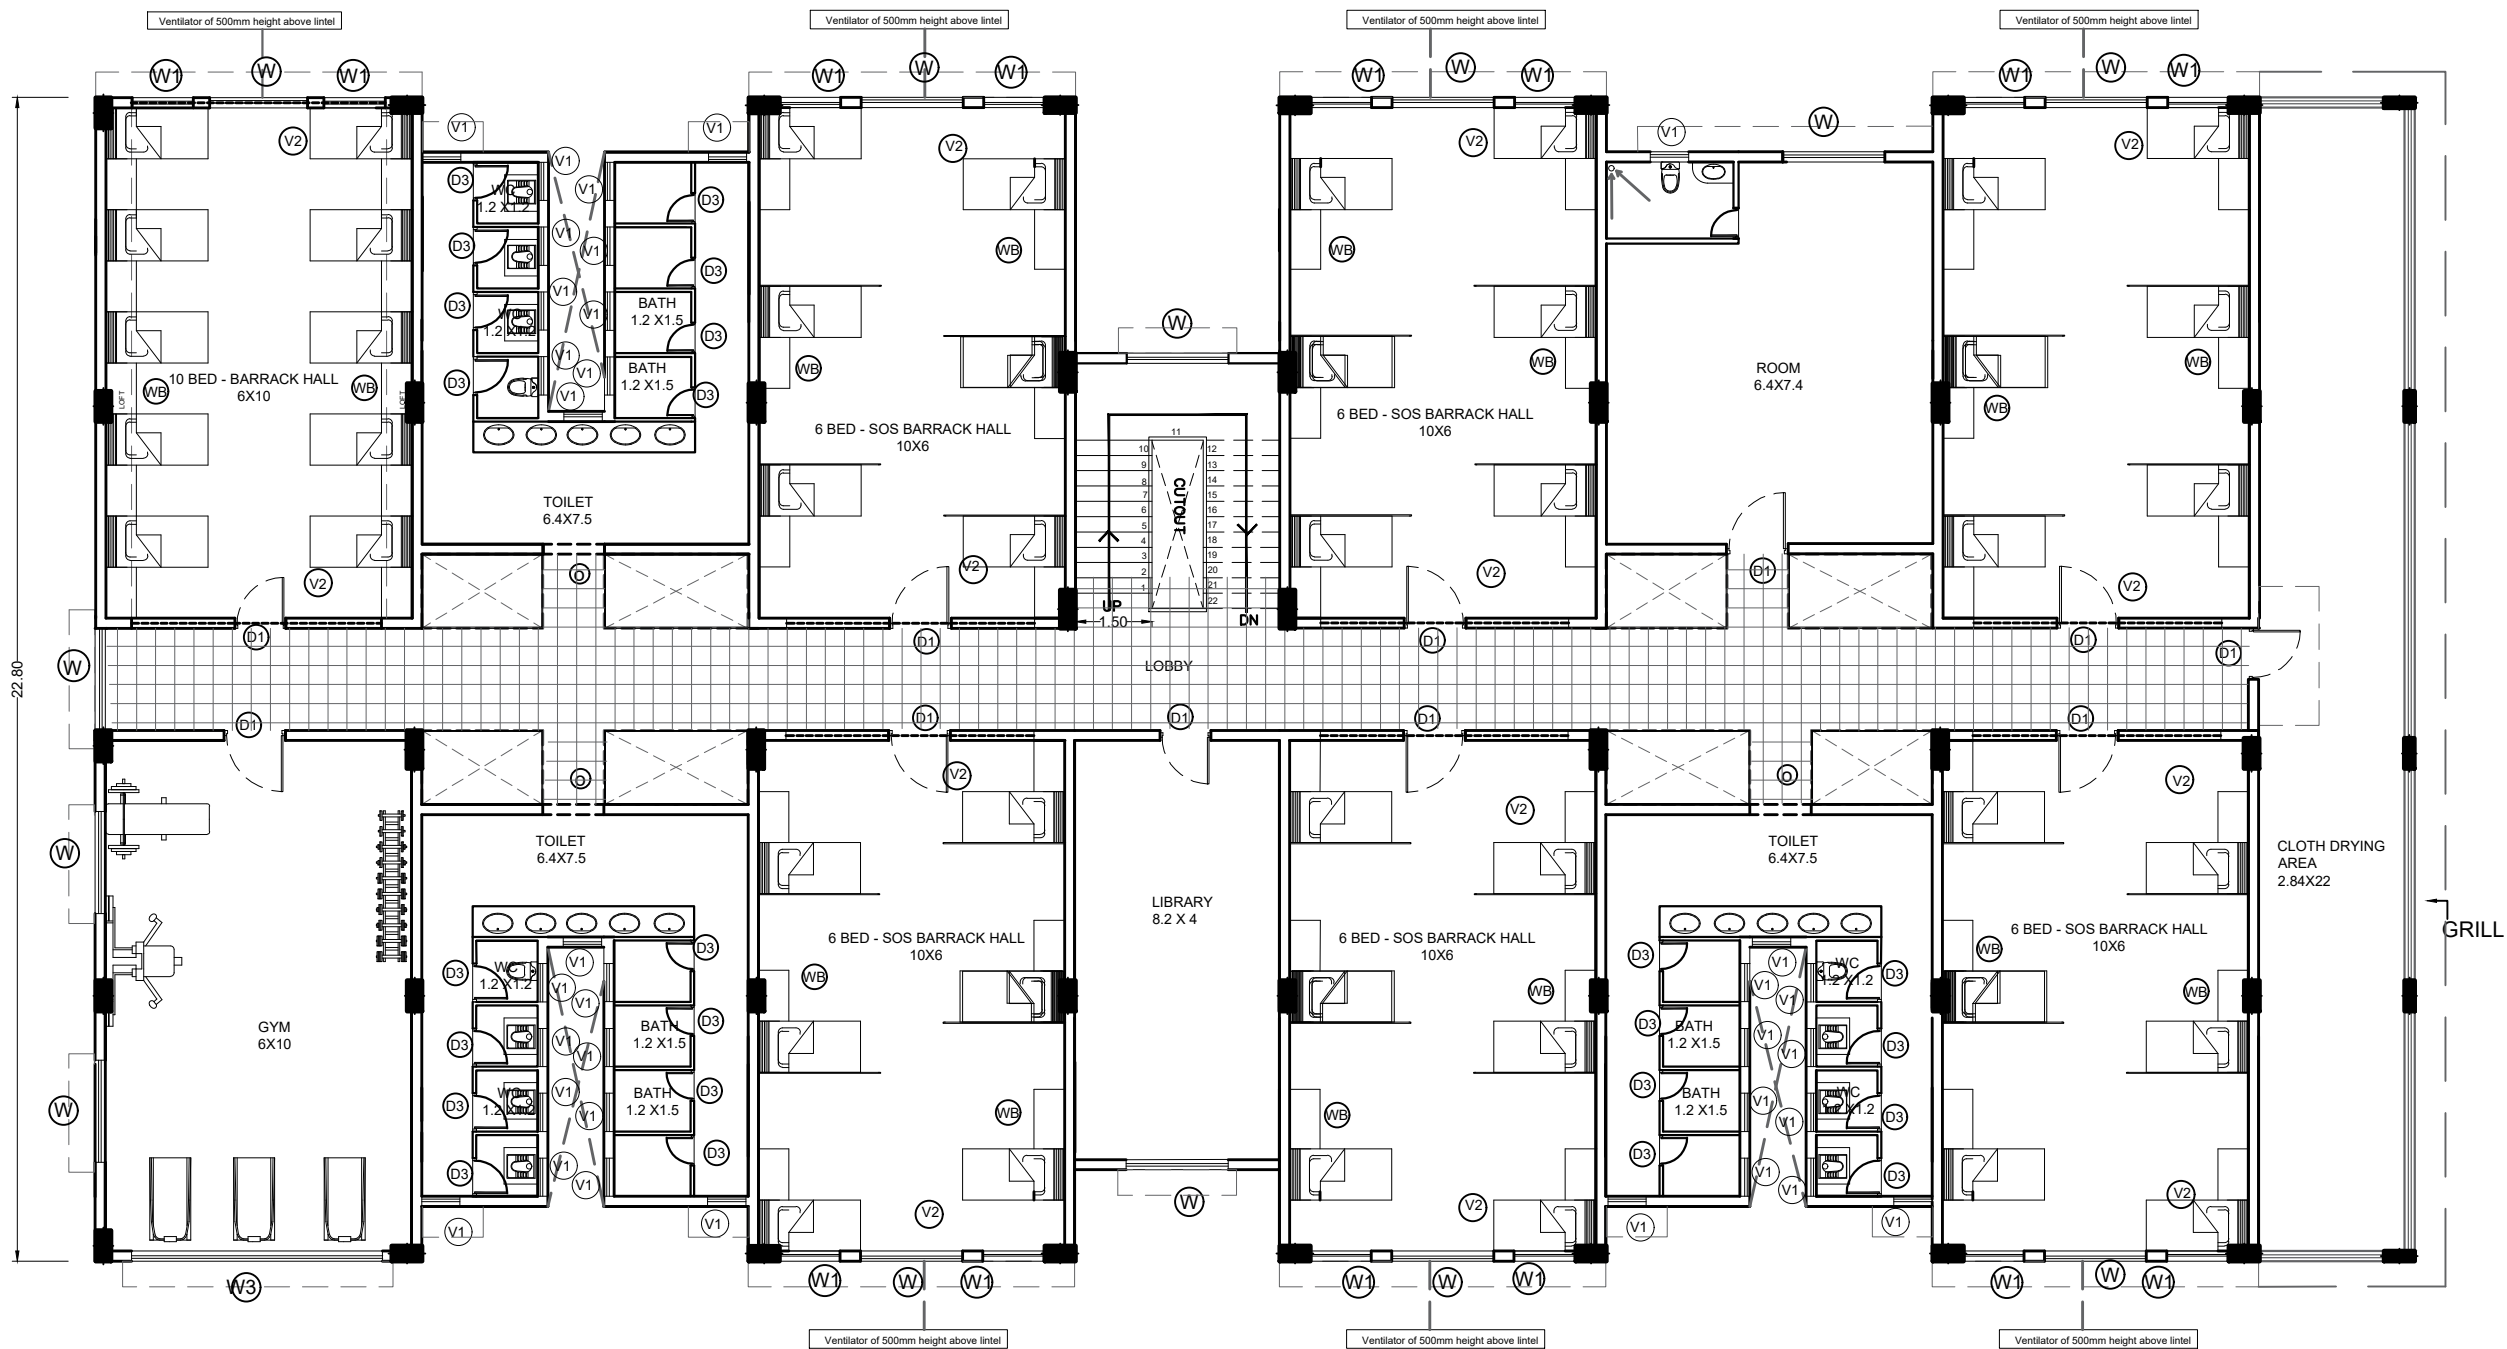

THIRD FLOOR PLAN


TOILET PROPORTION 1:4	
LEGEND:	
THIRD FLOOR BUILT UP - 935SQM	
LIST OF FACILITIES	
1. COMMON LOBBY	
2. BARRACK ROOM - 6X6=36 BEDS	
3. WASHROOM - 1X4 TOILET +1X4 BATH	
4. ROOM + A. TOILET - 2	
5. WASH AND DRYING AREA	
6. LIBRARY	
7. GYM	
8. STAIRCASE	
9. CLOTH DRYING AREA	
10. BARRACK ROOM - 1X10=10 BEDS	
NOTE : ALL DIMENSION IN METERS	



PROJECT : PROVIDING COMPREHENSIVE PROJECT MANAGEMENT CONSULTANCY SERVICES FOR PROPOSED CONSTRUCTION OF CISF INFRASTRUCTURE BUILDINGS AT NOTE MUDRAN NAGAR MYSORE	TENDER DRAWING	BRBNMPL - BARRACK FLOOR PLAN		N	ARCHITECTS : KULKARNI ASSOCIATES Surya Prema Building, next to Adiga's Restaurant, Kanakapura Road No-203, 2nd floor, Above Canara bank Raghuvahalli Branch Raghuvahalli Village, Uttarahalli hobli Bangalore-560062 Email Id : kulkarni.associates@yahoo.com
		Date : 10-10-2025	Drawn by: AMRUTHA		
		Page 34 of 129	Checked by: Ar. Kavitha		
		Rev Date: -----			

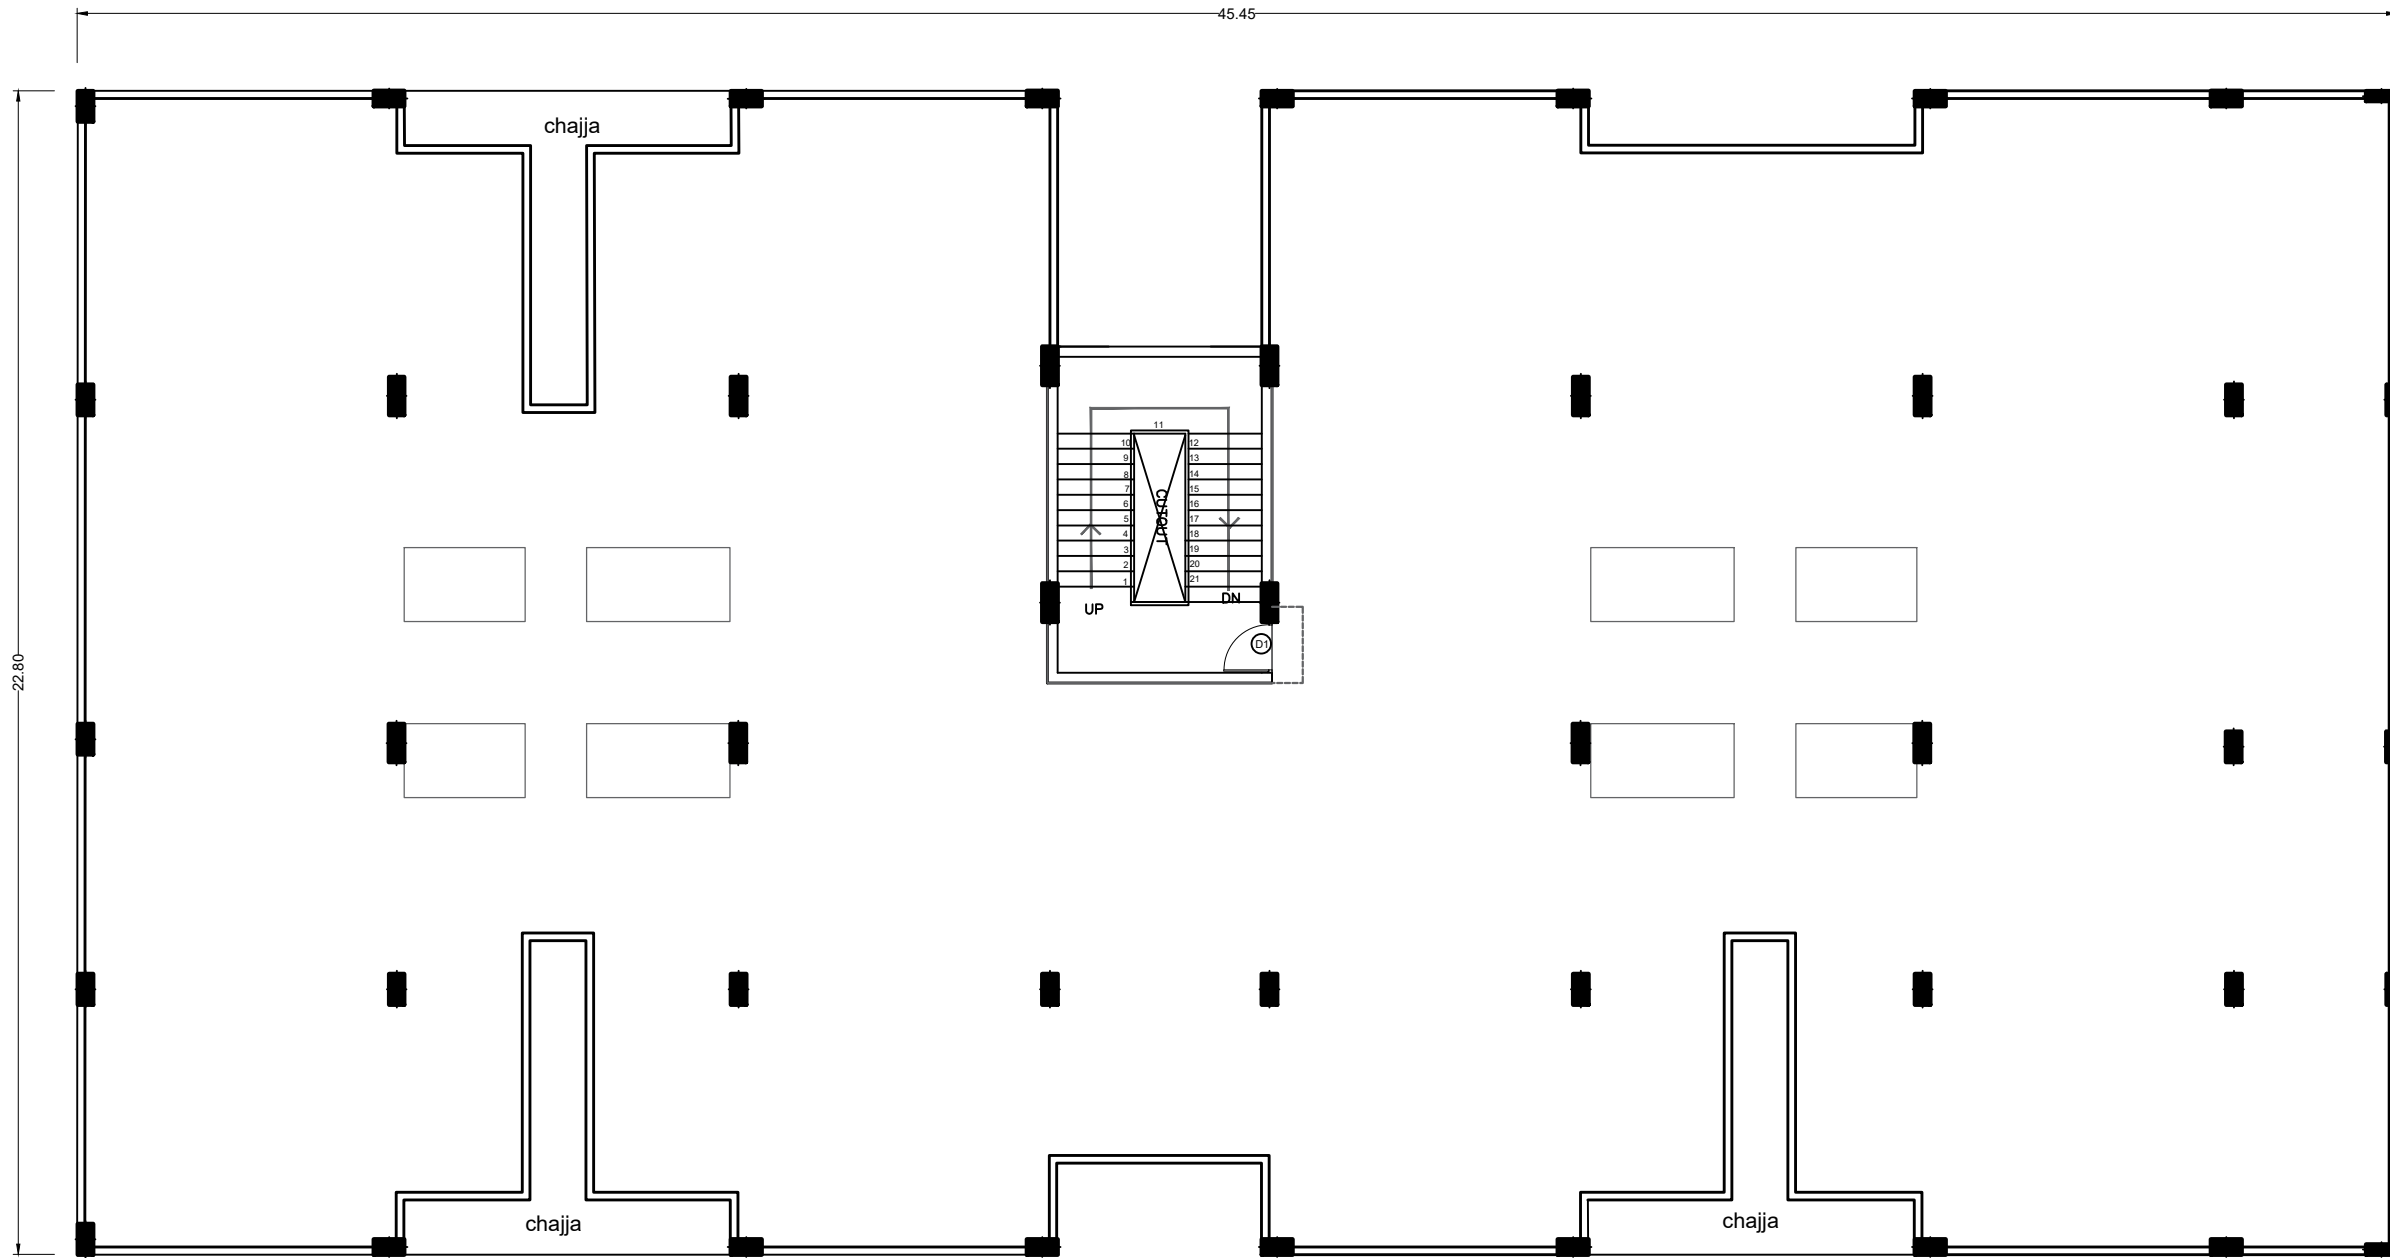

TERRACE FLOOR PLAN

 NOTE : ALL DIMENSION IN METERS

PROJECT : PROVIDING COMPREHENSIVE PROJECT MANAGEMENT CONSULTANCY SERVICES FOR PROPOSED CONSTRUCTION OF CISF INFRASTRUCTURE BUILDINGS AT NOTE MUDRAN NAGAR MYSORE	TENDER DRAWING	BRBNMPL - BARRACK FLOOR PLAN Date :30-10-2025 Drawn by: AMRUTHA Scale: 1/25 Checked by: Ar. Kavitha Rev Date: -----	N 	ARCHITECTS : KULKARNI ASSOCIATES Surya Prema Building,next to Adiga's Restaurant,Kanakapura Road No-203,2nd floor,Above Canara bank Raghuvahalli Branch Raghuvanhalli Village,Uttarahalli hobli Bangalore-560062 Email Id : kulkarni.associates@yahoo.com
--	---------------------------	--	---	--

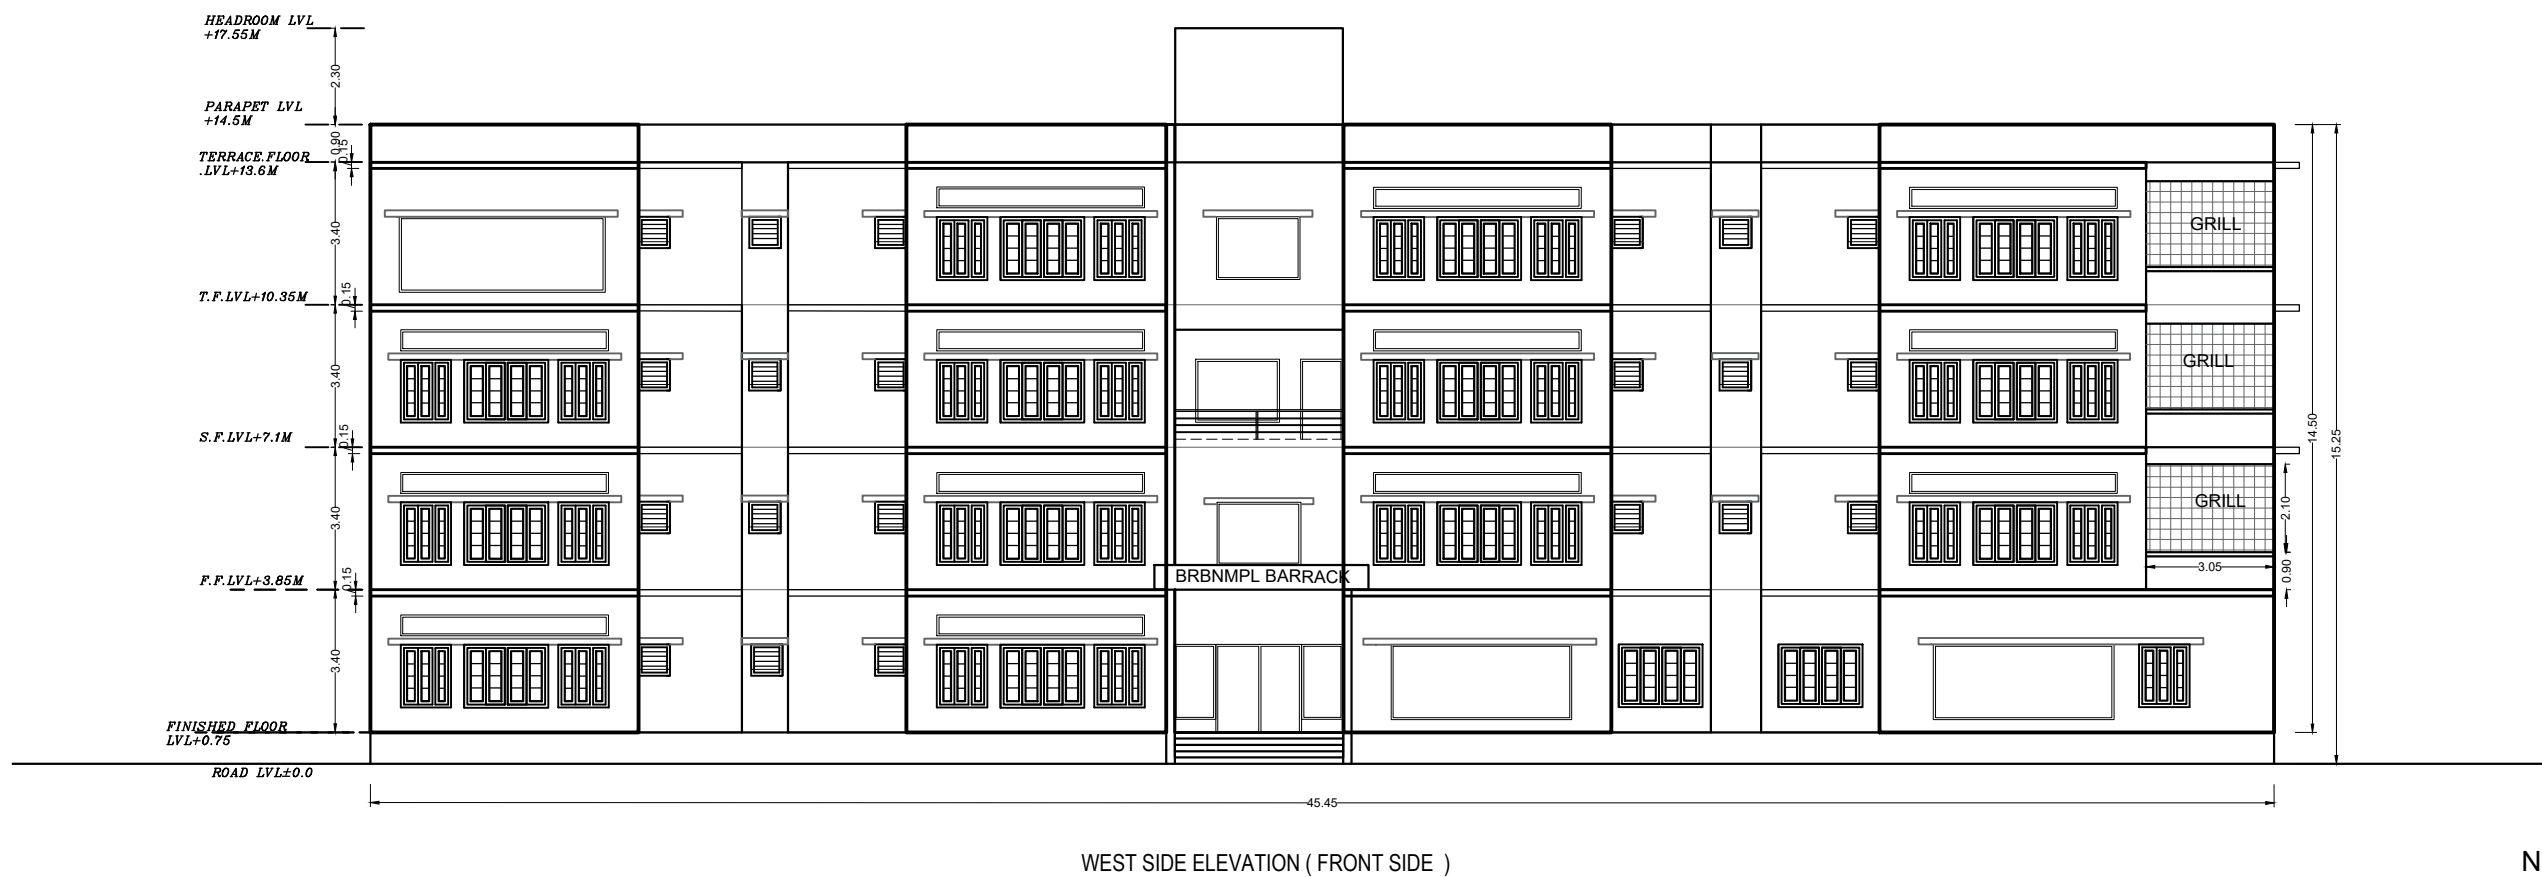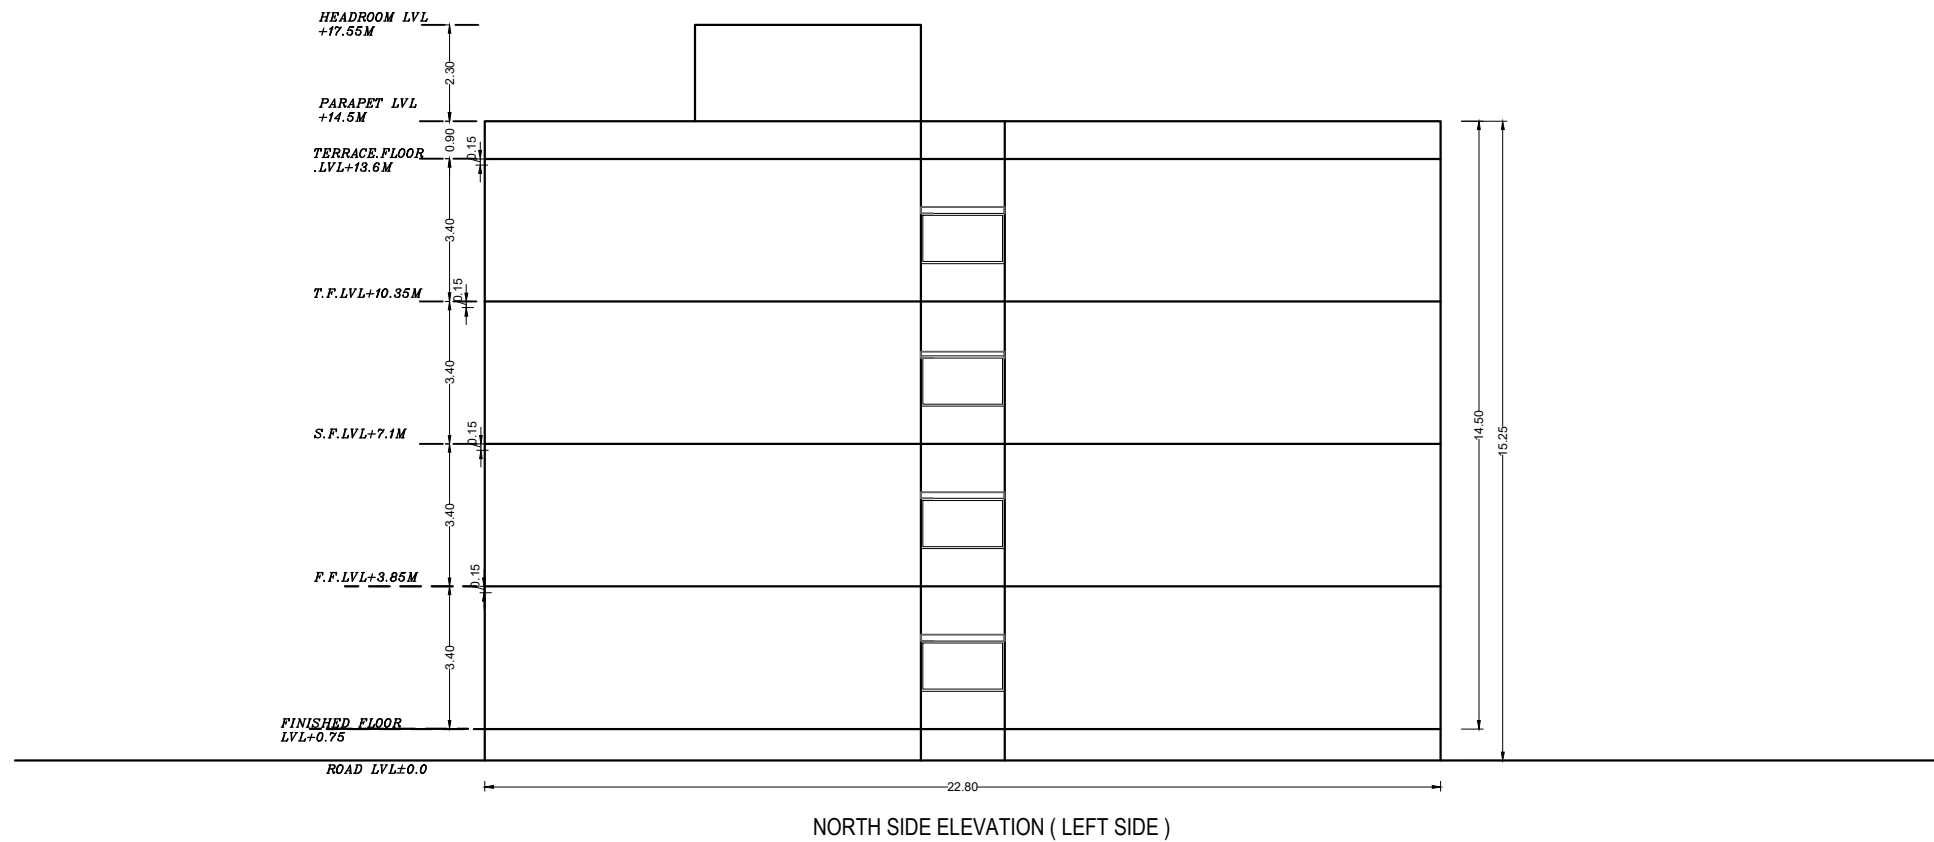

NOTE : ALL DIMENSION IN METERS

PROJECT :
PROVIDING COMPREHENSIVE PROJECT
MANAGEMENT CONSULTANCY SERVICES FOR
PROPOSED CONSTRUCTION OF CISF
INFRASTRUCTURE BUILDINGS
AT NOTE MUDRAN NAGAR MYSORE

TENDER DRAWING

BRBNMPL - BARRACK ELEVATION

Date : 30-10-2025

Drawn by: AMRUTHA


Checked by: Ar. Kavitha

Rev Date: -----


ARCHITECTS :
KULKARNI ASSOCIATES

Surya Prema Building, next to Adiga's Restaurant, Kanakapura Road
No-203, 2nd floor, Above Canara bank Raghuvahalli Branch
Raghuvahalli Village, Uttarahalli hobli Bangalore-560062

Email Id : kulkarni.associates@yahoo.com

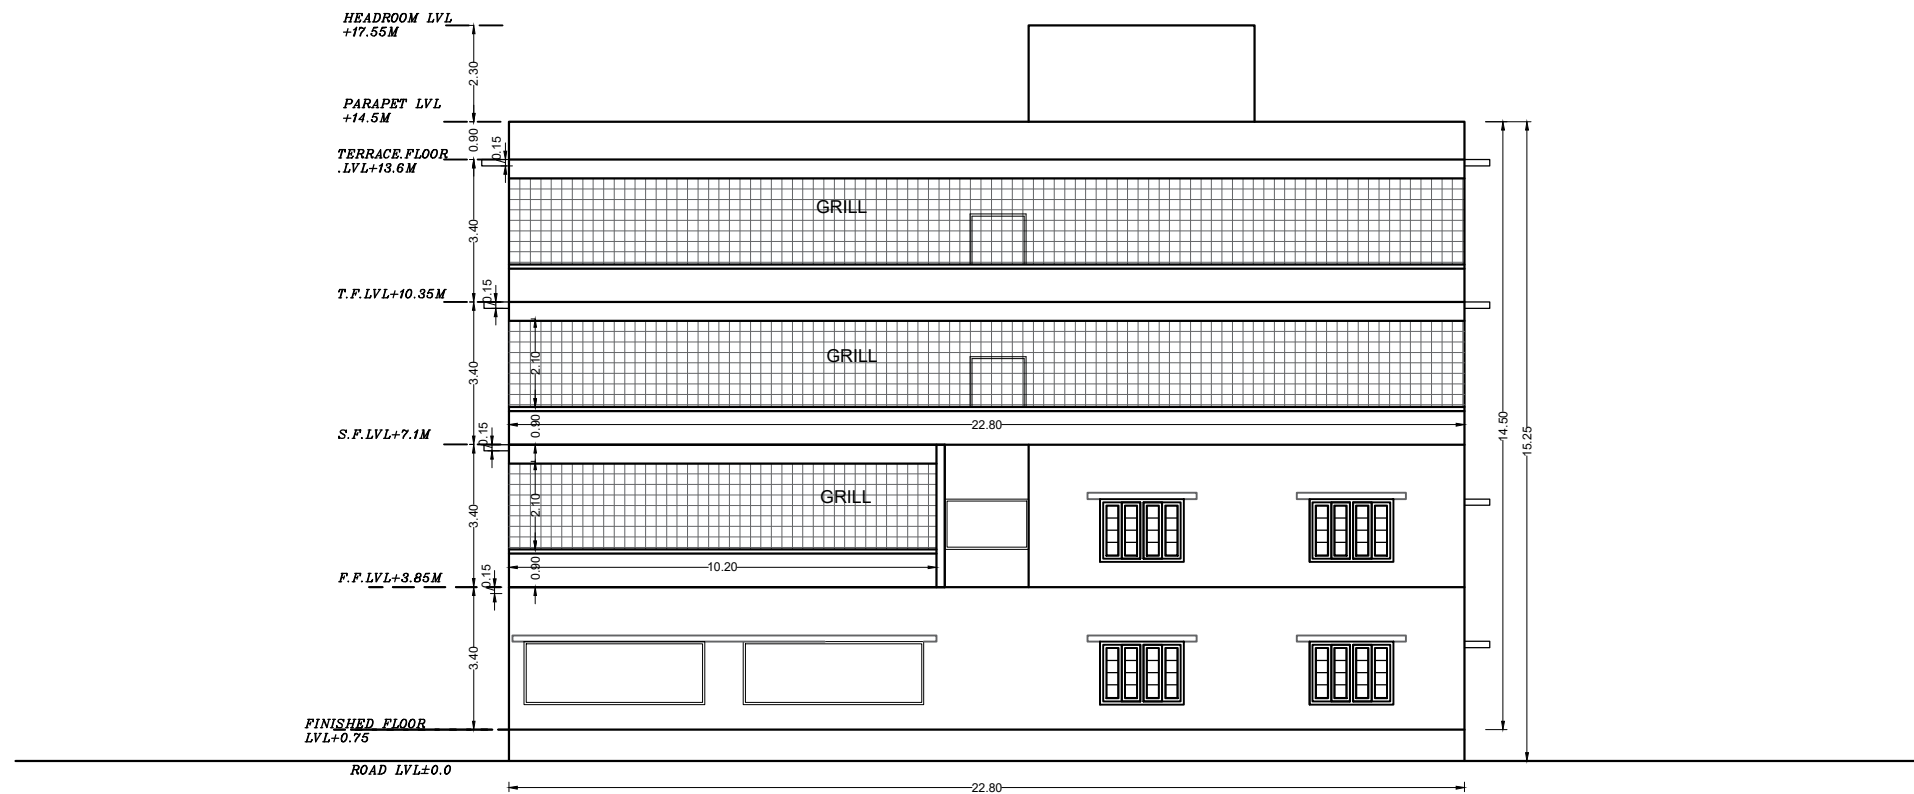

SOUTH SIDE ELEVATION (RIGHT SIDE)

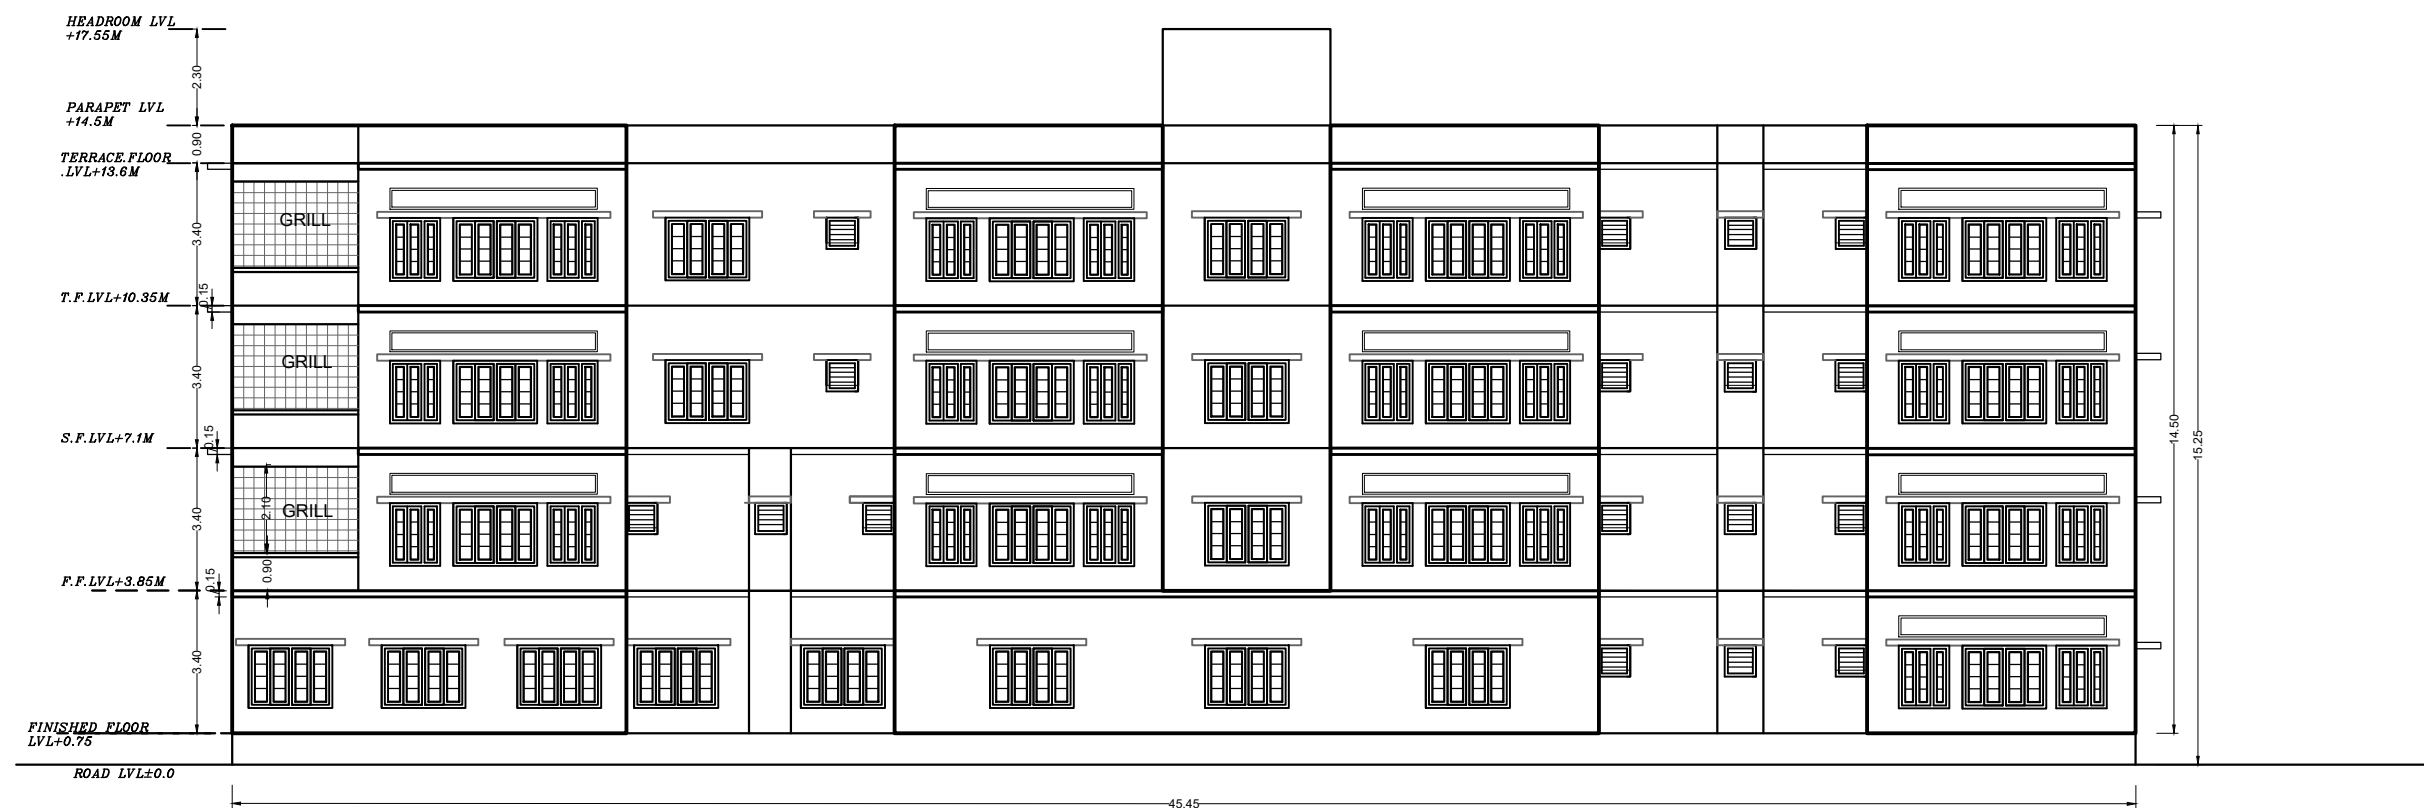

EAST SIDE ELEVATION (REAR SIDE)

NOTE : ALL DIMENSION IN METERS

PROJECT :
PROVIDING COMPREHENSIVE PROJECT
MANAGEMENT CONSULTANCY SERVICES FOR
PROPOSED CONSTRUCTION OF CISF
INFRASTRUCTURE BUILDINGS
AT NOTE MUDRAN NAGAR MYSORE

TENDER DRAWING

Page 37 of 129

BRBNMPL - BARRACK ELEVATION

Date : 30-10-2025

Drawn by: AMRUTHA

Checked by: Ar. Kavitha

Rev Date: -----


ARCHITECTS :
KULKARNI ASSOCIATES

Surya Prema Building, next to Adiga's Restaurant, Kanakapura Road
No-203, 2nd floor, Above Canara bank Raghuvahalli Branch
Raghuvahalli Village, Uttarahalli hobli Bangalore-560062



Email Id : kulkarni.associates@yahoo.com

SLAB

FINISHED FLOOR

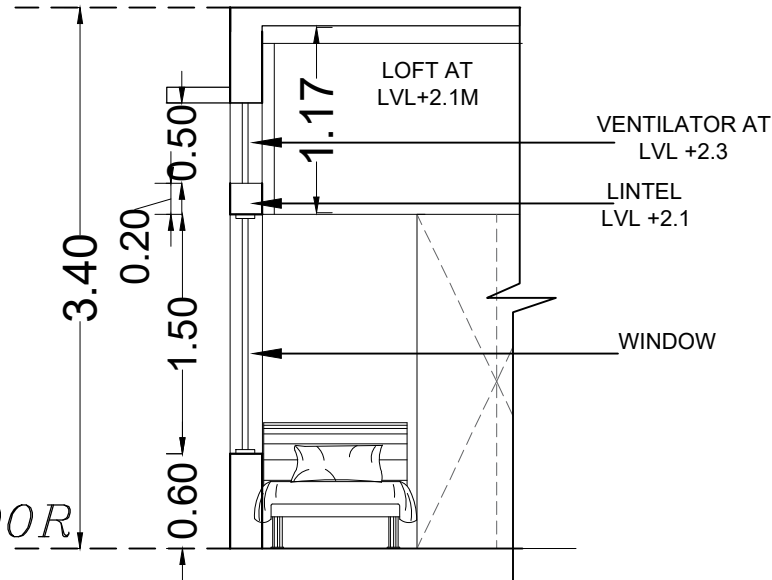

TYPICAL 10 BED BARRACK ROOM SECTION

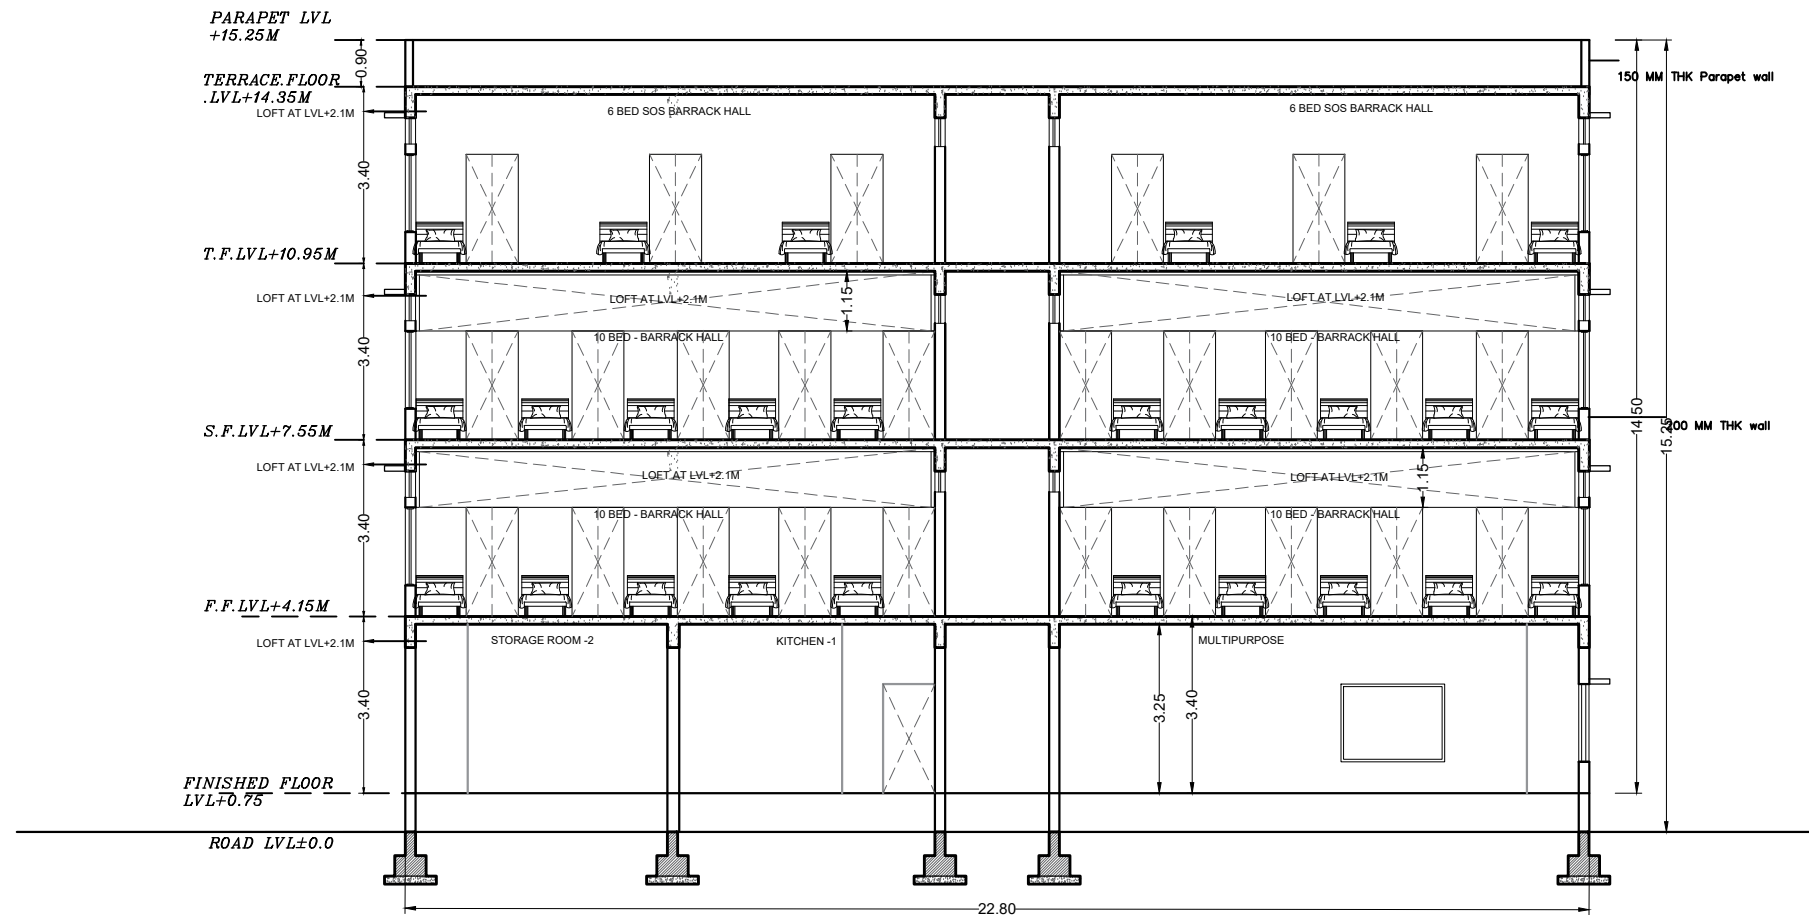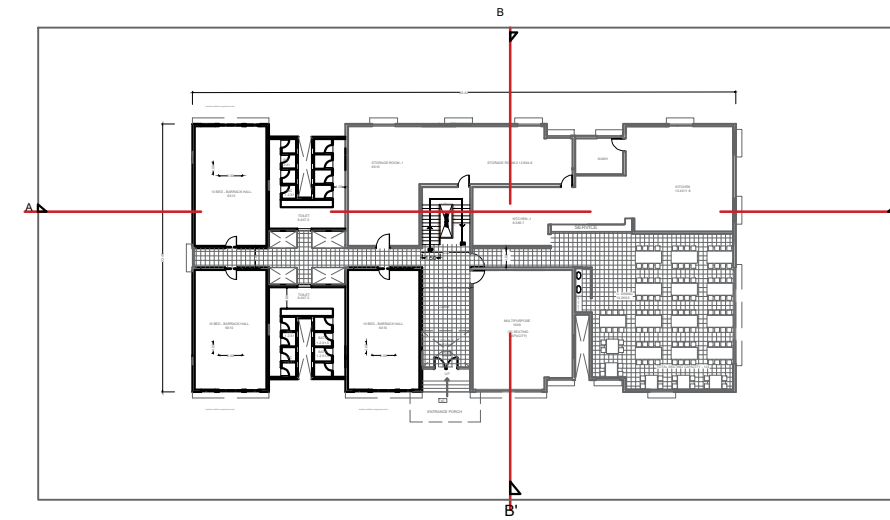

SECTION BB'

NOTE : ALL DIMENSION IN METERS

PROJECT :
PROVIDING COMPREHENSIVE PROJECT
MANAGEMENT CONSULTANCY SERVICES FOR
PROPOSED CONSTRUCTION OF CISF
INFRASTRUCTURE BUILDINGS
AT NOTE MUDRAN NAGAR MYSORE

TENDER DRAWING

Page 39 of 129

BRBNMPL - BARRACK SECTION

Date : 30-10-2025

Drawn by: AMRUTHA

Scale: 1/20


Checked by: Ar. Kavitha

Rev Date: -----

ARCHITECTS :
KULKARNI ASSOCIATES

Surya Prema Building, next to Adiga's Restaurant, Kanakapura Road
No-203, 2nd floor, Above Canara bank Raghuvahalli Branch
Raghuvahalli Village, Uttarahalli hobli Bangalore-560062

Email Id : kulkarni.associates@yahoo.com

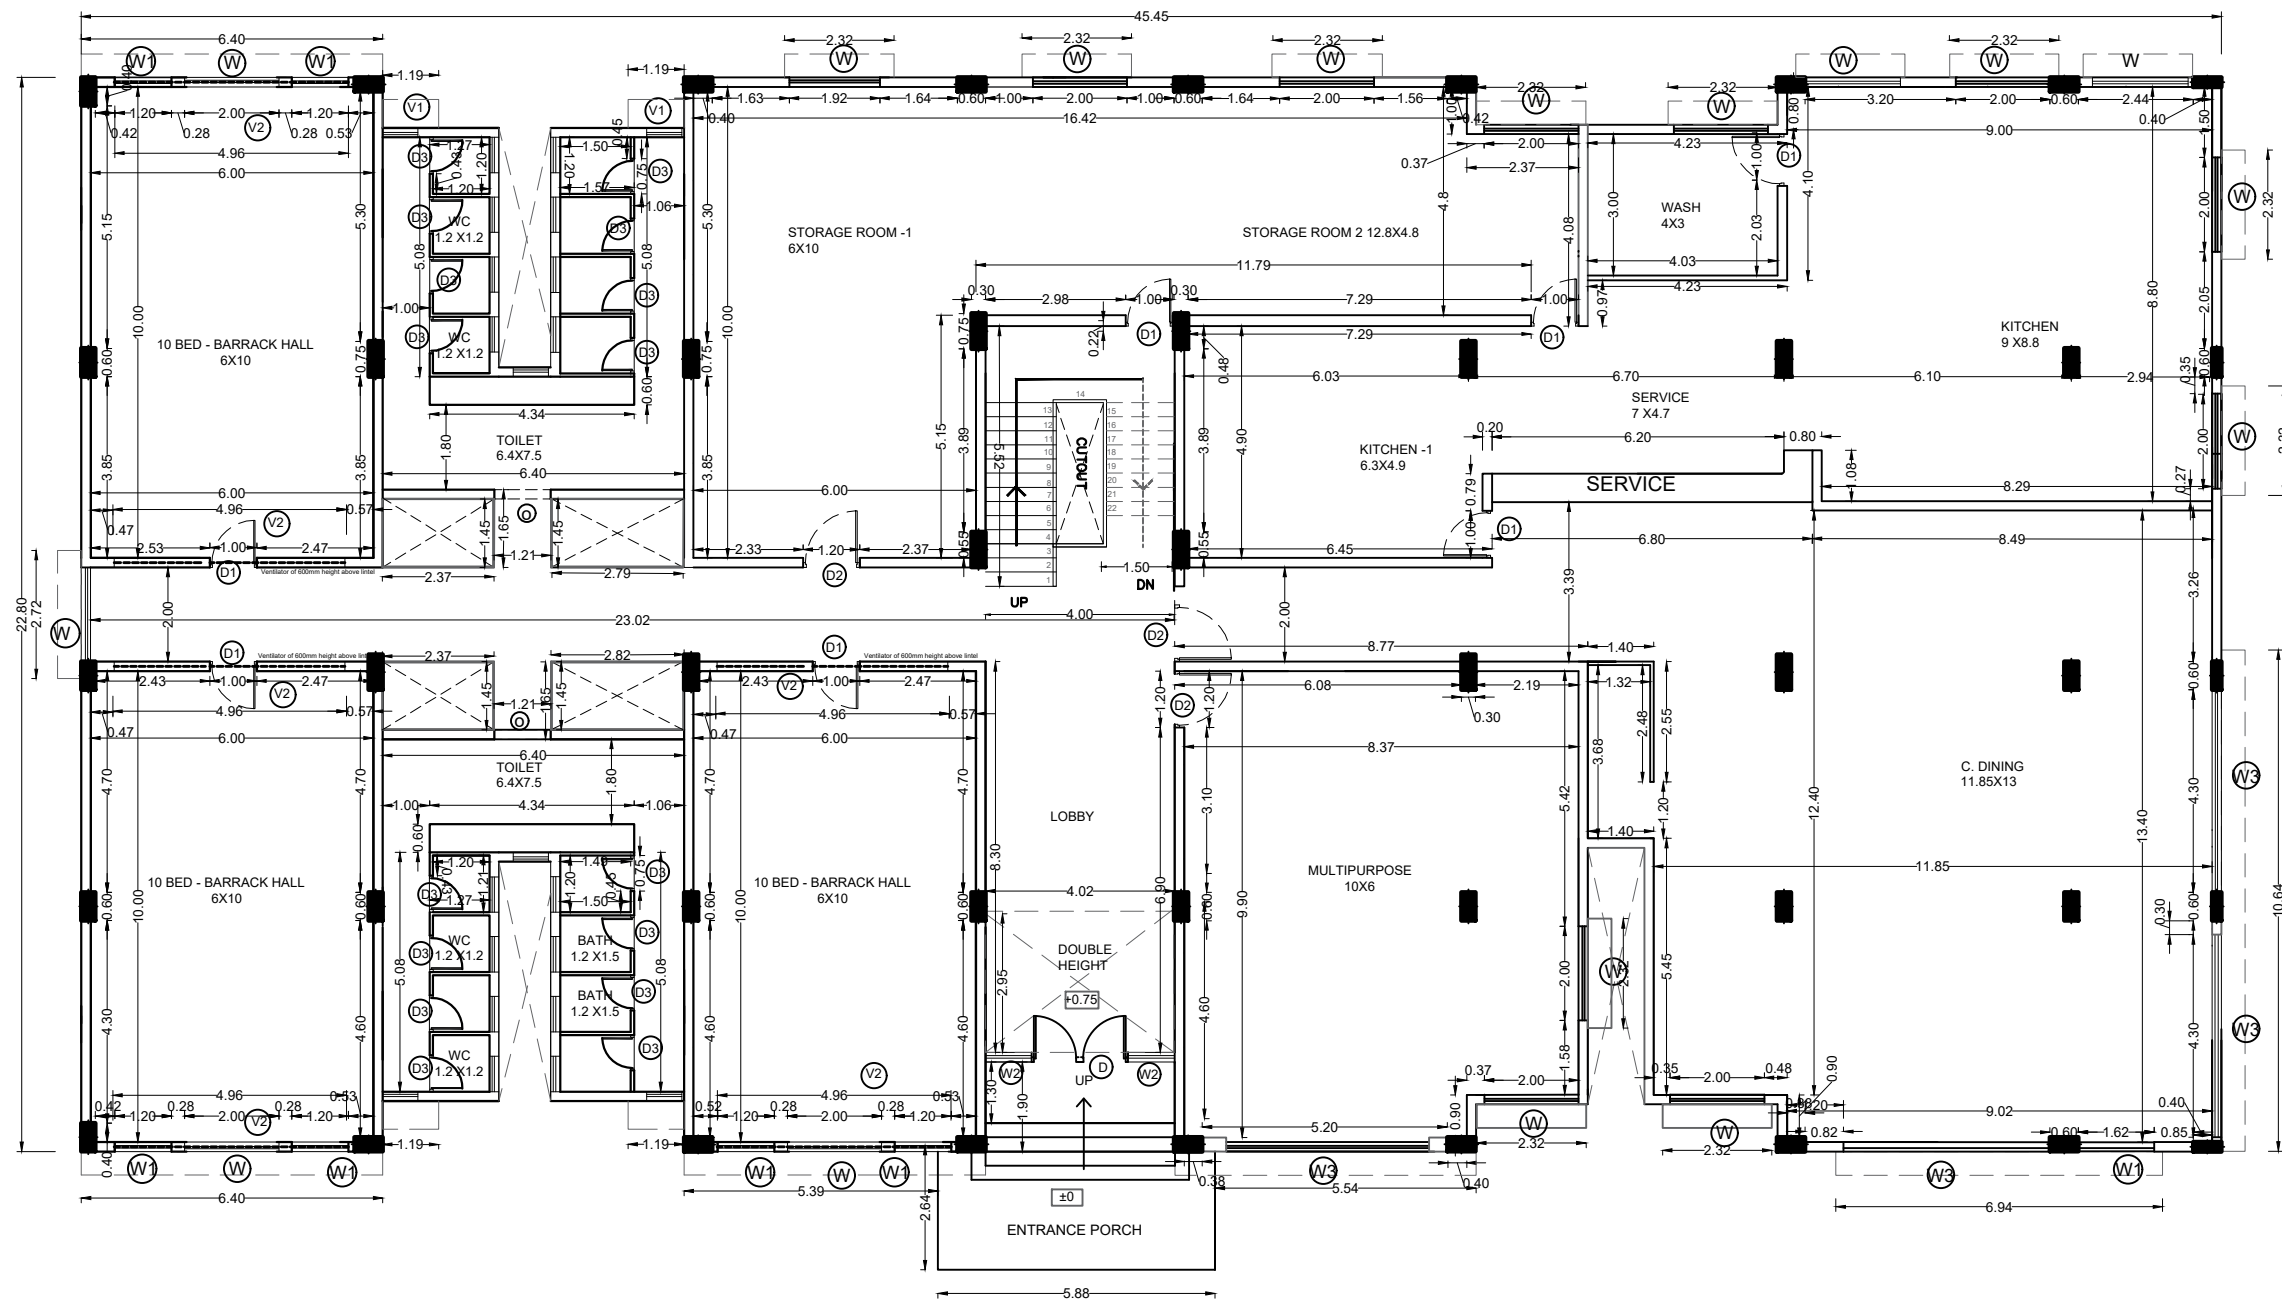

GROUND FLOOR PLAN

SCHEDULE OF OPENINGS		
DOORS		
	SIZE IN M	Nos
D	2.00 X 2.10	1
D1	1.00 X 2.10	7
D2	1.20 X 2.10	3
D3	0.75 X 2.10	16
WINDOWS		
W	2.00 X 1.50	14
W1	1.20 X 1.50	10
W2	1.00 X 1.79	2
W3	4.31 X 1.50	4
VENTILATORS		
V1	0.75X 0.75	22
V2	4.96X0.5	6
OPENING		
O	1.2X2.1	2

NOTE : ALL Chajja projection is 0.6m deep

TOILET PROPORTION 1:4

LEGEND:
GROUND FLOOR BUILT UP - 977 SQM
LIST OF FACILITIES
1. ENTRANCE LOBBY
2. MULTIPURPOSE HALL - 50 SEATING
3. STORAGE ROOM
4. KITCHEN
5. WASH AREA
6. DINING AREA - 124 SEATING
7. BARRACK HALL - 3X10=30 BEDS
8. WASHROOM - 2X4 TOILET + 2X4 BATH
9. STAIRCASE

NOTE : ALL DIMENSION IN METERS

PROJECT :
PROVIDING COMPREHENSIVE PROJECT
MANAGEMENT CONSULTANCY SERVICES FOR
PROPOSED CONSTRUCTION OF CISF
INFRASTRUCTURE BUILDINGS
AT NOTE MUDRAN NAGAR MYSORE

TENDER DRAWING

BRBNMPL - BARRACK FLOOR PLAN
WORKING DRAWING


Date :30-10-2025	Drawn by: AMRUTHA
Rev Date: -----	Checked by: Ar. Kavitha



ARCHITECTS :
KULKARNI ASSOCIATES

Surya Prema Building, next to Adiga's Restaurant, Kanakapura Road
No-203, 2nd floor, Above Canara bank Raghuvahalli Branch
Raghuvahalli Village, Uttarahalli hobli Bangalore-560062

Email Id : kulkarni.associates@yahoo.com

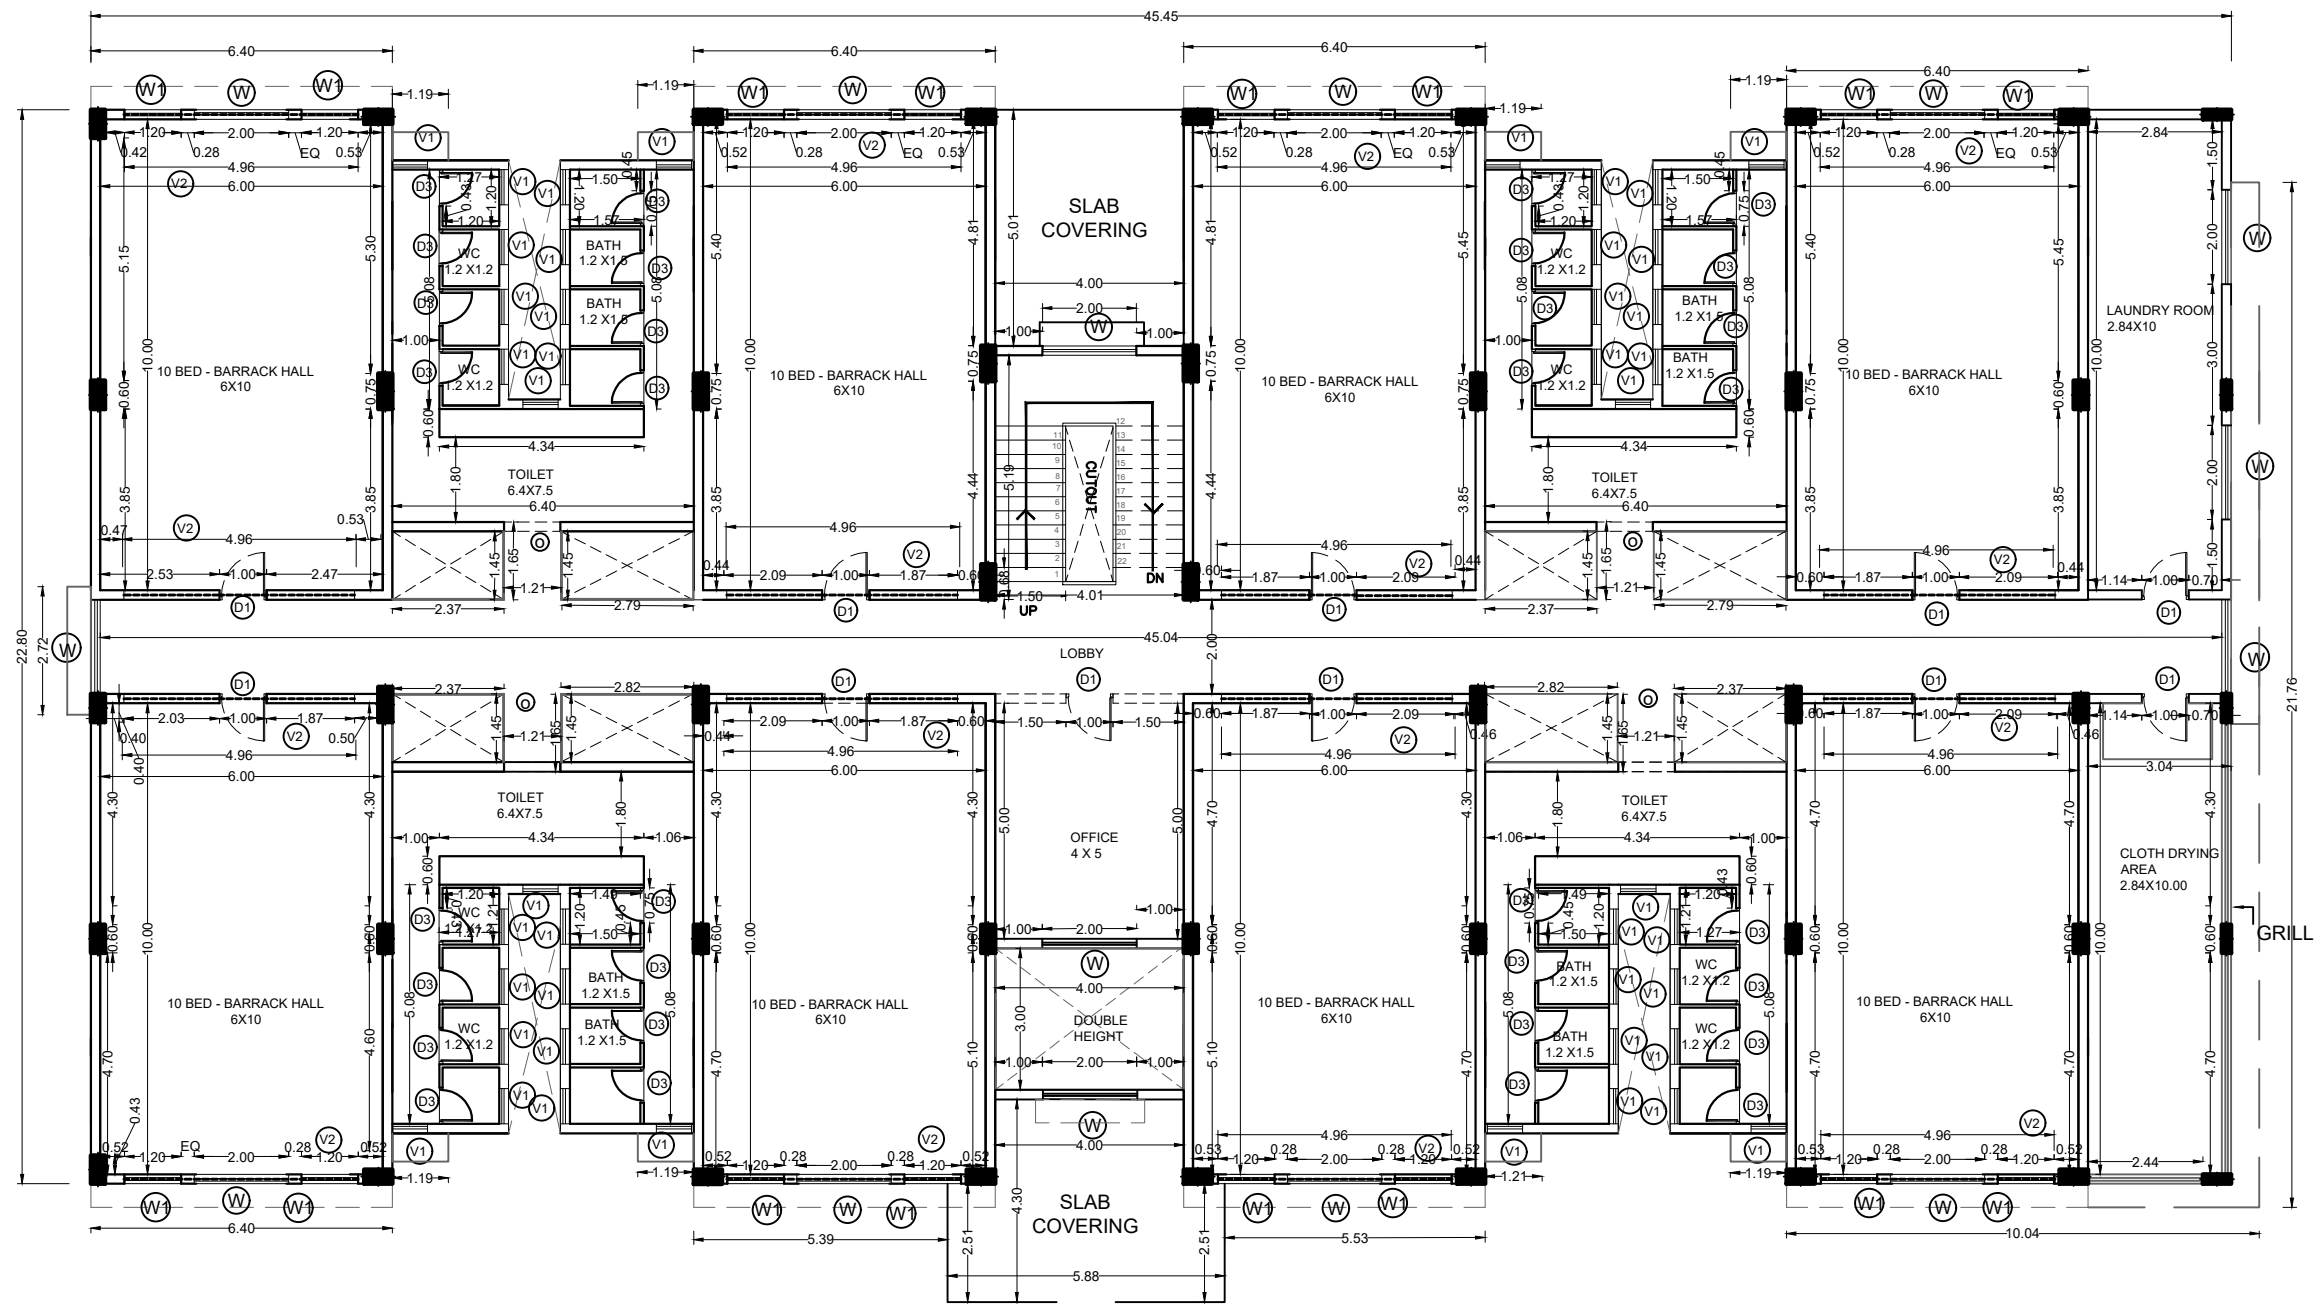

FIRST FLOOR PLAN

SCHEDULE OF OPENINGS		
DOORS		
	SIZE IN M	Nos
D1	1.00 X 2.10	11
D3	0.75 X 2.10	32
WINDOWS		
W	2.00 X 1.50	15
W1	1.20 X 1.50	16
VENTILATORS		
V1	0.75X 0.75	44
V2	4.96X0.5	16
OPENING		
O	1.2X2.1	4

NOTE : ALL Chajja projection is 0.6m deep

TOILET PROPORTION 1:5

LEGEND:

FIRST FLOOR BUILT UP - 944SQM

LIST OF FACILITIES

1. COMMON LOBBY

2. OFFICE

3. BARRACK HALL - 8X10= 80 BEDS

4. WASHROOM - 4X4 TOILET + 4X4BATH

5. STAIRCASE

6. CLOTH DRYING AREA

7. LAUNDRY

NOTE : ALL DIMENSION IN METERS

PROJECT :
PROVIDING COMPREHENSIVE PROJECT
MANAGEMENT CONSULTANCY SERVICES FOR
PROPOSED CONSTRUCTION OF CISF
INFRASTRUCTURE BUILDINGS
AT NOTE MUDRAN NAGAR MYSORE

TENDER DRAWING

Page 41 of 129

BRBNMPL - BARRACK FLOOR PLAN
WORKING DRAWING

Date :30-10-2025

Drawn by: AMRUTHA

Checked by: Ar. Kavitha


Rev Date: -----



ARCHITECTS :
KULKARNI ASSOCIATES

Surya Prema Building,next to Adiga's Restaurant,Kanakapura Road
No-203,2nd floor,Above Canara bank Raghuvahalli Branch
Raghuvanahalli Village,Uttarahalli hobli Bangalore-560062

Email Id : kulkarni.associates@yahoo.com

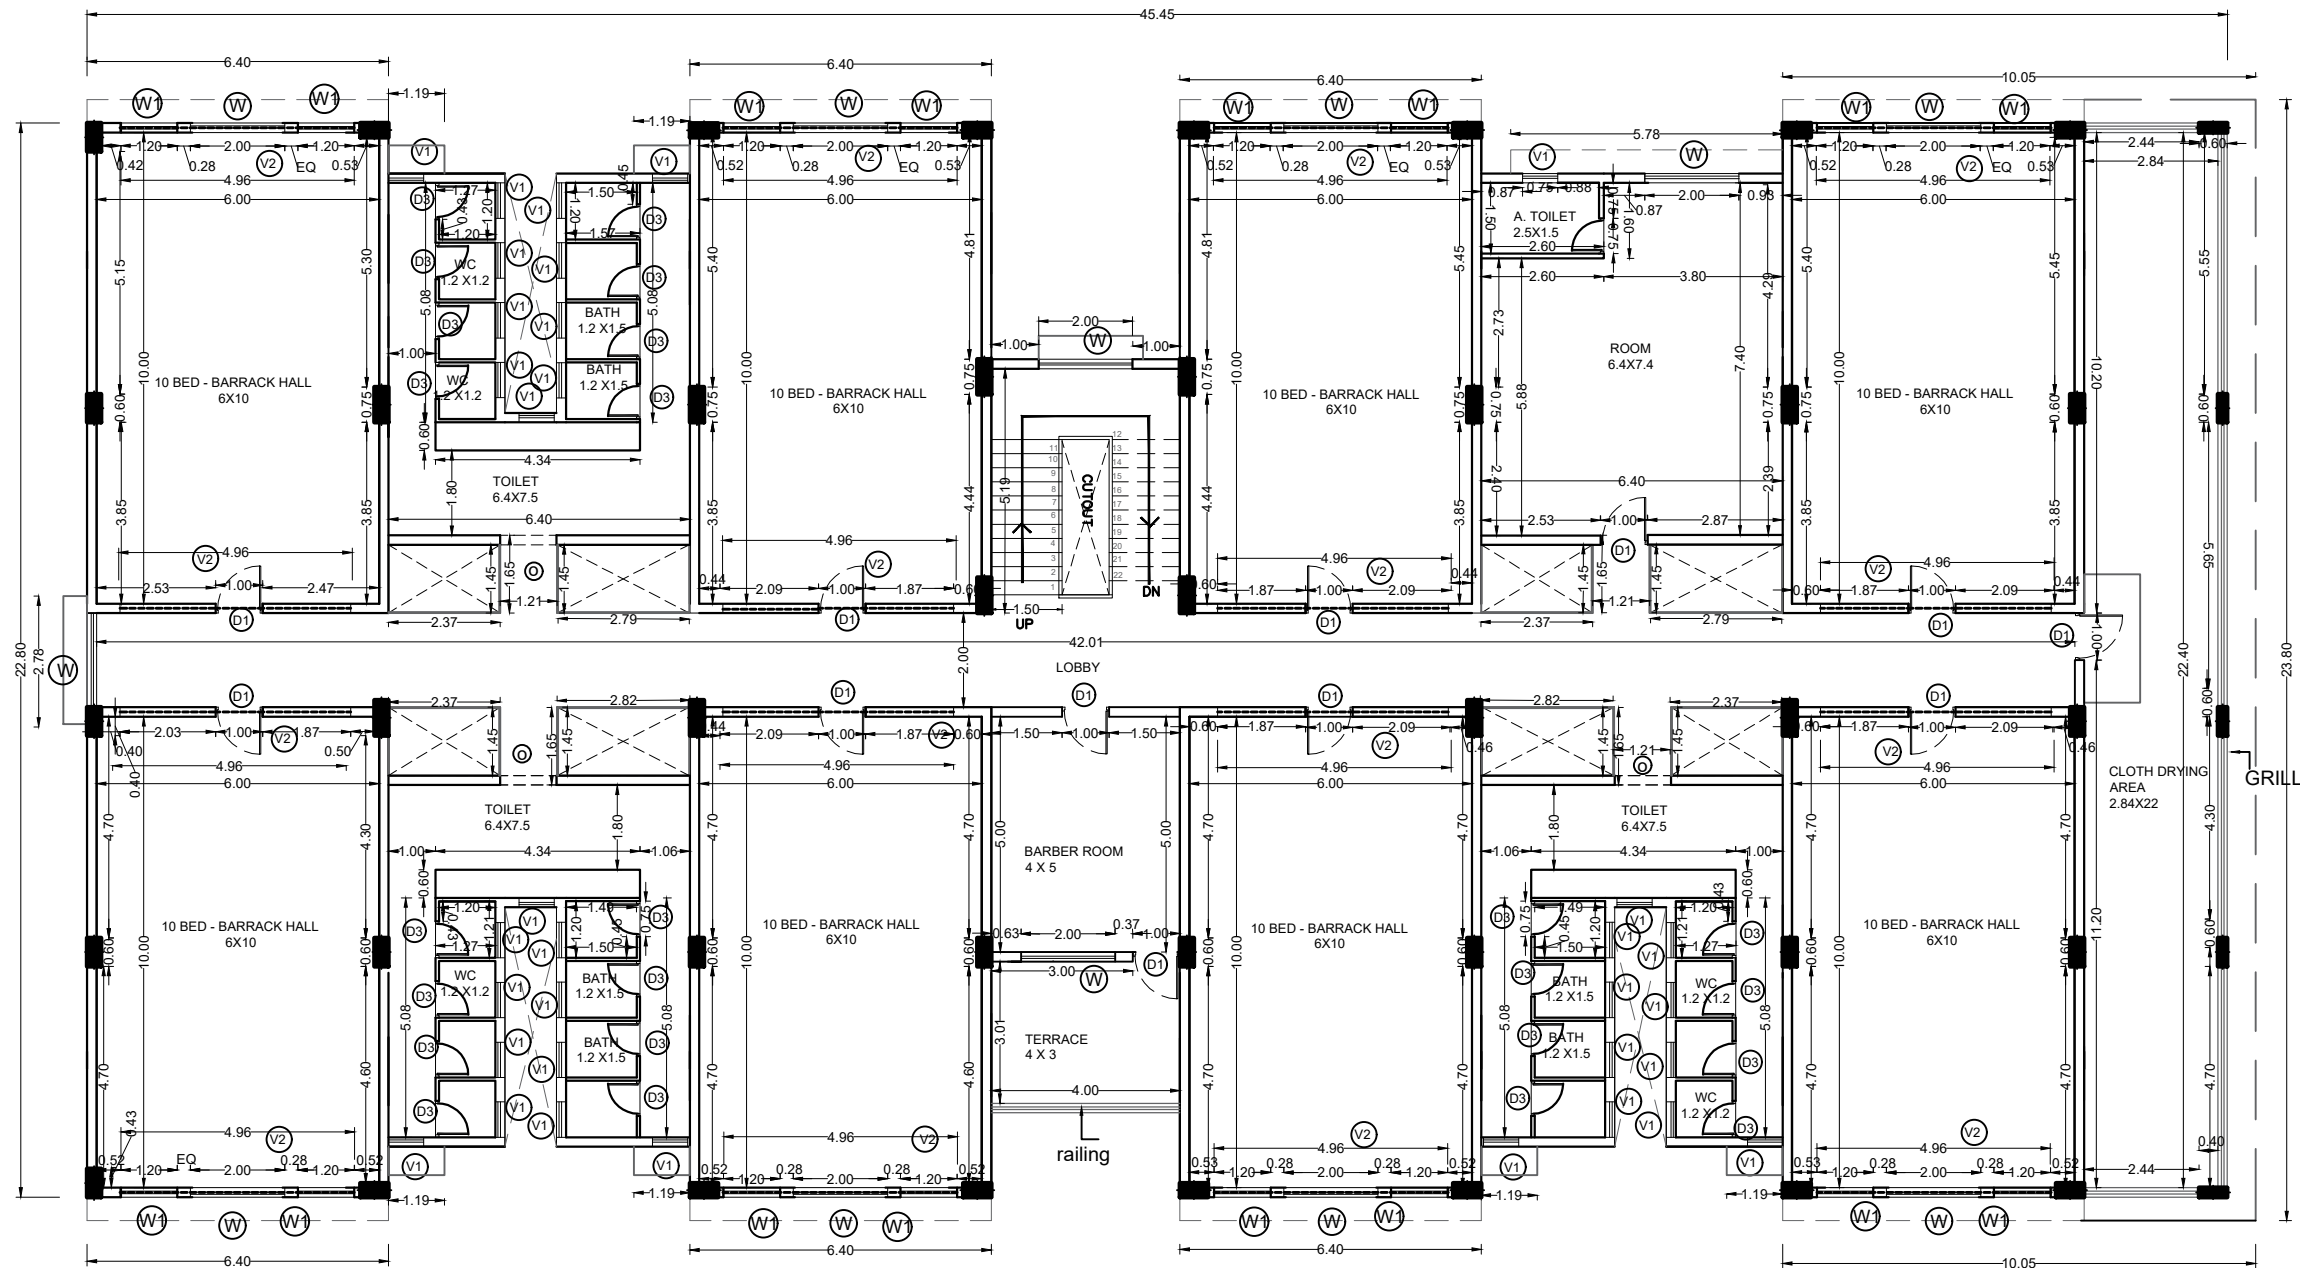

SECOND FLOOR PLAN

SCHEDULE OF OPENINGS		
DOORS		
	SIZE IN M	Nos
D1	1.00 X 2.10	12
D3	0.75 X 2.10	25
WINDOWS		
W	2.00 X 1.50	12
W1	1.20 X 1.50	16
VENTILATORS		
V1	0.75X 0.75	34
V2	4.96X0.5	16
OPENING		
O	1.2X2.1	3

NOTE : ALL Chajja projection is 0.6m deep

TOILET PROPORTION 1:7

LEGEND:
SECOND FLOOR BUILT UP - 935 SQM
LIST OF FACILITIES
1. COMMON LOBBY
2. BARBER ROOM
3. BARRACK ROOM - 8X10= 80 BEDS
4.ROOM + A. TOILET
5. WASHROOM - 3X5 TOILET+3X5 BATH
6. STAIRCASE
7. CLOTH DRYING AREA

NOTE : ALL DIMENSION IN METERS

PROJECT :
 PROVIDING COMPREHENSIVE PROJECT
 MANAGEMENT CONSULTANCY SERVICES FOR
 PROPOSED CONSTRUCTION OF CISF
 INFRASTRUCTURE BUILDINGS
 AT NOTE MUDRAN NAGAR MYSORE

TENDER DRAWING

BRBNMPL - BARRACK FLOOR PLAN
 WORKING DRAWING


Date :30-10-2025	Drawn by: AMRUTHA
	Checked by: Ar. Kavitha
Rev Date: -----	



ARCHITECTS :
KULKARNI ASSOCIATES
 Surya Prema Building, next to Adiga's Restaurant, Kanakapura Road
 No-203, 2nd floor, Above Canara bank Raghuvahalli Branch
 Raghuvahalli Village, Uttarahalli hobli Bangalore-560062
 Email Id : kulkarni.associates@yahoo.com

SCHEDULE OF OPENINGS		
DOORS		
	SIZE IN M	Nos
D1	1.00 X 2.10	11
D3	0.75 X 2.10	25
WINDOWS		
W	2.00 X 1.50	13
W1	1.20 X 1.50	14
W3	4.31 X 1.50	1
VENTILATORS		
V1	0.75X 0.75	34
V2	4.96X0.5	14
OPENING		
O	1.2X2.1	2

NOTE : ALL Chajja projection is 0.6m deep

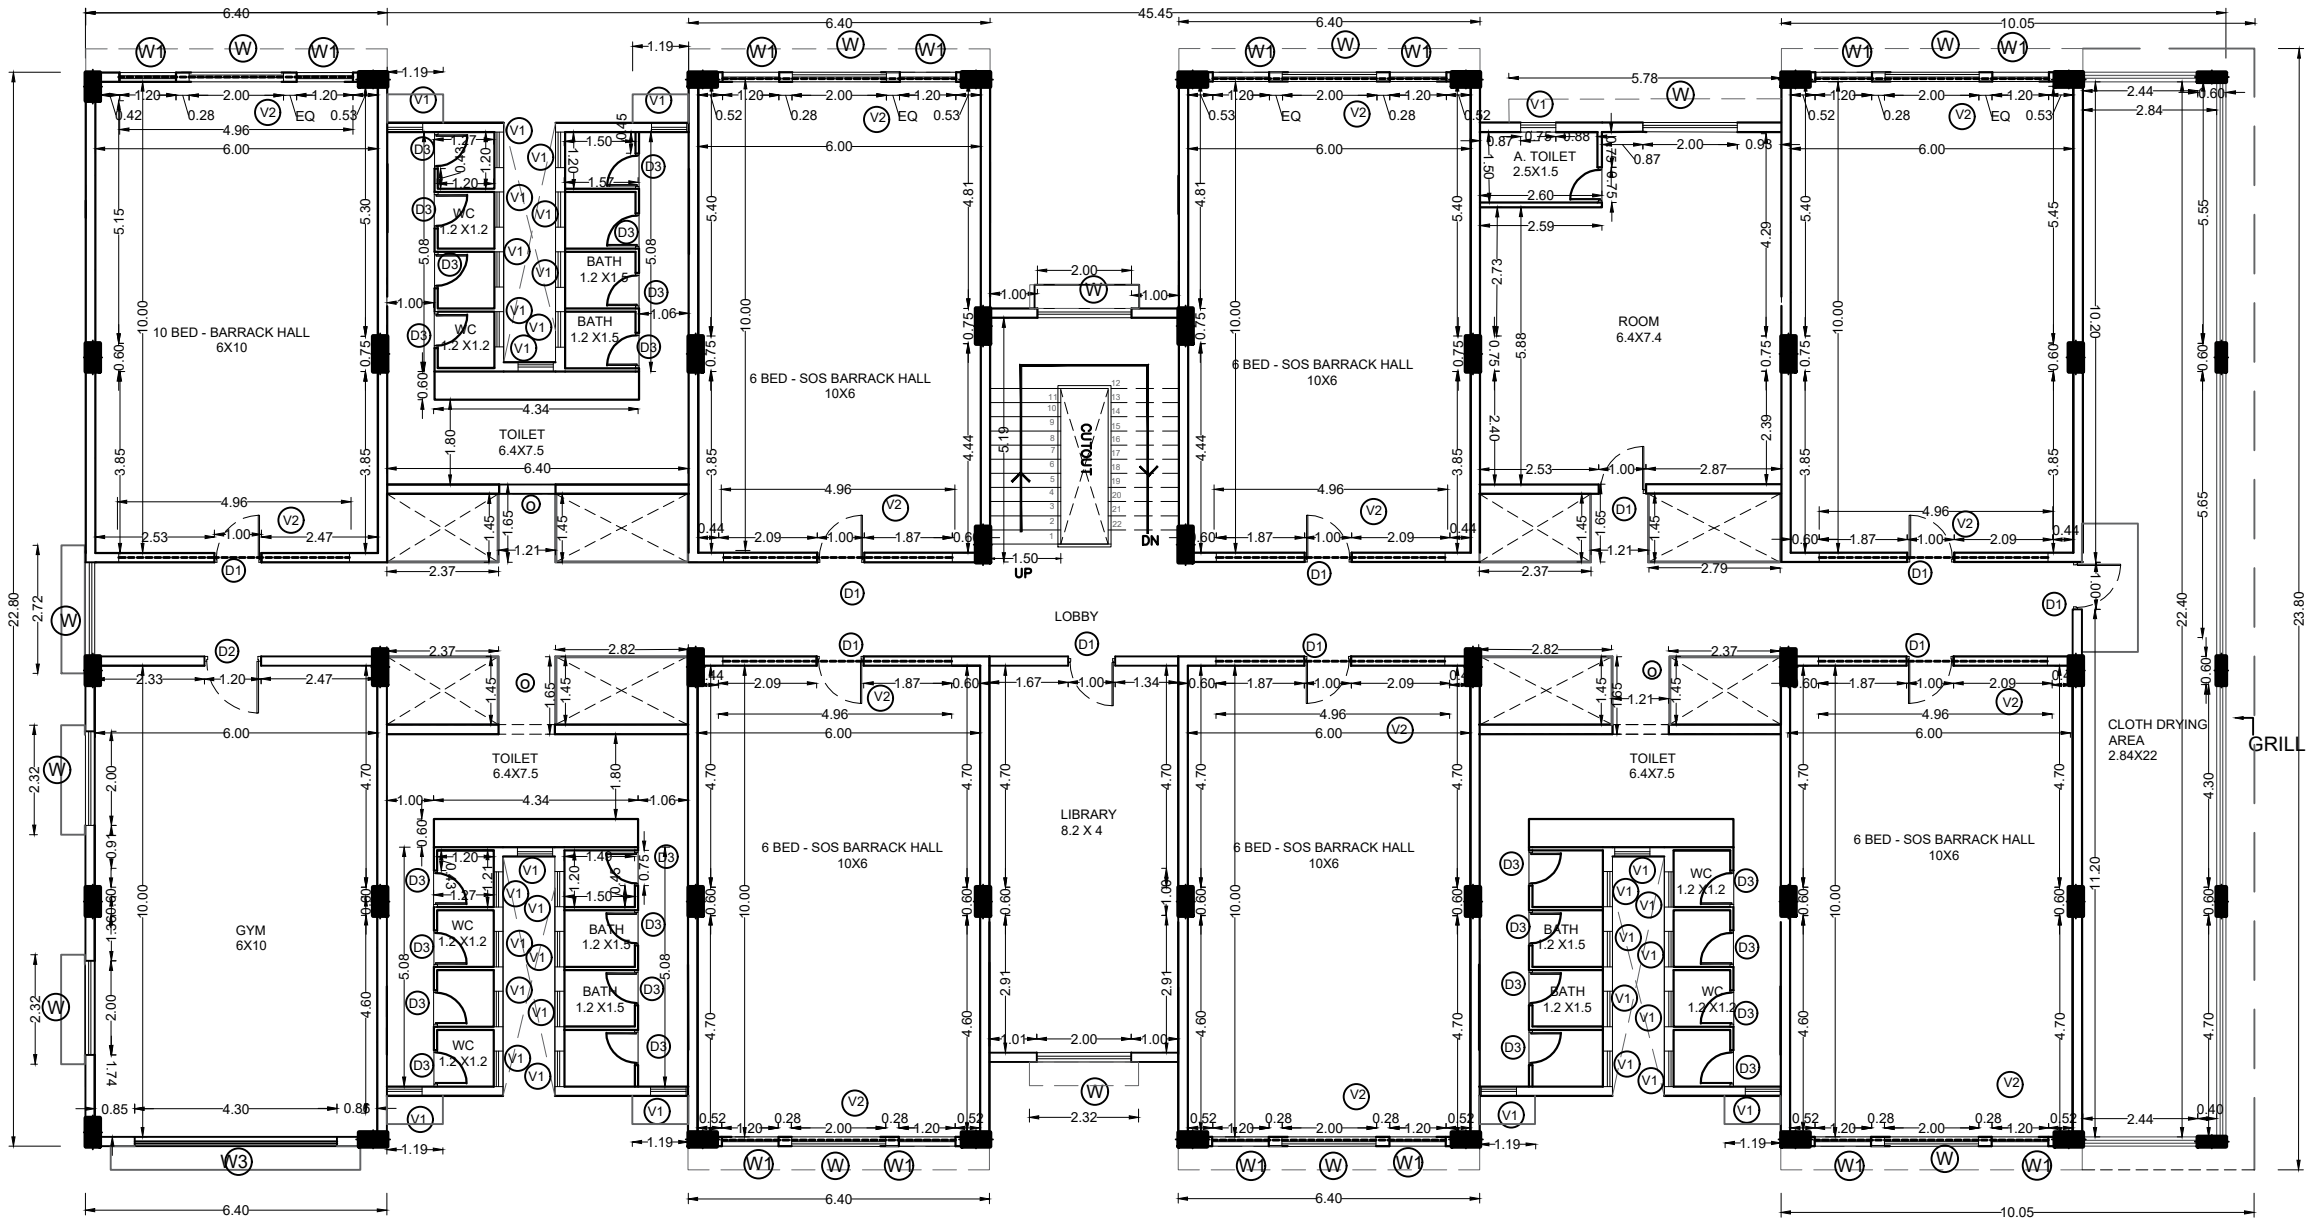

THIRD FLOOR PLAN

TOILET PROPORTION 1:4

LEGEND:
THIRD FLOOR BUILT UP - 935SQM
LIST OF FACILITIES
1. COMMON LOBBY
2. BARRACK ROOM - 6X6=36 BEDS
3. WASHROOM - 1X4 TOILET +1X4 BATH
4. ROOM + A. TOILET - 2
5. WASH AND DRYING AREA
6. LIBRARY
7. GYM
8. STAIRCASE
9. CLOTH DRYING AREA
10. BARRACK ROOM - 1X10=10 BEDS

NOTE : ALL DIMENSION IN METERS

PROJECT :
PROVIDING COMPREHENSIVE PROJECT
MANAGEMENT CONSULTANCY SERVICES FOR
PROPOSED CONSTRUCTION OF CISF
INFRASTRUCTURE BUILDINGS
AT NOTE MUDRAN NAGAR MYSORE

TENDER DRAWING

BRBNMPL - BARRACK FLOOR PLAN
WORKING DRAWING


Date :30-10-2025	Drawn by: AMRUTHA
	Checked by: Ar. Kavitha
Rev Date: -----	



ARCHITECTS :
KULKARNI ASSOCIATES

Surya Prema Building,next to Adiga's Restaurant,Kanakapura Road
No-203,2nd floor,Above Canara bank Raghuvahalli Branch
Raghuvanahalli Village,Uttarahalli hobli Bangalore-560062

Email Id : kulkarni.associates@yahoo.com

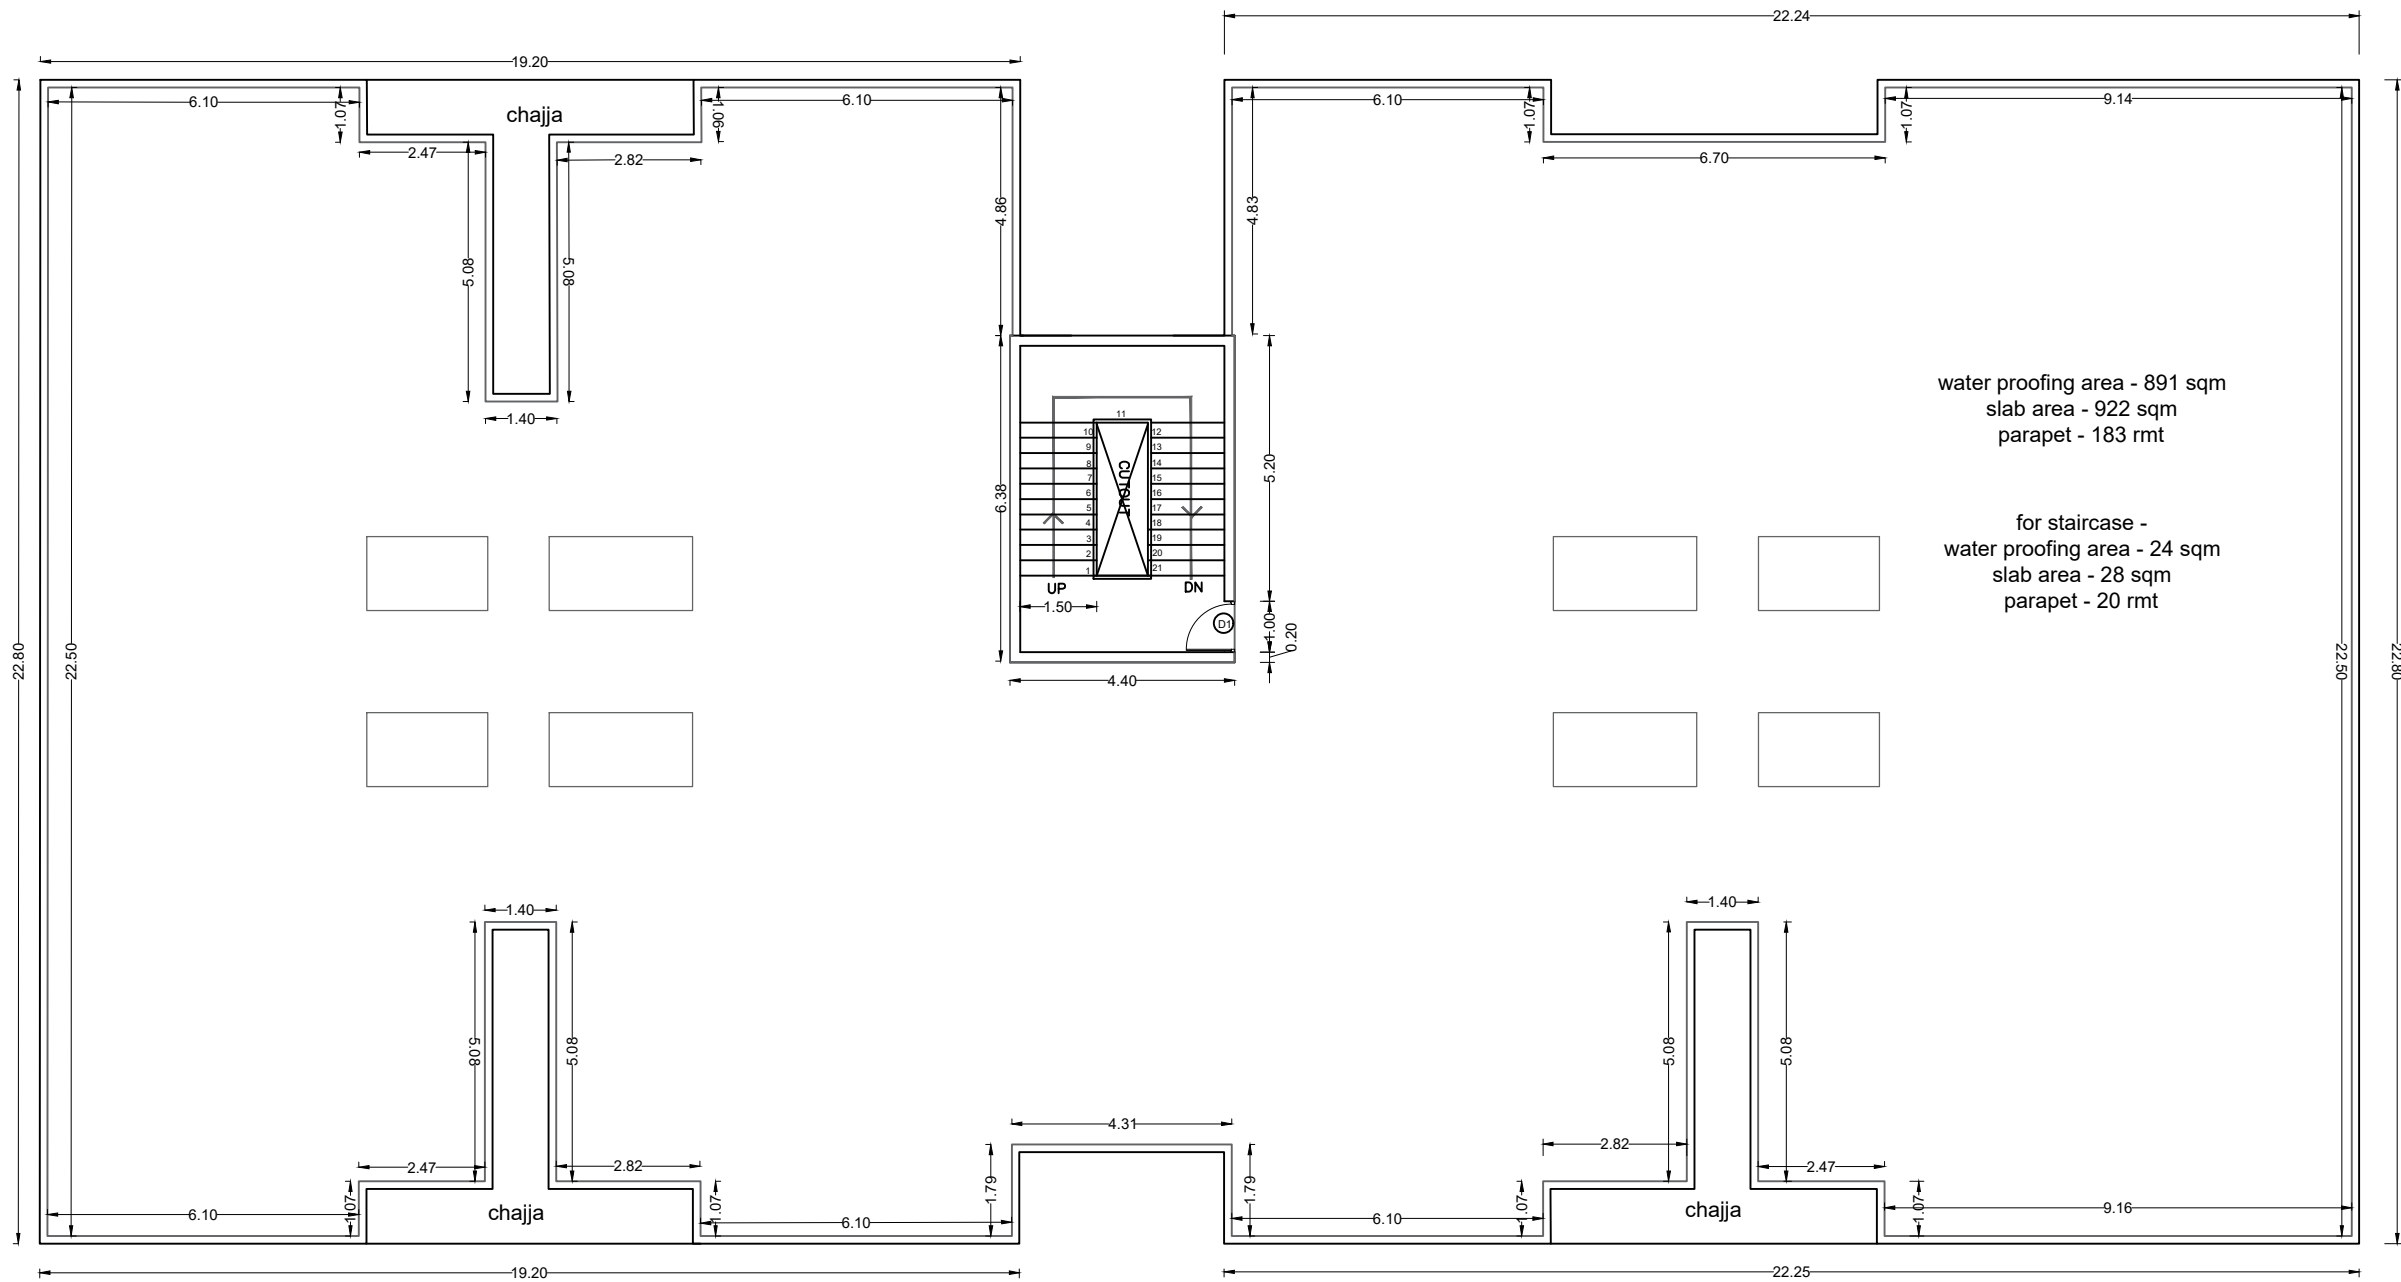

TERRACE FLOOR PLAN

SCHEDULE OF OPENINGS		
DOORS		
	SIZE IN M	Nos
D1	1.00 X 2.25	1
WINDOWS		
VENTILATORS		

water proofing area - 891 sqm
slab area - 922 sqm
parapet - 183 rmt

for staircase -
water proofing area - 24 sqm
slab area - 28 sqm
parapet - 20 rmt

NOTE : ALL DIMENSION IN METERS

PROJECT :
PROVIDING COMPREHENSIVE PROJECT
MANAGEMENT CONSULTANCY SERVICES FOR
PROPOSED CONSTRUCTION OF CISF
INFRASTRUCTURE BUILDINGS
AT NOTE MUDRAN NAGAR MYSORE

TENDER DRAWING

BRBNMPL - BARRACK FLOOR PLAN
WORKING DRAWING

Date :30-10-2025

Drawn by: AMRUTHA

Rev Date: -----


Checked by: Ar. Kavitha



ARCHITECTS :
KULKARNI ASSOCIATES

Surya Prema Building,next to Adiga's Restaurant,Kanakapura Road
No-203,2nd floor,Above Canara bank Raghuvahalli Branch
Raghuvanhalli Village,Uttarahalli hobli Bangalore-560062

Email Id : kulkarni.associates@yahoo.com

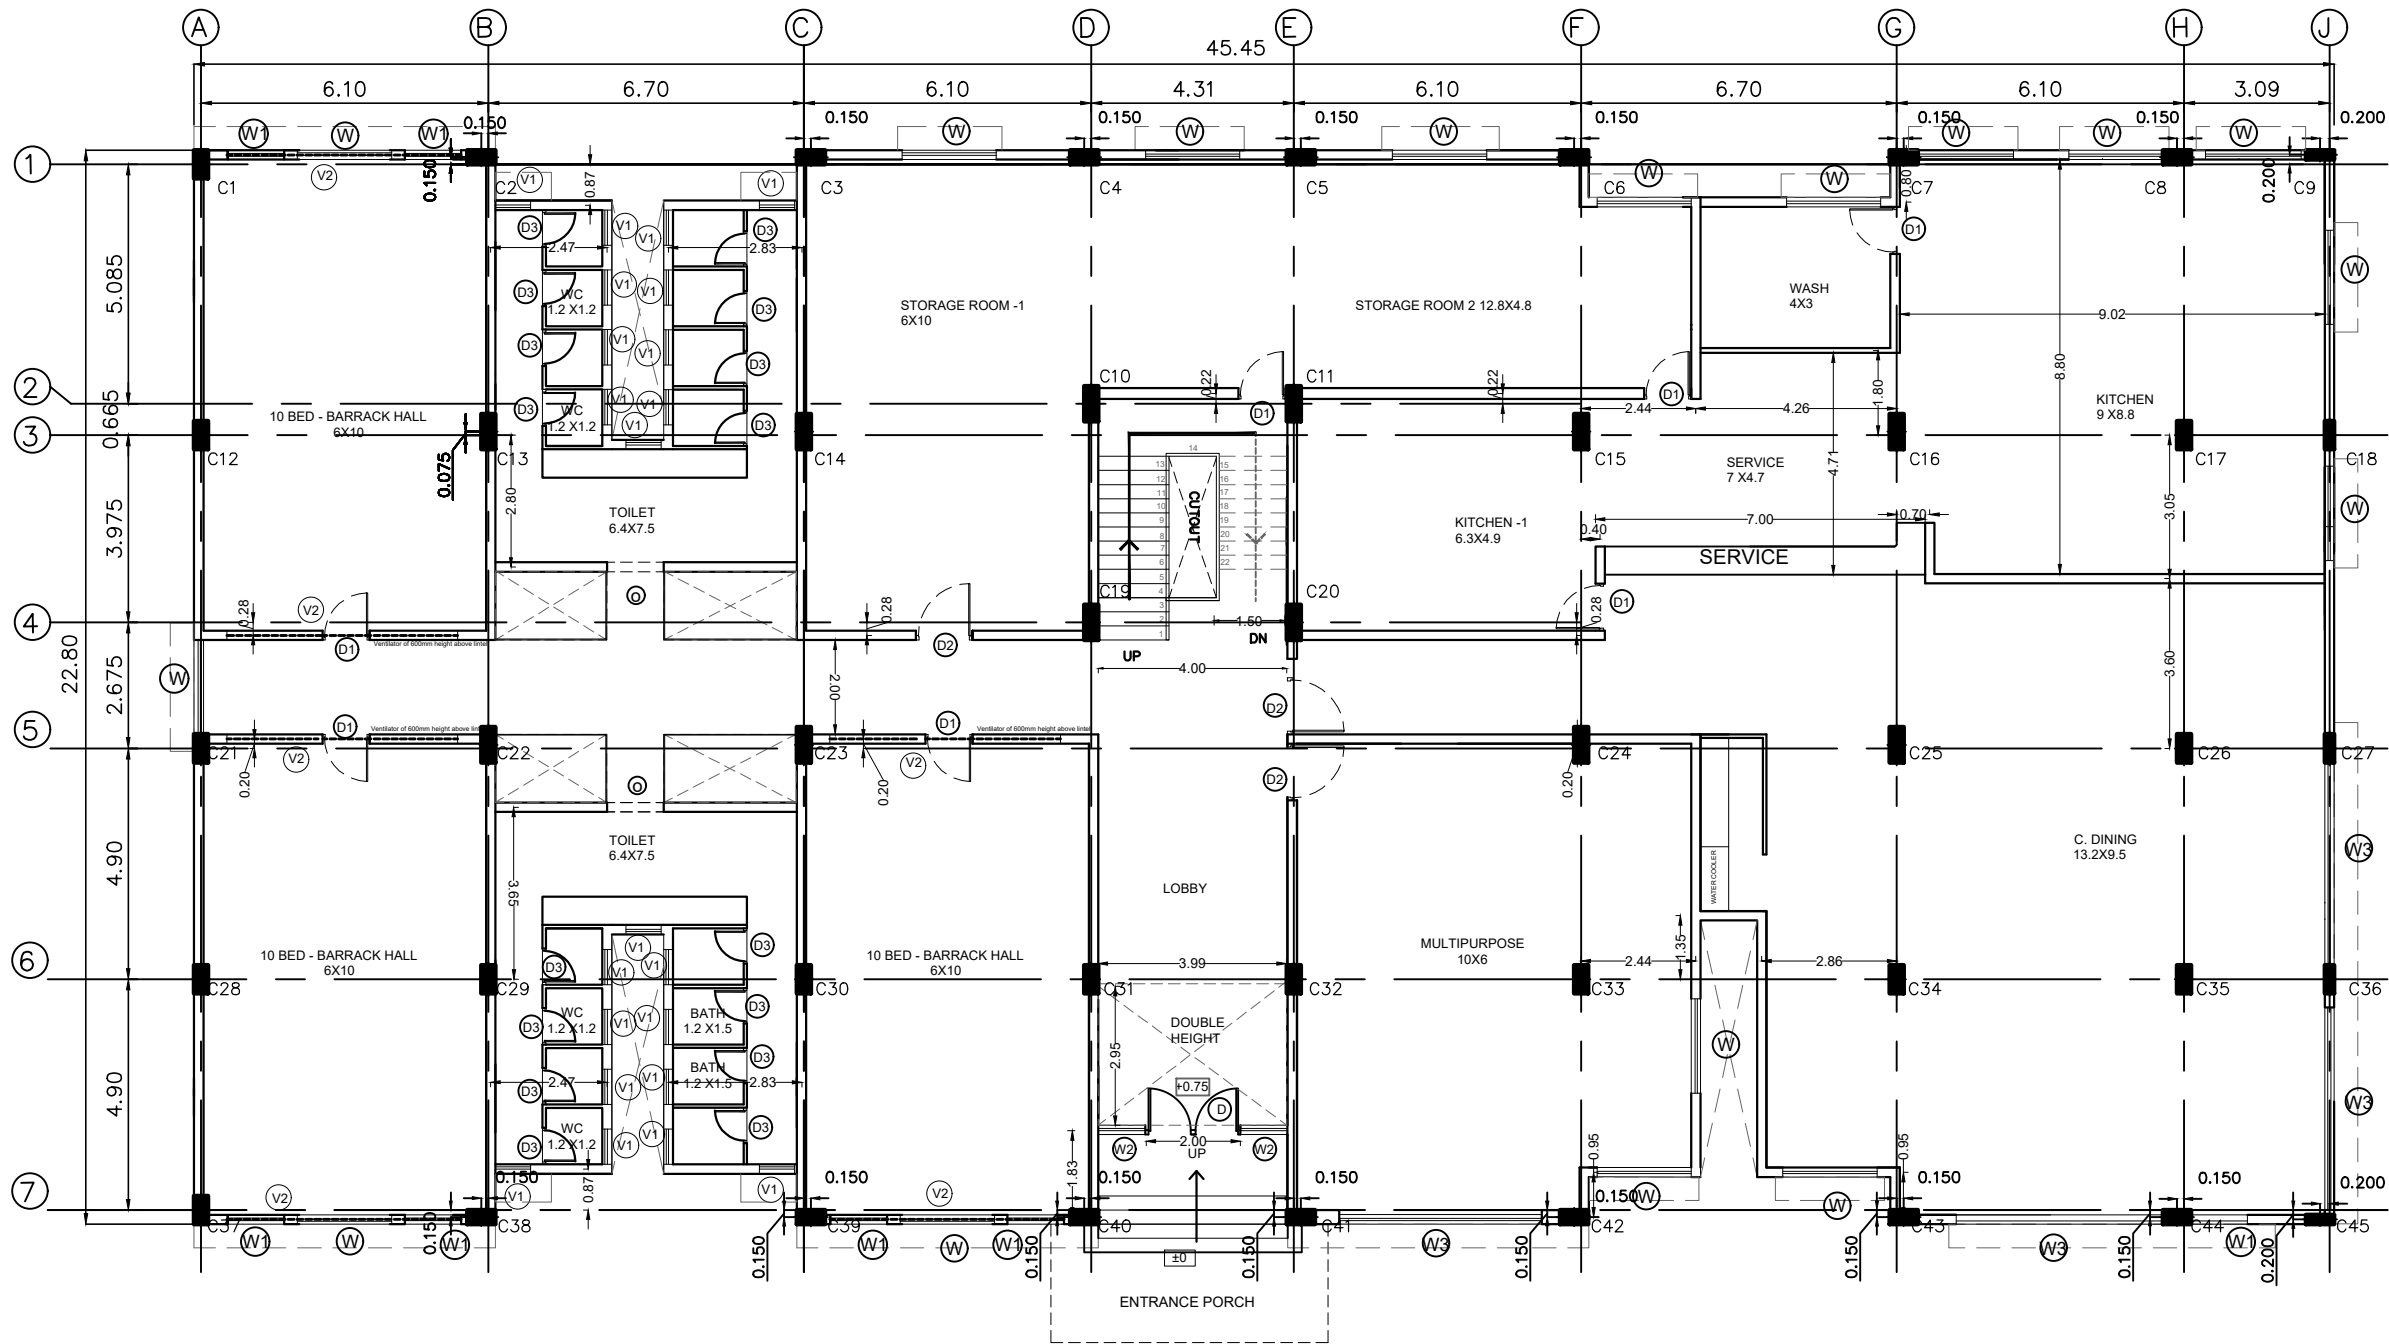

GROUND FLOOR PLAN

SCHEDULE OF OPENINGS		
DOORS		
	SIZE IN M	Nos
D	2.00 X 2.10	1
D1	1.00 X 2.10	7
D2	1.20 X 2.10	3
D3	0.75 X 2.10	16
WINDOWS		
W	2.00 X 1.50	14
W1	1.20 X 1.50	10
W2	1.00 X 1.79	2
W3	4.31 X 1.50	4
VENTILATORS		
V1	0.75X 0.75	22
V2	4.96X0.5	6
OPENING		
O	1.2X2.1	2

TOILET PROPORTION 1:4

LEGEND:

GROUND FLOOR BUILT UP - 977 SQM

LIST OF FACILITIES

1. ENTRANCE LOBBY

2. MULTIPURPOSE HALL - 50 SEATING

3. STORAGE ROOM

4. KITCHEN

5. WASH AREA

6. DINING AREA - 124 SEATING

7. BARRACK HALL - 3X10=30 BEDS

8. WASHROOM - 2X4 TOILET + 2X4 BATH

9. STAIRCASE

NOTE : ALL DIMENSION IN METERS

PROJECT :
PROVIDING COMPREHENSIVE PROJECT
MANAGEMENT CONSULTANCY SERVICES FOR
PROPOSED CONSTRUCTION OF CISF
INFRASTRUCTURE BUILDINGS
AT NOTE MUDRAN NAGAR MYSORE

TENDER DRAWING

BRBNMPL - BARRACK FLOOR PLAN
CENTER LINE PLAN

Date :30-10-2025

Drawn by: AMRUTHA

Rev Date: -----


Checked by: Ar. Kavitha



ARCHITECTS :
KULKARNI ASSOCIATES

Surya Prema Building,next to Adiga's Restaurant,Kanakapura Road
No-203,2nd floor,Above Canara bank Raghuvahalli Branch
Raghuvahalli Village,Uttarahalli hobli Bangalore-560062

Email Id : kulkarni.associates@yahoo.com

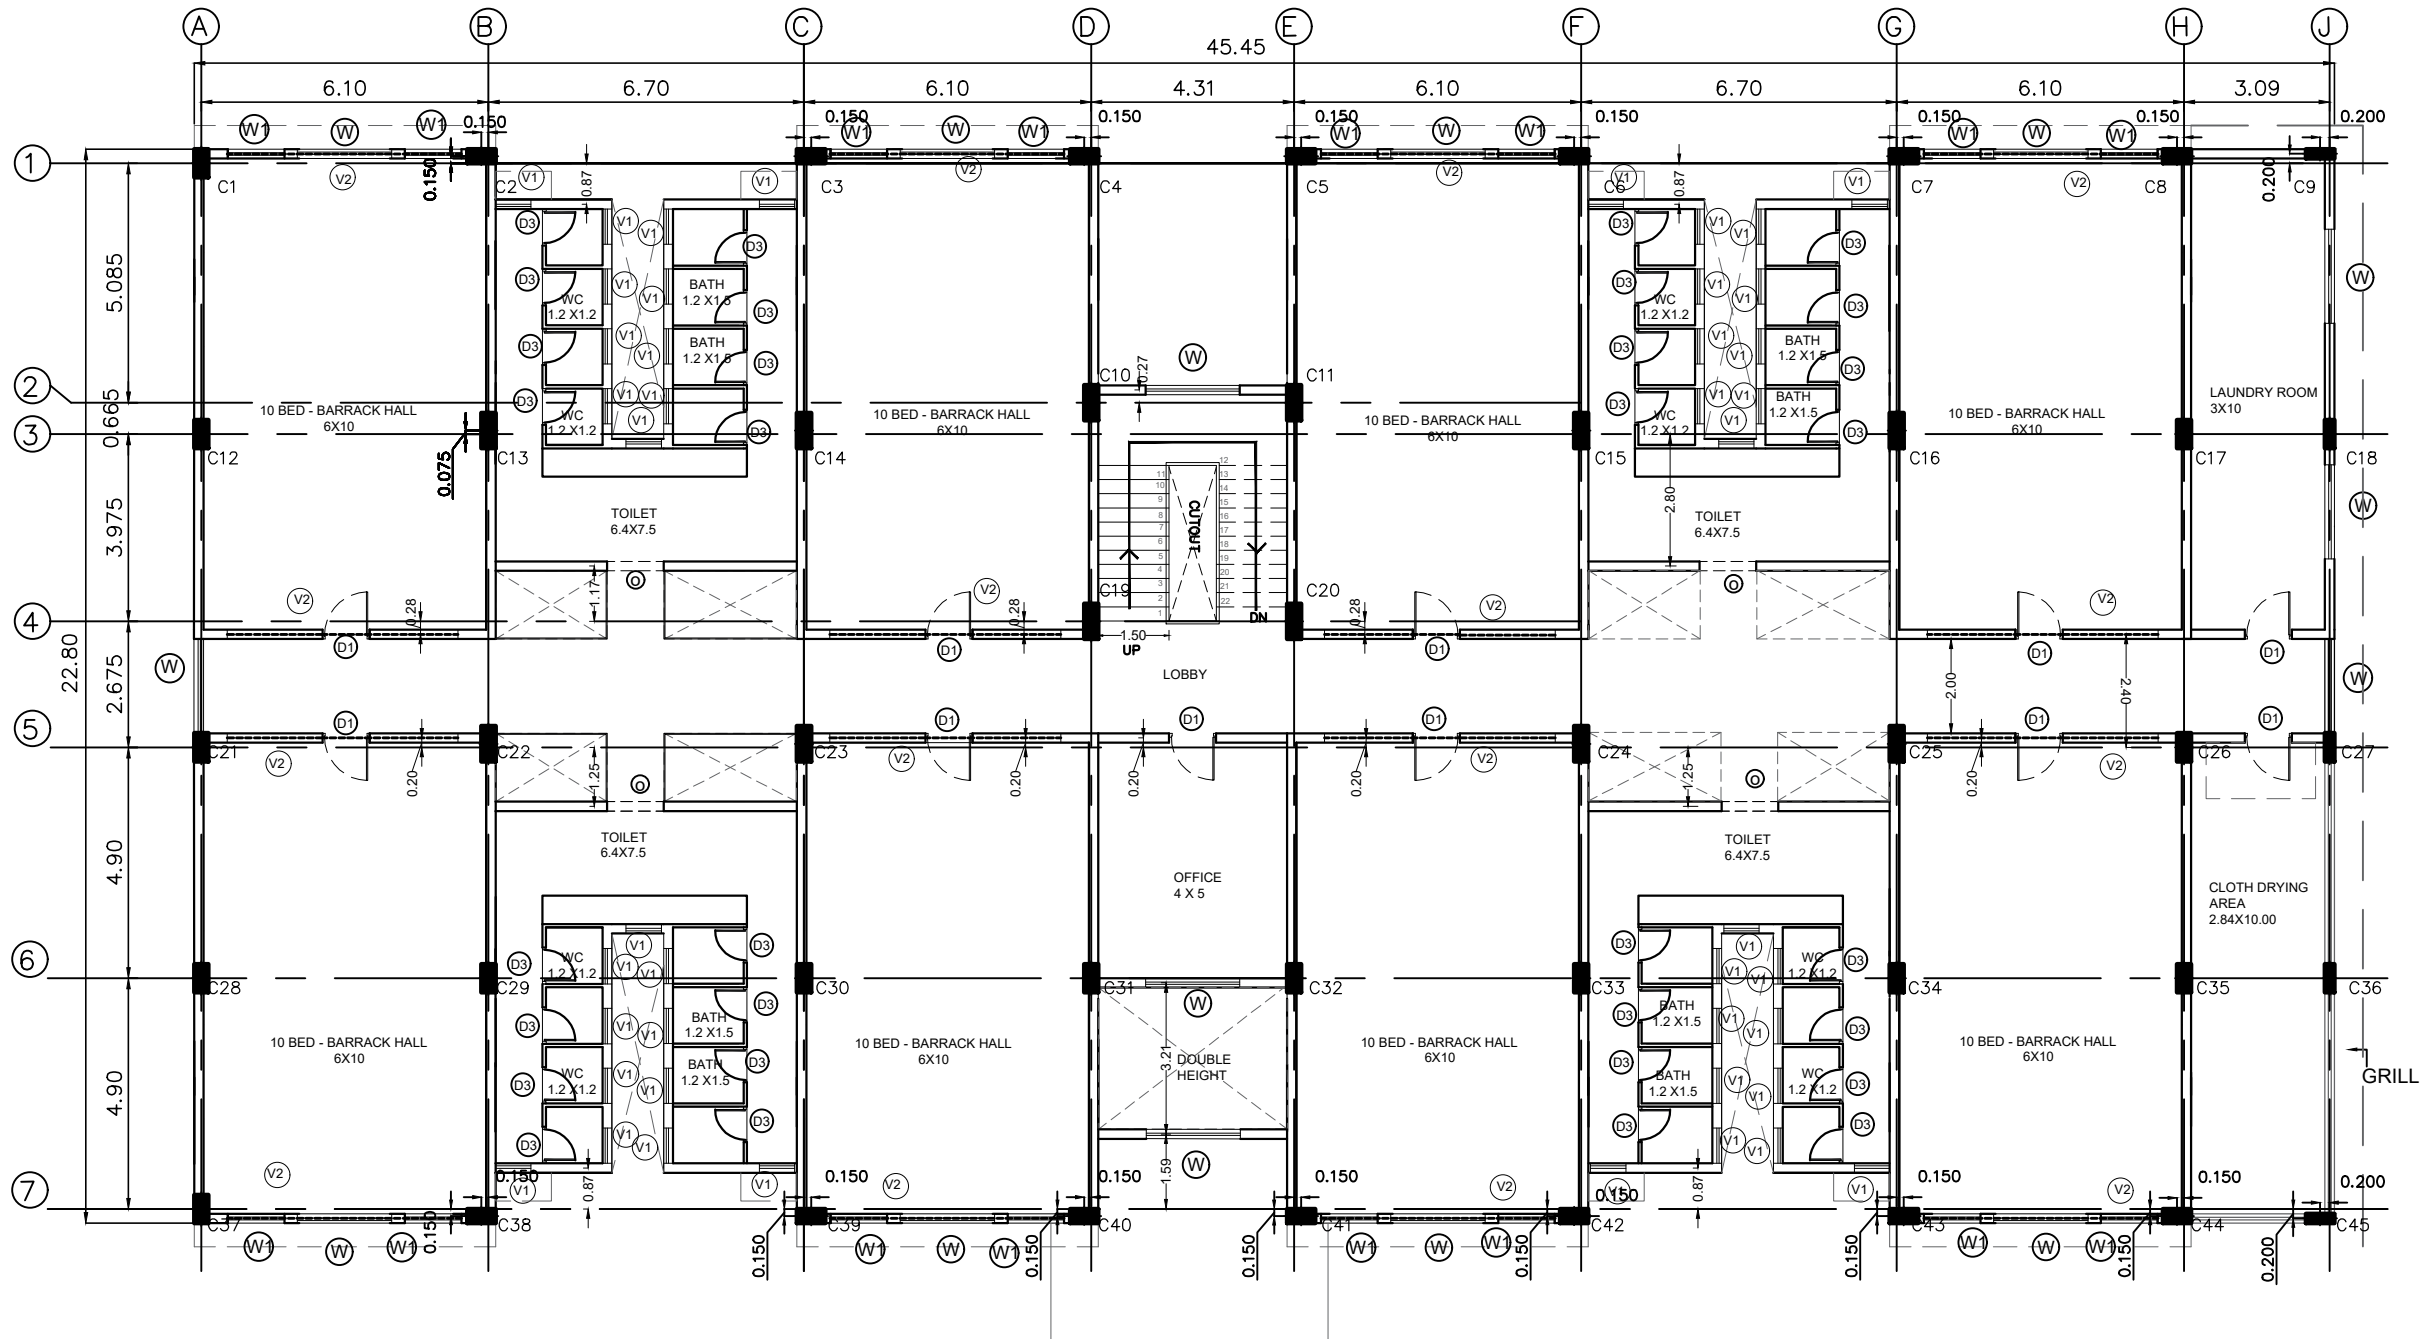

FIRST FLOOR PLAN

SCHEDULE OF OPENINGS		
DOORS		
	SIZE IN M	Nos
D1	1.00 X 2.10	11
D3	0.75 X 2.10	32
WINDOWS		
W	2.00 X 1.50	15
W1	1.20 X 1.50	16
VENTILATORS		
V1	0.75X 0.75	44
V2	4.96X0.5	16
OPENING		
O	1.2X2.1	4

TOILET PROPORTION 1:5

LEGEND:

FIRST FLOOR BUILT UP - 944SQM

LIST OF FACILITIES

1. COMMON LOBBY
2. OFFICE
3. BARRACK HALL - 8X10= 80 BEDS
4. WASHROOM - 4X4 TOILET + 4X4BATH
5. STAIRCASE
6. CLOTH DRYING AREA
7. LAUNDRY

NOTE : ALL DIMENSION IN METERS

PROJECT :
PROVIDING COMPREHENSIVE PROJECT
MANAGEMENT CONSULTANCY SERVICES FOR
PROPOSED CONSTRUCTION OF CISF
INFRASTRUCTURE BUILDINGS
AT NOTE MUDRAN NAGAR MYSORE

TENDER DRAWING

BRBNMPL - BARRACK FLOOR PLAN
CENTER LINE PLAN


Date :30-10-2025	Drawn by: AMRUTHA
Rev Date: -----	Checked by: Ar. Kavitha



ARCHITECTS :
KULKARNI ASSOCIATES

Surya Prema Building,next to Adiga's Restaurant,Kanakapura Road
No-203,2nd floor,Above Canara bank Raghuvahalli Branch
Raghuvanahalli Village,Uttarahalli hobli Bangalore-560062

Email Id : kulkarni.associates@yahoo.com

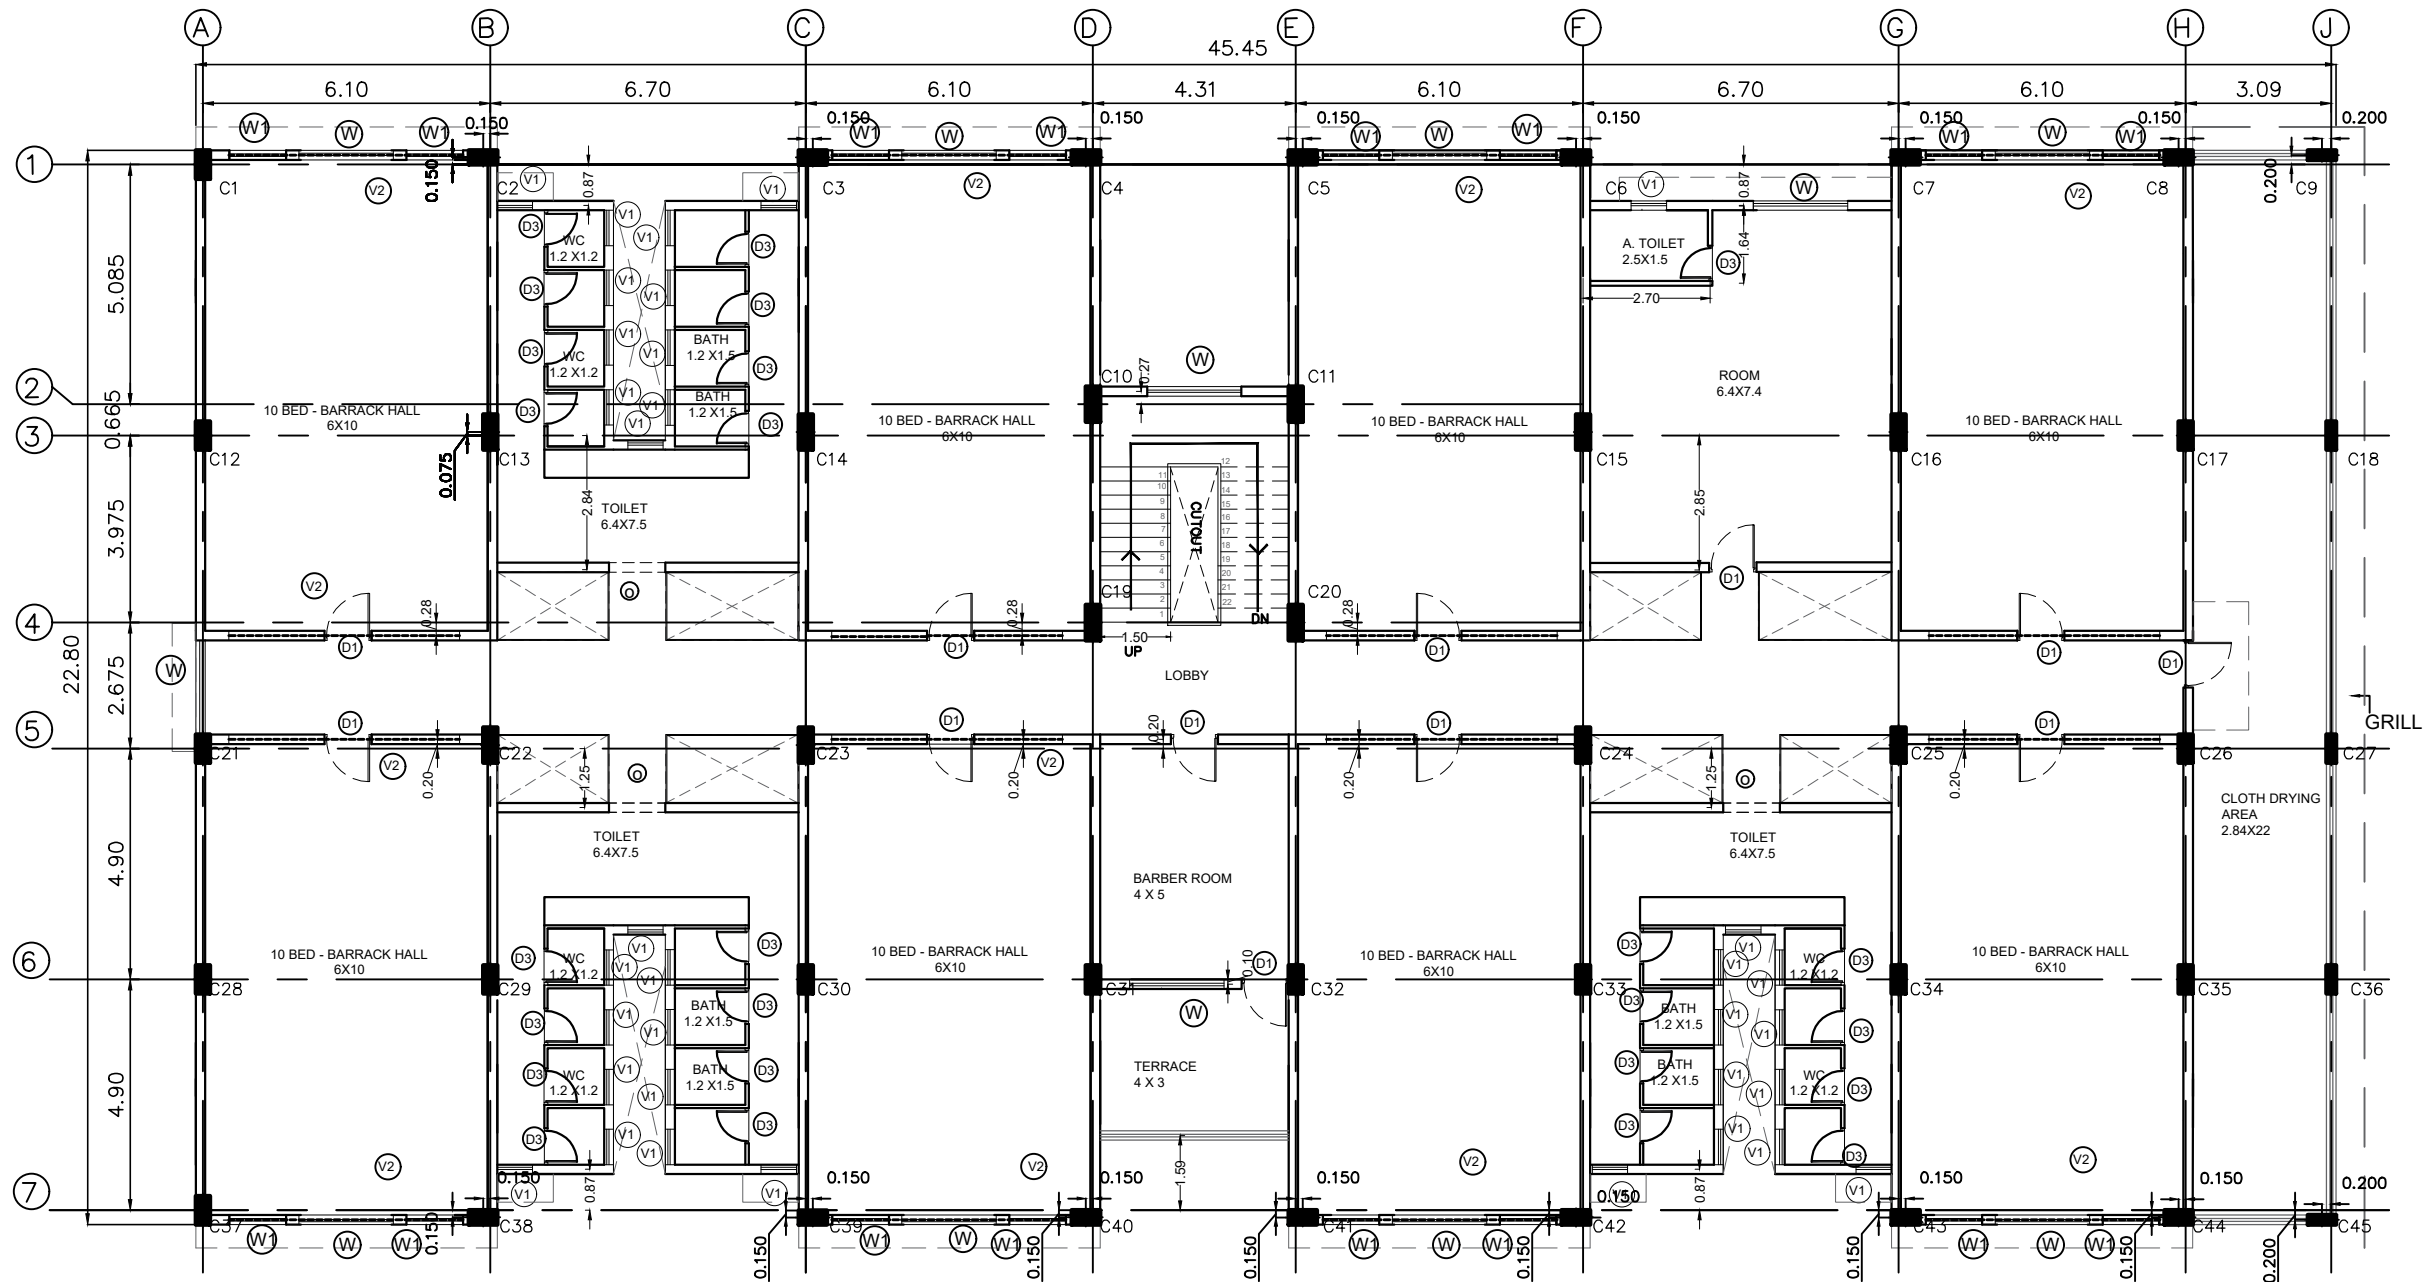

SECOND FLOOR PLAN

SCHEDULE OF OPENINGS		
DOORS		
	SIZE IN M	Nos
D1	1.00 X 2.10	12
D3	0.75 X 2.10	25
WINDOWS		
W	2.00 X 1.50	12
W1	1.20 X 1.50	16
	1.60 X 1.50	
VENTILATORS		
V1	0.75X 0.75	34
V2	4.96X0.5	16
OPENING		
O	1.2X2.1	3

TOILET PROPORTION 1:7

LEGEND:
SECOND FLOOR BUILT UP - 935 SQM
LIST OF FACILITIES
1. COMMON LOBBY
2. BARBER ROOM
3. BARRACK ROOM - 8X10= 80 BEDS
4.ROOM + A. TOILET
5. WASHROOM - 3X5 TOILET+3X5 BATH
6. STAIRCASE
7. CLOTH DRYING AREA

NOTE : ALL DIMENSION IN METERS

PROJECT :
PROVIDING COMPREHENSIVE PROJECT
MANAGEMENT CONSULTANCY SERVICES FOR
PROPOSED CONSTRUCTION OF CISF
INFRASTRUCTURE BUILDINGS
AT NOTE MUDRAN NAGAR MYSORE


TENDER DRAWING

BRBNMPL - BARRACK FLOOR PLAN CENTER LINE PLAN	
Date :30-10-2025	Drawn by: AMRUTHA
	Checked by: Ar. Kavitha
Rev Date: -----	



ARCHITECTS :
KULKARNI ASSOCIATES
Surya Prema Building,next to Adiga's Restaurant,Kanakapura Road
No-203,2nd floor,Above Canara bank Raghuvahalli Branch
Raghuvahalli Village,Uttarahalli hobli Bangalore-560062
Email Id : kulkarni.associates@yahoo.com

SCHEDULE OF OPENINGS		
DOORS		
	SIZE IN M	Nos
D1	1.00 X 2.10	11
D3	0.75 X 2.10	25
WINDOWS		
W	2.00 X 1.50	13
W1	1.20 X 1.50	14
W3	4.31 X 1.50	1
VENTILATORS		
V1	0.75X 0.75	34
V2	4.96X0.5	14
OPENING		
O	1.2X2.1	2

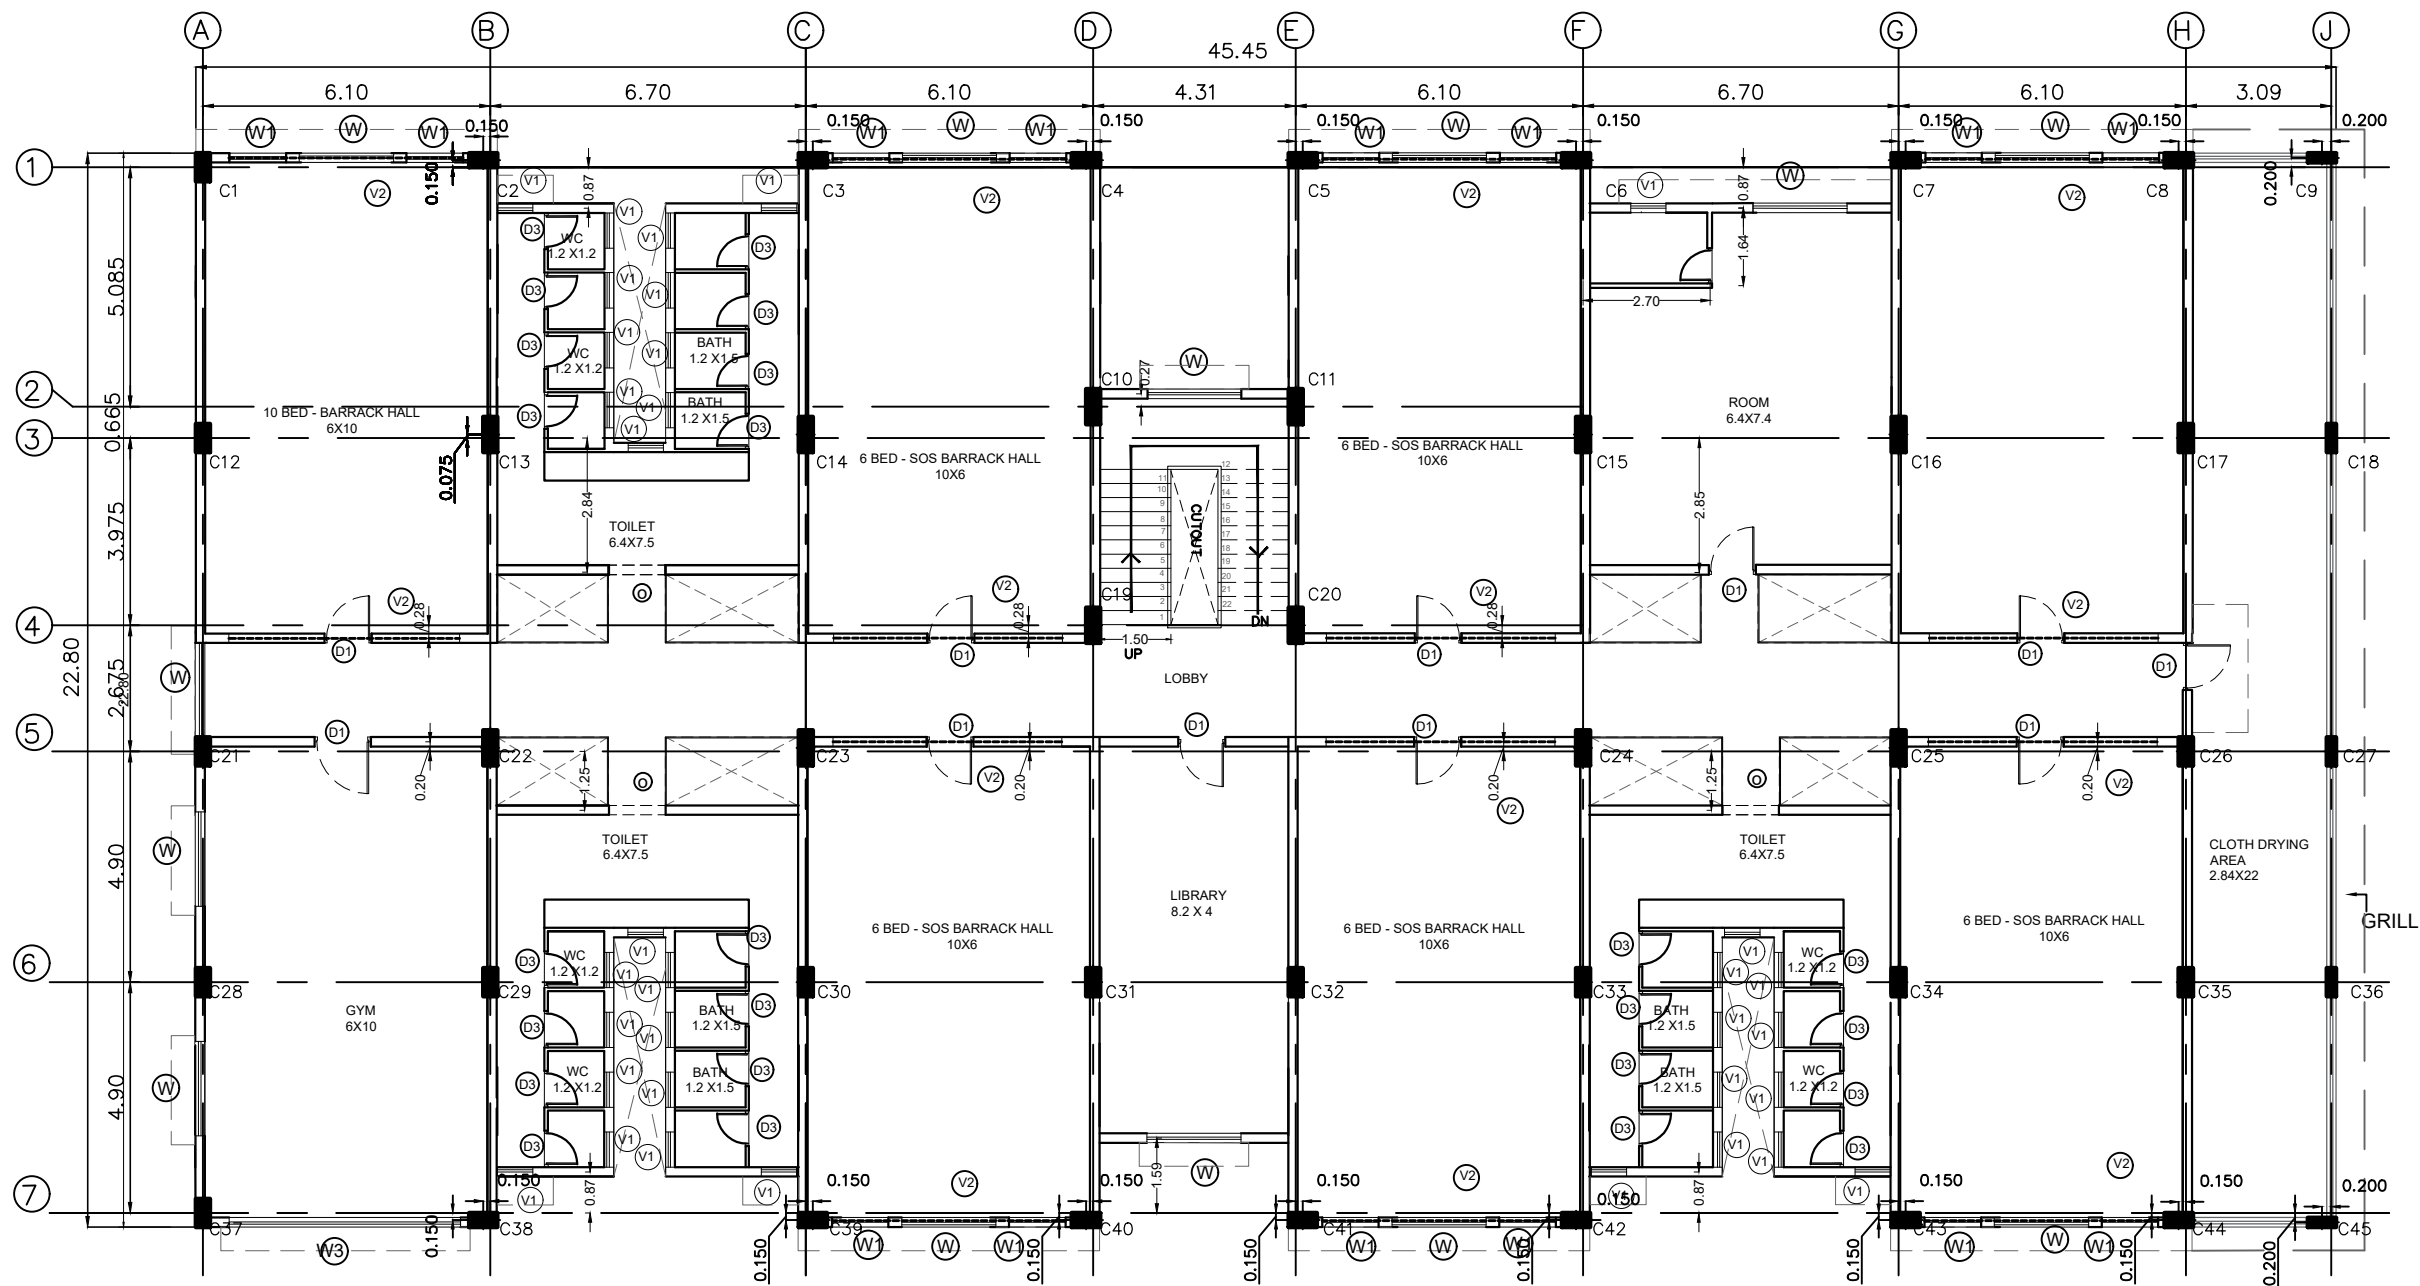

THIRD FLOOR PLAN

TOILET PROPORTION 1:4

LEGEND:

THIRD FLOOR BUILT UP - 935SQM

LIST OF FACILITIES

1. COMMON LOBBY
2. BARRACK ROOM - 6X6=36 BEDS
3. WASHROOM - 1X4 TOILET +1X4 BATH
4. ROOM + A. TOILET - 2
5. WASH AND DRYING AREA
6. LIBRARY
7. GYM
8. STAIRCASE
9. CLOTH DRYING AREA
10. BARRACK ROOM - 1X10=10 BEDS

NOTE : ALL DIMENSION IN METERS

PROJECT :
PROVIDING COMPREHENSIVE PROJECT
MANAGEMENT CONSULTANCY SERVICES FOR
PROPOSED CONSTRUCTION OF CISF
INFRASTRUCTURE BUILDINGS
AT NOTE MUDRAN NAGAR MYSORE

TENDER DRAWING

BRBNMPL - BARRACK FLOOR PLAN
CENTER LINE PLAN

Date :30-10-2025

Drawn by: AMRUTHA

Checked by: Ar. Kavitha


Rev Date: -----




ARCHITECTS :
KULKARNI ASSOCIATES

Surya Prema Building,next to Adiga's Restaurant,Kanakapura Road
No-203,2nd floor,Above Canara bank Raghuvahalli Branch
Raghuvanahalli Village,Uttarahalli hobli Bangalore-560062

Email Id : kulkarni.associates@yahoo.com

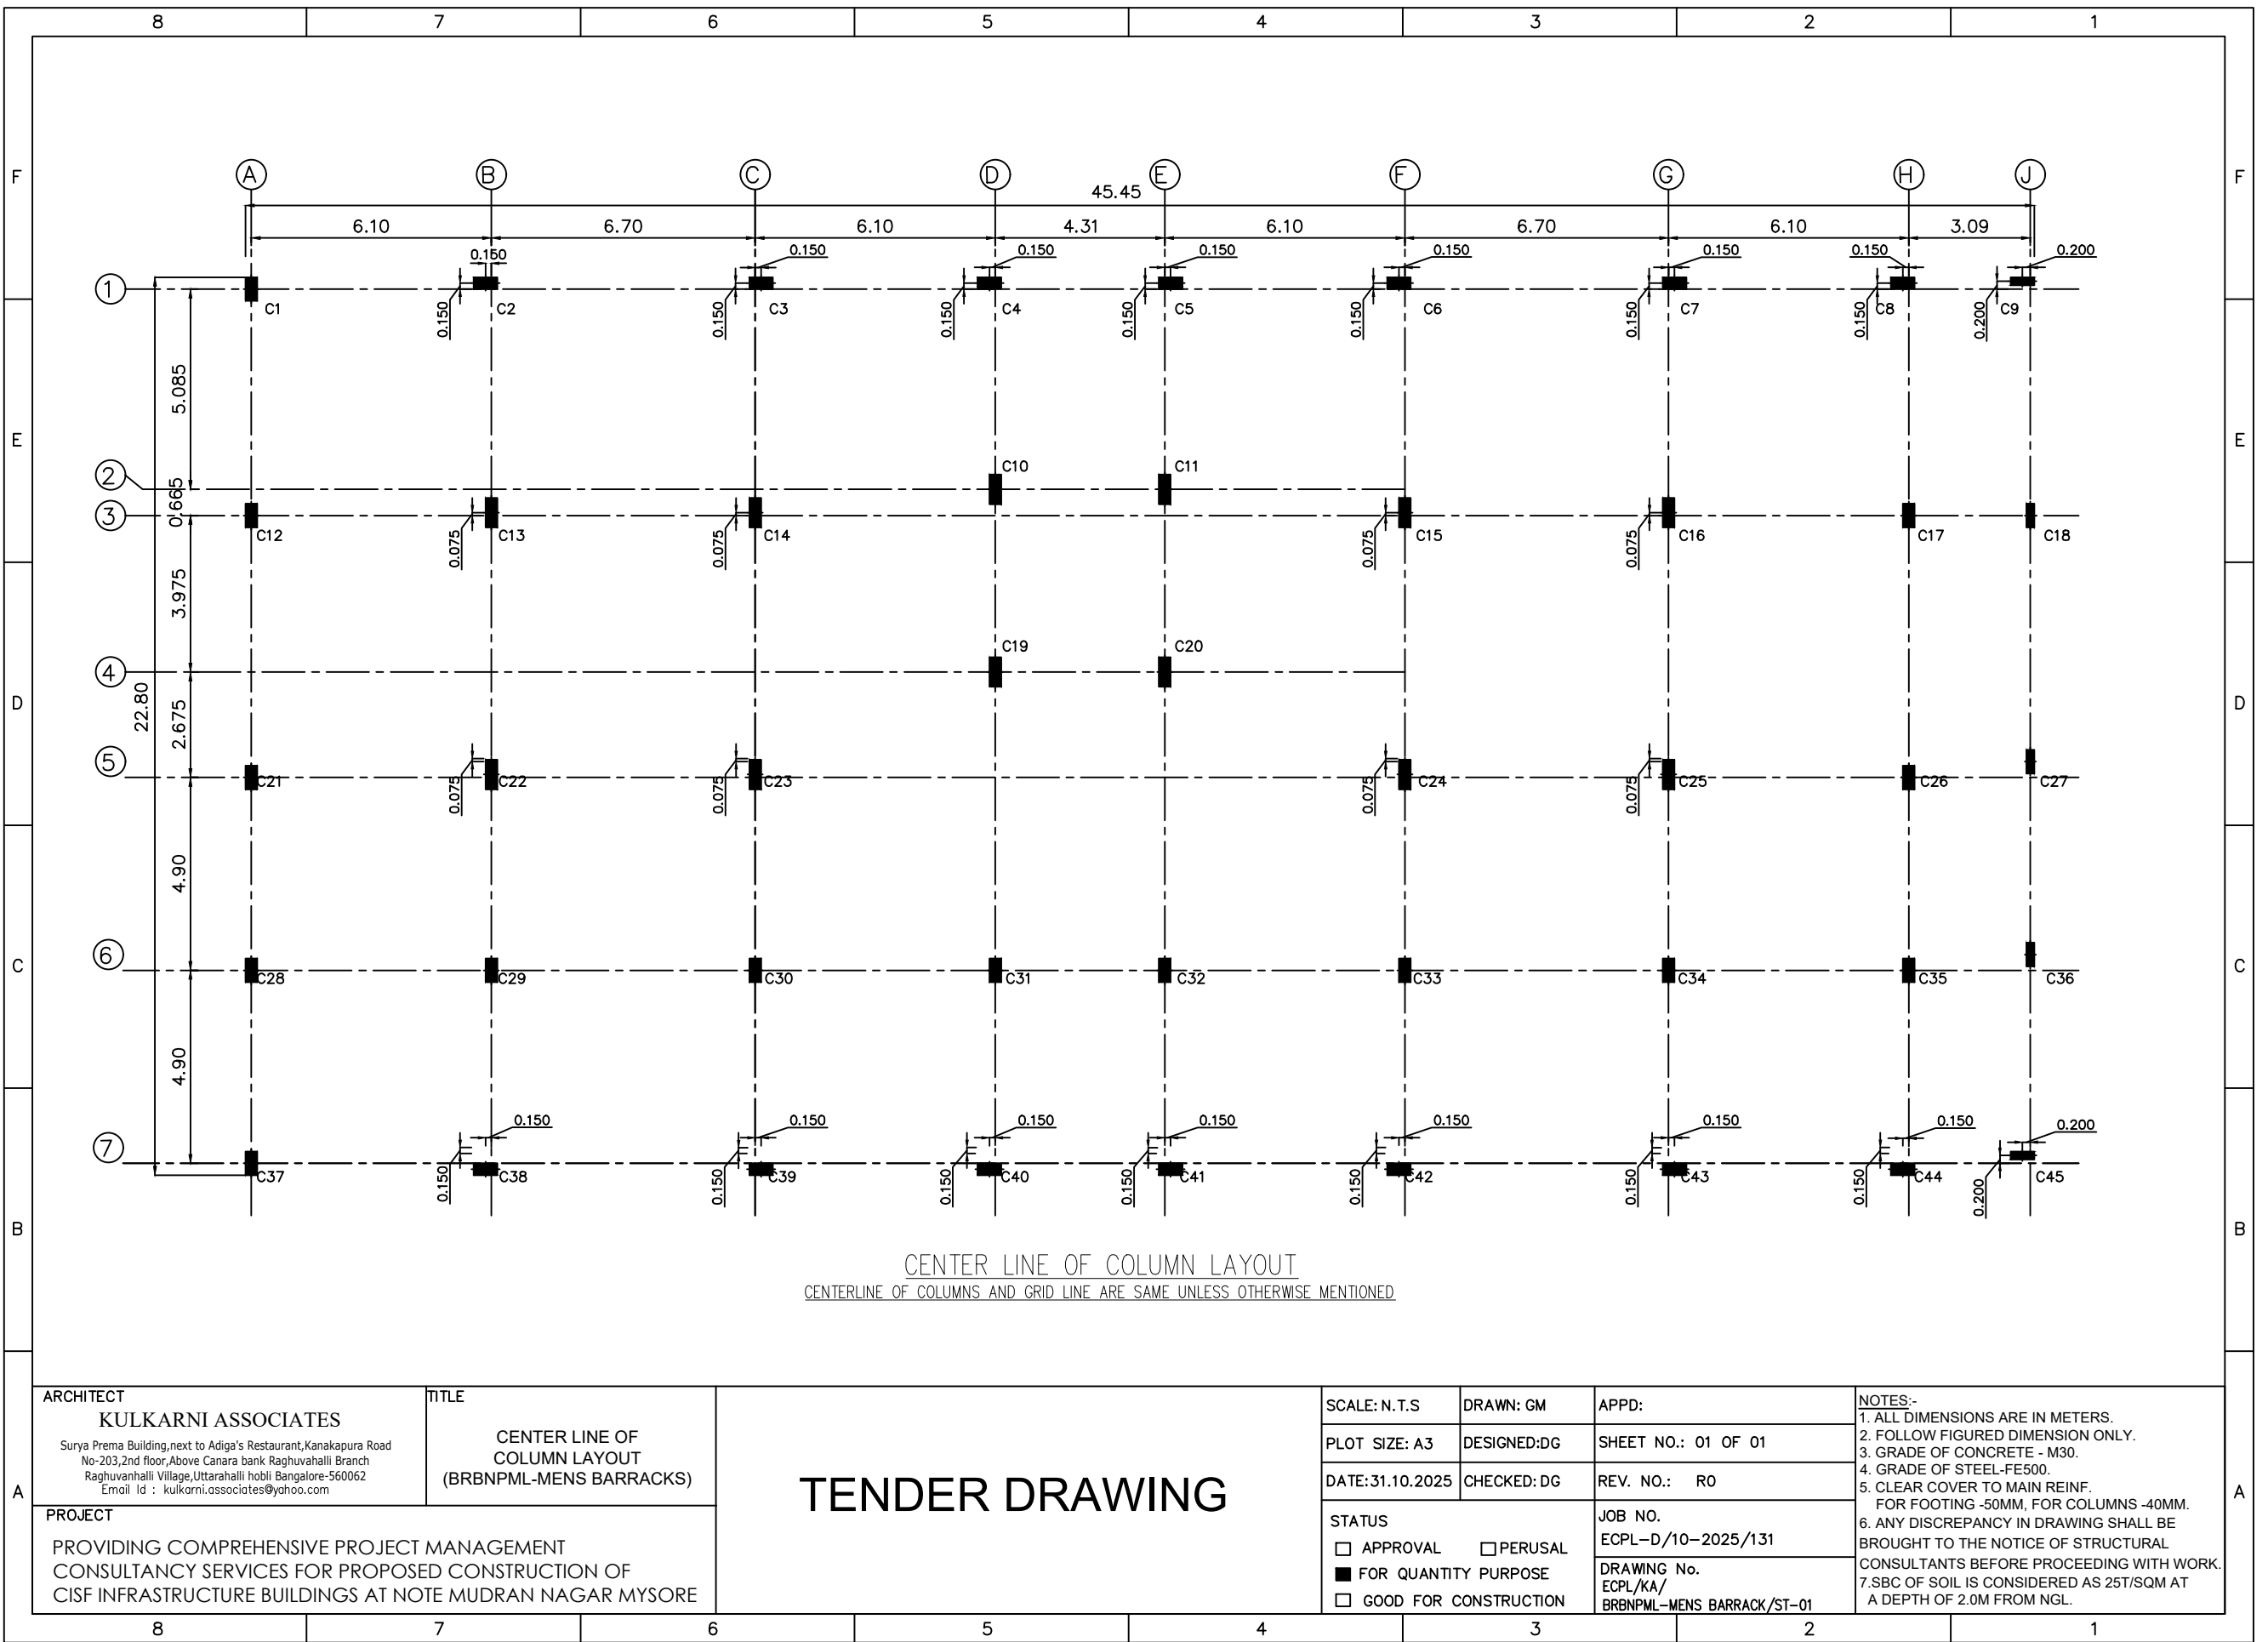

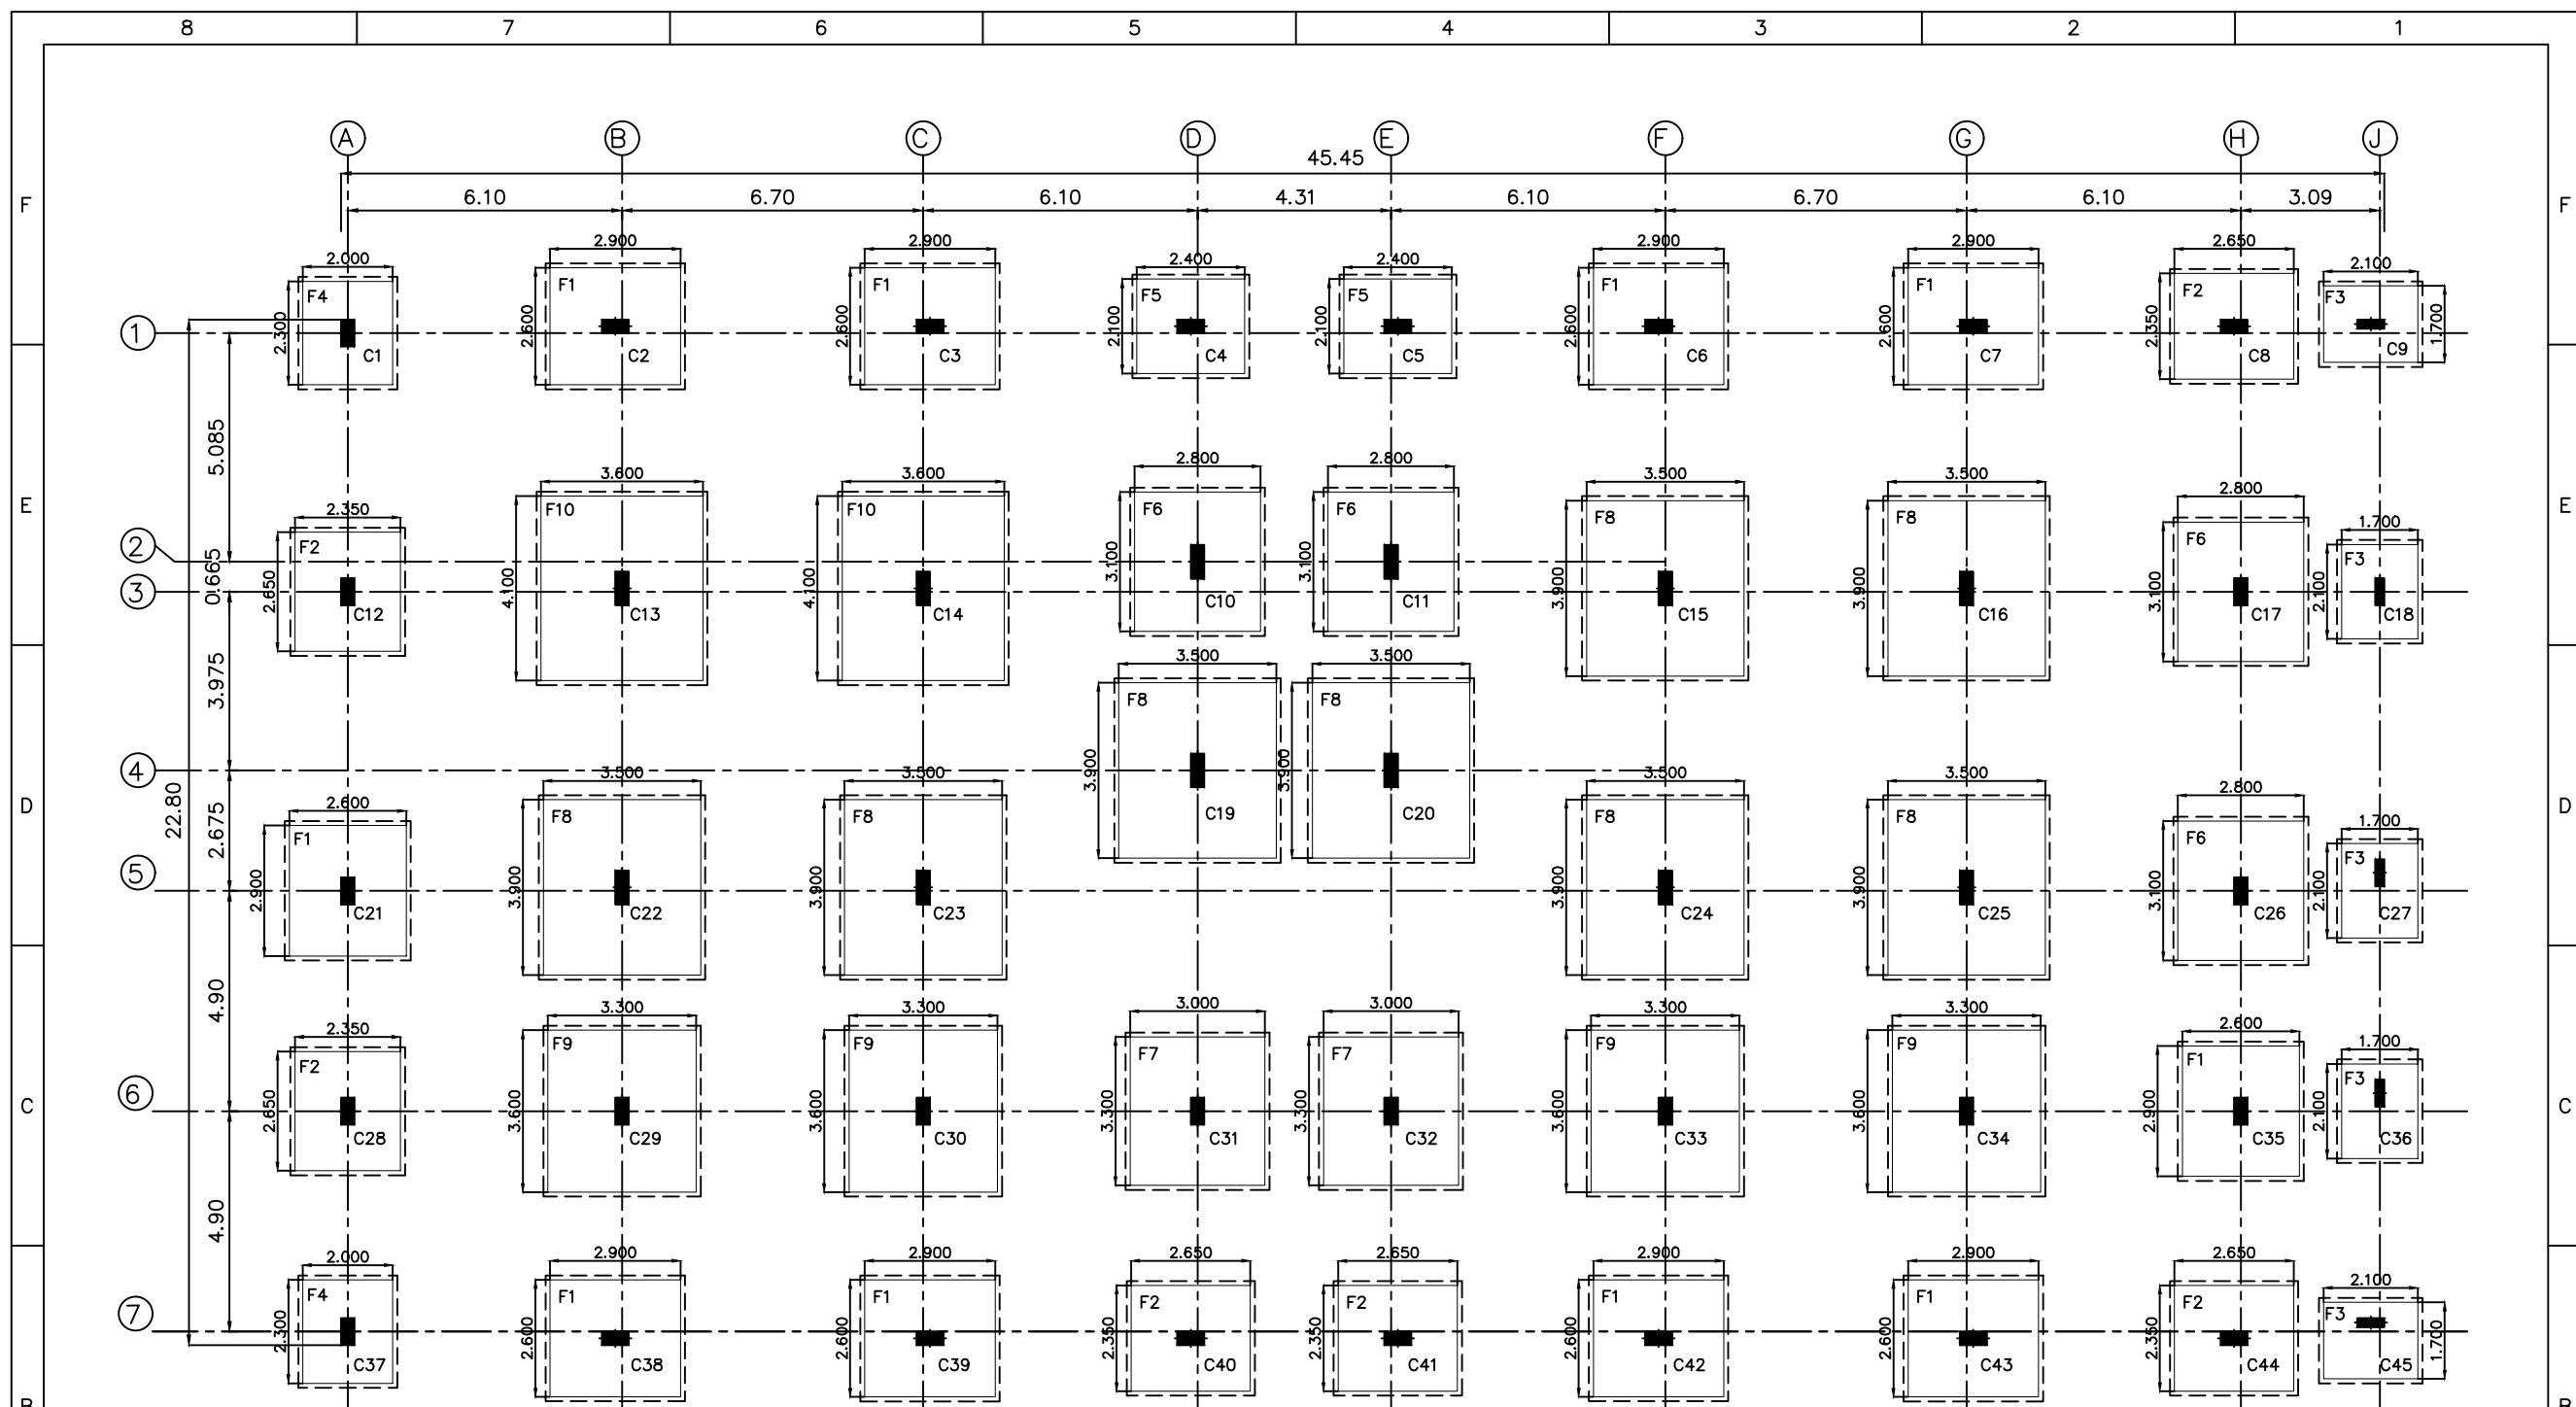

EXCAVATION LAYOUT OF FOOTINGS

EXCAVATION SHALL BE 100 MM ALL ROUND FOOTINGS

ARCHITECT
KULKARNI ASSOCIATES
Surya Prema Building, next to Adiga's Restaurant, Kanakapura Road
No-203, 2nd floor, Above Canara bank Raghuvahalli Branch
Raghuvahalli Village, Uttarahalli hobli Bangalore-560062
Email Id : kulkarni.associates@yahoo.com

TITLE
EXCAVATION LAYOUT
OF FOOTINGS
(BRBNPML-MENS BARRACKS)

PROJECT
PROVIDING COMPREHENSIVE PROJECT MANAGEMENT
CONSULTANCY SERVICES FOR PROPOSED CONSTRUCTION OF
CISF INFRASTRUCTURE BUILDINGS AT NOTE MUDRAN NAGAR MYSORE

TENDER DRAWING

SCALE: N.T.S	DRAWN: GM	APPD:
PLOT SIZE: A3	DESIGNED: SSN	SHEET NO.: 01 OF 01
DATE: 31.10.2025	CHECKED: DG	REV. NO.: R0
STATUS ☐ APPROVAL ☐ PERUSAL ☒ FOR QUANTITY PURPOSE ☐ GOOD FOR CONSTRUCTION		JOB NO. ECPL-D/10-2025/131 DRAWING No. ECPL/KA/ BRBNPML-MENS BARRACK/ST-02

NOTES:-
1. ALL DIMENSIONS ARE IN METERS.
2. FOLLOW FIGURED DIMENSION ONLY.
3. GRADE OF CONCRETE - M30.
4. GRADE OF STEEL-FE500.
5. CLEAR COVER TO MAIN REINF.
FOR FOOTING -50MM, FOR COLUMNS -40MM.
6. ANY DISCREPANCY IN DRAWING SHALL BE
BROUGHT TO THE NOTICE OF STRUCTURAL
CONSULTANTS BEFORE PROCEEDING WITH WORK.
7. SBC OF SOIL IS CONSIDERED AS 25T/SQM AT
A DEPTH OF 2.0M FROM NGL.

8

7

6

5

4

3

2

1

SCHEDULE OF FOOTING							SCHEDULE OF FOOTING REINFORCEMENT	
FOOTING NAME	NO OF FOOTING	EXCAVATION SIZE		FOOTING SIZE		DEPTH	BOTTOM REINFORCEMENT	
		Bx'	Lx'	Bx	Lx	D	X-Direction	Y-Direction
F1	10	2.800	3.100	2.600	2.900	0.750	12ø@ 0.100m C/C	12ø@ 0.100m C/C
F2	06	2.550	2.850	2.350	2.650	0.675	12ø@ 0.125m C/C	12ø@ 0.125m C/C
F3	05	1.900	2.300	1.700	2.100	0.525	10ø@ 0.100m C/C	10ø@ 0.100m C/C
F4	04	2.200	2.500	2.000	2.300	0.575	12ø@ 0.150m C/C	12ø@ 0.150m C/C
F5	02	2.300	2.600	2.100	2.400	0.625	12ø@ 0.125m C/C	12ø@ 0.125m C/C
F6	02	3.000	3.300	2.800	3.100	0.800	12ø@ 0.100m C/C	12ø@ 0.100m C/C
F7	02	3.200	3.600	3.000	3.300	0.850	12ø@ 0.100m C/C	12ø@ 0.100m C/C
F8	08	3.700	4.100	3.500	3.900	0.975	16ø@ 0.150m C/C	16ø@ 0.150m C/C
F9	02	3.800	4.300	3.600	4.100	1.000	16ø@ 0.125m C/C	16ø@ 0.125m C/C
F10	04	3.500	3.800	3.300	3.600	0.900	16ø@ 0.150m C/C	16ø@ 0.150m C/C

SCHEDULE OF COLUMNS		
COLUMN NAME	NO OF COLUMN	SIZE
C1,C2,C3,C4,C5,C6,C7,C8,C9,C12,C17,C21,C26,C28,C29,C30,C31,C32,C33,C34,C35,C37,C38,C39,C40,C41,C42,C43,C44.	28	0.300X0.600
C9,C18,C27,C36,C45.	05	0.200X0.600
C10,C11,C13,C14,C15,C16,C19,C20,C22,C23,C24,C25.	12	0.300X0.750

0.075

0.075

0.075

0.075

REINFT. ALONG 'L'

REINFT. ALONG 'B'

COLUMN

LINE OF EXCAVATION

LINE OF FOOTING

B'

Bx

PLAN-TYPICAL COLUMN FOOTING DETAILS

2.00M OR UPTO HARD STRATA

0.150

0.100

0.300

0.100

REINFT. ALONG 'B'

REINFT. ALONG 'L'

COLUMN BARS

TIES

NGL LVL

P.C.C. 1:4:8

SECTION X-X

ARCHITECT
KULKARNI ASSOCIATES
Surya Prema Building, next to Adiga's Restaurant, Kanakapura Road
No-203, 2nd floor, Above Canara bank Raghuvahalli Branch
Raghuvahalli Village, Uttarahalli hobli Bangalore-560062
Email Id : kulkarni.associates@yahoo.com

TITLE
FOOTING DETAILS
(BRBNPML-MENS BARRACKS)

PROJECT
PROVIDING COMPREHENSIVE PROJECT MANAGEMENT
CONSULTANCY SERVICES FOR PROPOSED CONSTRUCTION OF
CISF INFRASTRUCTURE BUILDINGS AT NOTE MUDRAN NAGAR MYSORE

TENDER DRAWING

SCALE: N.T.S

PLOT SIZE: A3

DATE: 31.10.2025

STATUS
☐ APPROVAL
☒ FOR QUANTITY PURPOSE
☐ GOOD FOR CONSTRUCTION

DRAWN: GM

DESIGNED: SSN

CHECKED: DG

JOB NO.
ECPL-D/10-2025/131

DRAWING No.
ECPL/KA/
BRBNPML-MENS BARRACK/ST-03


APPD:

SHEET NO.: 01 OF 01

REV. NO.: R0

NOTES:-
1. ALL DIMENSIONS ARE IN METERS.
2. FOLLOW FIGURED DIMENSION ONLY.
3. GRADE OF CONCRETE - M30.
4. GRADE OF STEEL-FE500.
5. CLEAR COVER TO MAIN REINF. FOR BEAM -30MM
FOR SLAB -25MM, FOR COLUMNS -40MM.
6. ANY DISCREPANCY IN DRAWING SHALL BE BROUGHT TO THE NOTICE OF STRUCTURAL CONSULTANTS BEFORE PROCEEDING WITH WORK.

Page 51 of 129

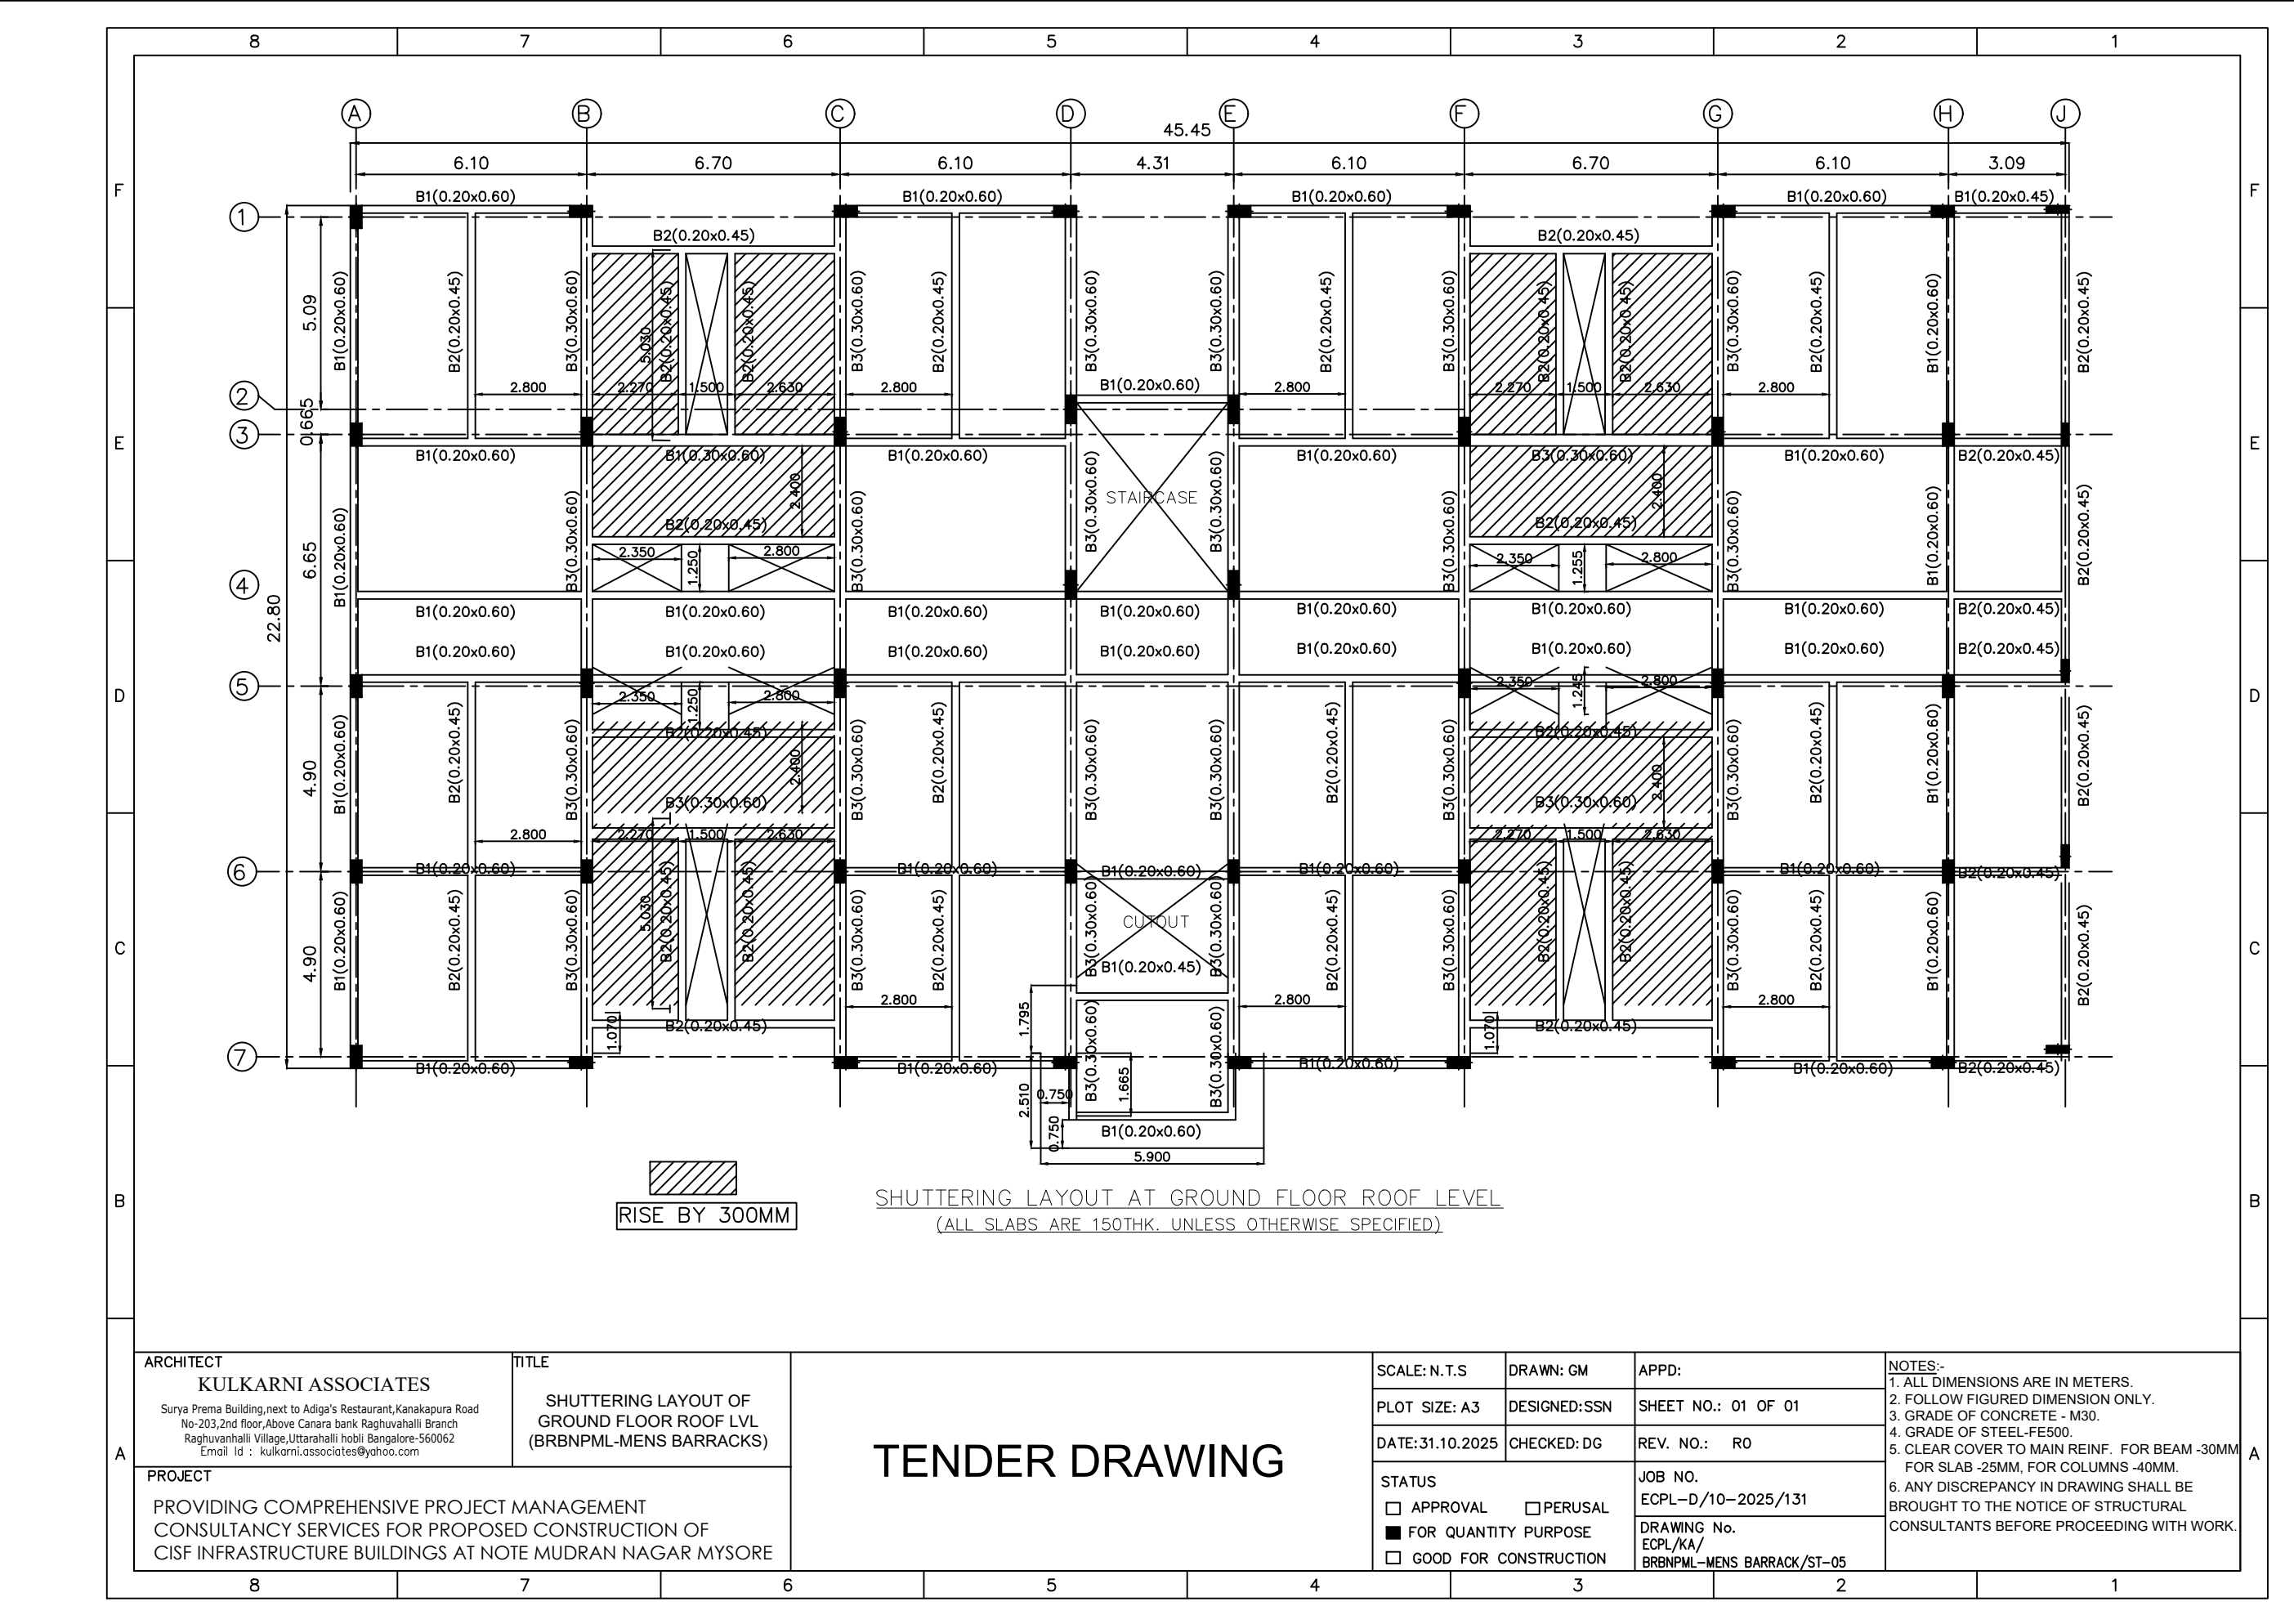

ARCHITECT

KULKARNI ASSOCIATES

Surya Prema Building,next to Adiga's Restaurant,Kanakapura Road
No-203,2nd floor,Above Canara bank Raghuvahalli Branch
Raghuvanhalli Village,Uttarahalli hobli Bangalore-560062
Email Id : kulkarni.associates@yahoo.com

PROJECT


PROVIDING COMPREHENSIVE PROJECT MANAGEMENT
CONSULTANCY SERVICES FOR PROPOSED CONSTRUCTION OF
CISF INFRASTRUCTURE BUILDINGS AT NOTE MUDRAN NAGAR MYSORE


TITLE

SHUTTERING LAYOUT OF
GROUND FLOOR ROOF LVL
(BRBNPML-MENS BARRACKS)


TENDER DRAWING

SCALE: N.T.S	DRAWN: GM	APPD:	NOTES:- 1. ALL DIMENSIONS ARE IN METERS. 2. FOLLOW FIGURED DIMENSION ONLY. 3. GRADE OF CONCRETE - M30. 4. GRADE OF STEEL-FE500. 5. CLEAR COVER TO MAIN REINF. FOR BEAM -30MM FOR SLAB -25MM, FOR COLUMNS -40MM. 6. ANY DISCREPANCY IN DRAWING SHALL BE BROUGHT TO THE NOTICE OF STRUCTURAL CONSULTANTS BEFORE PROCEEDING WITH WORK.
PLOT SIZE: A3	DESIGNED:SSN	SHEET NO.: 01 OF 01	
DATE:31.10.2025	CHECKED: DG	REV. NO.: R0	
STATUS ☐ APPROVAL ☐ PERUSAL ☒ FOR QUANTITY PURPOSE ☐ GOOD FOR CONSTRUCTION		JOB NO. ECPL-D/10-2025/131	
		DRAWING No. ECPL/KA/ BRBNPML-MENS BARRACK/ST-05	

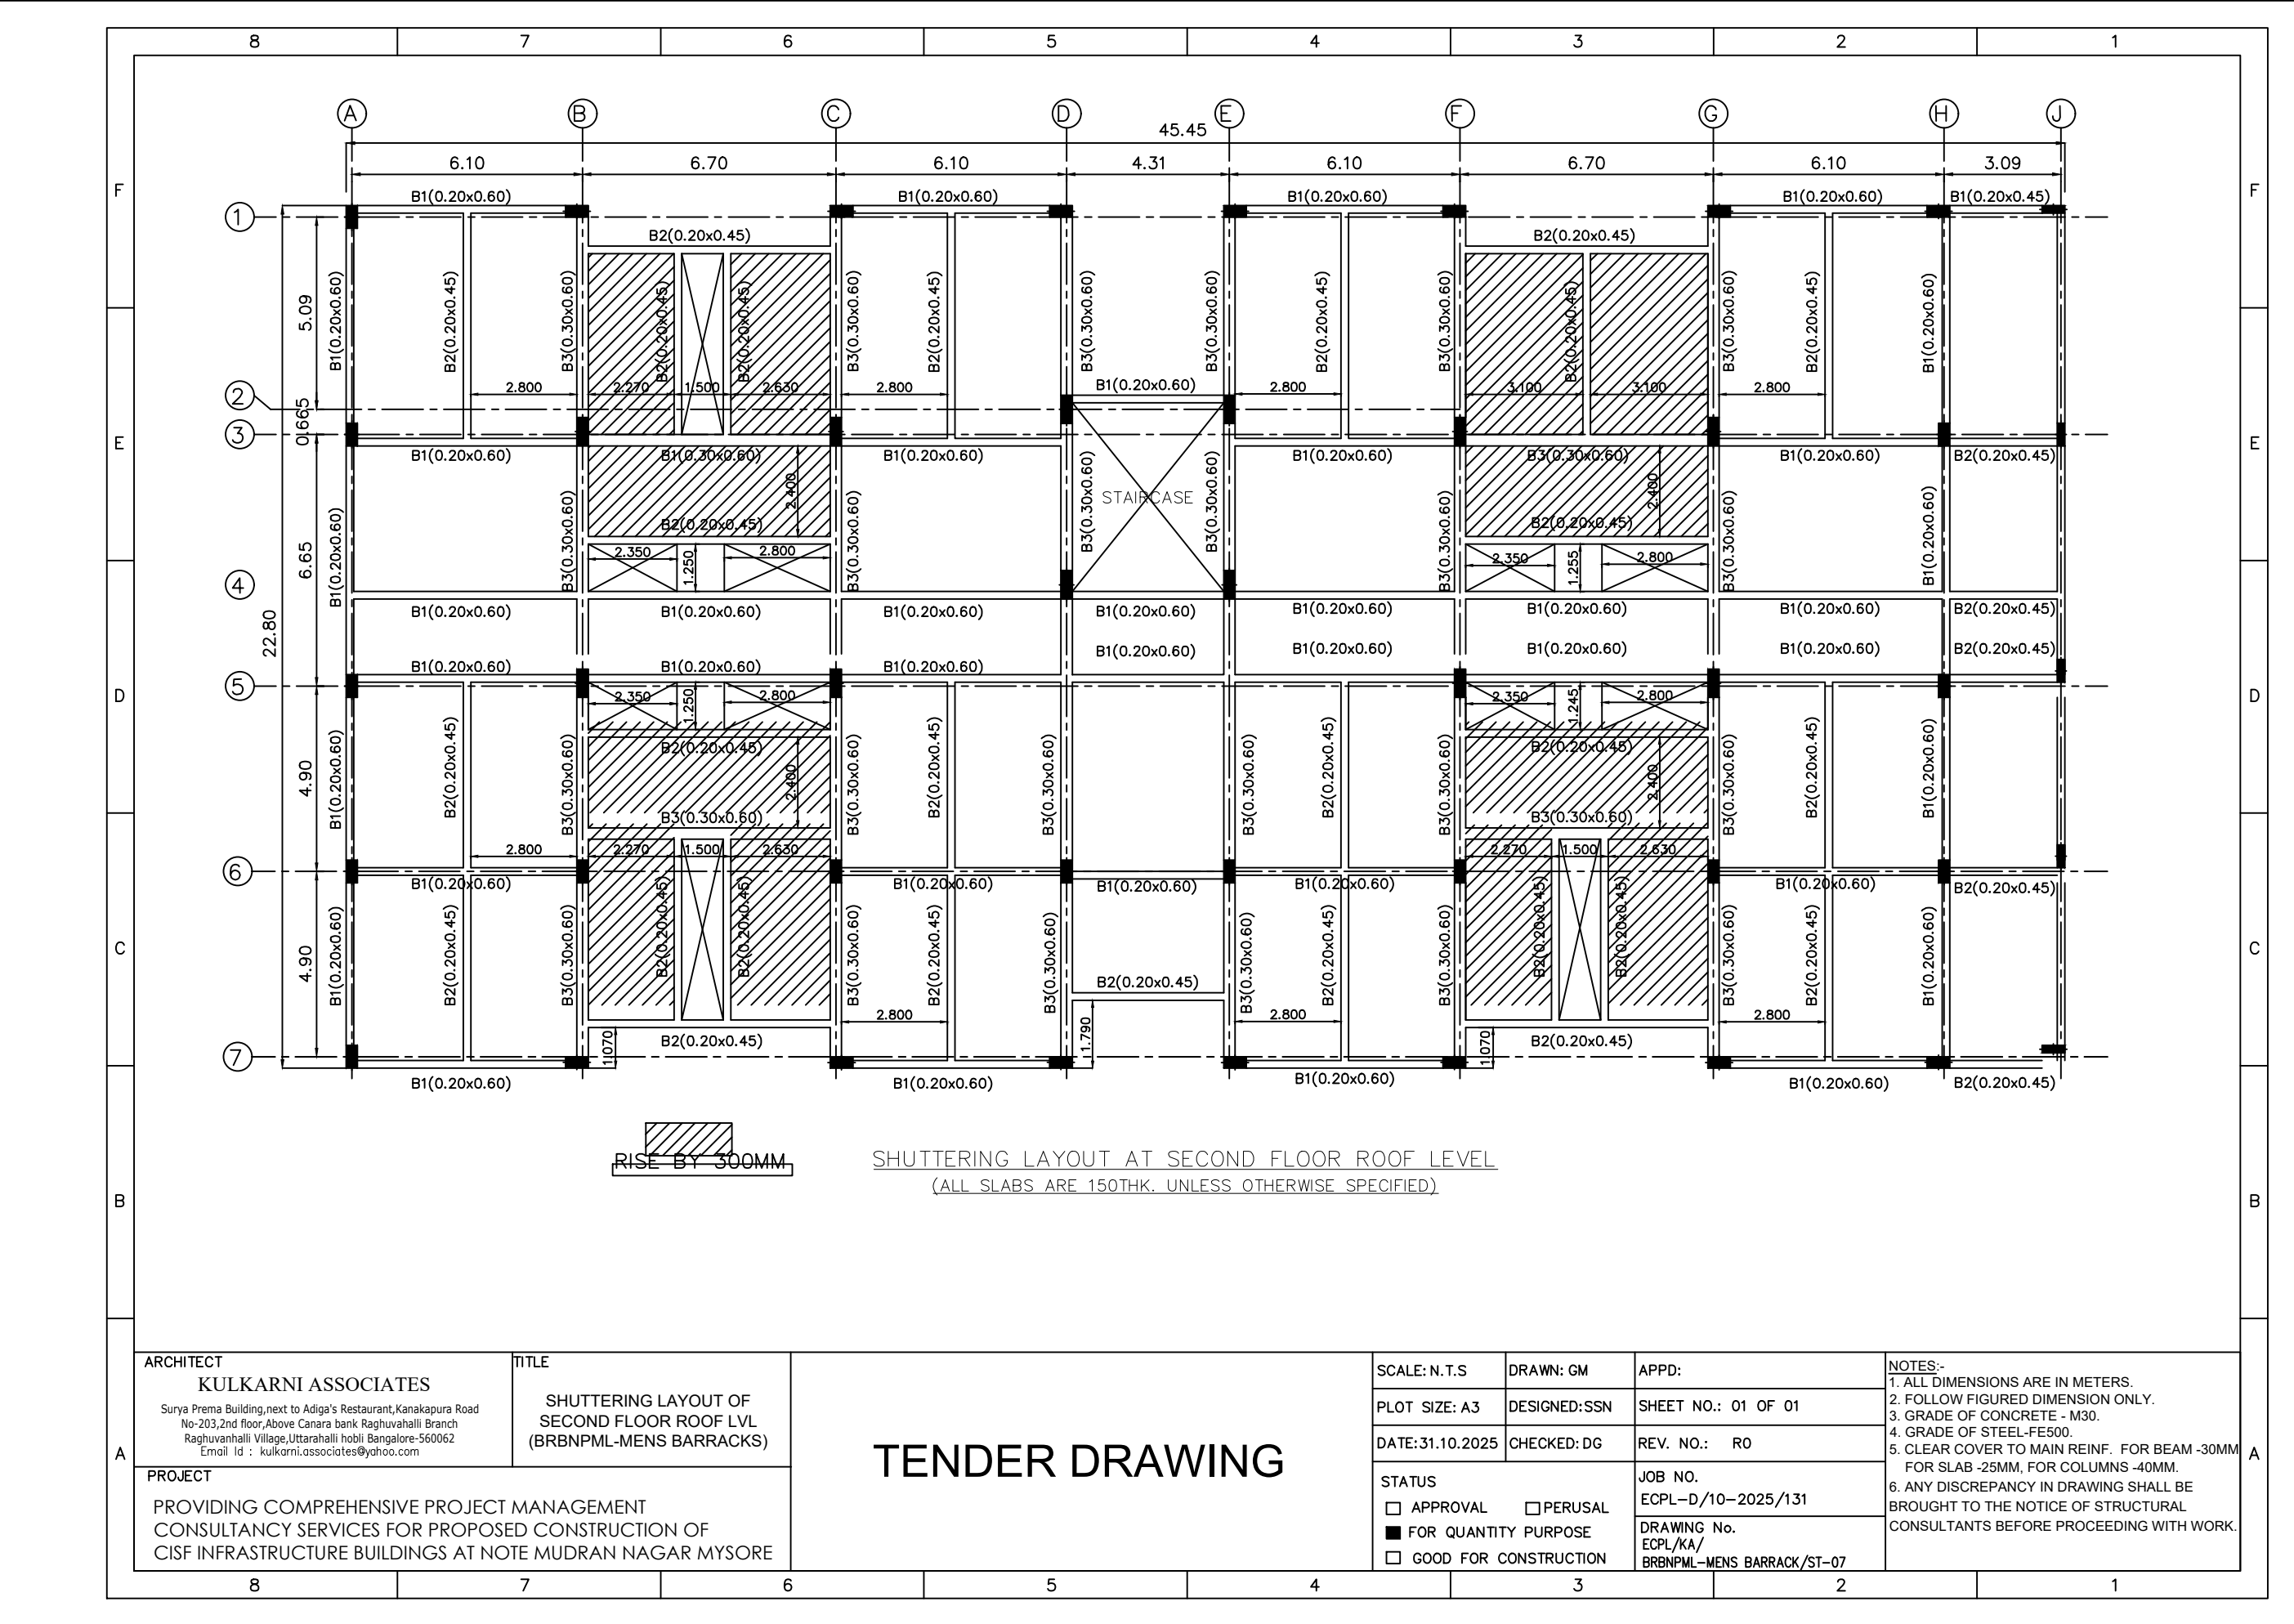

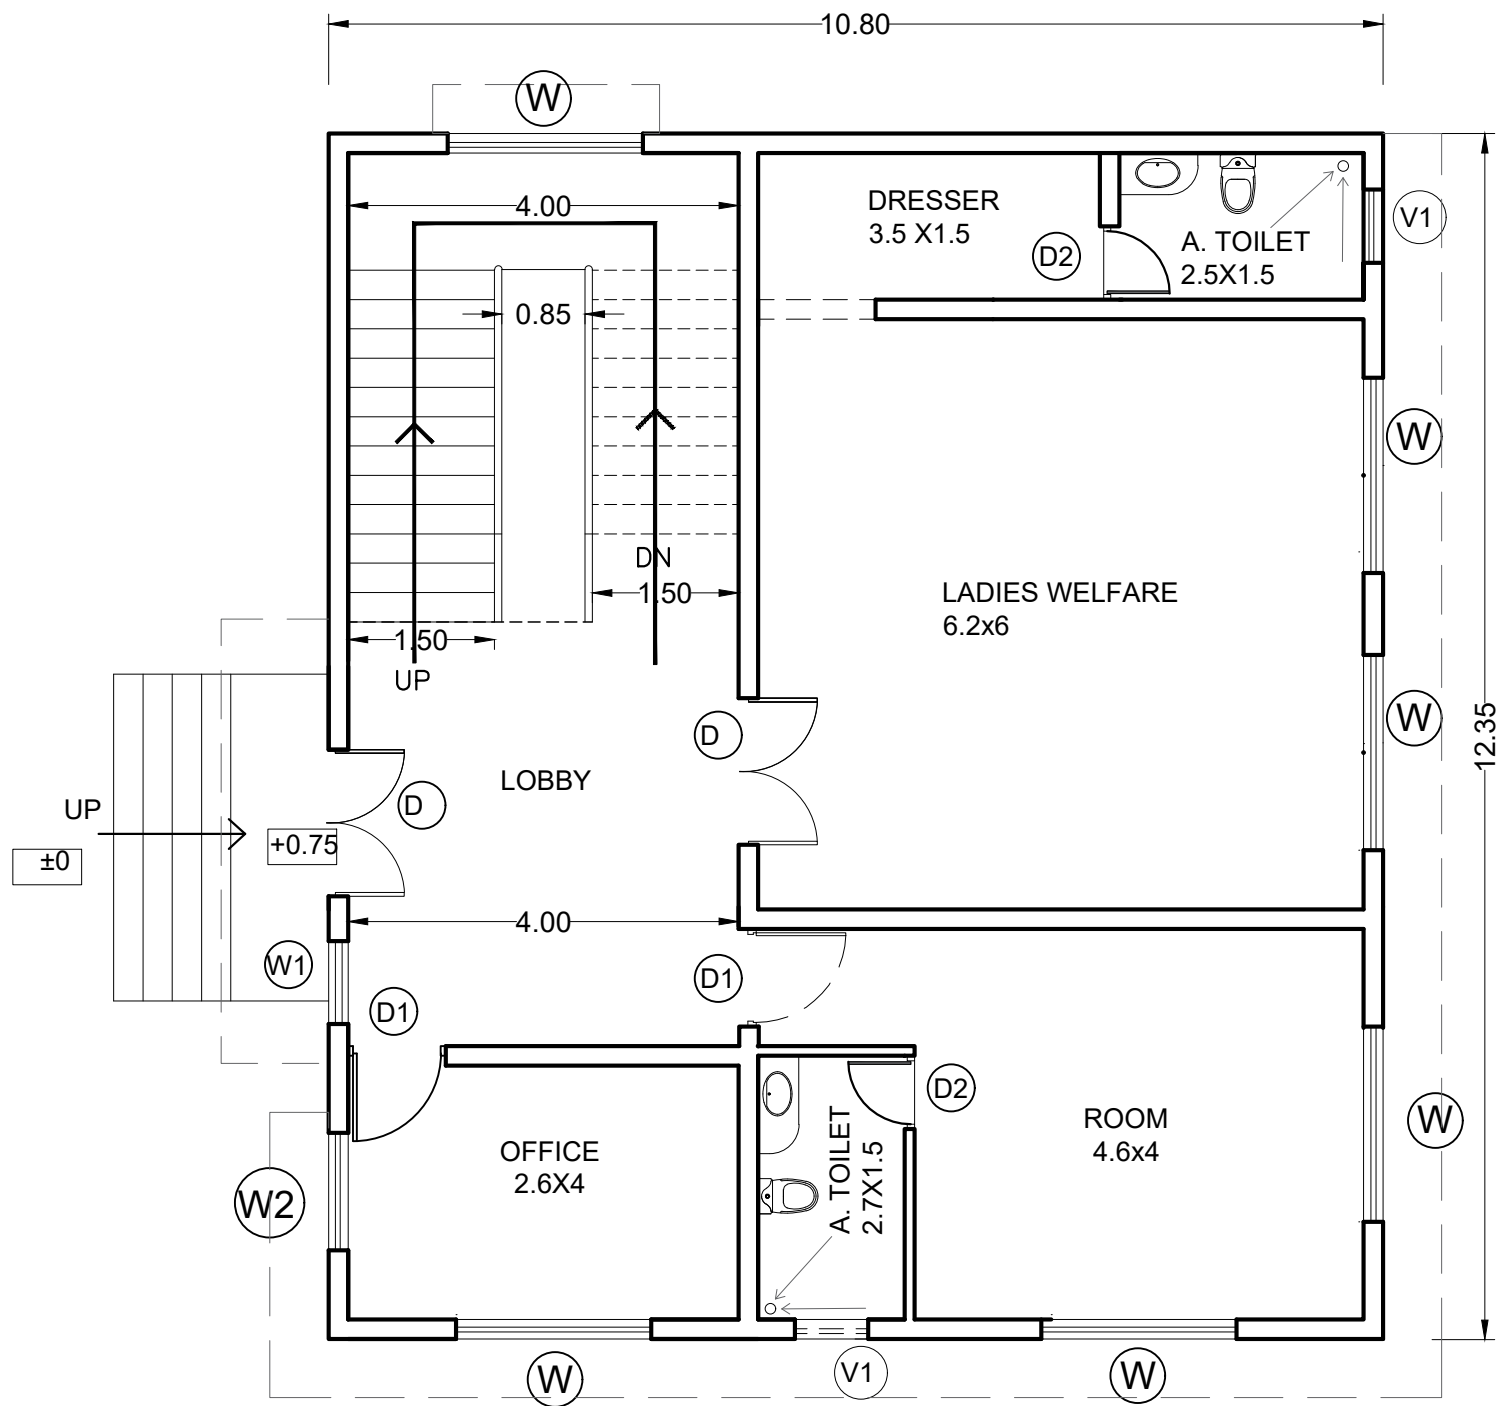


GROUND FLOOR PLAN

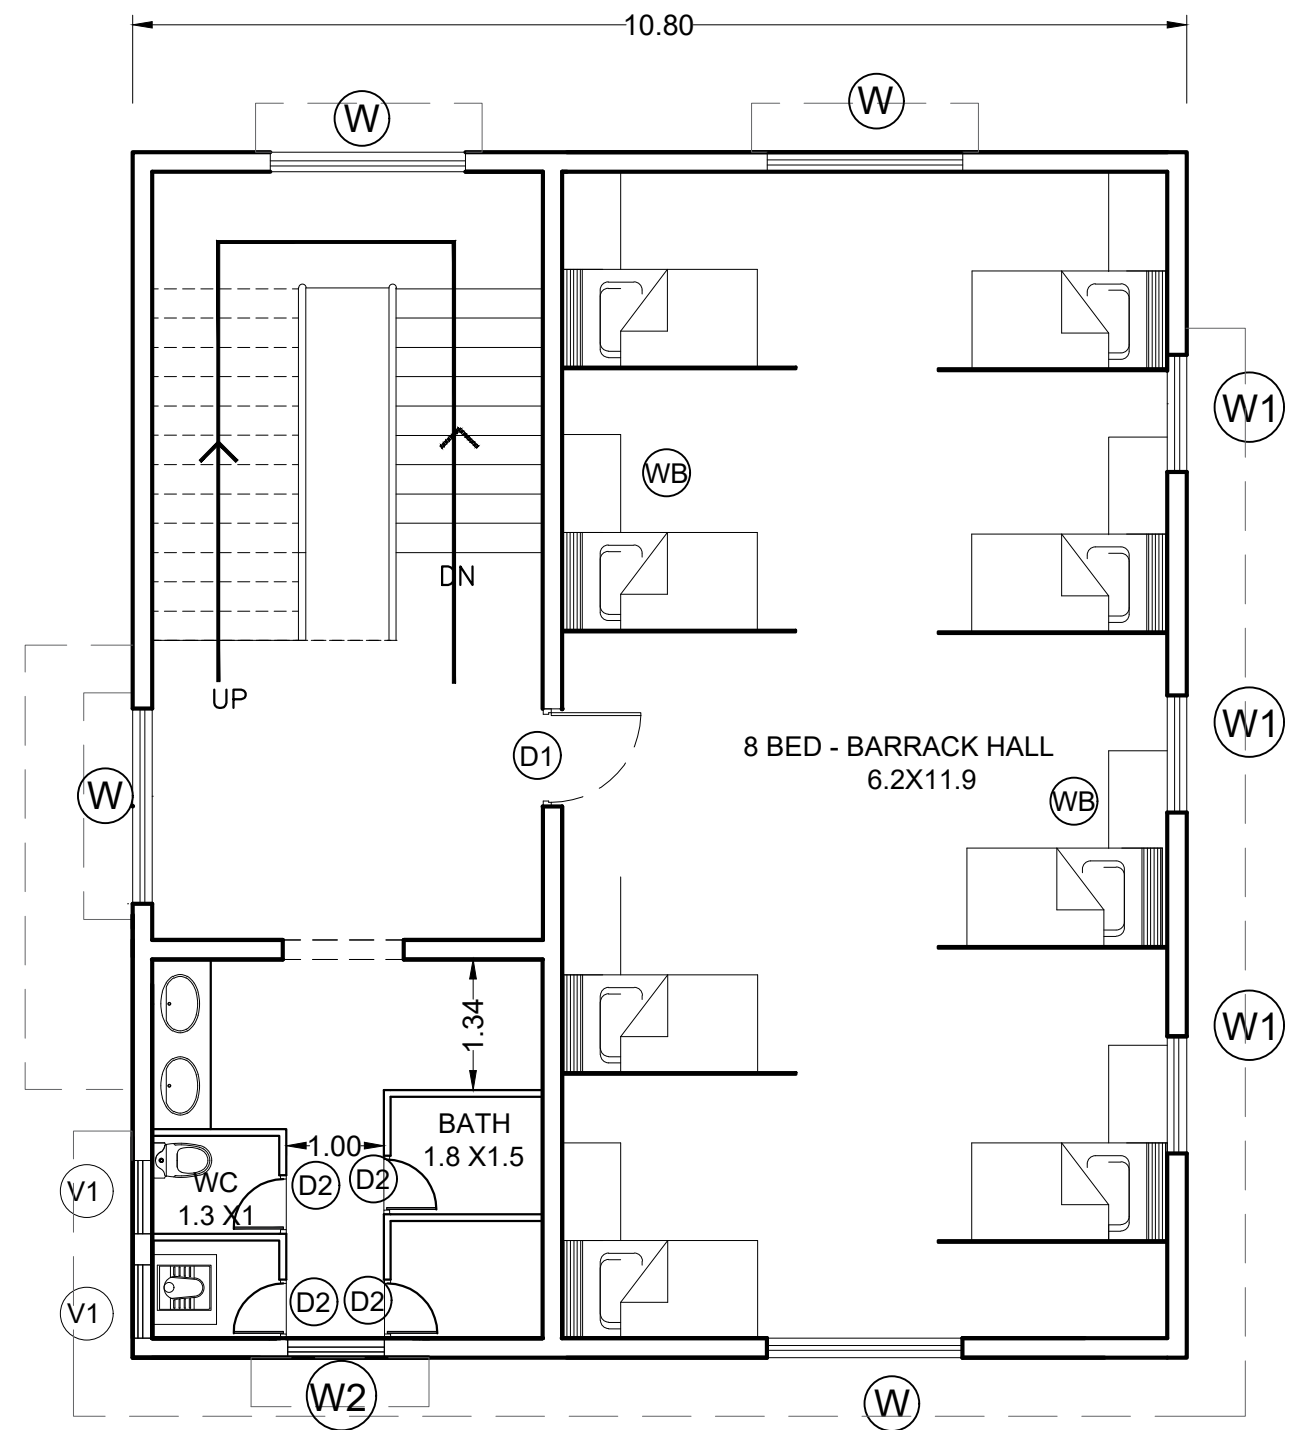

FIRST FLOOR PLAN

NOTE : ALL DIMENSION IN METERS



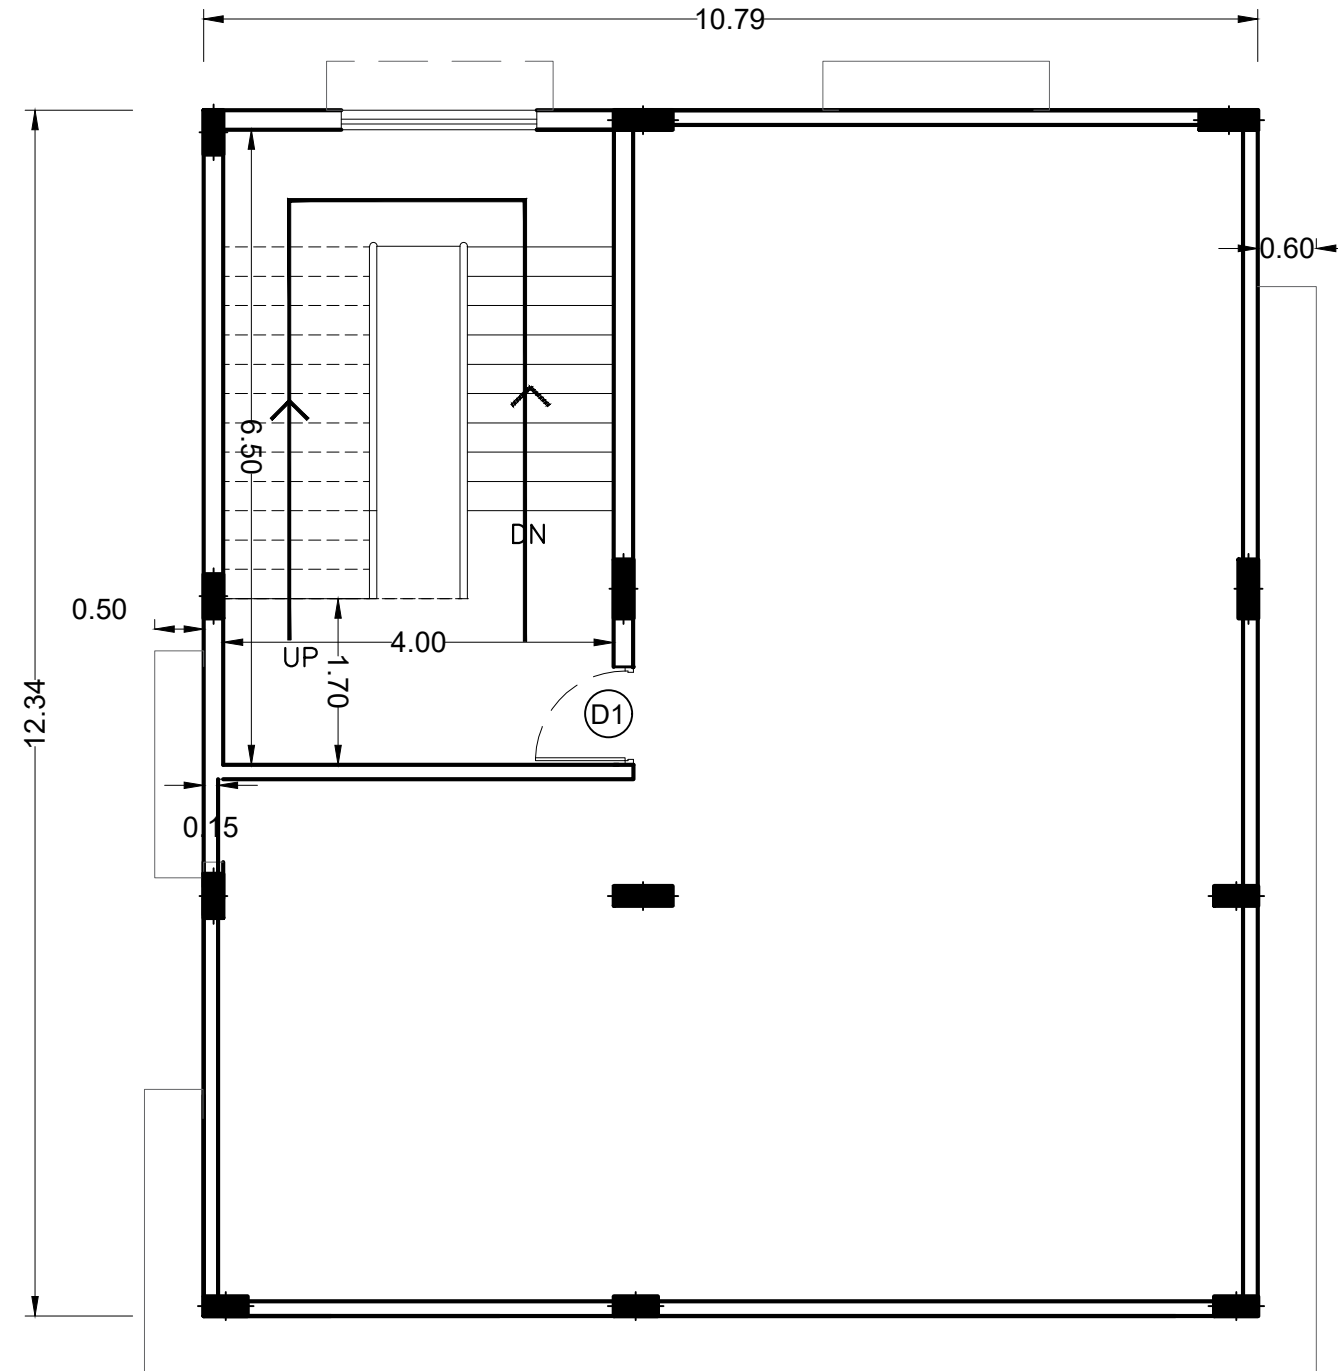

TERRACE FLOOR PLAN

NOTE : ALL DIMENSION IN METERS

PROJECT :
PROPOSED SITE LAYOUT PLAN FOR
CISF INFRASTRUCTURE BUILDINGS
AT NOTE MUDRAN NAGAR MYSORE

TENDER DRAWING

Page 58 of 129

BNPM LADIES - BARRACK FLOOR PLAN

Date : 30-10-2025

Drawn by: AMRUTHA

Scale: 1:200

Checked by: Ar. Kavitha


Rev Date: -----




ARCHITECTS :
KULKARNI ASSOCIATES

Surya Prema Building, next to Adiga's Restaurant, Kanakapura Road
No-203, 2nd floor, Above Canara bank Raghuvahalli Branch
Raghuvahalli Village, Uttarahalli hobli Bangalore-560062


Email Id : kulkarni.associates@yahoo.com

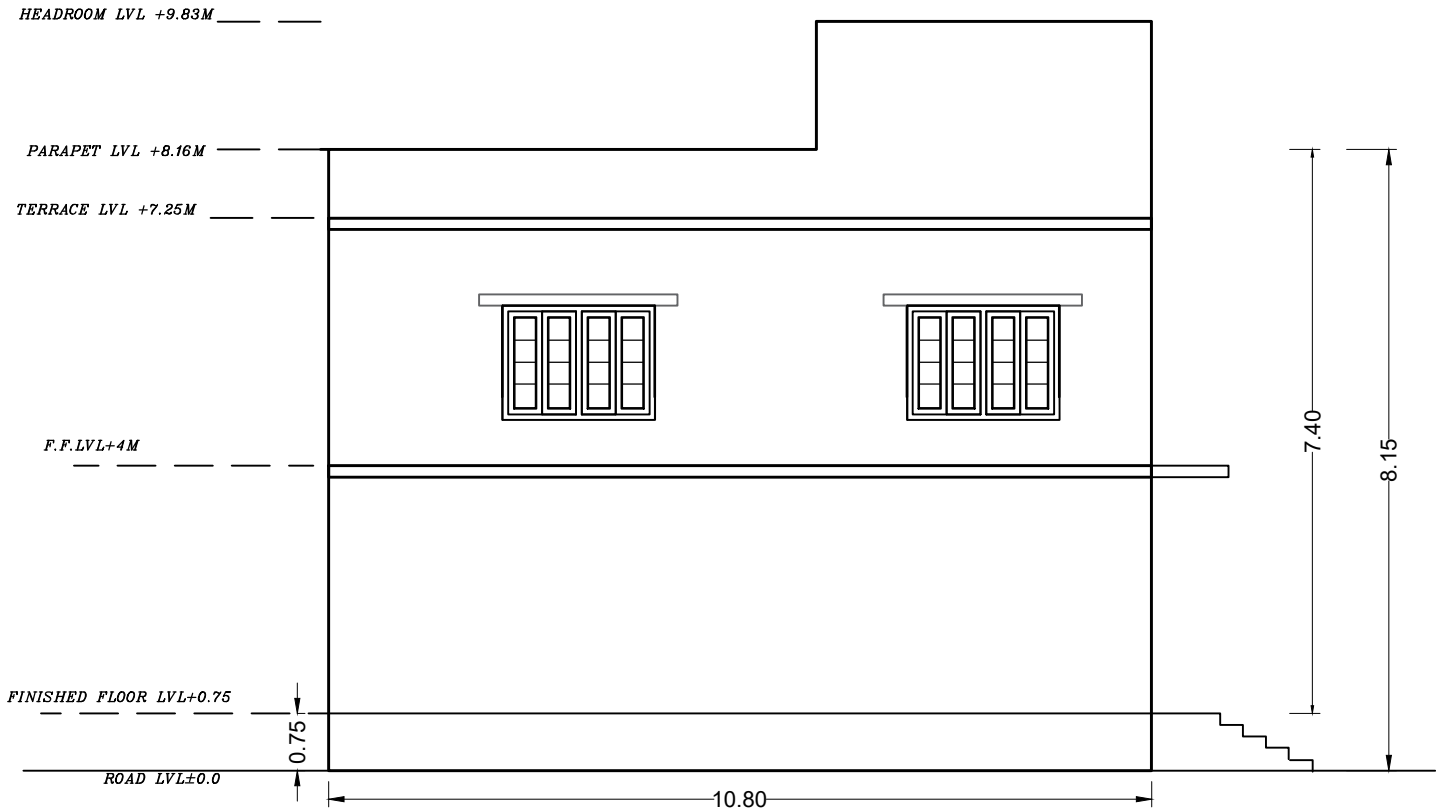


NORTH SIDE ELEVATION (LEFT SIDE)

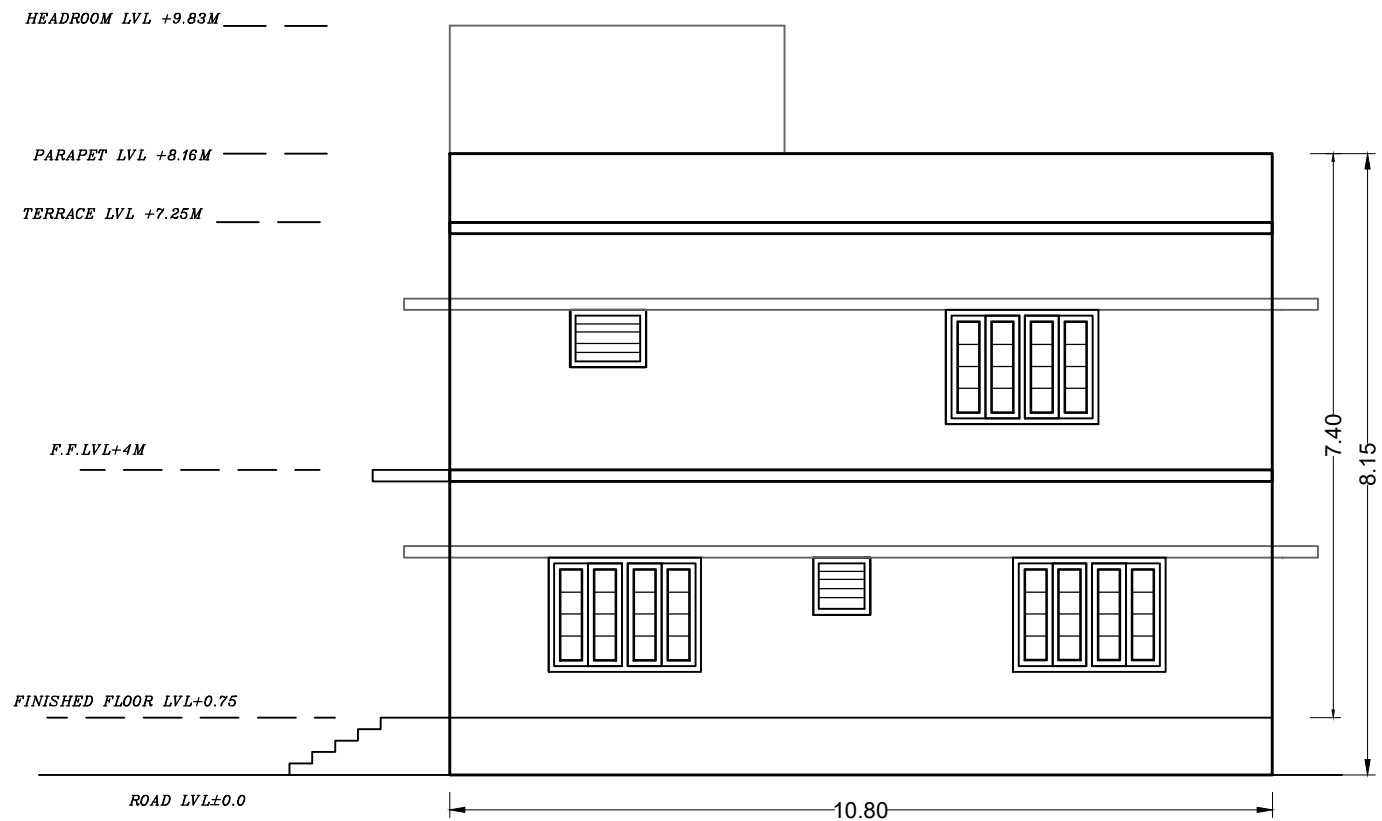

SOUTH SIDE ELEVATION (RIGHT SIDE)

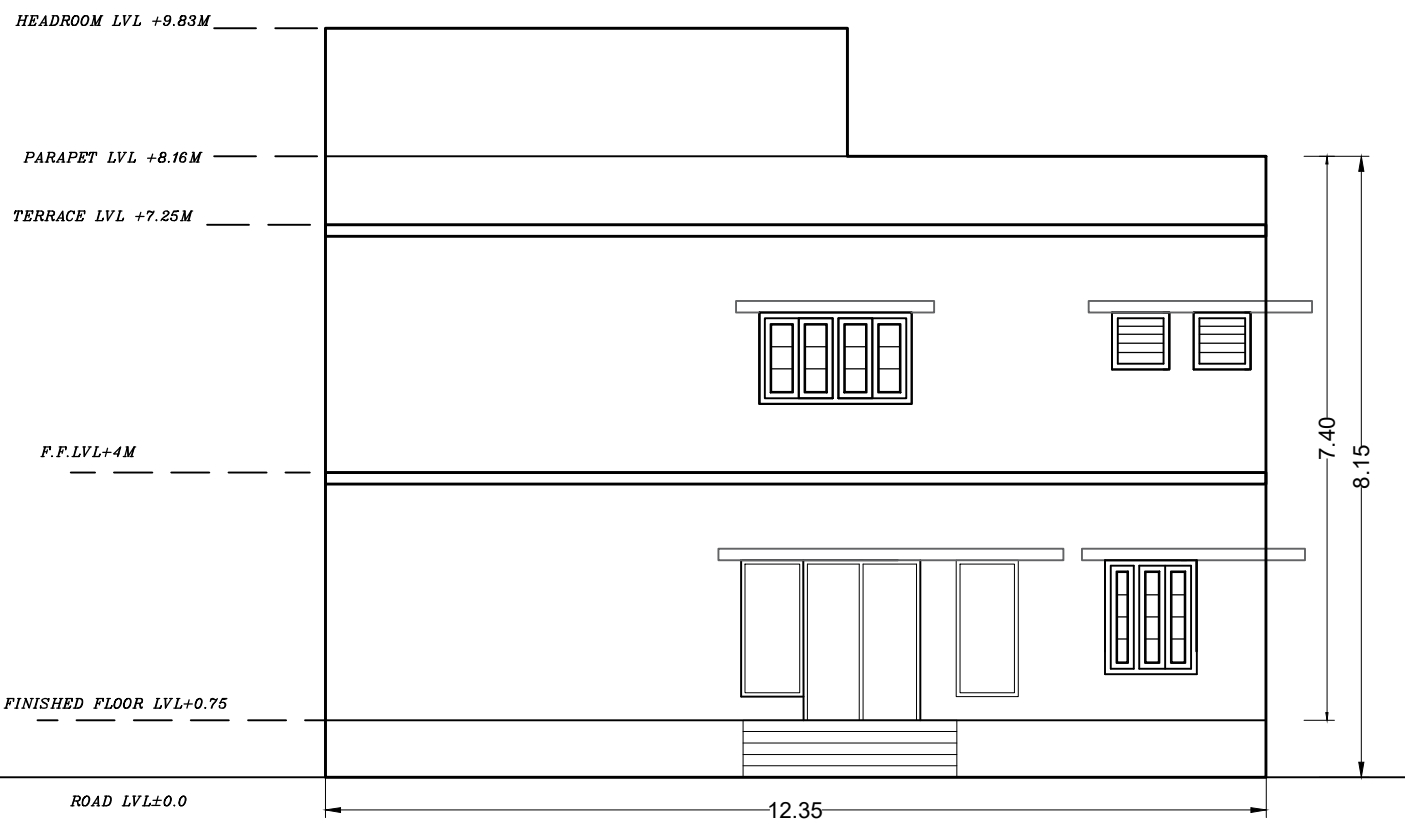

WEST SIDE ELEVATION (FRONT SIDE)

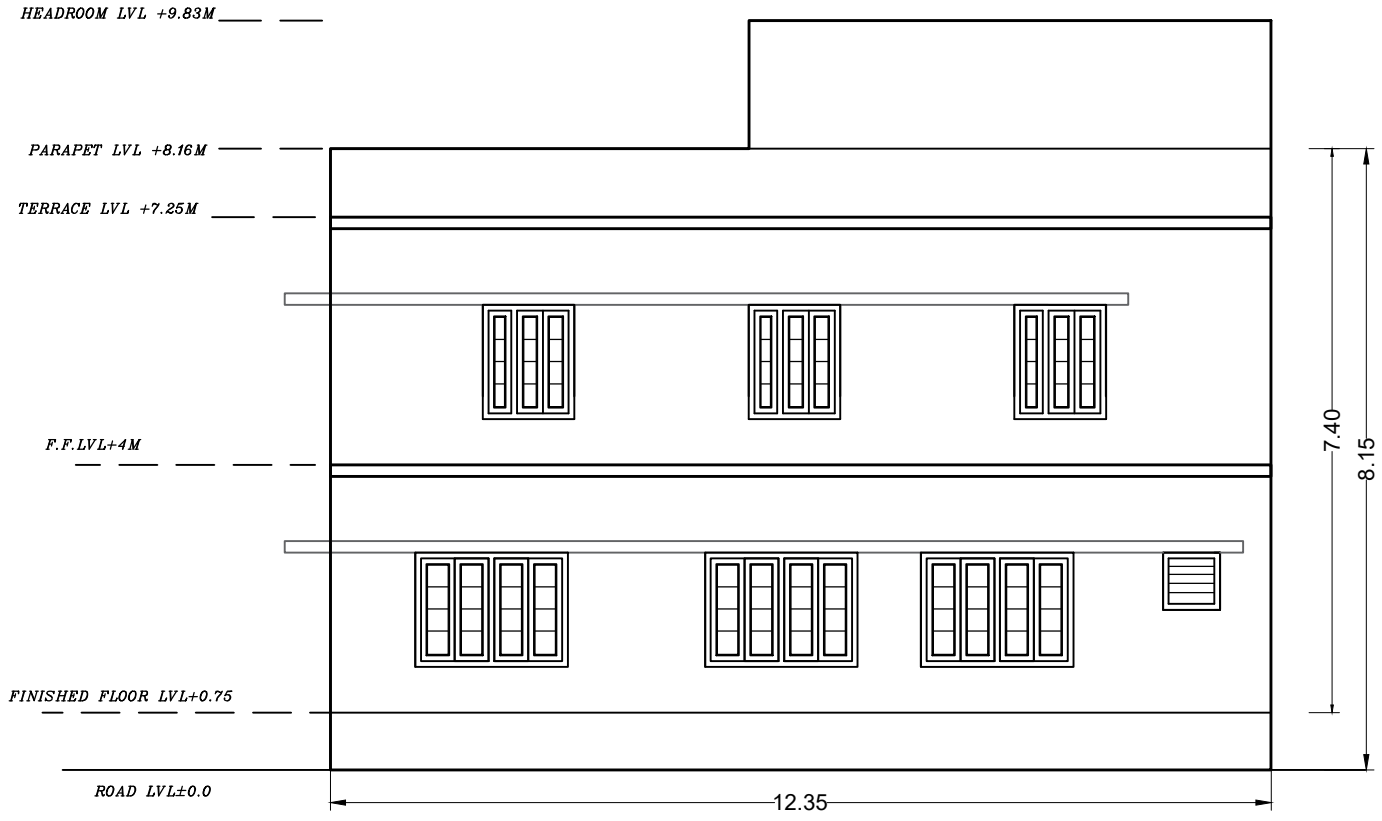

EAST SIDE ELEVATION (REAR SIDE)

NOTE : ALL DIMENSION IN METERS

PROJECT :
PROPOSED SITE LAYOUT PLAN FOR
CISF INFRASTRUCTURE BUILDINGS
AT NOTE MUDRAN NAGAR MYSORE

TENDER DRAWING




BNPM LADIES - BARRACK ELEVATION

Date : 30-10-2025	Drawn by: AMRUTHA
Scale: 1:100	Checked by: Ar. Kavitha
Rev Date: -----	

ARCHITECTS :
KULKARNI ASSOCIATES


Surya Prema Building, next to Adiga's Restaurant, Kanakapura Road
No-203, 2nd floor, Above Canara bank Raghuvahalli Branch
Raghuvahalli Village, Uttarahalli hobli Bangalore-560062

Email Id : kulkarni.associates@yahoo.com

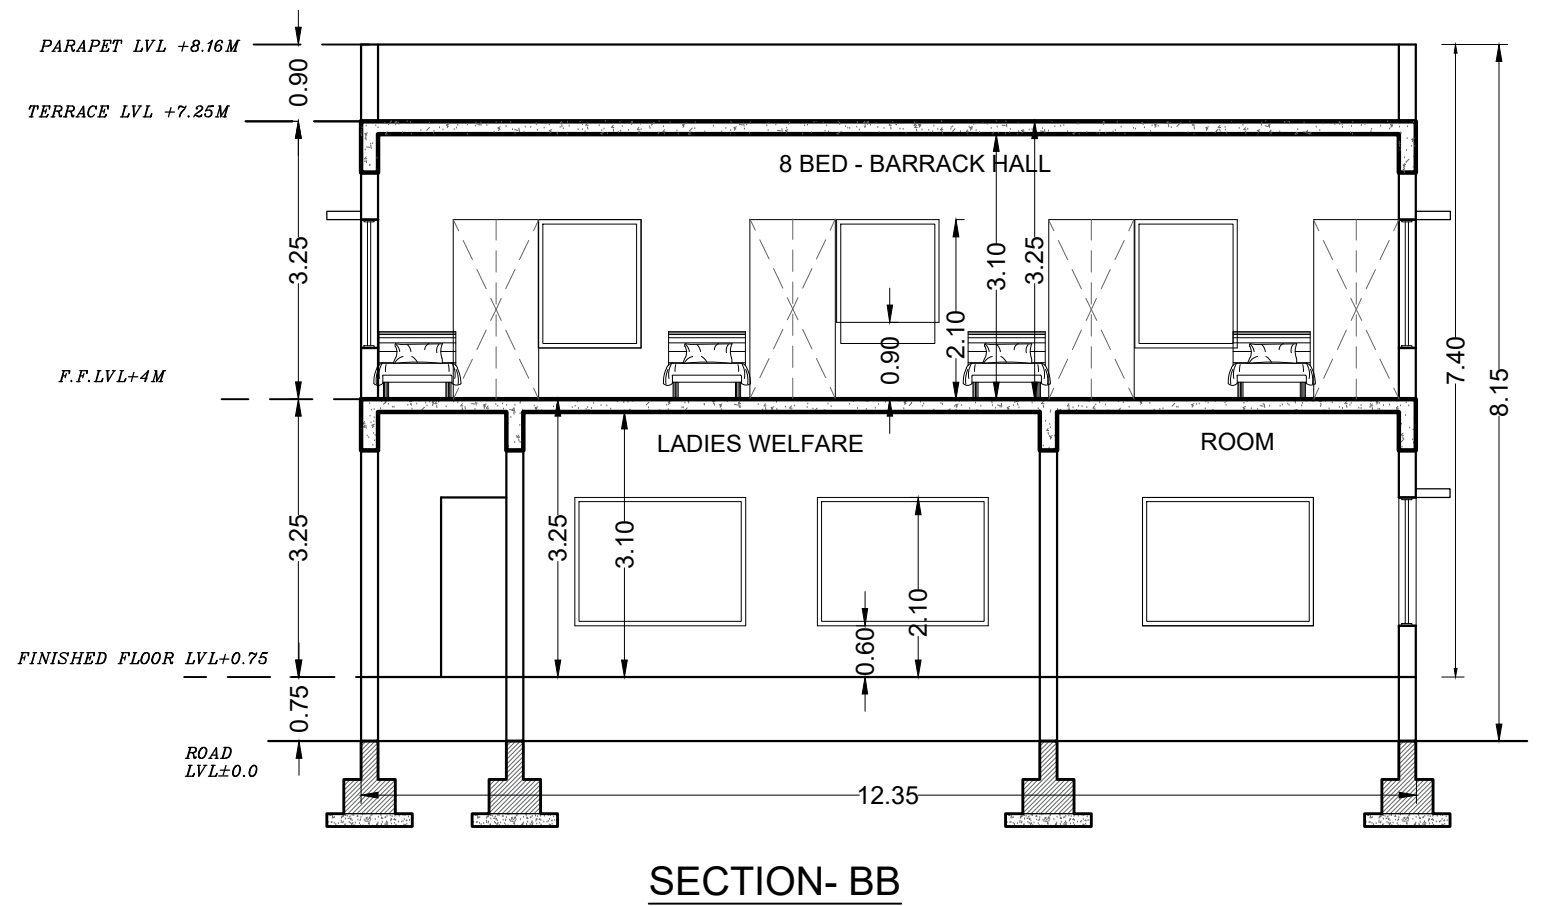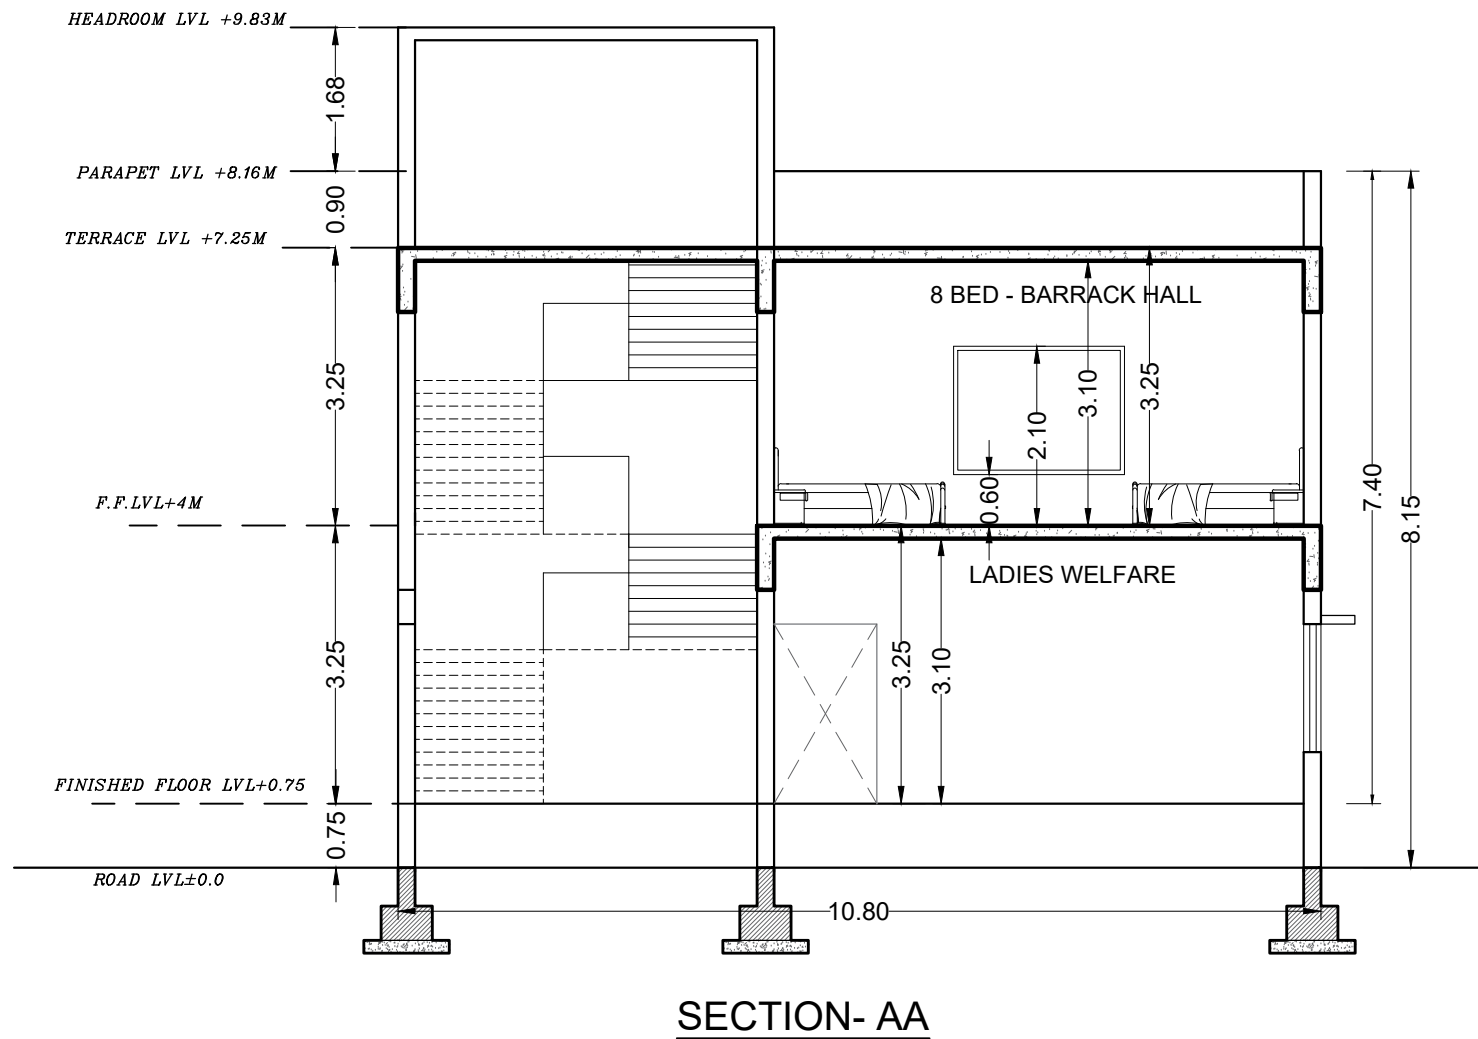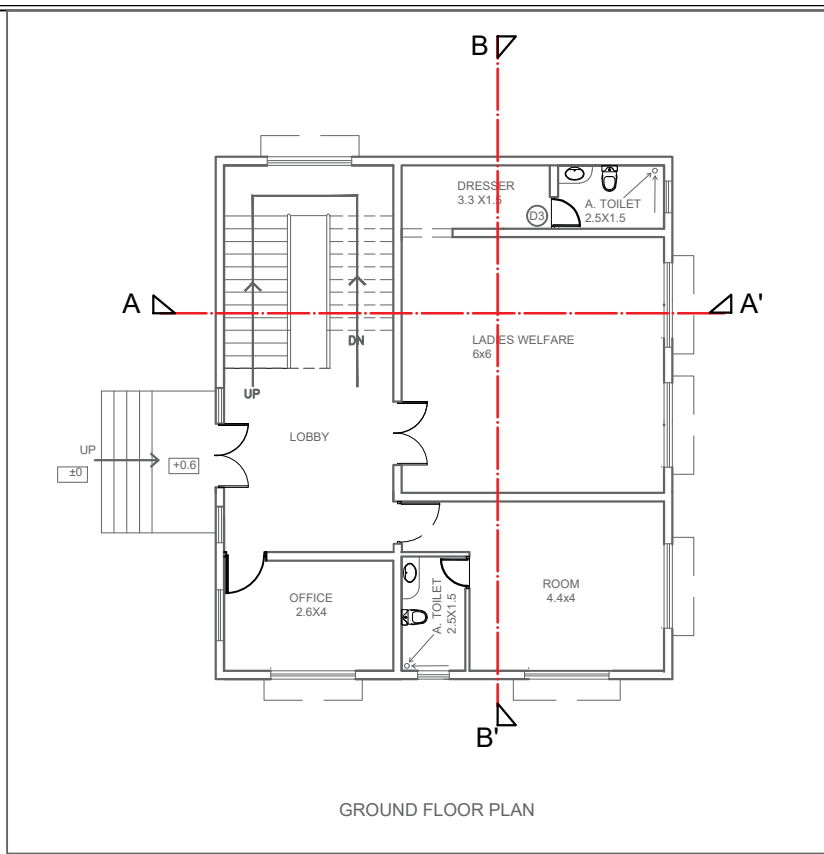

NOTE : ALL DIMENSION IN METERS

PROJECT : PROPOSED SITE LAYOUT PLAN FOR CISF INFRASTRUCTURE BUILDINGS AT NOTE MUDRAN NAGAR MYSORE	TENDER DRAWING	BNPM LADIES - BARRACK SECTION		ARCHITECTS : KULKARNI ASSOCIATES Surya Prema Building,next to Adiga's Restaurant,Kanakapura Road No-203,2nd floor,Above Canara bank Raghuvahalli Branch Raghuvanhalli Village,Uttarahalli hobli Bangalore-560062 Email Id : kulkarni.associates@yahoo.com
		Date : 30-10-2025	Drawn by: AMRUTHA	
		Scale: 1:1000	Checked by: Ar. Kavitha	
		Rev Date: -----		

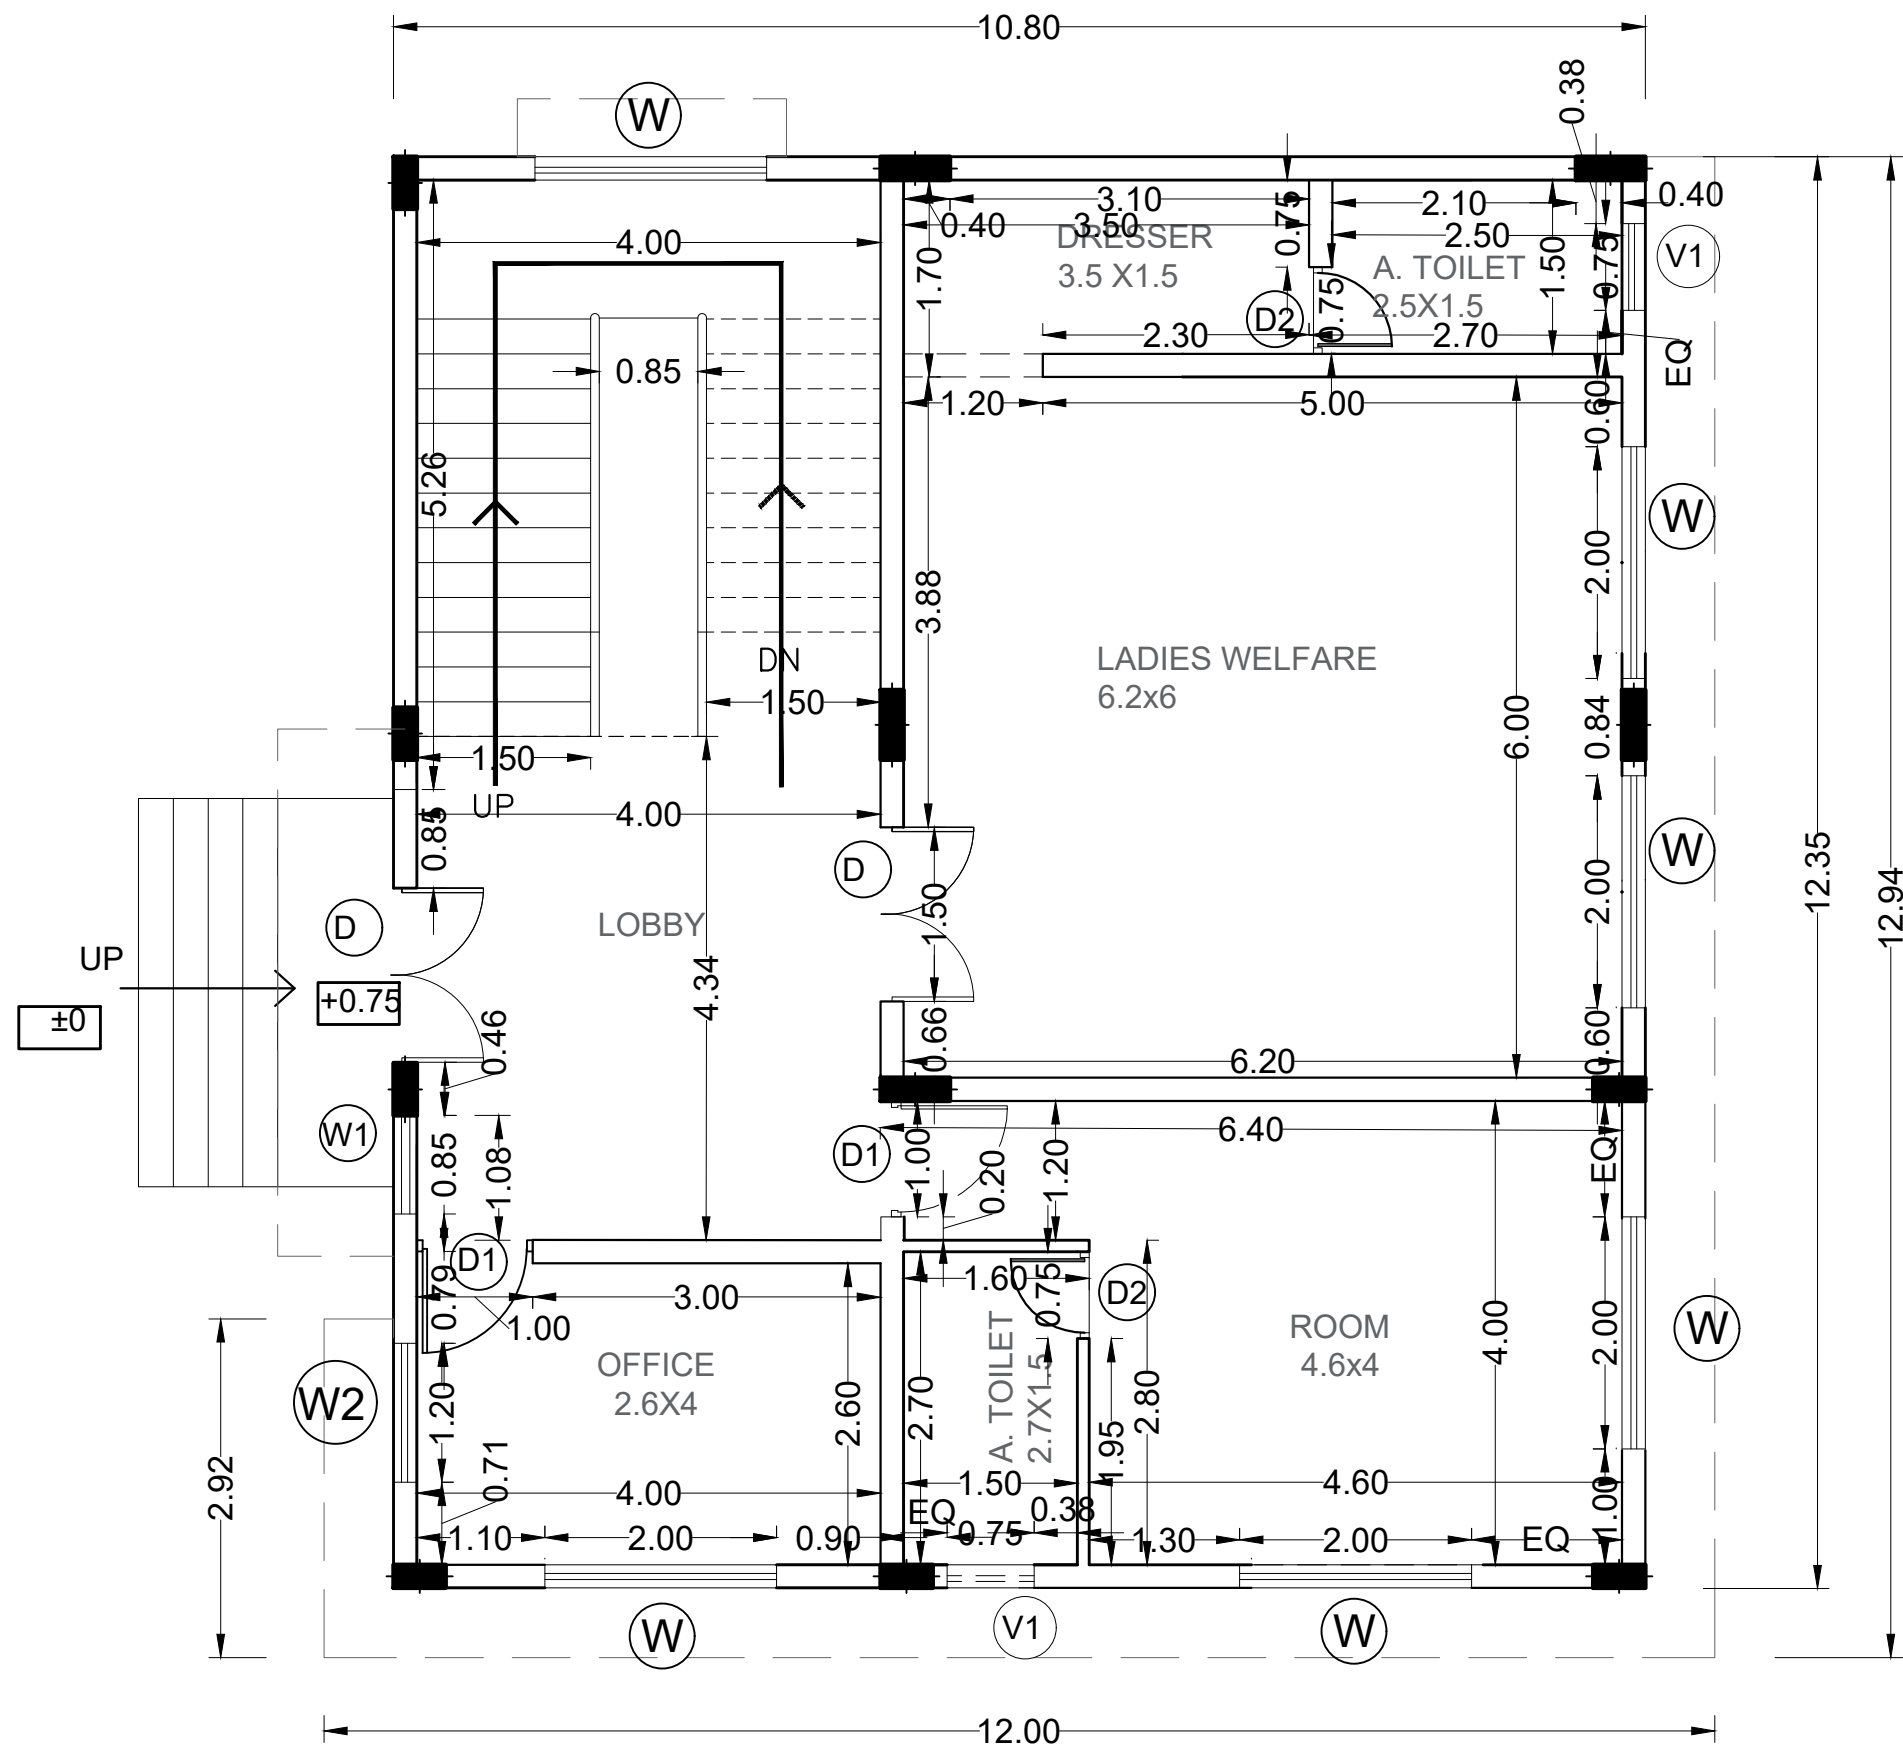

GROUND FLOOR PLAN

SCHEDULE OF OPENINGS		
DOORS		
	SIZE IN M	Nos
D	1.50 X 2.10	2
D1	1.00 X 2.10	2
D2	0.75 X 2.10	2
WINDOWS		
W	2.00 X 1.50	6
W1	0.85 X 1.79	1
W2	1.20 X 1.50	1
VENTILATORS		
V1	0.75X 0.75	2

NOTE : ALL Chajja projection is 0.6m deep

NOTE : ALL DIMENSION IN METERS

PROJECT :
PROPOSED SITE LAYOUT PLAN FOR
CISF INFRASTRUCTURE BUILDINGS
AT NOTE MUDRAN NAGAR MYSORE

TENDER DRAWING

Page 61 of 129

BNPM LADIES - BARRACK FLOOR PLAN WORKING DRAWING

Date : 30-10-2025

Drawn by: AMRUTHA

Scale: 1/20

Checked by: Ar. Kavitha


Rev Date: -----



ARCHITECTS :
KULKARNI ASSOCIATES

Surya Prema Building, next to Adiga's Restaurant, Kanakapura Road
No-203, 2nd floor, Above Canara bank Raghuvahalli Branch
Raghuvahalli Village, Uttarahalli hobli Bangalore-560062

Email Id : kulkarni.associates@yahoo.com

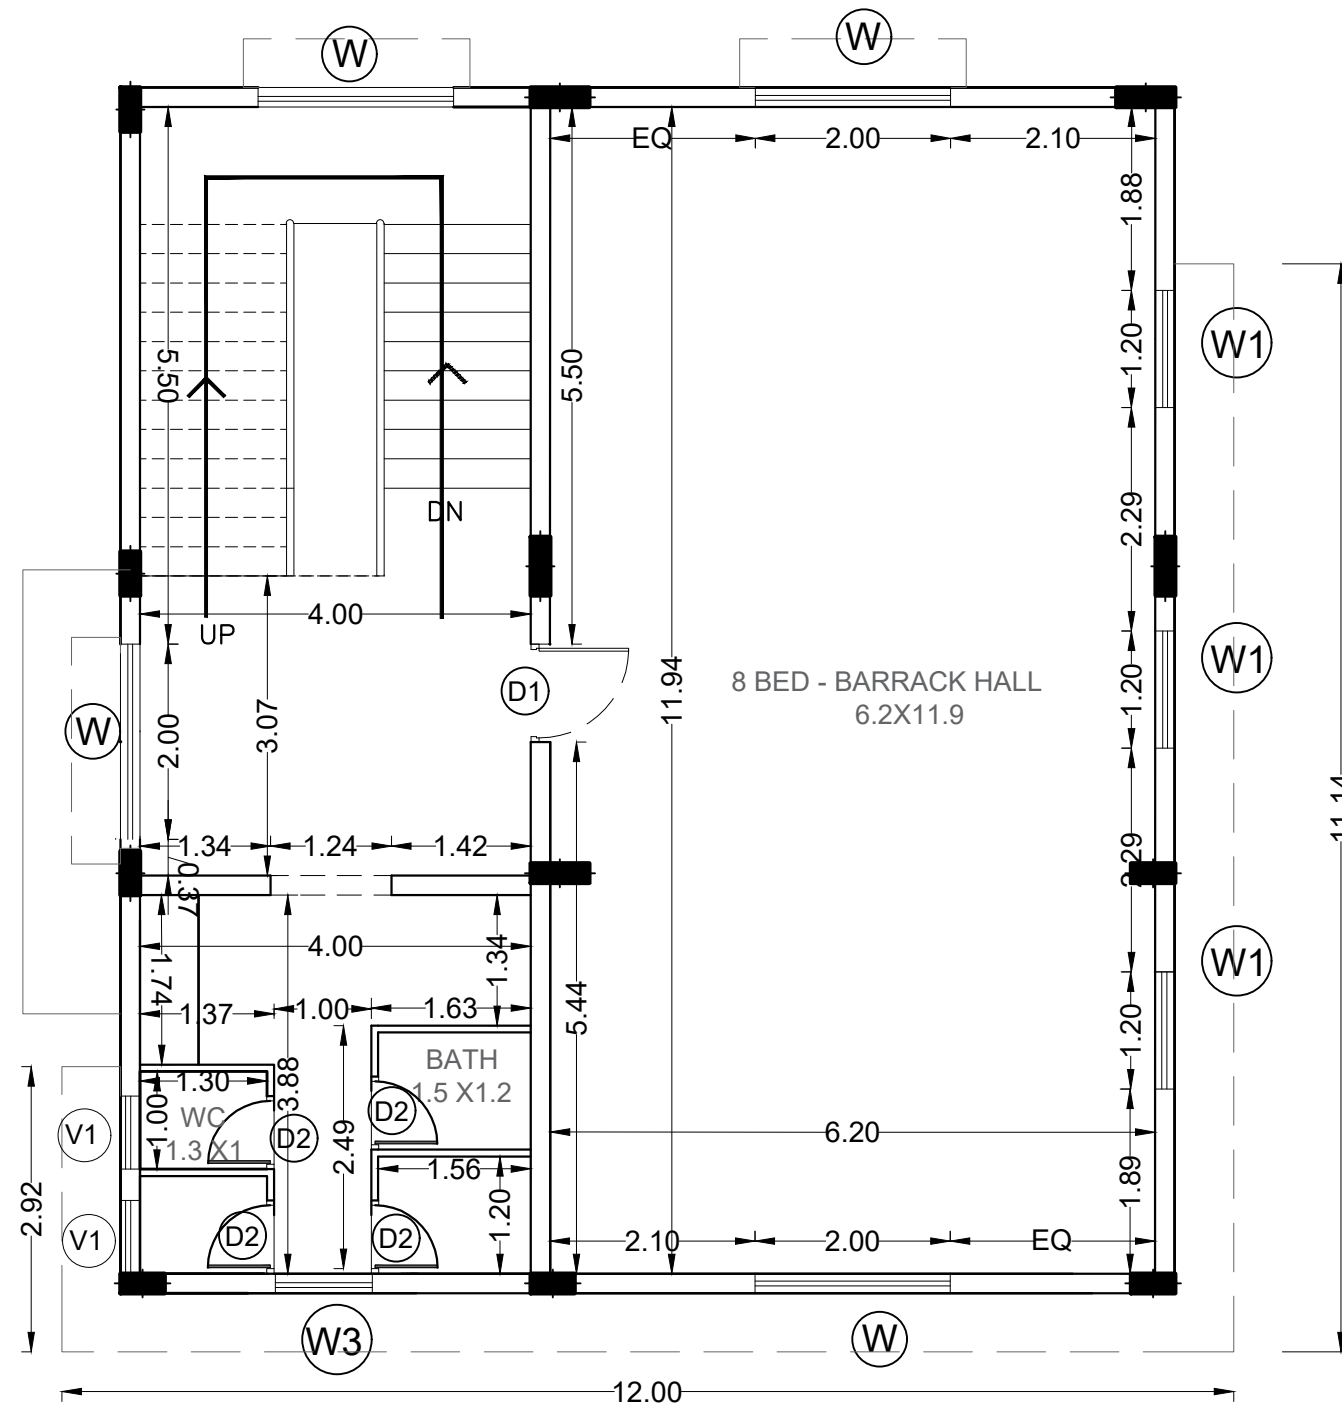


FIRST FLOOR PLAN

SCHEDULE OF OPENINGS		
DOORS		
	SIZE IN M	Nos
D1	1.00 X 2.10	1
D2	0.75 X 2.10 (TOILET)	4
WINDOWS		
W	2.00 X 1.50	4
W1	1.20 X 1.50	3
W3	1.00 X 0.75	1
VENTILATORS		
V1	0.75X 0.75	2

NOTE : ALL Chajja projection is 0.6m deep


NOTE : ALL DIMENSION IN METERS

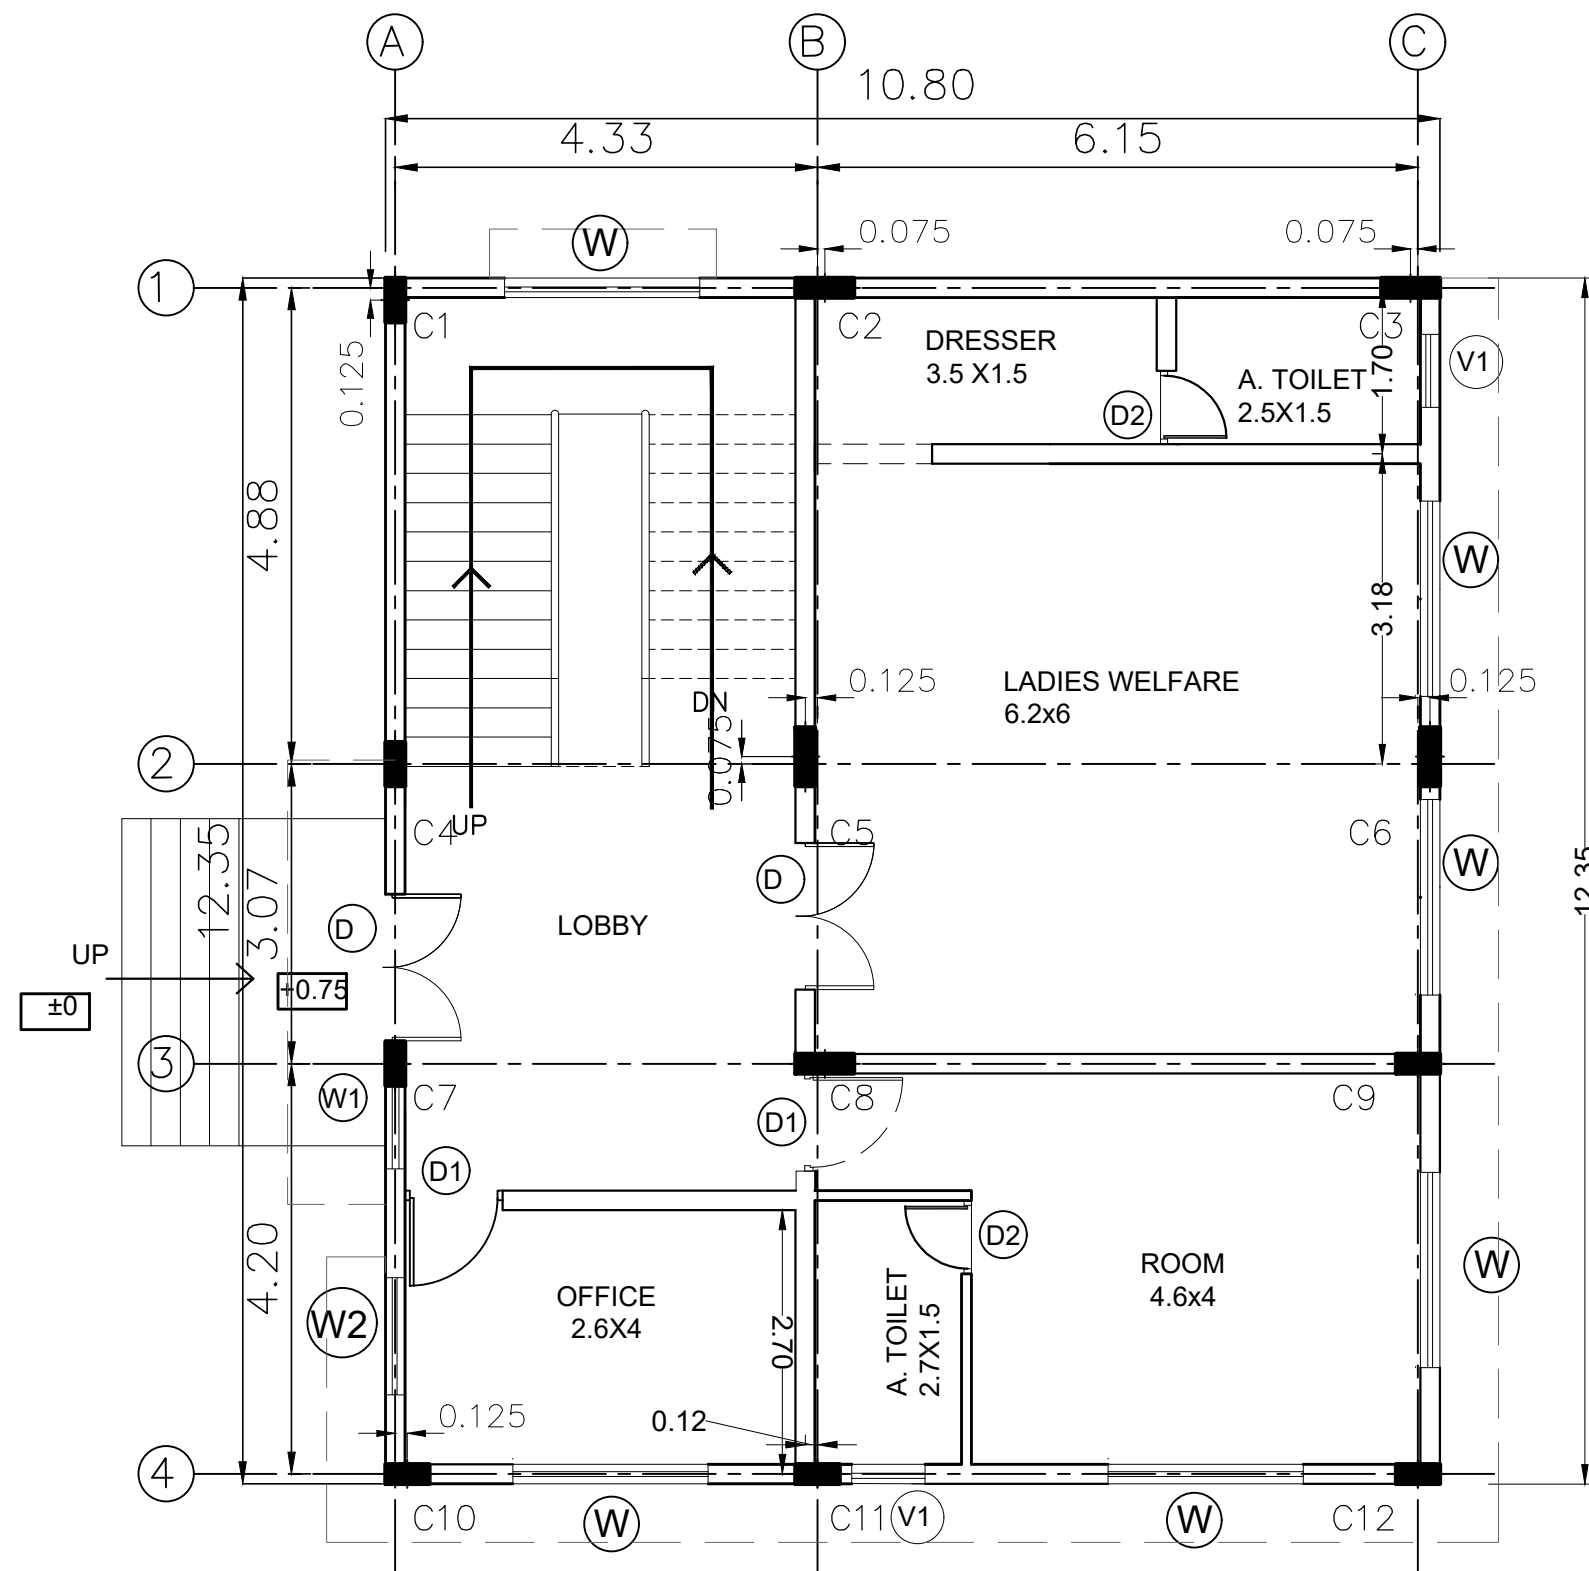

GROUND FLOOR PLAN

NOTE : ALL DIMENSION IN METERS




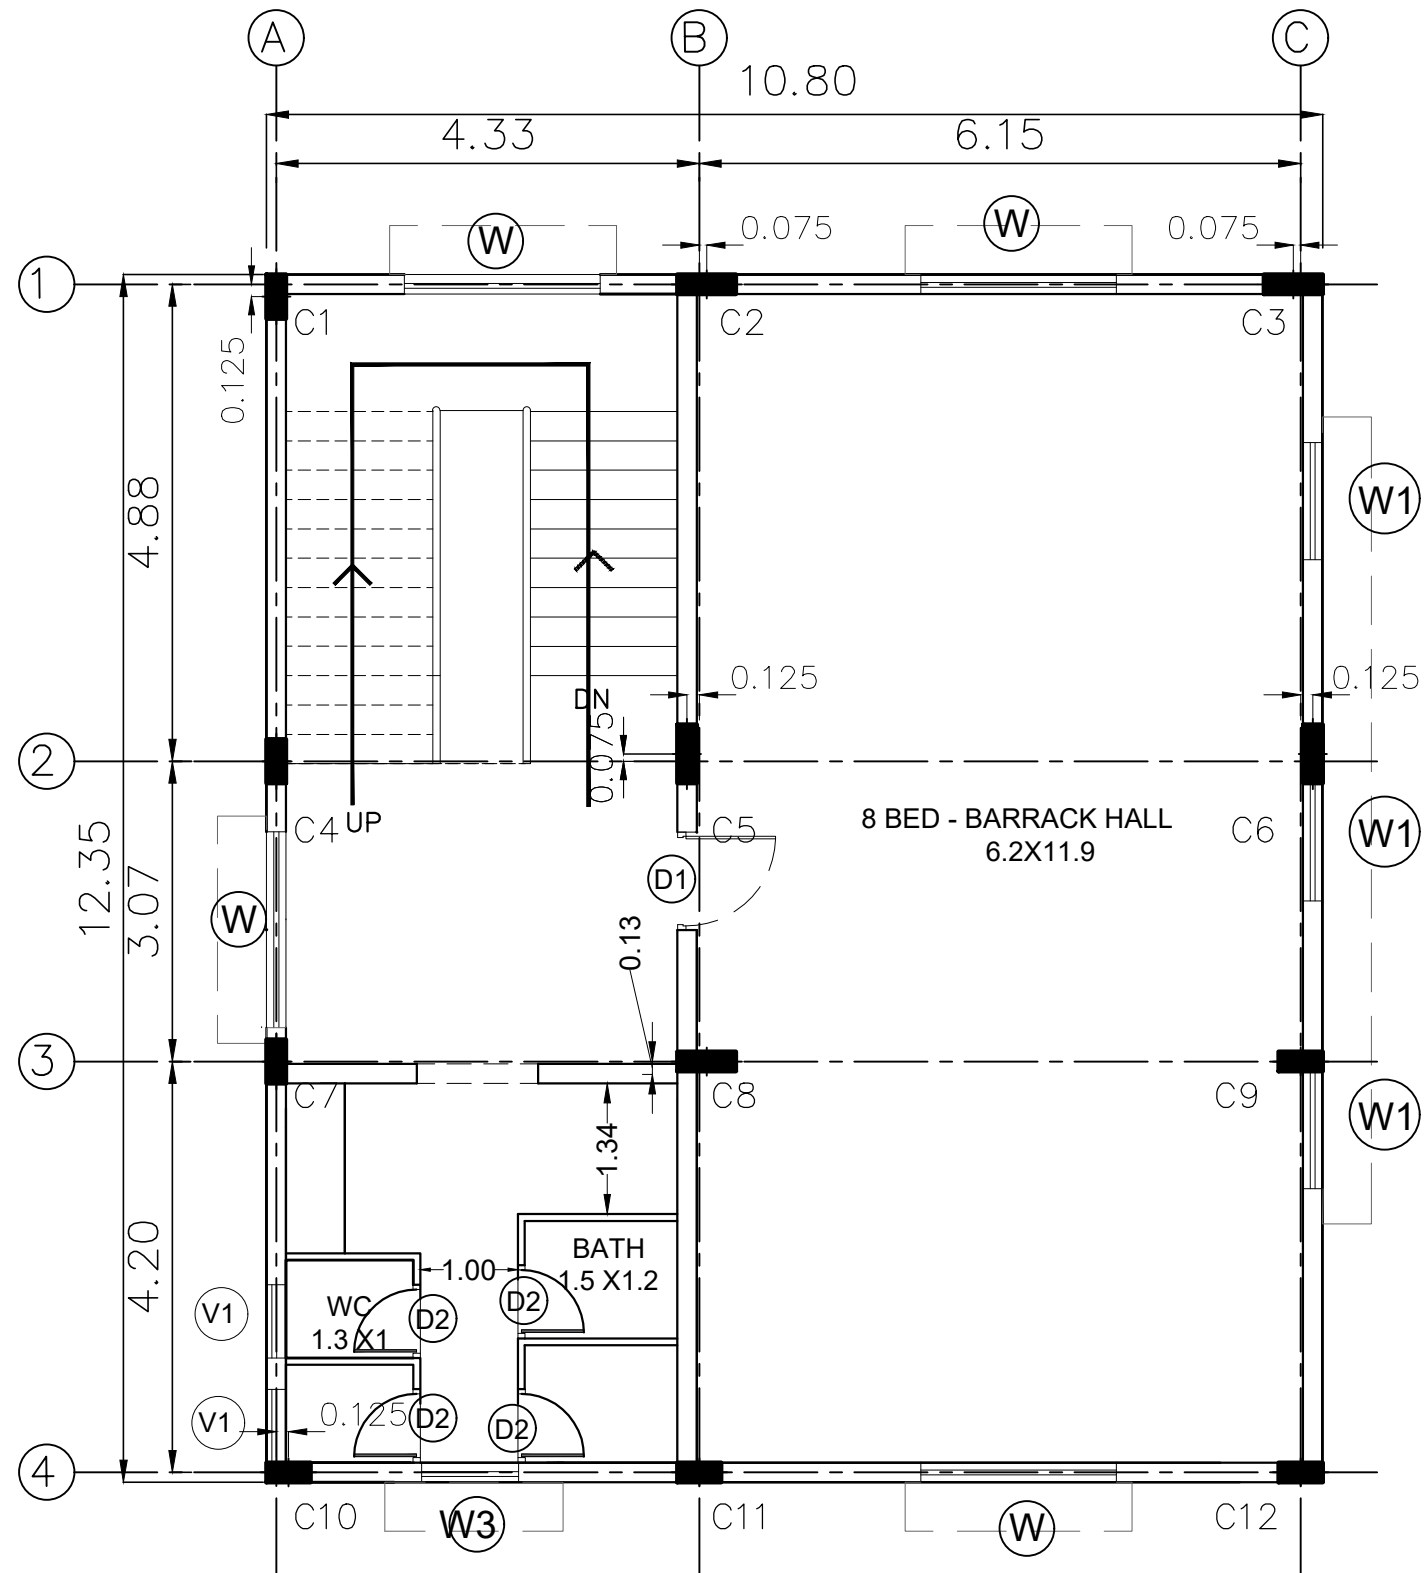



FIRST FLOOR PLAN

SCHEDULE OF OPENINGS		
DOORS		
	SIZE IN M	Nos
D1	1.00 X 2.10	1
D2	0.75 X 2.10 (TOILET)	4
WINDOWS		
W	2.00 X 1.50	4
W1	1.20 X 1.50	3
W3	1.00 X 0.75	1
VENTILATORS		
V1	0.75X 0.75	2

NOTE : ALL DIMENSION IN METERS

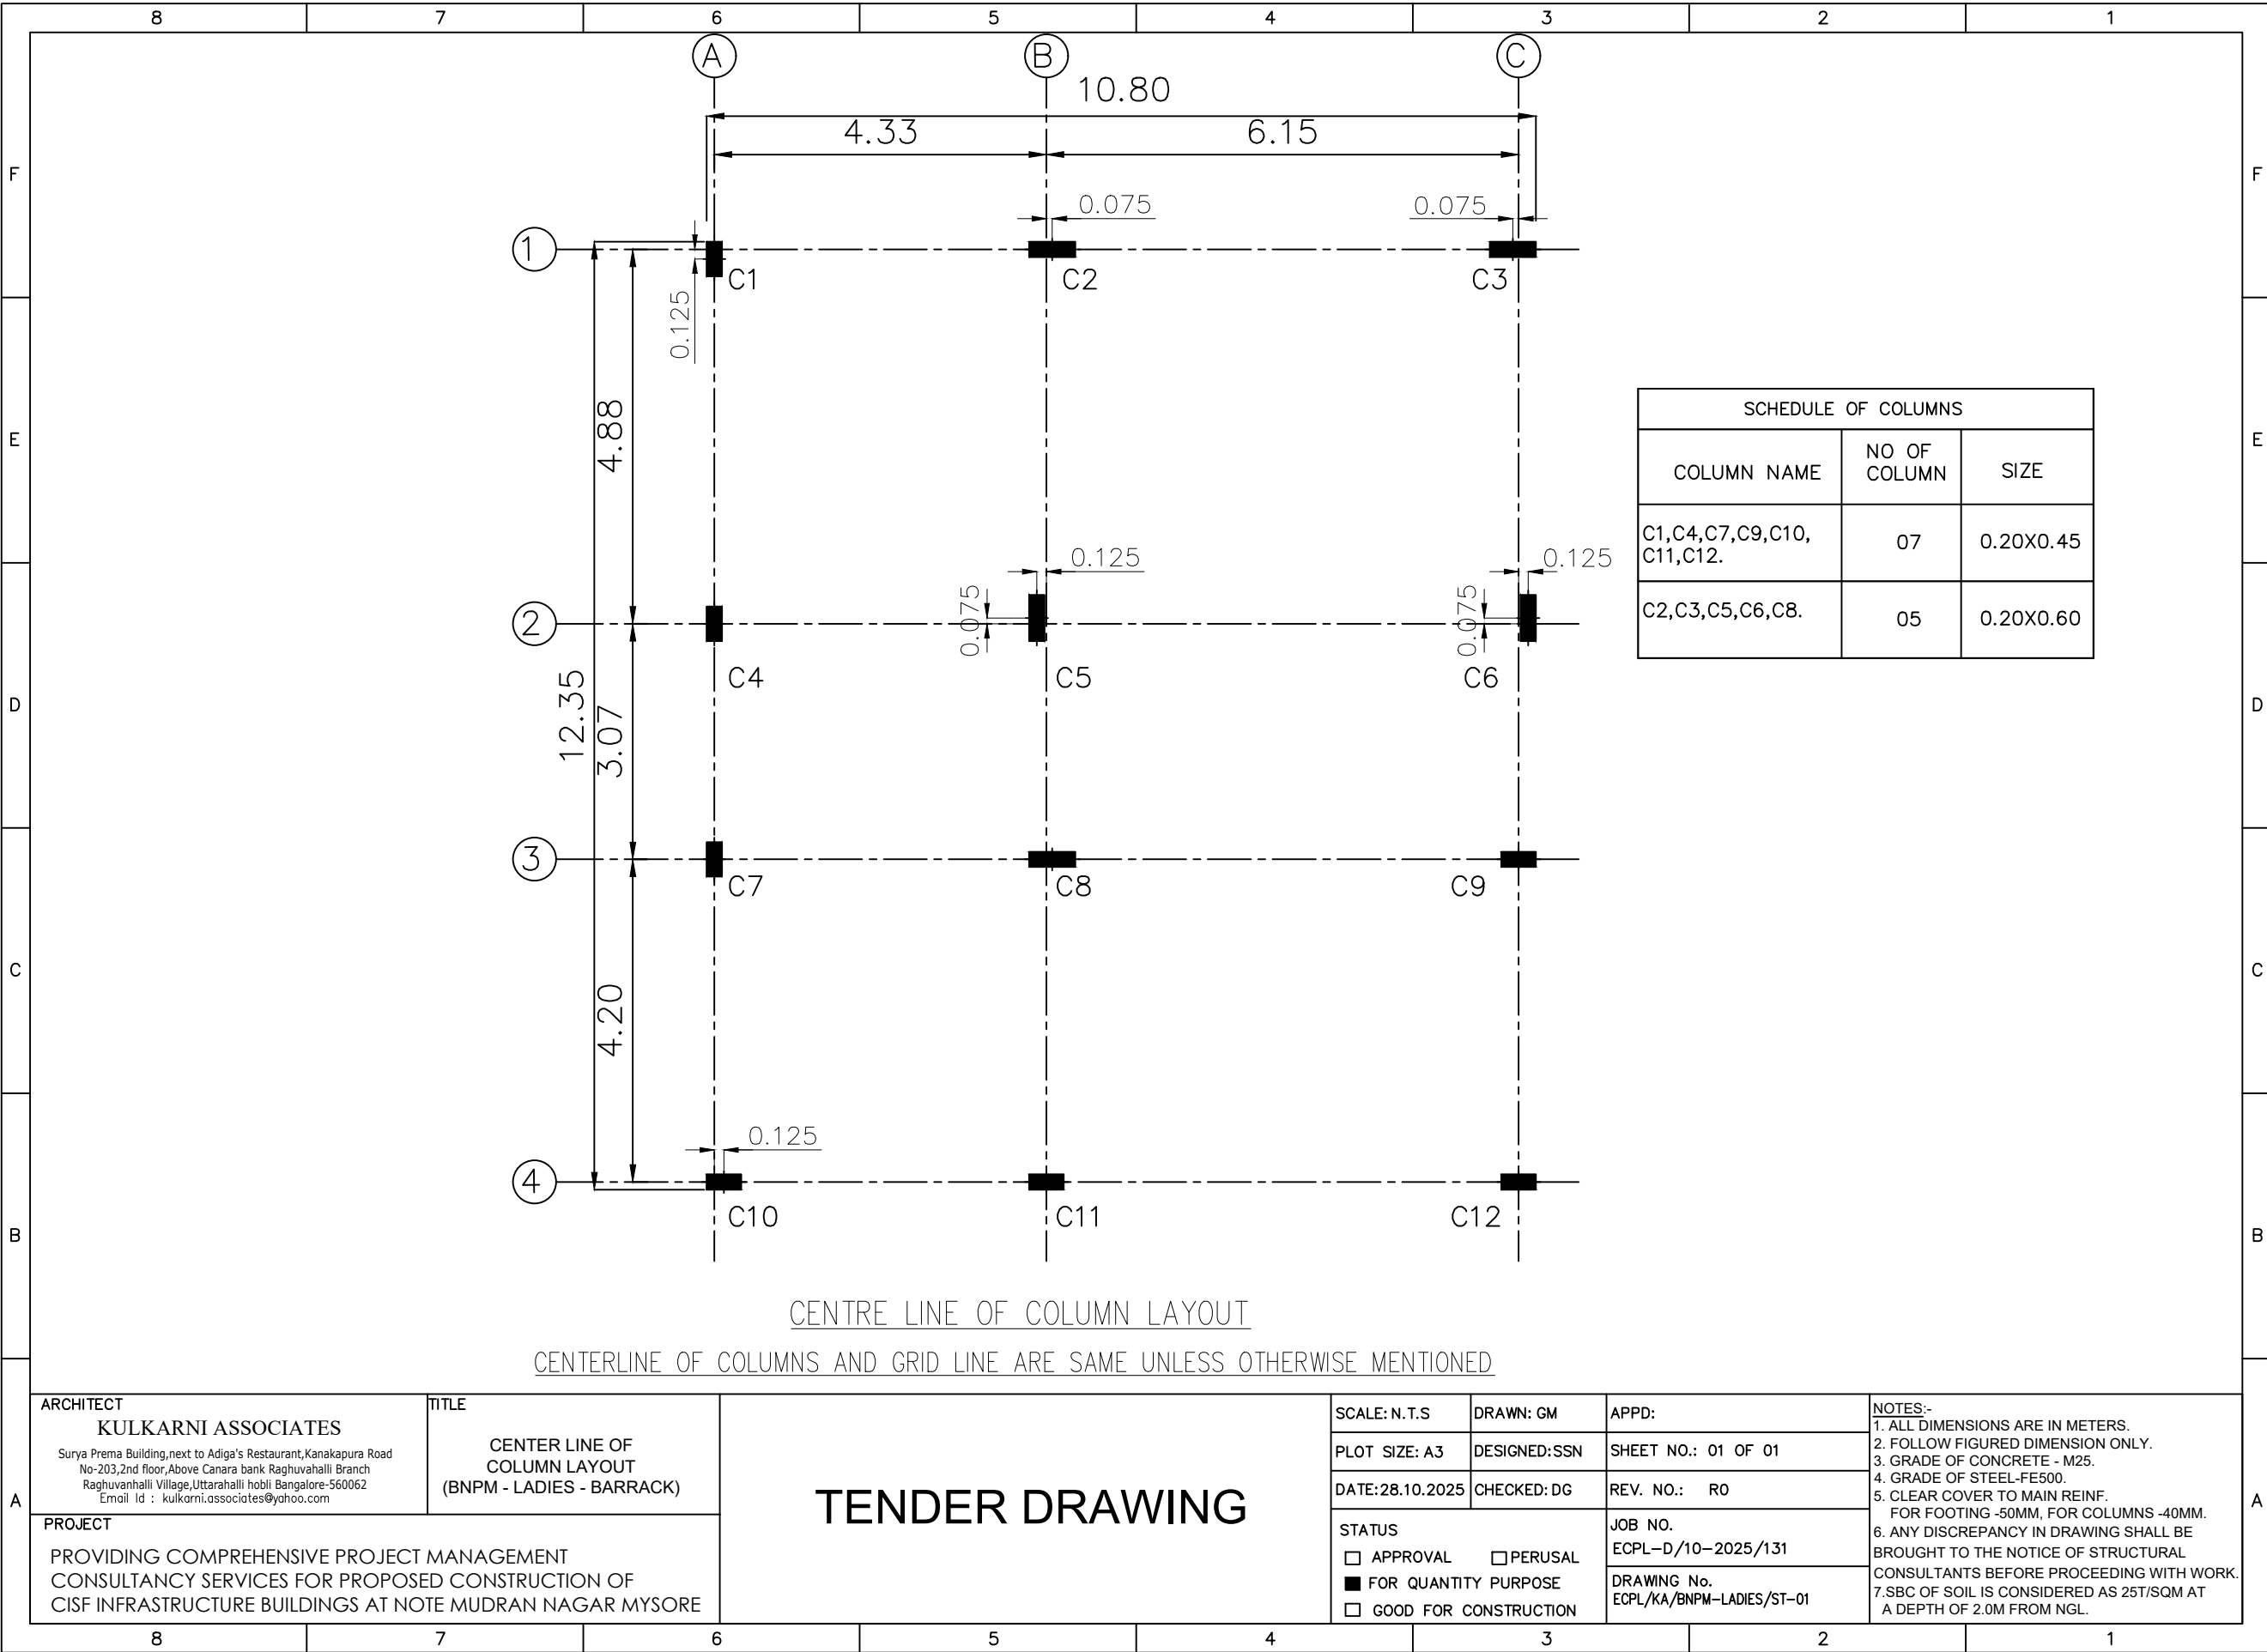


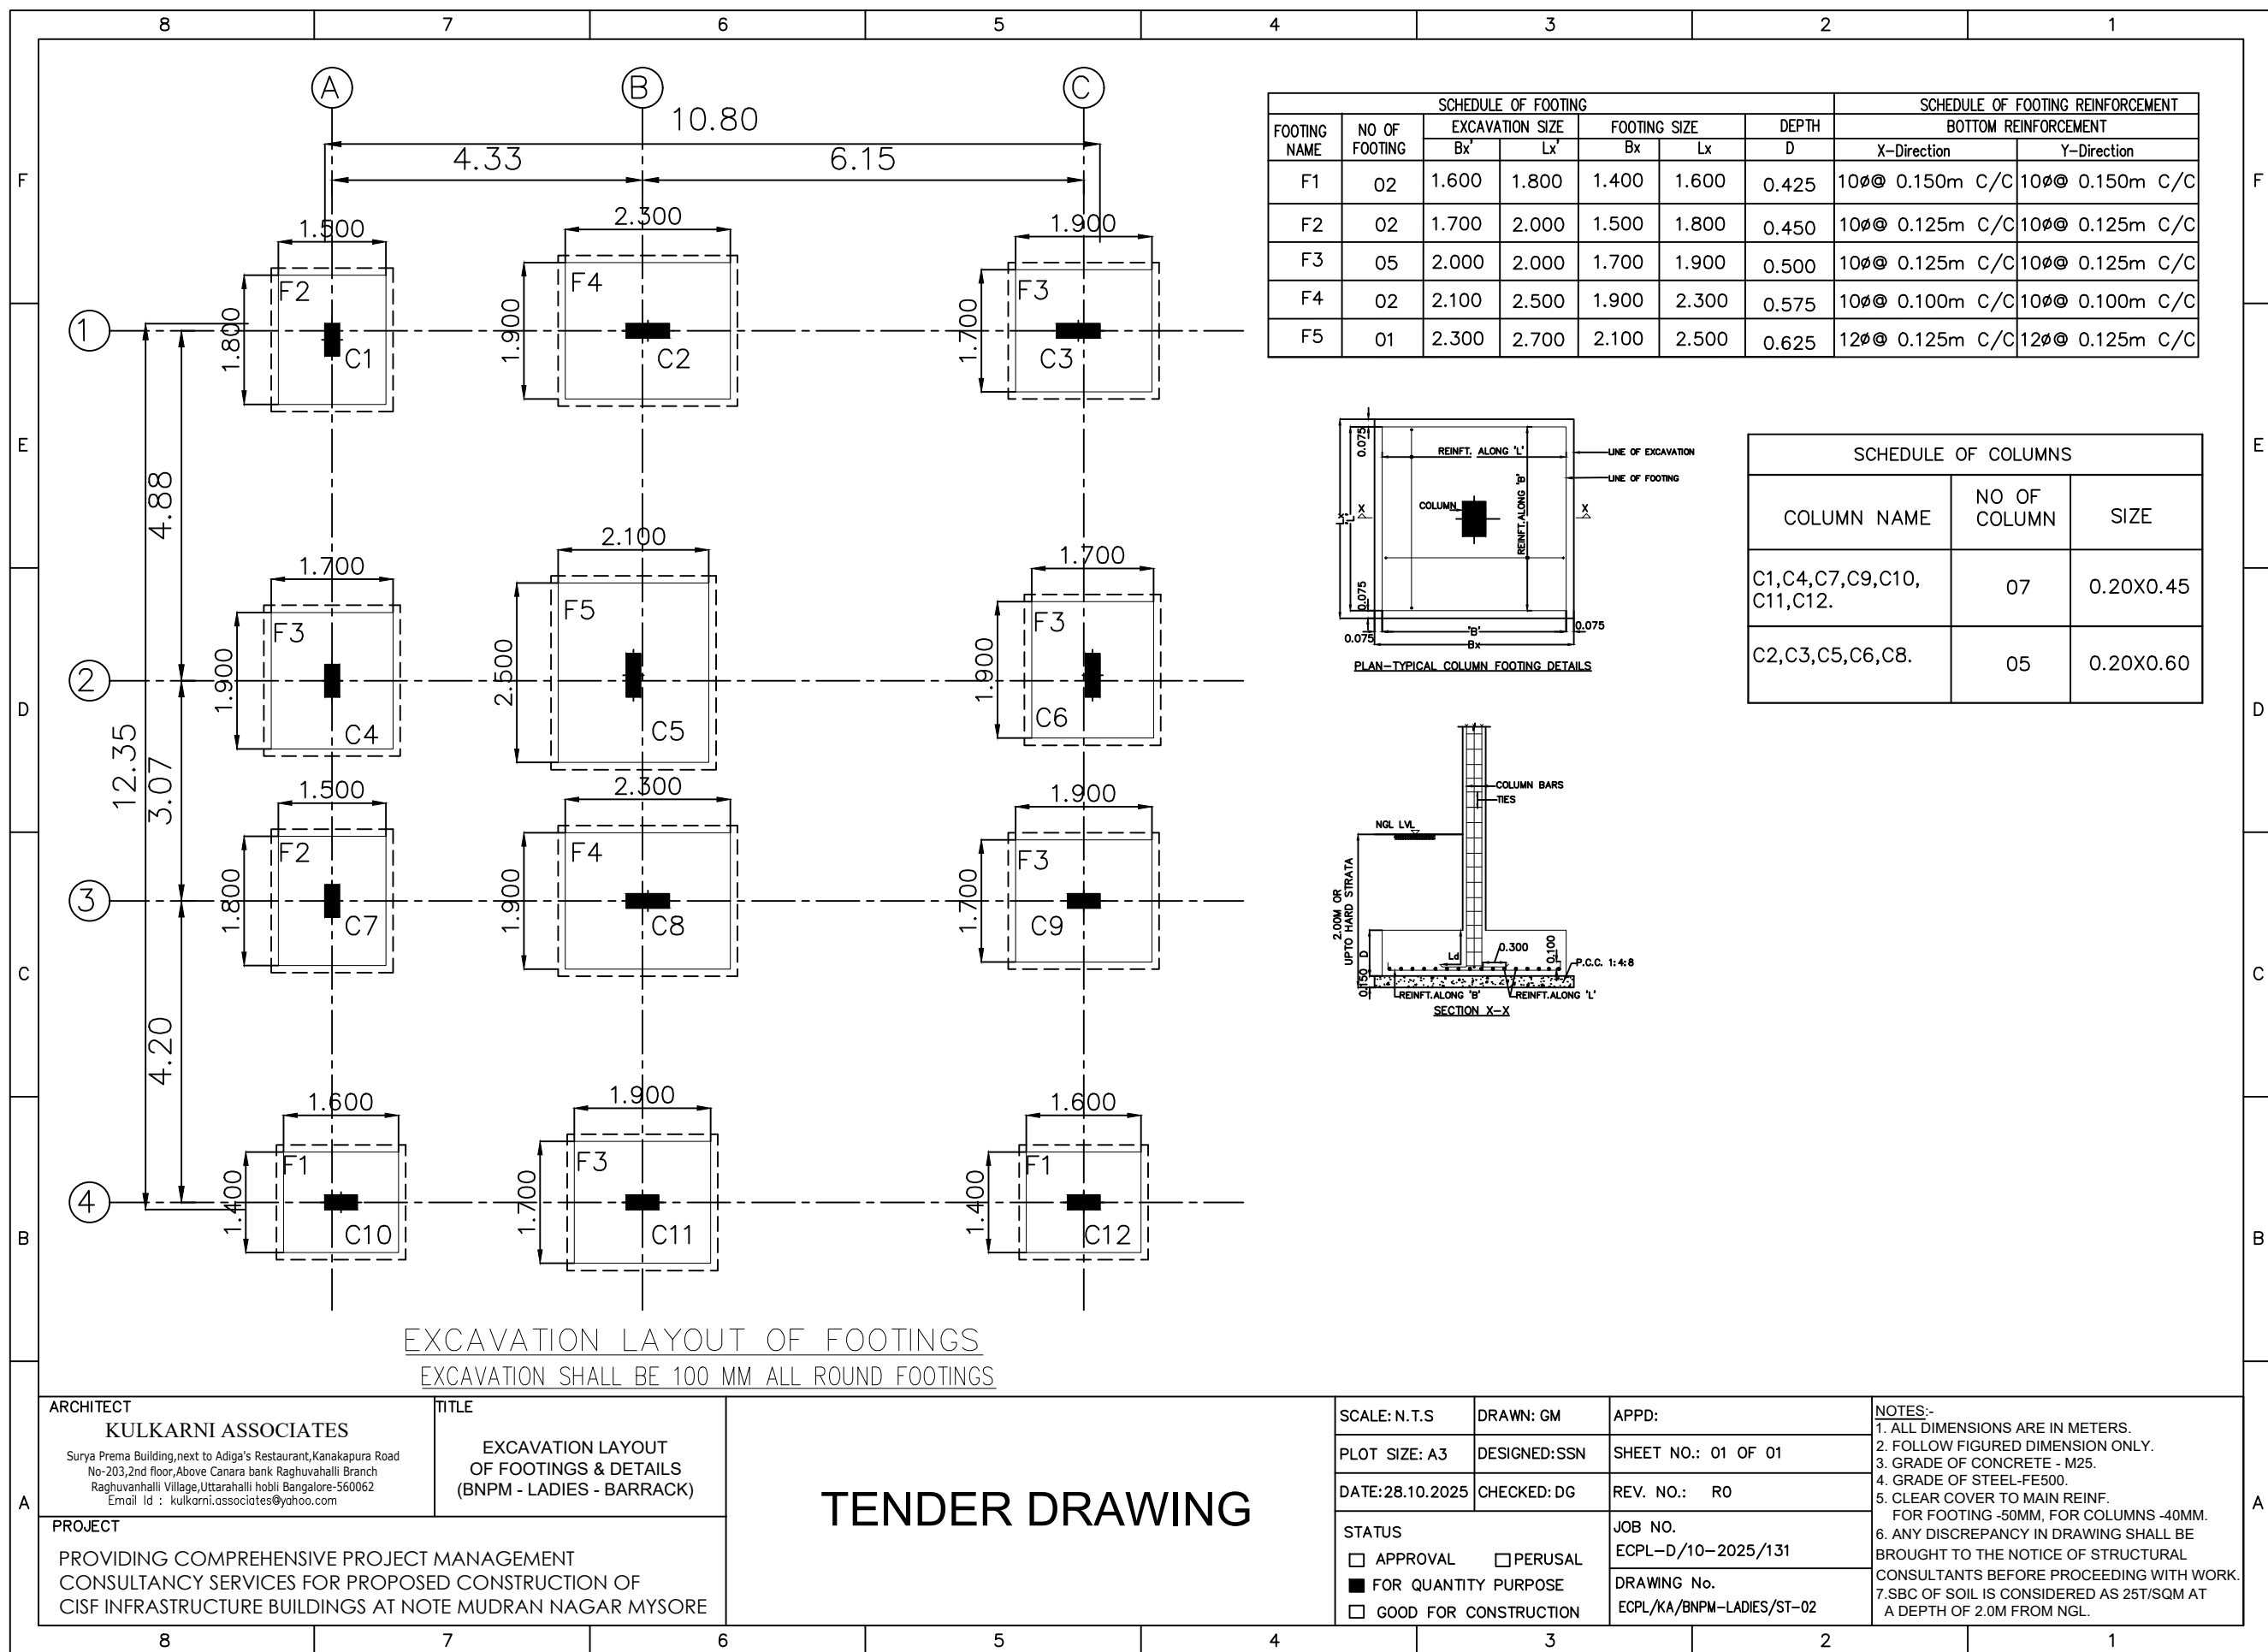



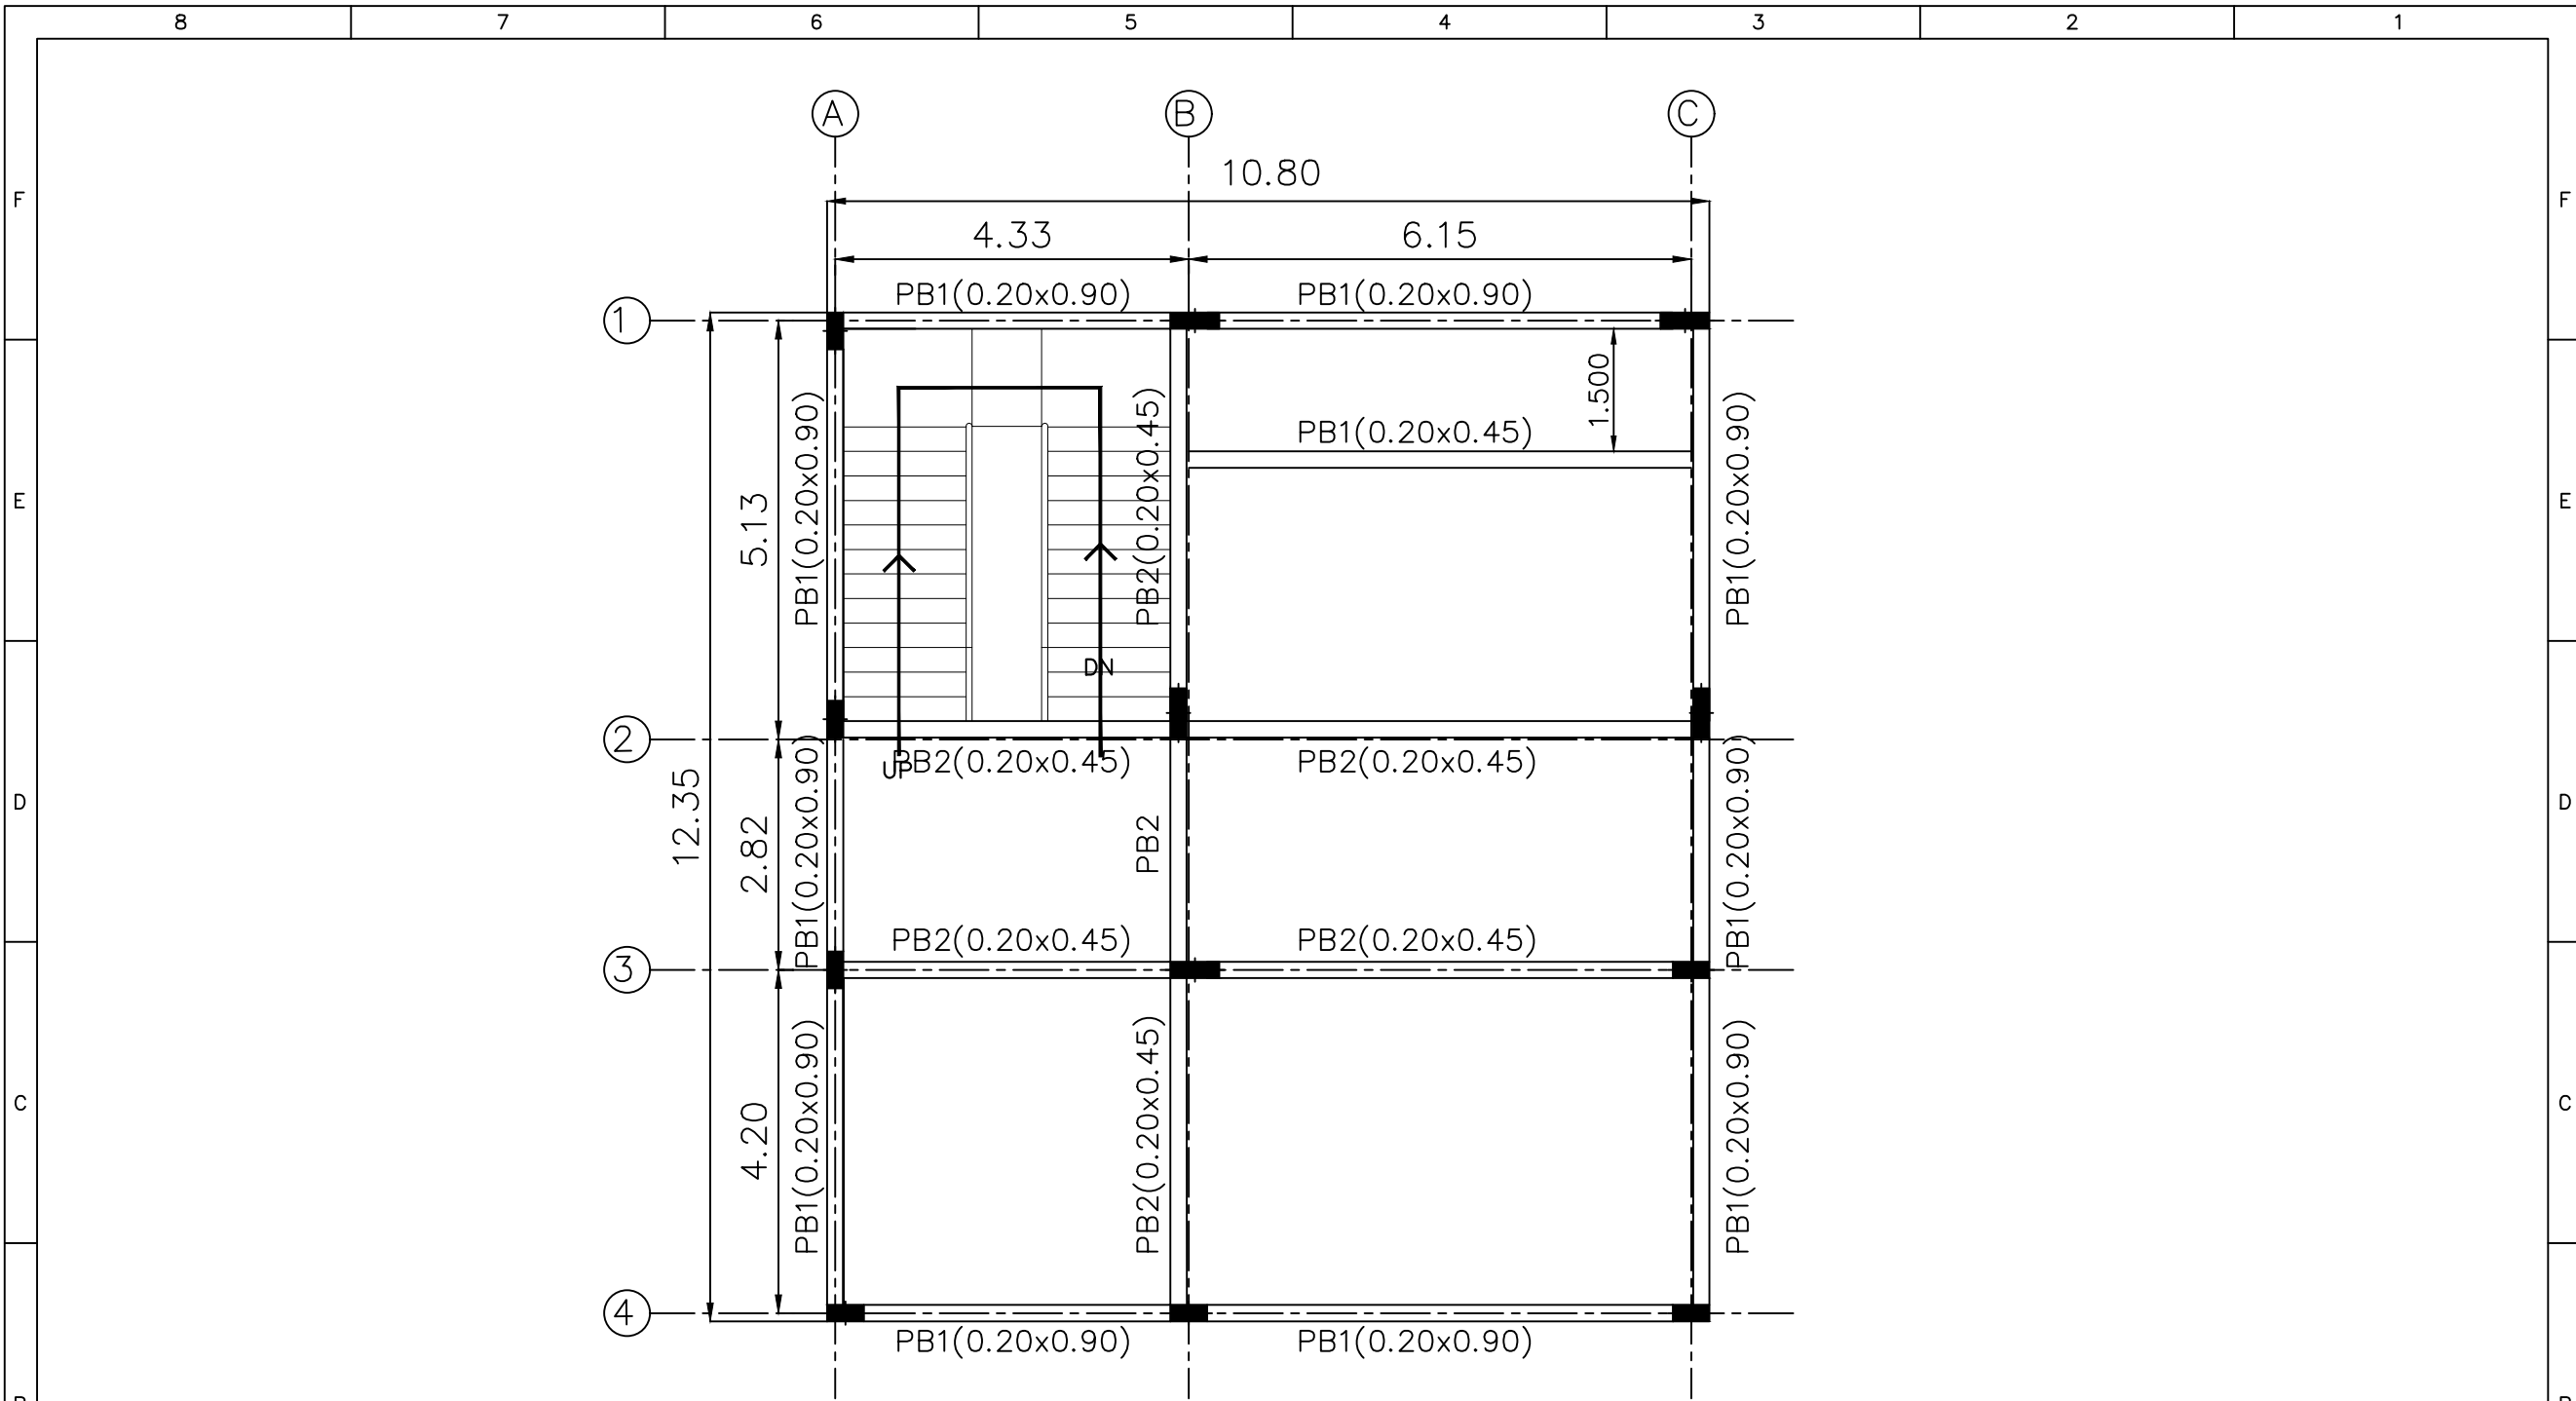


LAYOUT OF PLINTH BEAM

ARCHITECT KULKARNI ASSOCIATES Surya Prema Building, next to Adiga's Restaurant, Kanakapura Road No-203, 2nd floor, Above Canara bank Raghuvahalli Branch Raghuvahalli Village, Uttarahalli hobli Bangalore-560062 Email Id : kulkarni.associates@yahoo.com PROJECT PROVIDING COMPREHENSIVE PROJECT MANAGEMENT CONSULTANCY SERVICES FOR PROPOSED CONSTRUCTION OF CISF INFRASTRUCTURE BUILDINGS AT NOTE MUDRAN NAGAR MYSORE	TITLE LAYOUT OF PLINTH BEAM (BNPM - LADIES - BARRACK) TENDER DRAWING	SCALE: N.T.S	DRAWN: GM	APPD:	NOTES:- 1. ALL DIMENSIONS ARE IN METERS. 2. FOLLOW FIGURED DIMENSION ONLY. 3. GRADE OF CONCRETE - M25. 4. GRADE OF STEEL-FE500. 5. CLEAR COVER TO MAIN REINF. FOR BEAM -30MM, FOR SLAB -25MM, FOR COLUMNS -40MM. 6. ANY DISCREPANCY IN DRAWING SHALL BE BROUGHT TO THE NOTICE OF STRUCTURAL CONSULTANTS BEFORE PROCEEDING WITH WORK.
		PLOT SIZE: A3	DESIGNED:SSN	SHEET NO.: 01 OF 01	
		DATE:28.10.2025	CHECKED: DG	REV. NO.: R0	
		STATUS ☐ APPROVAL ☐ PERUSAL ☒ FOR QUANTITY PURPOSE ☐ GOOD FOR CONSTRUCTION		JOB NO. ECPL-D/10-2025/131 DRAWING No. ECPL/KA/BNPM-LADIES/ST-03	

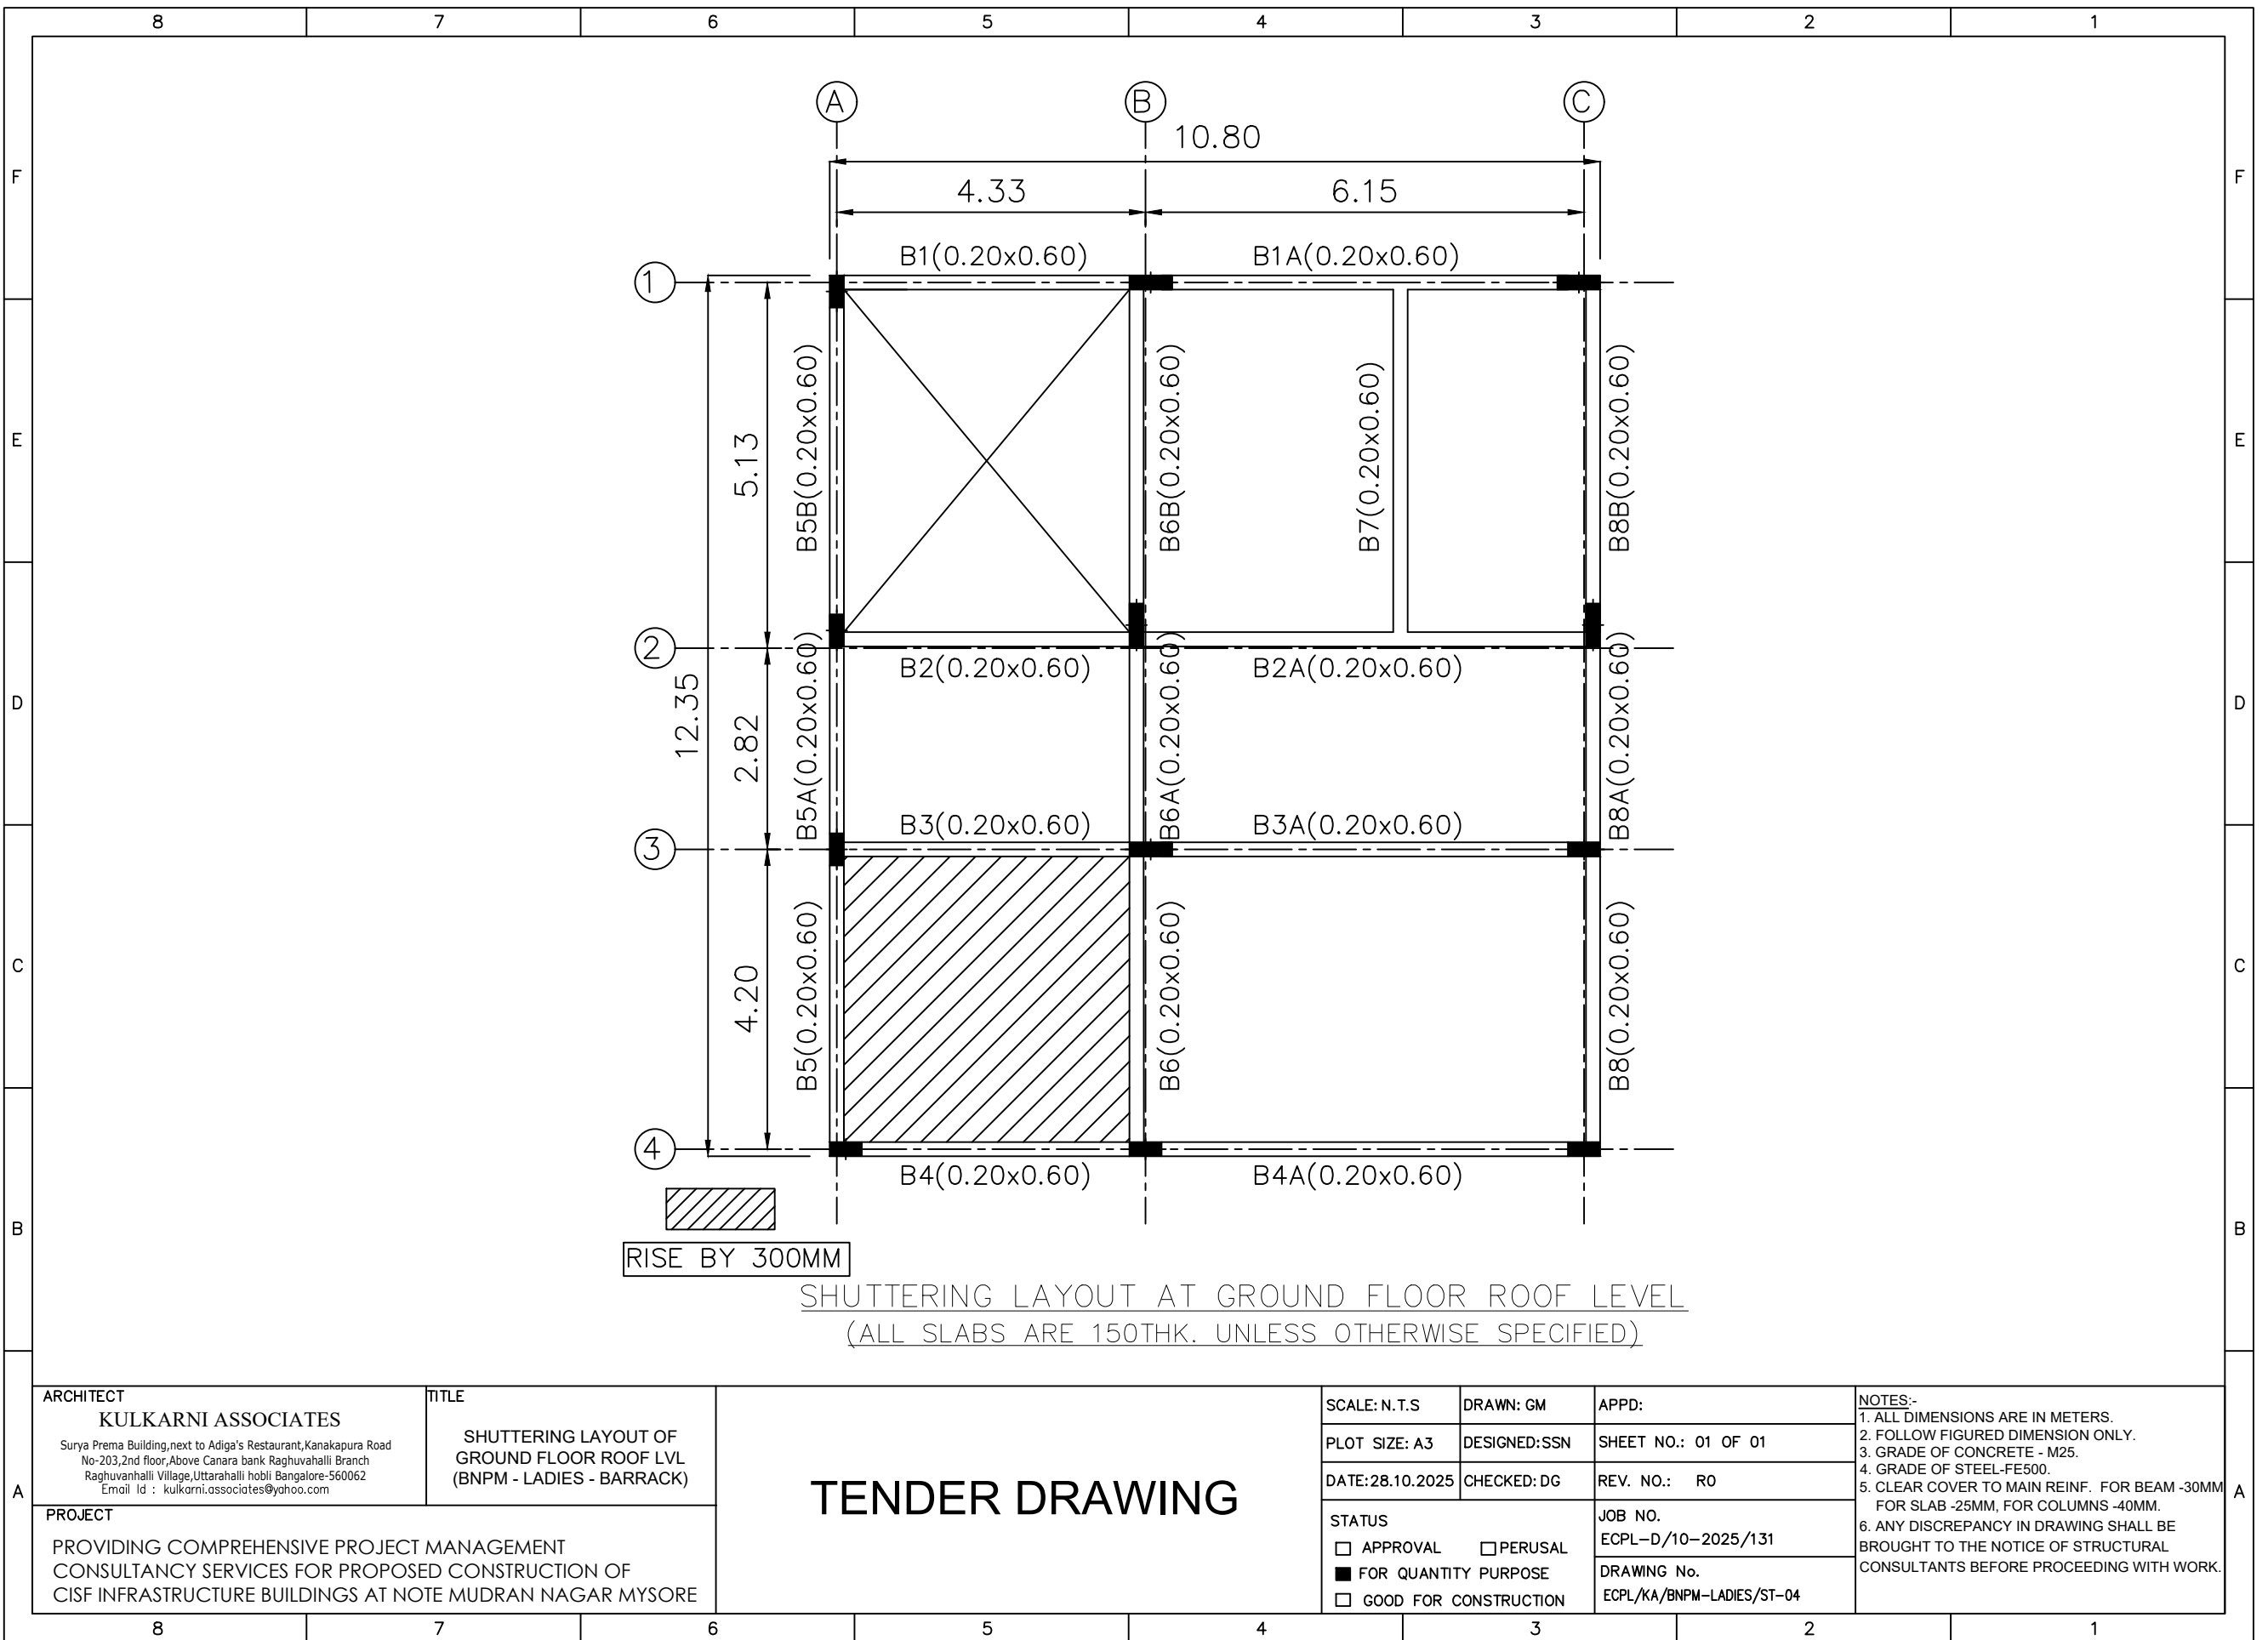

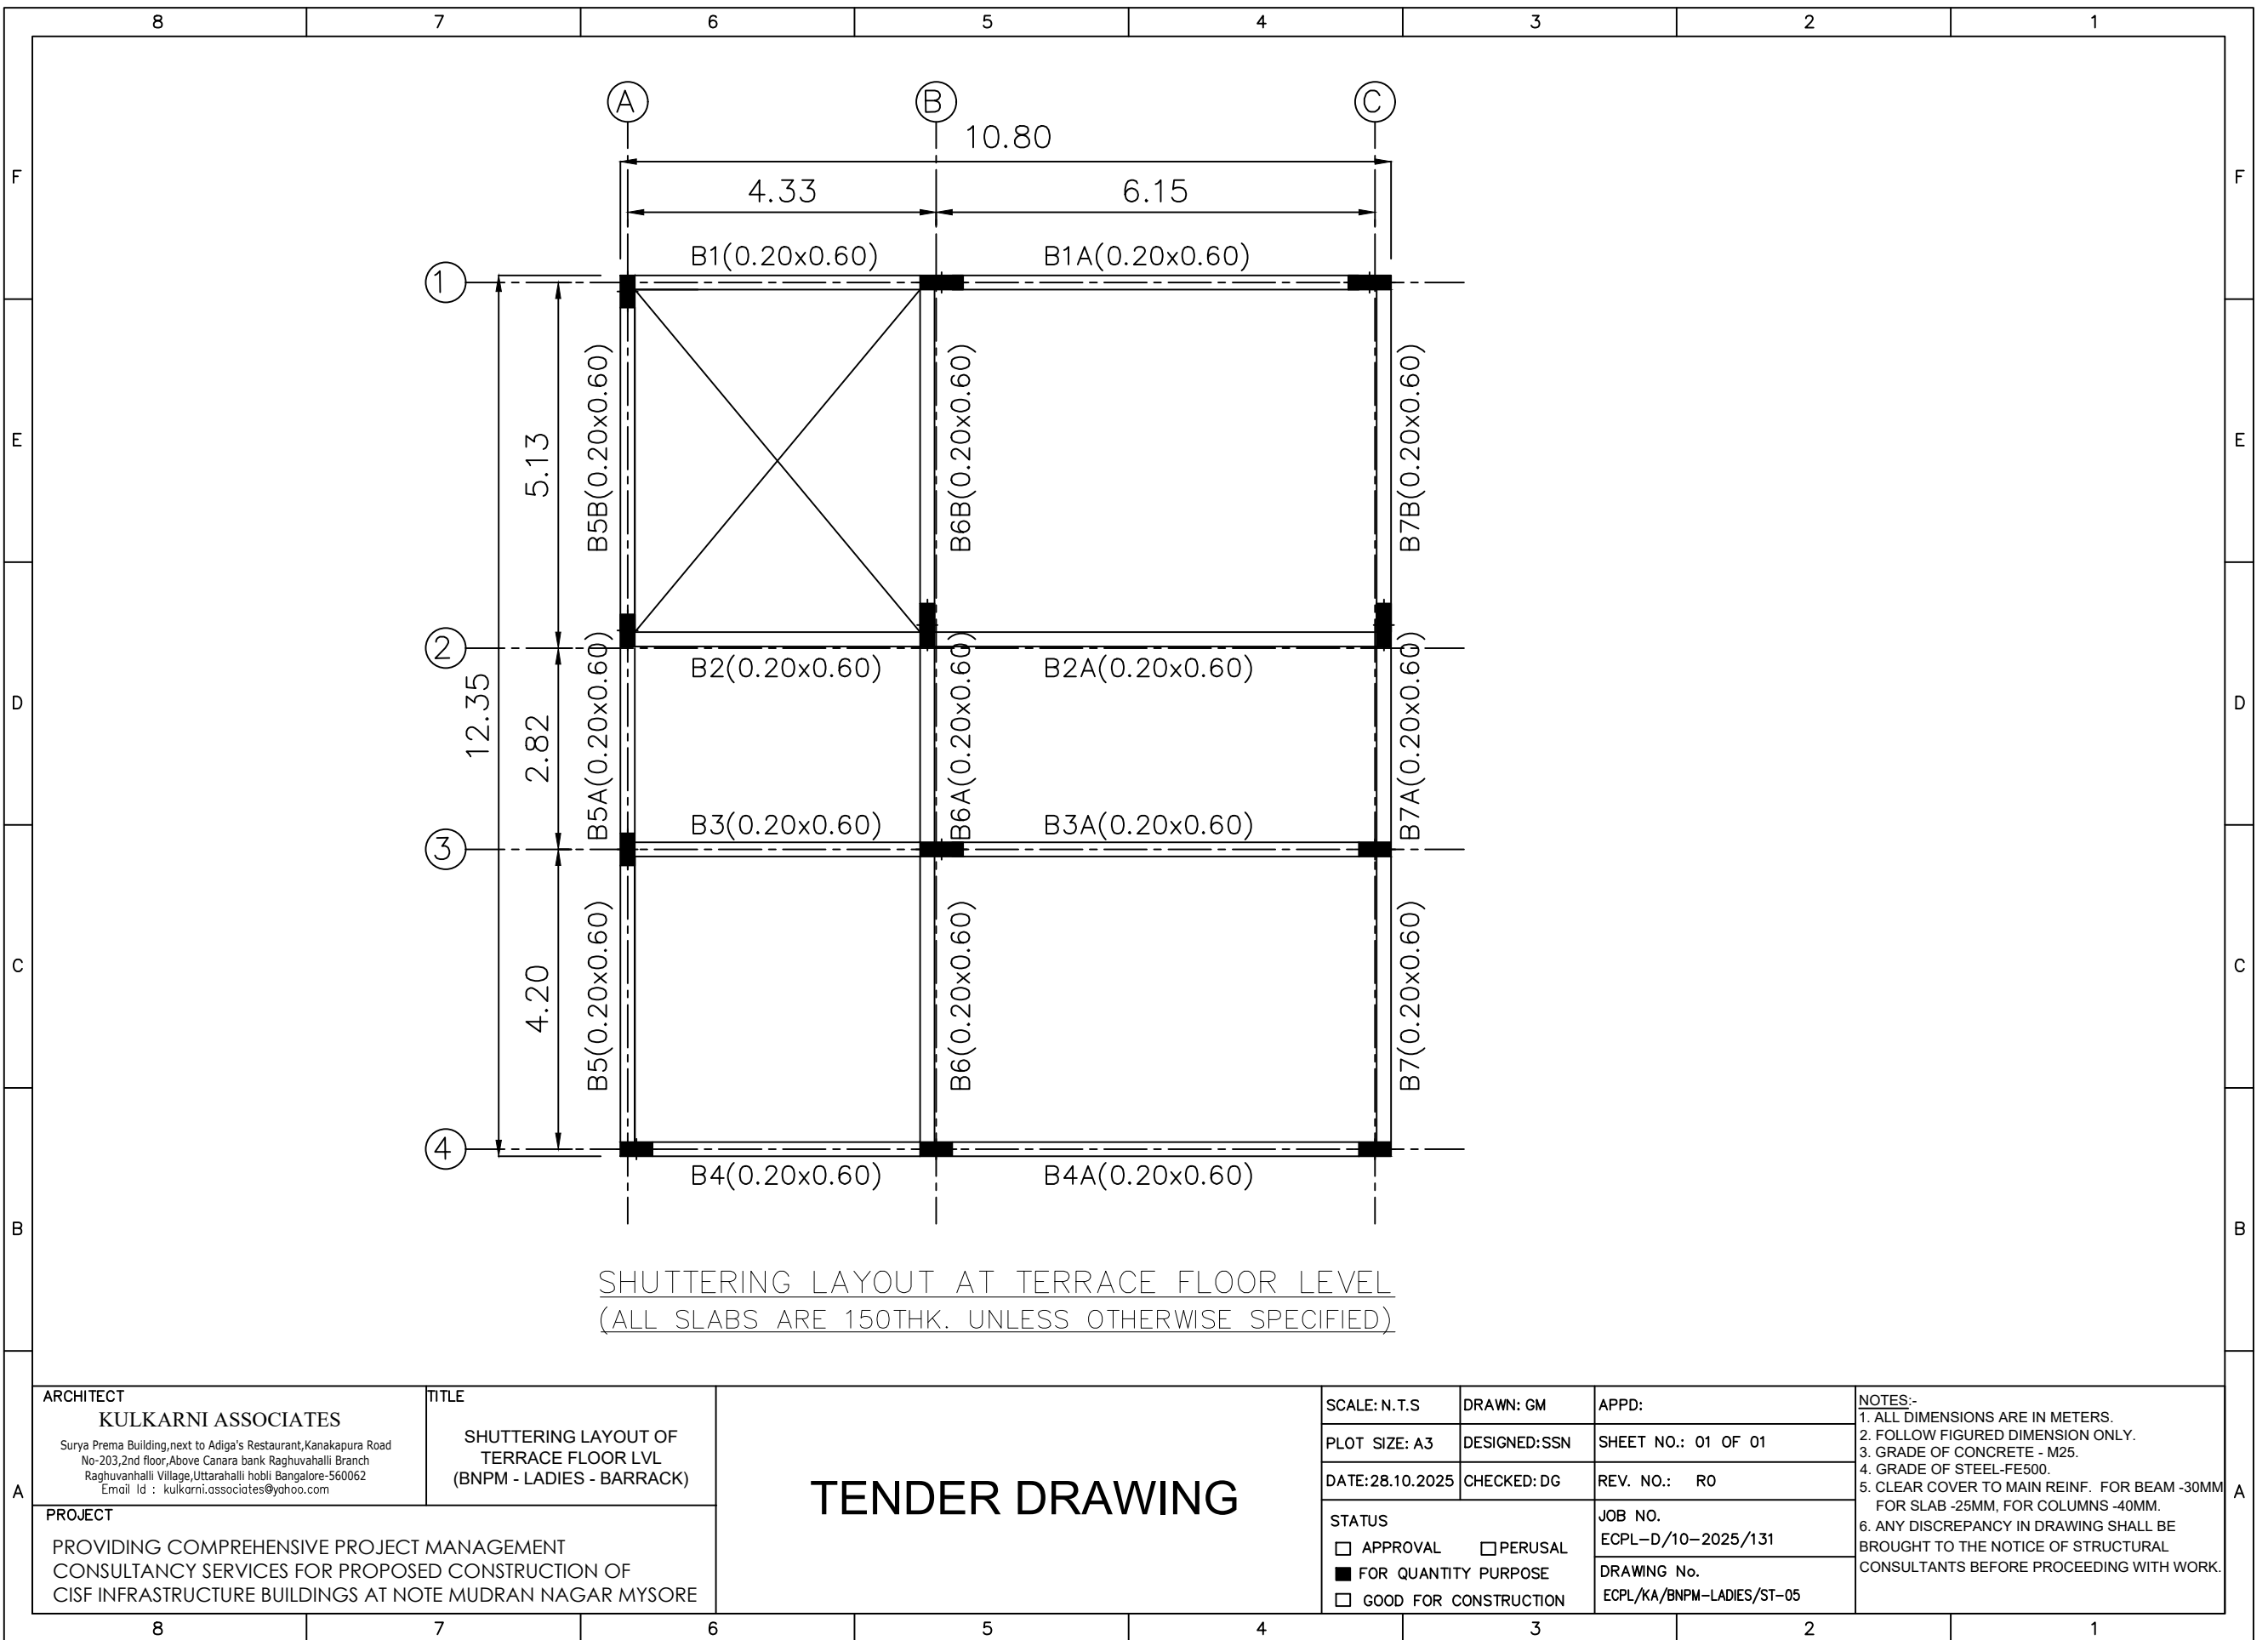

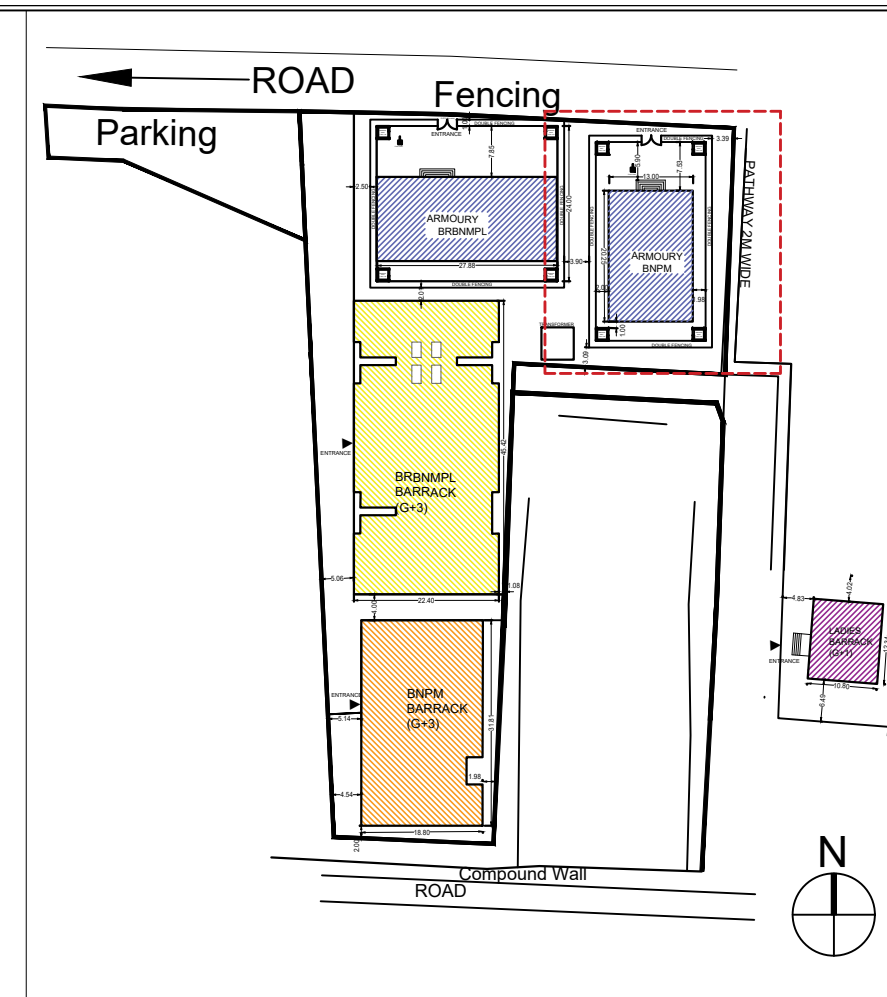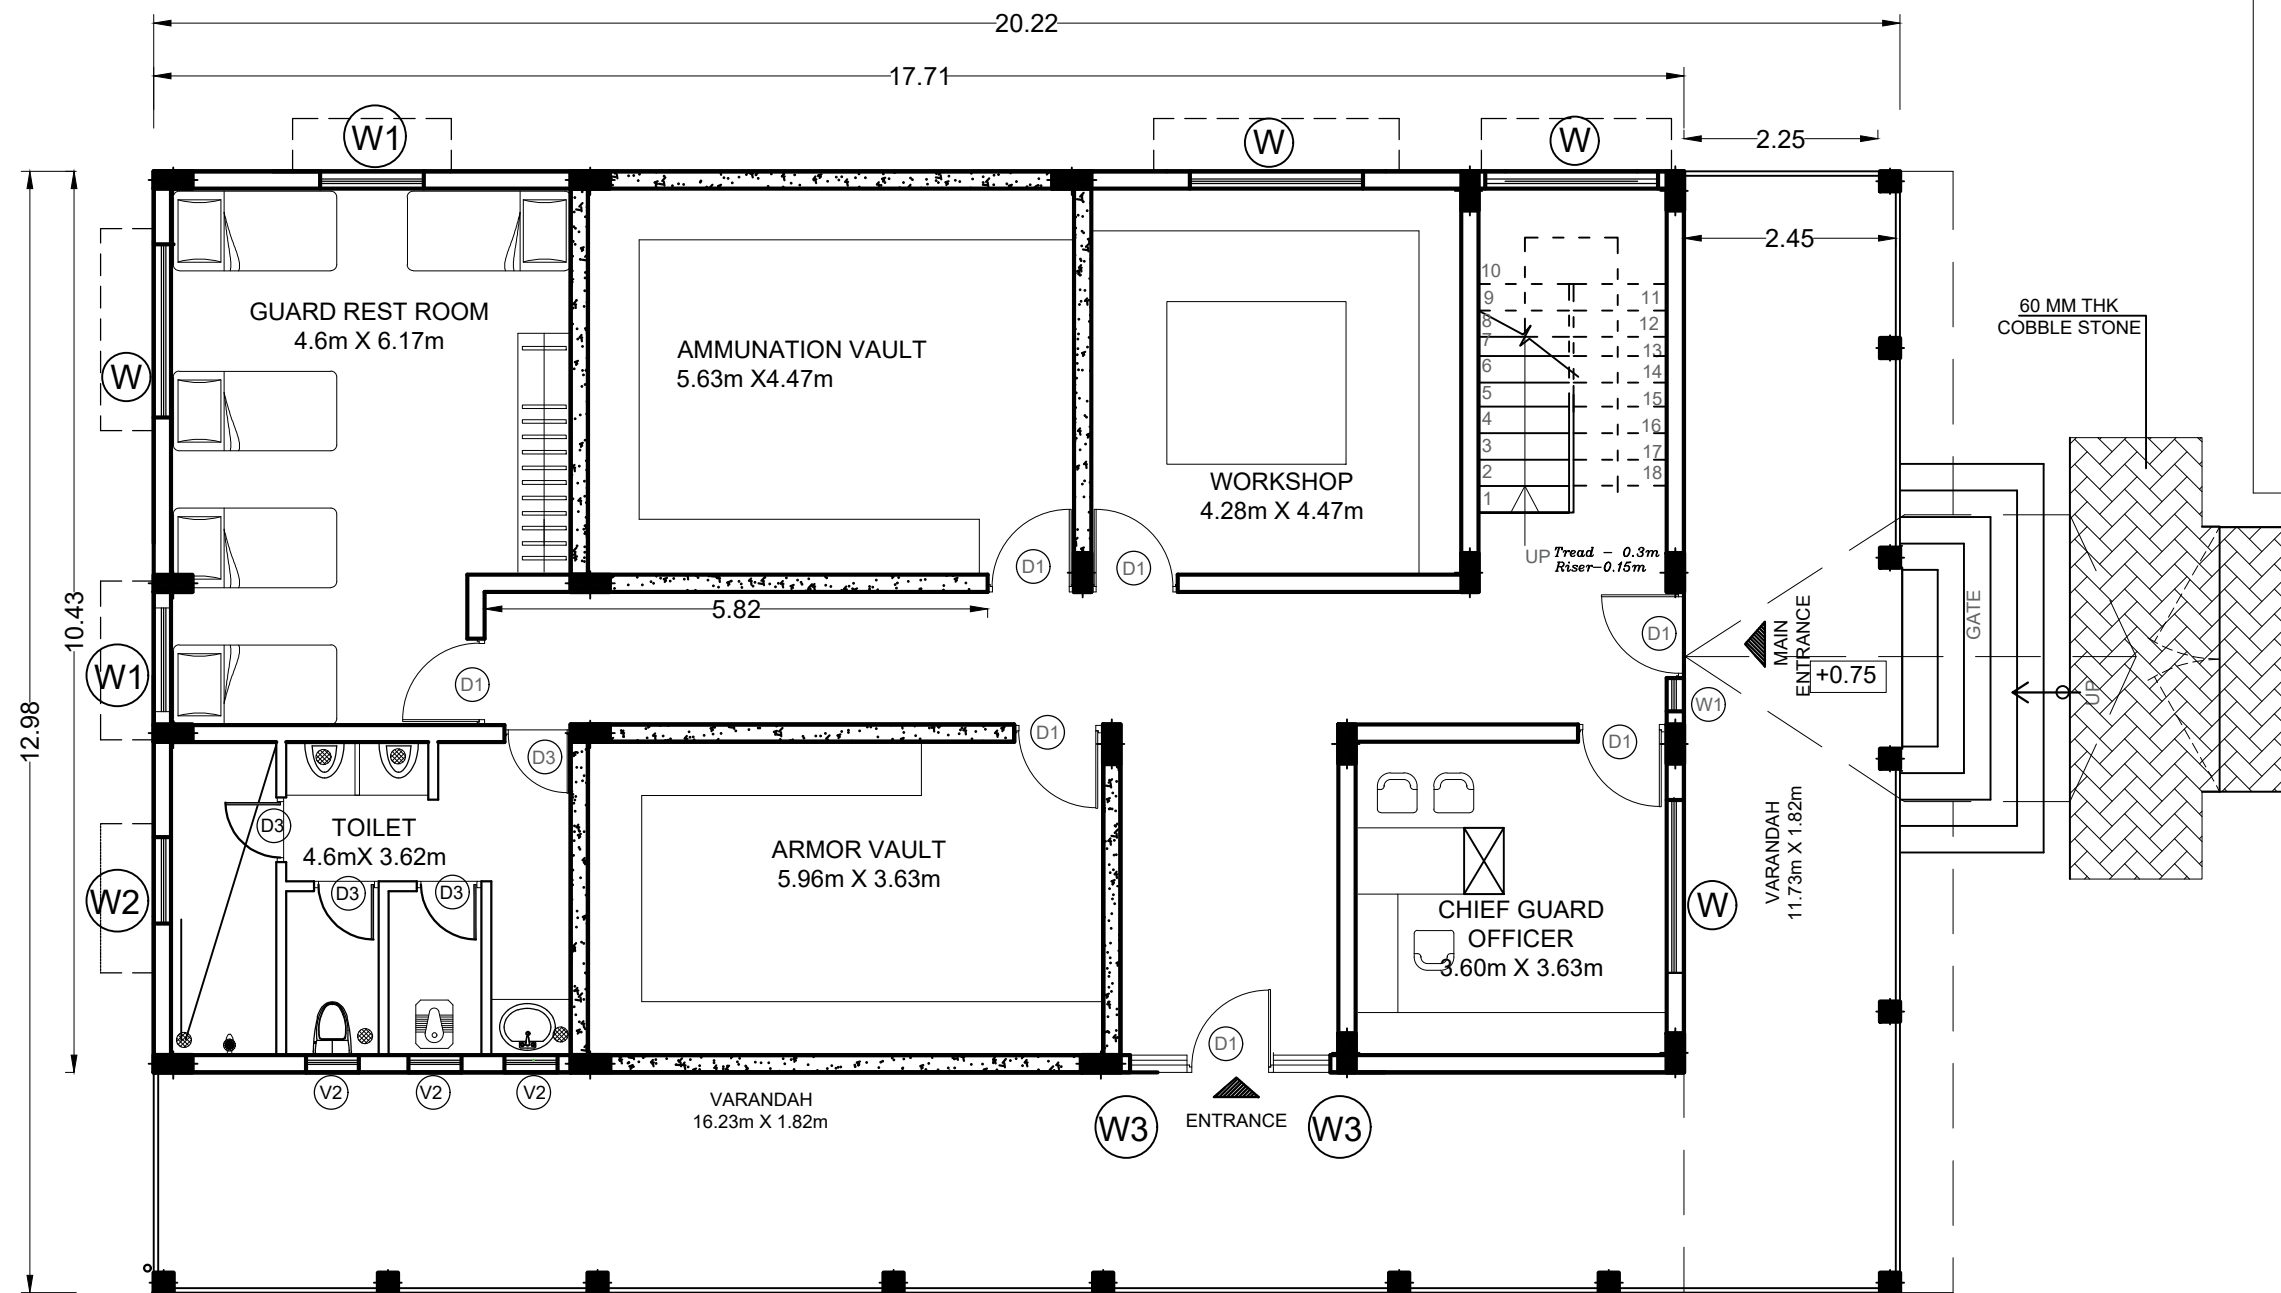

NOTE : ALL DIMENSION IN METERS

PROJECT :
PROVIDING COMPREHENSIVE PROJECT
MANAGEMENT CONSULTANCY SERVICES
FOR PROPOSED CONSTRUCTION OF CISF
INFRASTRUCTURE BUILDINGS
AT NOTE MUDRAN NAGAR MYSORE

TENDER DRAWING

Page 70 of 129

 
BNPM - ARMOUR HOUSE PLAN

Date : 10-10-2025

Drawn by: AMRUTHA

Checked by: Ar. Kavitha


Rev Date:



ARCHITECTS :
KULKARNI ASSOCIATES

Surya Prema Building, next to Adiga's Restaurant, Kanakapura Road
No-203, 2nd floor, Above Canara bank Raghuvahalli Branch
Raghuvahalli Village, Uttarahalli hobli Bangalore-560062

Email Id : kulkarni.associates@yahoo.com

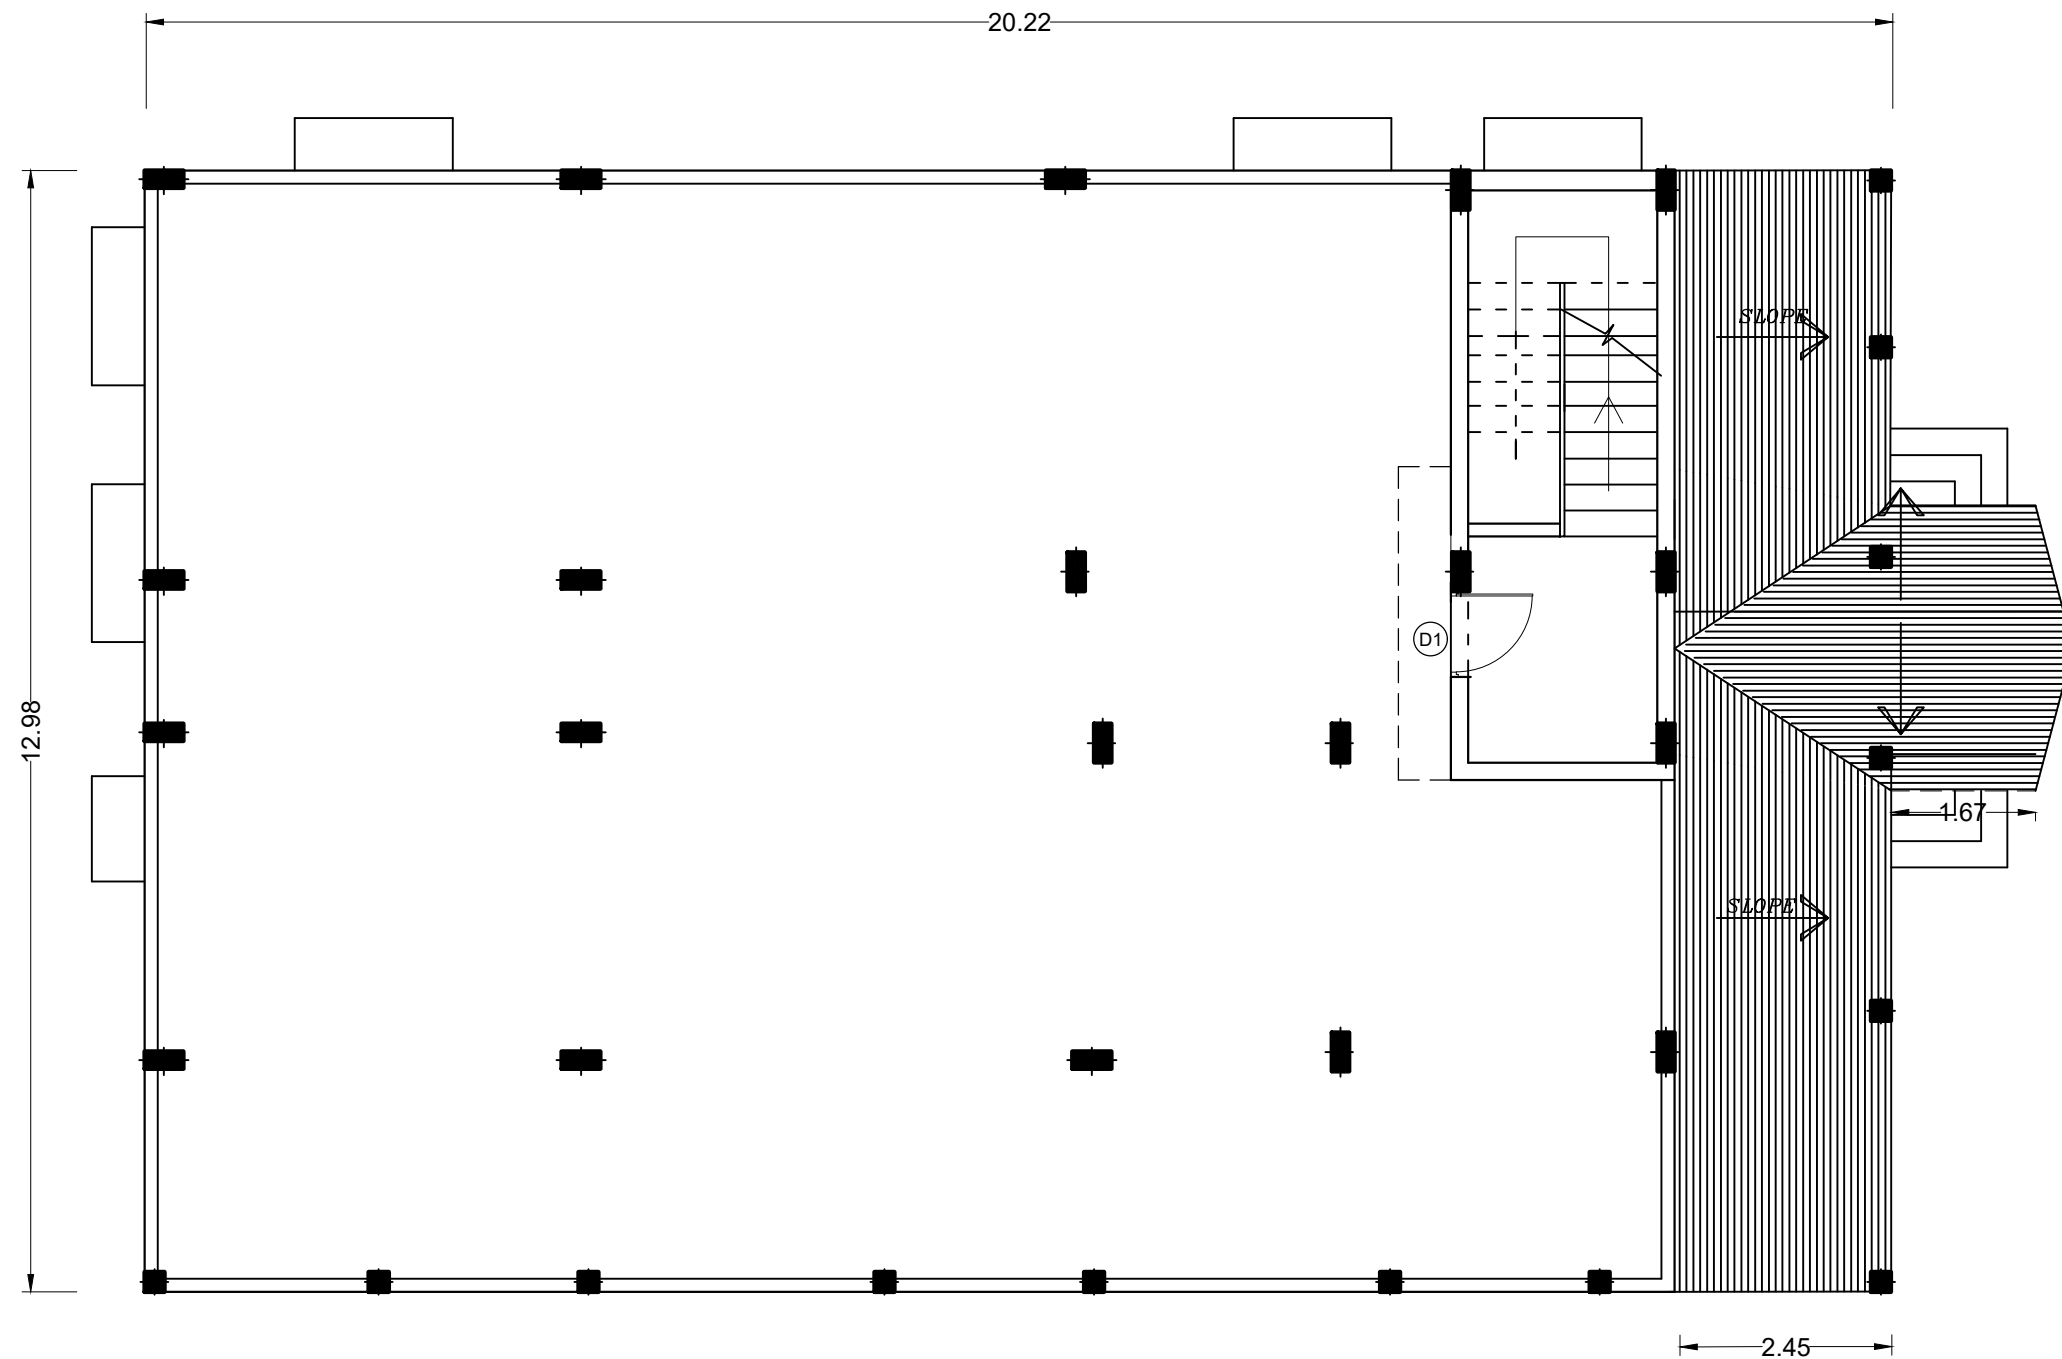

TERRACE FLOOR PLAN

NOTE : ALL DIMENSION IN METERS

PROJECT :
PROVIDING COMPREHENSIVE PROJECT
MANAGEMENT CONSULTANCY SERVICES
FOR PROPOSED CONSTRUCTION OF CISF
INFRASTRUCTURE BUILDINGS
AT NOTE MUDRAN NAGAR MYSORE

TENDER DRAWING

Page 71 of 129

 
BNPM - ARMOUR HOUSE PLAN

Date : 10-10-2025

Drawn by: AMRUTHA

Rev Date: -----



Checked by: Ar. Kavitha



ARCHITECTS :
KULKARNI ASSOCIATES

Surya Prema Building, next to Adiga's Restaurant, Kanakapura Road
No-203, 2nd floor, Above Canara bank Raghuvahalli Branch
Raghuvahalli Village, Uttarahalli hobli Bangalore-560062

Email Id : kulkarni.associates@yahoo.com

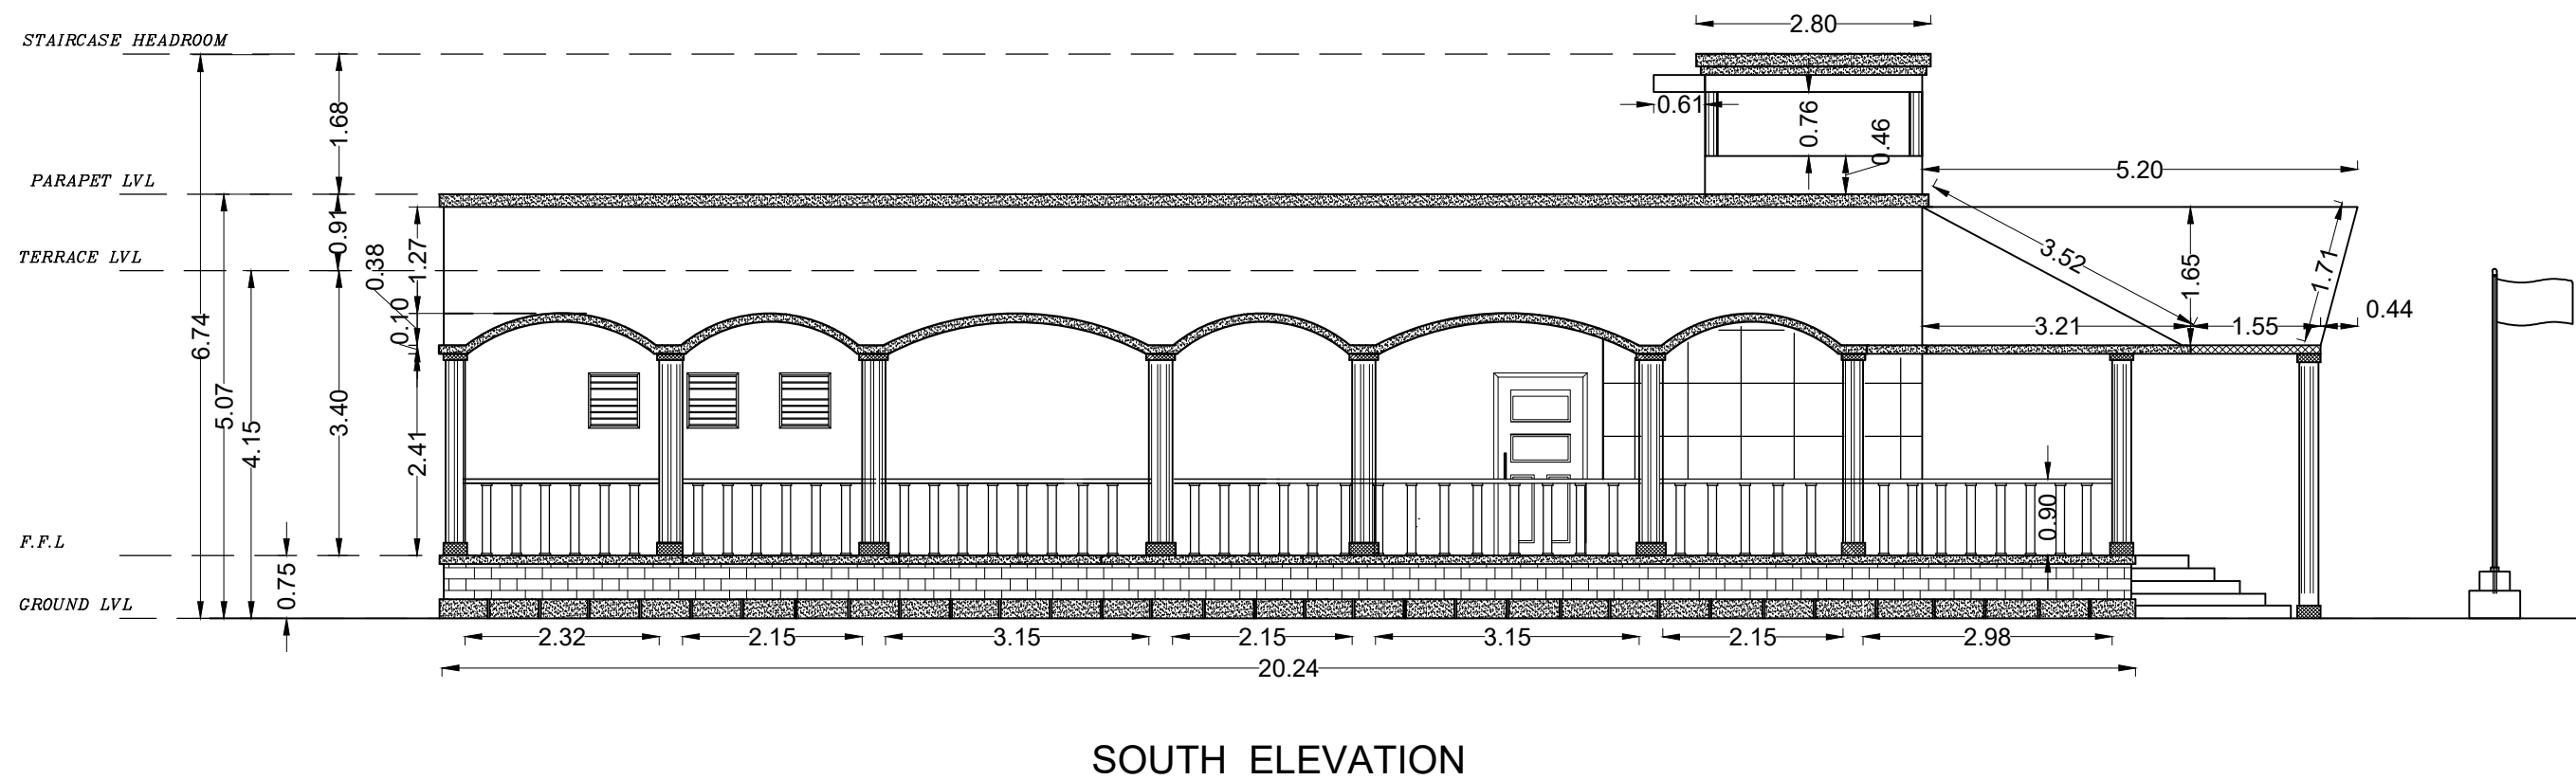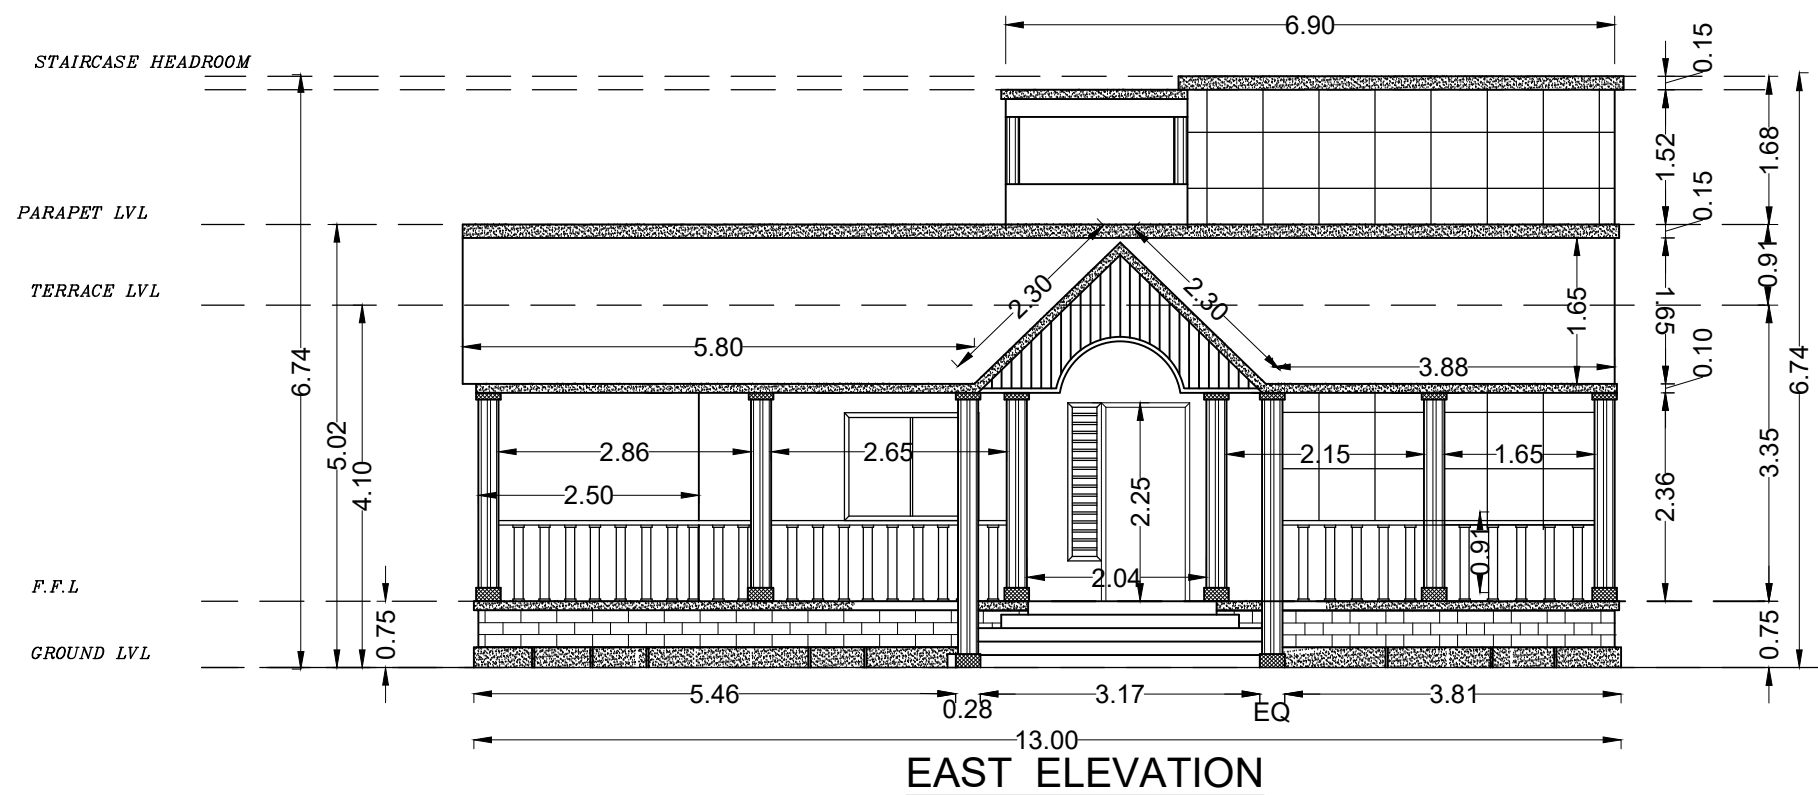

NOTE : ALL DIMENSION IN METERS

PROJECT :
PROVIDING COMPREHENSIVE PROJECT
MANAGEMENT CONSULTANCY SERVICES FOR
PROPOSED CONSTRUCTION OF CISF
INFRASTRUCTURE BUILDINGS
AT NOTE MUDRAN NAGAR MYSORE

TENDER DRAWING

Page 72 of 129

BNPM - ARMOUR HOUSE ELEVATION

Date : 30-10-2025

Drawn by: AMRUTHA

Rev Date: -----


Checked by: Ar. Kavitha




ARCHITECTS :
KULKARNI ASSOCIATES

Surya Prema Building, next to Adiga's Restaurant, Kanakapura Road
No-203, 2nd floor, Above Canara bank Raghuvahalli Branch
Raghuvahalli Village, Uttarahalli hobli Bangalore-560062

Email Id : kulkarni.associates@yahoo.com

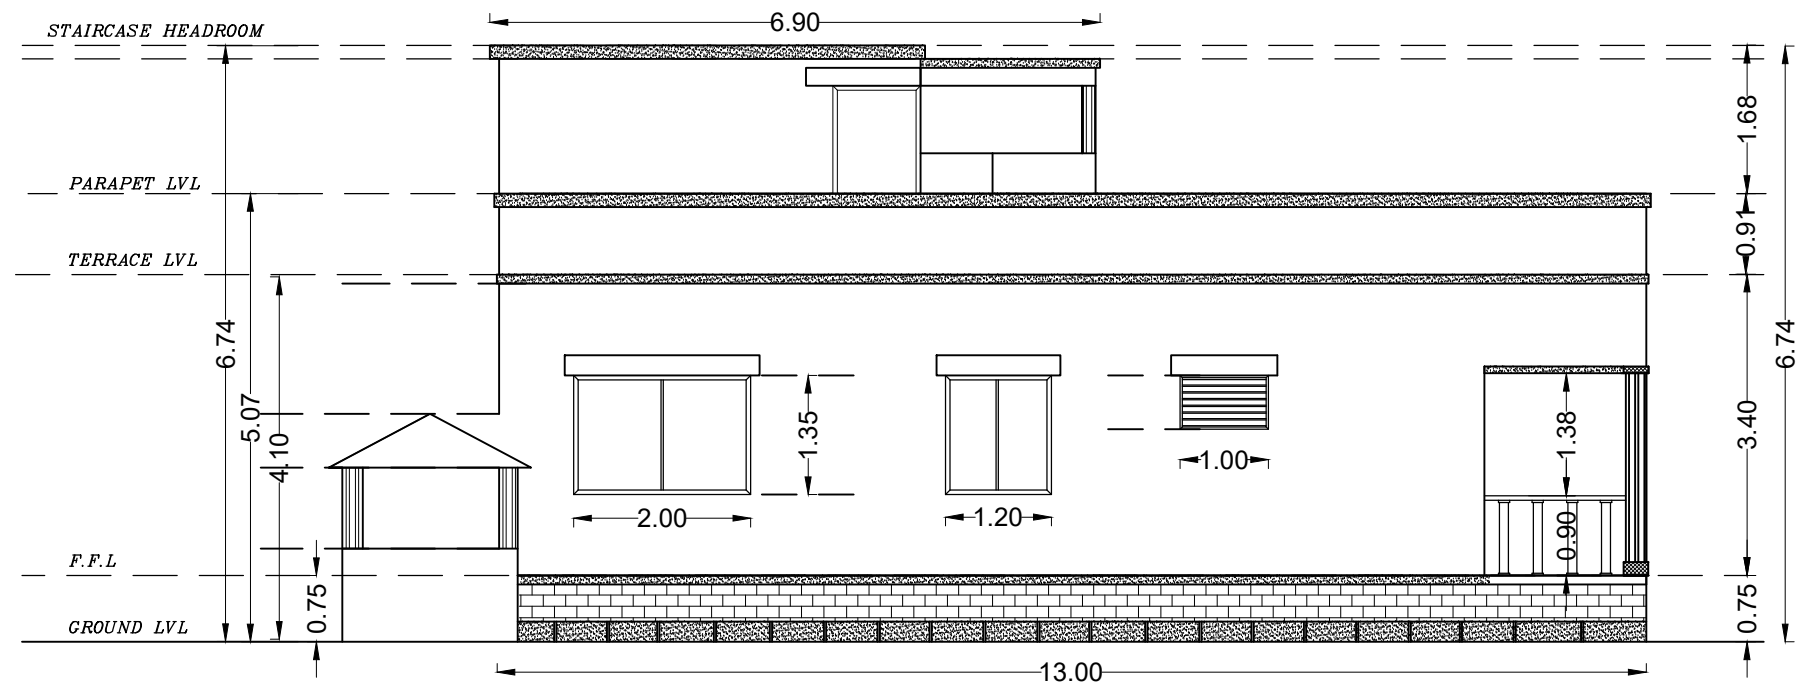

WEST ELEVATION

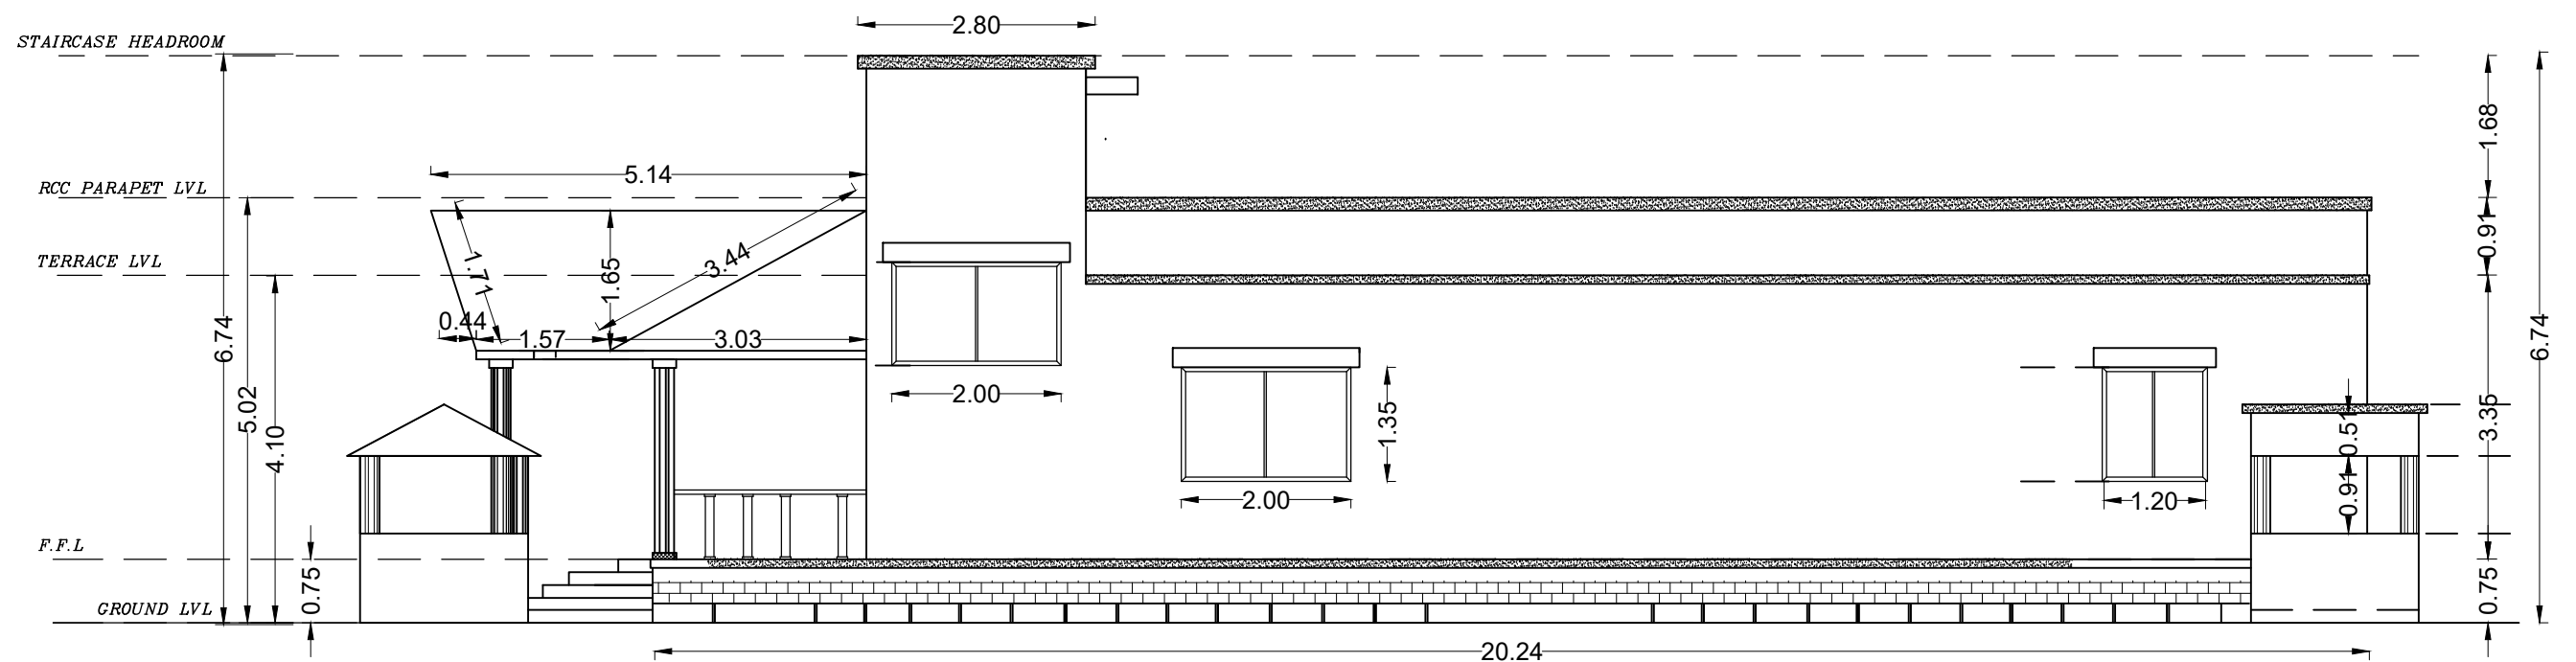

NORTH ELEVATION

NOTE : ALL DIMENSION IN METERS

PROJECT :
PROVIDING COMPREHENSIVE PROJECT
MANAGEMENT CONSULTANCY SERVICES FOR
PROPOSED CONSTRUCTION OF CISF
INFRASTRUCTURE BUILDINGS
AT NOTE MUDRAN NAGAR MYSORE

TENDER DRAWING

Page 73 of 129

BNPM - ARMOUR HOUSE ELEVATION

Date : 30-10-2025

Drawn by: AMRUTHA

Scale : NTS

Checked by: Ar. Kavitha


Rev Date:





ARCHITECTS :
KULKARNI ASSOCIATES

Surya Prema Building, next to Adiga's Restaurant, Kanakapura Road
No-203, 2nd floor, Above Canara bank Raghuvahalli Branch
Raghuvahalli Village, Uttarahalli hobli Bangalore-560062

Email Id : kulkarni.associates@yahoo.com

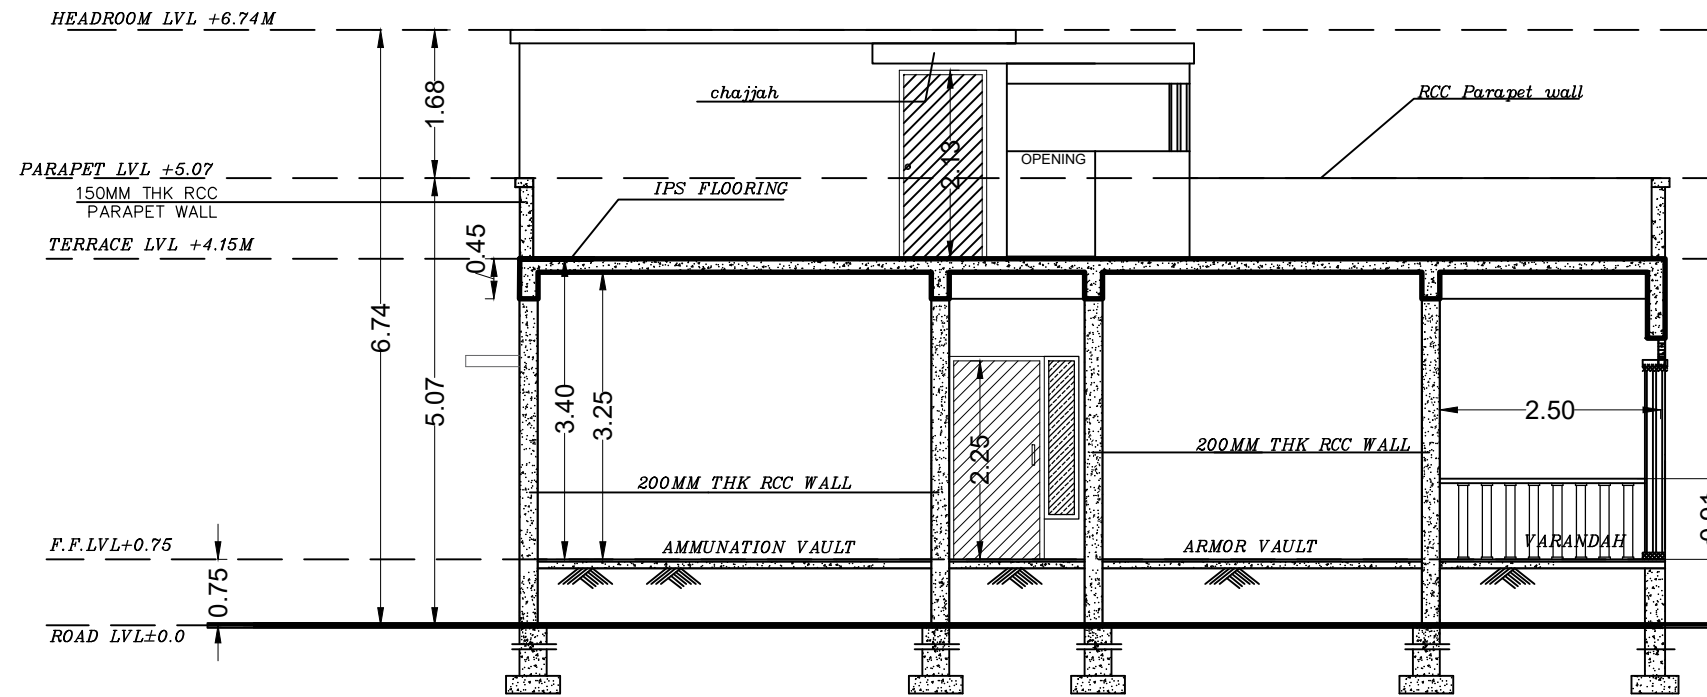

SECTION- AA

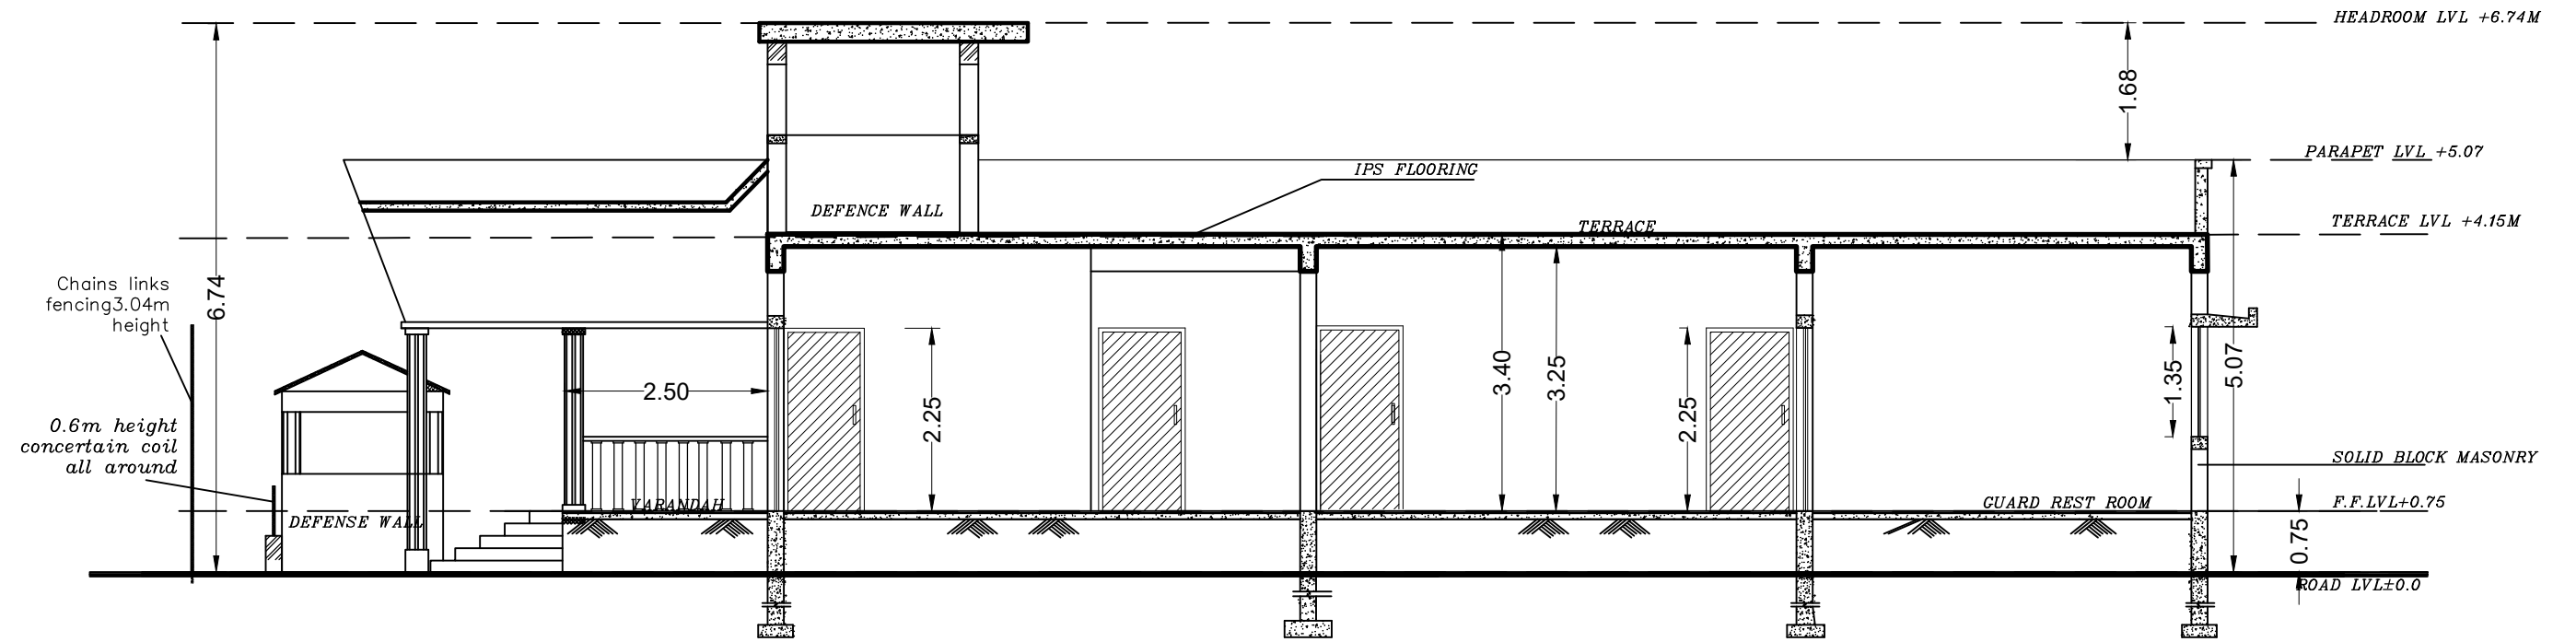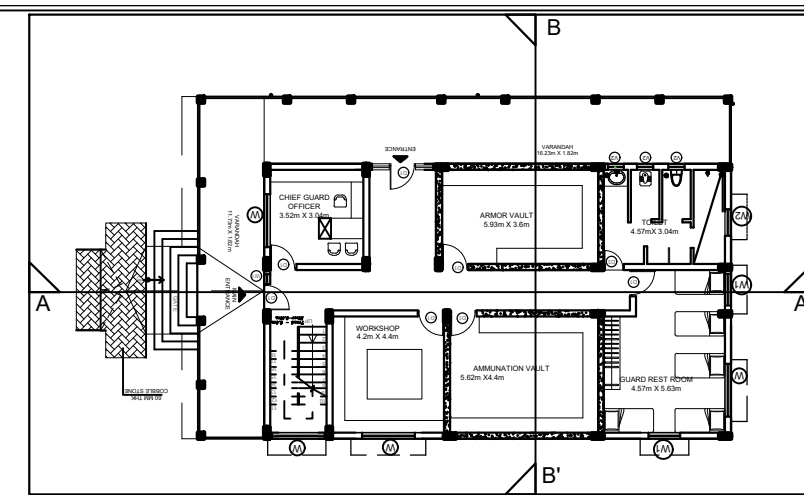

SECTION- BB

NOTE : ALL DIMENSION IN METERS

PROJECT :
PROVIDING COMPREHENSIVE PROJECT
MANAGEMENT CONSULTANCY SERVICES FOR
PROPOSED CONSTRUCTION OF CISF
INFRASTRUCTURE BUILDINGS
AT NOTE MUDRAN NAGAR MYSORE

TENDER DRAWING

Page 74 of 129

BNPM - ARMOUR HOUSE SECTION

Date : 30-10-2025

Drawn by: AMRUTHA

Checked by: Ar. Kavitha


Rev Date: -----



ARCHITECTS :
KULKARNI ASSOCIATES

Surya Prema Building, next to Adiga's Restaurant, Kanakapura Road
No-203, 2nd floor, Above Canara bank Raghuvahalli Branch
Raghuvahalli Village, Uttarahalli hobli Bangalore-560062

Email Id : kulkarni.associates@yahoo.com

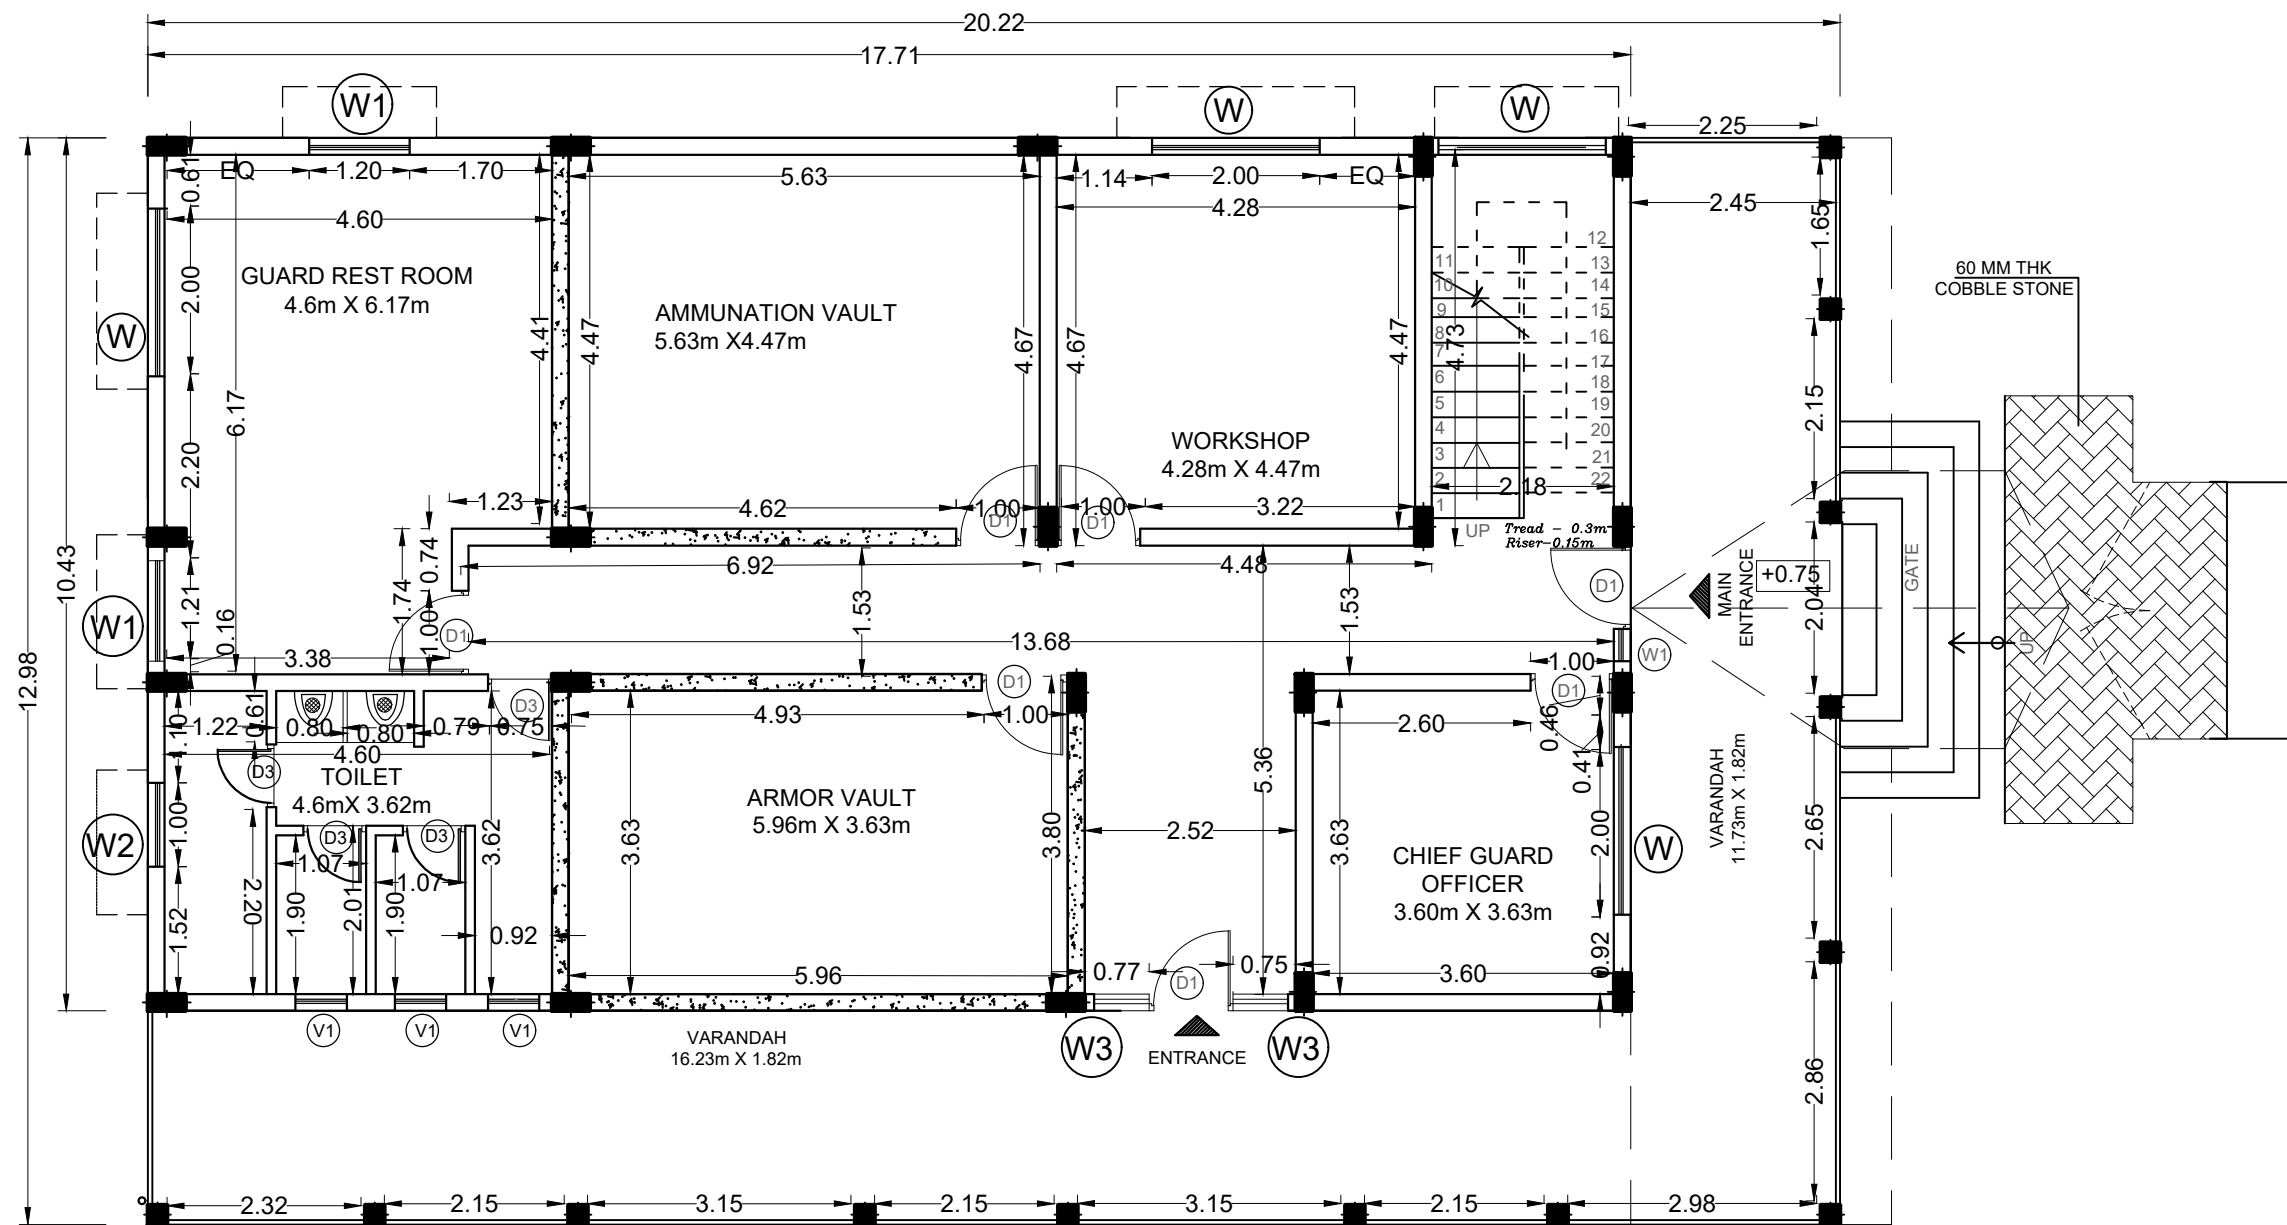

SCHEDULE OF OPENINGS

DOORS

	SIZE IN M	Nos
D1	1.00 X 2.25	7
D3	0.75 X 2.25 (TOILET)	4

WINDOWS

W	2.00 X 1.35	4
W1	1.20 X 1.35	2
W2	1.00 X 0.75	1
W3	1.00 X 1.79	2

VENTILATORS

V1	0.61X 0.75	3
----	------------	---

NOTE : ALL Chajja projection is 0.6m deep

NOTE : ALL DIMENSION IN METERS

PROJECT :
PROVIDING COMPREHENSIVE PROJECT
MANAGEMENT CONSULTANCY SERVICES
FOR PROPOSED CONSTRUCTION OF CISF
INFRASTRUCTURE BUILDINGS
AT NOTE MUDRAN NAGAR MYSORE

TENDER DRAWING

Page 75 of 129

BNPM - ARMOUR HOUSE PLAN WORKING DRAWING

 
Date :30-10-2025

Drawn by: AMRUTHA

Scale: 1/10

Checked by: Ar. Kavitha


Rev Date: -----



ARCHITECTS :
KULKARNI ASSOCIATES

Surya Prema Building, next to Adiga's Restaurant, Kanakapura Road
No-203, 2nd floor, Above Canara bank Raghuvahalli Branch
Raghuvahalli Village, Uttarahalli hobli Bangalore-560062

Email Id : kulkarni.associates@yahoo.com

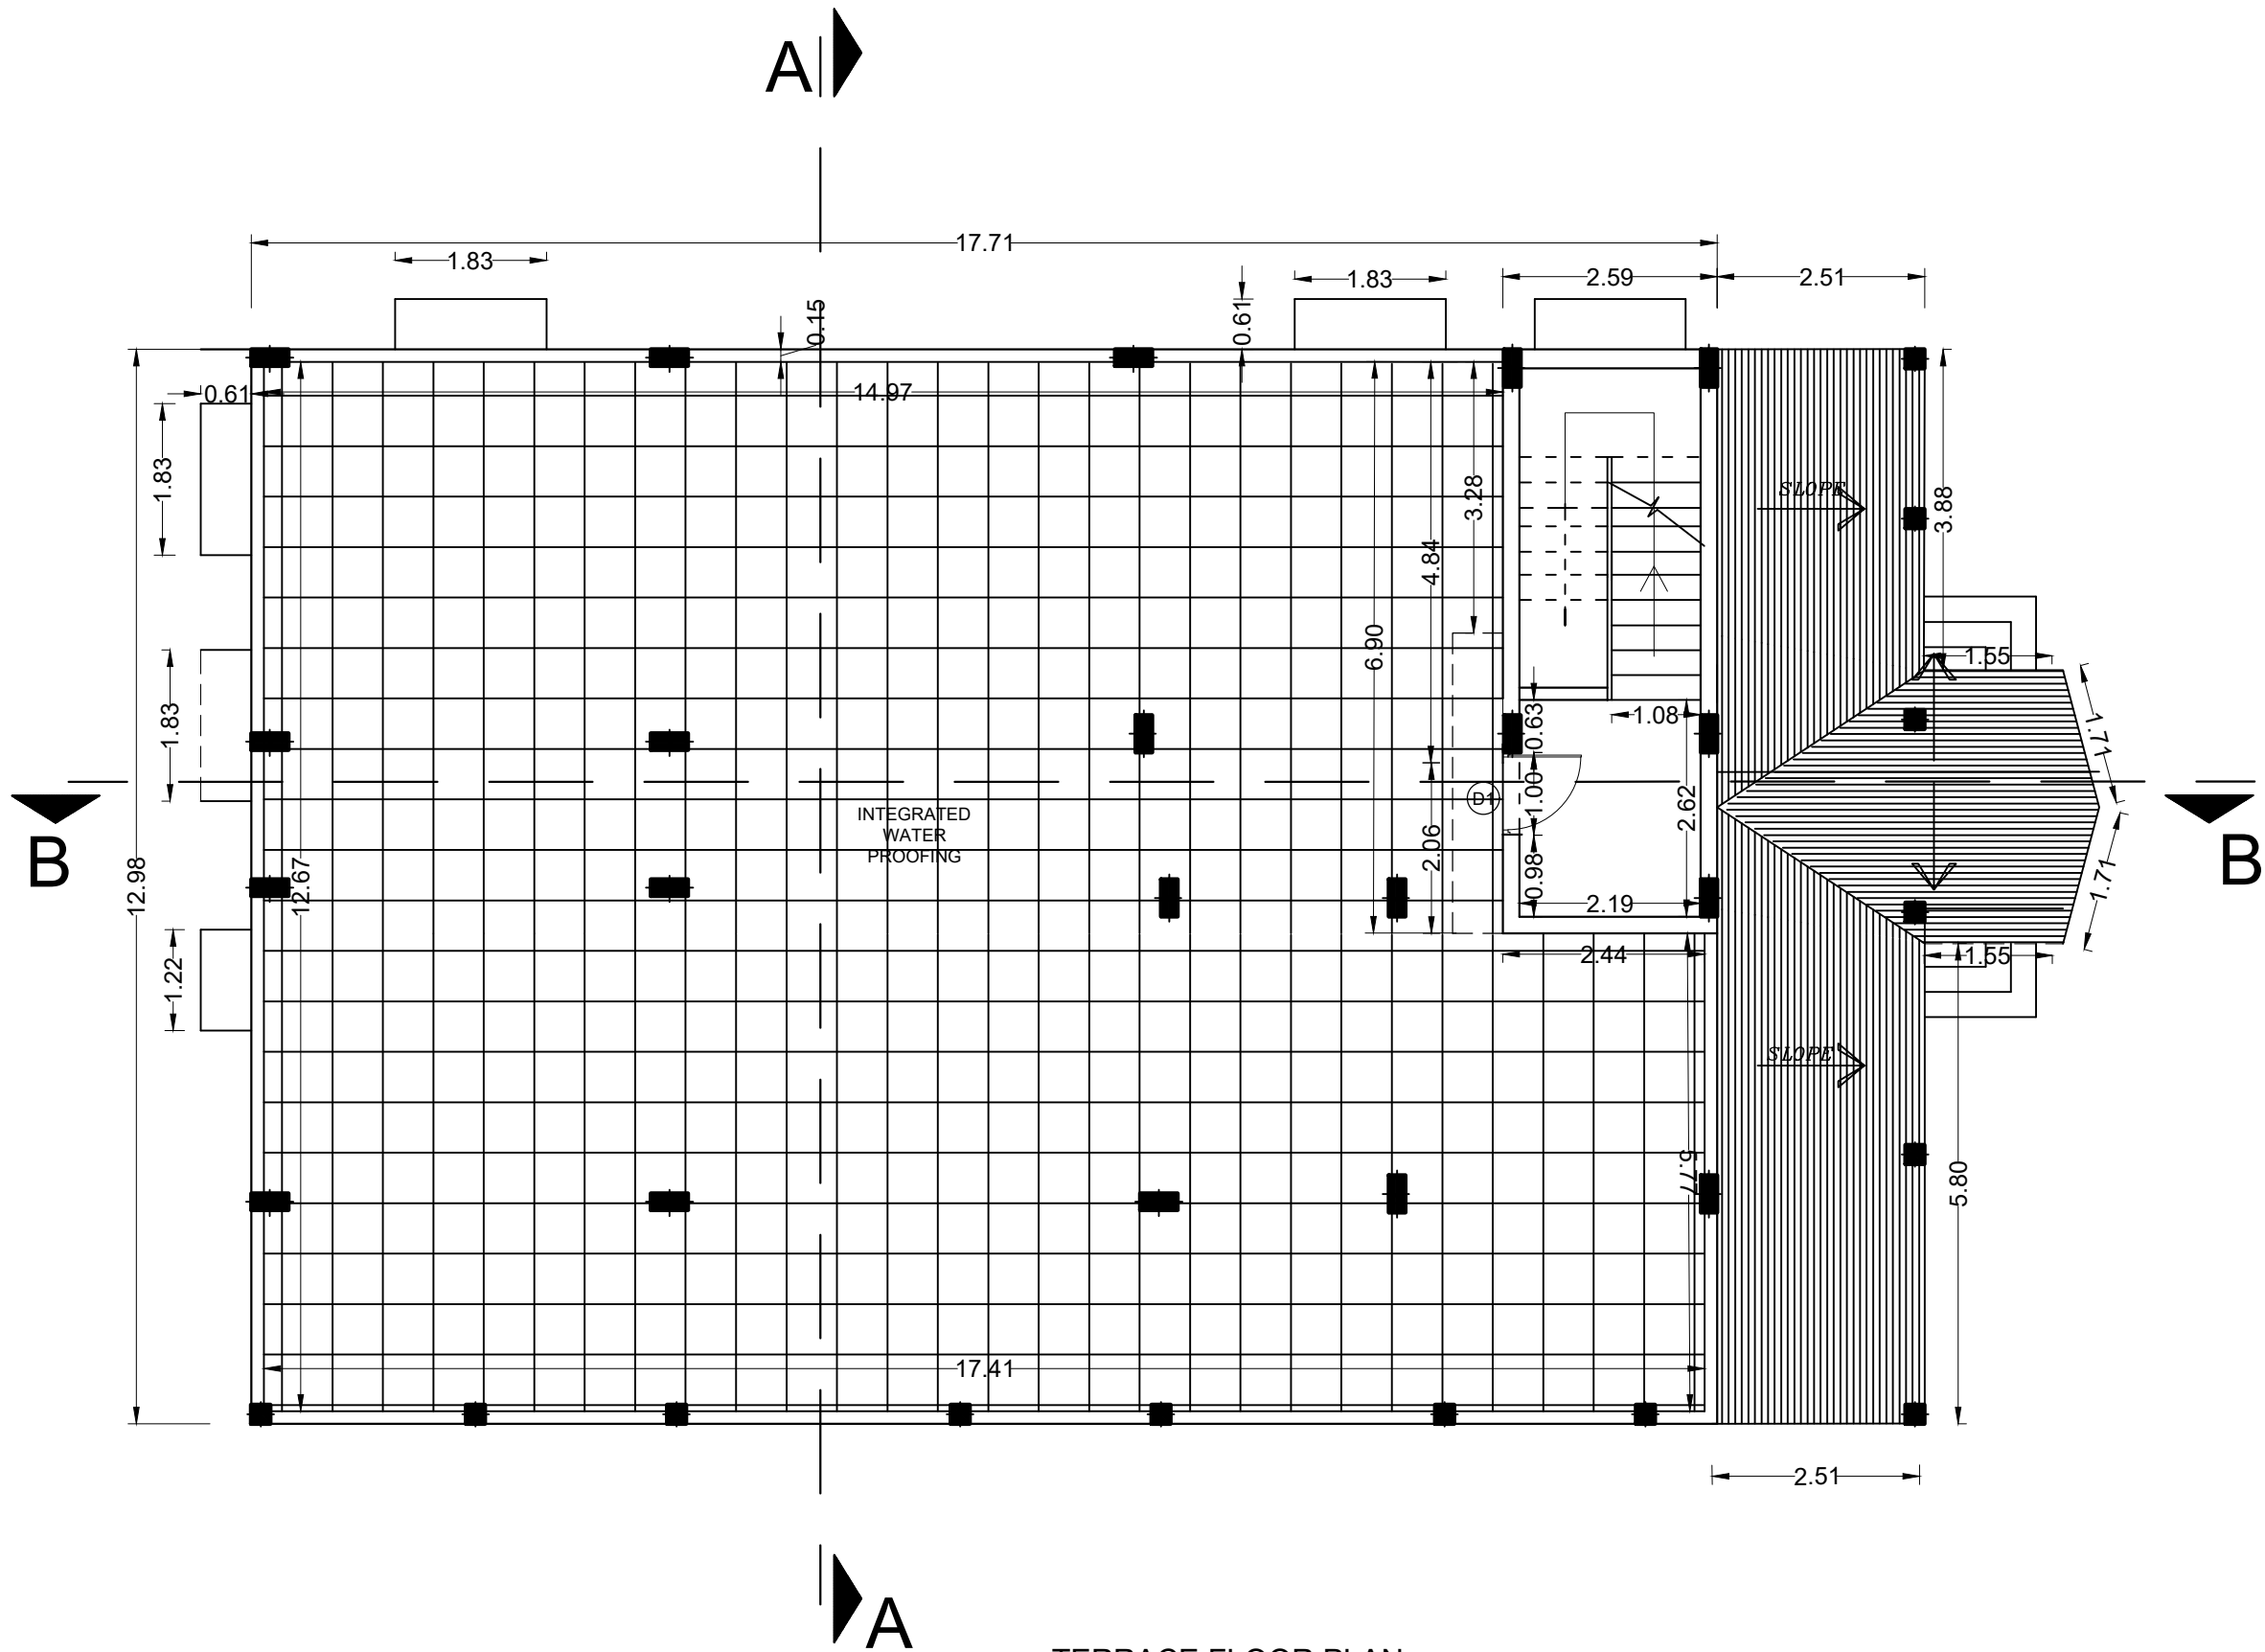

TERRACE FLOOR PLAN

SCHEDULE OF OPENINGS

DOORS

	SIZE IN M	Nos
D1	1.00 X 2.25	1

WINDOWS

VENTILATORS

water proofing area - 203.47 sqm
slab area - 219.74 sqm
parapet - 60.15 rmt

for staircase -
water proofing area - 26.85 sqm
slab area - 30.14 sqm
parapet - 21.30 rmt

NOTE : ALL DIMENSION IN METERS

PROJECT :
PROVIDING COMPREHENSIVE PROJECT
MANAGEMENT CONSULTANCY SERVICES
FOR PROPOSED CONSTRUCTION OF CISF
INFRASTRUCTURE BUILDINGS
AT NOTE MUDRAN NAGAR MYSORE

BNPM - ARMOUR HOUSE PLAN

Date : 10-10-2025

Drawn by: AMRUTHA

Scale: 1:100

Checked by: Ar. Kavitha


Rev Date: -----



ARCHITECTS :
KULKARNI ASSOCIATES

Surya Prema Building, next to Adiga's Restaurant, Kanakapura Road
No-203, 2nd floor, Above Canara bank Raghuvahalli Branch
Raghuvahalli Village, Uttarahalli hobli Bangalore-560062

Email Id : kulkarni.associates@yahoo.com

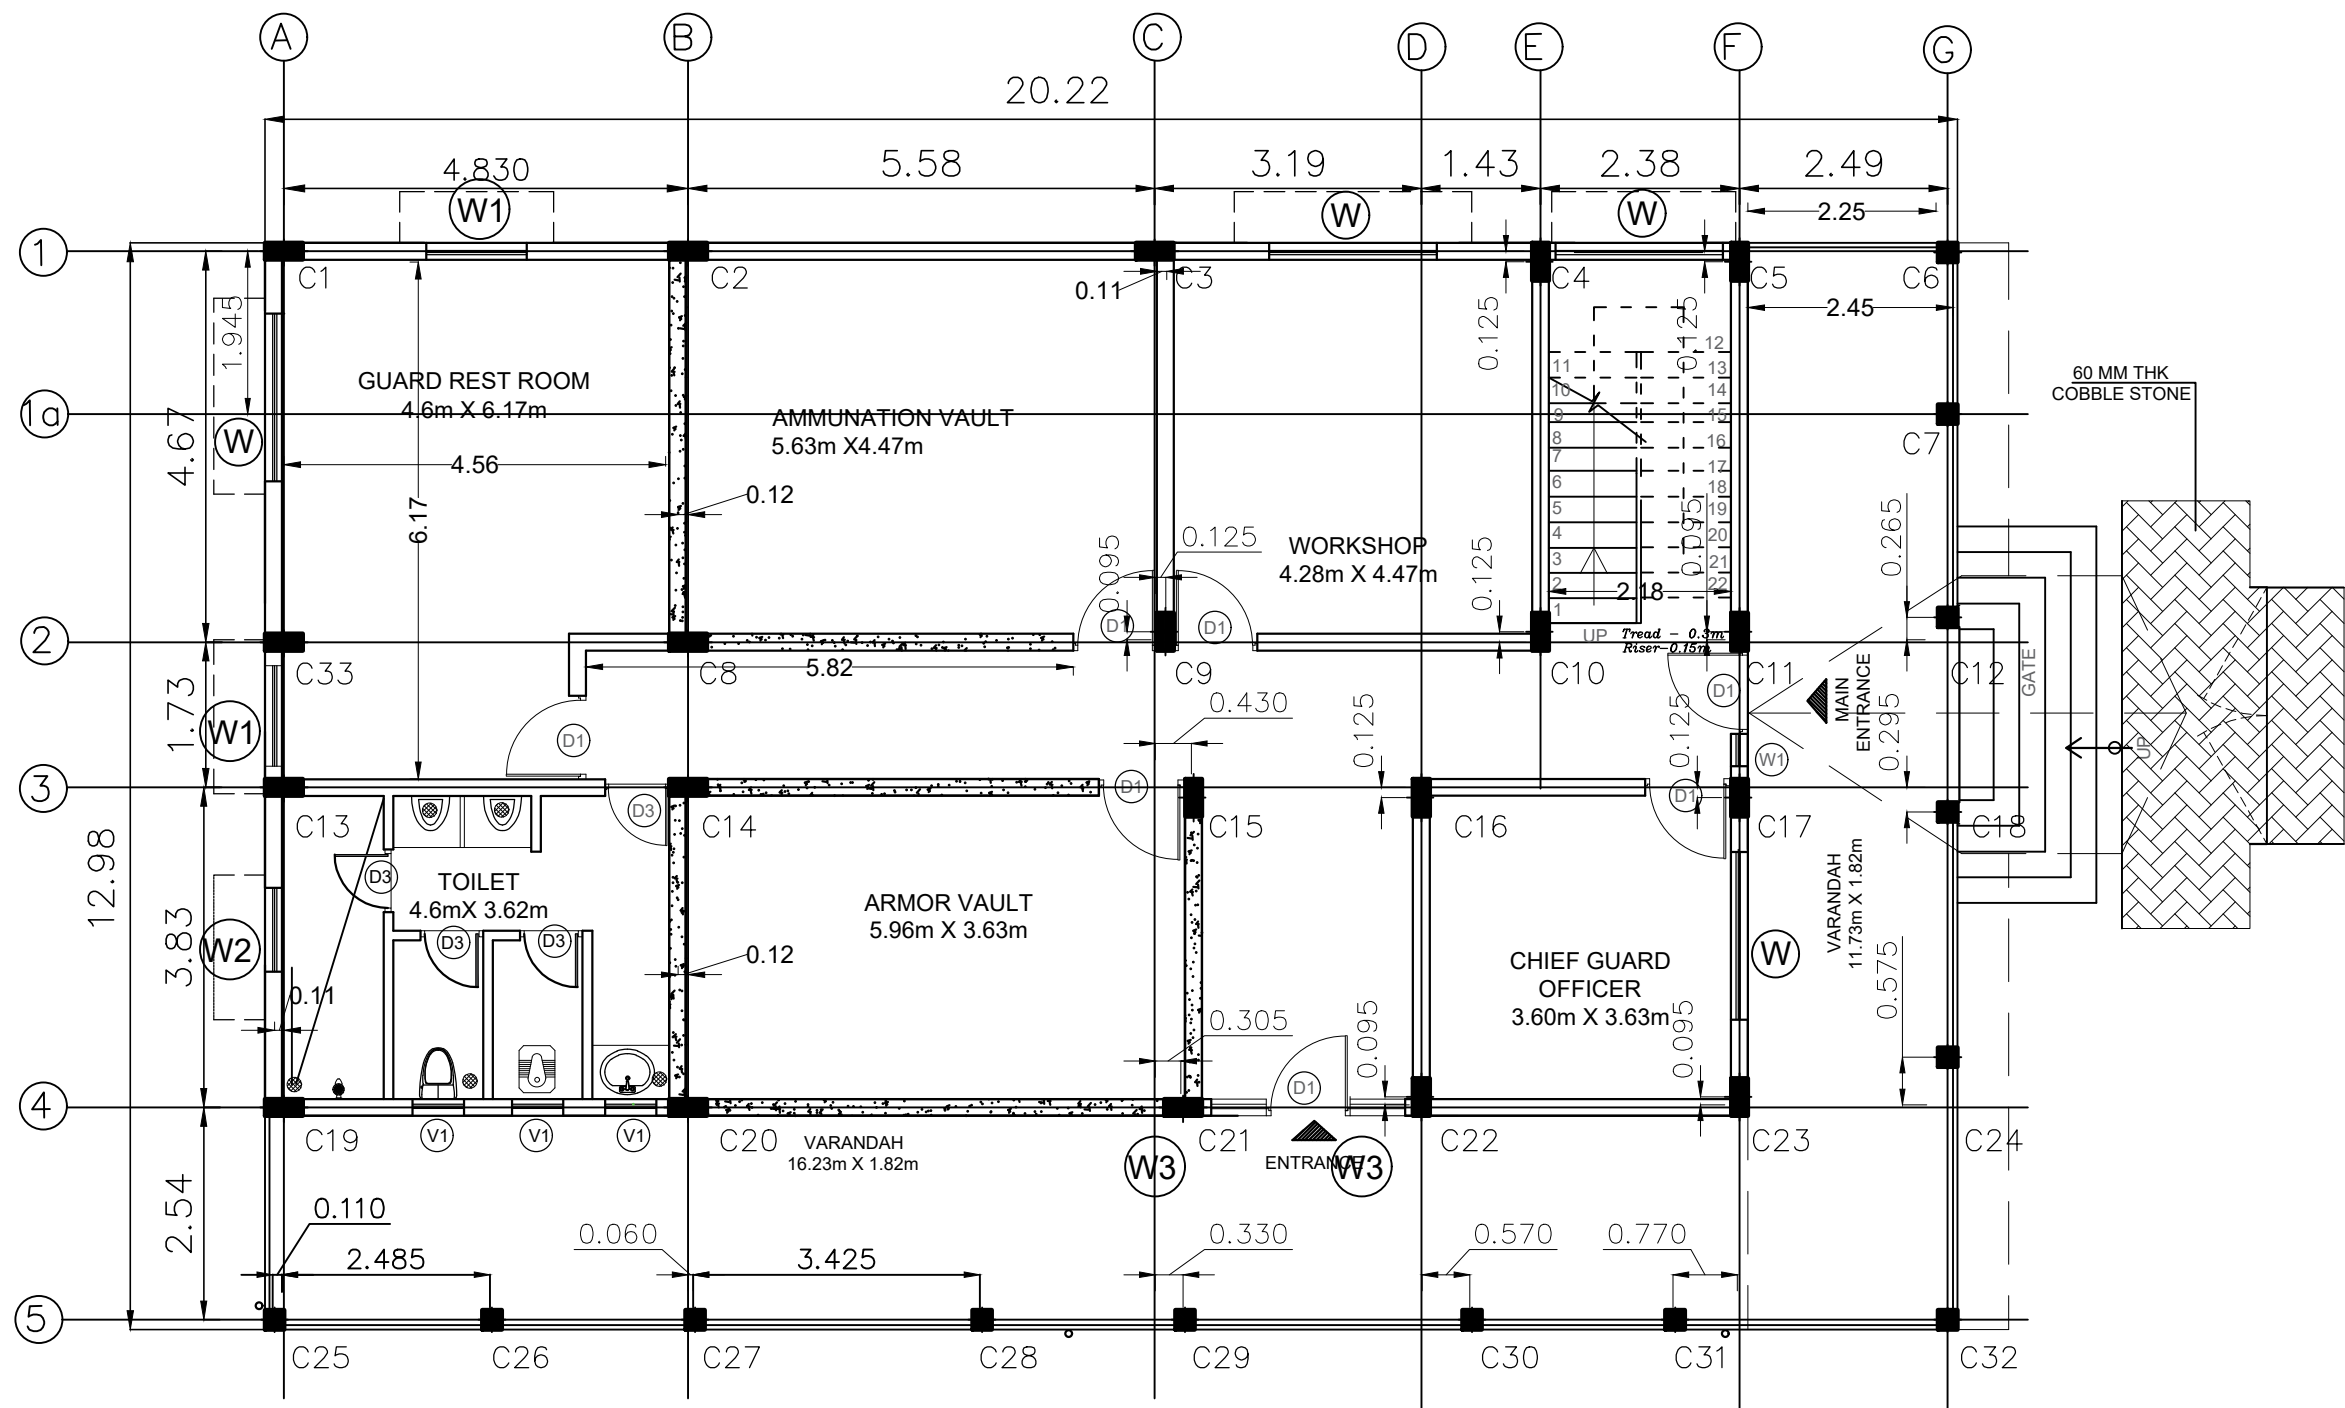

SCHEDULE OF OPENINGS		
DOORS		
	SIZE IN M	Nos
D1	1.00 X 2.25	7
D3	0.75 X 2.25 (TOILET)	4
WINDOWS		
W	2.00 X 1.35	4
W1	1.20 X 1.35	2
W2	1.00 X 0.75	1
W3	1.00 X 1.79	2
VENTILATORS		
V1	0.61X 0.75	3

NOTE : ALL Chajja projection is 0.6m deep

NOTE : ALL DIMENSION IN METERS

PROJECT :
PROVIDING COMPREHENSIVE PROJECT
MANAGEMENT CONSULTANCY SERVICES
FOR PROPOSED CONSTRUCTION OF CISF
INFRASTRUCTURE BUILDINGS
AT NOTE MUDRAN NAGAR MYSORE

TENDER DRAWING

BNPM - ARMOUR HOUSE PLAN
CENTER LINE PLAN

Date :30-10-2025

Drawn by: AMRUTHA

Rev Date: -----


Checked by: Ar. Kavitha




ARCHITECTS :
KULKARNI ASSOCIATES

Surya Prema Building, next to Adiga's Restaurant, Kanakapura Road
No-203, 2nd floor, Above Canara bank Raghuvahalli Branch
Raghuvahalli Village, Uttarahalli hobli Bangalore-560062

Email Id : kulkarni.associates@yahoo.com

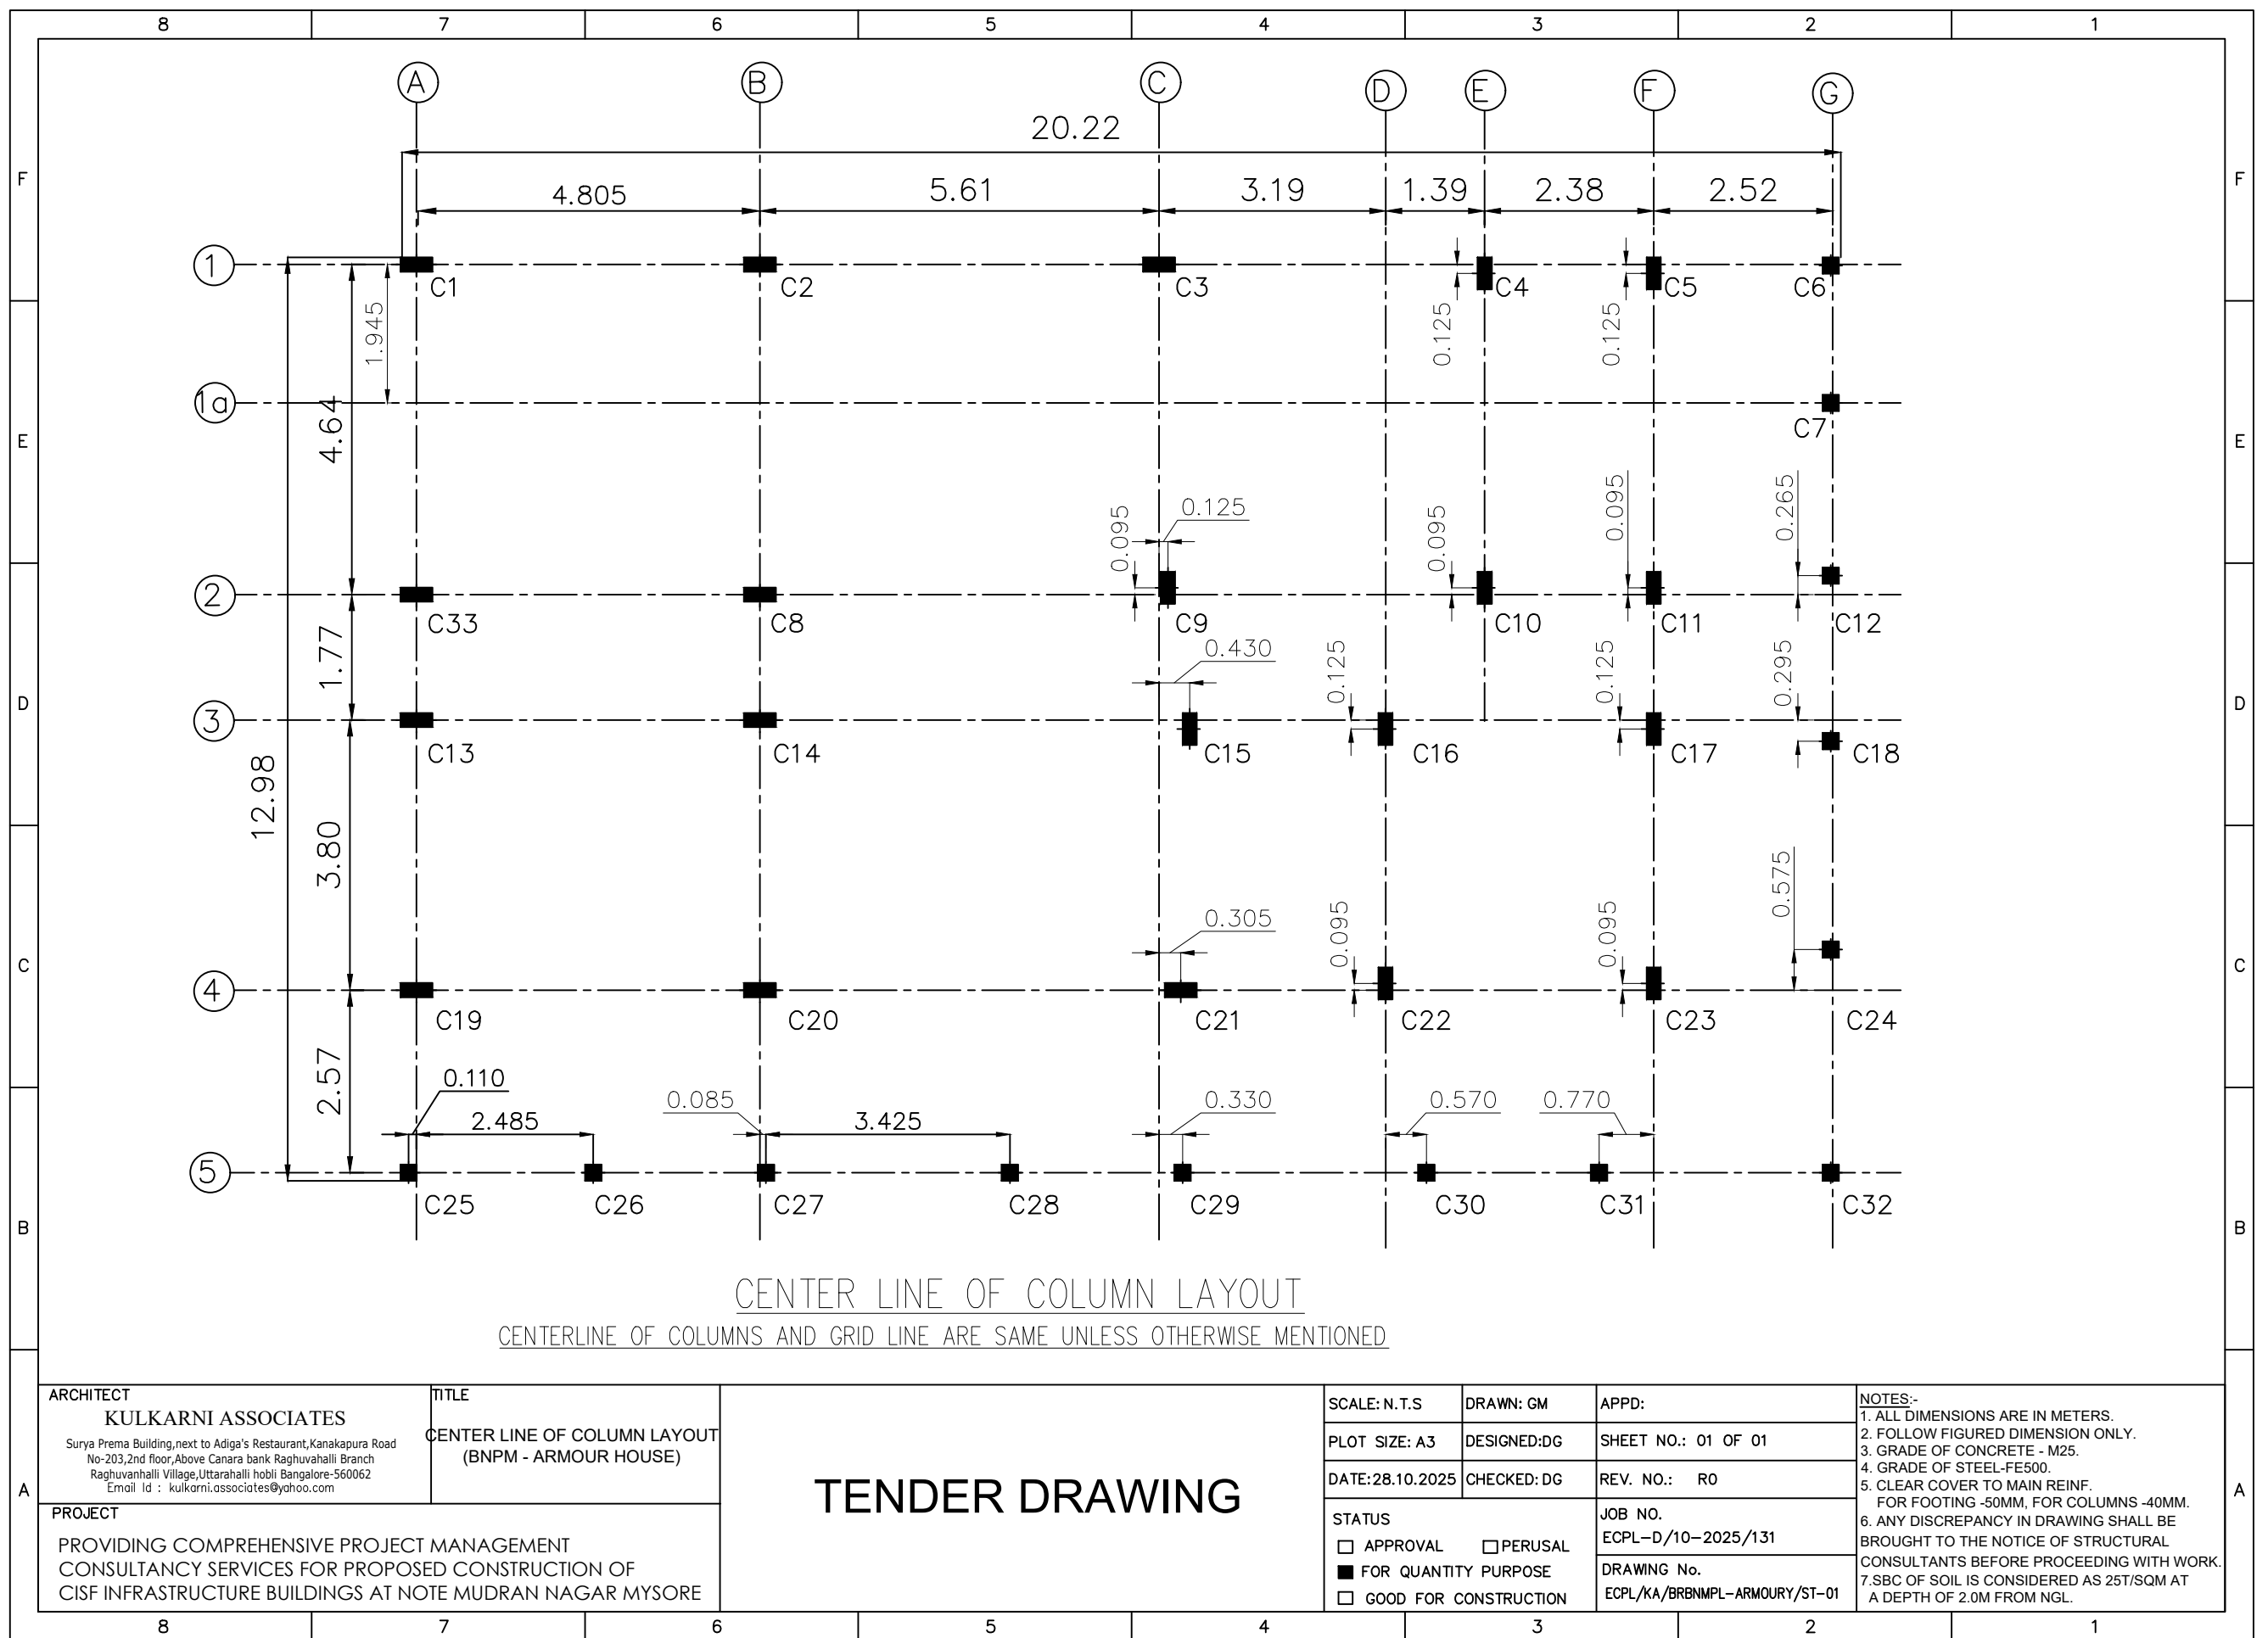

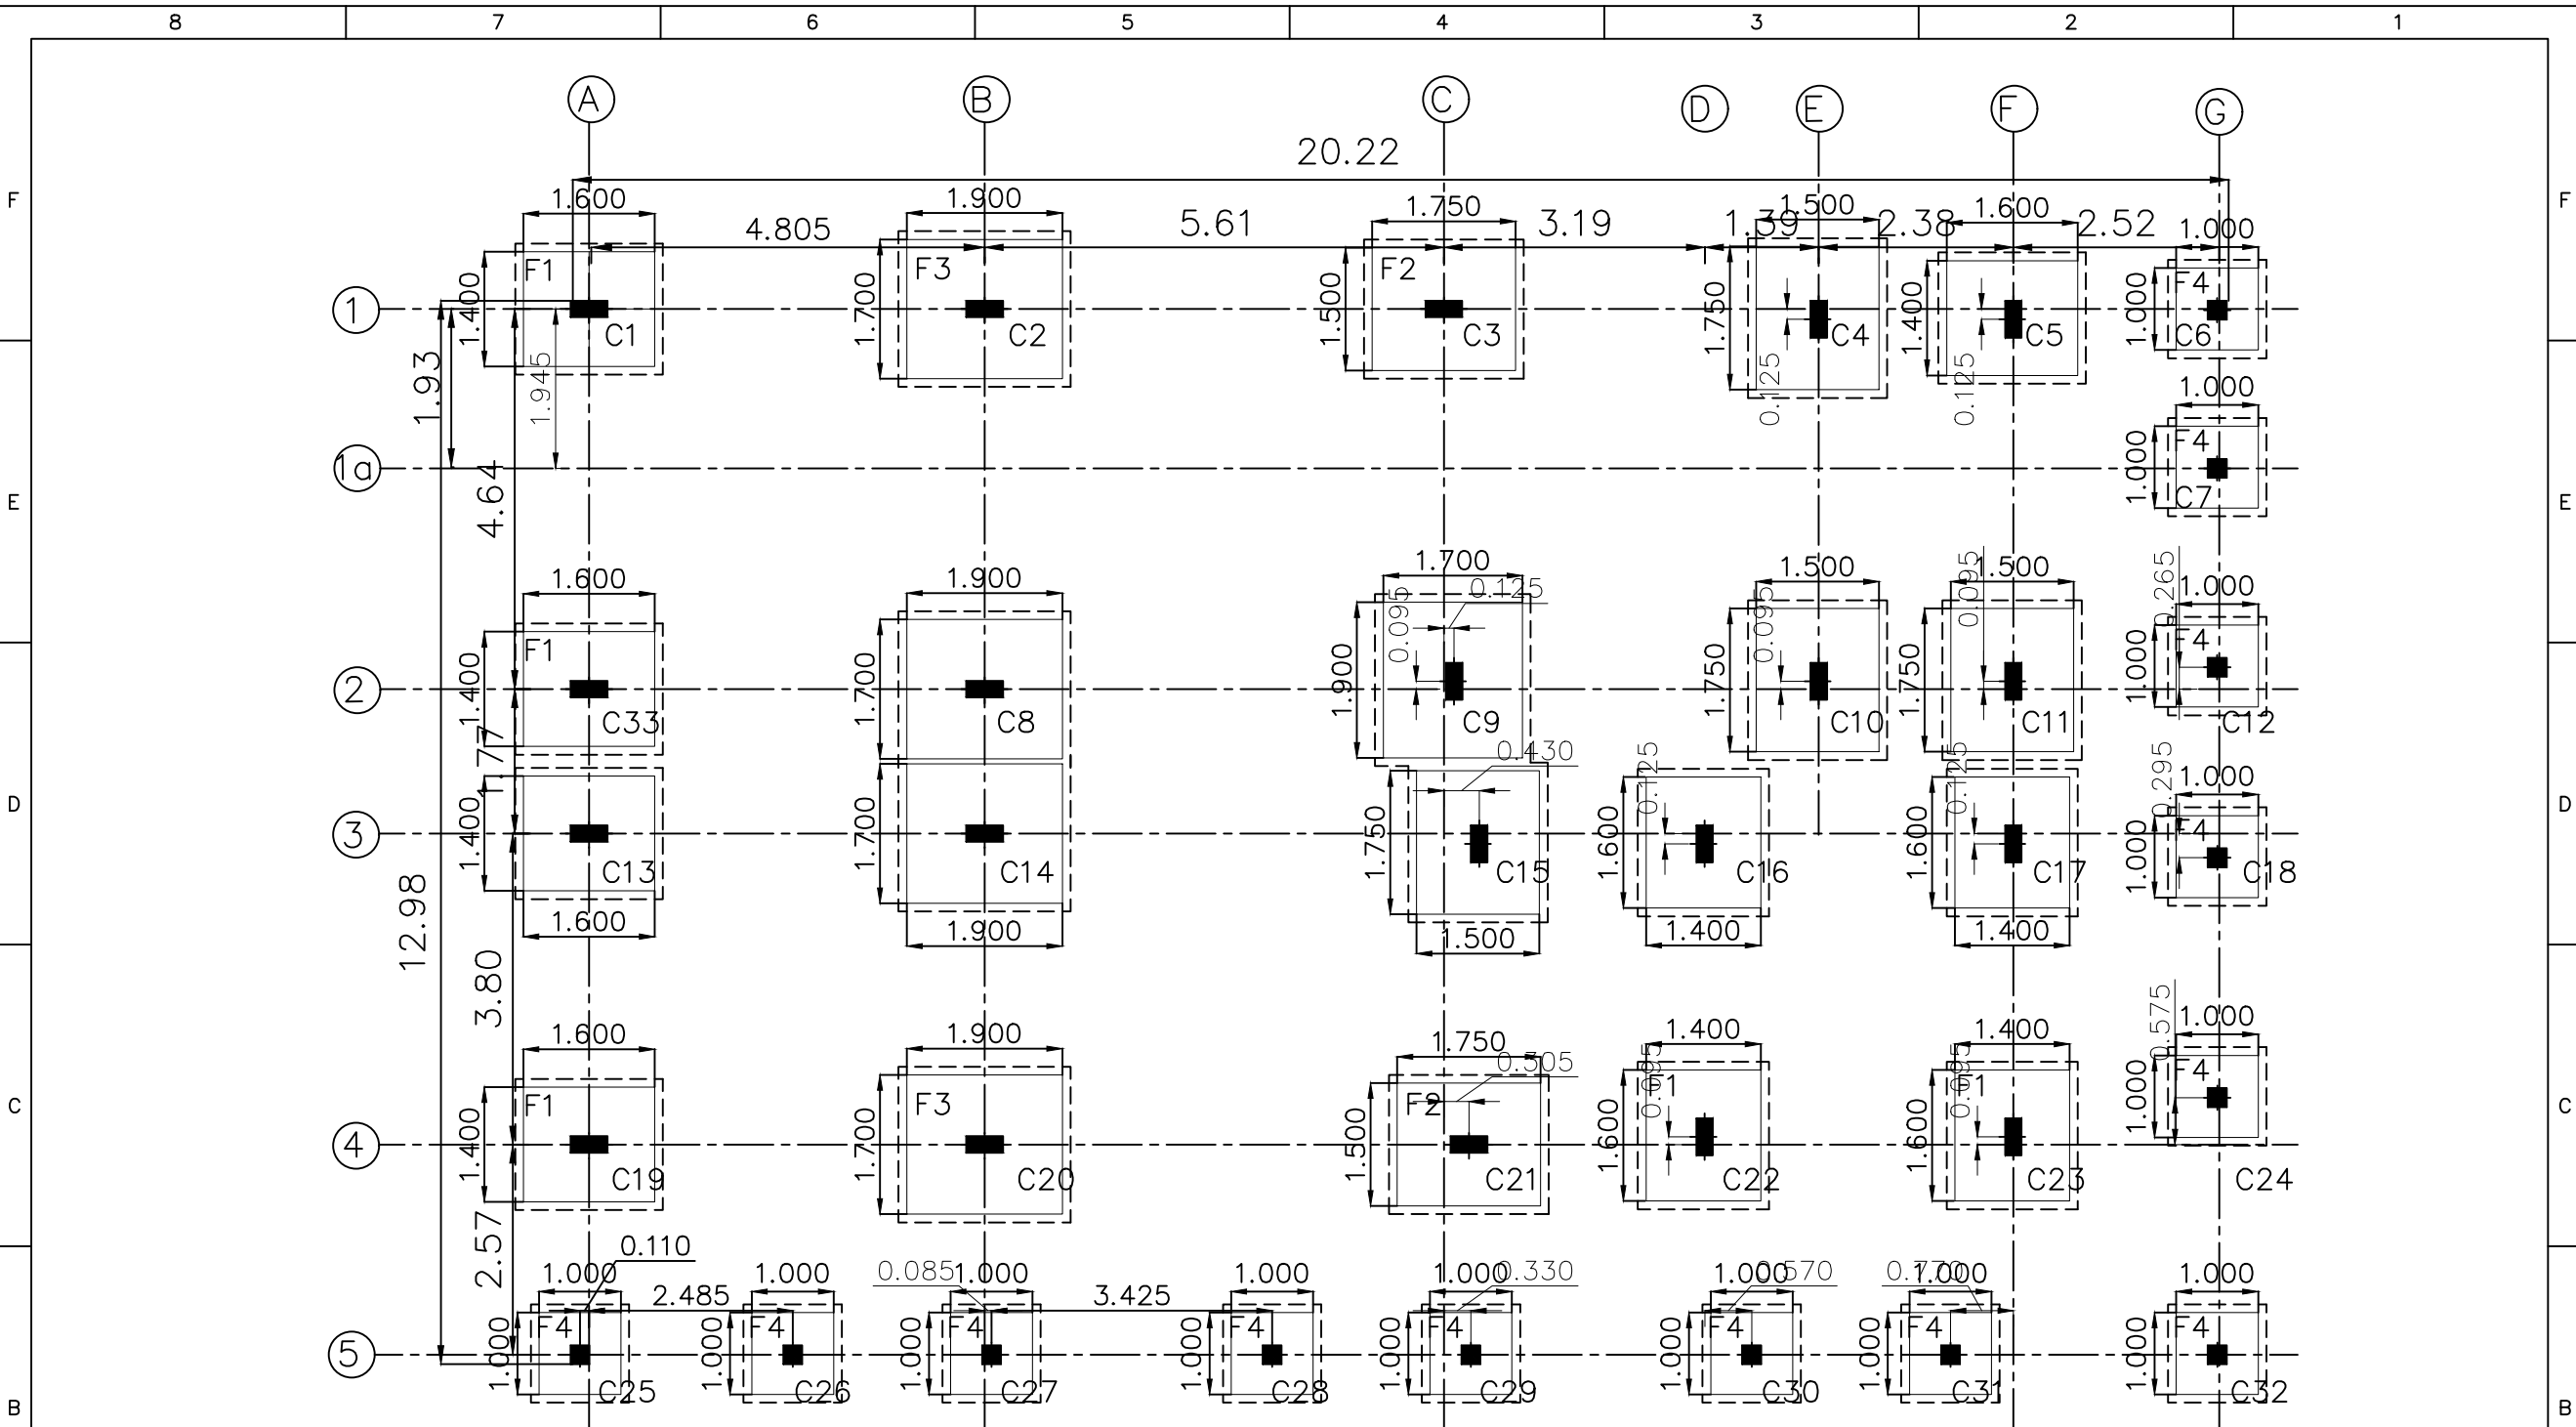

EXCAVATION LAYOUT OF FOOTINGS
EXCAVATION SHALL BE 100 MM ALL ROUND FOOTINGS

ARCHITECT

KULKARNI ASSOCIATES

Surya Prema Building, next to Adiga's Restaurant, Kanakapura Road
No-203, 2nd floor, Above Canara bank Raghuvahalli Branch
Raghuvahalli Village, Uttarahalli hobli Bangalore-560062
Email Id : kulkarni.associates@yahoo.com

TITLE

EXCAVATION LAYOUT
OF FOOTINGS
(BNPM - ARMOUR HOUSE)

PROJECT

PROVIDING COMPREHENSIVE PROJECT MANAGEMENT
CONSULTANCY SERVICES FOR PROPOSED CONSTRUCTION OF
CISF INFRASTRUCTURE BUILDINGS AT NOTE MUDRAN NAGAR MYSORE

TENDER DRAWING

SCALE: N.T.S

PLOT SIZE: A3

DATE: 28.10.2025

DRAWN: GM

DESIGNED: SSN

CHECKED: DG

APPD:

SHEET NO.: 01 OF 01

REV. NO.: R0

STATUS
☐ APPROVAL ☐ PERUSAL
☒ FOR QUANTITY PURPOSE
☐ GOOD FOR CONSTRUCTION

JOB NO.
ECPL-D/10-2025/131

DRAWING No.
ECPL/KA/BNPM-ARMOURY/ST-02

NOTES:-
1. ALL DIMENSIONS ARE IN METERS.
2. FOLLOW FIGURED DIMENSION ONLY.
3. GRADE OF CONCRETE - M25.
4. GRADE OF STEEL-FE500.
5. CLEAR COVER TO MAIN REINF.
FOR FOOTING -50MM, FOR COLUMNS -40MM.
6. ANY DISCREPANCY IN DRAWING SHALL BE
BROUGHT TO THE NOTICE OF STRUCTURAL
CONSULTANTS BEFORE PROCEEDING WITH WORK.
7. SBC OF SOIL IS CONSIDERED AS 25T/SQM AT
A DEPTH OF 2.0M FROM NGL.

8

7

6


5


4

3

2

1

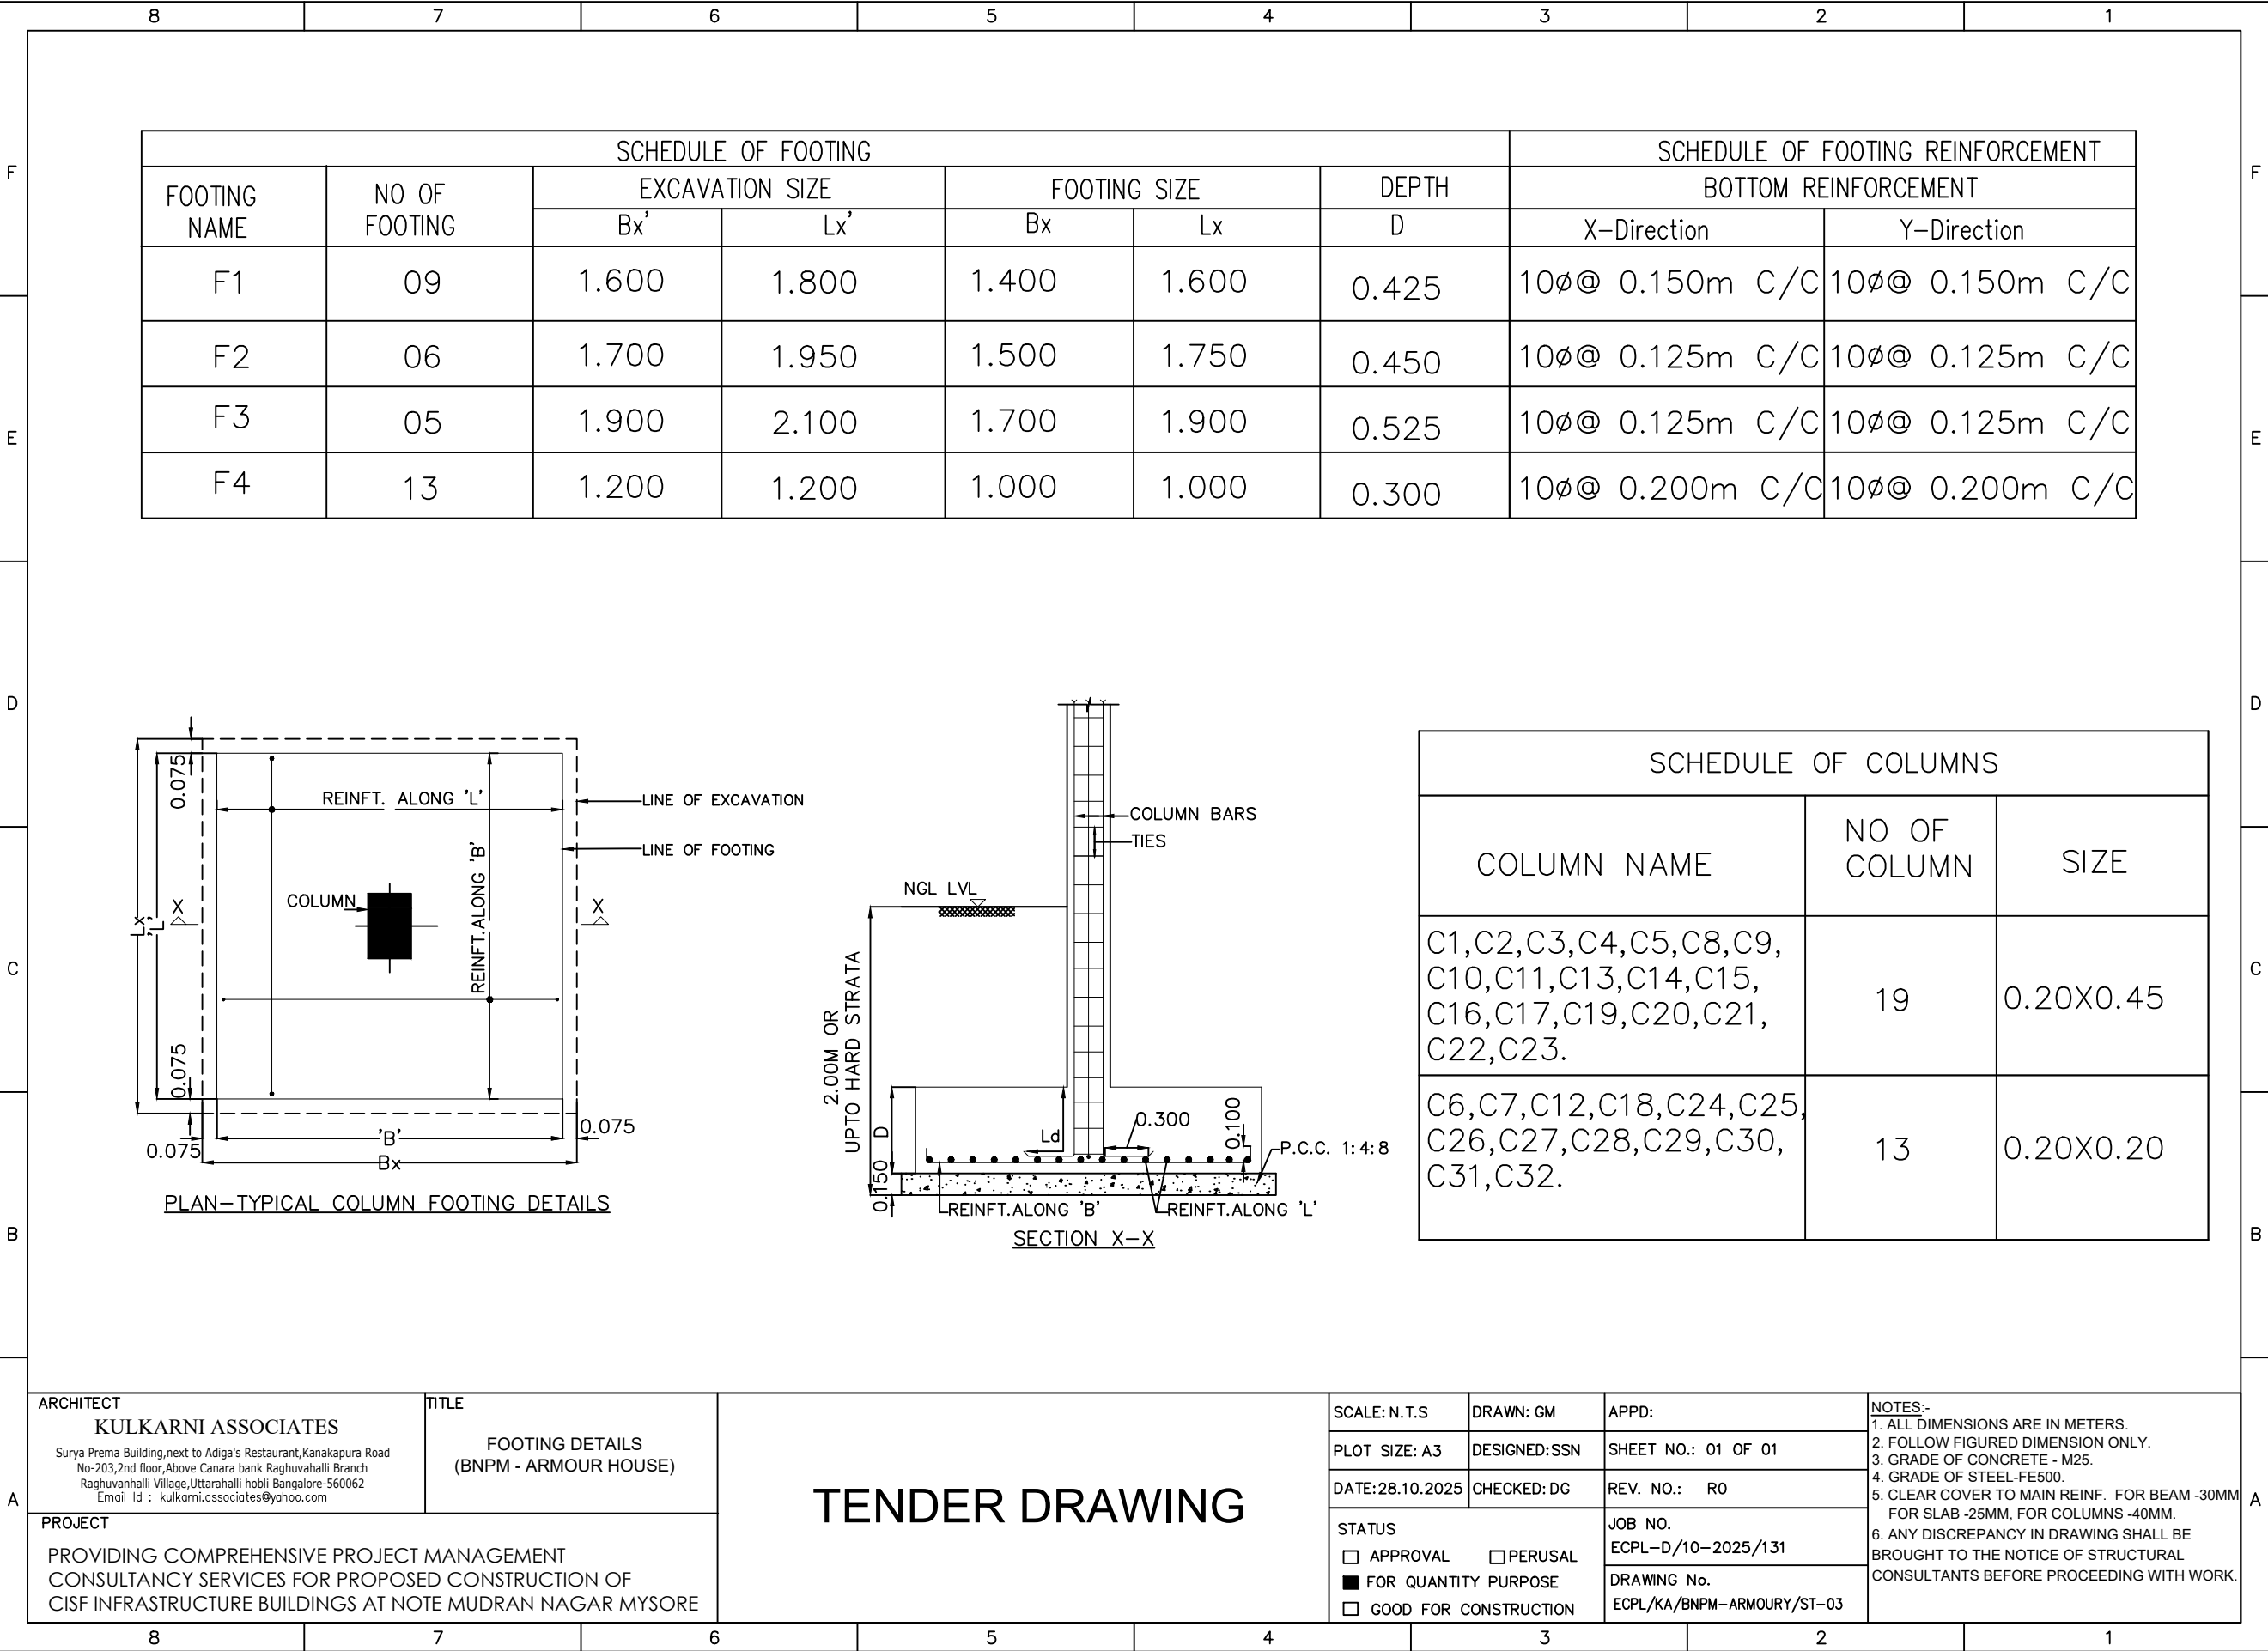

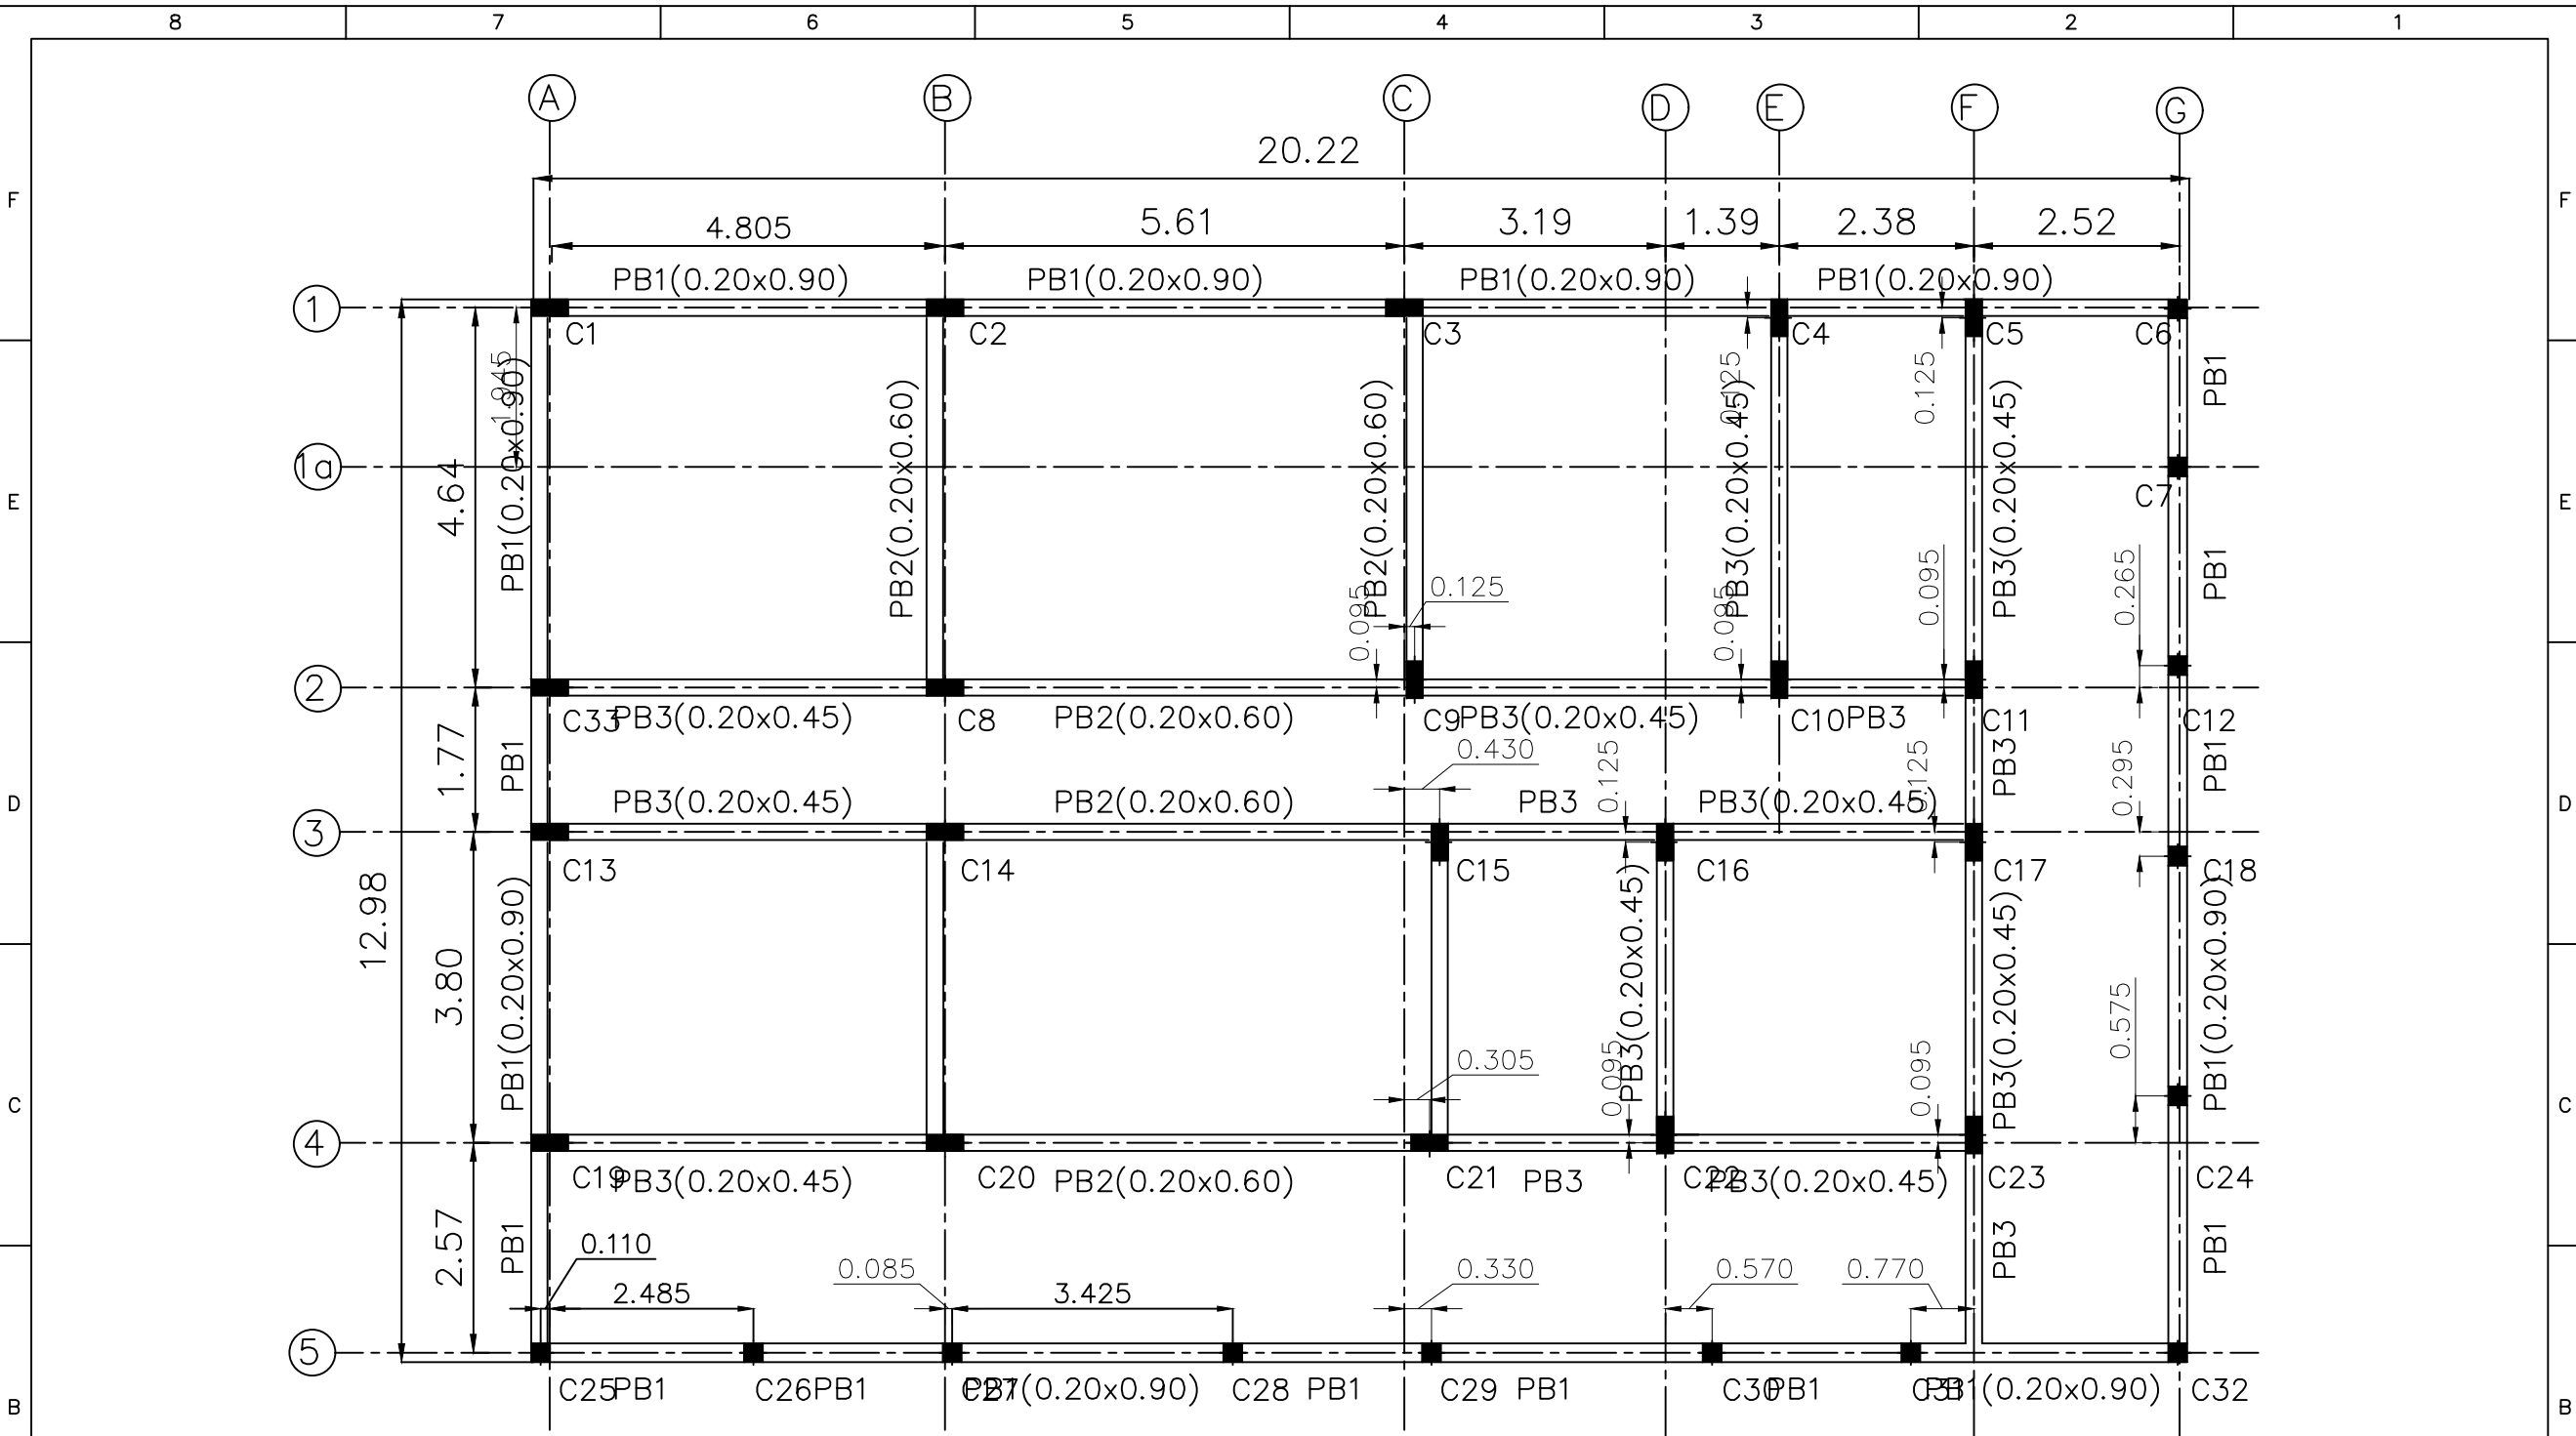

LAYOUT OF PLINTH BEAM

ARCHITECT

KULKARNI ASSOCIATES

Surya Prema Building, next to Adiga's Restaurant, Kanakapura Road
No-203, 2nd floor, Above Canara bank Raghuvahalli Branch
Raghuvahalli Village, Uttarahalli hobli Bangalore-560062
Email Id : kulkarni.associates@yahoo.com

TITLE

LAYOUT OF PLINTH BEAM
(BNPM - ARMOUR HOUSE)

PROJECT

PROVIDING COMPREHENSIVE PROJECT MANAGEMENT
CONSULTANCY SERVICES FOR PROPOSED CONSTRUCTION OF
CISF INFRASTRUCTURE BUILDINGS AT NOTE MUDRAN NAGAR MYSORE

TENDER DRAWING

SCALE: N.T.S

PLOT SIZE: A3

DATE: 28.10.2025

STATUS

☐ APPROVAL

☐ PERUSAL

☒ FOR QUANTITY PURPOSE

☐ GOOD FOR CONSTRUCTION

DRAWN: GM

DESIGNED: SSN

CHECKED: DG

JOB NO.
ECPL-D/10-2025/131

DRAWING No.
ECPL/KA/BNPM-ARMOURY/ST-04

APPD:

SHEET NO.: 01 OF 01

REV. NO.: R0

NOTES:-

1. ALL DIMENSIONS ARE IN METERS.


2. FOLLOW FIGURED DIMENSION ONLY.

3. GRADE OF CONCRETE - M25.

4. GRADE OF STEEL-FE500.

5. CLEAR COVER TO MAIN REINF. FOR BEAM -30MM
FOR SLAB -25MM, FOR COLUMNS -40MM.

6. ANY DISCREPANCY IN DRAWING SHALL BE
BROUGHT TO THE NOTICE OF STRUCTURAL
CONSULTANTS BEFORE PROCEEDING WITH WORK.

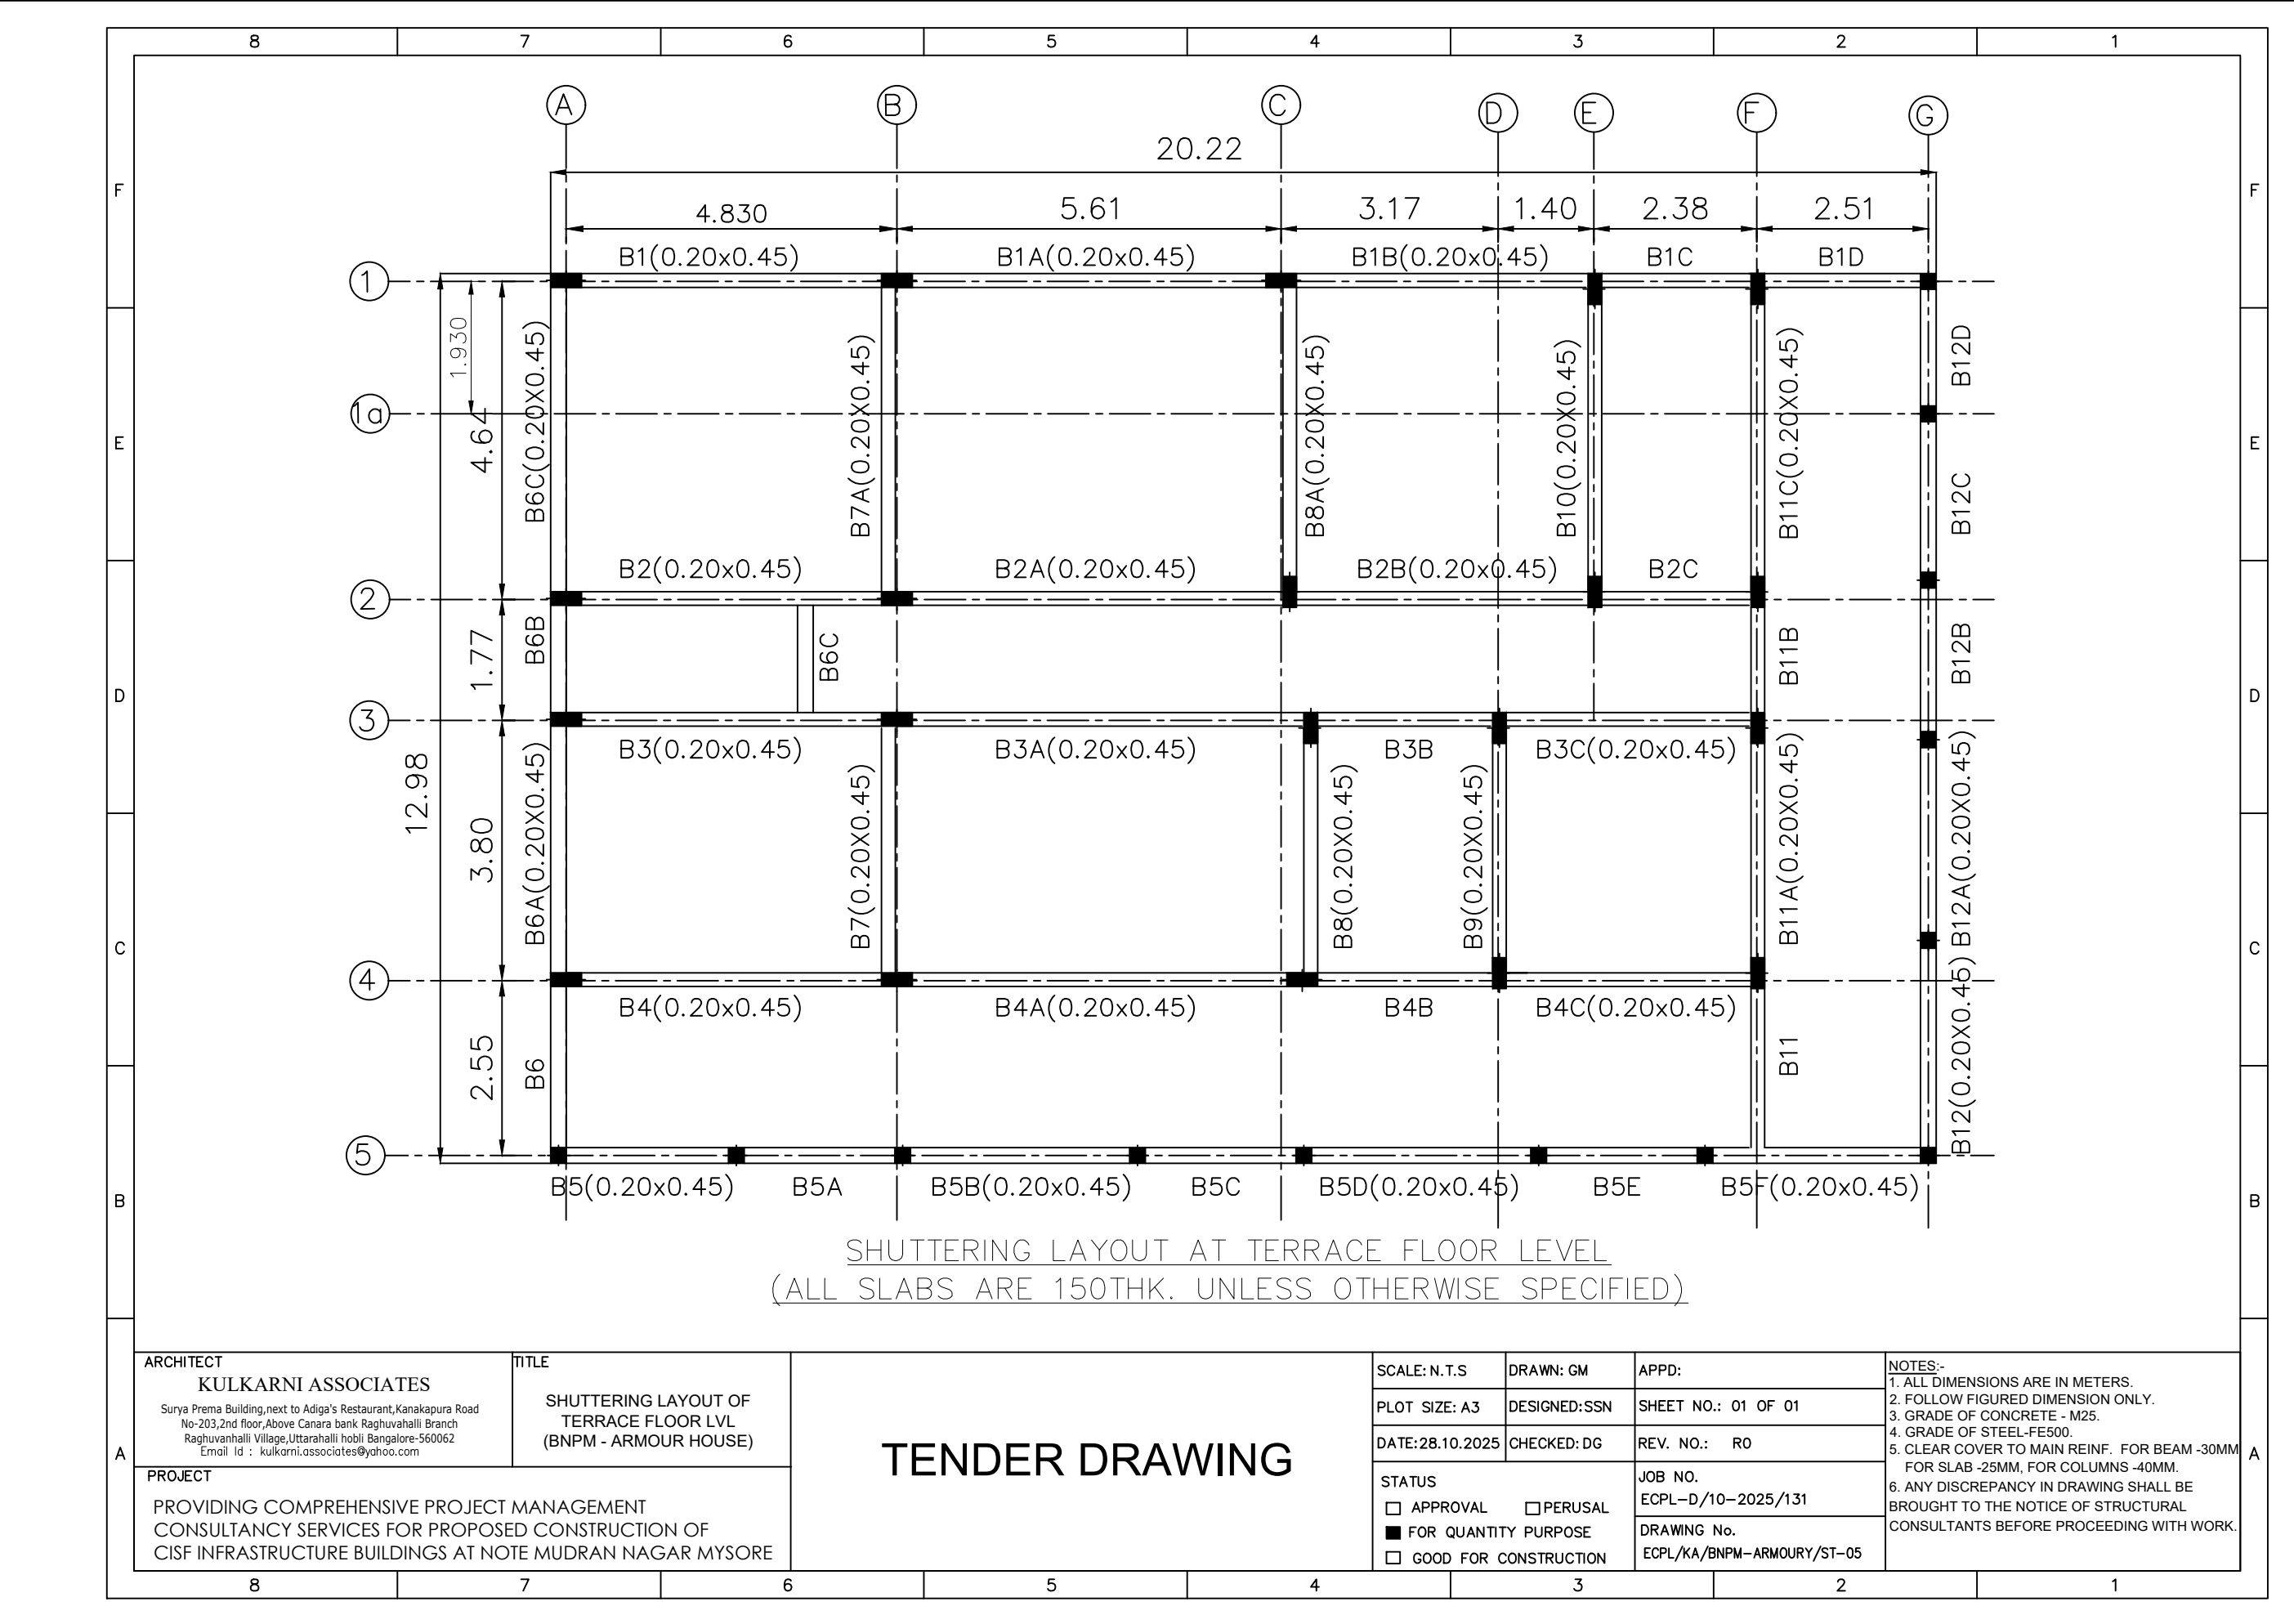

ARCHITECT

KULKARNI ASSOCIATES

Surya Prema Building,next to Adiga's Restaurant,Kanakapura Road
No-203,2nd floor,Above Canara bank Raghuvahalli Branch
Raghuvahalli Village,Uttarahalli hobli Bangalore-560062
Email Id : kulkarni.associates@yahoo.com

TITLE


SHUTTERING LAYOUT OF
TERRACE FLOOR LVL
(BNPM - ARMOUR HOUSE)

PROJECT


PROVIDING COMPREHENSIVE PROJECT MANAGEMENT
CONSULTANCY SERVICES FOR PROPOSED CONSTRUCTION OF
CISF INFRASTRUCTURE BUILDINGS AT NOTE MUDRAN NAGAR MYSORE

TENDER DRAWING

SCALE: N.T.S	DRAWN: GM	APPD:	NOTES:- 1. ALL DIMENSIONS ARE IN METERS. 2. FOLLOW FIGURED DIMENSION ONLY. 3. GRADE OF CONCRETE - M25. 4. GRADE OF STEEL-FE500. 5. CLEAR COVER TO MAIN REINF. FOR BEAM -30MM FOR SLAB -25MM, FOR COLUMNS -40MM. 6. ANY DISCREPANCY IN DRAWING SHALL BE BROUGHT TO THE NOTICE OF STRUCTURAL CONSULTANTS BEFORE PROCEEDING WITH WORK.
PLOT SIZE: A3	DESIGNED:SSN	SHEET NO.: 01 OF 01	
DATE:28.10.2025	CHECKED: DG	REV. NO.: R0	
STATUS ☐ APPROVAL ☐ PERUSAL ☒ FOR QUANTITY PURPOSE ☐ GOOD FOR CONSTRUCTION		JOB NO. ECPL-D/10-2025/131	
		DRAWING No. ECPL/KA/BNPM-ARMOURY/ST-05	

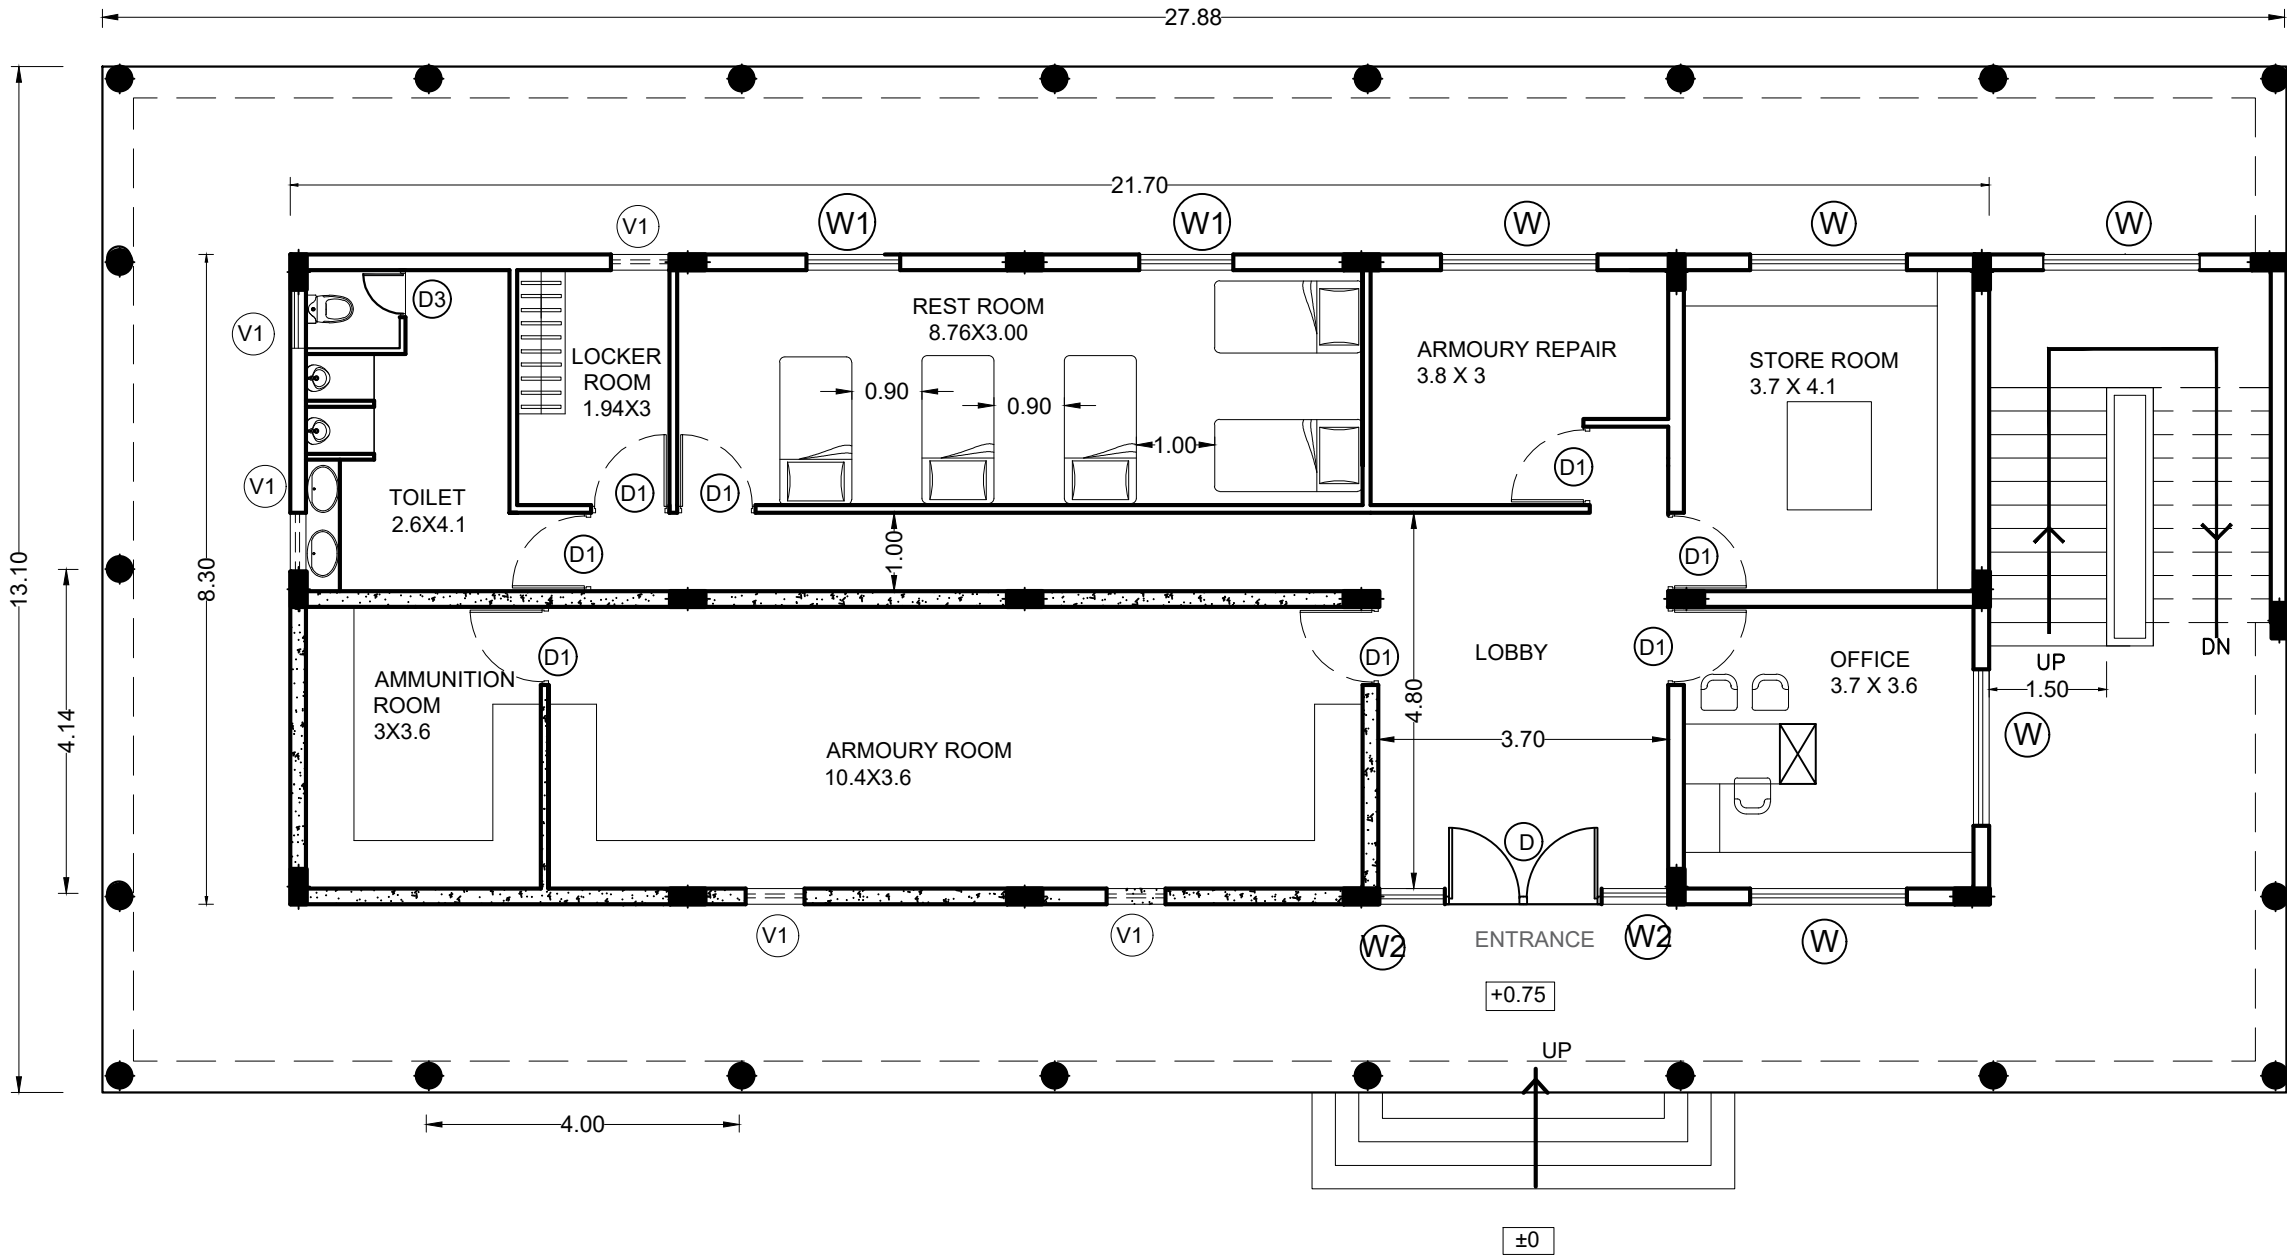

GROUND FLOOR PLAN

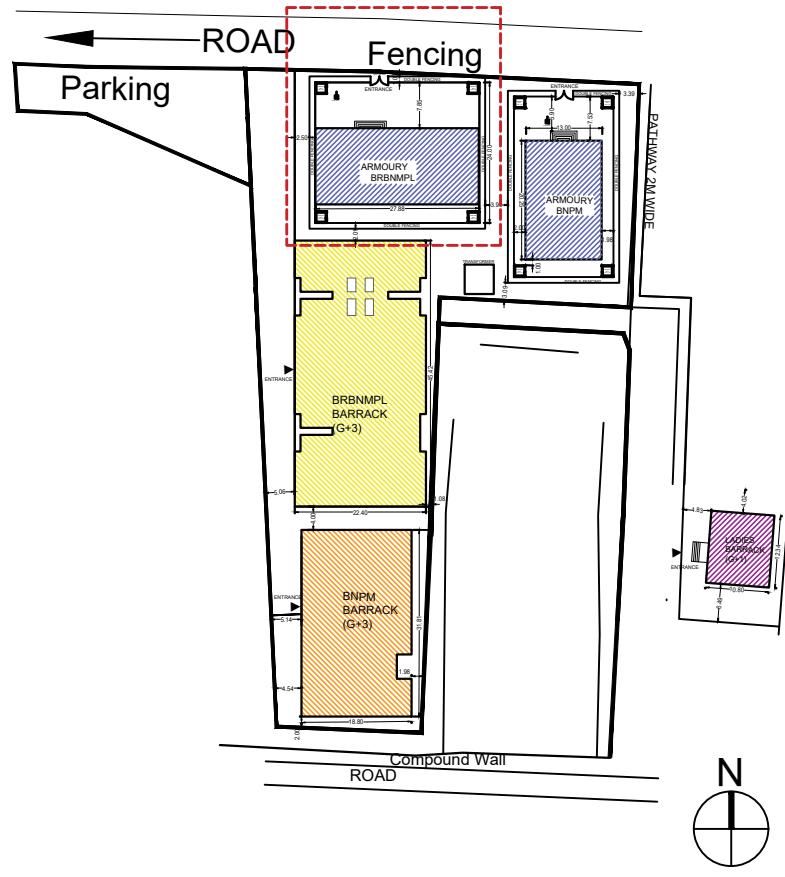


NOTE : ALL DIMENSION IN METERS


PROJECT :
PROVIDING COMPREHENSIVE PROJECT
MANAGEMENT CONSULTANCY SERVICES FOR
PROPOSED CONSTRUCTION OF CISF
INFRASTRUCTURE BUILDINGS
AT NOTE MUDRAN NAGAR MYSORE

TENDER DRAWING


BRBNMPL- ARMOUR HOUSE PLAN	
Date : 10-10-2025	Drawn by: AMRUTHA
Page 83 of 129	Checked by: Ar. Kavitha
Rev Date:	

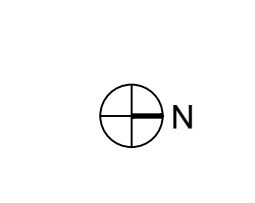

ARCHITECTS :
KULKARNI ASSOCIATES
Surya Prema Building, next to Adiga's Restaurant, Kanakapura Road
No-203, 2nd floor, Above Canara bank Raghuvahalli Branch
Raghuvahalli Village, Uttarahalli hobli Bangalore-560062
Email Id : kulkarni.associates@yahoo.com

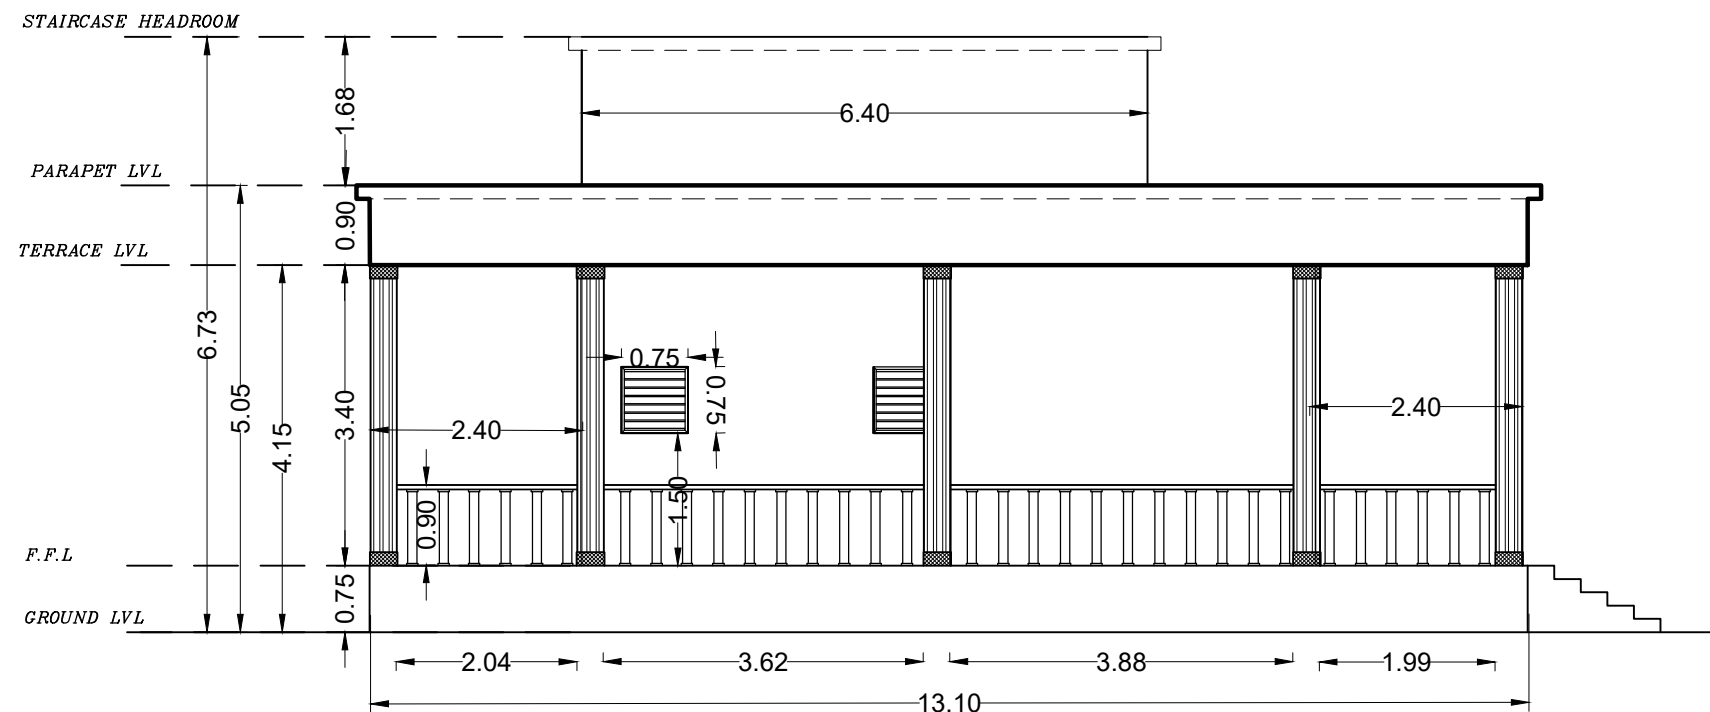

SOUTH ELEVATION

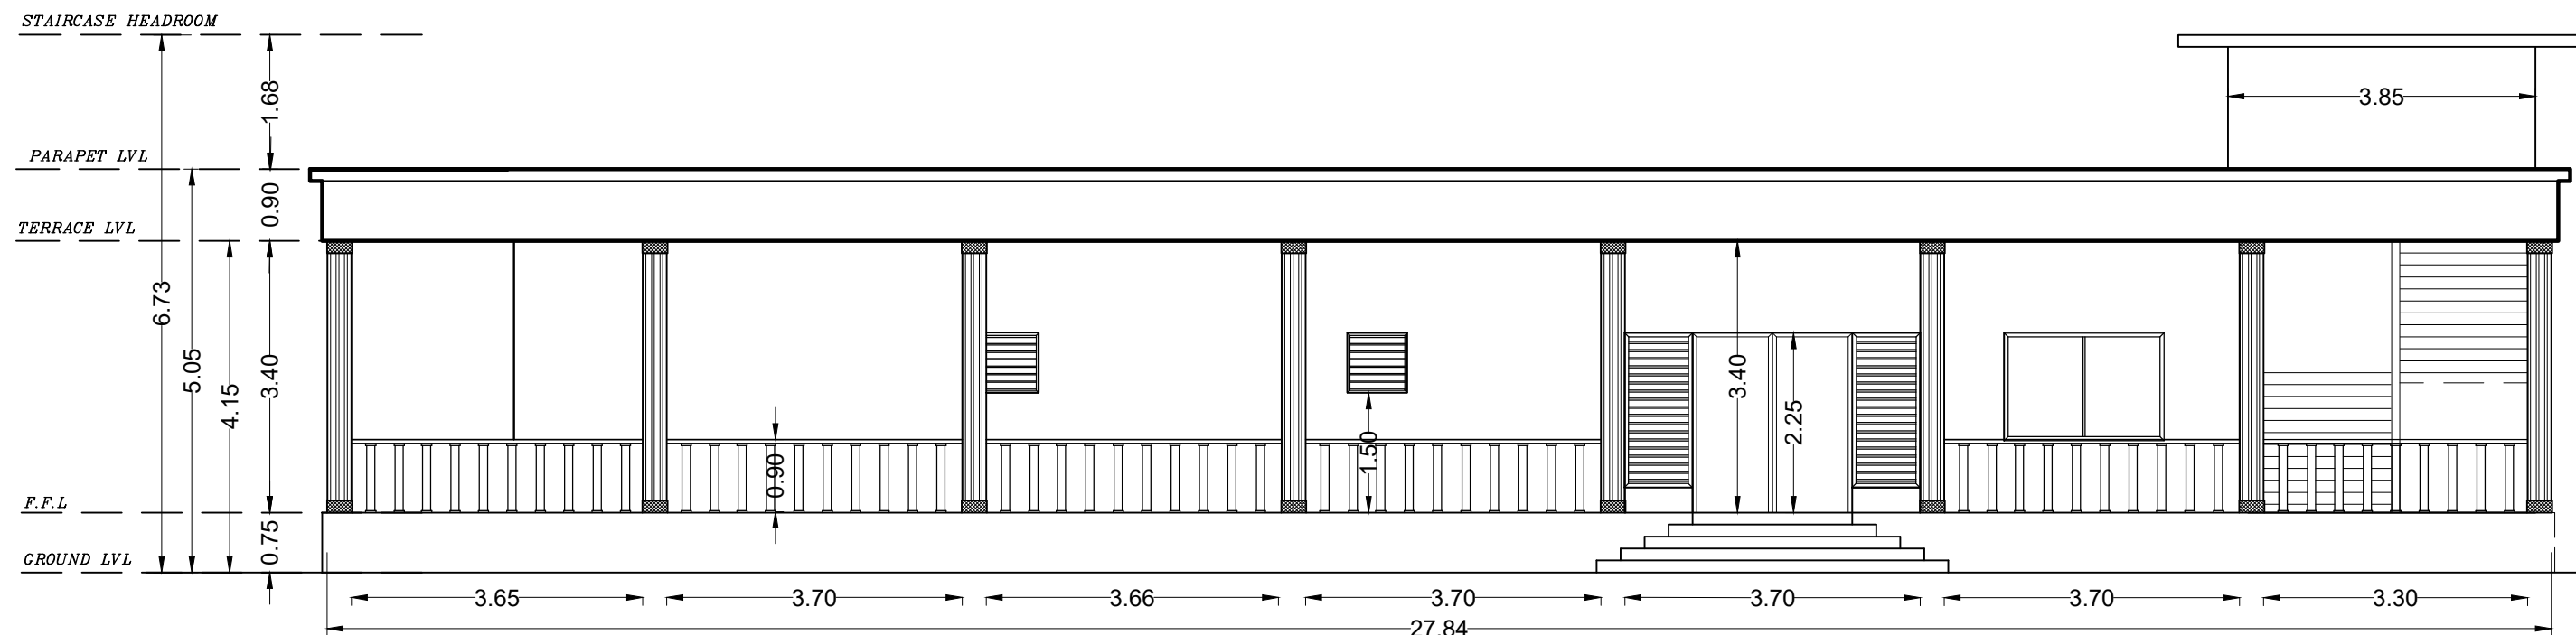

EAST ELEVATION

NOTE : ALL DIMENSION IN METERS

PROJECT :
PROVIDING COMPREHENSIVE PROJECT
MANAGEMENT CONSULTANCY SERVICES FOR
PROPOSED CONSTRUCTION OF CISF
INFRASTRUCTURE BUILDINGS
AT NOTE MUDRAN NAGAR MYSORE

TENDER DRAWING

Page 84 of 129

BRBNMPL- ARMOUR HOUSE ELEVATION

Date : 30-10-2025

Drawn by: AMRUTHA

Scale : NTS


Checked by: Ar. Kavitha

Rev Date: -----


ARCHITECTS :
KULKARNI ASSOCIATES

Surya Prema Building,next to Adiga's Restaurant,Kanakapura Road
No-203,2nd floor,Above Canara bank Raghuvahalli Branch
Raghuvahalli Village,Uttarahalli hobli Bangalore-560062

Email Id : kulkarni.associates@yahoo.com

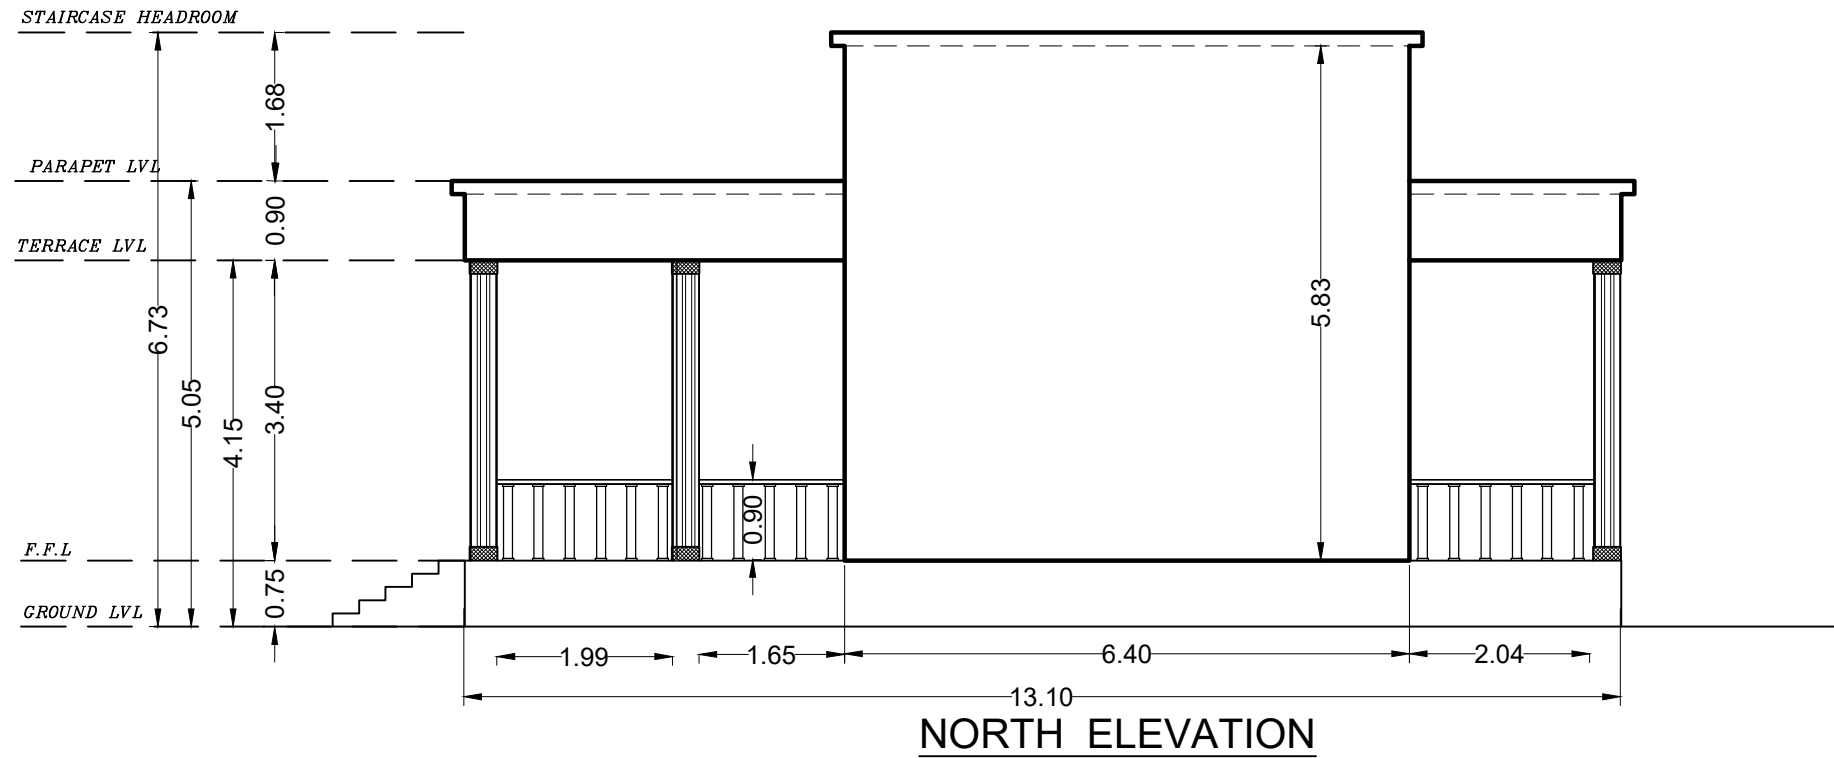

NORTH ELEVATION

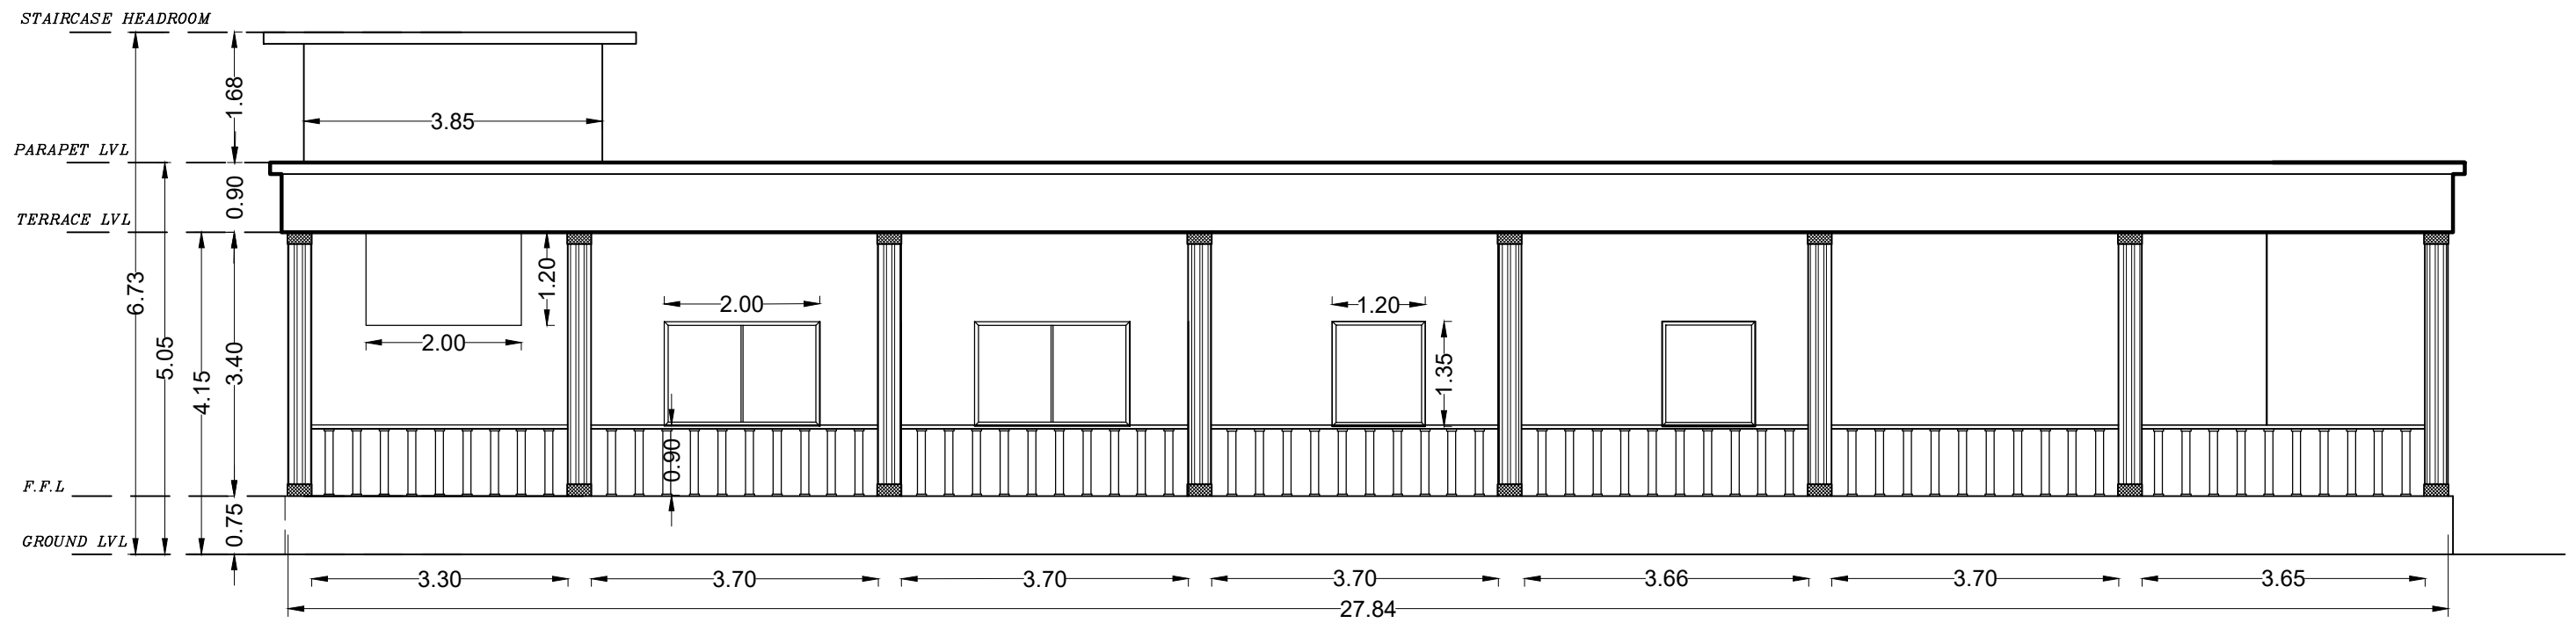

WEST ELEVATION

NOTE : ALL DIMENSION IN METERS

PROJECT :
PROVIDING COMPREHENSIVE PROJECT
MANAGEMENT CONSULTANCY SERVICES FOR
PROPOSED CONSTRUCTION OF CISF
INFRASTRUCTURE BUILDINGS
AT NOTE MUDRAN NAGAR MYSORE

TENDER DRAWING

Page 85 of 129

BRBNMPL- ARMOUR HOUSE ELEVATION

Date : 30-10-2025

Drawn by: AMRUTHA



Checked by: Ar. Kavitha

Rev Date:


ARCHITECTS :
KULKARNI ASSOCIATES

Surya Prema Building, next to Adiga's Restaurant, Kanakapura Road
No-203, 2nd floor, Above Canara bank Raghuvahalli Branch
Raghuvahalli Village, Uttarahalli hobli Bangalore-560062

Email Id : kulkarni.associates@yahoo.com

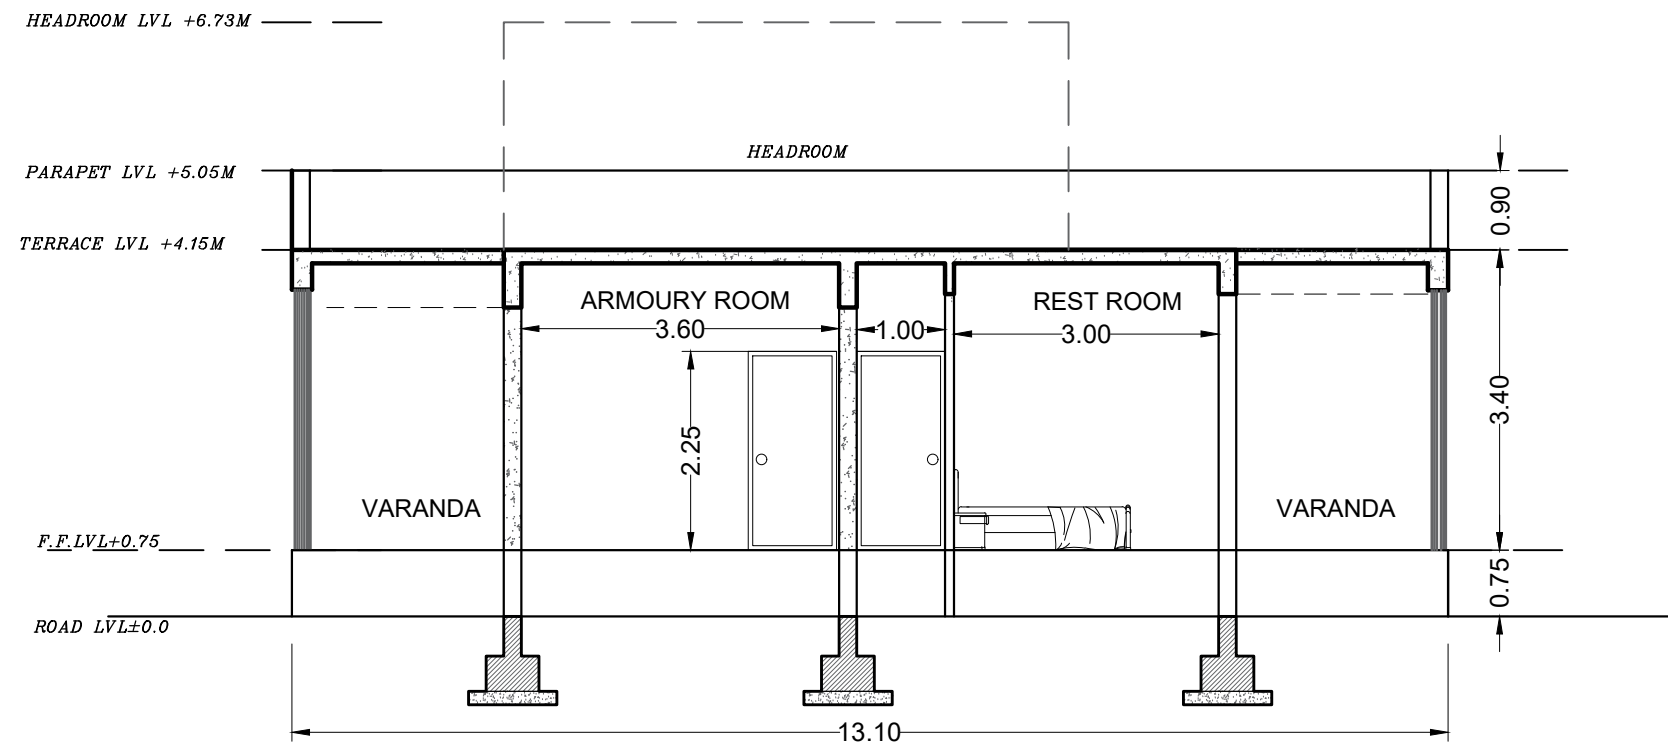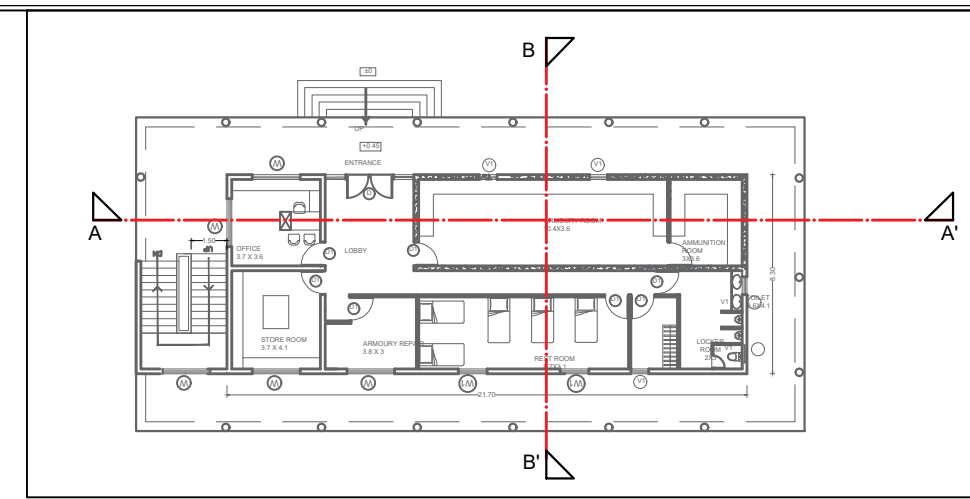

SECTION- AA

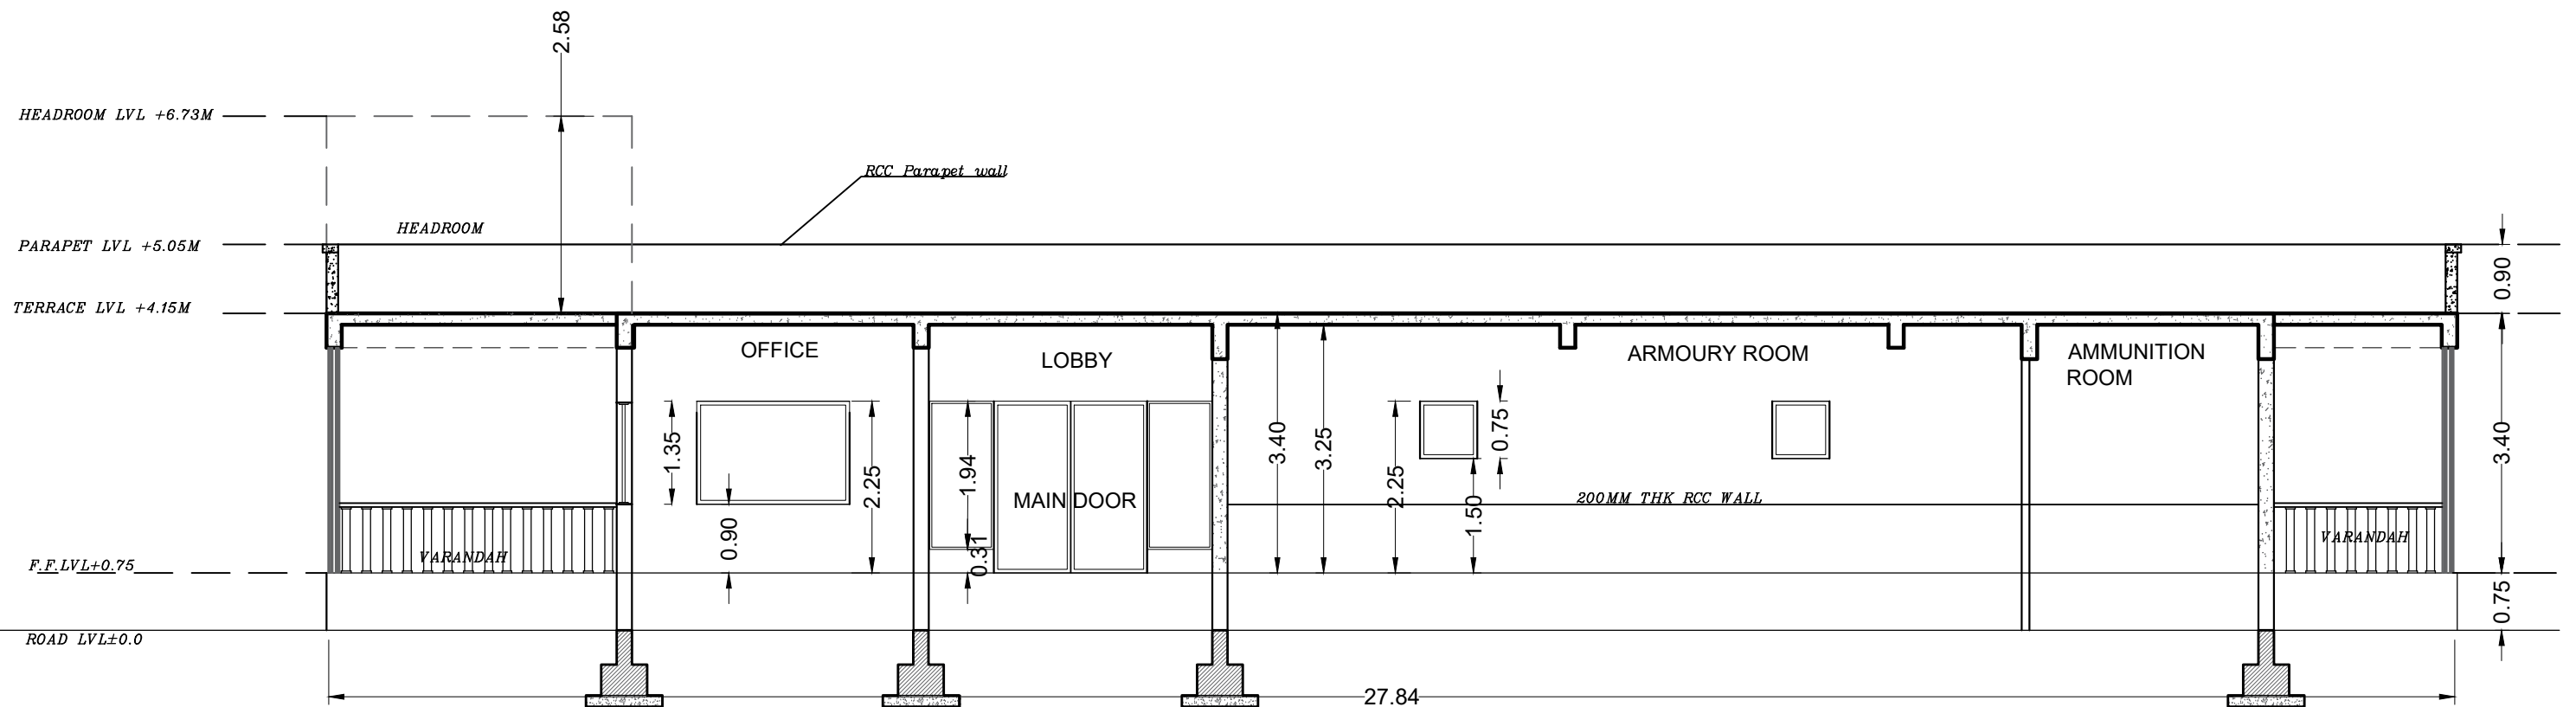

SECTION- BB

NOTE : ALL DIMENSION IN METERS

PROJECT :
PROVIDING COMPREHENSIVE PROJECT
MANAGEMENT CONSULTANCY SERVICES FOR
PROPOSED CONSTRUCTION OF CISF
INFRASTRUCTURE BUILDINGS
AT NOTE MUDRAN NAGAR MYSORE

TENDER DRAWING

Page 86 of 129

BRBNMPL- ARMOUR HOUSE SECTION

Date : 30-10-2025

Drawn by: AMRUTHA


Rev Date: -----

Checked by: Ar. Kavitha

ARCHITECTS :
KULKARNI ASSOCIATES

Surya Prema Building, next to Adiga's Restaurant, Kanakapura Road
No-203, 2nd floor, Above Canara bank Raghuvahalli Branch
Raghuvahalli Village, Uttarahalli hobli Bangalore-560062

Email Id : kulkarni.associates@yahoo.com

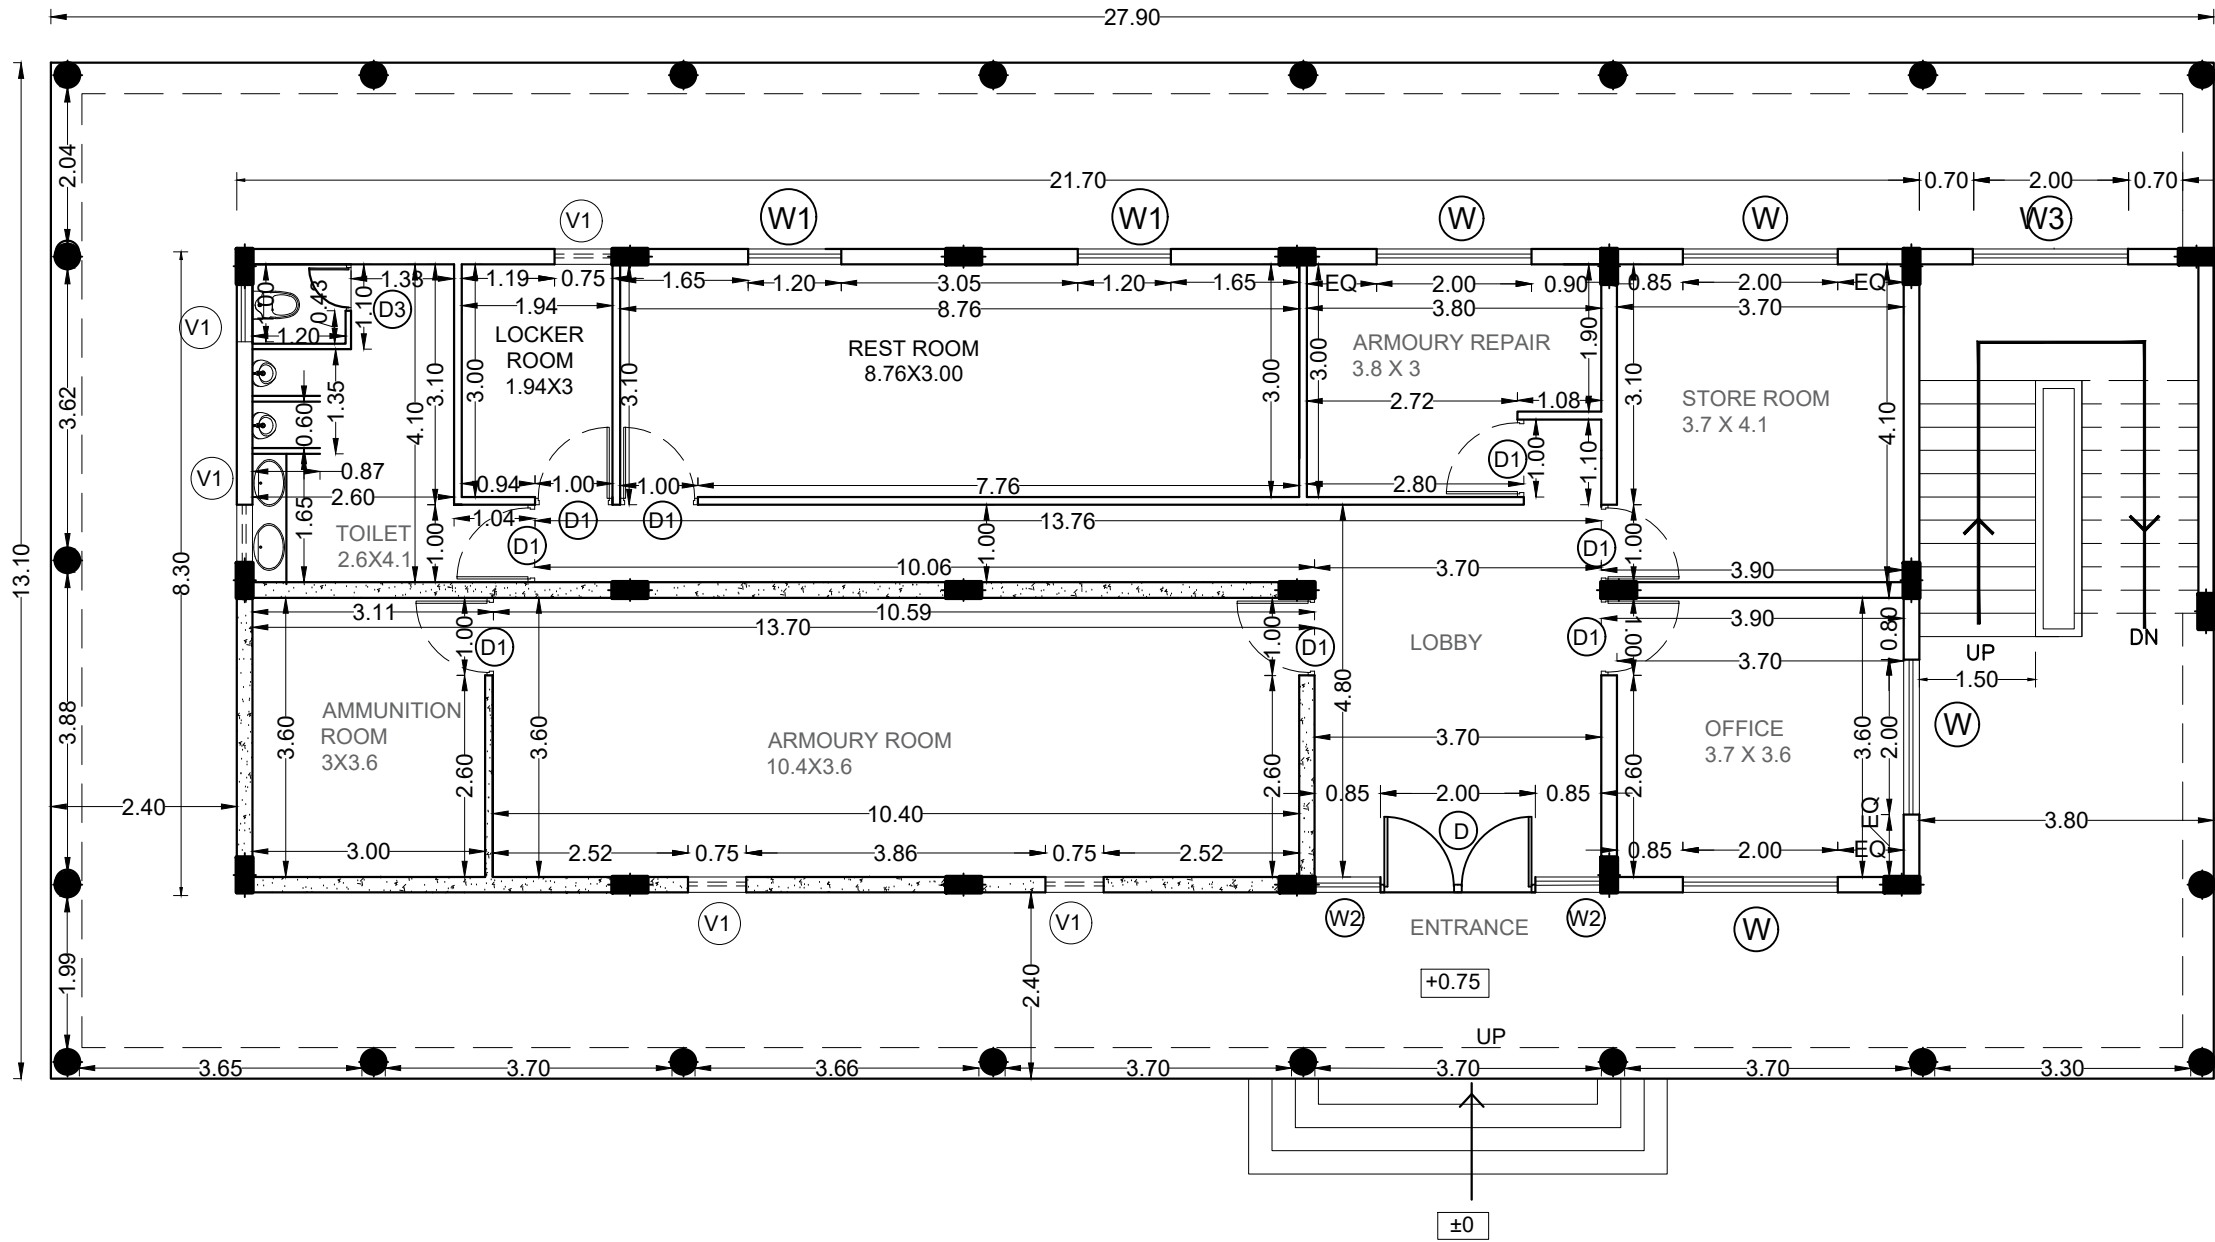

GROUND FLOOR PLAN

SCHEDULE OF OPENINGS		
DOORS		
	SIZE IN M	Nos
D	2.00 X 2.25	1
D1	1.00 X 2.25	8
D3	0.75 X 2.25 (TOILET)	1
WINDOWS		
W	2.00 X 1.35	4
W1	1.20 X 1.35	2
W2	0.85 X 1.94	2
W3	2.00 X 1.20	1
VENTILATORS		
V1	0.75X 0.75	5

NOTE : ALL DIMENSION IN METERS

PROJECT :
PROVIDING COMPREHENSIVE PROJECT
MANAGEMENT CONSULTANCY SERVICES FOR
PROPOSED CONSTRUCTION OF CISF
INFRASTRUCTURE BUILDINGS
AT NOTE MUDRAN NAGAR MYSORE

**BRBNMPL- ARMOUR HOUSE
CENTER LINE PLAN**

Date : 30-10-2025

Drawn by: AMRUTHA

Rev Date:


Checked by: Ar. Kavitha



ARCHITECTS :
KULKARNI ASSOCIATES

Surya Prema Building, next to Adiga's Restaurant, Kanakapura Road
No-203, 2nd floor, Above Canara bank Raghuvahalli Branch
Raghuvahalli Village, Uttarahalli hobli Bangalore-560062

Email Id : kulkarni.associates@yahoo.com

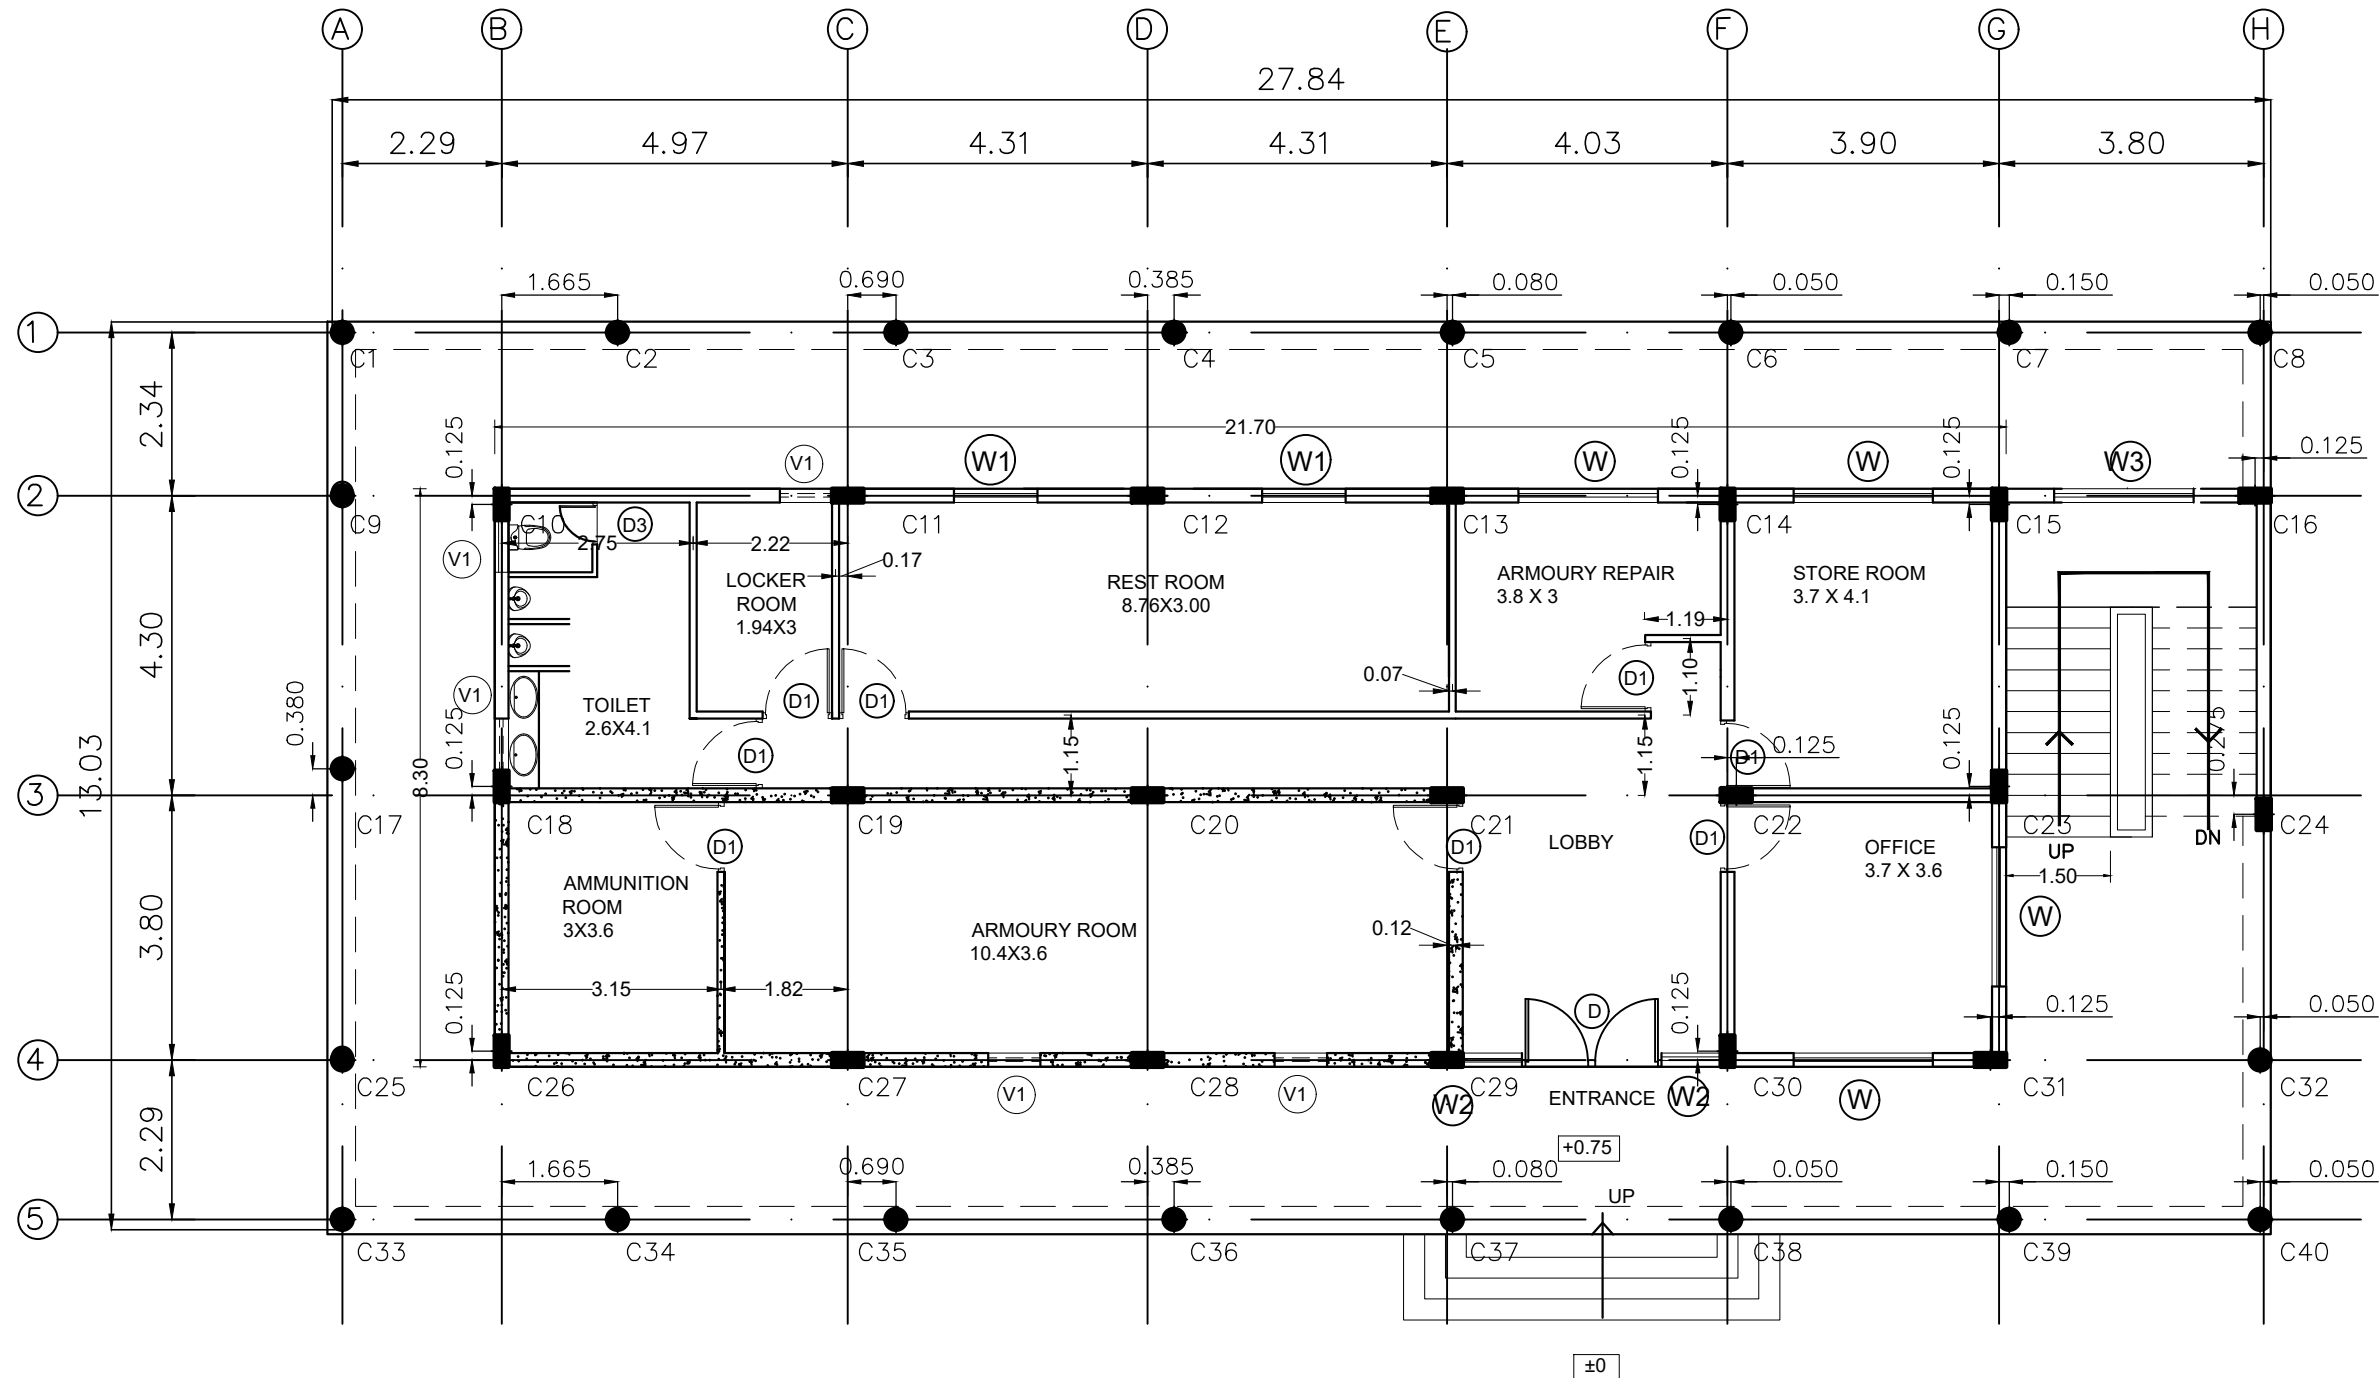

GROUND FLOOR PLAN

SCHEDULE OF OPENINGS

DOORS

	SIZE IN M	Nos
D	2.00 X 2.25	1
D1	1.00 X 2.25	8
D3	0.75 X 2.25 (TOILET)	1

WINDOWS

W	2.00 X 1.35	4
W1	1.20 X 1.35	2
W2	0.85 X 1.94	2
W3	2.00 X 1.20	1

VENTILATORS

V1	0.75X 0.75	5
----	------------	---

NOTE : ALL DIMENSION IN METERS

PROJECT :
PROVIDING COMPREHENSIVE PROJECT
MANAGEMENT CONSULTANCY SERVICES FOR
PROPOSED CONSTRUCTION OF CISF
INFRASTRUCTURE BUILDINGS
AT NOTE MUDRAN NAGAR MYSORE

BRBNMPL- ARMOUR HOUSE
CENTER LINE PLAN

Page 88 of 129

Date : 30-10-2025

Drawn by: AMRUTHA

Rev Date: -----


Checked by: Ar. Kavitha





ARCHITECTS :
KULKARNI ASSOCIATES

Surya Prema Building, next to Adiga's Restaurant, Kanakapura Road
No-203, 2nd floor, Above Canara bank Raghuvahalli Branch
Raghuvahalli Village, Uttarahalli hobli Bangalore-560062

Email Id : kulkarni.associates@yahoo.com

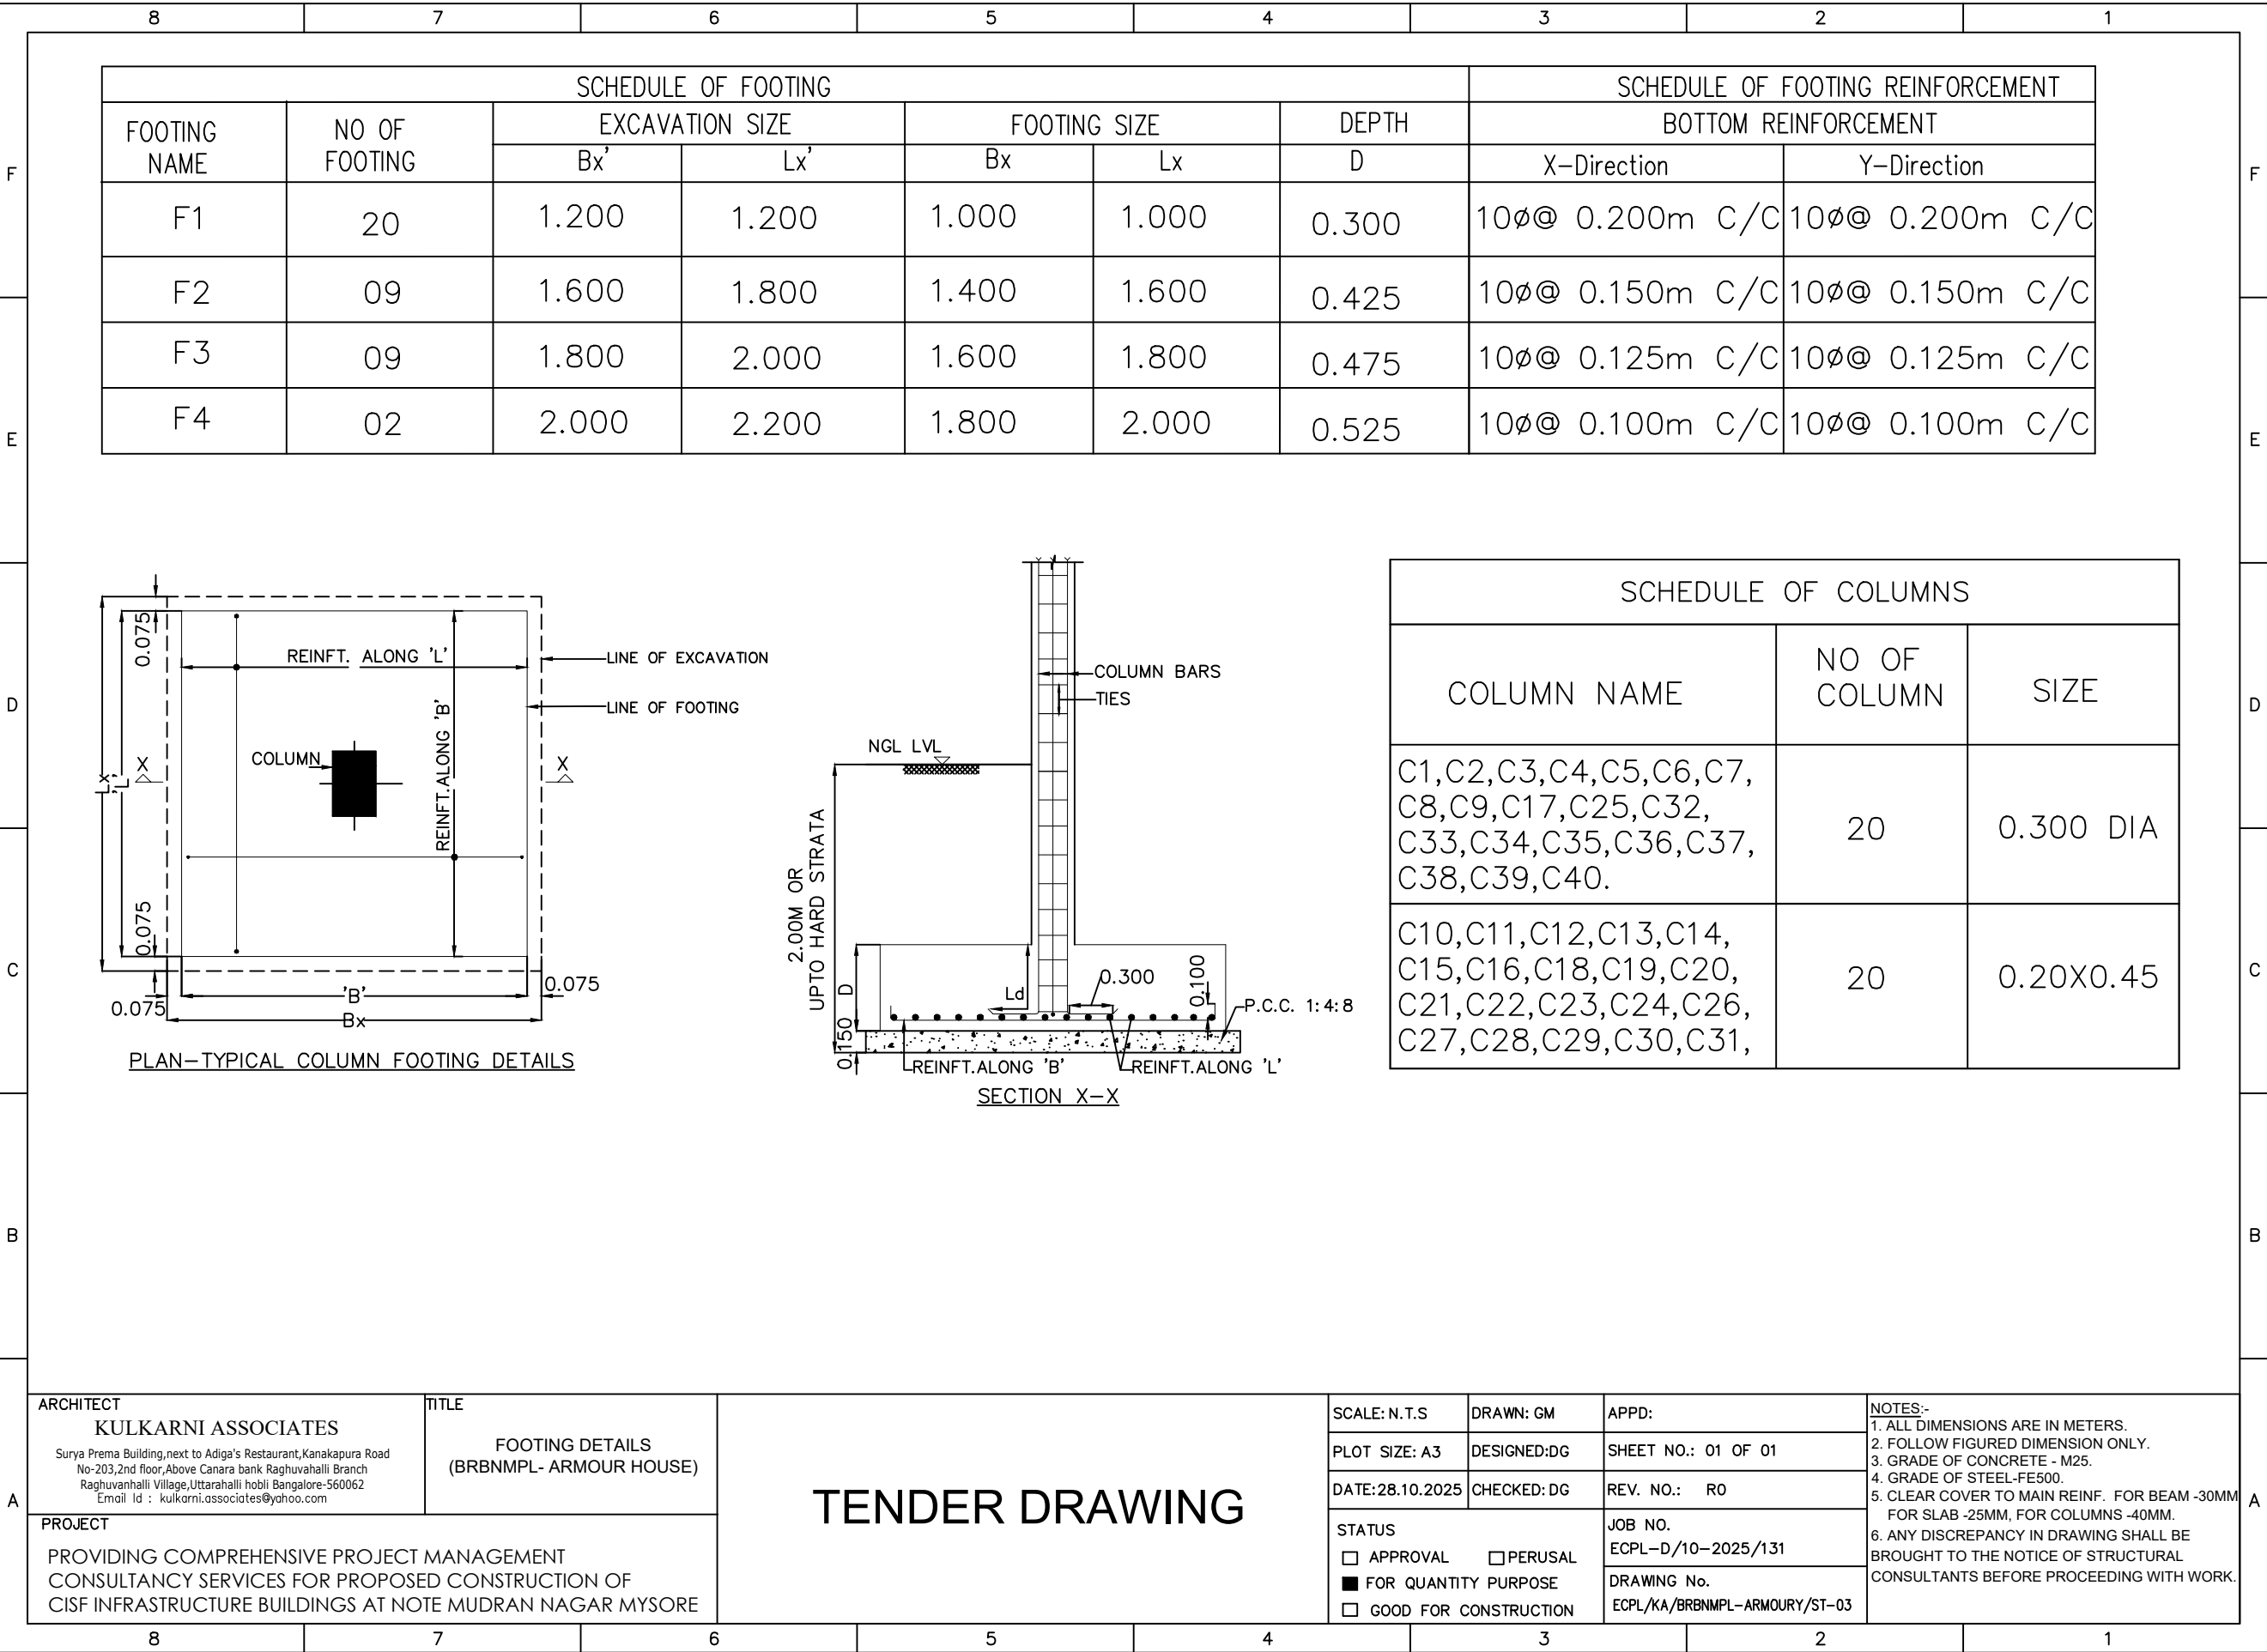

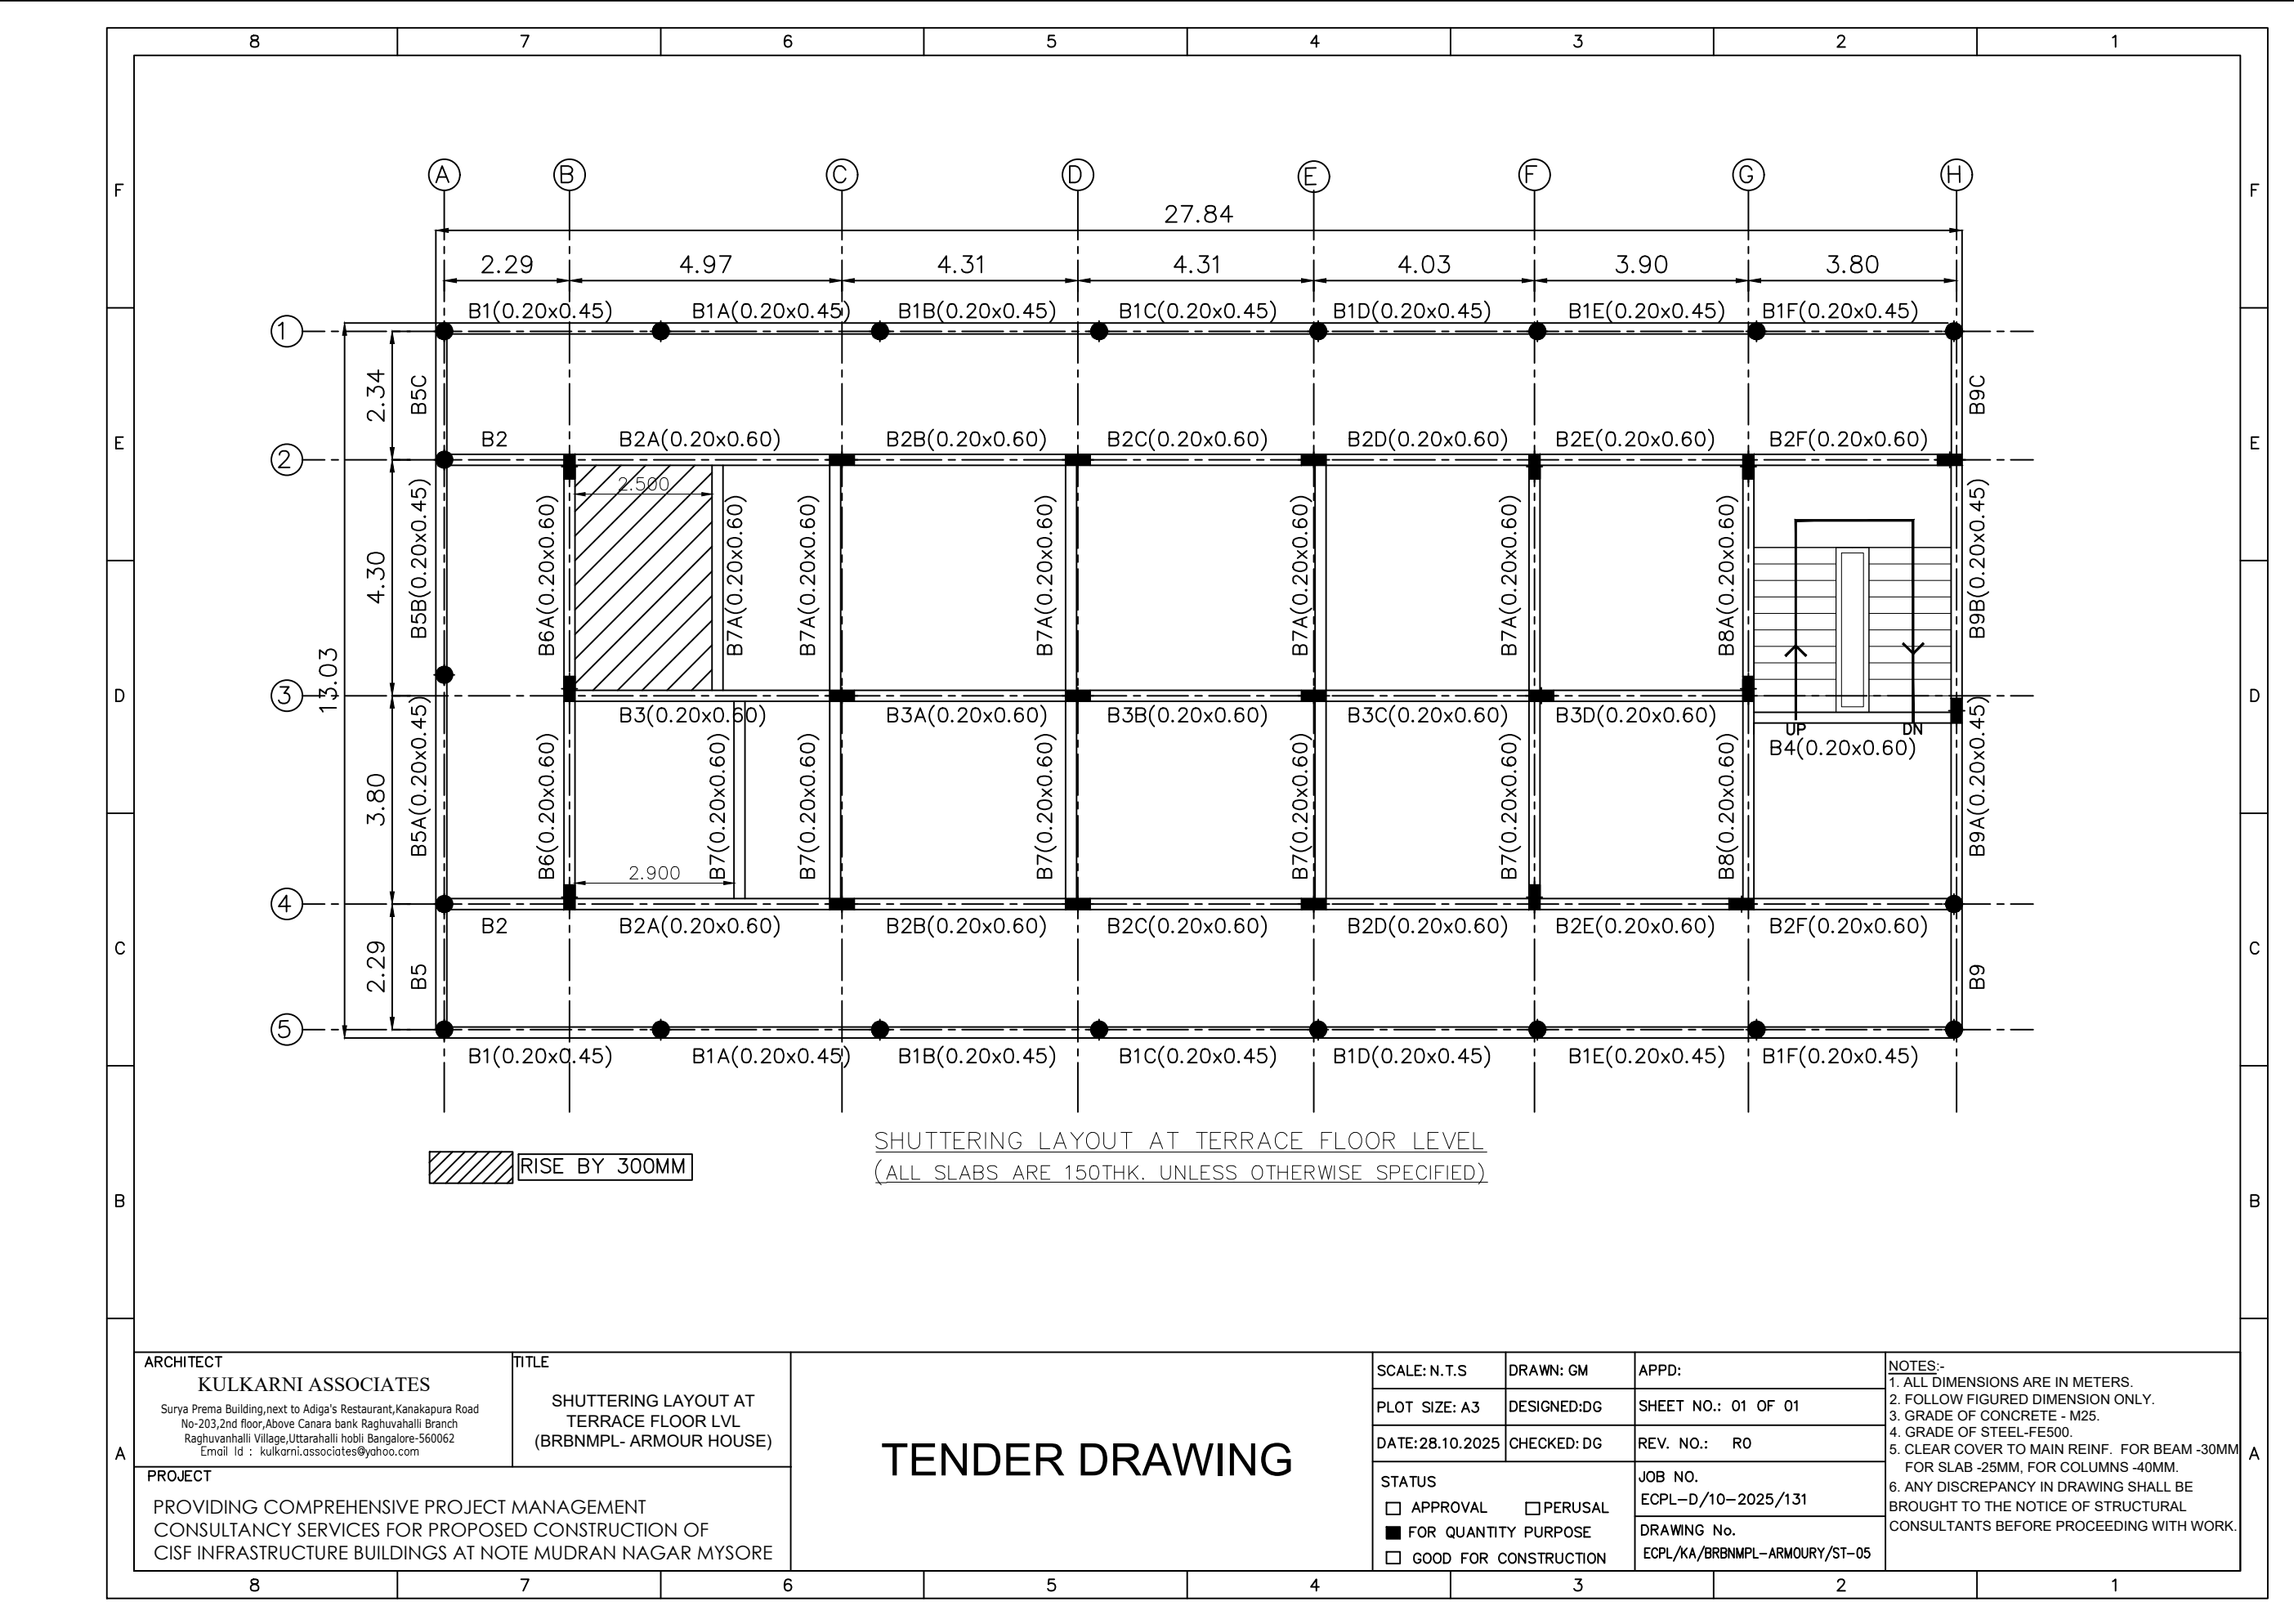

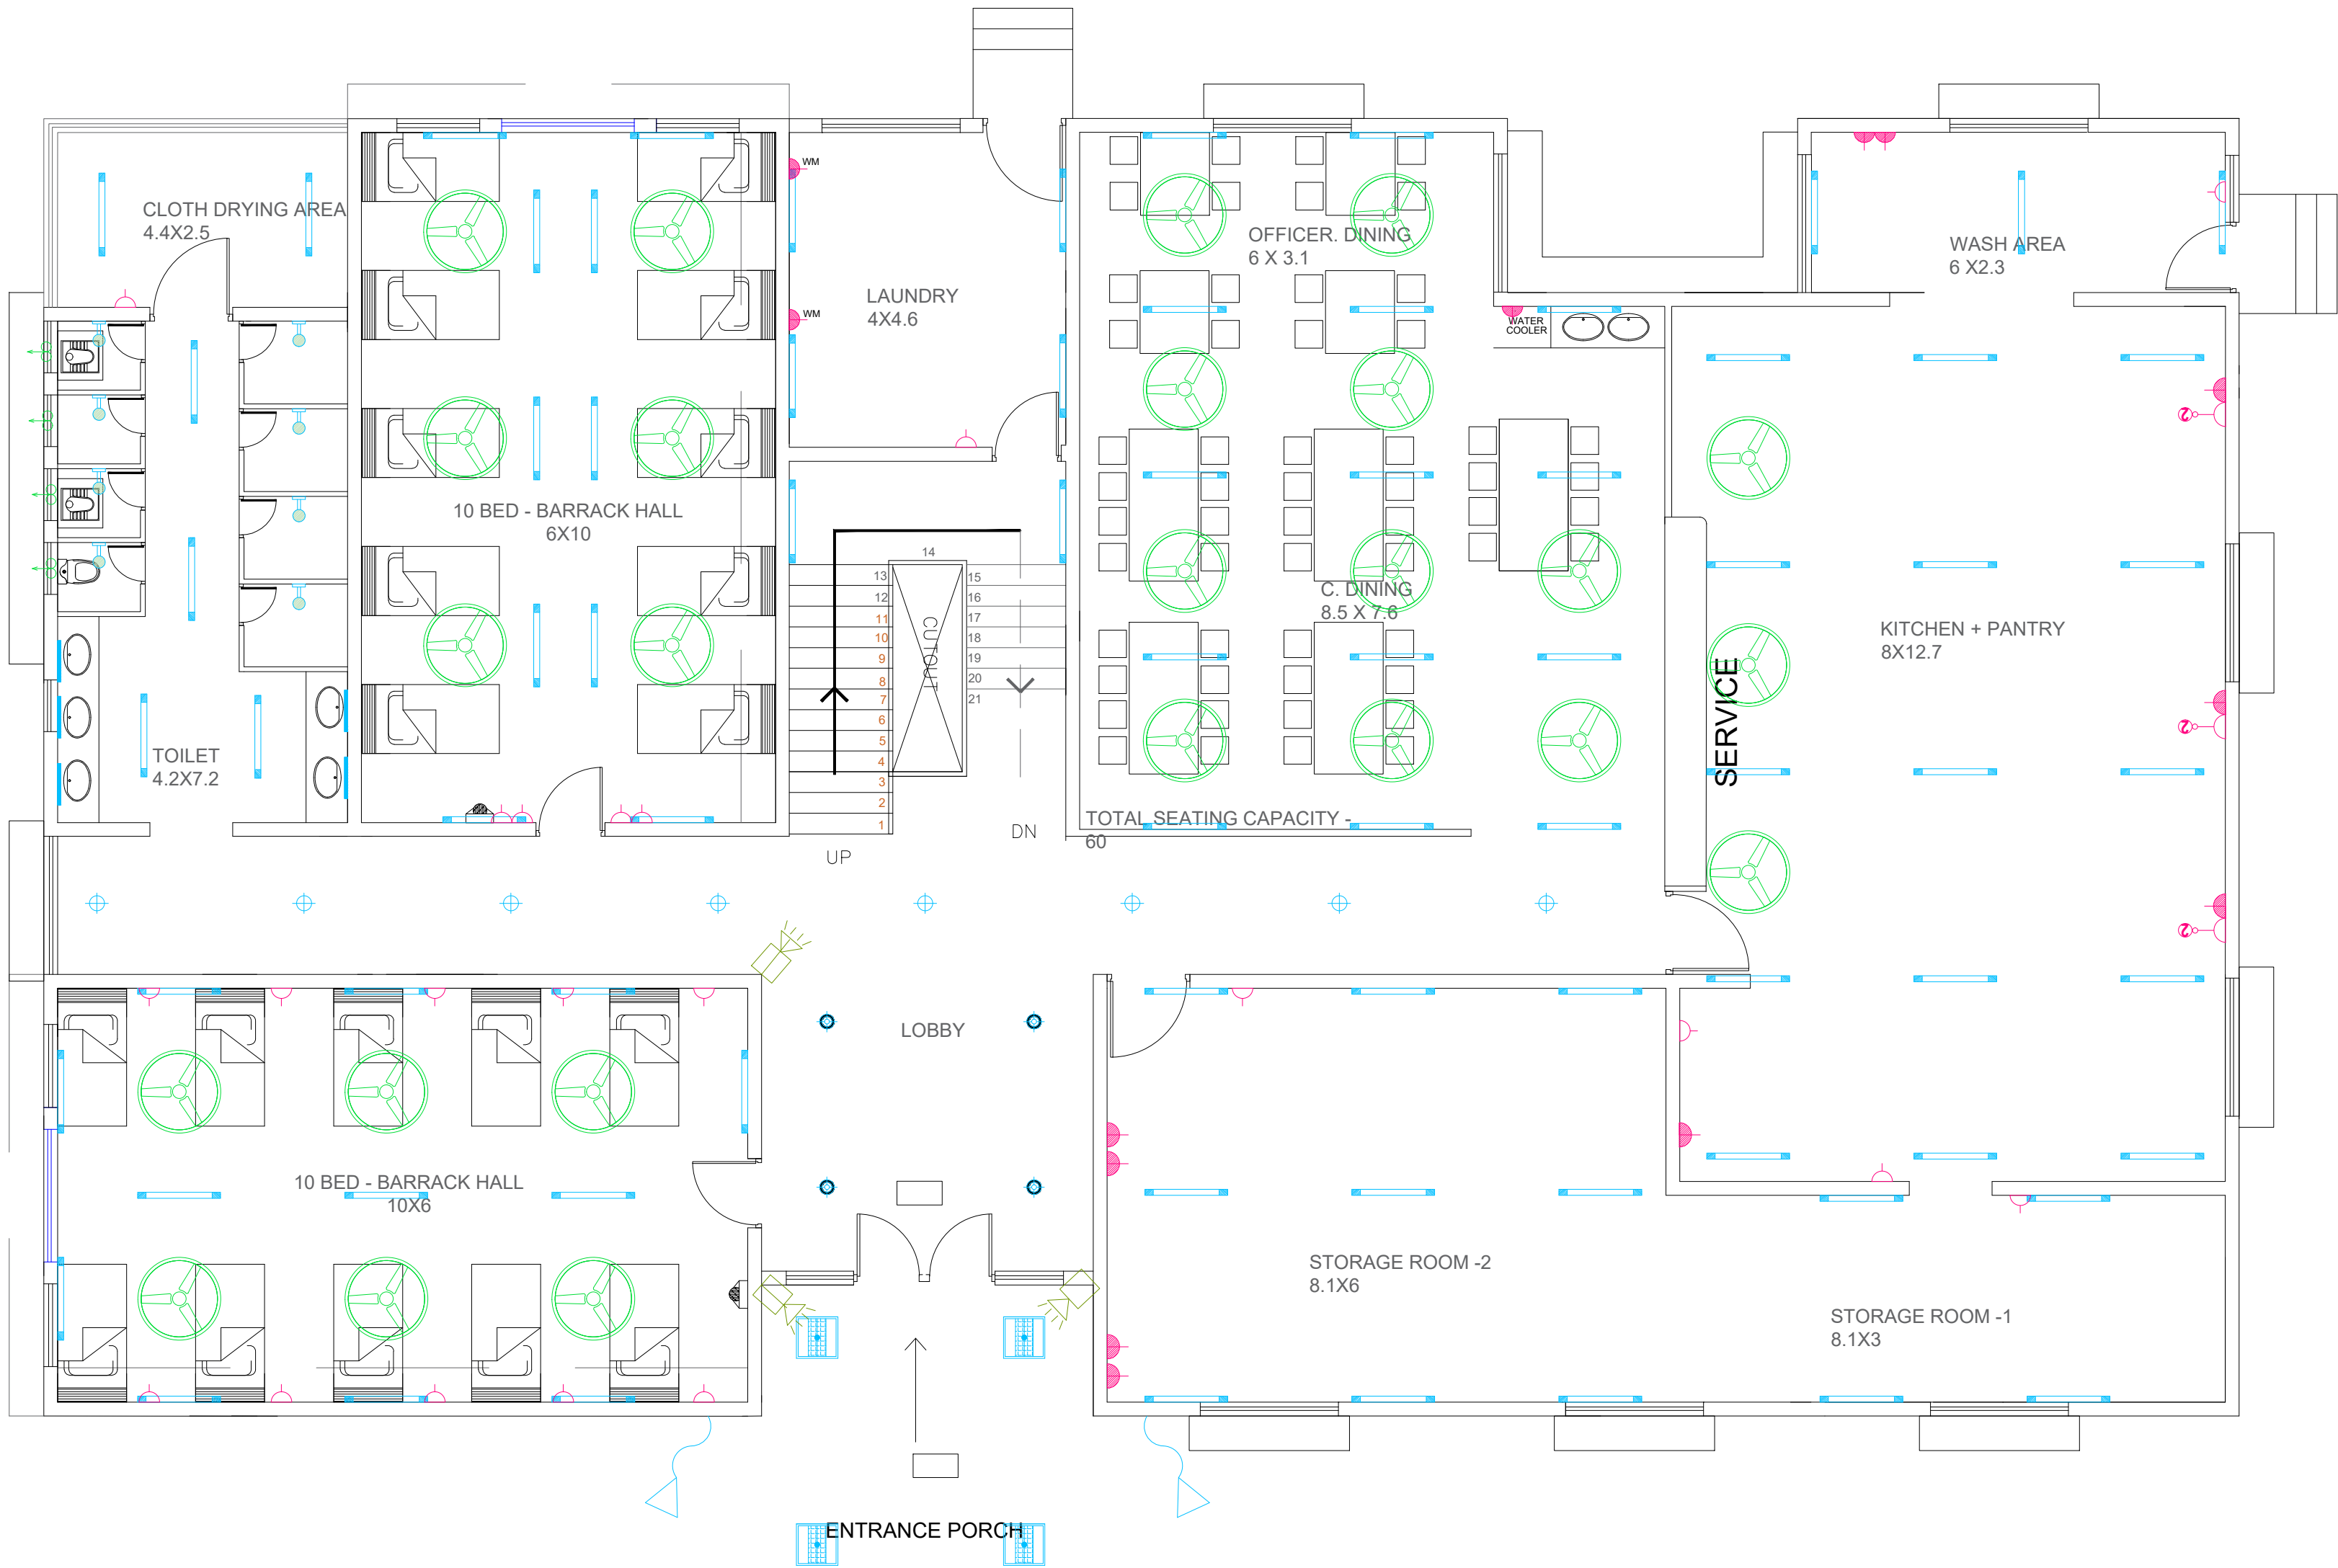

SYMBOL	DESCRIPTION	GF	TOTAL	GF	FF	TOTAL	GF	TOTAL
	40W STREET LIGHT							
	1X2' 10W MIRROR LIGHT FITTING							
	1X4' 20W LED LIGHT FITTING							
	7W RECESS/SURFACE MOUNTED LED SENSOR LIGHT FTG							
	12W RECESS/SURFACE MOUNTED LED TYPE DOWN LIGHT FTG							
	18W RECESS/SURFACE MOUNTED LED TYPE DOWN LIGHT FTG UPS							
	18W RECESS/SURFACE MOUNTED LED TYPE DOWN LIGHT FTG							
	2'-2'-36W LED RECESS MOUNTED FITTING							
	12W SURFACE MOUNTED RETROFIT TYPE LED LIGHT FTG							
	BULK HEAD FTG							
	WALL FAN							
	1200 MM CEILING FAN							

	300 MM LIGHT DUTY EXHAUST FAN								
	6A 3 PIN SOCKET WITH SWITCH								
	2NOS 6A 3 PIN SOCKET WITH SWITCH								
	2NOS 6A 3 PIN SOCKET WITH SWITCH (UPS)								
	3NOS 6A 3 PIN SOCKET WITH SWITCH (UPS)								
	6/16A 5 PIN SOCKET WITH SWITCH								
	TELEPHONE POINT								
	DATA POINT								
	CCTV POINT								

TENDER DRAWINGS

ELECTRICAL

ELECTRICAL FIXTURE LAYOUT

REV	DESCRIPTION	CHKD	DATE
	DRAWING NO : ARCH001/ELE-01		
	FILE NAME :		
	Drawn : JEEVAN		
	Checked : AMOL	REV.NO: R0	
	Approved : Ar.Anil.K.	SCALE : NTS	
	DATE : 08-11-2025	JOB.NO:	

TITLE : ELE DRAWING
GROUND FLOOR PLAN

PROJECT TITLE:
PROPOSED CONSTRUCTION OF
BNPM - BARRACK

ARCHITECTS :
KULKARNI ASSOCIATES
Consulting Architects, Engineers, Project Management
Consultants Interior Designers & Regd. valuers
Surya Prema Building, next to Adiga's
Restaurant, Kanakapura Road
No-203, 2nd floor, Above Canara bank
Raghuvanahalli Branch
Raghuvanahalli Village, Uttarahalli hobli
Bangalore-560062
Email Id : kulkarni.associates@yahoo.com




SYMBOL	DESCRIPTION	GF	TOTAL	GF	FF	TOTAL	GF	TOTAL
	40W STREET LIGHT							
	1X2' 10W MIRROR LIGHT FITTING							
	1X4' 20W LED LIGHT FITTING							
	7W RECESS/SURFACE MOUNTED LED SENSOR LIGHT FTG							
	12W RECESS/SURFACE MOUNTED LED TYPE DOWN LIGHT FTG							
	18W RECESS/SURFACE MOUNTED LED TYPE DOWN LIGHT FTG UPS							
	18W RECESS/SURFACE MOUNTED LED TYPE DOWN LIGHT FTG							
	2'-2'-36W LED RECESS MOUNTED FITTING							
	12W SURFACE MOUNTED RETROFIT TYPE LED LIGHT FTG							
	BULK HEAD FTG							
	WALL FAN							
	1200 MM CEILING FAN							

	300 MM LIGHT DUTY EXHAUST FAN																
	6A 3 PIN SOCKET WITH SWITCH																
	2NOS 6A 3 PIN SOCKET WITH SWITCH																
	2NOS 6A 3 PIN SOCKET WITH SWITCH (UPS)																
	3NOS 6A 3 PIN SOCKET WITH SWITCH (UPS)																
	6/16A 5 PIN SOCKET WITH SWITCH																
	TELEPHONE POINT																
	DATA POINT																
	CCTV POINT																

TENDER DRAWINGS

 ELECTRICAL
ELECTRICAL FIXTURE LAYOUT

REV	DESCRIPTION	CHKD	DATE	
DRAWING NO : ARCH001/ELE-02			REV.NO: R0	
FILE NAME :				
Drawn : JEEVAN				
Checked : AMOL		SCALE : NTS		
DATE : 08-11-2025		JOB.NO:		

TITLE : ELE DRAWING
FIRST FLOOR PLAN

PROJECT TITLE:
PROPOSED CONSTRUCTION OF
BNPM - BARRACK

ARCHITECTS :
KULKARNI ASSOCIATES
Consulting Architects, Engineers, Project Management
Consultants Interior Designers & Regd. valuers
Surya Prema Building, next to Adiga's
Restaurant, Kanakapura Road
No-203, 2nd floor, Above Canara bank
Raghuvanahalli Branch
Raghuvanahalli Village, Uttarahalli hobli
Bangalore-560062
Email Id : kulkarni.associates@yahoo.com




SYMBOL	DESCRIPTION	GF	TOTAL	GF	FF	TOTAL	GF	TOTAL
	40W STREET LIGHT							
	1X2' 10W MIRROR LIGHT FITTING							
	1X4' 20W LED LIGHT FITTING							
	7W RECESS/SURFACE MOUNTED LED SENSOR LIGHT FTG							
	12W RECESS/SURFACE MOUNTED LED TYPE DOWN LIGHT FTG							
	18W RECESS/SURFACE MOUNTED LED TYPE DOWN LIGHT FTG UPS							
	18W RECESS/SURFACE MOUNTED LED TYPE DOWN LIGHT FTG							
	2'-2'-36W LED RECESS MOUNTED FITTING							
	12W SURFACE MOUNTED RETROFIT TYPE LED LIGHT FTG							
	BULK HEAD FTG							
	WALL FAN							
	1200 MM CEILING FAN							

	300 MM LIGHT DUTY EXHAUST FAN								
	6A 3 PIN SOCKET WITH SWITCH								
	2NOS 6A 3 PIN SOCKET WITH SWITCH								
	2NOS 6A 3 PIN SOCKET WITH SWITCH (UPS)								
	3NOS 6A 3 PIN SOCKET WITH SWITCH(UPS)								
	6/16A 5 PIN SOCKET WITH SWITCH								
	TELEPHONE POINT								
	DATA POINT								
	CCTV POINT								

TENDER DRAWINGS

ELECTRICAL

 ELECTRICAL FIXTURE LAYOUT

REV	DESCRIPTION	CHKD	DATE
DRAWING NO : ARCH001/ELE-02			
FILE NAME :			
Drawn : JEEVAN			
Checked : AMOL		REV.NO: R0	
Approved : Ar.Anil.K.		SCALE : NTS	
DATE : 08-11-2025		JOB.NO:	

TITLE : ELE DRAWING

SECOND FLOOR PLAN


PROJECT TITLE:

PROPOSED CONSTRUCTION OF
BNPM - BARRACK

ARCHITECTS :

KULKARNI ASSOCIATES

Consulting Architects, Engineers, Project Management
Consultants Interior Designers & Regd. valuers
Surya Prema Building, next to Adiga's
Restaurant, Kanakapura Road
No-203, 2nd floor, Above Canara bank
Raghuvanahalli Branch
Raghuvanahalli Village, Uttarahalli hobli
Bangalore-560062
Email Id : kulkarni.associates@yahoo.com

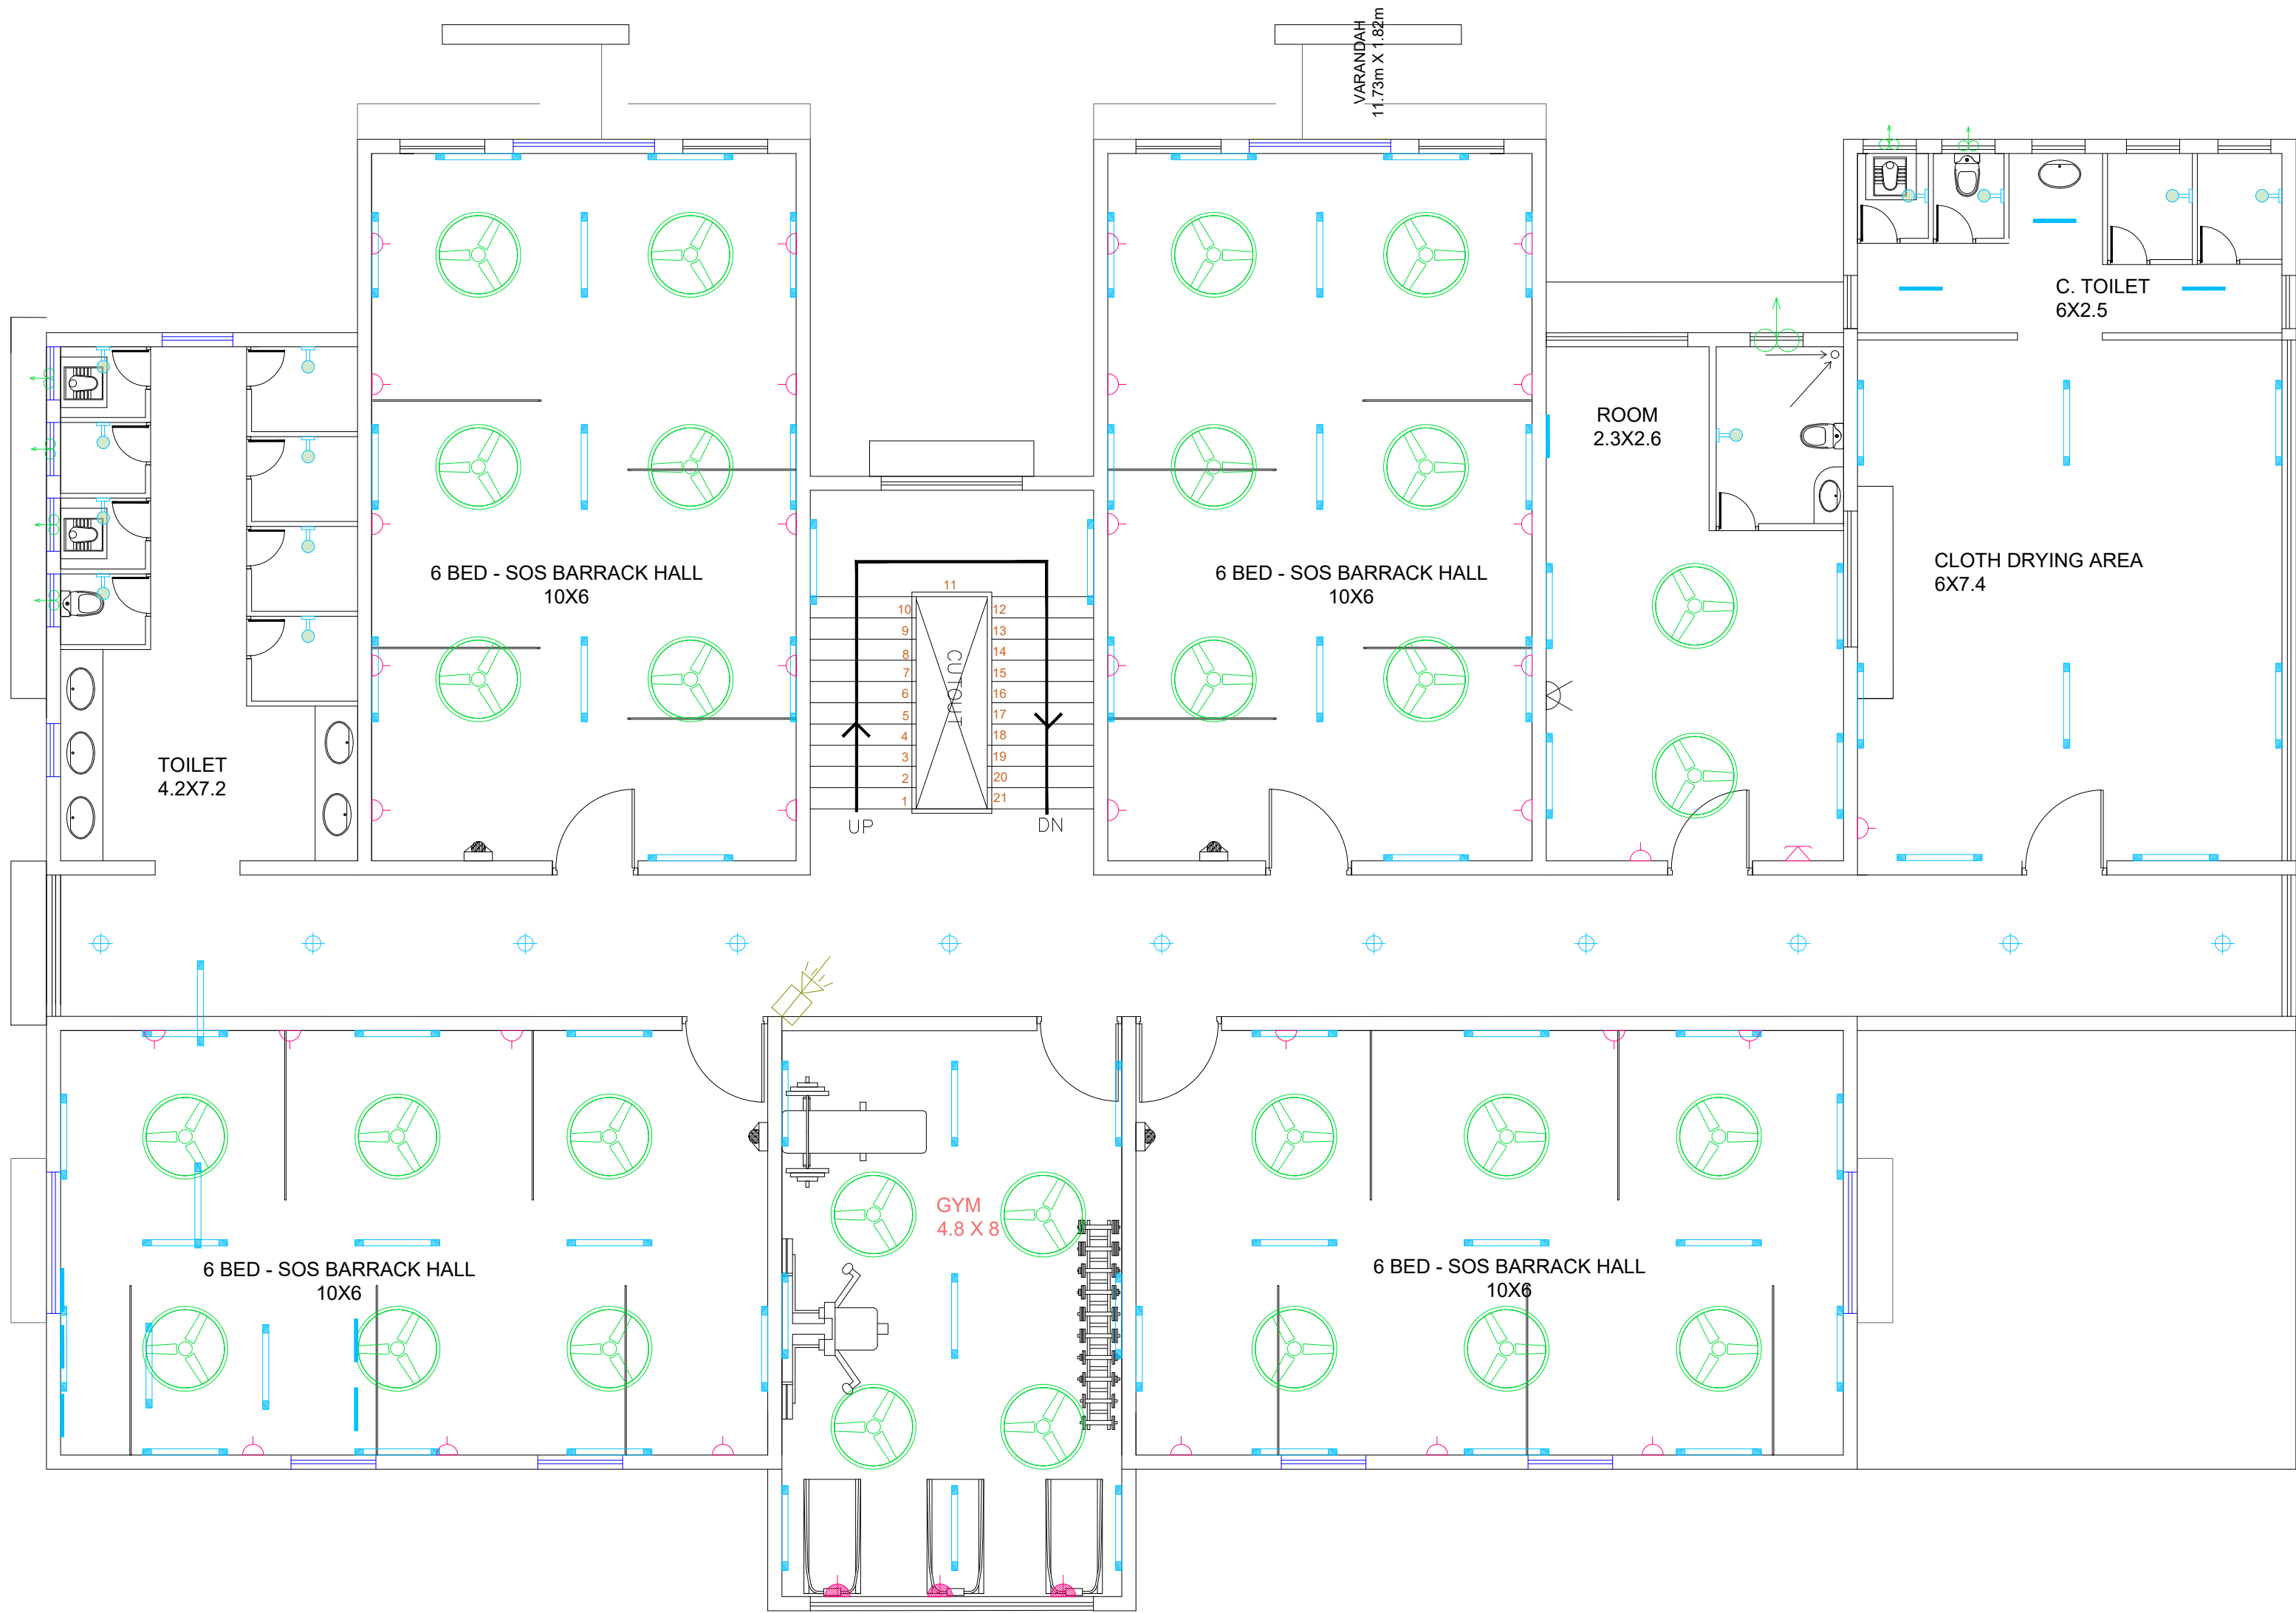

SYMBOL	DESCRIPTION	GF	TOTAL	GF	FF	TOTAL	GF	TOTAL
	40W STREET LIGHT							
	1X2' 10W MIRROR LIGHT FITTING							
	1X4' 20W LED LIGHT FITTING							
	7W RECESS/SURFACE MOUNTED LED SENSOR LIGHT FTG							
	12W RECESS/SURFACE MOUNTED LED TYPE DOWN LIGHT FTG							
	18W RECESS/SURFACE MOUNTED LED TYPE DOWN LIGHT FTG UPS							
	18W RECESS/SURFACE MOUNTED LED TYPE DOWN LIGHT FTG							
	2'-2'-36W LED RECESS MOUNTED FITTING							
	12W SURFACE MOUNTED RETROFIT TYPE LED LIGHT FTG							
	BULK HEAD FTG							
	WALL FAN							
	1200 MM CEILING FAN							

	300 MM LIGHT DUTY EXHAUST FAN								
	6A 3 PIN SOCKET WITH SWITCH								
	2NOS 6A 3 PIN SOCKET WITH SWITCH								
	2NOS 6A 3 PIN SOCKET WITH SWITCH (UPS)								
	3NOS 6A 3 PIN SOCKET WITH SWITCH(UPS)								
	6/16A 5 PIN SOCKET WITH SWITCH								
	TELEPHONE POINT								
	DATA POINT								
	CCTV POINT								

TENDER DRAWINGS

ELECTRICAL

ELECTRICAL FIXTURE LAYOUT

REV	DESCRIPTION	CHKD	DATE
DRAWING NO : ARCH001/ELE-04			
FILE NAME :			
Drawn : JEEVAN			
Checked : AMOL		REV.NO: R0	
Approved : Ar.Anil.K.		SCALE : NTS	
DATE : 08-11-2025		JOB.NO:	


TITLE : ELE DRAWING

THIRD FLOOR PLAN

PROJECT TITLE:

PROPOSED CONSTRUCTION OF
BNPM - BARRACK

ARCHITECTS :
KULKARNI ASSOCIATES
Consulting Architects, Engineers, Project Management
Consultants Interior Designers & Regd. valuers
Surya Prema Building,next to Adiga's
Restaurant,Kanakapura Road
No-203,2nd floor,Above Canara bank
Raghuvanhalli Branch
Raghuvanhalli Village,Uttarahalli hobli
Bangalore-560062
Email Id : kulkarni.associates@yahoo.com

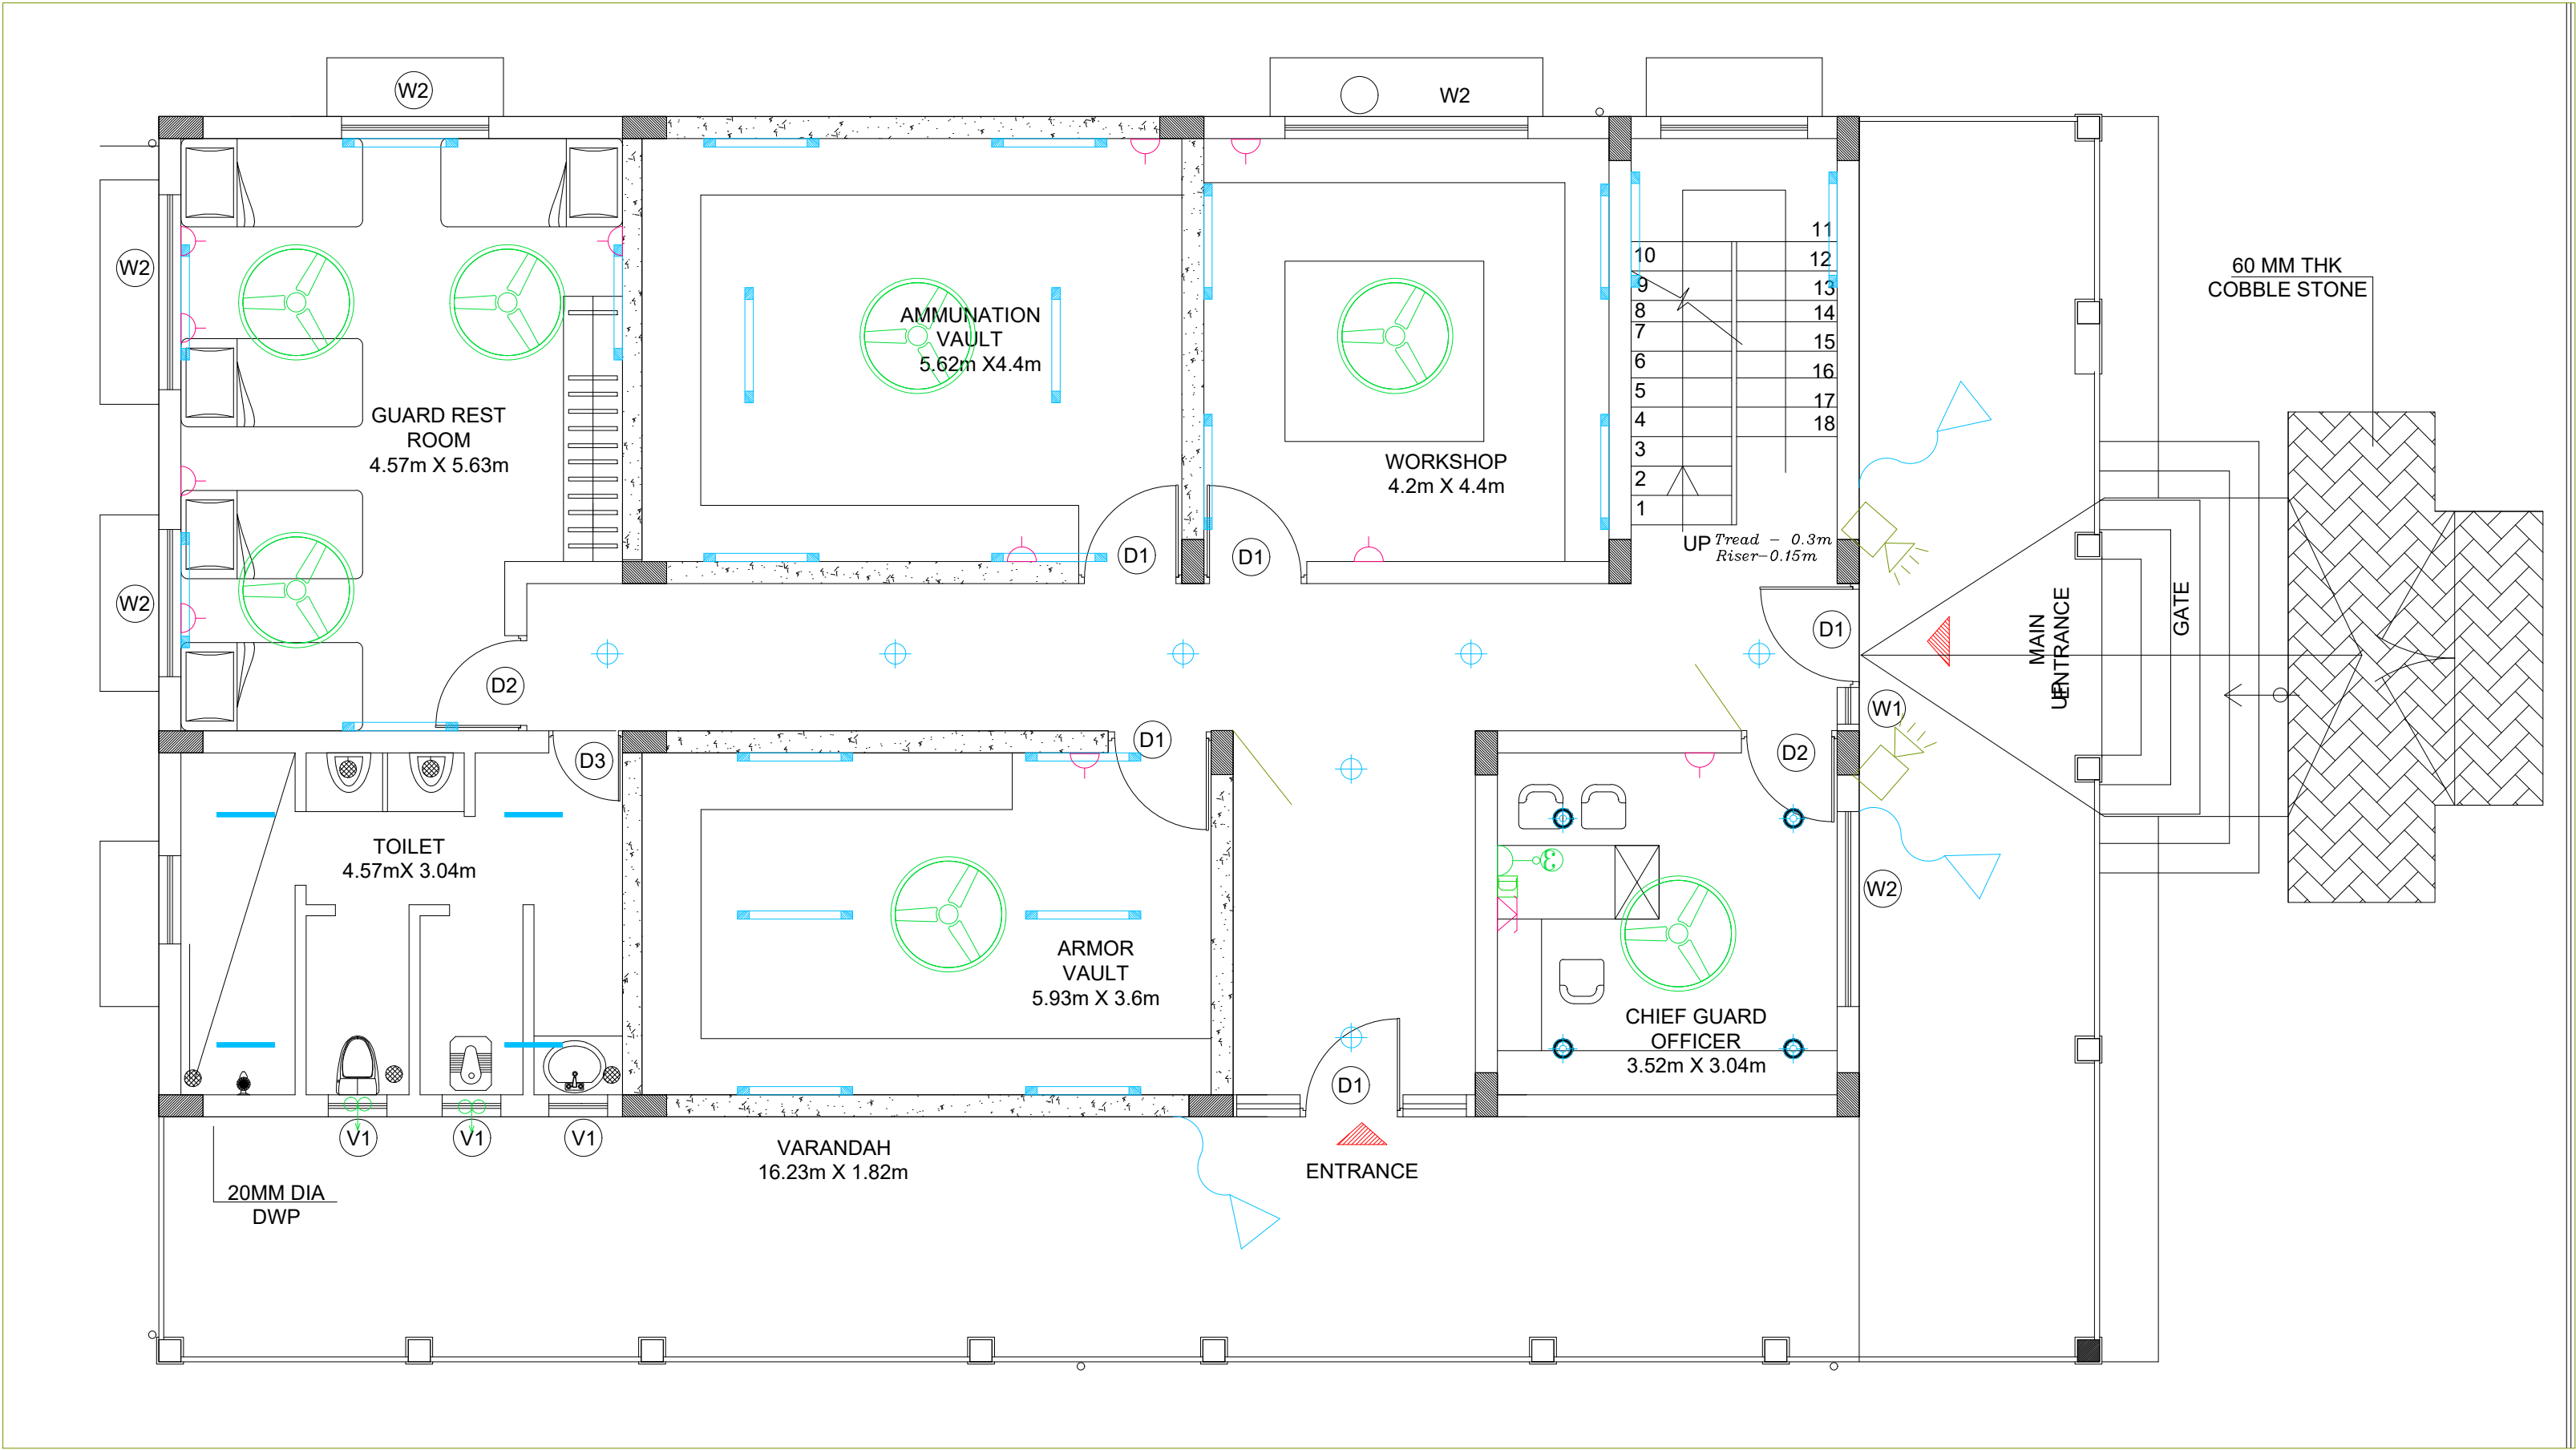

SYMBOL	DESCRIPTION	GF	TOTAL	GF	FF	TOTAL	GF	TOTAL
	40W STREET LIGHT							
	1X2' 10W MIRROR LIGHT FITTING							
	1X4' 20W LED LIGHT FITTING							
	7W RECESS/SURFACE MOUNTED LED SENSOR LIGHT FTG							
	12W RECESS/SURFACE MOUNTED LED TYPE DOWN LIGHT FTG							
	18W RECESS/SURFACE MOUNTED LED TYPE DOWN LIGHT FTG UPS							
	18W RECESS/SURFACE MOUNTED LED TYPE DOWN LIGHT FTG							
	2'-2'-36W LED RECESS MOUNTED FITTING							
	12W SURFACE MOUNTED RETROFIT TYPE LED LIGHT FTG							
	BULK HEAD FTG							
	WALL FAN							
	1200 MM CEILING FAN							


	300 MM LIGHT DUTY EXHAUST FAN								
	6A 3 PIN SOCKET WITH SWITCH								
	2NOS 6A 3 PIN SOCKET WITH SWITCH								
	2NOS 6A 3 PIN SOCKET WITH SWITCH (UPS)								
	3NOS 6A 3 PIN SOCKET WITH SWITCH(UPS)								
	6/16A 5 PIN SOCKET WITH SWITCH								
	TELEPHONE POINT								
	DATA POINT								
	CCTV POINT								

TENDER DRAWINGS

ELECTRICAL

ELECTRICAL FIXTURE LAYOUT

REV	DESCRIPTION	CHKD	DATE
	DRAWING NO : ARCH001/ELE-01		
	FILE NAME :		
	Drawn : JEEVAN		
	Checked : AMOL	REV.NO: R0	
	Approved : Ar.Anil.K.	SCALE : NTS	
	DATE : 08-11-2025	JOB.NO:	

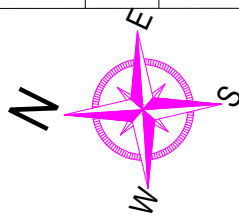

TITLE : ELE DRAWING

GROUND FLOOR PLAN


PROJECT TITLE:

PROPOSED CONSTRUCTION OF
BNPM - ARMOUR HOUSE


ARCHITECTS :

KULKARNI ASSOCIATES

Consulting Architects, Engineers, Project Management
Consultants Interior Designers & Regd. valuers
Surya Prema Building, next to Adiga's
Restaurant, Kanakapura Road
No-203, 2nd floor, Above Canara bank
Raghuvanahalli Branch
Raghuvanahalli Village, Uttarahalli hobli
Bangalore-560062
Email Id : kulkarni.associates@yahoo.com

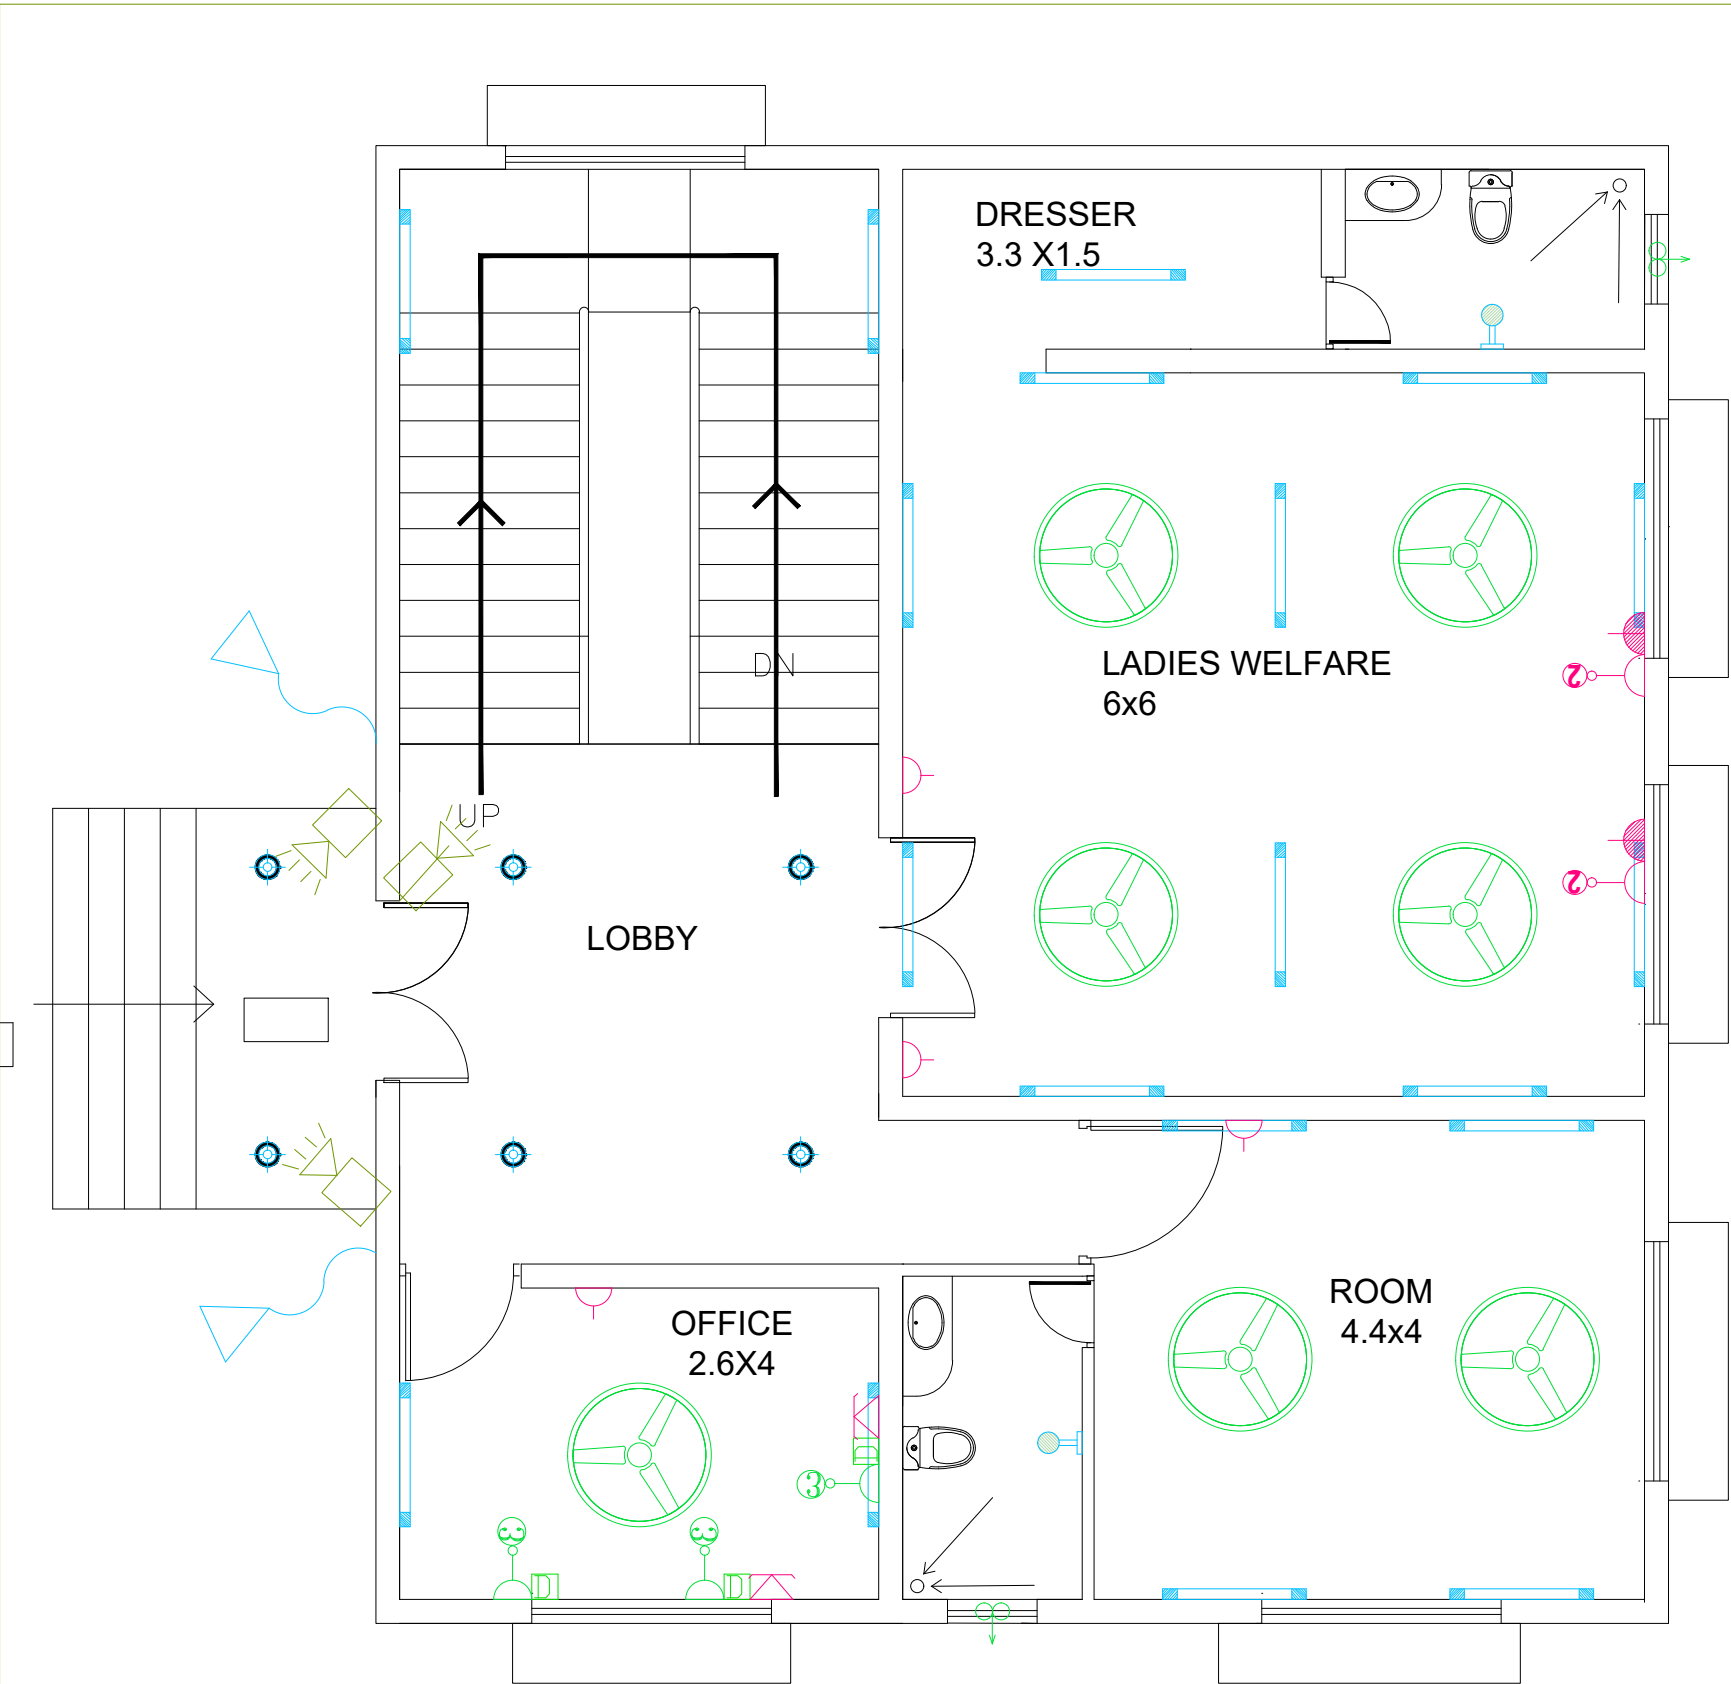

GROUND FLOOR PLAN

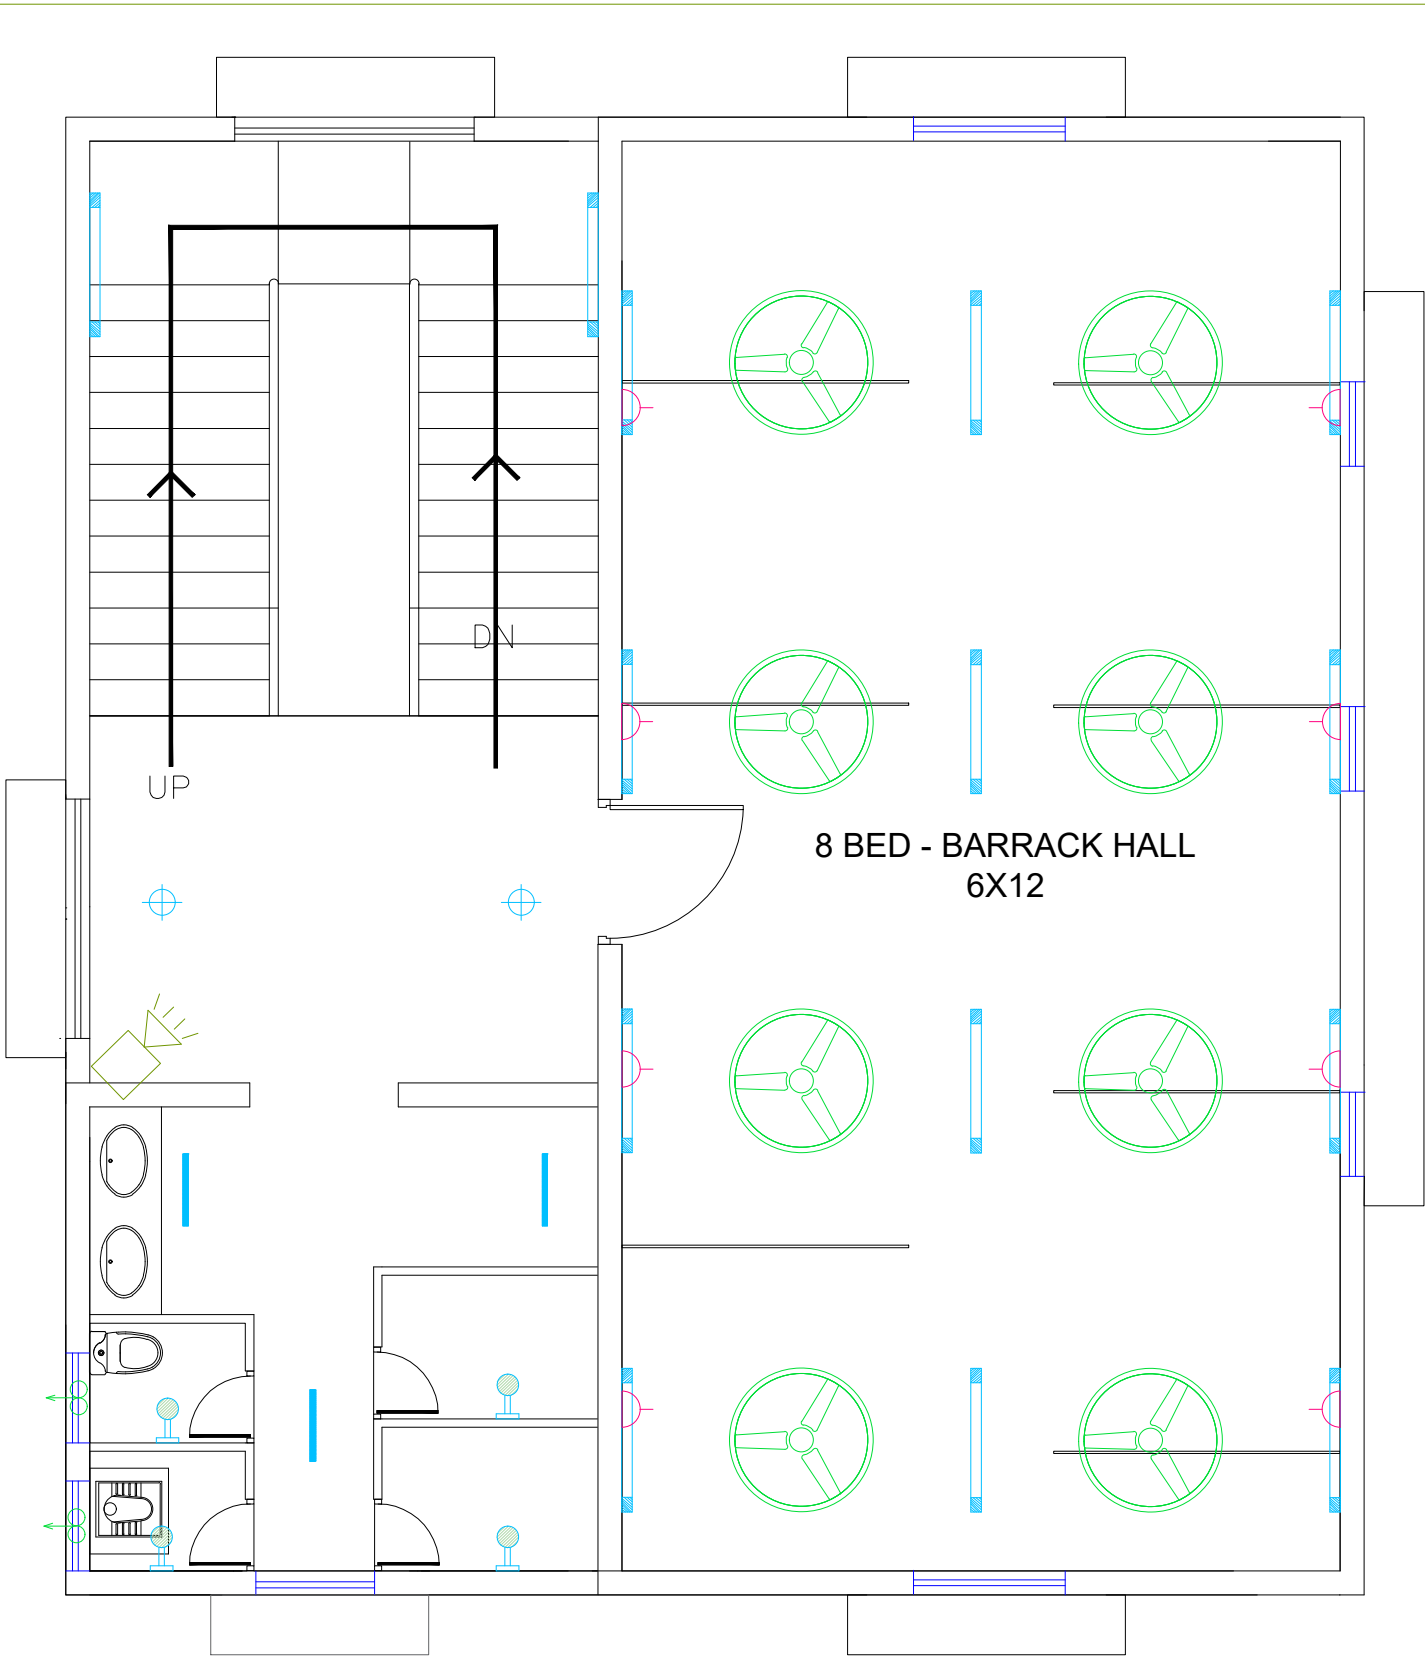

FIRST FLOOR PLAN

SYMBOL	DESCRIPTION	GF	TOTAL	GF	FF	TOTAL	GF	TOTAL
	40W STREET LIGHT							
	1X2' 10W MIRROR LIGHT FITTING							
	1X4' 20W LED LIGHT FITTING							
	7W RECESS/SURFACE MOUNTED LED SENSOR LIGHT FTG							
	12W RECESS/SURFACE MOUNTED LED TYPE DOWN LIGHT FTG							
	18W RECESS/SURFACE MOUNTED LED TYPE DOWN LIGHT FTG UPS							
	18W RECESS/SURFACE MOUNTED LED TYPE DOWN LIGHT FTG							
	2'-2'-36W LED RECESS MOUNTED FITTING							
	12W SURFACE MOUNTED RETROFIT TYPE LED LIGHT FTG							
	BULK HEAD FTG							
	WALL FAN							
	1200 MM CEILING FAN							

	300 MM LIGHT DUTY EXHAUST FAN								
	6A 3 PIN SOCKET WITH SWITCH								
	2NOS 6A 3 PIN SOCKET WITH SWITCH								
	2NOS 6A 3 PIN SOCKET WITH SWITCH (UPS)								
	3NOS 6A 3 PIN SOCKET WITH SWITCH(UPS)								
	6/16A 5 PIN SOCKET WITH SWITCH								
	TELEPHONE POINT								
	DATA POINT								
	CCTV POINT								

TENDER DRAWINGS

ELECTRICAL

ELECTRICAL FIXTURE LAYOUT

REV	DESCRIPTION	CHKD	DATE
DRAWING NO : ARCH001/ELE-01			
FILE NAME :			
Drawn : JEEVAN			
Checked : AMOL		REV.NO: R0	
Approved : Ar.Anil.K.		SCALE : NTS	
DATE : 08-11-2025		JOB.NO:	


TITLE : ELE DRAWING

GROUND & FIRST FLOOR PLAN

PROJECT TITLE:

PROPOSED CONSTRUCTION OF
BNPM - LADIES BARRACK

ARCHITECTS :
KULKARNI ASSOCIATES
Consulting Architects , Engineers,Project Management
Consultants Interior Designers & Regd. valuers
Surya Prema Building,next to Adiga's
Restaurant,Kanakapura Road
No-203,2nd floor,Above Canara bank
Raghuvanahalli Branch
Raghuvanahalli Village,Uttarahalli hobli
Bangalore-560062
Email Id : kulkarni.associates@yahoo.com

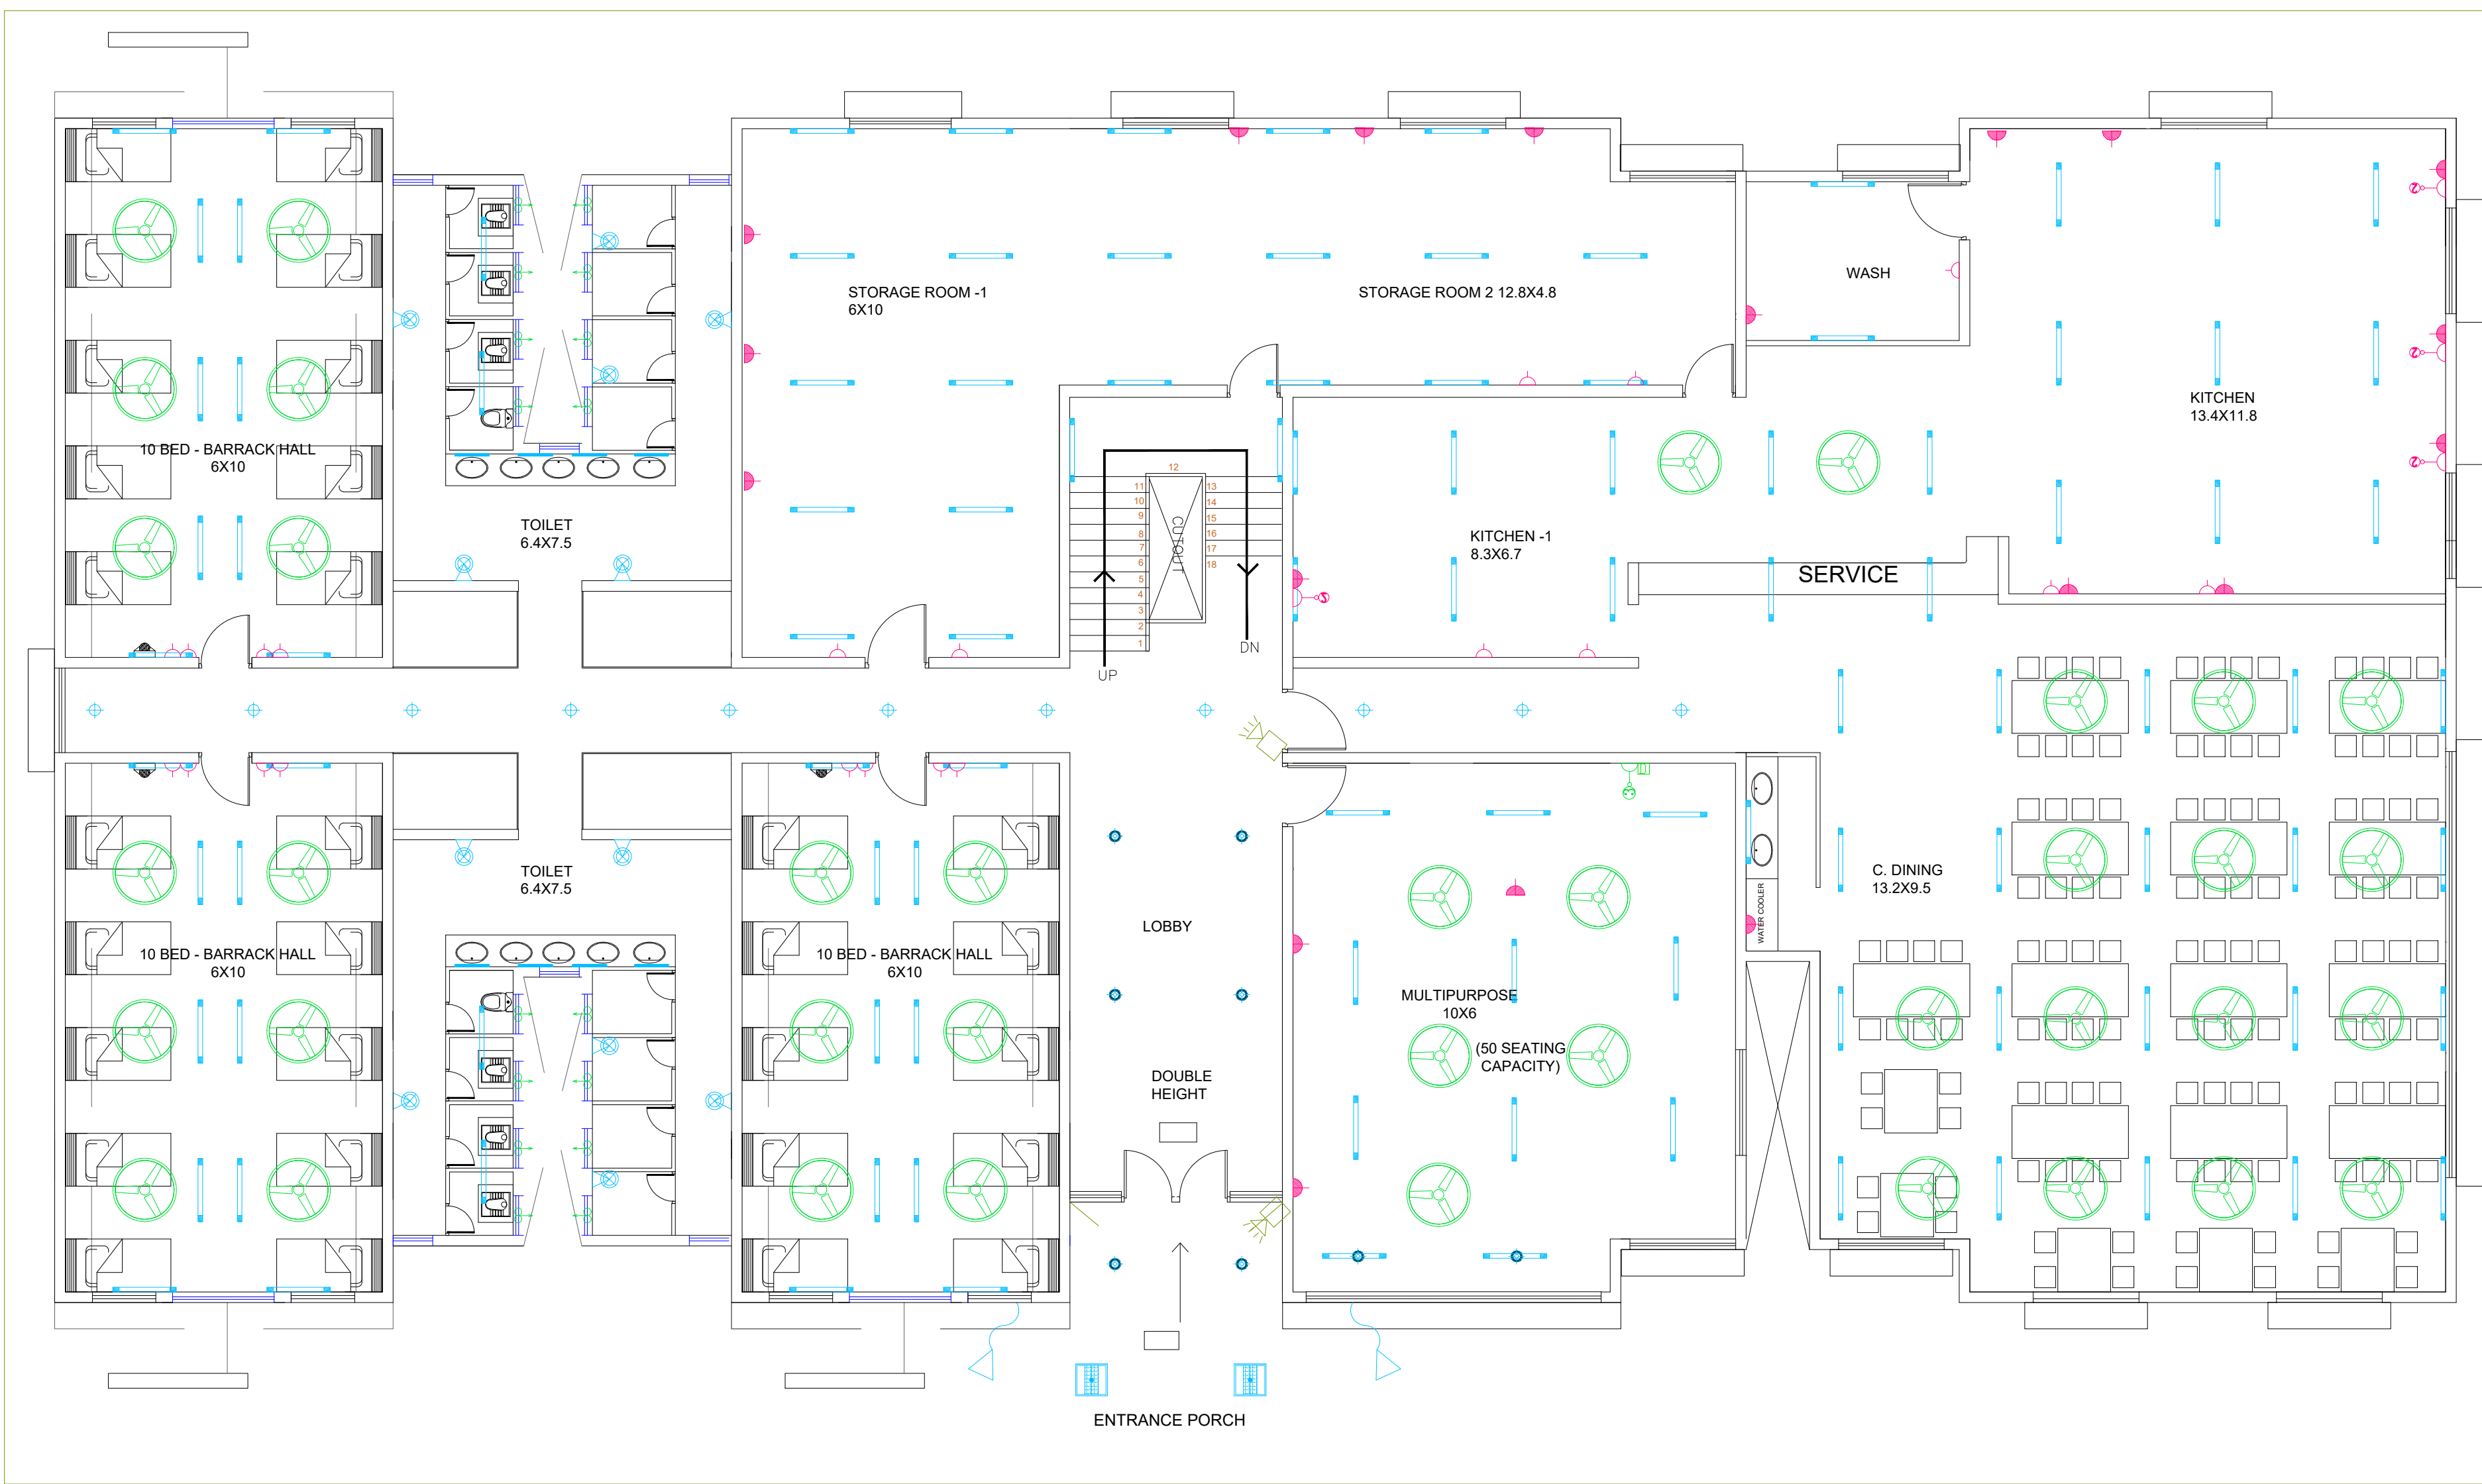

TENDER DRAWINGS

ELECTRICAL

ELECTRICAL FIXTURE LAYOUT

REV	DESCRIPTION	CHKD	DATE
DRAWING NO : ARCH001/ELE-01			
FILE NAME :			
Drawn : JEEVAN			
Checked : AMOL			
Approved : Ar.Anil.K.		REV.NO: R0	SCALE : NTS
DATE : 08-11-2025		JOB.NO:	
TITLE : ELE DRAWING			
GROUND FLOOR PLAN			
PROJECT TITLE:			
PROPOSED CONSTRUCTION OF BRBNMPL - BARRACK			
ARCHITECTS : KULKARNI ASSOCIATES Consulting Architects, Engineers, Project Management Consultants Interior Designers & Regd. valuers Surya Prema Building, next to Adiga's Restaurant, Kanakapura Road No-203, 2nd floor, Above Canara bank Raghuvanahalli Branch Raghuvanahalli Village, Uttarahalli hobli Bangalore-560062 Email Id : kulkarni.associates@yahoo.com			

SYMBOL	DESCRIPTION	GF	TOTAL	GF	FF	TOTAL	GF	TOTAL
	40W STREET LIGHT							
	1X2' 10W MIRROR LIGHT FITTING							
	1X4' 20W LED LIGHT FITTING							
	7W RECESS/SURFACE MOUNTED LED SENSOR LIGHT FTG							
	12W RECESS/SURFACE MOUNTED LED TYPE DOWN LIGHT FTG							
	18W RECESS/SURFACE MOUNTED LED TYPE DOWN LIGHT FTG UPS							
	18W RECESS/SURFACE MOUNTED LED TYPE DOWN LIGHT FTG							
	2'-2'-36W LED RECESS MOUNTED FITTING							
	12W SURFACE MOUNTED RETROFIT TYPE LED LIGHT FTG							
	BULK HEAD FTG							
	WALL FAN							
	1200 MM CEILING FAN							

	300 MM LIGHT DUTY EXHAUST FAN																		
	6A 3 PIN SOCKET WITH SWITCH																		
	2NOS 6A 3 PIN SOCKET WITH SWITCH																		
	2NOS 6A 3 PIN SOCKET WITH SWITCH (UPS)																		
	3NOS 6A 3 PIN SOCKET WITH SWITCH (UPS)																		
	6/16A 5 PIN SOCKET WITH SWITCH																		
	TELEPHONE POINT																		
	DATA POINT																		
	CCTV POINT																		



SYMBOL	DESCRIPTION	GF	TOTAL	GF	FF	TOTAL	GF	TOTAL
	40W STREET LIGHT							
	1X2' 10W MIRROR LIGHT FITTING							
	1X4' 20W LED LIGHT FITTING							
	7W RECESS/SURFACE MOUNTED LED SENSOR LIGHT FTG							
	12W RECESS/SURFACE MOUNTED LED TYPE DOWN LIGHT FTG							
	18W RECESS/SURFACE MOUNTED LED TYPE DOWN LIGHT FTG UPS							
	18W RECESS/SURFACE MOUNTED LED TYPE DOWN LIGHT FTG							
	2'-2'-36W LED RECESS MOUNTED FITTING							
	12W SURFACE MOUNTED RETROFIT TYPE LED LIGHT FTG							
	BULK HEAD FTG							
	WALL FAN							
	1200 MM CEILING FAN							

	300 MM LIGHT DUTY EXHAUST FAN								
	6A 3 PIN SOCKET WITH SWITCH								
	2NOS 6A 3 PIN SOCKET WITH SWITCH								
	2NOS 6A 3 PIN SOCKET WITH SWITCH (UPS)								
	3NOS 6A 3 PIN SOCKET WITH SWITCH(UPS)								
	6/16A 5 PIN SOCKET WITH SWITCH								
	TELEPHONE POINT								
	DATA POINT								
	CCTV POINT								

TENDER DRAWINGS

ELECTRICAL

ELECTRICAL FIXTURE LAYOUT

REV	DESCRIPTION	CHKD	DATE
DRAWING NO : ARCH001/ELE-02			
FILE NAME :			
Drawn : JEEVAN			
Checked : AMOL			REV.NO: R0
Approved : Ar.Anil.K.		SCALE : NTS	
DATE : 08-11-2025		JOB.NO:	
TITLE : ELE DRAWING			
FIRST FLOOR PLAN			
PROJECT TITLE:			
PROPOSED CONSTRUCTION OF BRBNMPL - BARRACK			
ARCHITECTS : KULKARNI ASSOCIATES Consulting Architects, Engineers, Project Management Consultants Interior Designers & Regd. valuers Surya Prema Building,next to Adiga's Restaurant,Kanakapura Road No-203,2nd floor,Above Canara bank Raghuvanahalli Branch Raghuvanahalli Village,Uttarahalli hobli Bangalore-560062 Email Id : kulkarni.associates@yahoo.com			



TENDER DRAWINGS


ELECTRICAL

ELECTRICAL FIXTURE LAYOUT

REV	DESCRIPTION	CHKD	DATE
DRAWING NO : ARCH001/ELE-02			
FILE NAME :			
Drawn : JEEVAN			
Checked : AMOL		REV.NO: R0	
Approved : Ar.Anil.K.		SCALE : NTS	
DATE : 08-11-2025		JOB.NO:	
TITLE : ELE DRAWING			
SECOND FLOOR PLAN			
PROJECT TITLE:			
PROPOSED CONSTRUCTION OF BRBNMPL - BARRACK			
ARCHITECTS : KULKARNI ASSOCIATES Consulting Architects, Engineers, Project Management Consultants Interior Designers & Regd. valuers Surya Prema Building, next to Adiga's Restaurant, Kanakapura Road No-203, 2nd floor, Above Canara bank Raghuvanahalli Branch Raghuvanahalli Village, Uttarahalli hobli Bangalore-560062 Email Id : kulkarni.associates@yahoo.com			

SYMBOL	DESCRIPTION	GF	TOTAL	GF	FF	TOTAL	GF	TOTAL
	40W STREET LIGHT							
	1X2' 10W MIRROR LIGHT FITTING							
	1X4' 20W LED LIGHT FITTING							
	7W RECESS/SURFACE MOUNTED LED SENSOR LIGHT FTG							
	12W RECESS/SURFACE MOUNTED LED TYPE DOWN LIGHT FTG							
	18W RECESS/SURFACE MOUNTED LED TYPE DOWN LIGHT FTG UPS							
	18W RECESS/SURFACE MOUNTED LED TYPE DOWN LIGHT FTG							
	2'-2'-36W LED RECESS MOUNTED FITTING							
	12W SURFACE MOUNTED RETROFIT TYPE LED LIGHT FTG							
	BULK HEAD FTG							
	WALL FAN							
	1200 MM CEILING FAN							

	300 MM LIGHT DUTY EXHAUST FAN								
	6A 3 PIN SOCKET WITH SWITCH								
	2NOS 6A 3 PIN SOCKET WITH SWITCH								
	2NOS 6A 3 PIN SOCKET WITH SWITCH (UPS)								
	3NOS 6A 3 PIN SOCKET WITH SWITCH (UPS)								
	6/16A 5 PIN SOCKET WITH SWITCH								
	TELEPHONE POINT								
	DATA POINT								
	CCTV POINT								

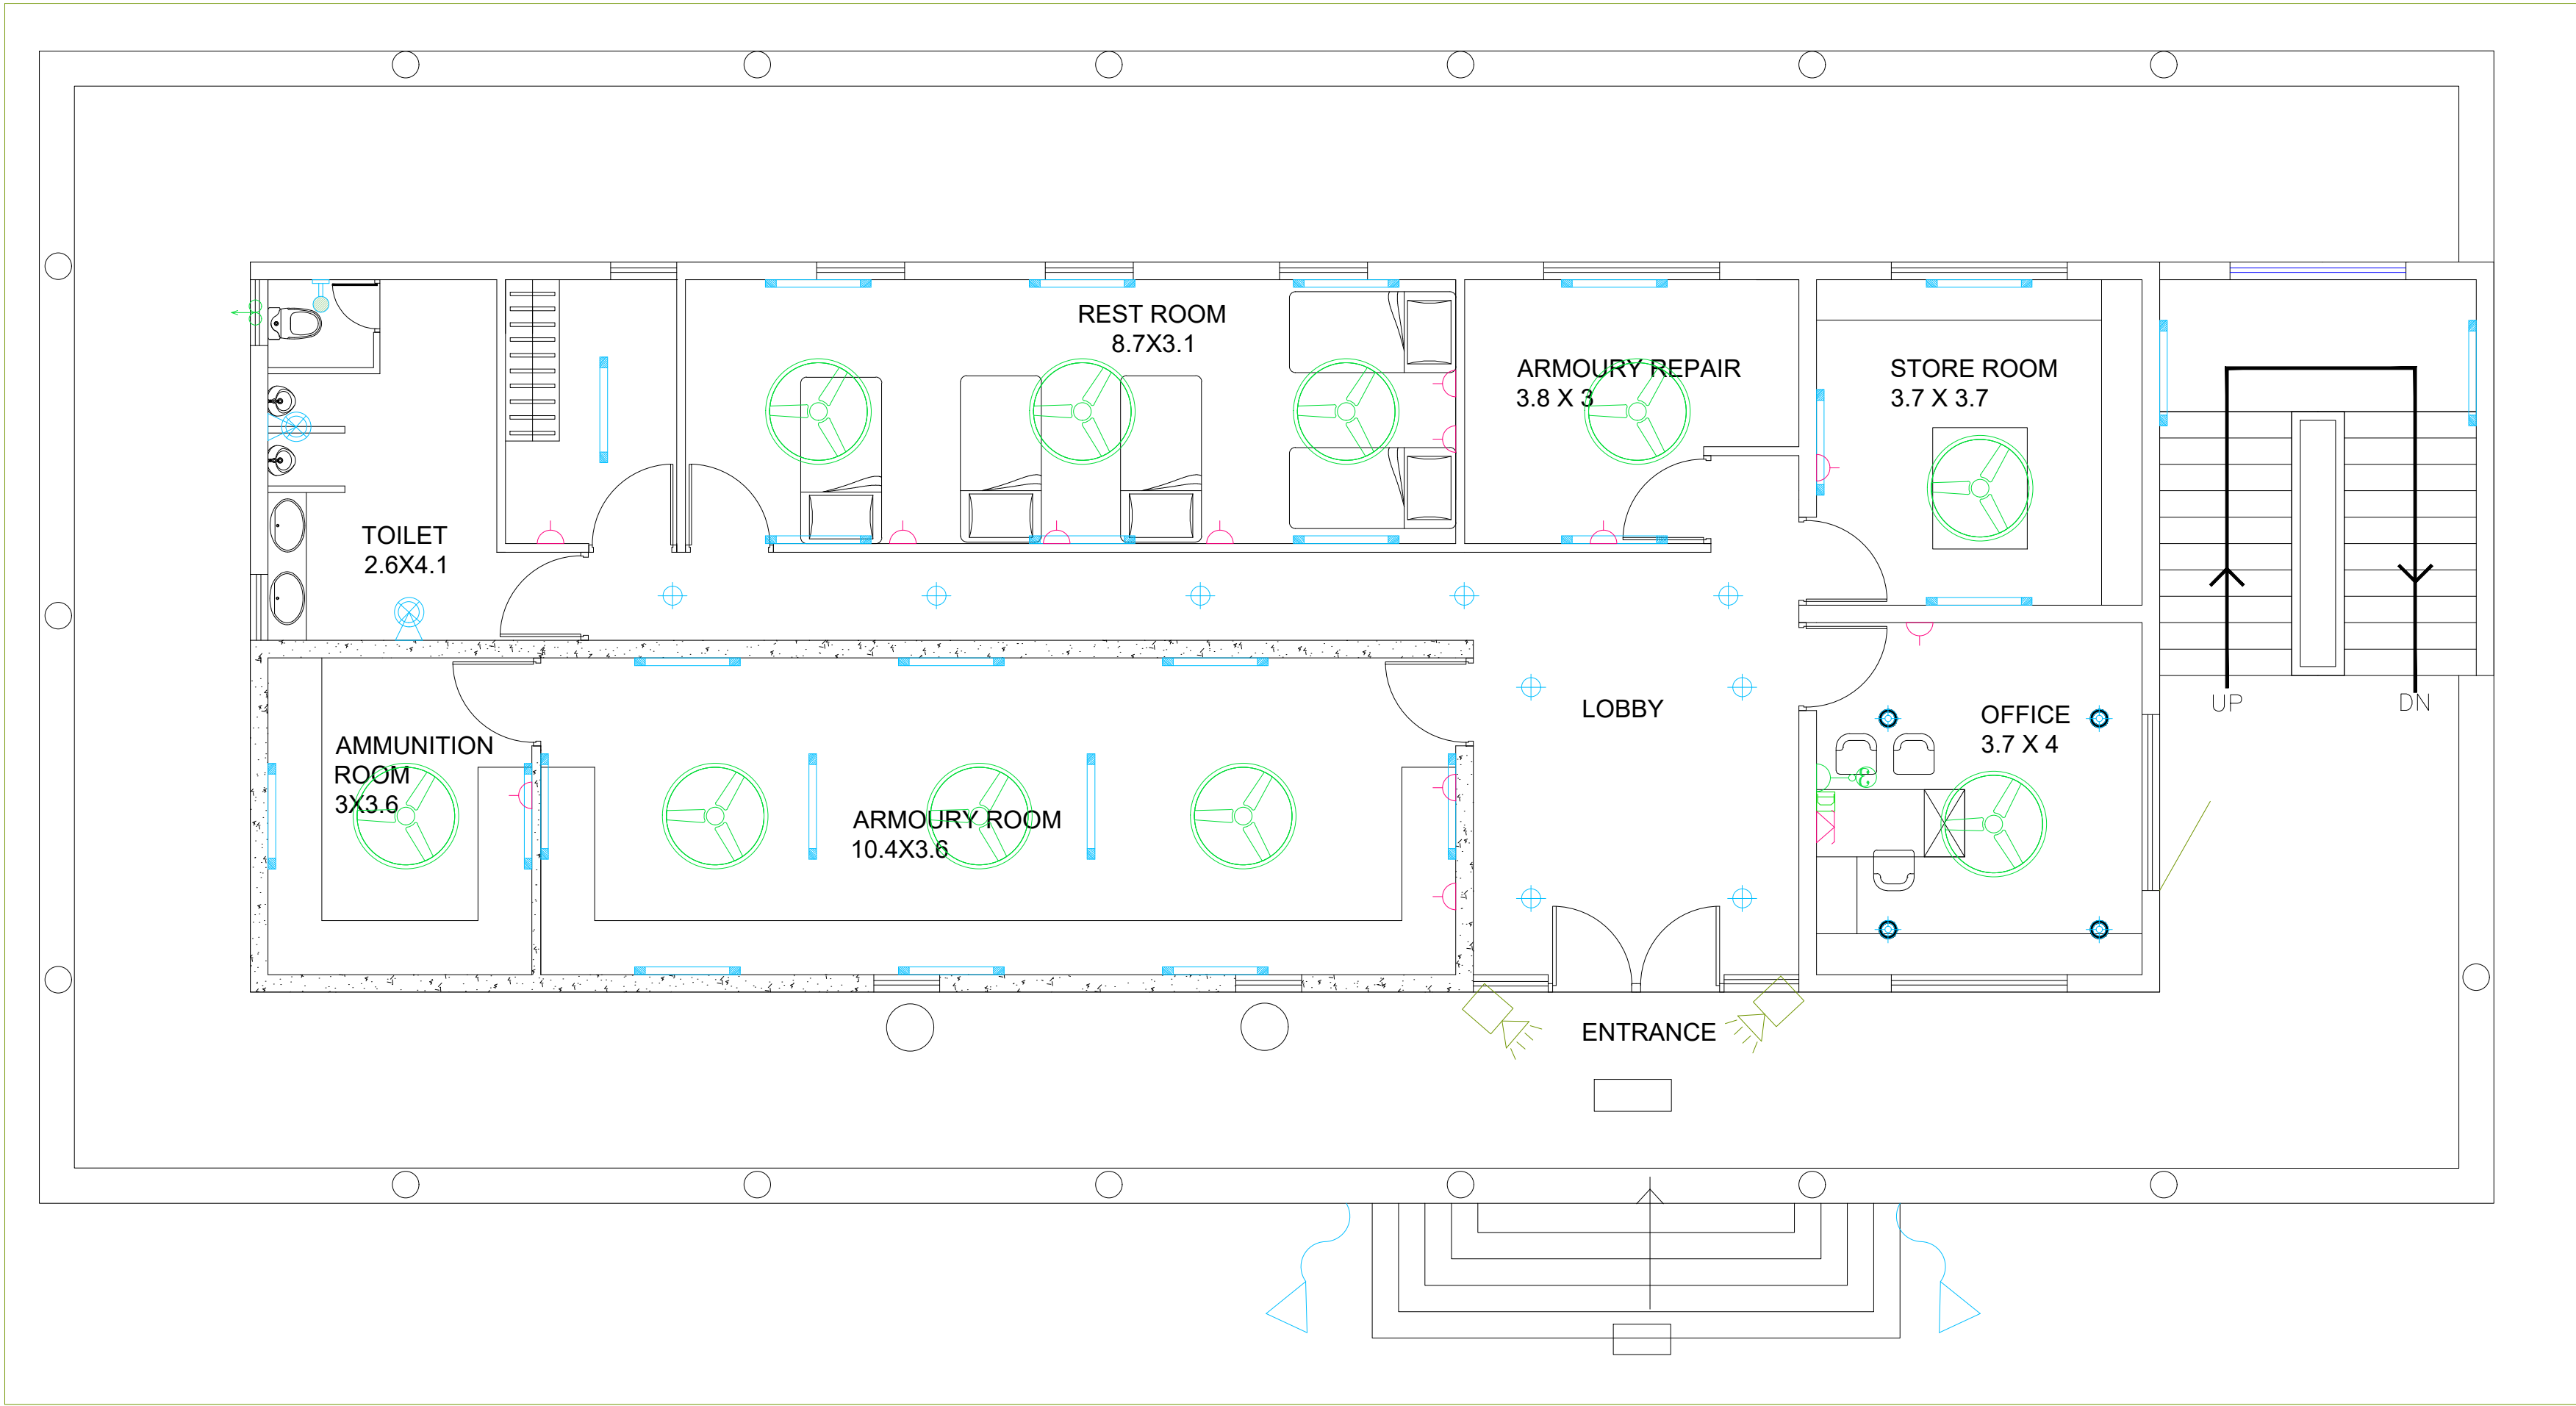

SYMBOL	DESCRIPTION	GF	TOTAL	GF	FF	TOTAL	GF	TOTAL
	40W STREET LIGHT							
	1X2' 10W MIRROR LIGHT FITTING							
	1X4' 20W LED LIGHT FITTING							
	7W RECESS/SURFACE MOUNTED LED SENSOR LIGHT FTG							
	12W RECESS/SURFACE MOUNTED LED TYPE DOWN LIGHT FTG							
	18W RECESS/SURFACE MOUNTED LED TYPE DOWN LIGHT FTG UPS							
	18W RECESS/SURFACE MOUNTED LED TYPE DOWN LIGHT FTG							
	2'-2'-36W LED RECESS MOUNTED FITTING							
	12W SURFACE MOUNTED RETROFIT TYPE LED LIGHT FTG							
	BULK HEAD FTG							
	WALL FAN							
	1200 MM CEILING FAN							

	300 MM LIGHT DUTY EXHAUST FAN																
	6A 3 PIN SOCKET WITH SWITCH																
	2NOS 6A 3 PIN SOCKET WITH SWITCH																
	2NOS 6A 3 PIN SOCKET WITH SWITCH (UPS)																
	3NOS 6A 3 PIN SOCKET WITH SWITCH(UPS)																
	6/16A 5 PIN SOCKET WITH SWITCH																
	TELEPHONE POINT																
	DATA POINT																
	CCTV POINT																

TENDER DRAWINGS

ELECTRICAL

ELECTRICAL FIXTURE LAYOUT

REV	DESCRIPTION	CHKD	DATE
DRAWING NO : ARCH001/ELE-01			
FILE NAME :			
Drawn : JEEVAN			
Checked : AMOL		REV.NO:	R0
Approved : Ar.Anil.K.		SCALE :	NTS
DATE : 08-11-2025		JOB.NO:	





TITLE : ELE DRAWING

GROUND FLOOR

PROJECT TITLE:

PROPOSED CONSTRUCTION OF
BRBNMPL - ARMOUR HOUSE

ARCHITECTS :
KULKARNI ASSOCIATES
Consulting Architects, Engineers, Project Management
Consultants Interior Designers & Regd. valuers
Surya Prema Building,next to Adiga's
Restaurant,Kanakapura Road
No-203,2nd floor,Above Canara bank
Raghuvanahalli Branch
Raghuvanahalli Village,Uttarahalli hobli
Bangalore-560062
Email Id : kulkarni.associates@yahoo.com

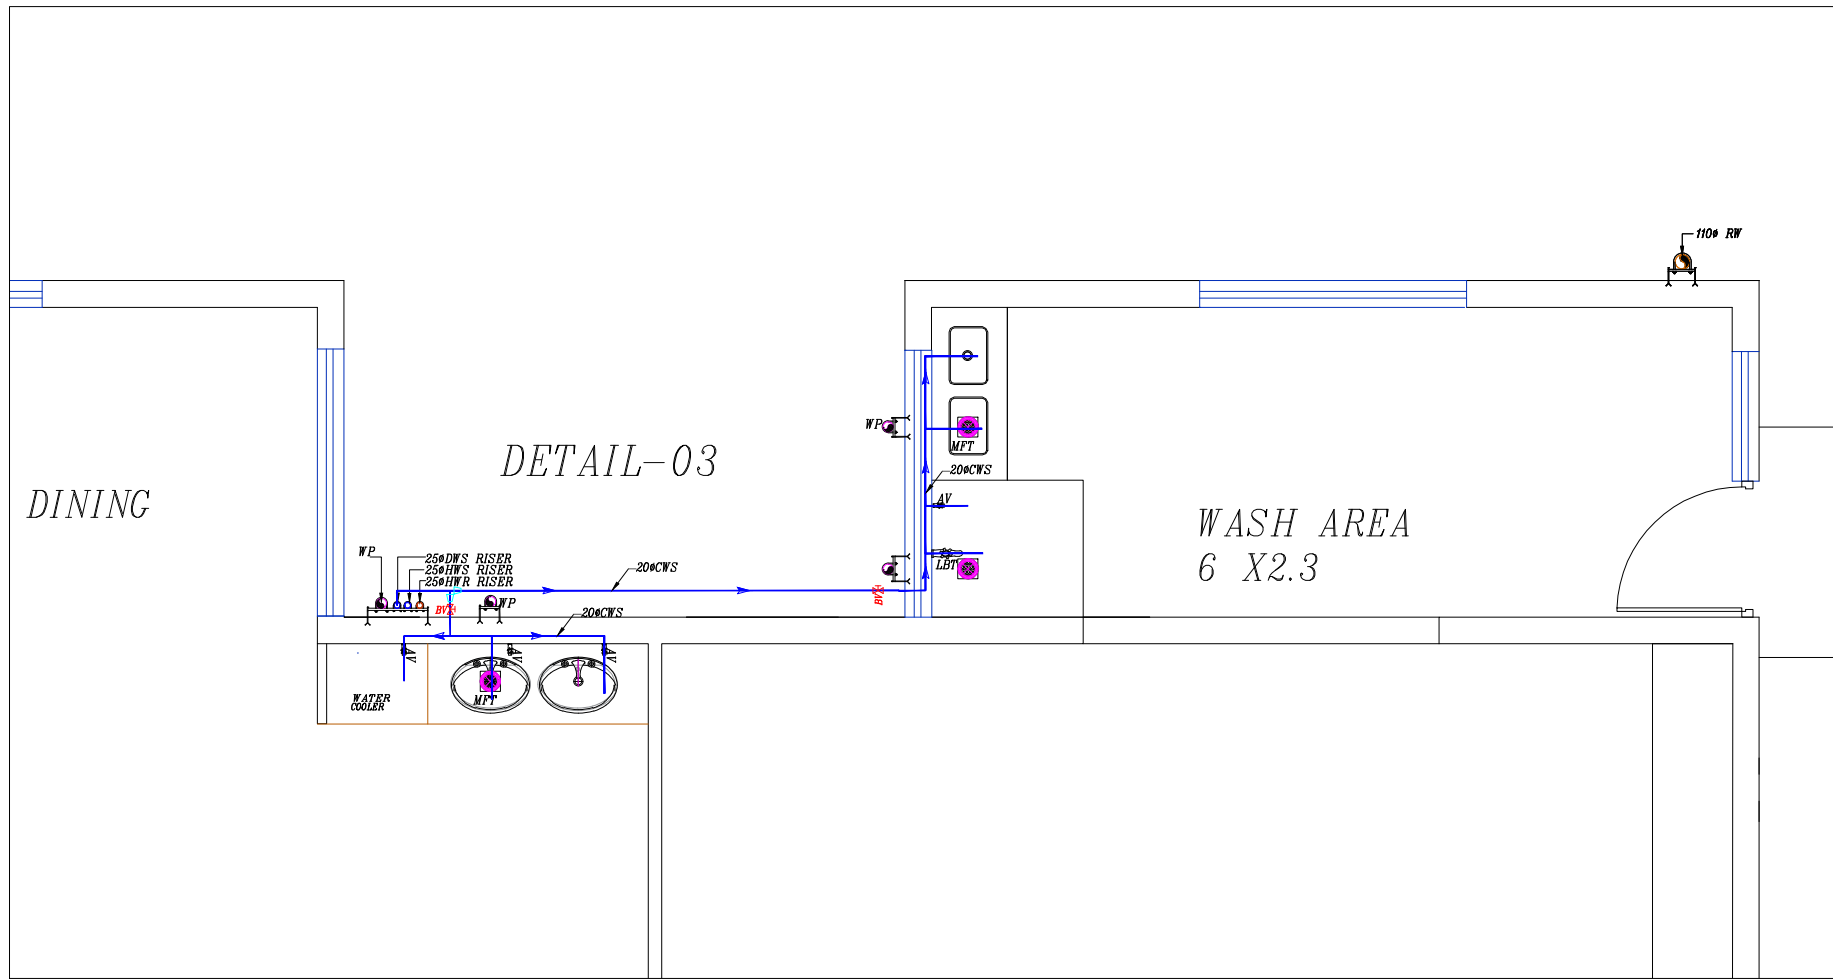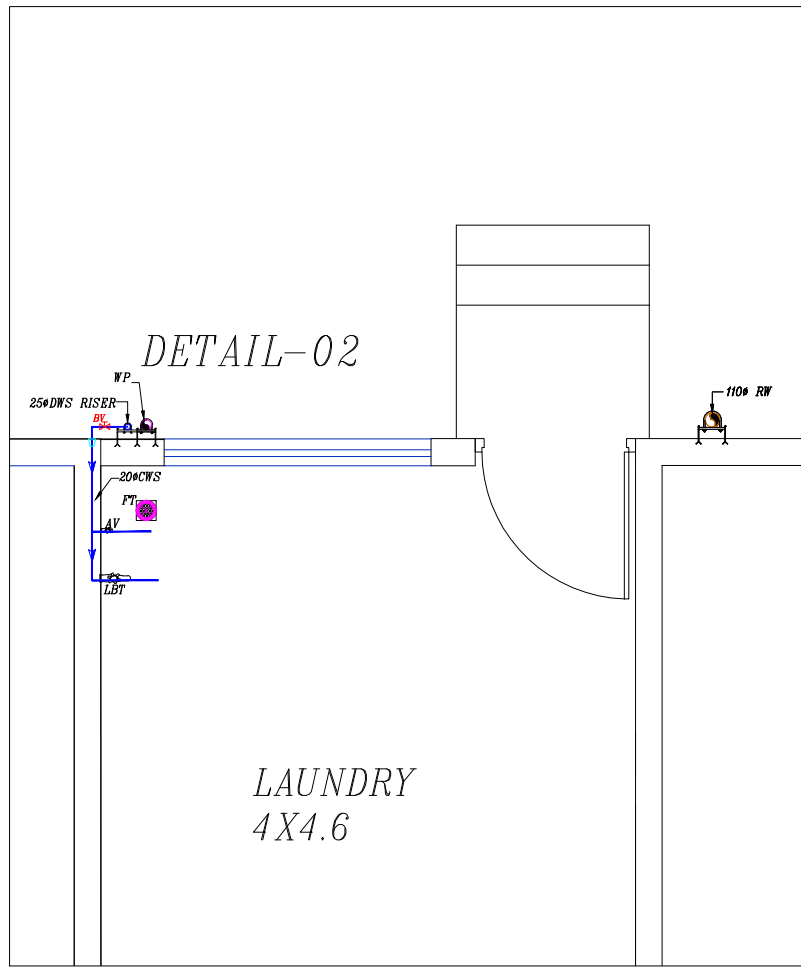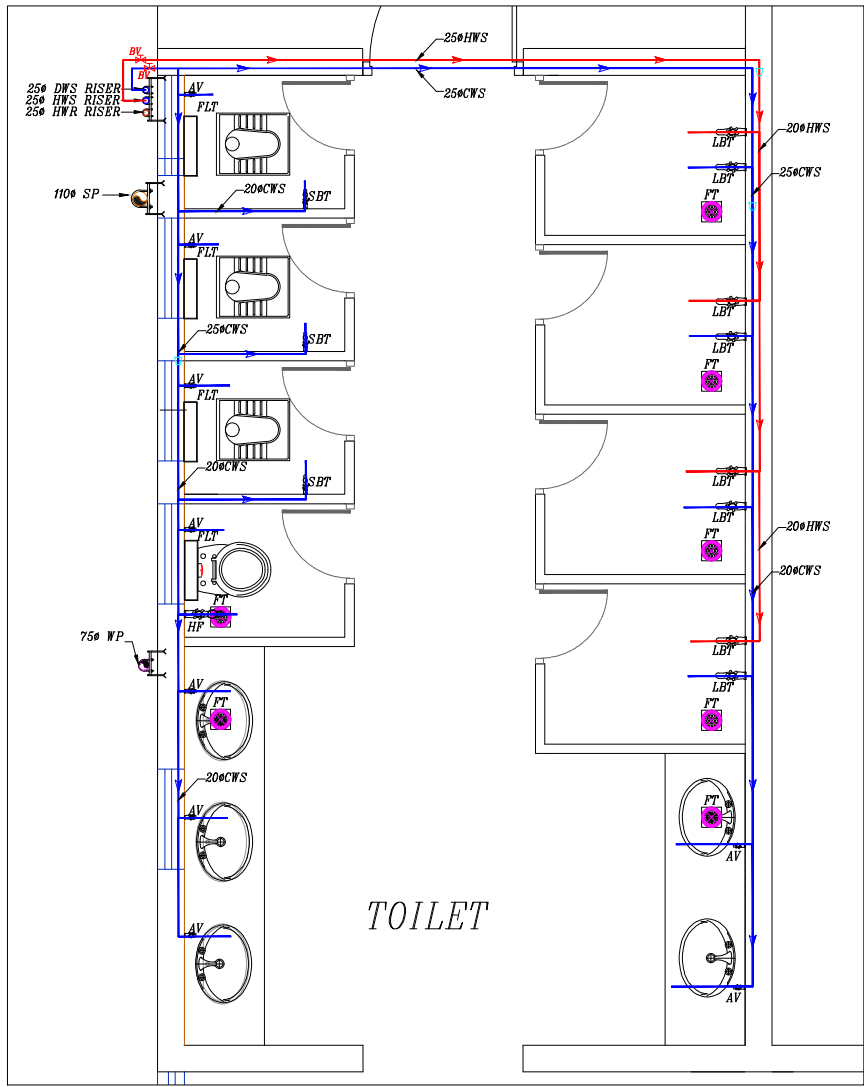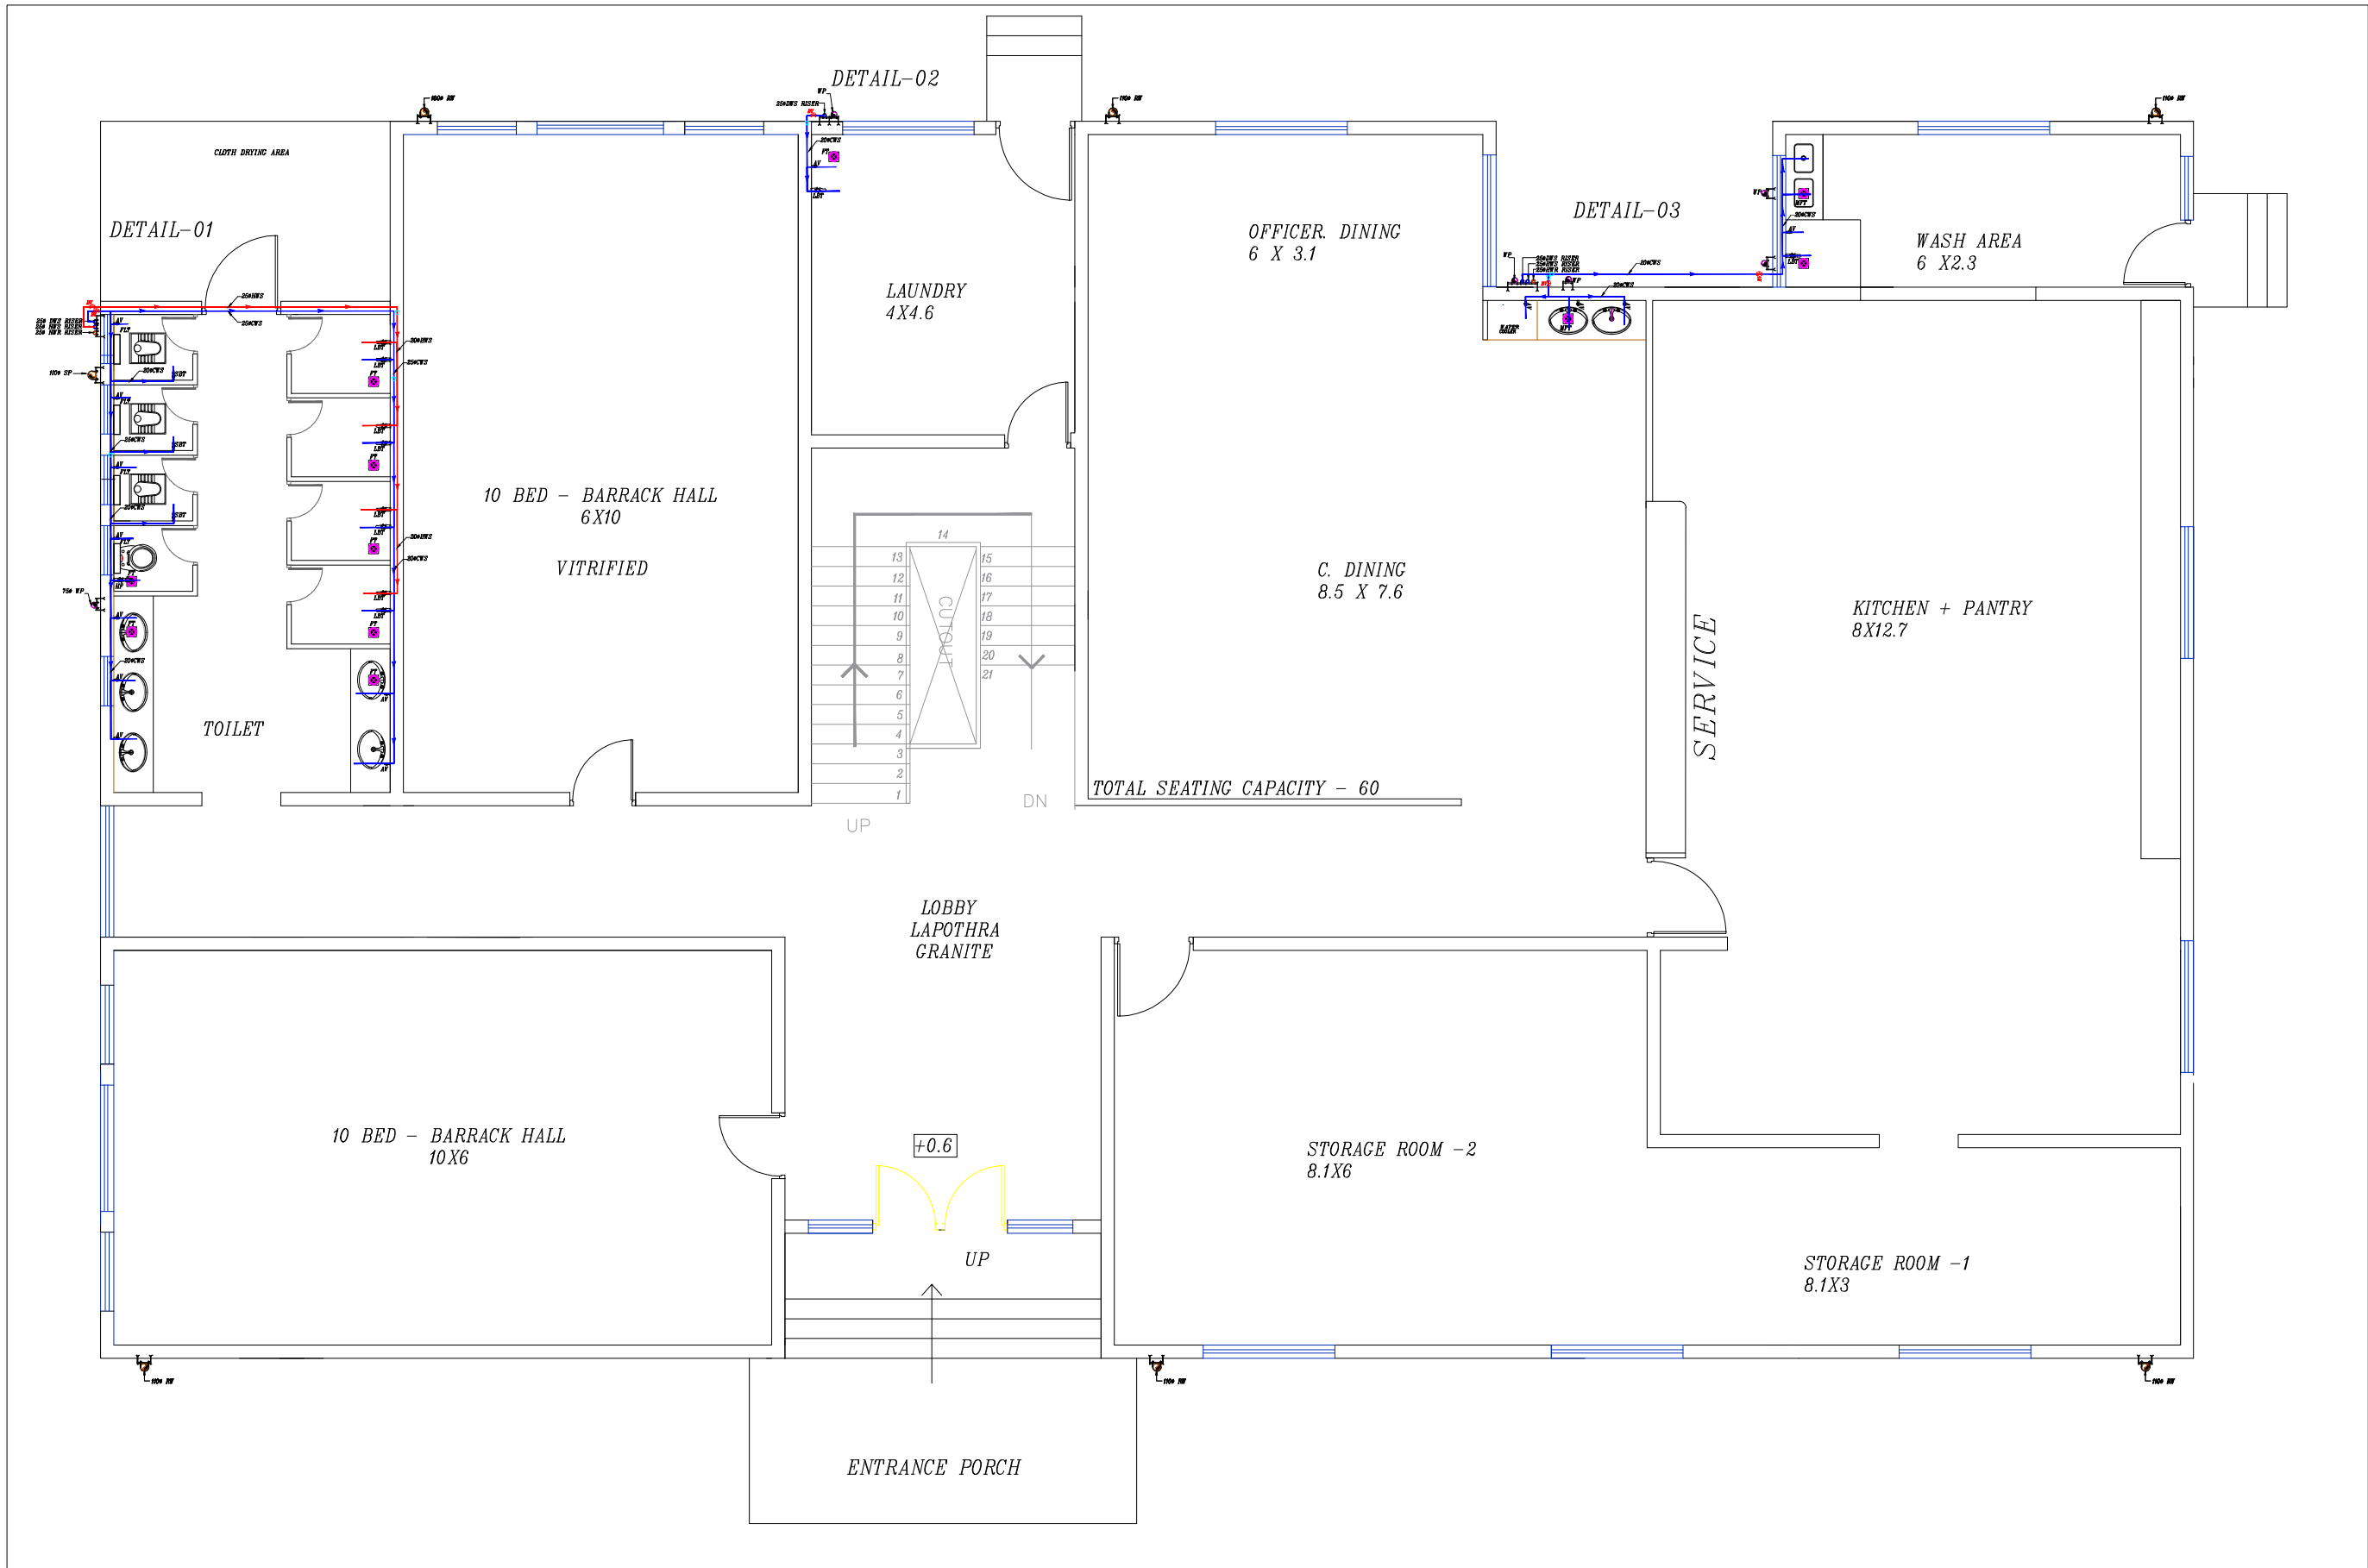

LEGEND		
01	EWC	INDIAN WATER CLOSET
02	EWC	EUROPEAN WATER CLOSET
03	HF	HEALTH FAUCET
04	WB	OVAL WASH BASIN
05	FT	FLOOR TRAP
06	MPT	MULTI INLET FLOOR TRAP
07	SSS	STAINLESS STEEL SINK
08	LBT	LONG BODY TAP
09	SBT	SHORT BODY TAP
10	AV	ANGLE VALVE
11	750 WP	750 WASTE PIPE
12	1100 SP	1100 SOIL PIPE
13	DWS RISER	DOMESTIC WATER SUPPLY RISER
14	HWS RISES	HOT WATER SUPPLY RISER
15	HWR RISER	HOT WATER RETURN RISER
16	HWS	HOT WATER SUPPLY
17	BY	BALL VALVE
18		PIPE REDUCER

TENDER DRAWINGS

PHE




DOMESTIC COLD AND HOT WATER SUPPLY

REV	DESCRIPTION	CHKD	DATE
DRAWING NO : ARCH002/PHE-01			
FILE NAME :			
Drawn : AV			
Checked : AMOL			REV.NO: R0
Approved : Ar.Anil.K.		SCALE : NTS	
DATE : 01-1-2025		JOB.NO:	

TITLE : PHE DRAWING
GROUND FLOOR PLAN

PROJECT TITLE:
PROPOSED CONSTRUCTION OF
BNPM - BARRACK

ARCHITECTS :
KULKARNI ASSOCIATES
Consulting Architects, Engineers, Project Management Consultants
Interior Designers & Regd. valuers
Surya Prema Building, next to Adiga's Restaurant, Kanakapura Road
No-203, 2nd floor, Above Canara bank Raghuvanahalli Branch
Raghuvanahalli Village, Uttarahalli hobli Bangalore-560062
Email Id : kulkarni.associates@yahoo.com

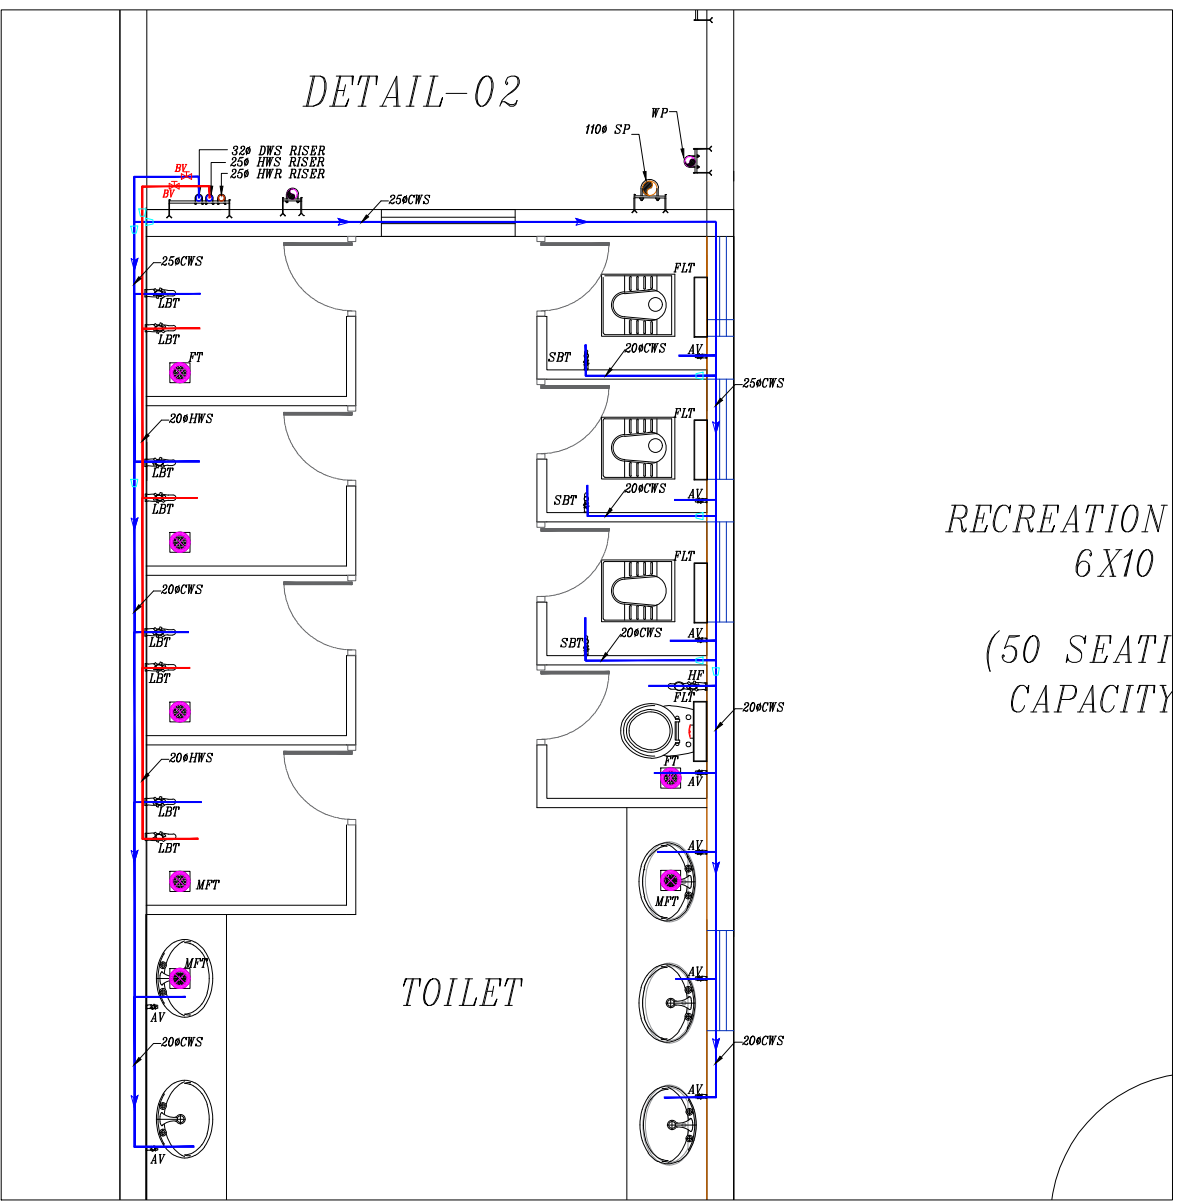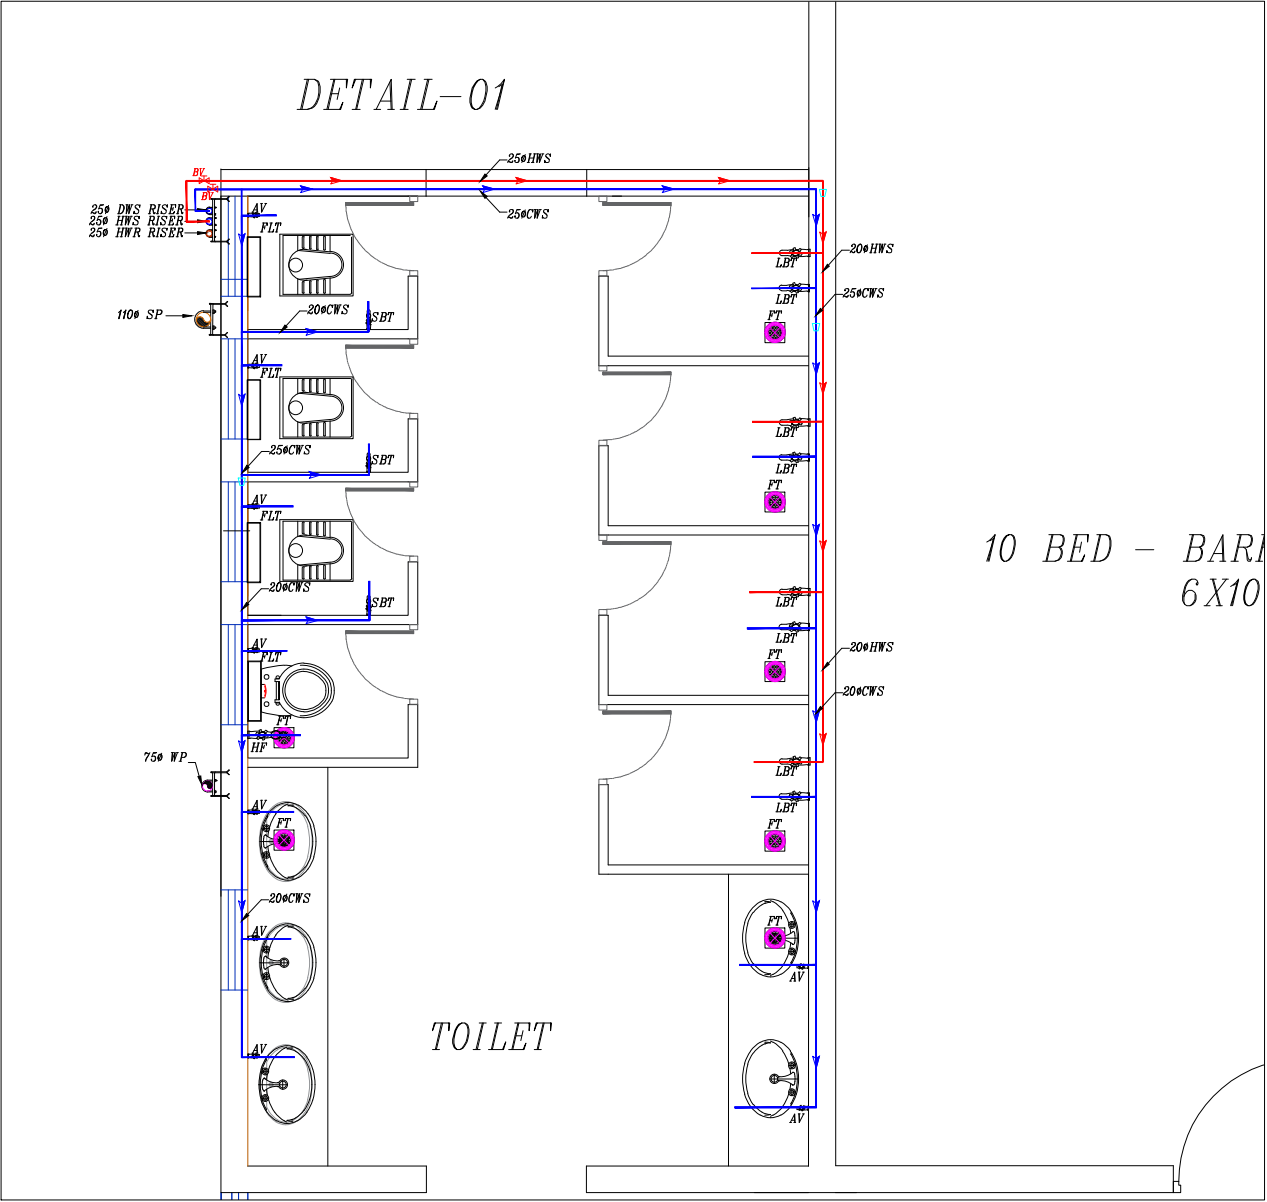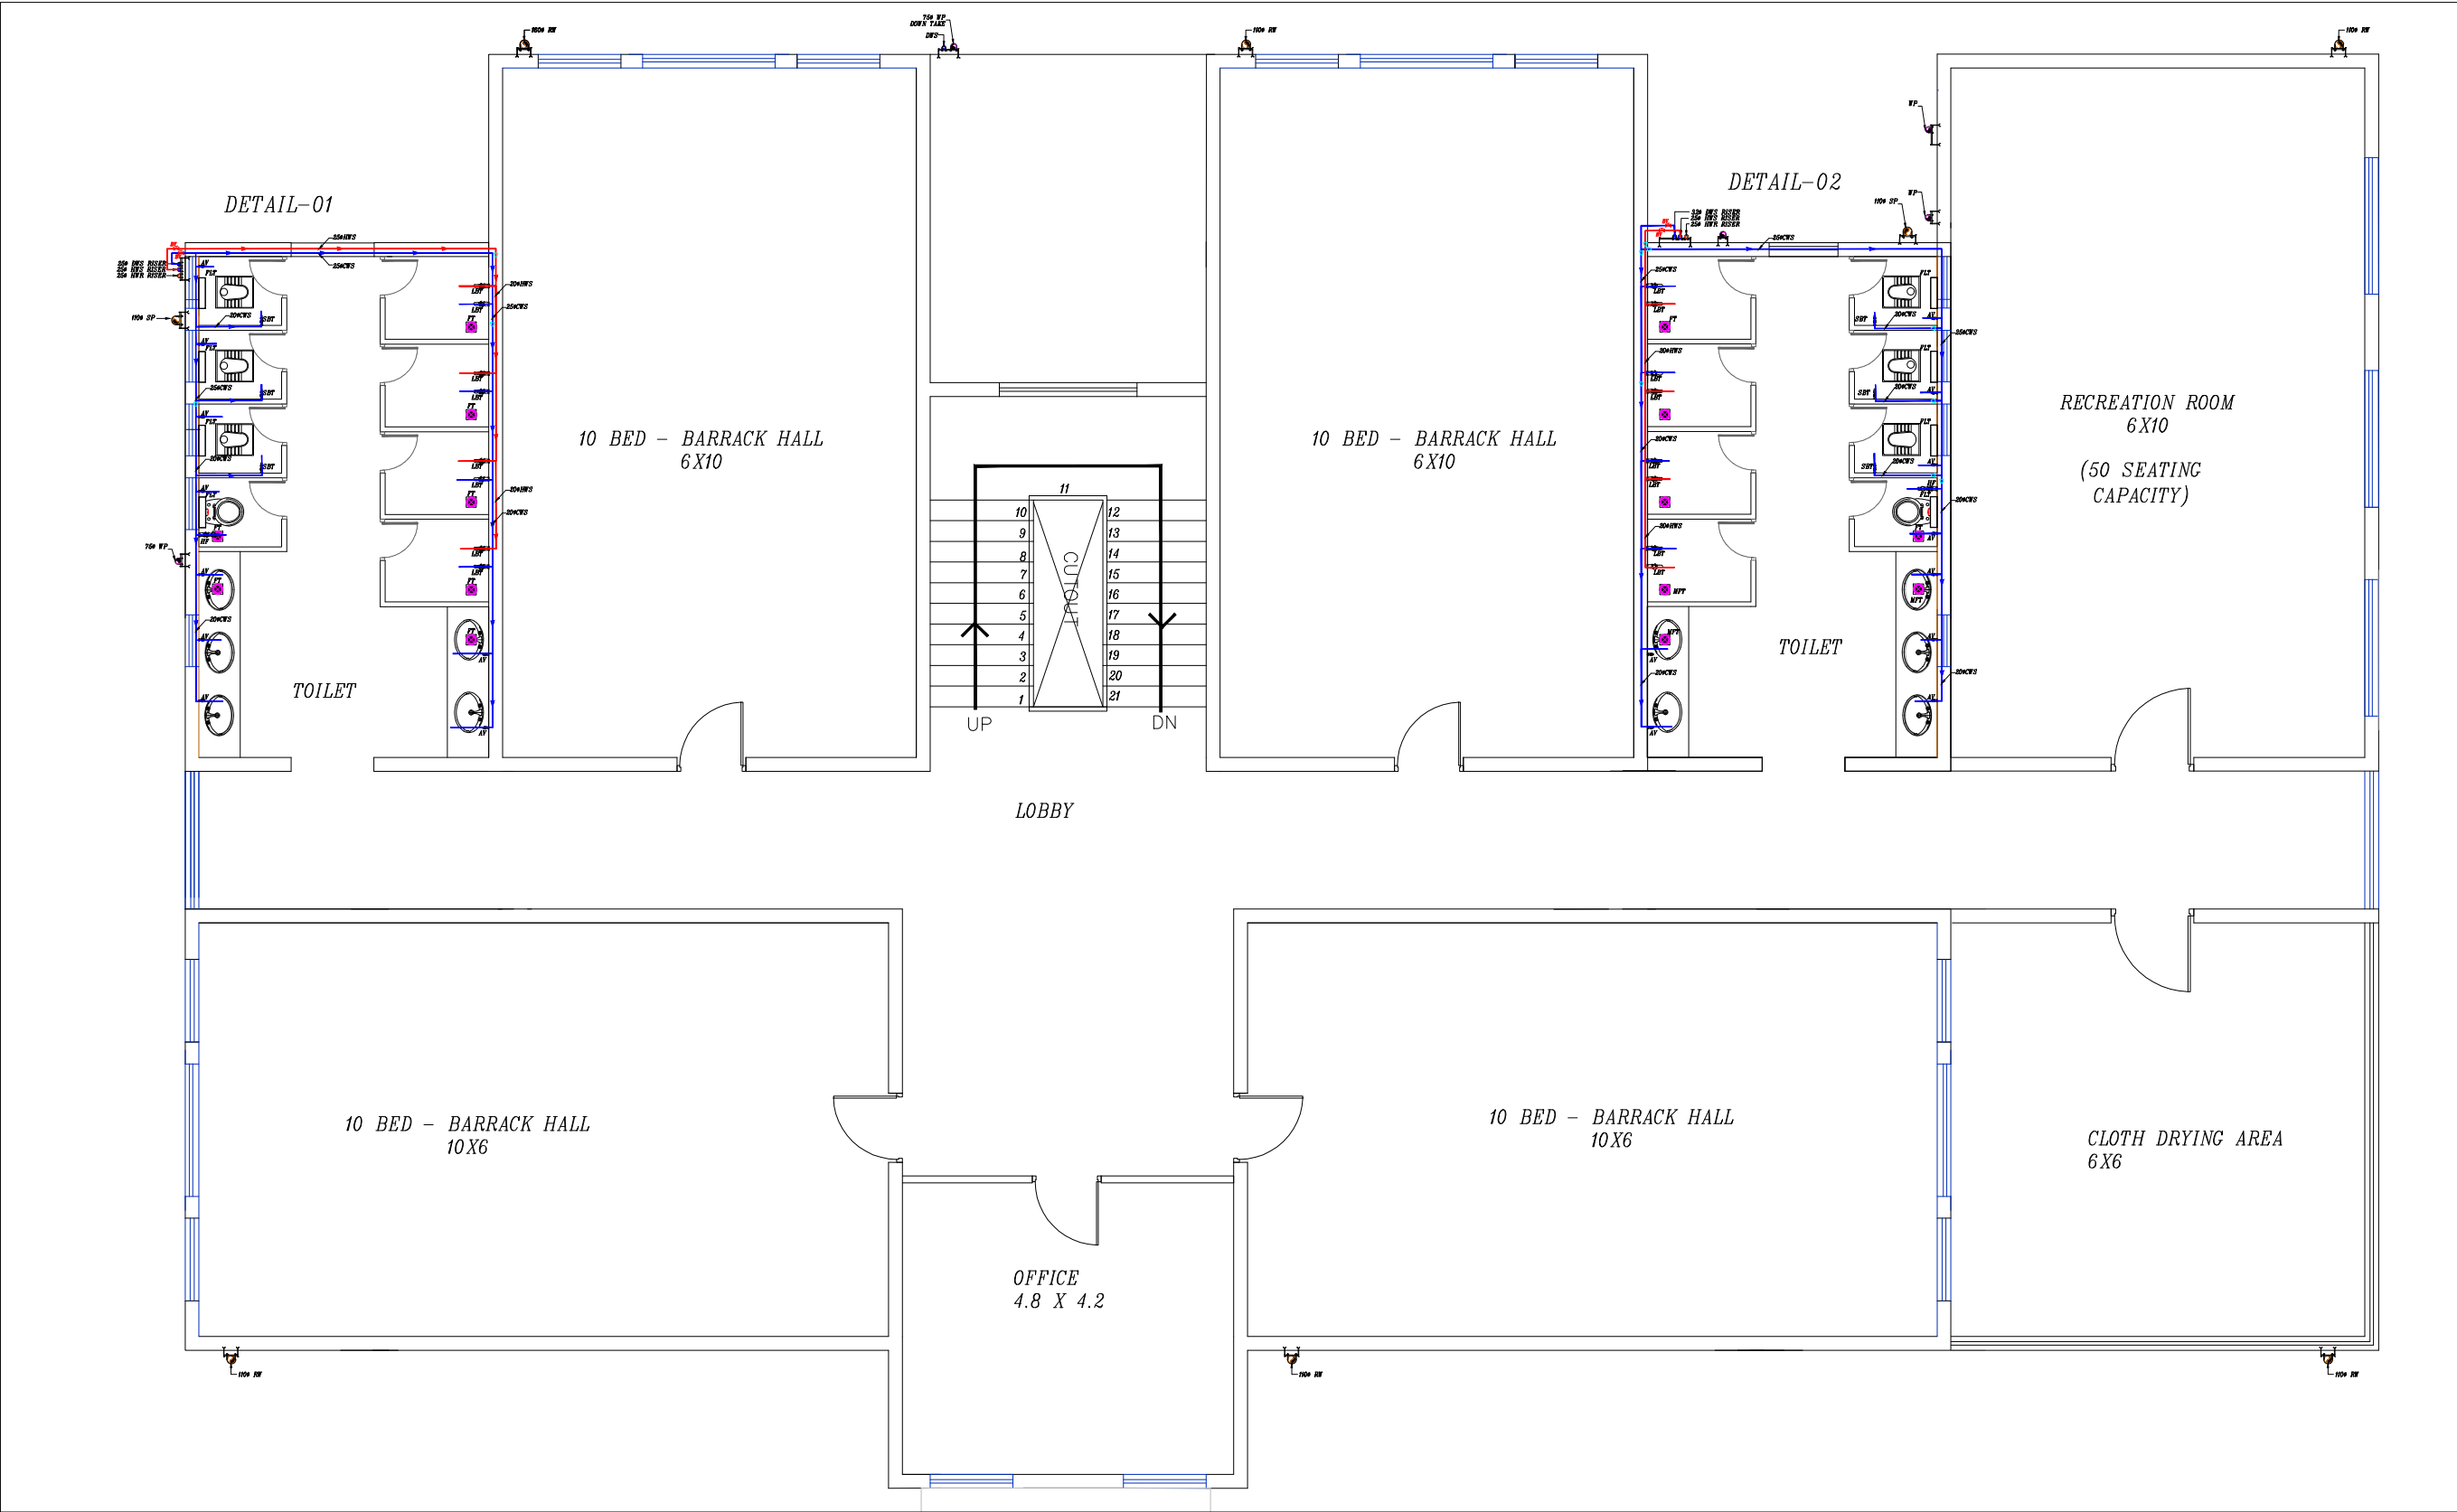

LEGEND			
01	EWC		INDIAN WATER CLOSET
02	EWC		EUROPEAN WATER CLOSET
03	HF		HEALTH FAUCET
04	WB		OVAL WASH BASIN
05	FT		FLOOR TRAP
06	MPT		MULTI INLET FLOOR TRAP
07	SSS		STAINLESS STEEL SINK
08	LBT		LONG BODY TAP
09	SBT		SHORT BODY TAP
10	AV		ANGLE VALVE
11	750 WP		750 WASTE PIPE
12	1100 SP		1100 SOIL PIPE
13	DWS RISER		DOMESTIC WATER SUPPLY RISER
14	HWS RISES		HOT WATER SUPPLY RISER
15	HWR RISER		HOT WATER RETURN RISER
16	HWS		HOT WATER SUPPLY
17	BY		BALL VALVE
18			PIPE REDUCER

TENDER DRAWINGS

PHE





DOMESTIC COLD AND HOT WATER SUPPLY

REV	DESCRIPTION	CHKD	DATE
DRAWING NO : ARCH001/PHE-02			R0
FILE NAME :			
Drawn : AV			
Checked : AMOL		REV.NO:	SCALE : NTS
DATE : 01-1-2025		JOB.NO:	

TITLE : PHE DRAWING
FIRST FLOOR PLAN

PROJECT TITLE:
PROPOSED CONSTRUCTION OF
BNPM - BARRACK

ARCHITECTS :
KULKARNI ASSOCIATES
Consulting Architects, Engineers,Project Management Consultants
Interior Designers & Regd. valuers
Surya Prema Building,next to Adiga's Restaurant,Kanakapura Road
No-203,2nd floor,Above Canara bank Raghuvanahalli Branch
Raghuvanahalli Village,Uttarahalli hobli Bangalore-560062
Email Id : kulkarni.associates@yahoo.com

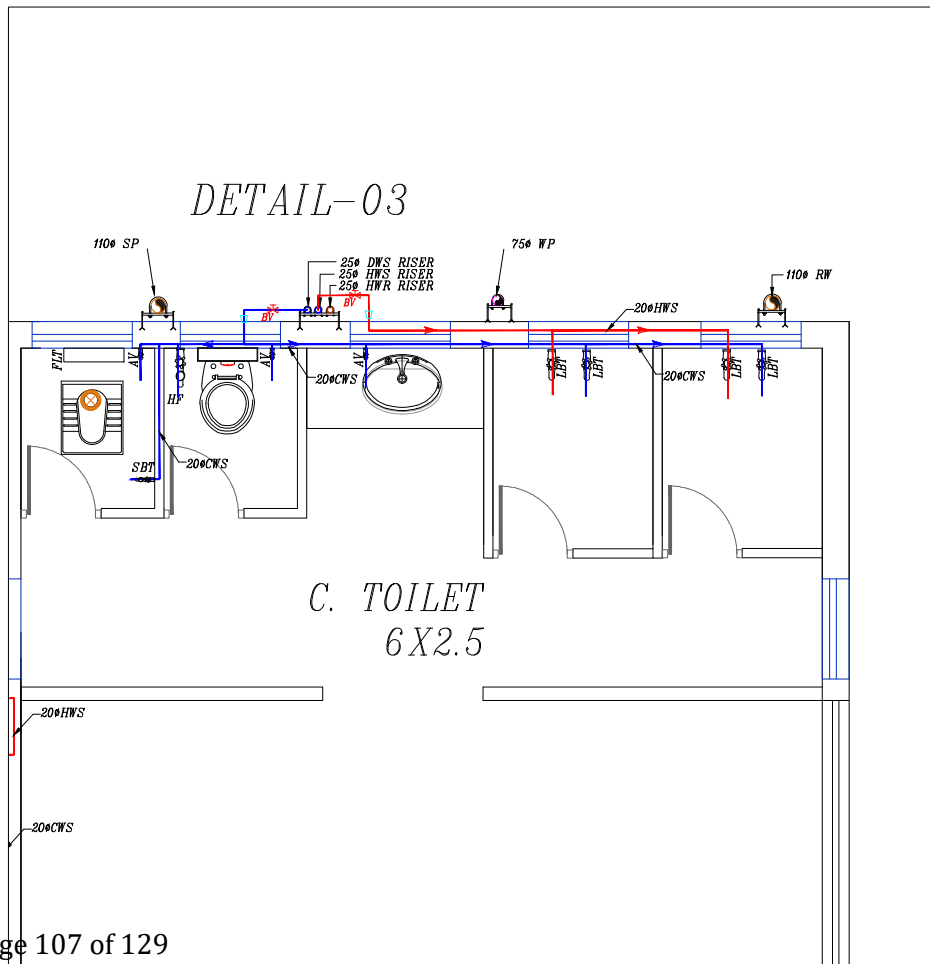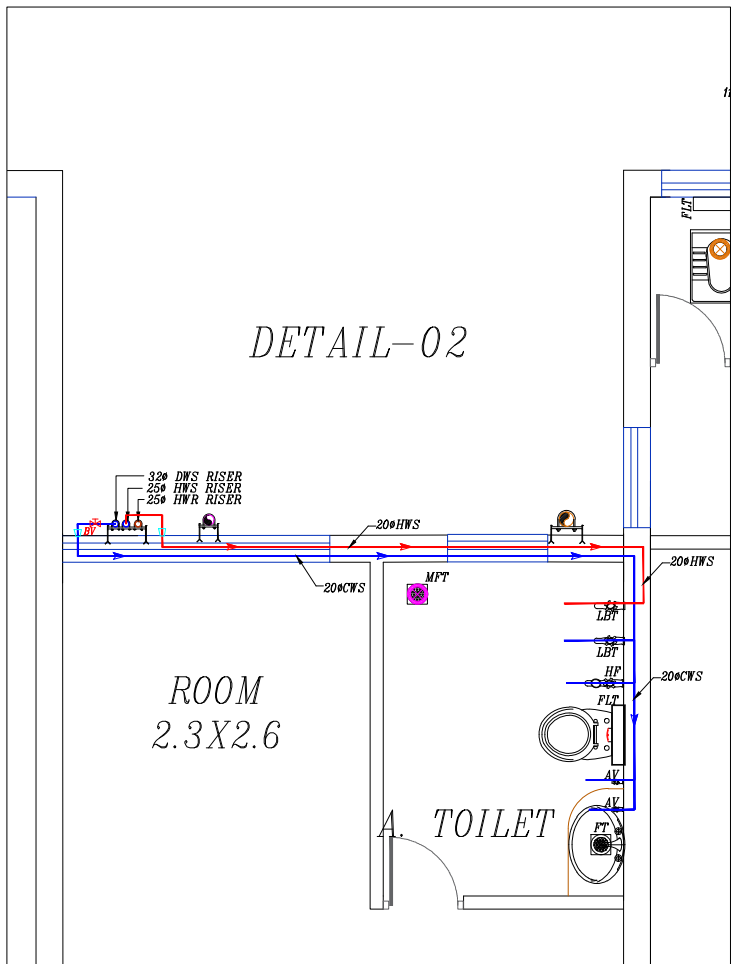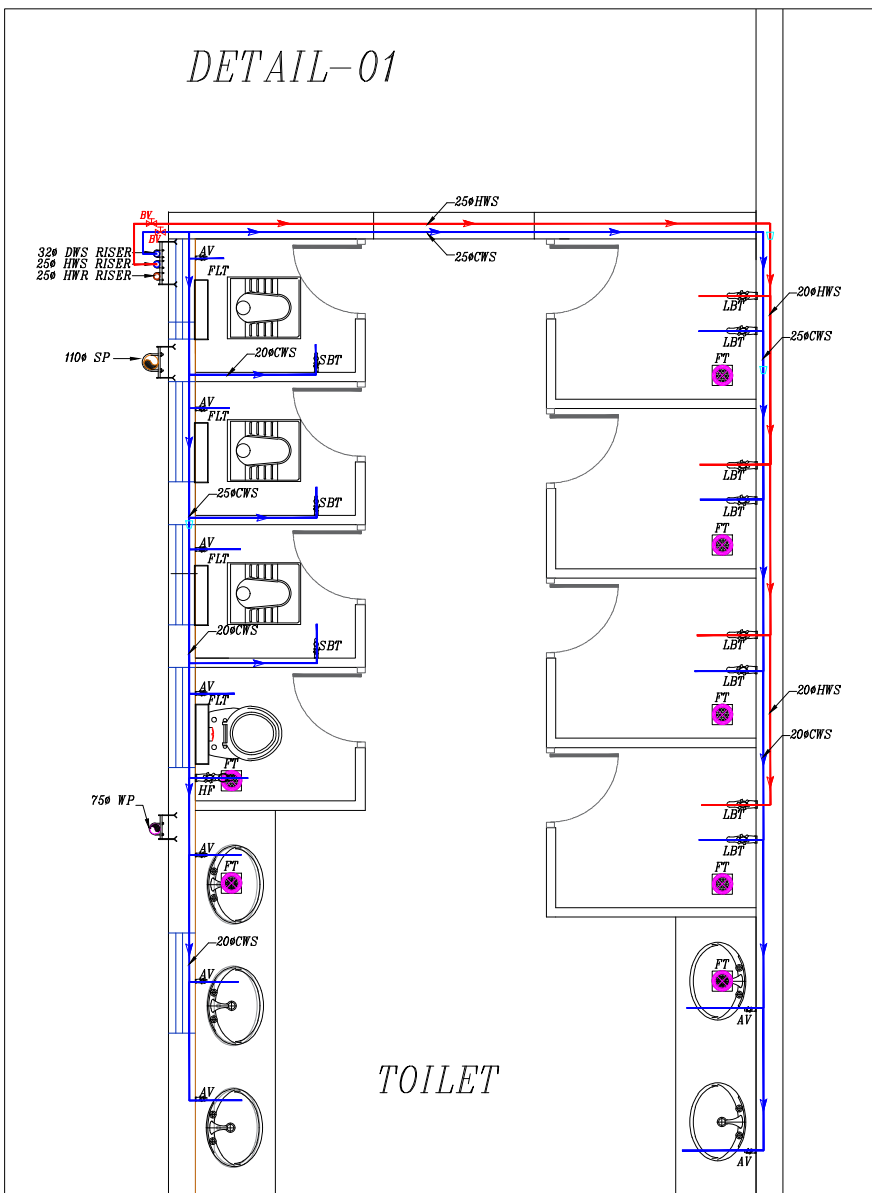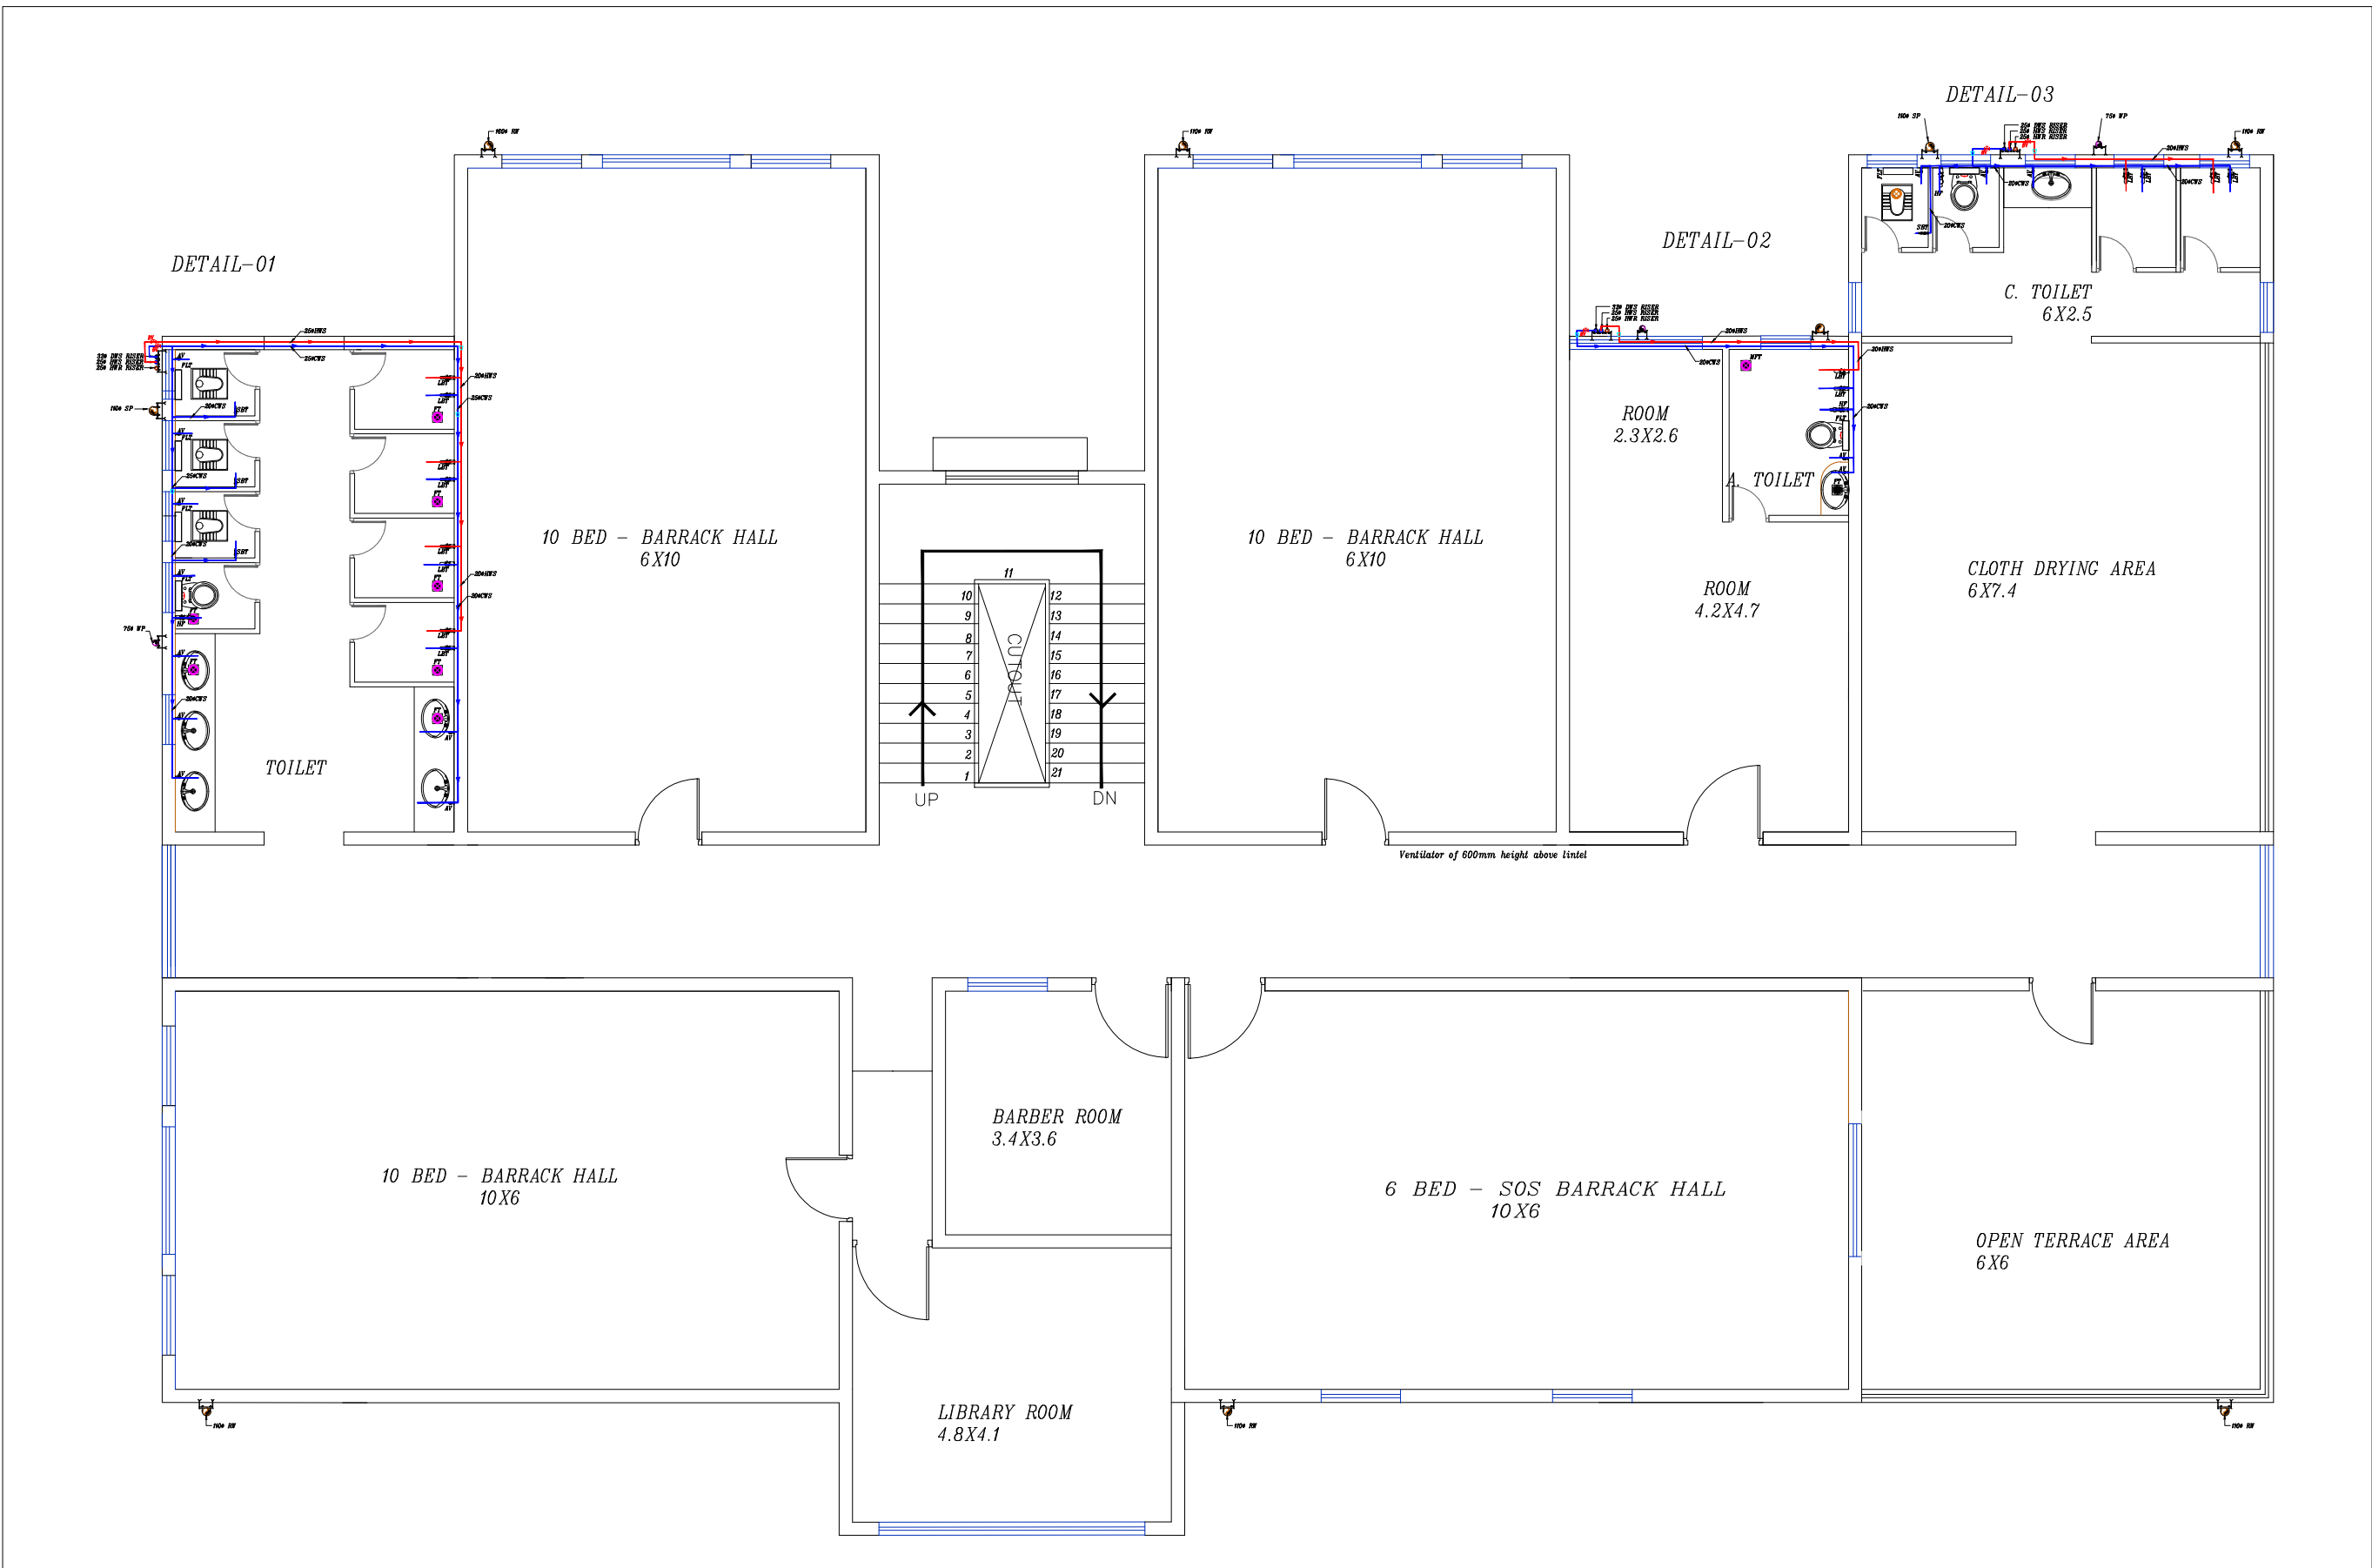

LEGEND			
01	EWC		INDIAN WATER CLOSET
02	EWC		EUROPEAN WATER CLOSET
03	HF		HEALTH FAUCET
04	WB		OVAL WASH BASIN
05	FT		FLOOR TRAP
06	MPT		MULTI INLET FLOOR TRAP
07	SSS		STAINLESS STEEL SINK
08	LBT		LONG BODY TAP
09	SBT		SHORT BODY TAP
10	AV		ANGLE VALVE
11	750 WP		750 WASTE PIPE
12	1100 SP		1100 SOIL PIPE
13	DWS RISER		DOMESTIC WATER SUPPLY RISER
14	HWS RISES		HOT WATER SUPPLY RISER
15	HWR RISER		HOT WATER RETURN RISER
16	HWS		HOT WATER SUPPLY
17	BY		BALL VALVE
18			PIPE REDUCER

TENDER DRAWINGS

PHE





DOMESTIC COLD AND HOT WATER SUPPLY

REV	DESCRIPTION	CHKD	DATE
	DRAWING NO : ARCH001/PHE-03		
	FILE NAME :		
	Drawn : AV		
	Checked : AMOL	REV.NO: R0	
	Approved : Ar.Anil.K.	SCALE : NTS	
	DATE : 01-1-2025	JOB.NO:	


TITLE : PHE DRAWING
SECOND FLOOR PLAN



PROJECT TITLE:
PROPOSED CONSTRUCTION OF
BNPM - BARRACK

ARCHITECTS :
KULKARNI ASSOCIATES
Consulting Architects, Engineers,Project Management Consultants
Interior Designers & Regd. valuers
Surya Prema Building,next to Adiga's Restaurant,Kanakapura Road
No-203,2nd floor,Above Canara bank Raghuvanahalli Branch
Raghuvanahalli Village,Uttarahalli hobli Bangalore-560062
Email Id : kulkarni.associates@yahoo.com

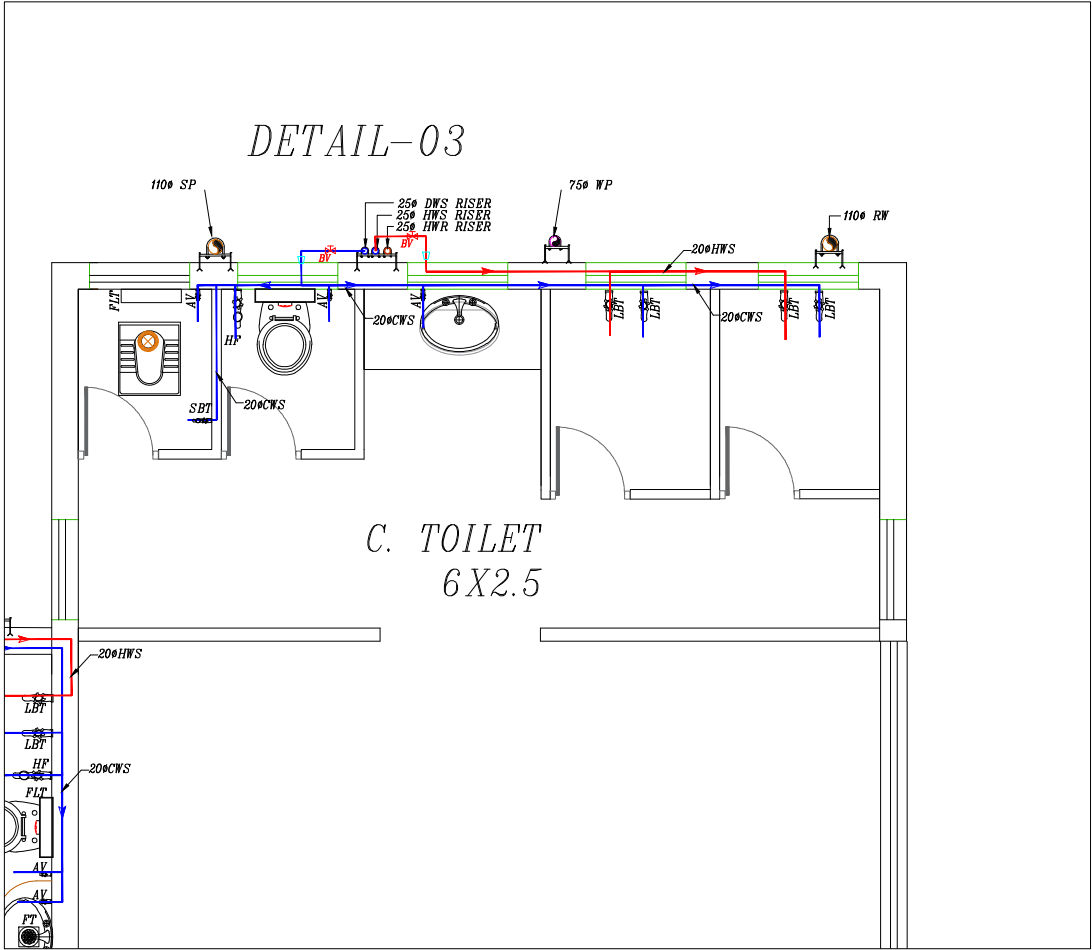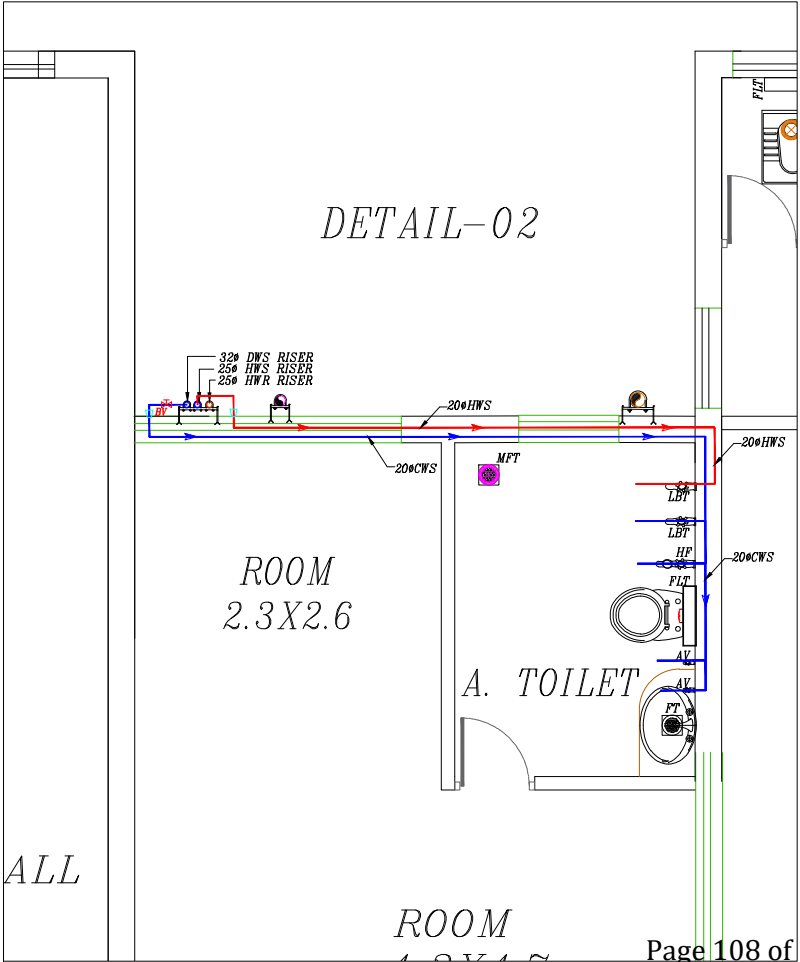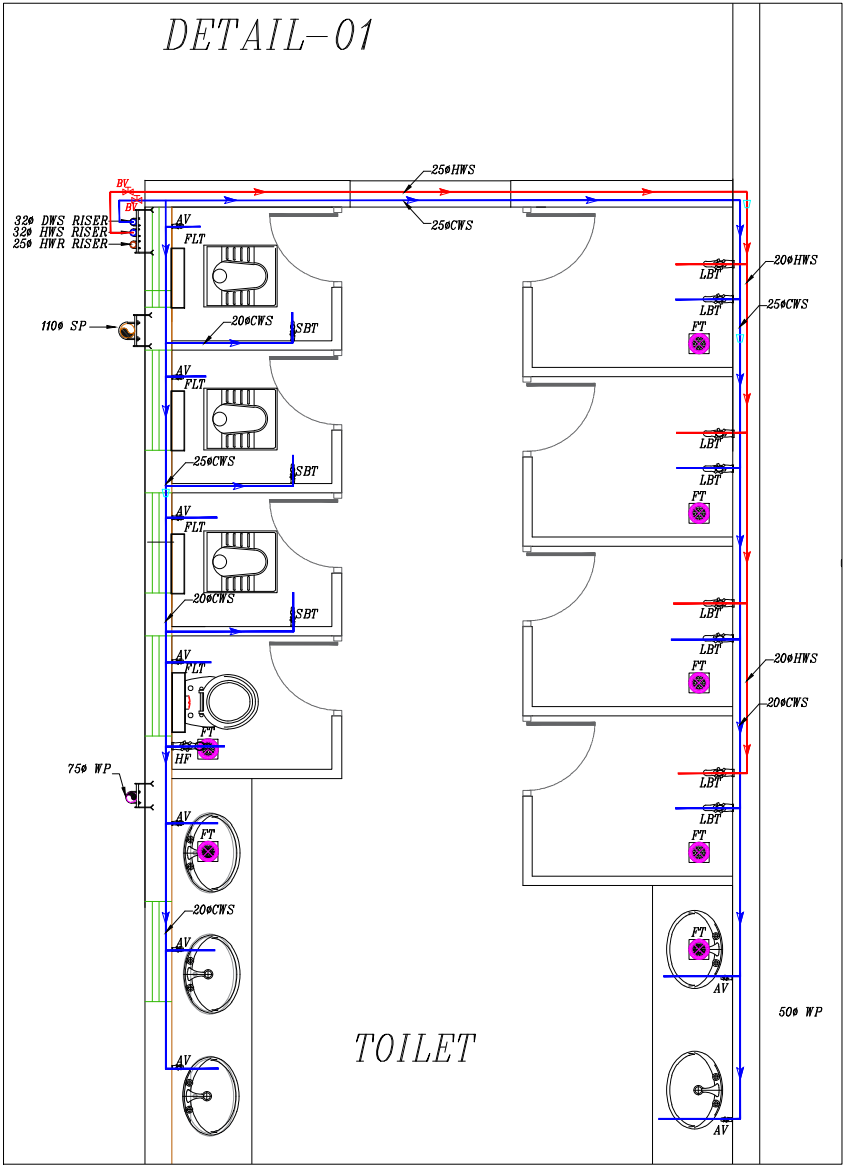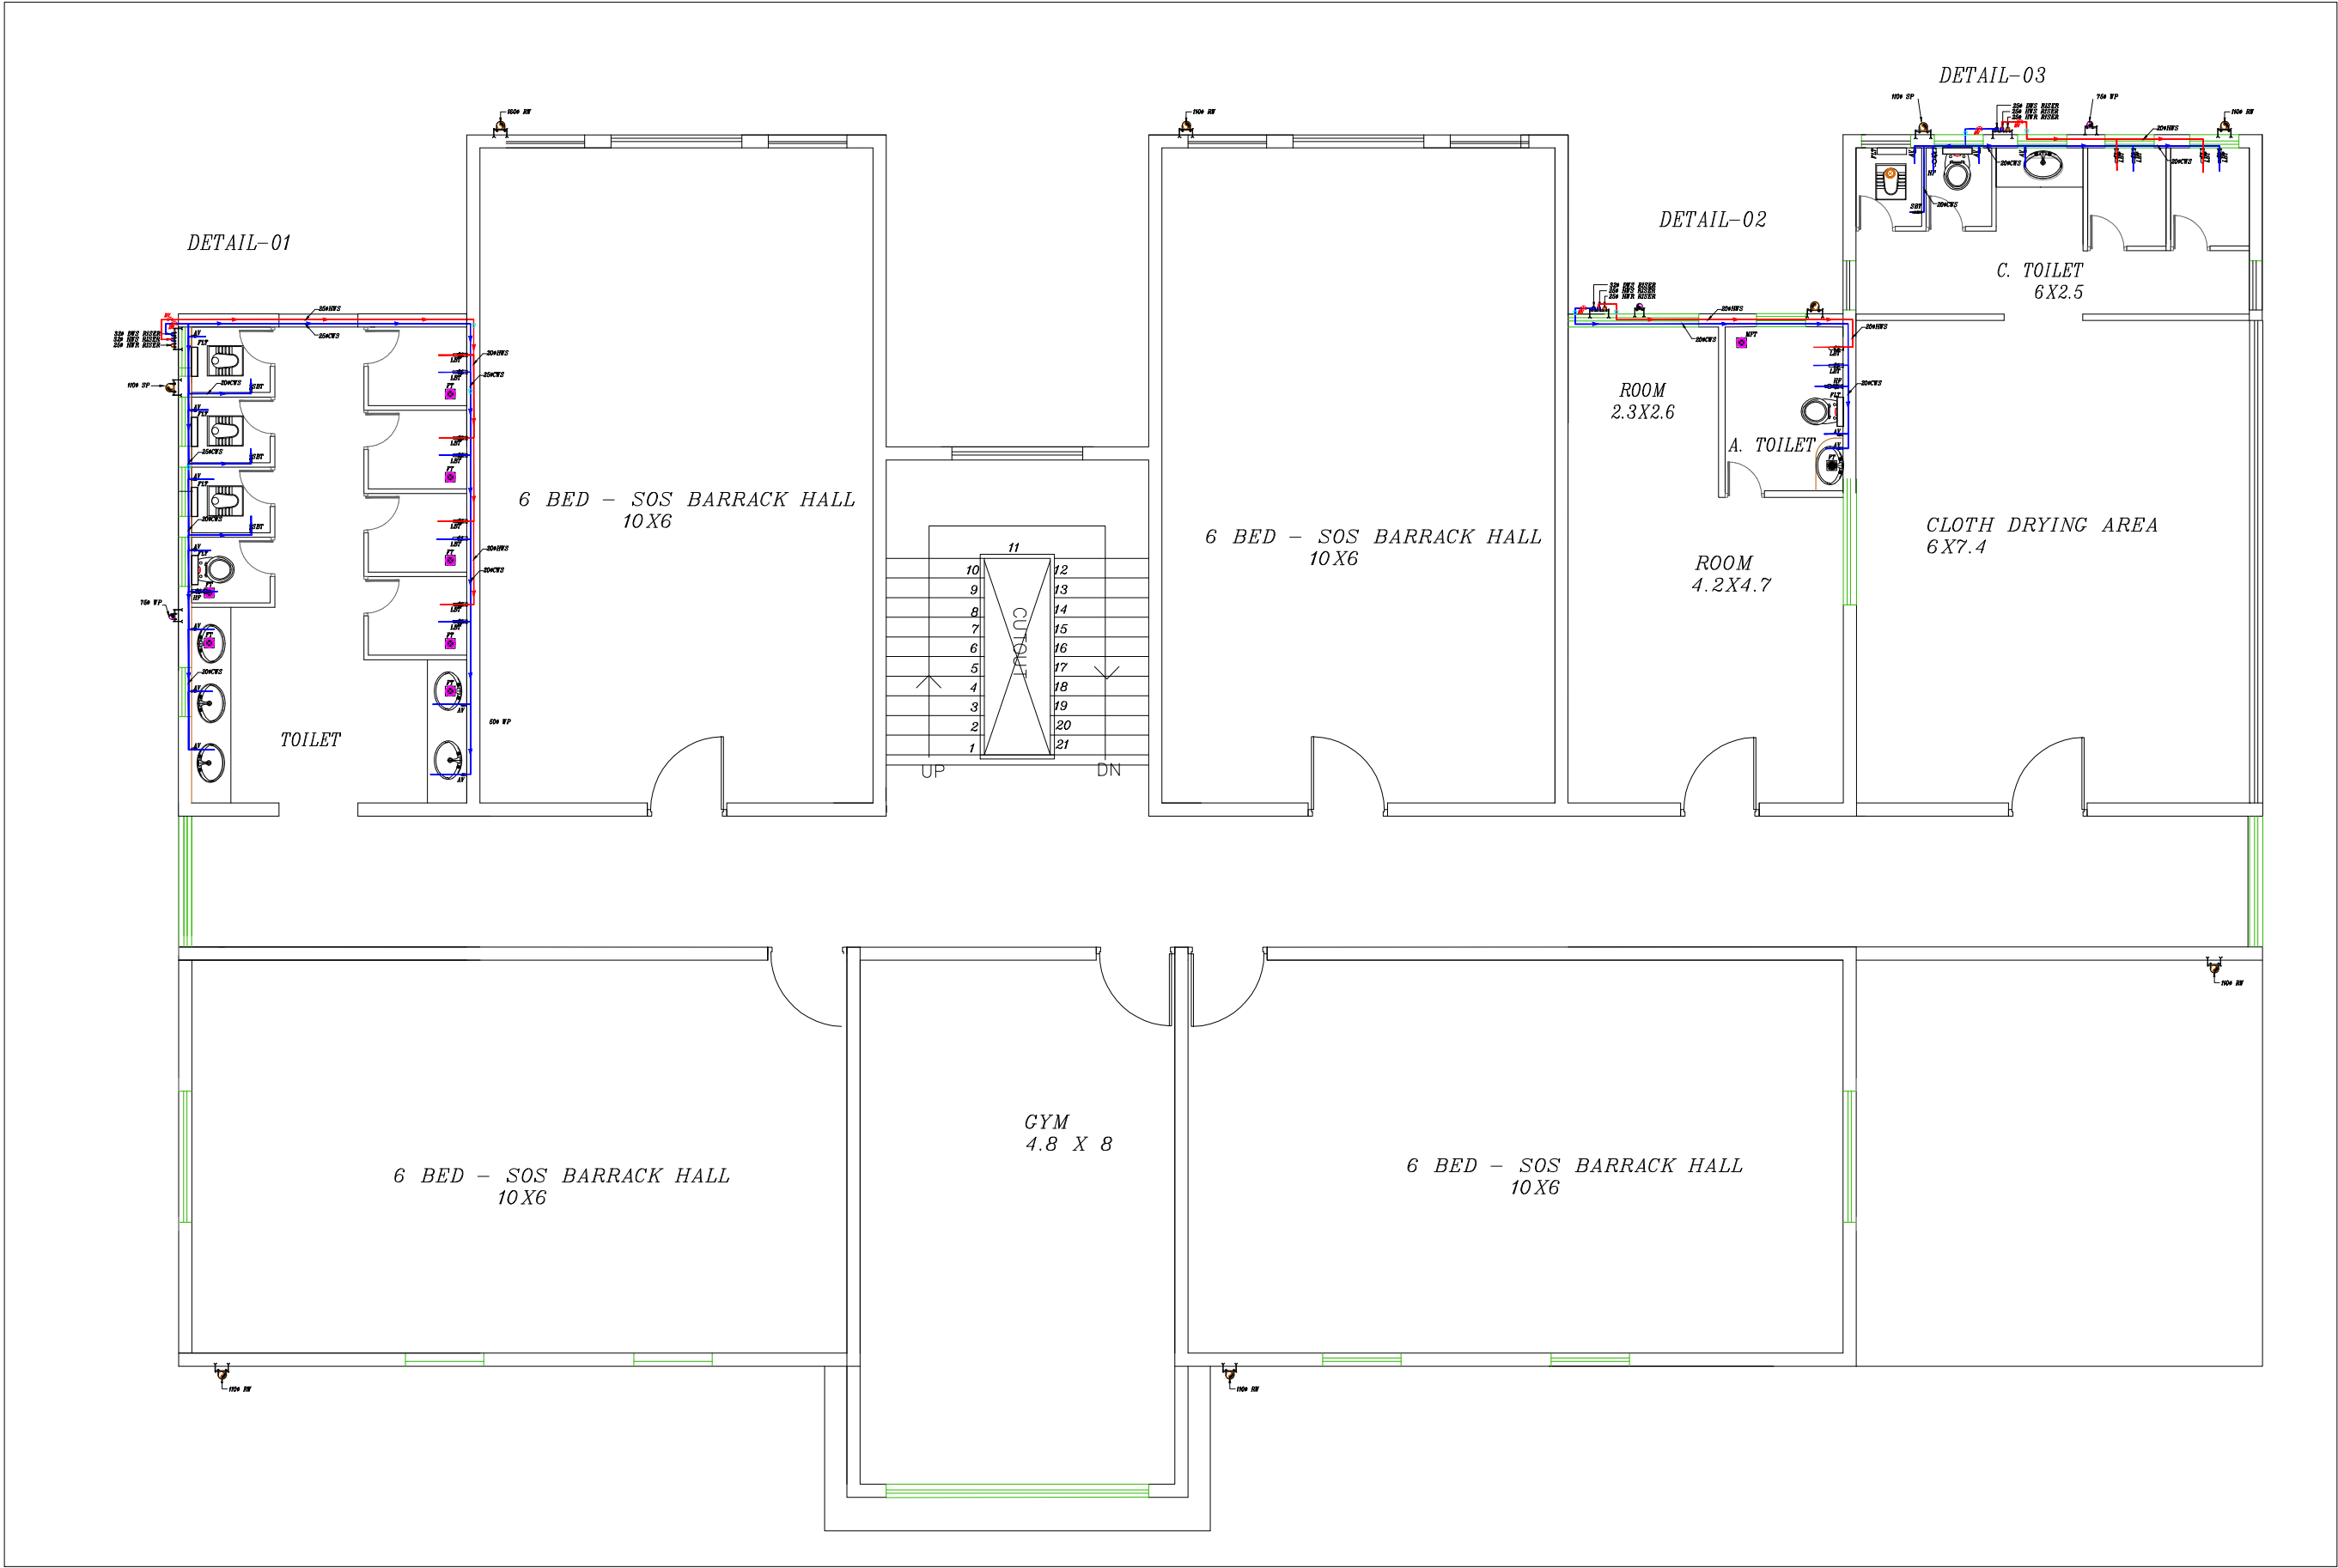

LEGEND		
01	EWC	INDIAN WATER CLOSET
02	EWC	EUROPEAN WATER CLOSET
03	HF	HEALTH FAUCET
04	WB	OVAL WASH BASIN
05	FT	FLOOR TRAP
06	MPT	MULTI INLET FLOOR TRAP
07	SSS	STAINLESS STEEL SINK
08	LBT	LONG BODY TAP
09	SBT	SHORT BODY TAP
10	AV	ANGLE VALVE
11	750 WP	750 WASTE PIPE
12	1100 SP	1100 SOIL PIPE
13	DWS RISER	DOMESTIC WATER SUPPLY RISER
14	HWS RISES	HOT WATER SUPPLY RISER
15	HWR RISER	HOT WATER RETURN RISER
16	HWS	HOT WATER SUPPLY
17	BY	BALL VALVE
18		PIPE REDUCER

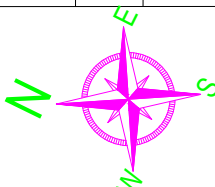TENDER DRAWINGS			
PHE			
DOMESTIC COLD AND HOT WATER SUPPLY			
REV	DESCRIPTION	CHKD	DATE
DRAWING NO : ARCH001/PHE-04			
FILE NAME :			
Drawn : AV			
Checked : AMOL		REV.NO:	R0
Approved : Ar.Anil.K.		SCALE :	NTS
DATE : 01-1-2025		JOB.NO:	
TITLE : PHE DRAWING THIRD FLOOR PLAN			
PROJECT TITLE: PROPOSED CONSTRUCTION OF BNPM - BARRACK			
ARCHITECTS : KULKARNI ASSOCIATES Consulting Architects, Engineers,Project Management Consultants Interior Designers & Regd. valuers Surya Prema Building,next to Adiga's Restaurant,Kanakapura Road No-203,2nd floor,Above Canara bank Raghuvanahalli Branch Raghuvanahalli Village,Uttarahalli hobli Bangalore-560062 Email Id : kulkarni.associates@yahoo.com			

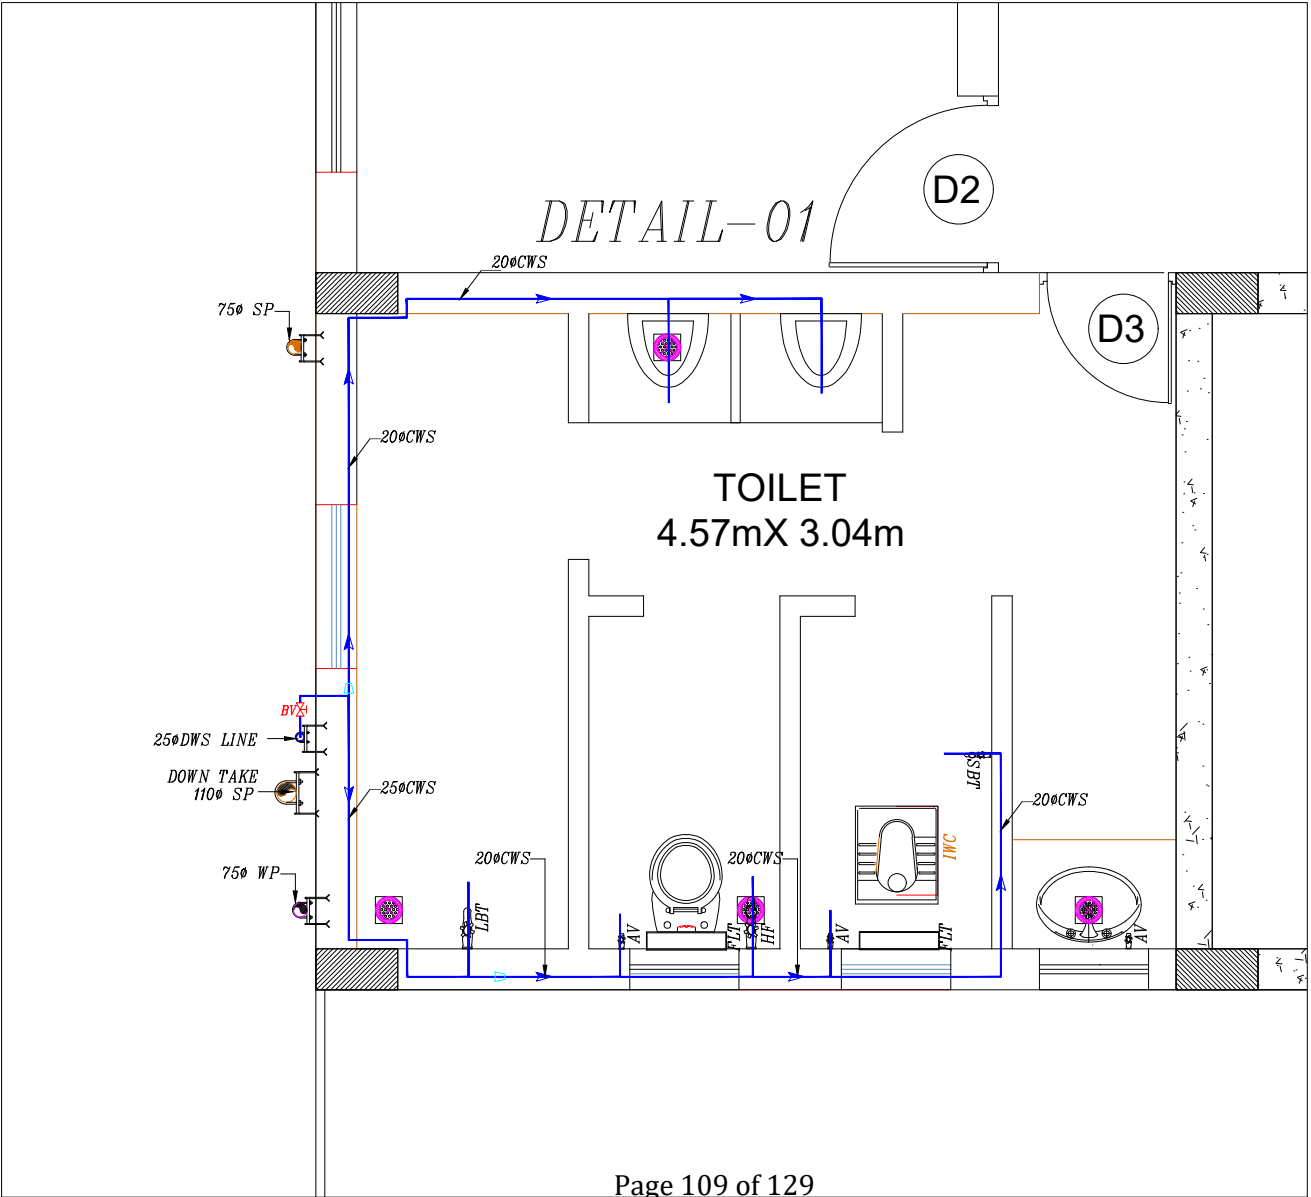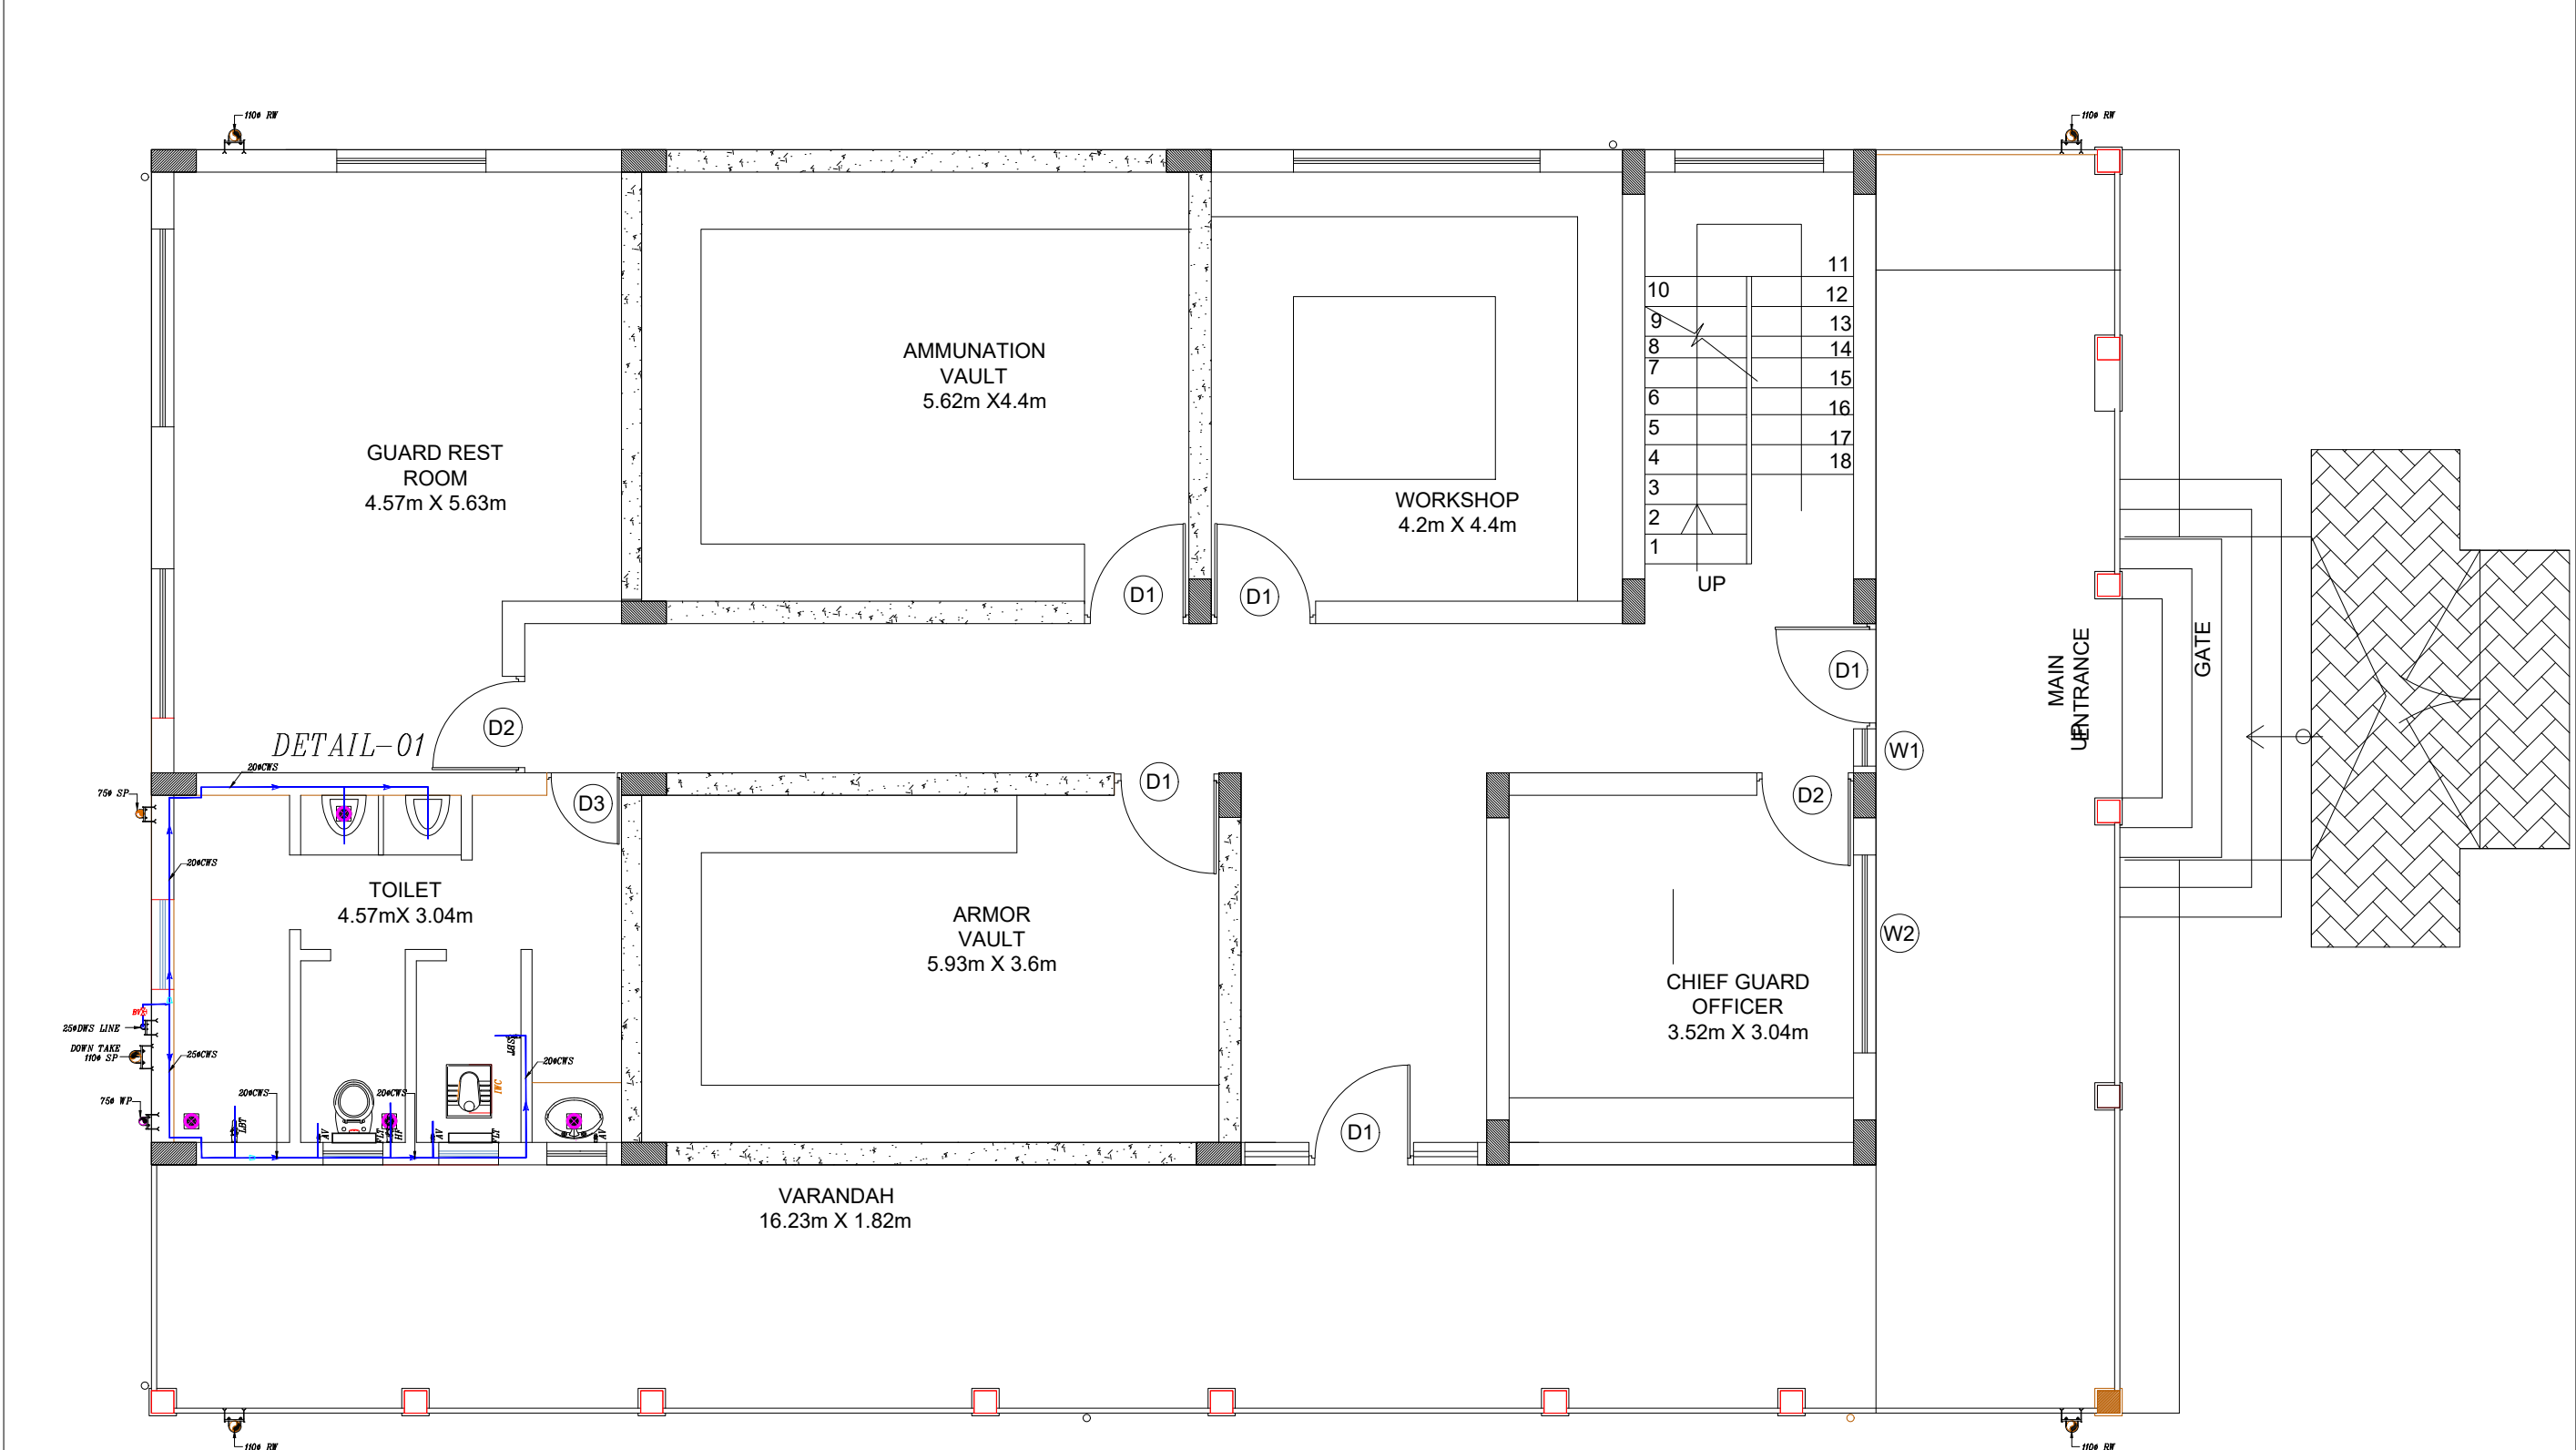

LEGEND		
01	EW	INDIAN WATER CLOSET
02	EW	EUROPEAN WATER CLOSET
03	HF	HEALTH FAUCET
04	WB	OVAL WASH BASIN
05	FT	FLOOR TRAP
06	MFT	MULTI INLET FLOOR TRAP
07	SSS	STAINLESS STEEL SINK
08	LBT	LONG BODY TAP
09	SBT	SHORT BODY TAP
10	AV	ANGLE VALVE
11	750 WP	750 WASTE PIPE
12	1100 SP	1100 SOIL PIPE
13	DWS RISER	DOMESTIC WATER SUPPLY RISER
14	HWS RISES	HOT WATER SUPPLY RISER
15	HWR RISER	HOT WATER RETURN RISER
16	HWS	HOT WATER SUPPLY
17	BV	BALL VALVE
18		PIPE REDUCER

TENDER DRAWINGS

PHE

DOMESTIC WATER SUPPLY LINE



REV	DESCRIPTION	CHKD	DATE
	DRAWING NO : ARCH001/PHE-01		
	FILE NAME :		
	Drawn : AV		
	Checked : AMOL	REV.NO: R0	
	Approved : Ar.Anil.K.	SCALE : NTS	
	DATE : 01-1-2025	JOB.NO:	

TITLE : PHE DRAWING
GROUND FLOOR PLAN



PROJECT TITLE:


PROPOSED CONSTRUCTION OF
BNPM - ARMOUR HOUSE


ARCHITECTS :
KULKARNI ASSOCIATES
Consulting Architects, Engineers, Project Management Consultants
Interior Designers & Regd. valuers
Surya Prema Building, next to Adiga's Restaurant, Kanakapura Road
No-203, 2nd floor, Above Canara bank Raghuvanahalli Branch
Raghuvanahalli Village, Uttarahalli hobli Bangalore-560062
Email Id : kulkarni.associates@yahoo.com

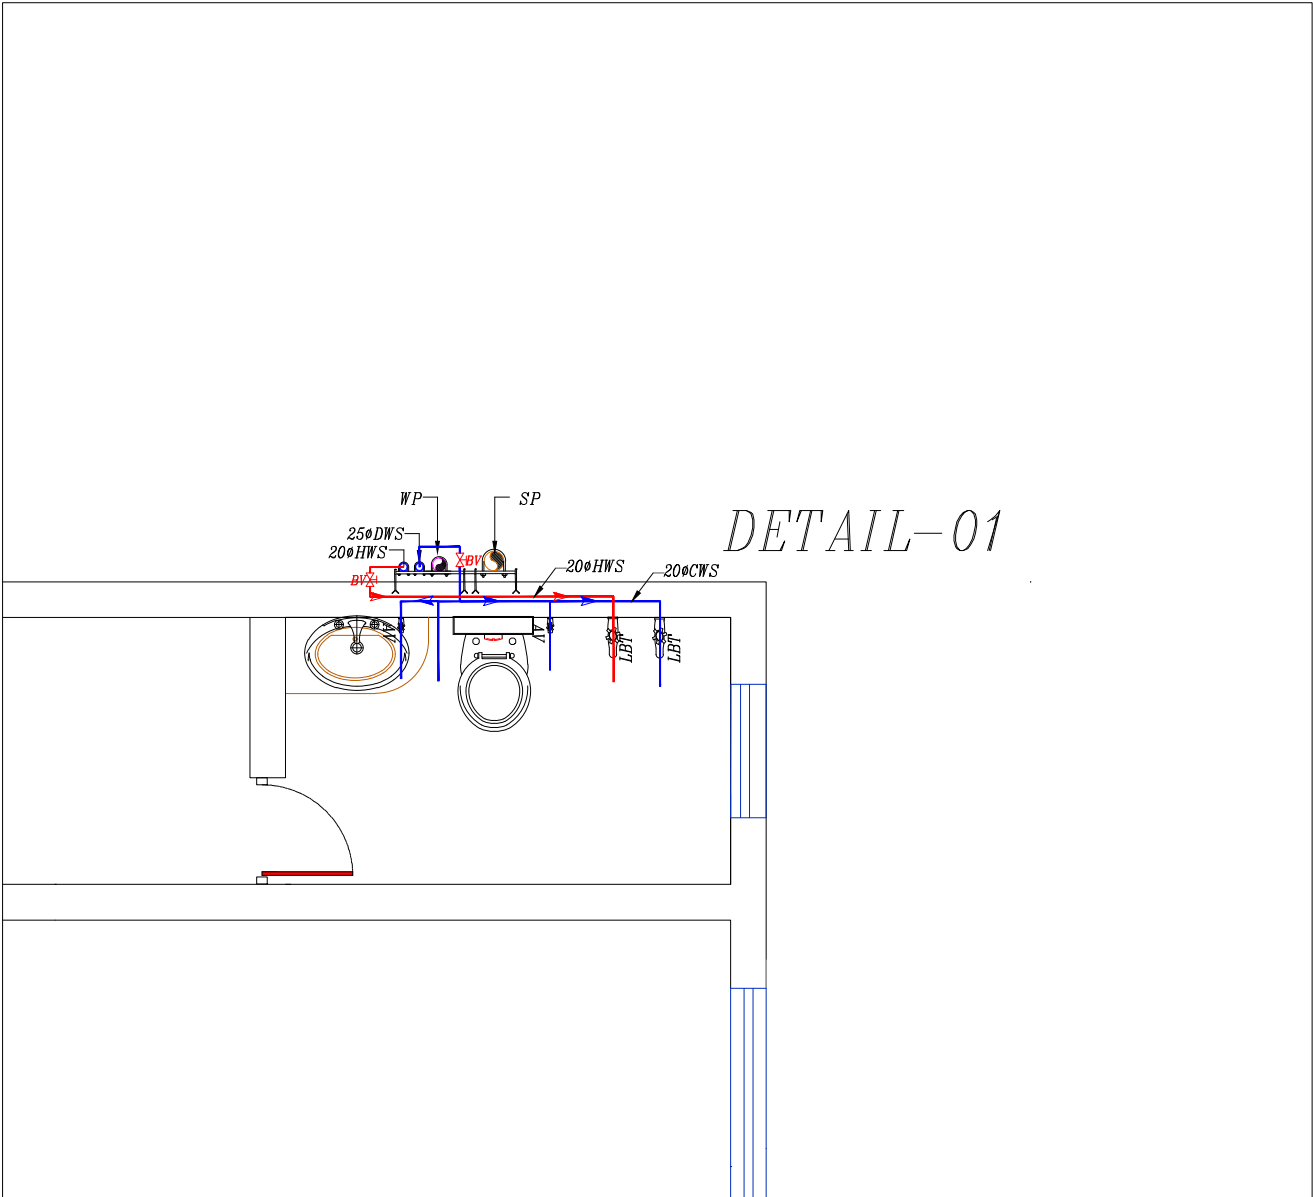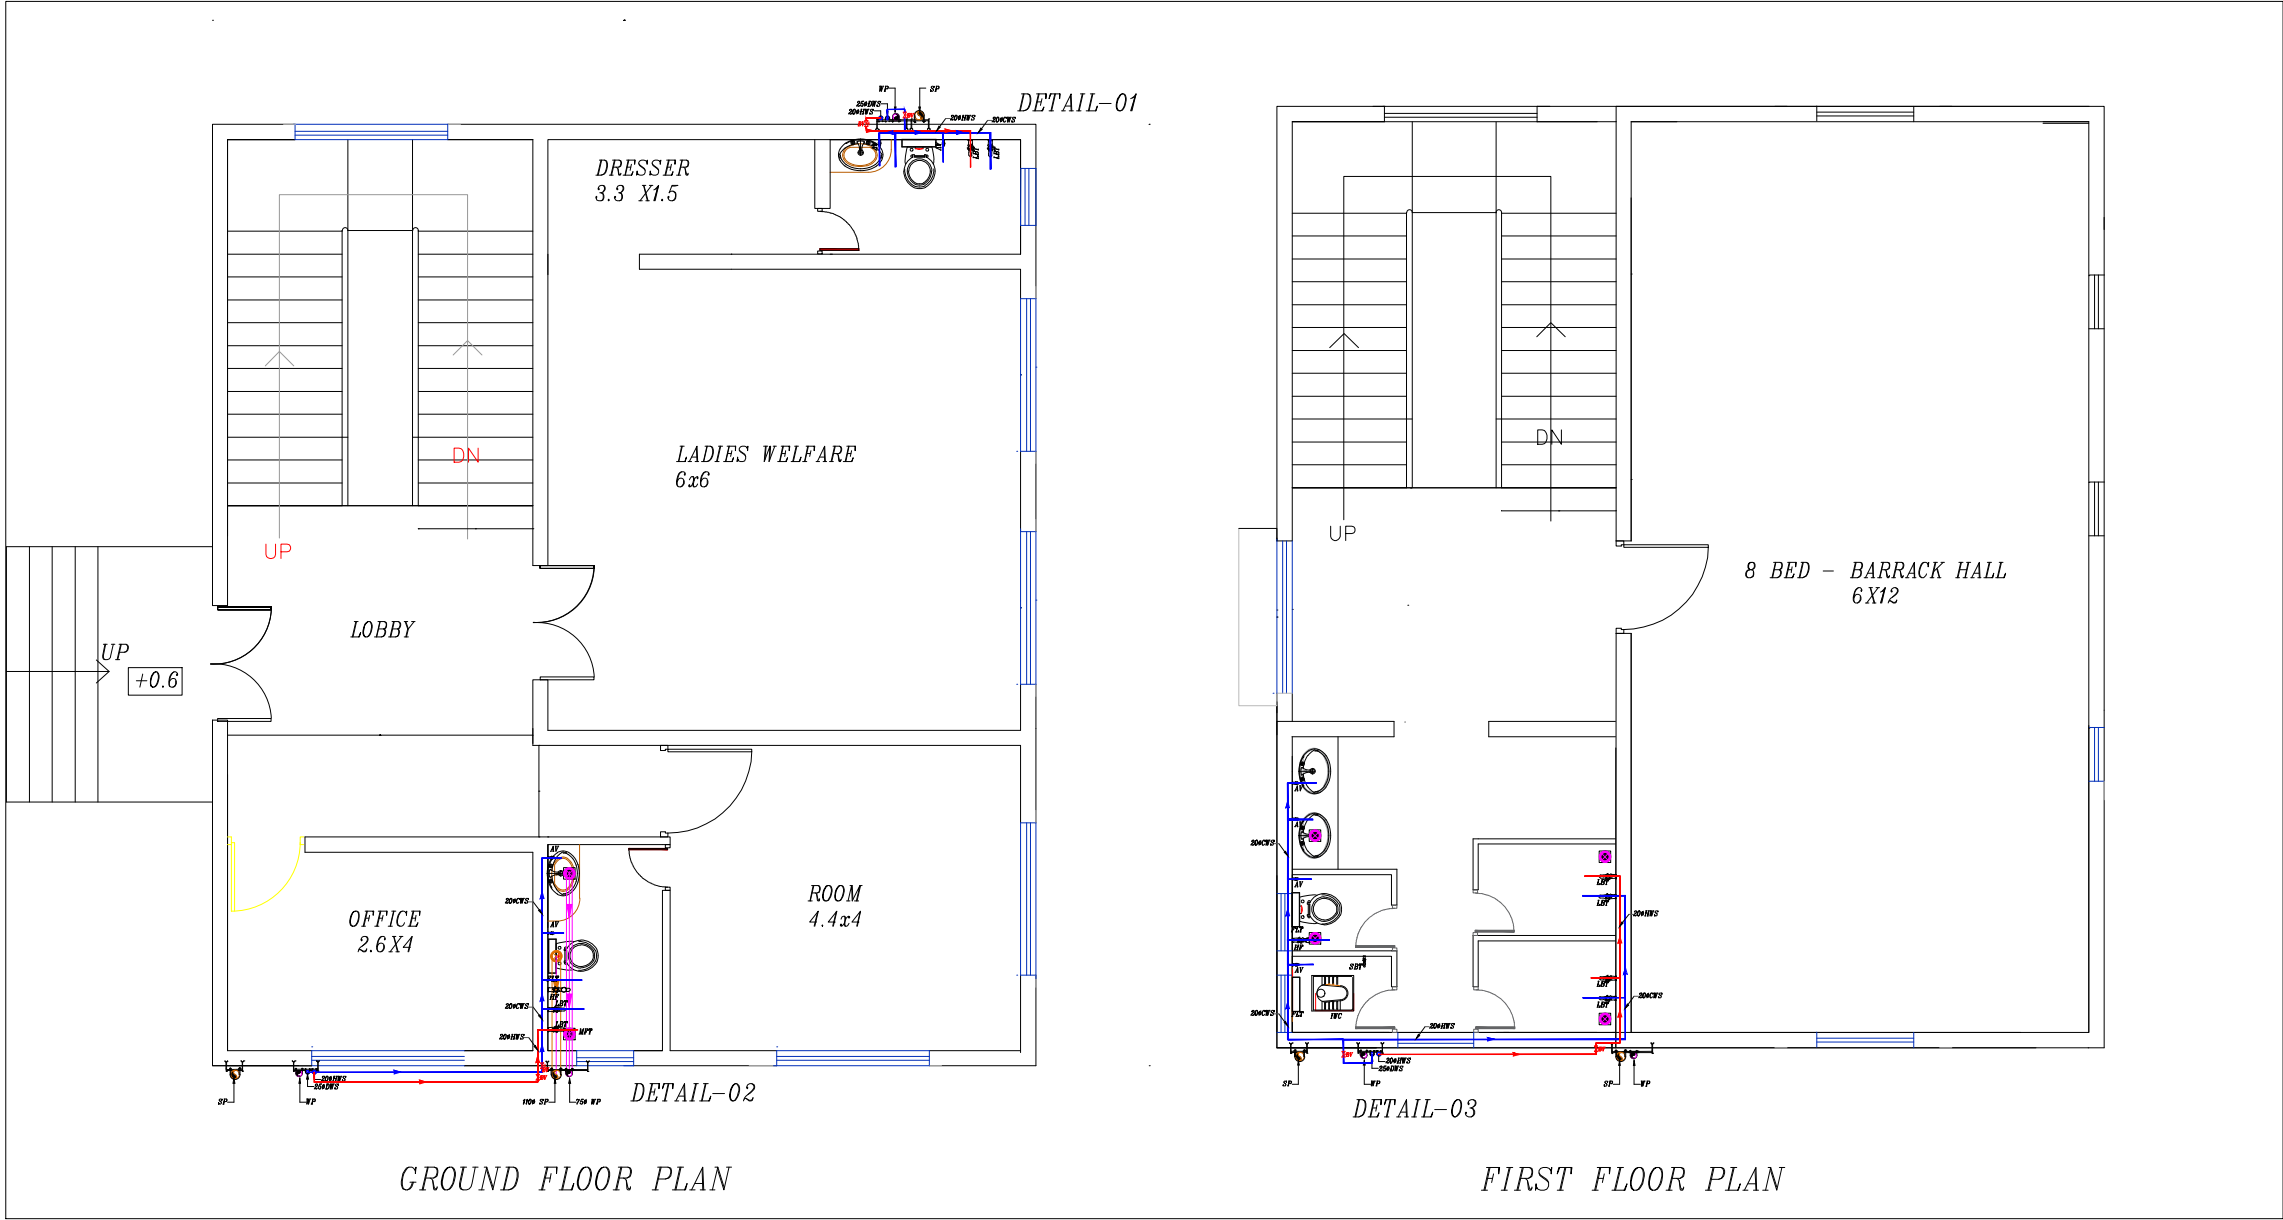

LEGEND			
01	EWC		INDIAN WATER CLOSET
02	EWC		EUROPEAN WATER CLOSET
03	HF		HEALTH FAUCET
04	WB		OVAL WASH BASIN
05	FT		FLOOR TRAP
06	MFT		MULTI INLET FLOOR TRAP
07	SSS		STAINLESS STEEL SINK
08	LBT		LONG BODY TAP
09	SBT		SHORT BODY TAP
10	AV		ANGLE VALVE
11	75ø WP		75ø WASTE PIPE
12	110ø SP		110ø SOIL PIPE
13	DWS RISER		DOMESTIC WATER SUPPLY RISER
14	HWS RISES		HOT WATER SUPPLY RISER
15	HWR RISER		HOT WATER RETURN RISER
16	HWS		HOT WATER SUPPLY
17	BY		BALL VALVE
18			PIPE REDUCER

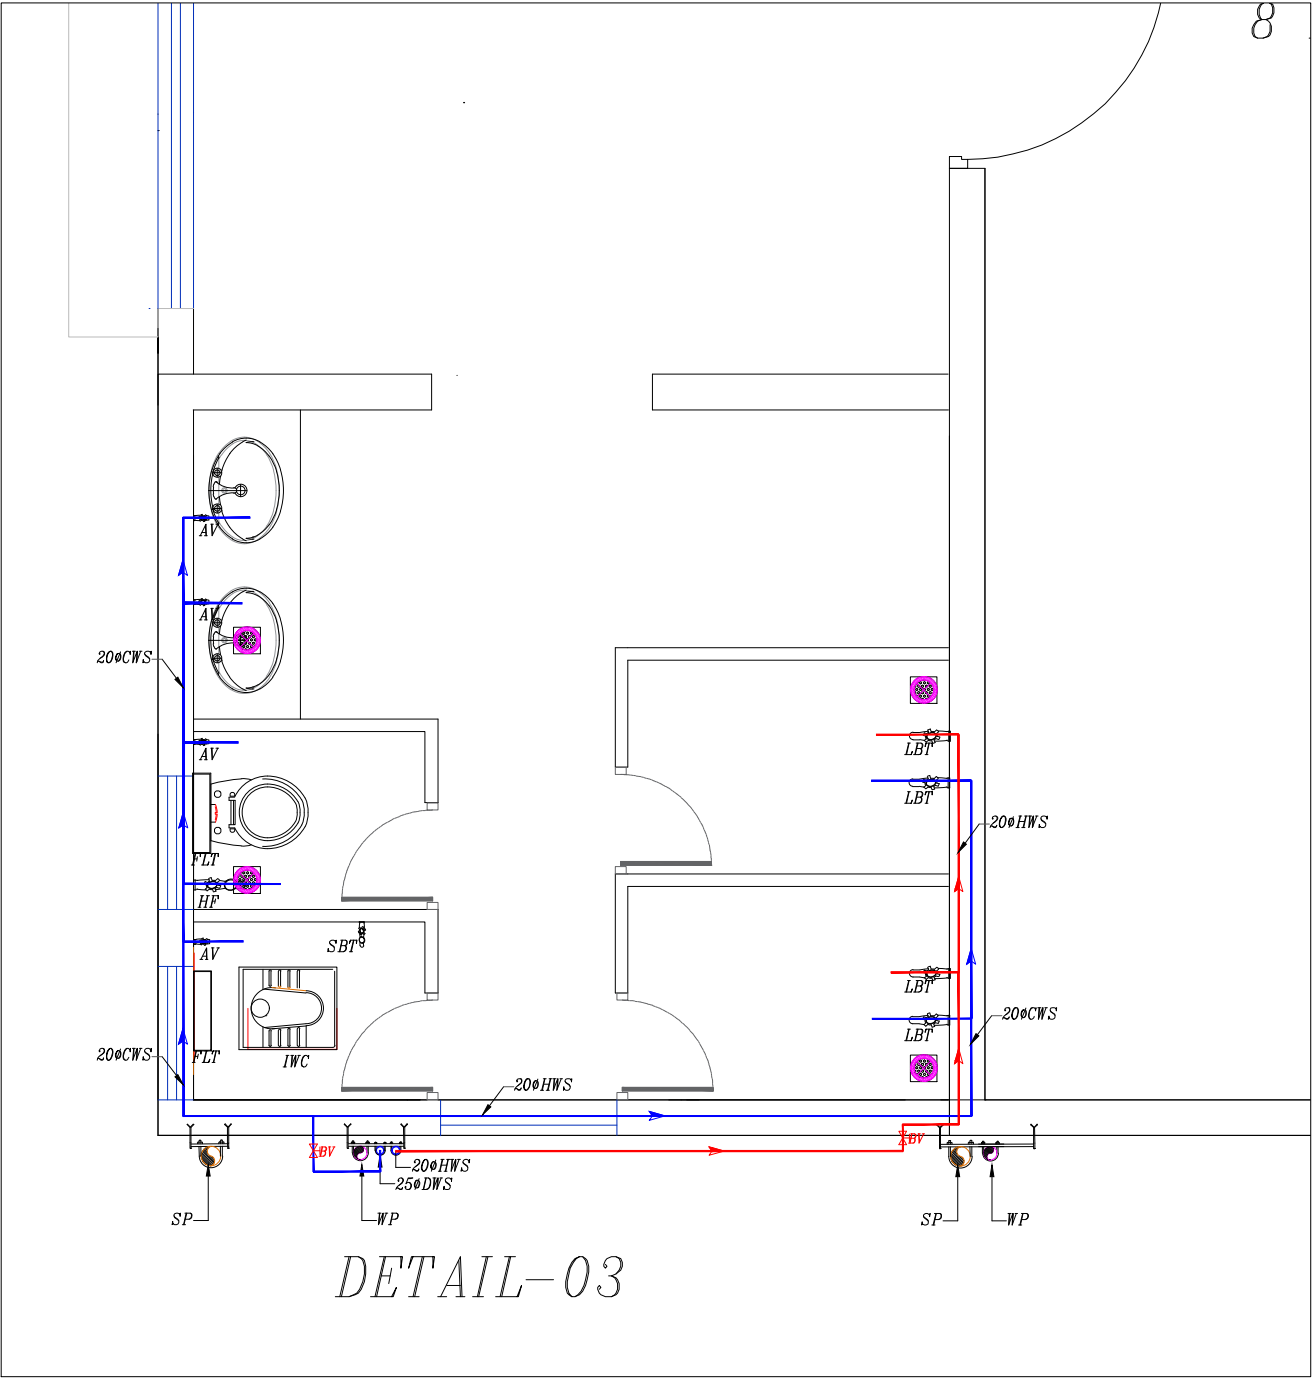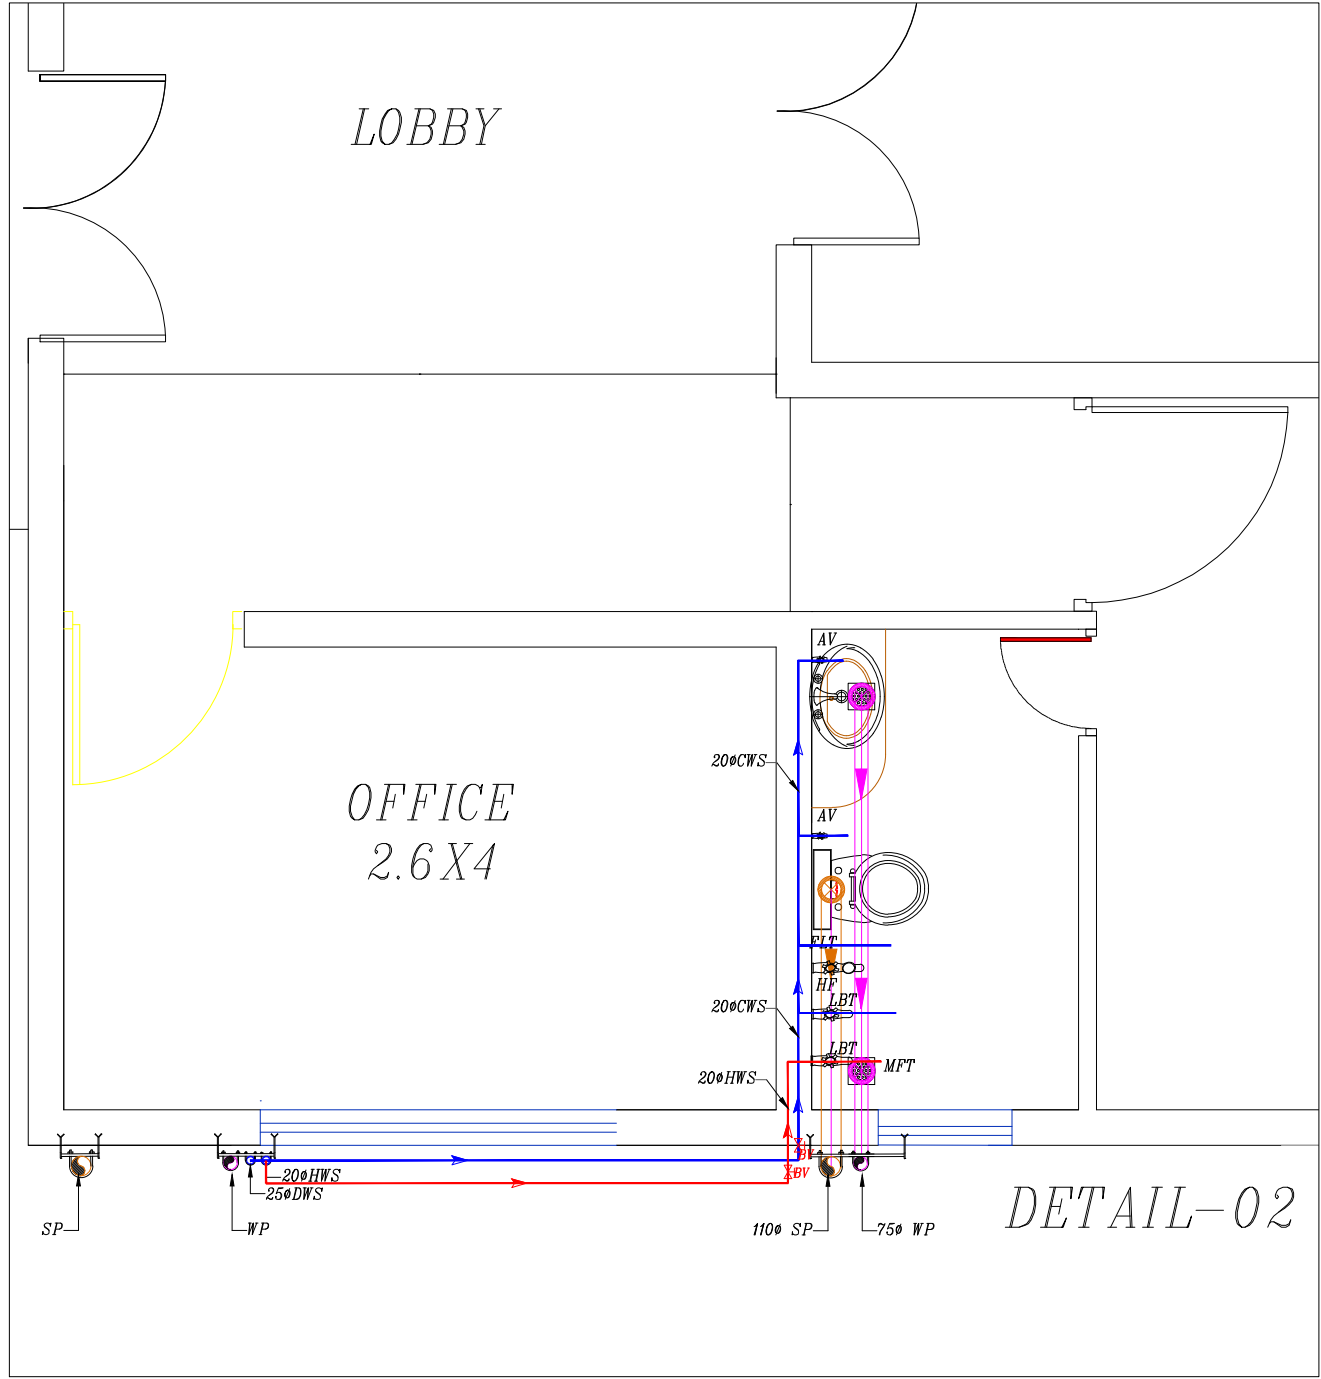

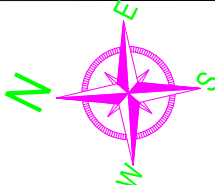TENDER DRAWINGS			
PHE			
DOMESTIC WATER SUPPLY LINE			
REV	DESCRIPTION	CHKD	DATE
DRAWING NO : ARCH001/PHE-02			
FILE NAME :			
Drawn : AV			
Checked : AMOL			
Approved : Ar.Anil.K.		REV.NO:	R0
DATE : 01-1-2025		SCALE :	NTS
TITLE : PHE DRAWING GROUND FLOOR PLAN		JOB.NO:	
PROJECT TITLE: PROPOSED CONSTRUCTION OF BNPM - LADIES- BARRACK			
ARCHITECTS : KULKARNI ASSOCIATES Consulting Architects, Engineers,Project Management Consultants Interior Designers & Regd. valuers Surya Prema Building,next to Adiga's Restaurant,Kanakapura Road No-203,2nd floor,Above Canara bank Raghuvanahalli Branch Raghuvanahalli Village,Uttarahalli hobli Bangalore-560062 Email Id : kulkarni.associates@yahoo.com			

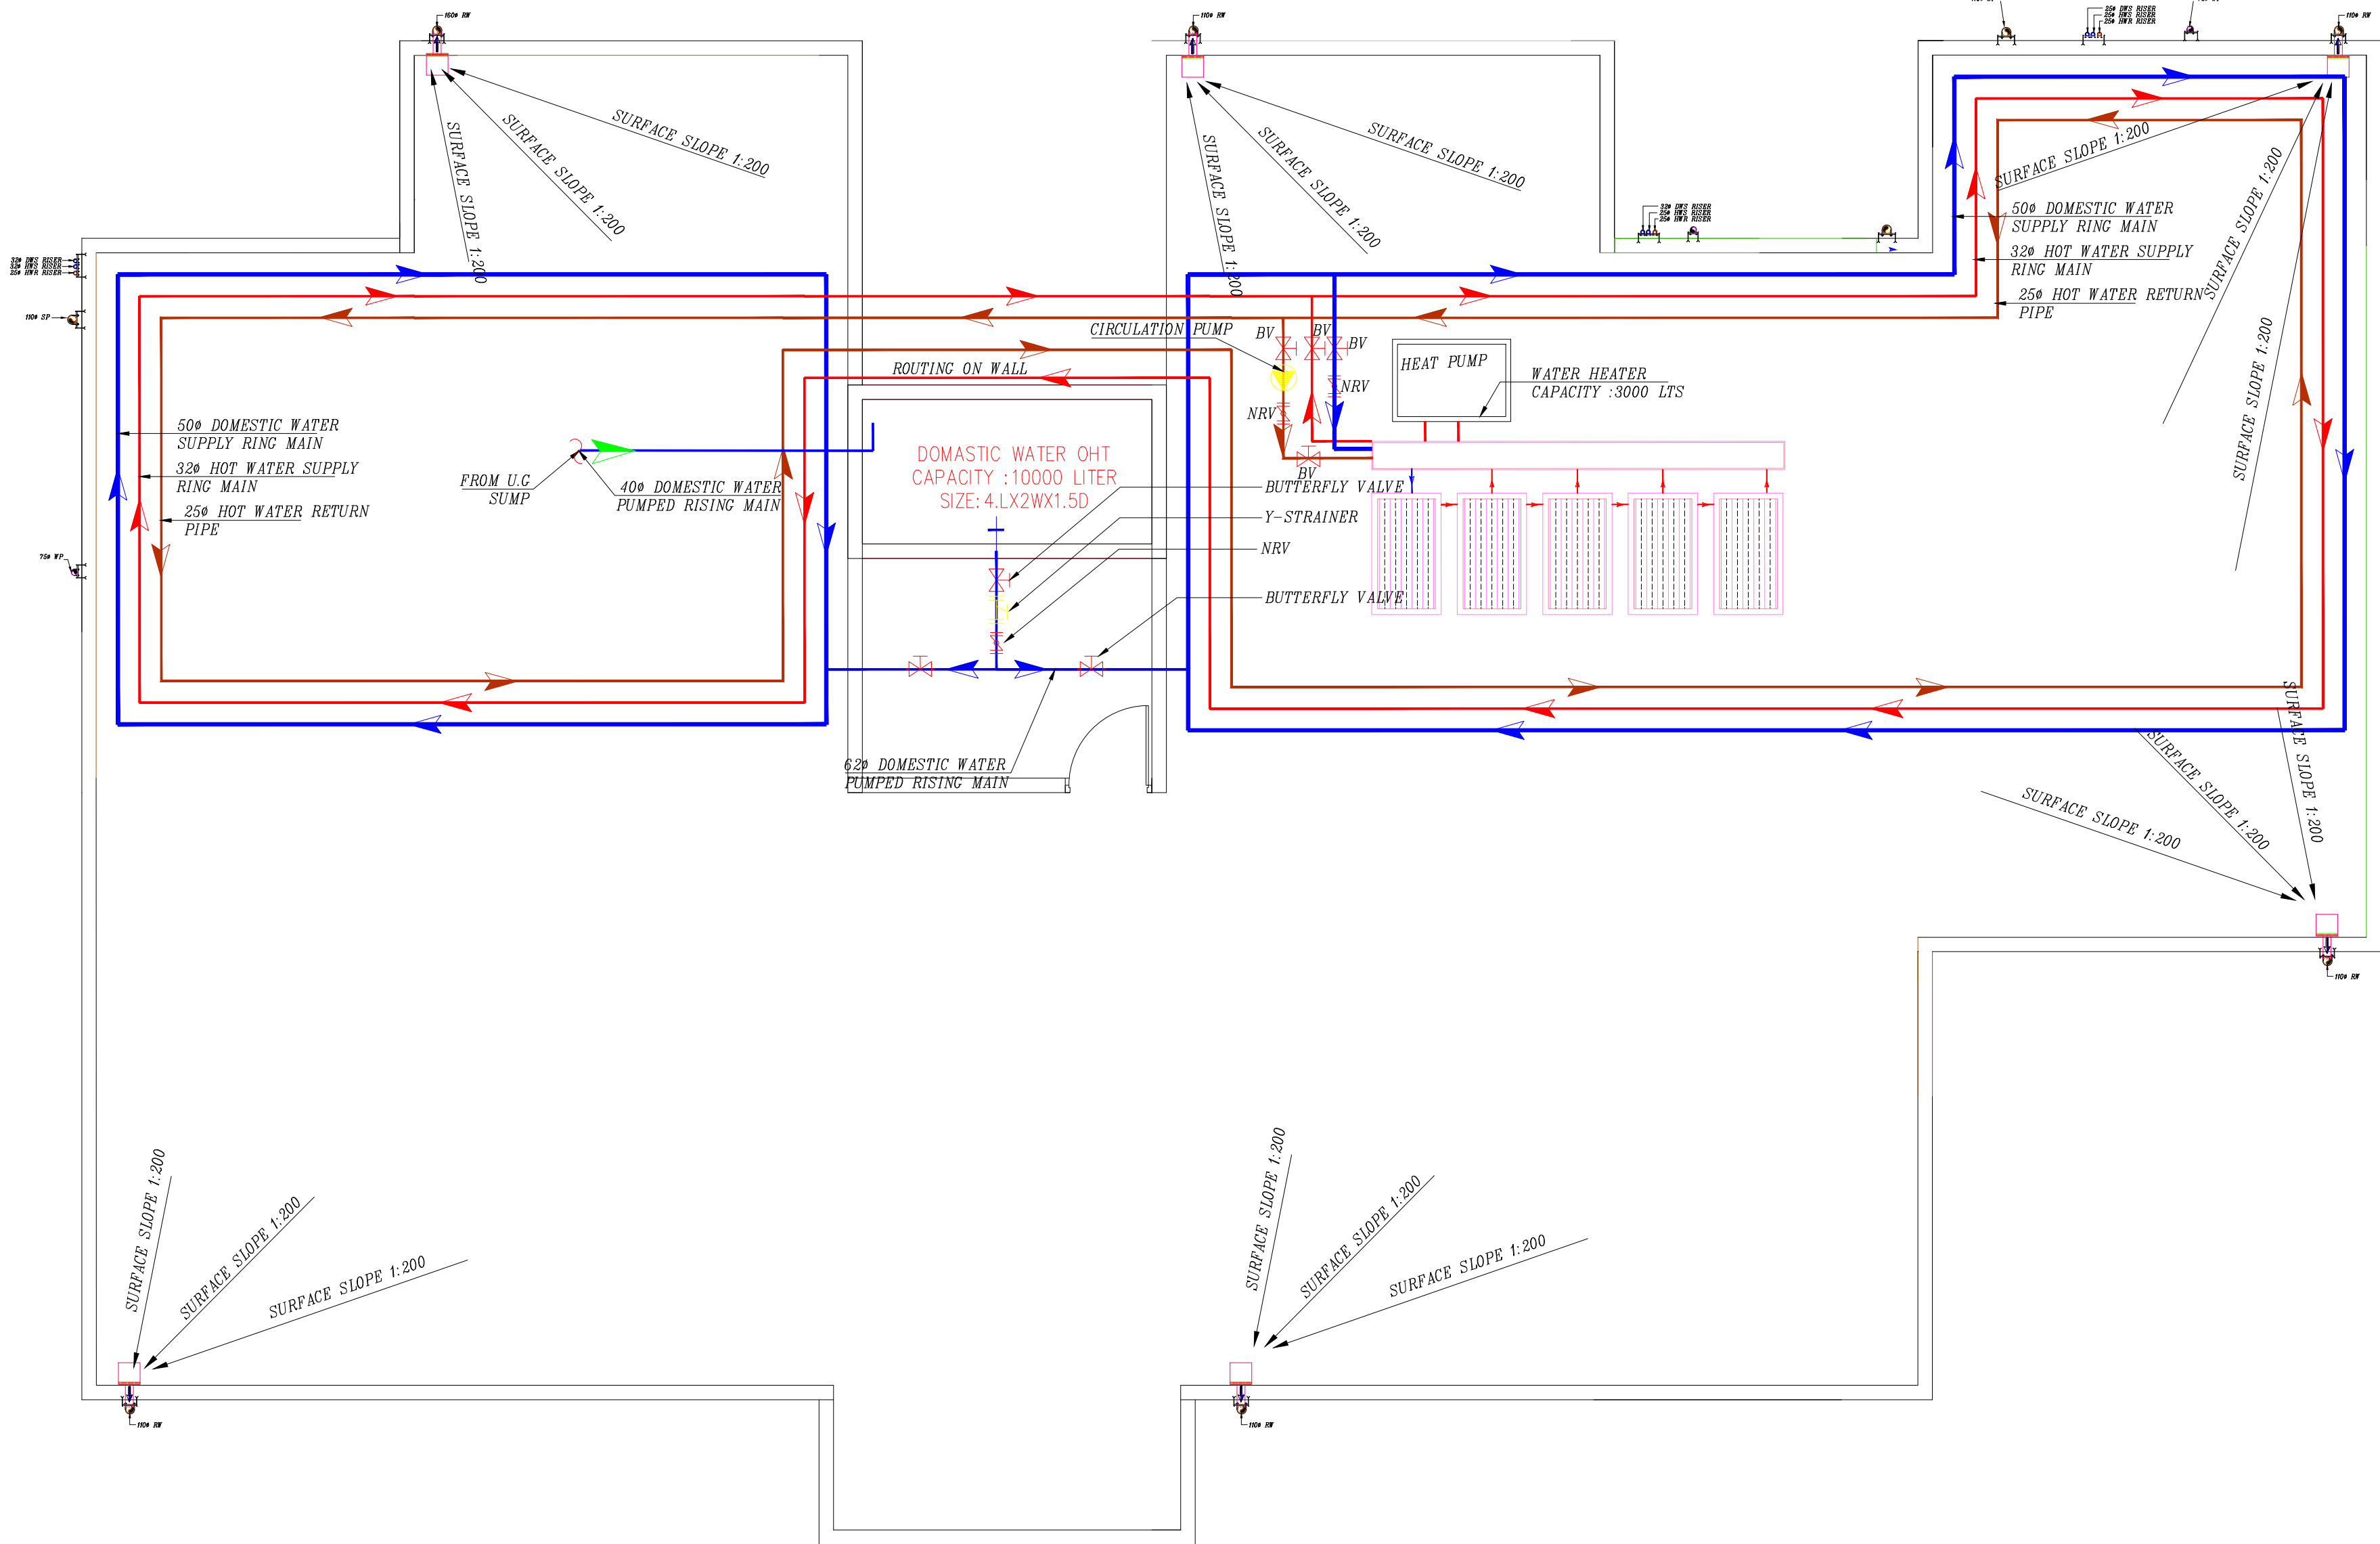

THIRD FLOOR PLAN

LEGEND		
01	EW	INDIAN WATER CLOSET
02	EW	EUROPEAN WATER CLOSET
03	HF	HEALTH FAUCET
04	WB	OVAL WASH BASIN
05	FT	FLOOR TRAP
06	MPT	MULTI INLET FLOOR TRAP
07	SSS	STAINLESS STEEL SINK
08	LBT	LONG BODY TAP
09	SBT	SHORT BODY TAP
10	AV	ANGLE VALVE
11	75 WP	75 WASTE PIPE
12	110 SP	110 SOIL PIPE
13	DWS RISER	DOMESTIC WATER SUPPLY RISER
14	HWS RISES	HOT WATER SUPPLY RISER
15	HWR RISER	HOT WATER RETURN RISER
16	HWS	HOT WATER SUPPLY
17	BV	BALL VALVE
18		PIPE REDUCER

TENDER DRAWINGS

PHE

OHT AND RING MAIN

REV	DESCRIPTION	CHKD	DATE
DRAWING NO : ARCH001/PHE-05			
FILE NAME :			
Drawn : AV			
Checked : AMOL		REV.NO: R0	
Approved : Ar.Anil.K.		SCALE : NTS	
DATE : 01-1-2025		JOB.NO:	

TITLE : PHE DRAWING

TERRACE FLOOR PLAN



PROJECT TITLE:


PROPOSED CONSTRUCTION OF BNPM - BARRACK

ARCHITECTS :





KULKARNI ASSOCIATES

Consulting Architects, Engineers,Project Management Consultants
Interior Designers & Regd. valuers
Surya Prema Building,next to Adiga's Restaurant,Kanakapura Road
No-203,2nd floor,Above Canara bank Raghuvanahalli Branch
Raghuvanahalli Village,Uttarahalli hobli Bangalore-560062
Email Id : kulkarni.associates@yahoo.com

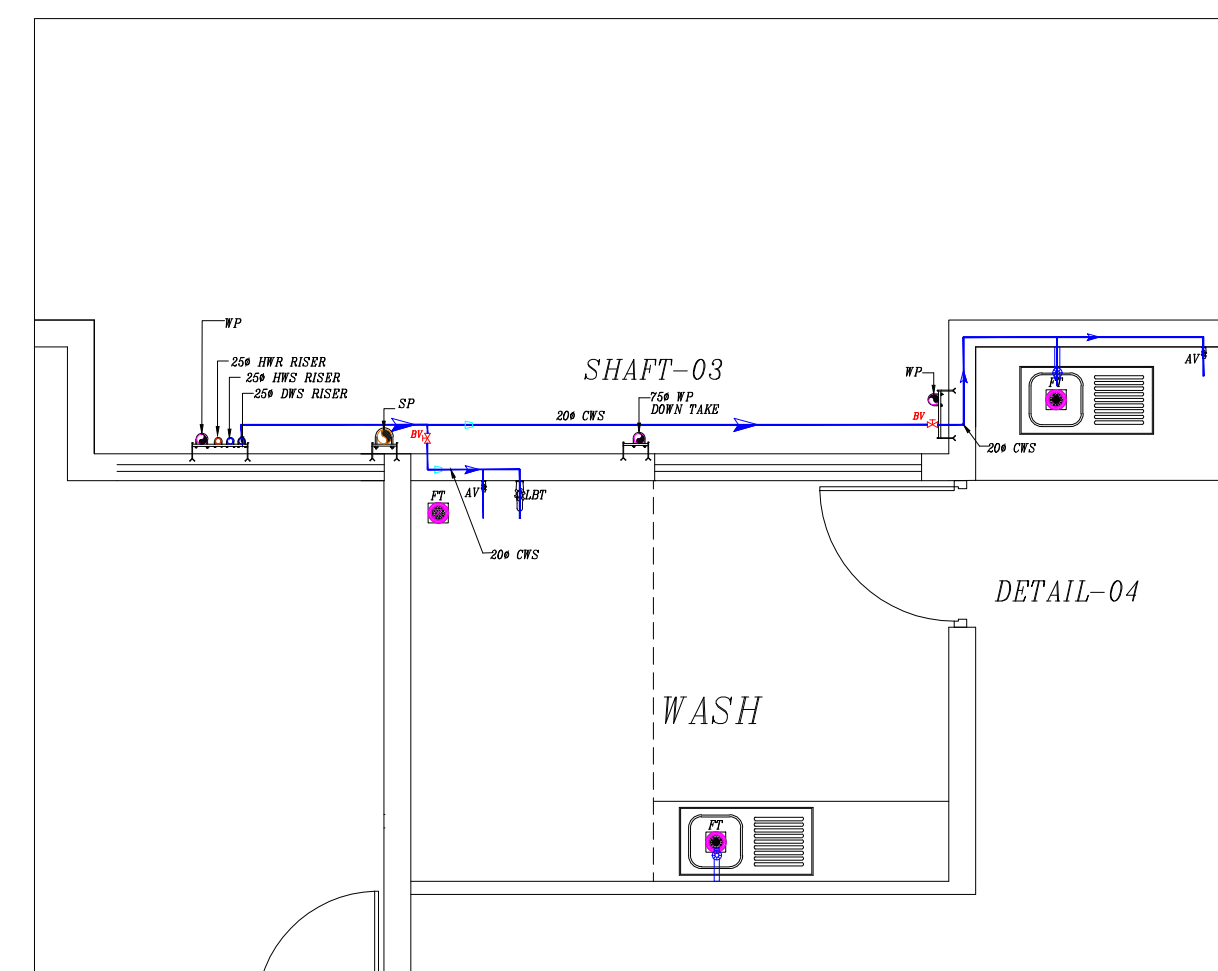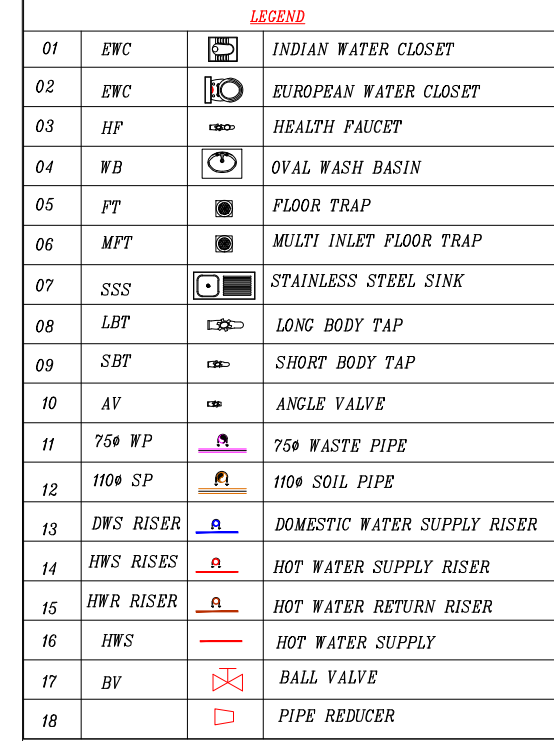



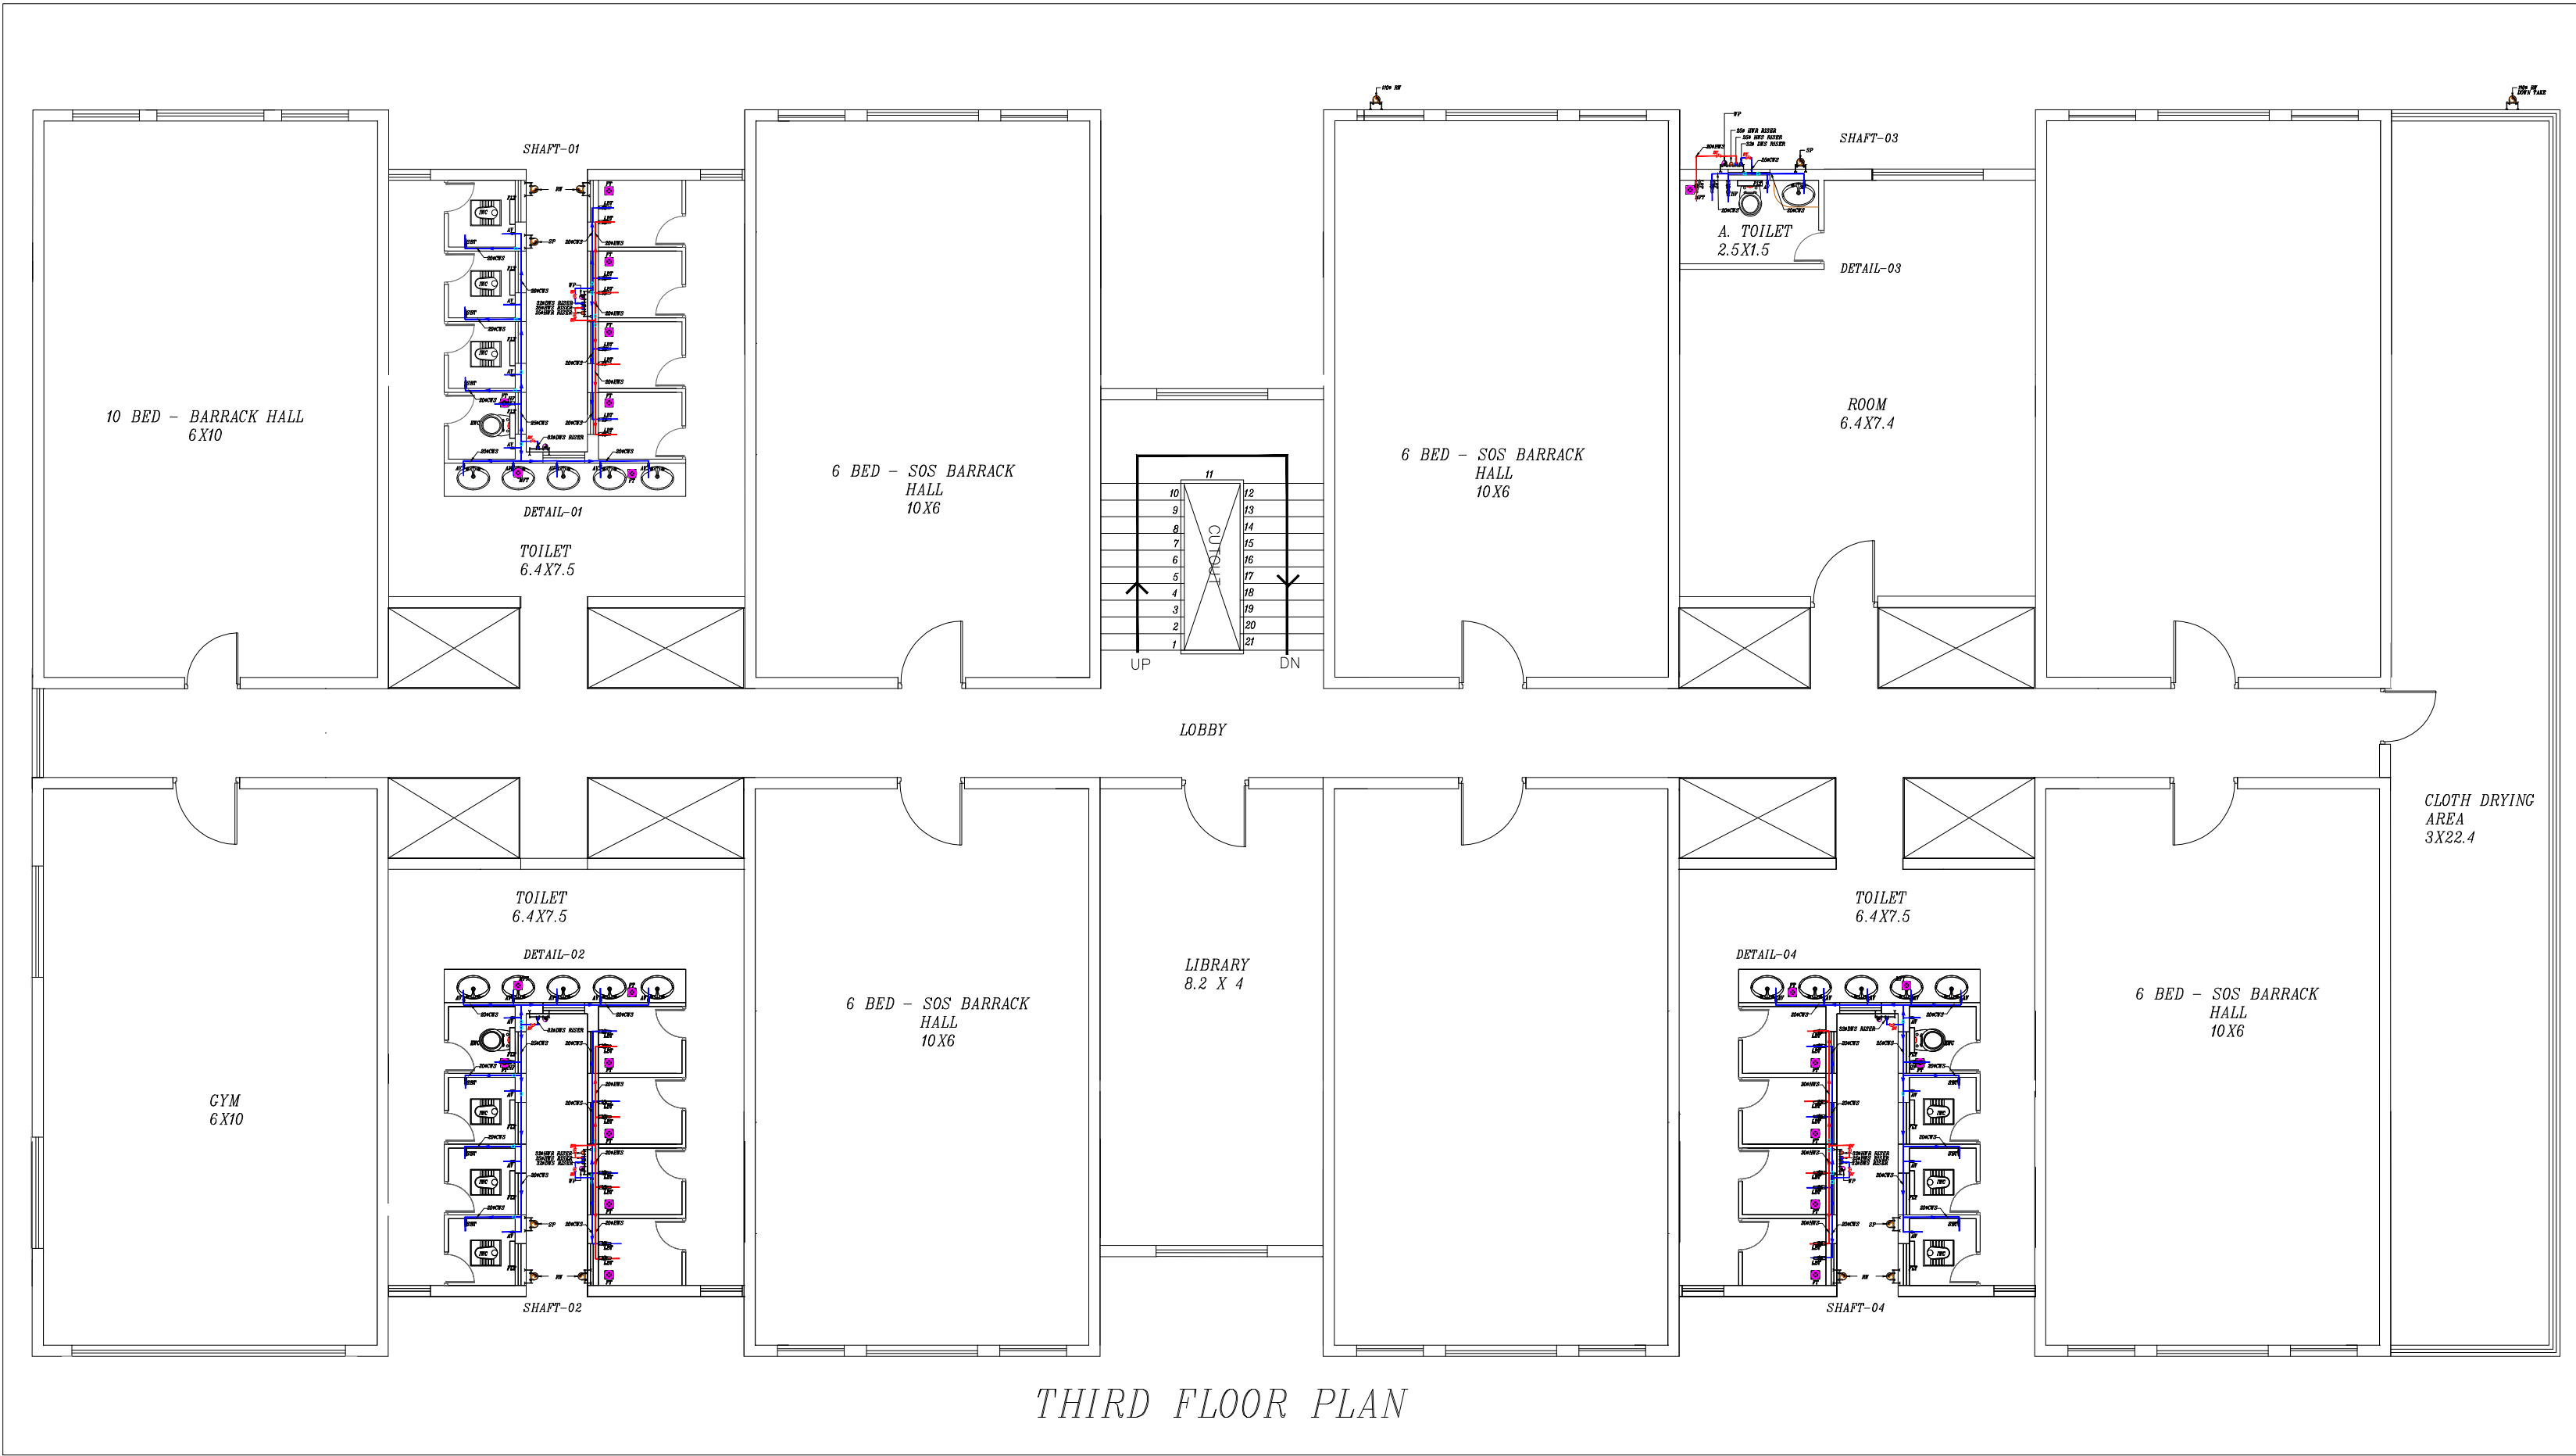


THIRD FLOOR PLAN

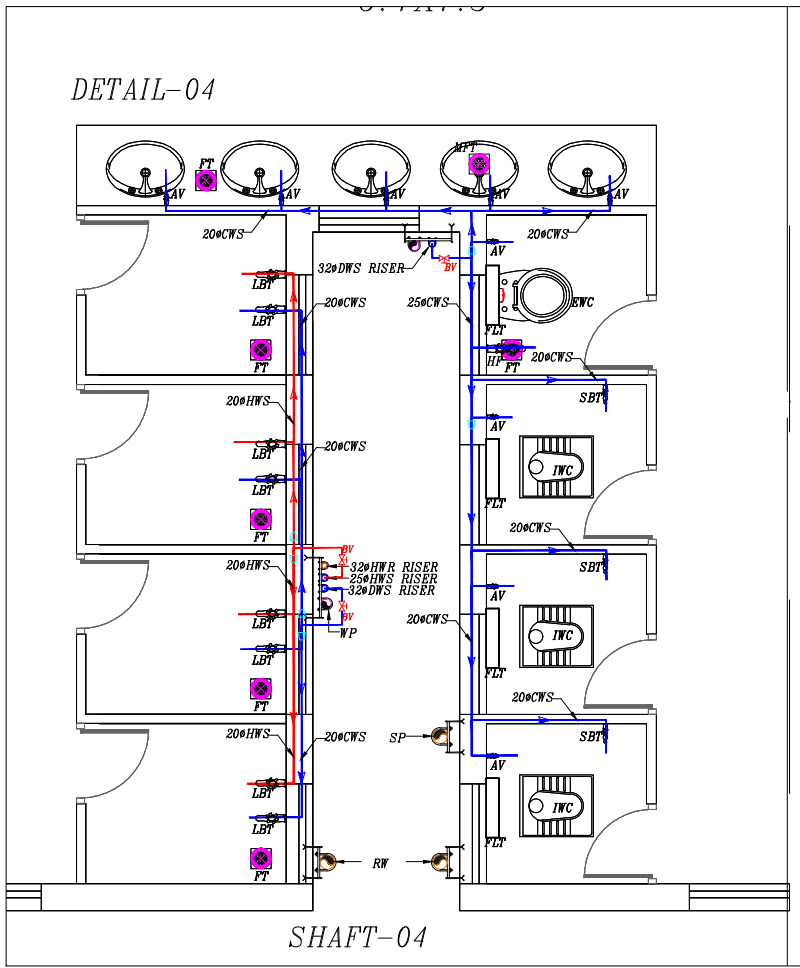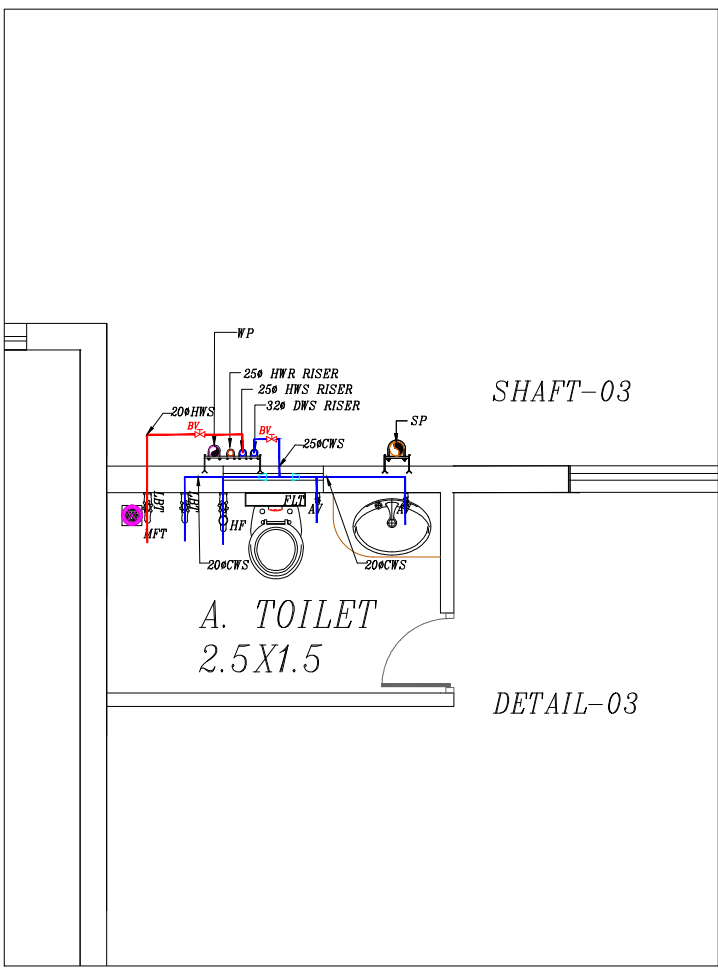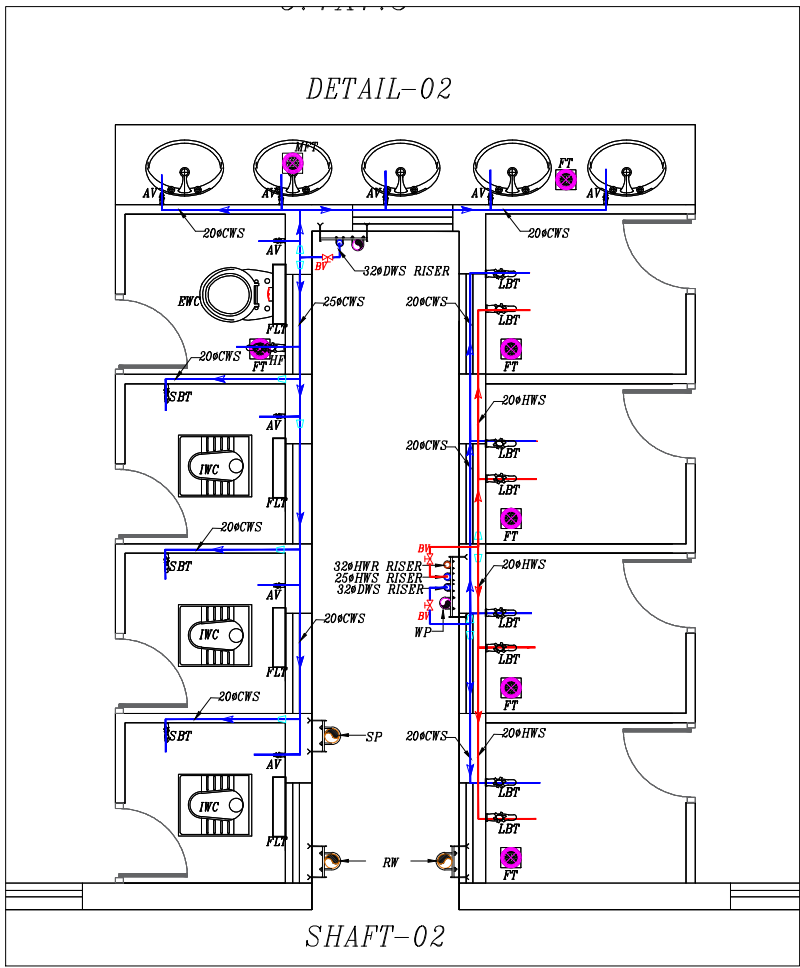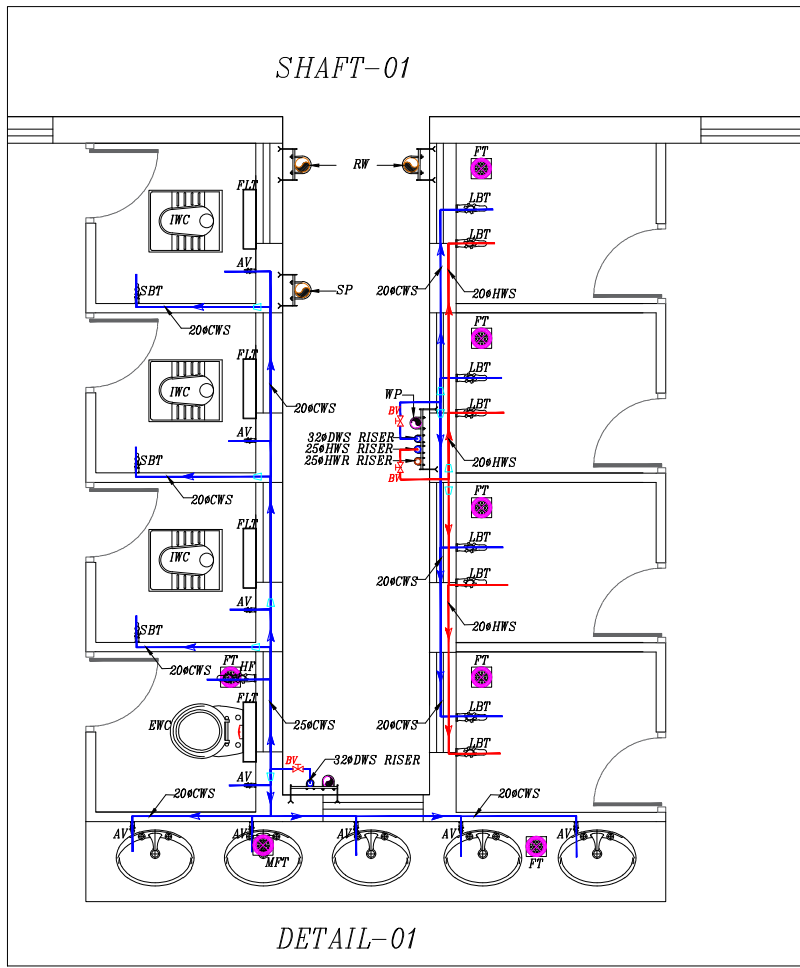



LEGEND		
01	EWC	INDIAN WATER CLOSET
02	EWC	EUROPEAN WATER CLOSET
03	HF	HEALTH FAUCET
04	WB	OVAL WASH BASIN
05	FT	FLOOR TRAP
06	MPT	MULTI INLET FLOOR TRAP
07	SSS	STAINLESS STEEL SINK
08	LBT	LONG BODY TAP
09	SBT	SHORT BODY TAP
10	AV	ANGLE VALVE
11	75 WP	75 WASTE PIPE
12	110 SP	110 SOIL PIPE
13	DWS RISER	DOMESTIC WATER SUPPLY RISER
14	HWS RISES	HOT WATER SUPPLY RISER
15	HWR RISER	HOT WATER RETURN RISER
16	HWS	HOT WATER SUPPLY
17	BY	BALL VALVE
18		PIPE REDUCER

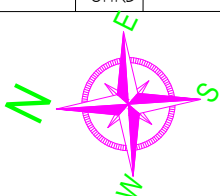
TENDER DRAWINGS			
PHE			
DOMESTIC COLD AND HOT WATER SUPPLY			
REV	DESCRIPTION	CHKD	DATE
DRAWING NO : ARCH001/PHE-04			
FILE NAME :			
Drawn : AV			
Checked : AMOL		REV.NO:	R0
Approved : Ar.Anil.K.		SCALE :	NTS
DATE : 01-1-2025		JOB.NO:	
TITLE : PHE DRAWING			
THIRD FLOOR PLAN			
PROJECT TITLE:			
PROPOSED CONSTRUCTION OF BRBNMPL - BARRACK			
ARCHITECTS :			
KULKARNI ASSOCIATES			
Consulting Architects, Engineers,Project Management Consultants Interior Designers & Regd. valuers Surya Prema Building,next to Adiga's Restaurant,Kanakapura Road No-203,2nd floor,Above Canara bank Raghuvanahalli Branch Raghuvanahalli Village,Uttarahalli hobli Bangalore-560062 Email Id : kulkarni.associates@yahoo.com			

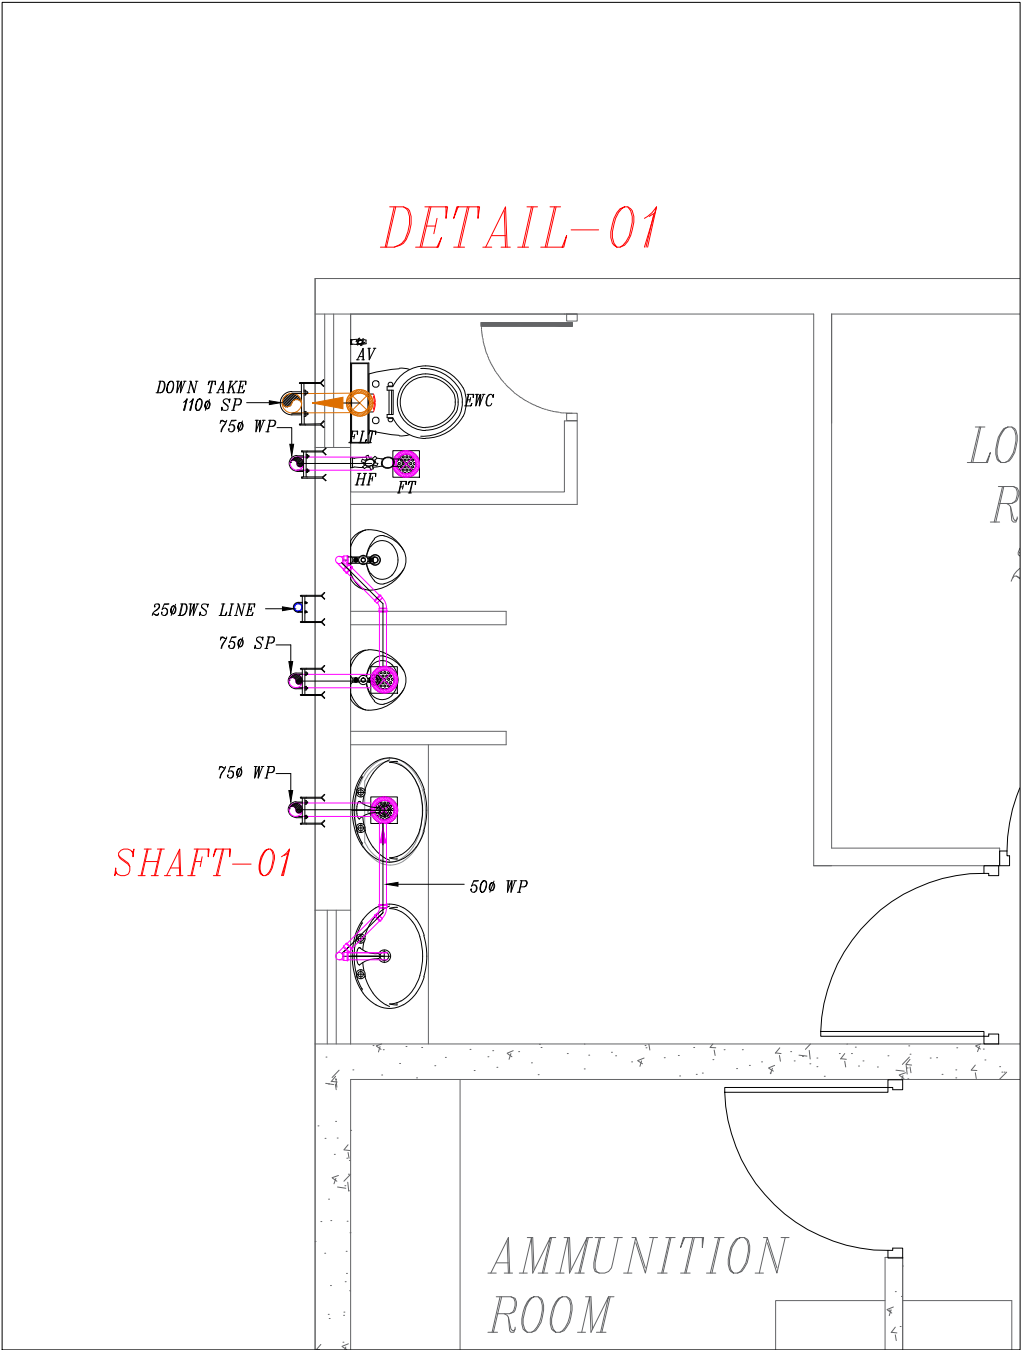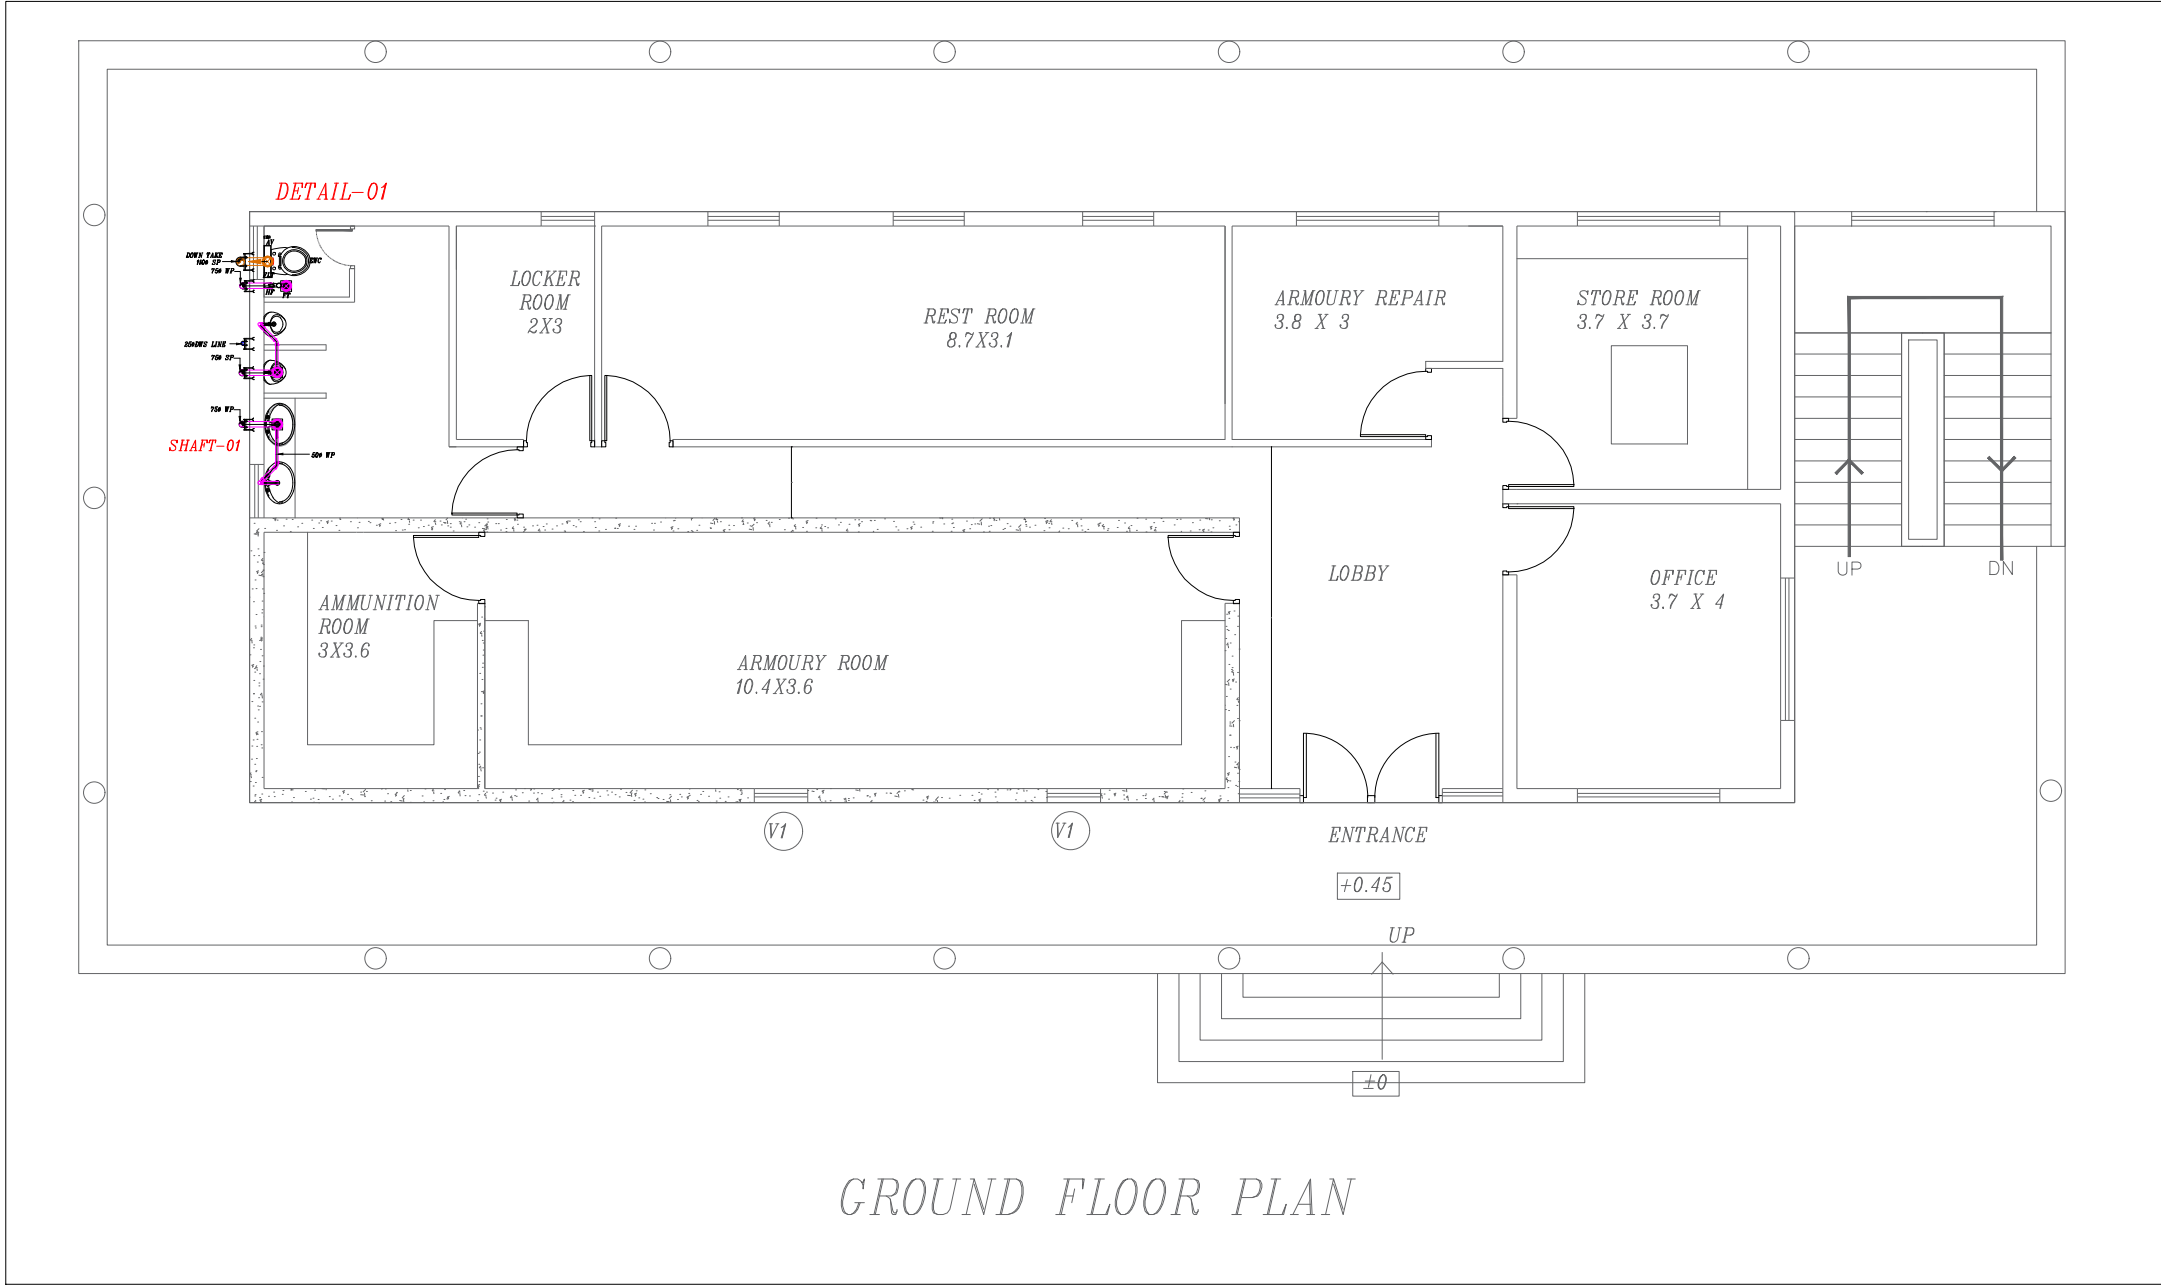


LEGEND		
01	EWC	INDIAN WATER CLOSET
02	EWC	EUROPEAN WATER CLOSET
03	HF	HEALTH FAUCET
04	WB	OVAL WASH BASIN
05	FT	FLOOR TRAP
06	MPT	MULTI INLET FLOOR TRAP
07	SSS	STAINLESS STEEL SINK
08	LBT	LONG BODY TAP
09	SBT	SHORT BODY TAP
10	AV	ANGLE VALVE
11	750 WP	750 WASTE PIPE
12	1100 SP	1100 SOIL PIPE
13	DWS RISER	DOMESTIC WATER SUPPLY RISER
14	HWS RISES	HOT WATER SUPPLY RISER
15	HWR RISER	HOT WATER RETURN RISER
16	HWS	HOT WATER SUPPLY
17	BY	BALL VALVE
18		PIPE REDUCER

SOIL AND WASTE WATER LINE

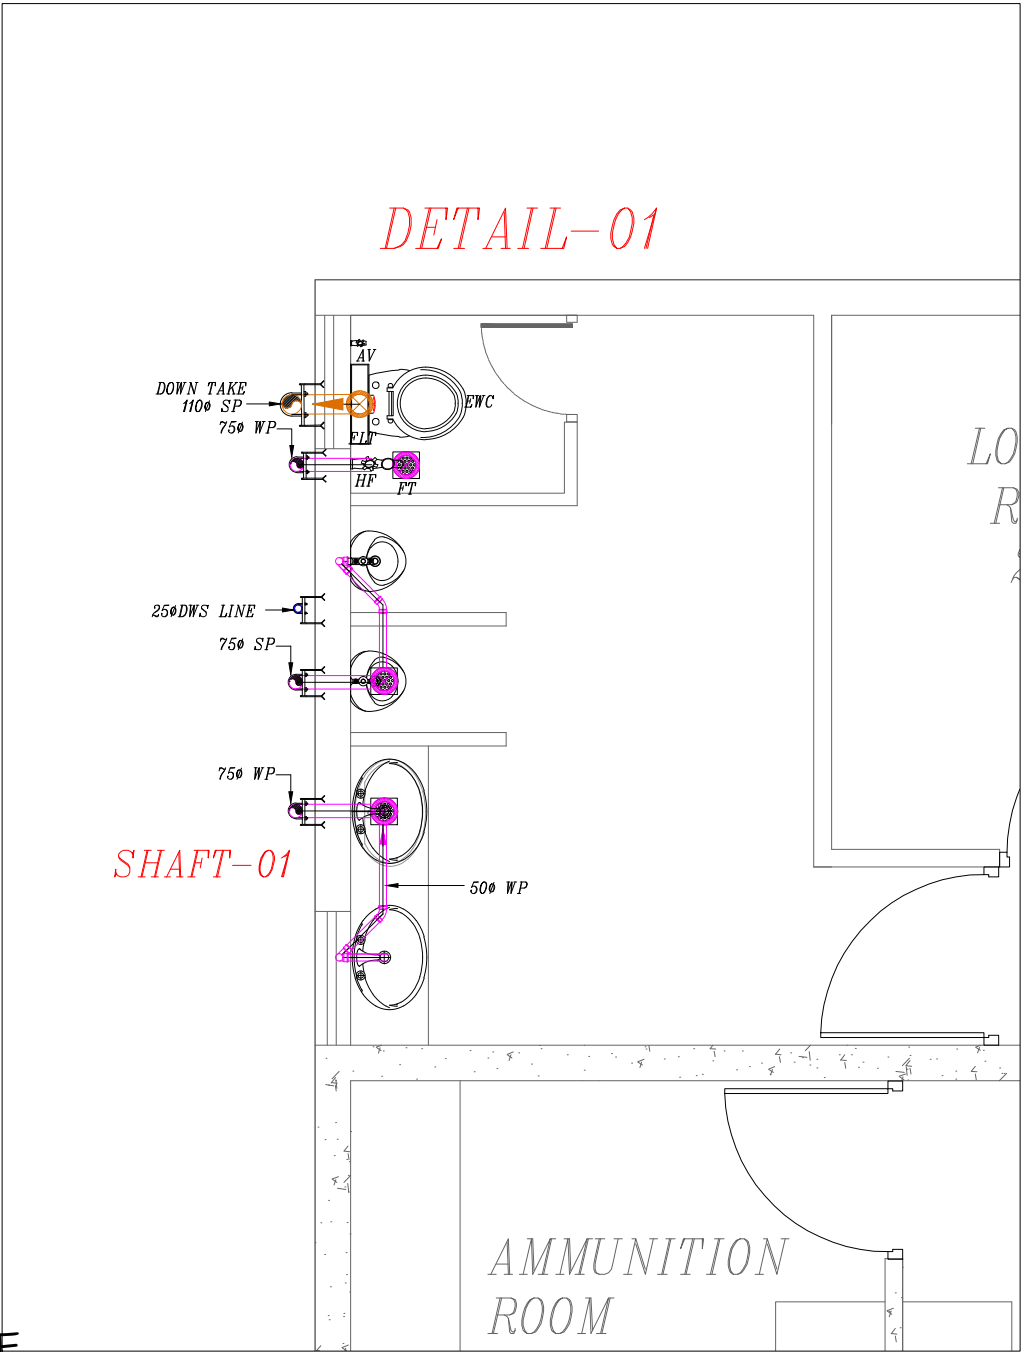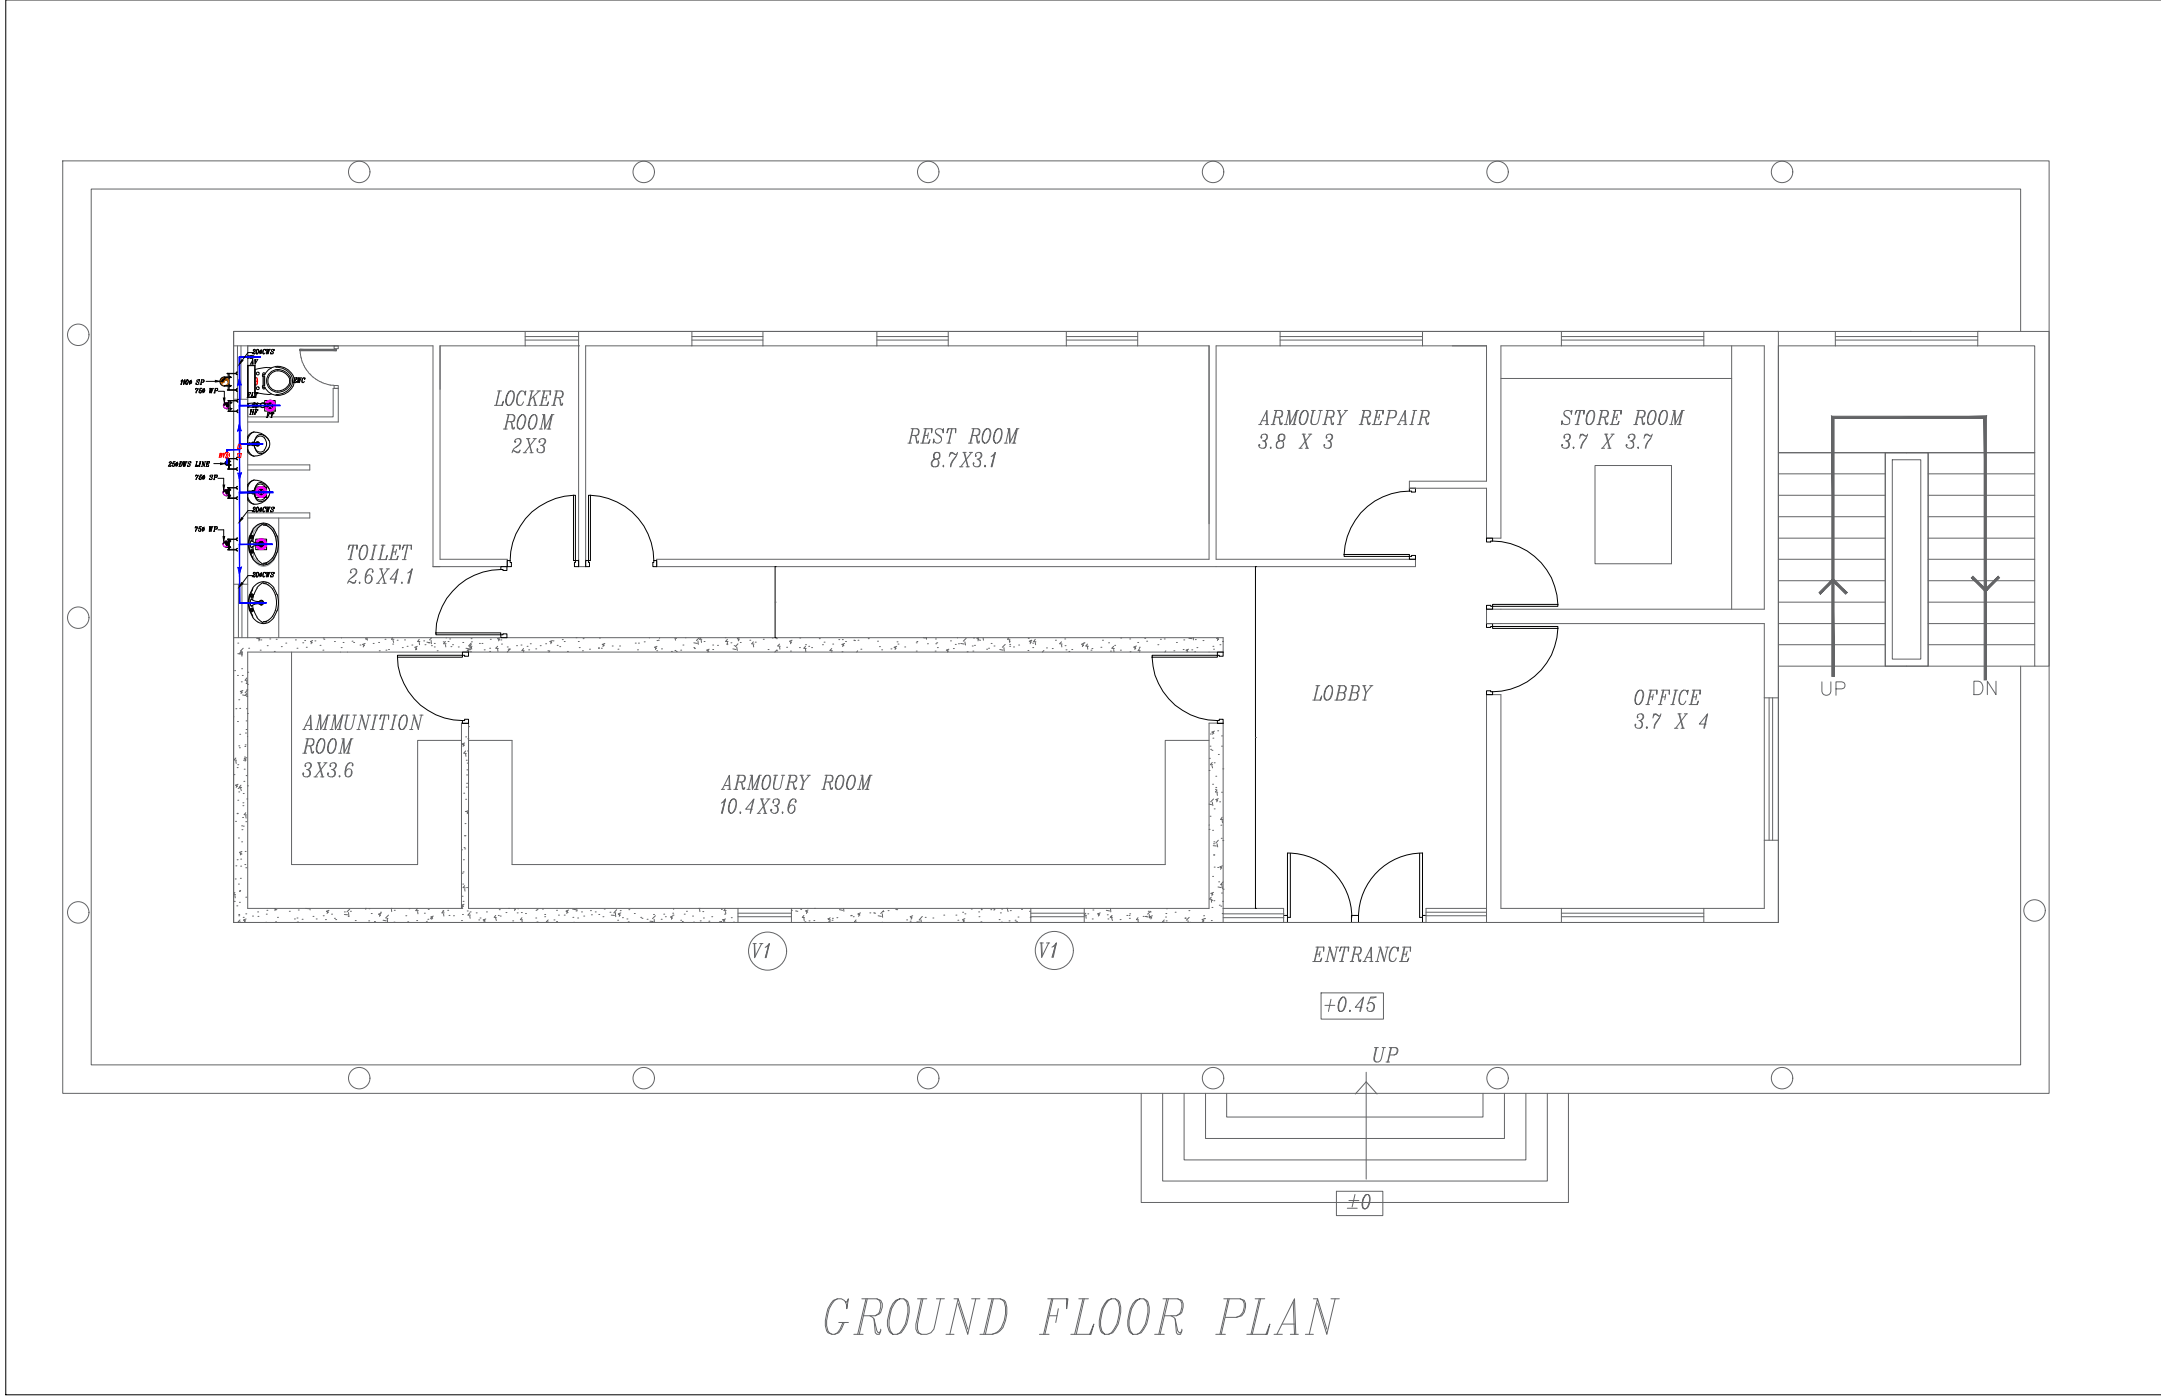

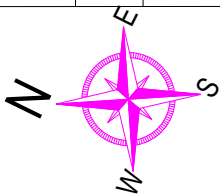TENDER DRAWINGS			
PHE			
SOIL AND WASTE WATER LINE DOMESTIC WATER SUPPLY LINE			
REV	DESCRIPTION	CHKD	DATE
DRAWING NO : ARCH001/PHE-01			
FILE NAME :			
Drawn : AV			
Checked : AMOL		REV.NO:	R0
Approved : Ar.Anil.K.		SCALE :	NTS
DATE : 01-1-2025		JOB.NO:	
TITLE : PHE DRAWING GROUND FLOOR PLAN			
PROJECT TITLE: PROPOSED CONSTRUCTION OF BRBNMPL - ARMOUR HOUSE			
ARCHITECTS : KULKARNI ASSOCIATES Consulting Architects, Engineers,Project Management Consultants Interior Designers & Regd. valuers Surya Prema Building,next to Adiga's Restaurant,Kanakapura Road No-203,2nd floor,Above Canara bank Raghuvanahalli Branch Raghuvanahalli Village,Uttarahalli hobli Bangalore-560062 Email Id : kulkarni.associates@yahoo.com			

DOMESTIC WATER SUPPLY LINE

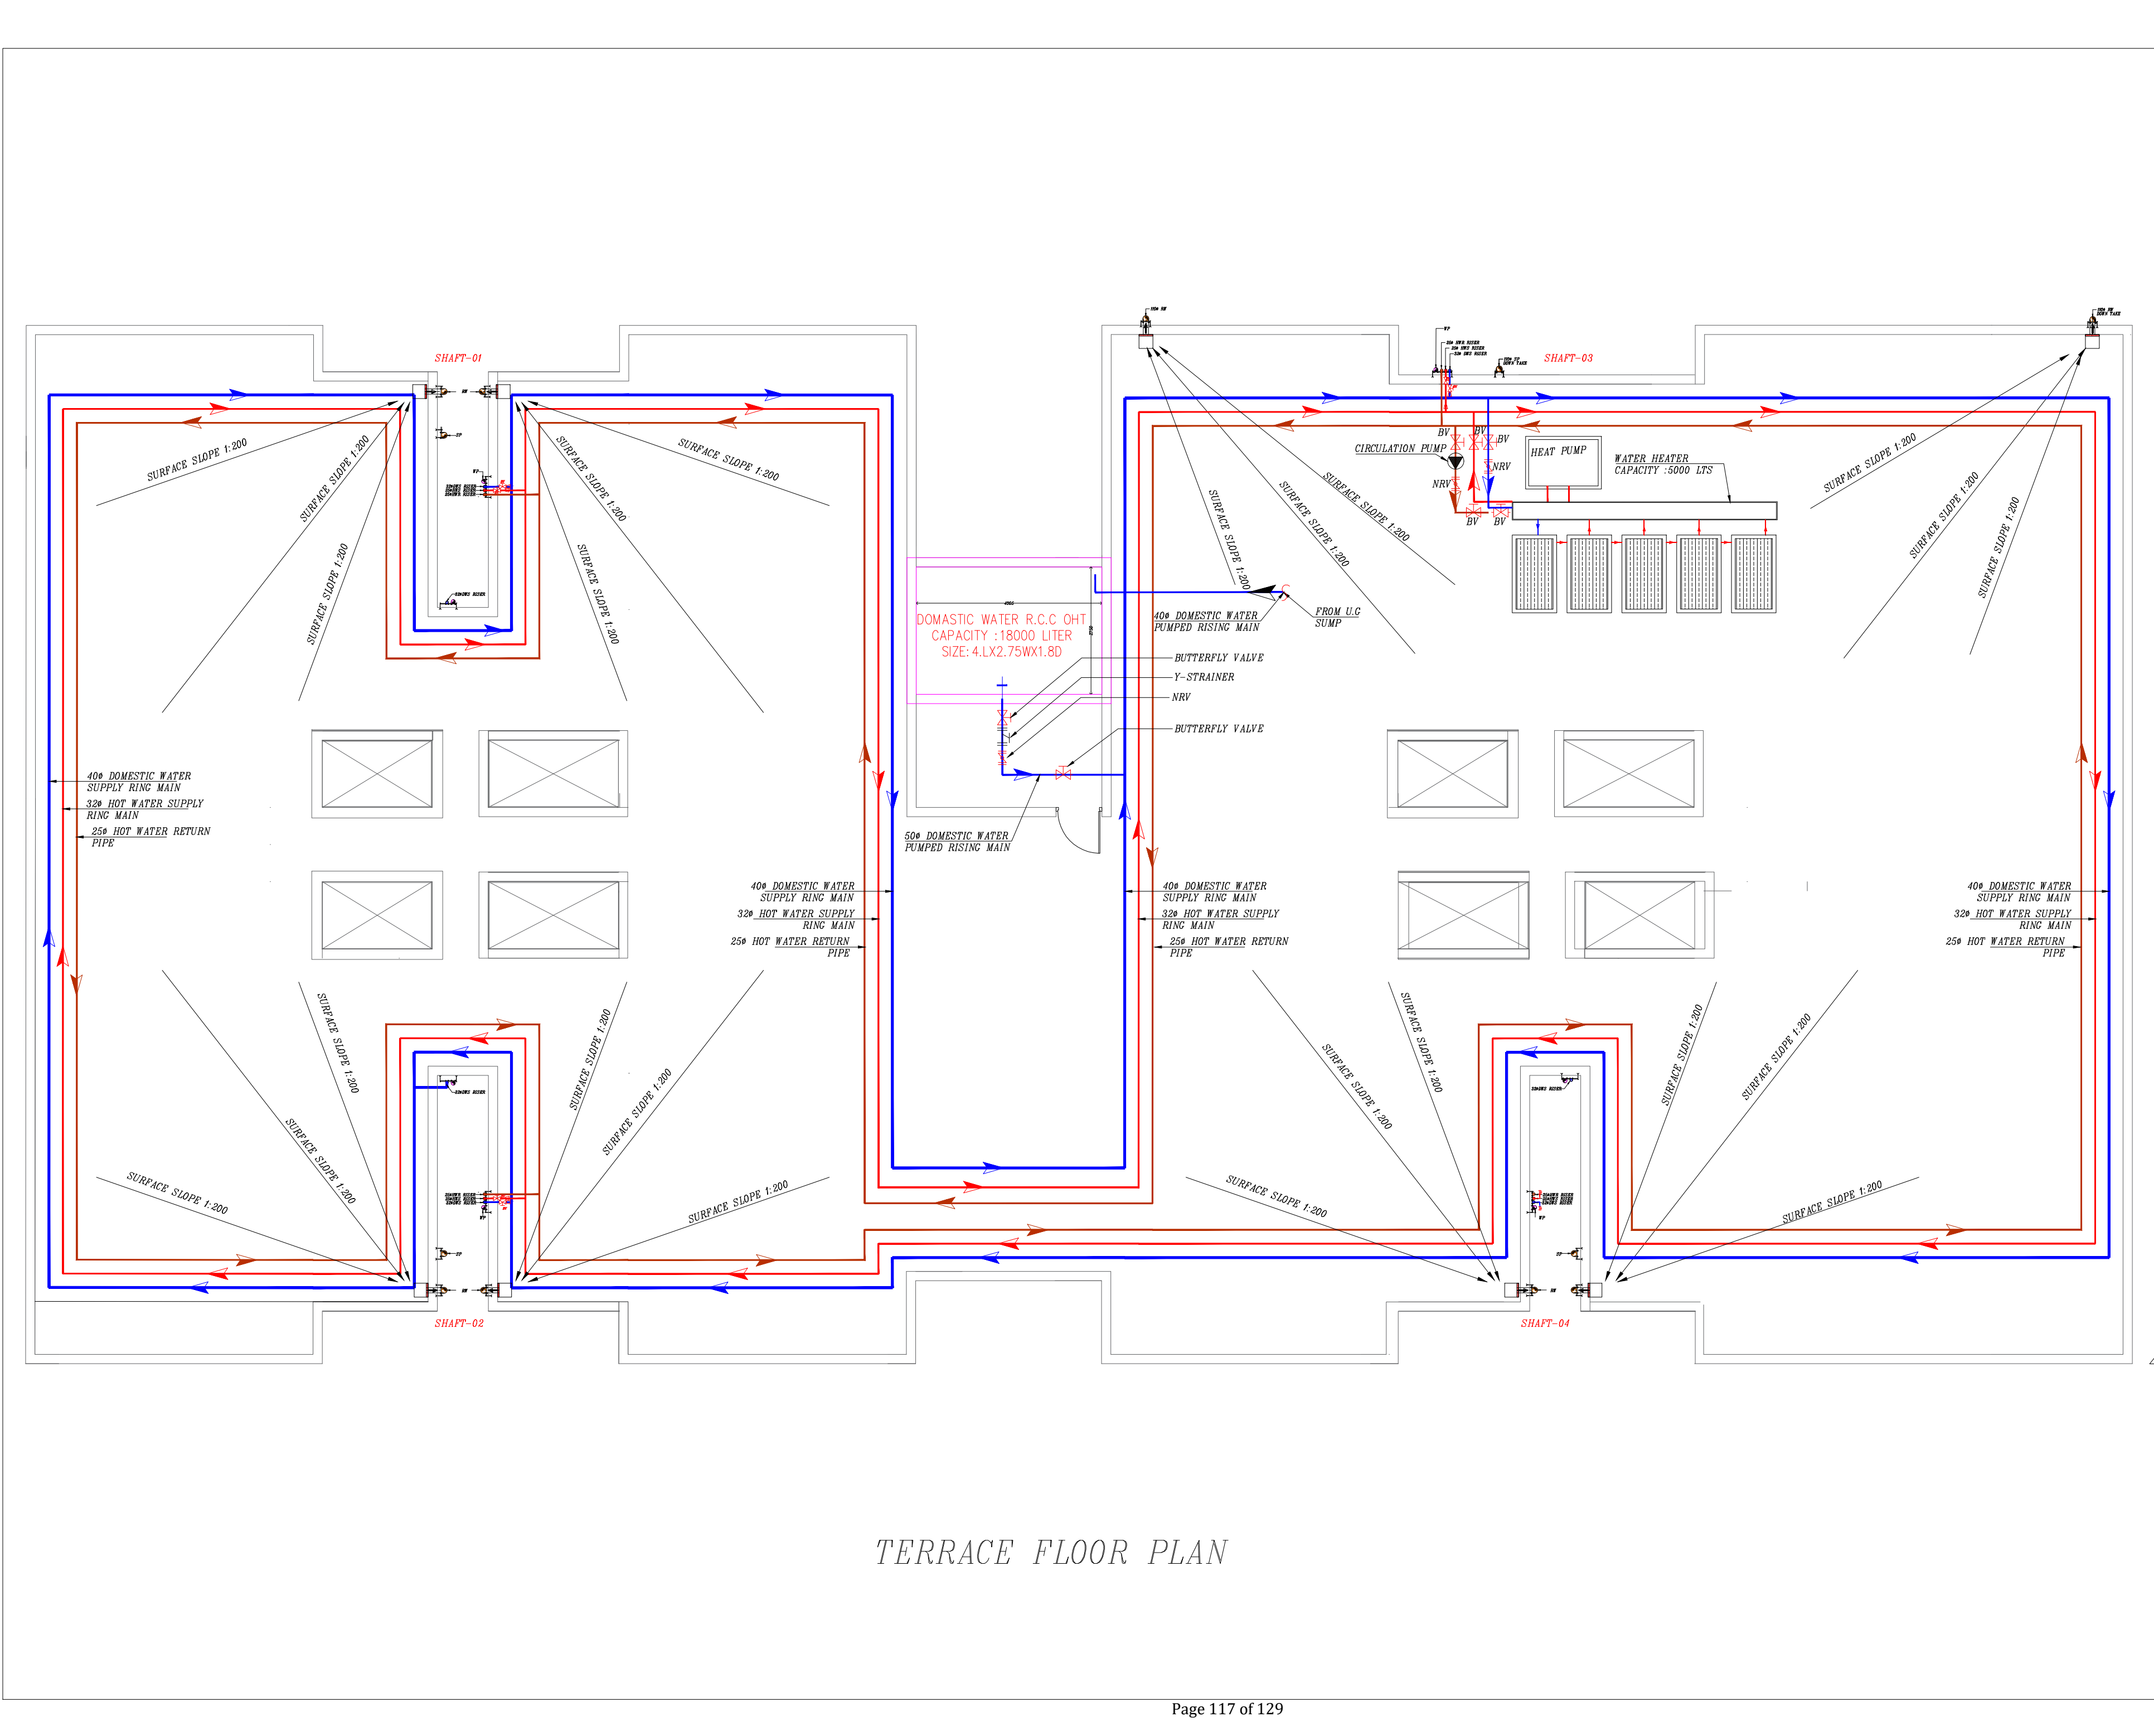

01

EWC

INDIAN WATER CLOSET

02

EWC

EUROPEAN WATER CLOSET

03

HF

HEALTH FAUCET

04

WB

OVAL WASH BASIN

05

FT

FLOOR TRAP

06

MPT

MULTI INLET FLOOR TRAP

07

SSS

STAINLESS STEEL SINK

08

LBT

LONG BODY TAP

09

SBT

SHORT BODY TAP

10

AV

ANGLE VALVE

11

75 WP

75mm WASTE PIPE

12

110 SP

110mm SOIL PIPE

13

DWS RISER

DOMESTIC WATER SUPPLY RISER

14

HWS RISES

HOT WATER SUPPLY RISER

15

HWR RISER

HOT WATER RETURN RISER

16

HWS

HOT WATER SUPPLY

17

BV

BALL VALVE

18





PIPE REDUCER

TENDER DRAWINGS


PHE




OHT AND RING MAIN

REV	DESCRIPTION	CHKD	DATE
DRAWING NO : ARCH001/PHE-05			REV.NO: R0
FILE NAME :			
Drawn : AV			
Checked : AMOL		SCALE : NTS	
DATE : 01-1-2025		JOB.NO:	
TITLE : PHE DRAWING			
TERRACE FLOOR PLAN			
PROJECT TITLE:			
PROPOSED CONSTRUCTION OF BRBNMPL - BARRACK			
ARCHITECTS :			
KULKARNI ASSOCIATES			
Consulting Architects, Engineers,Project Management Consultants			
Interior Designers & Regd. valuers			
Surya Prema Building,next to Adiga's Restaurant,Kanakapura Road			
No-203,2nd floor,Above Canara bank Raghuvanahalli Branch			
Raghuvanahalli Village,Uttarahalli hobli Bangalore-560062			
Email Id : kulkarni.associates@yahoo.com			

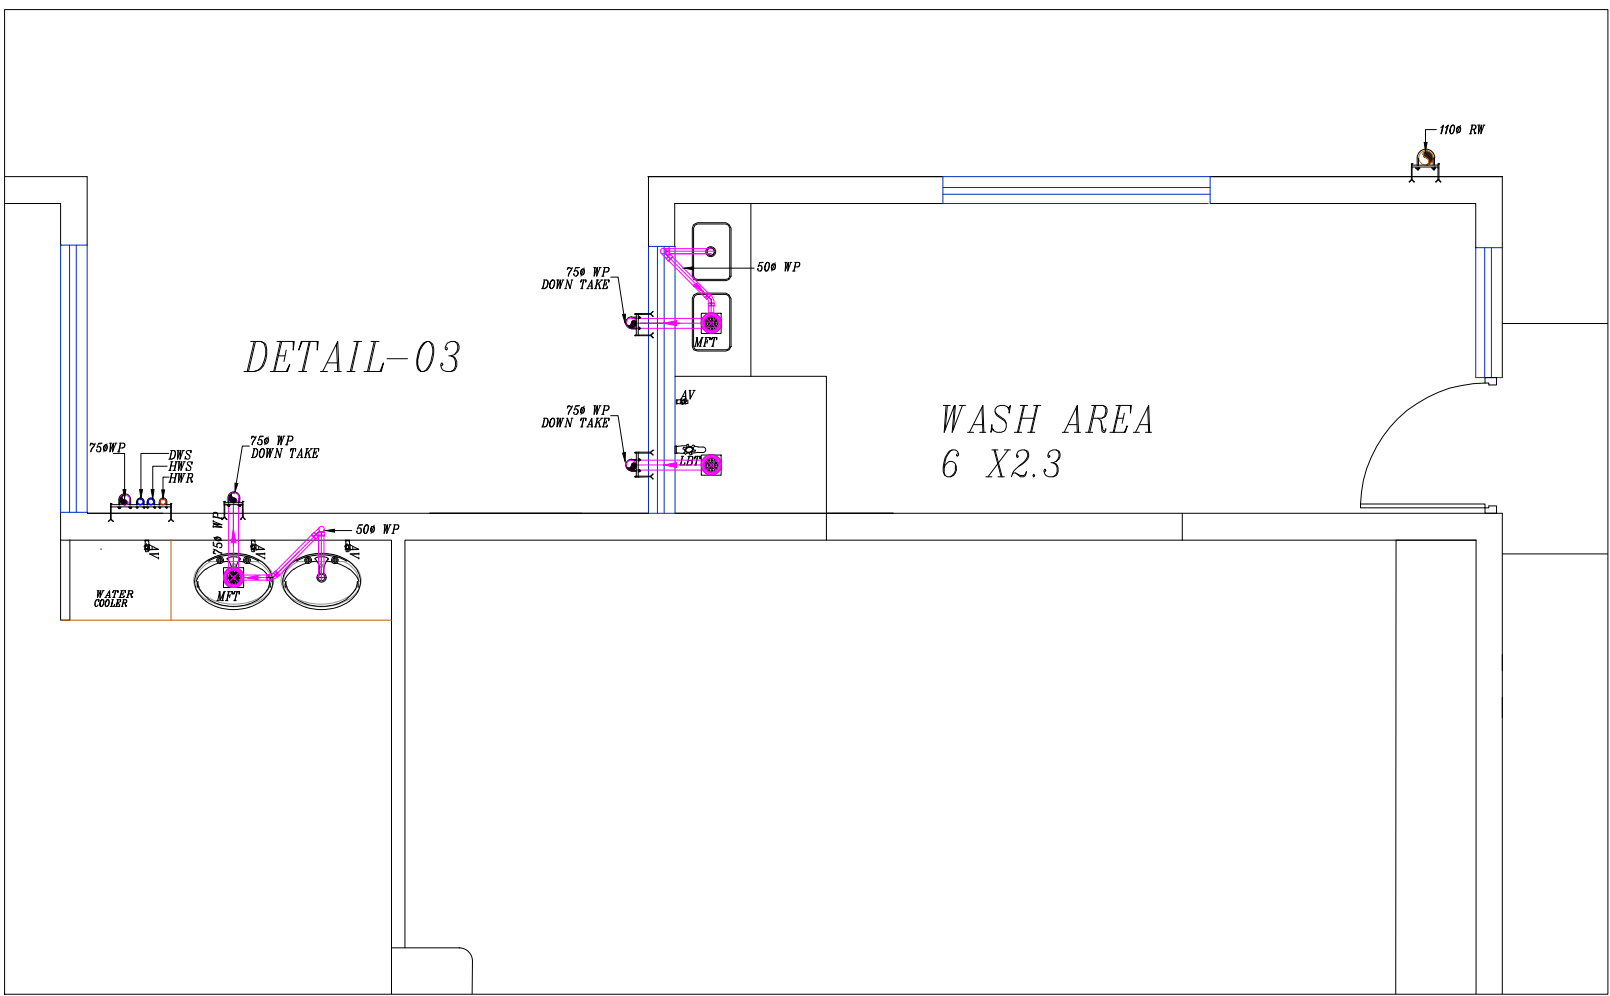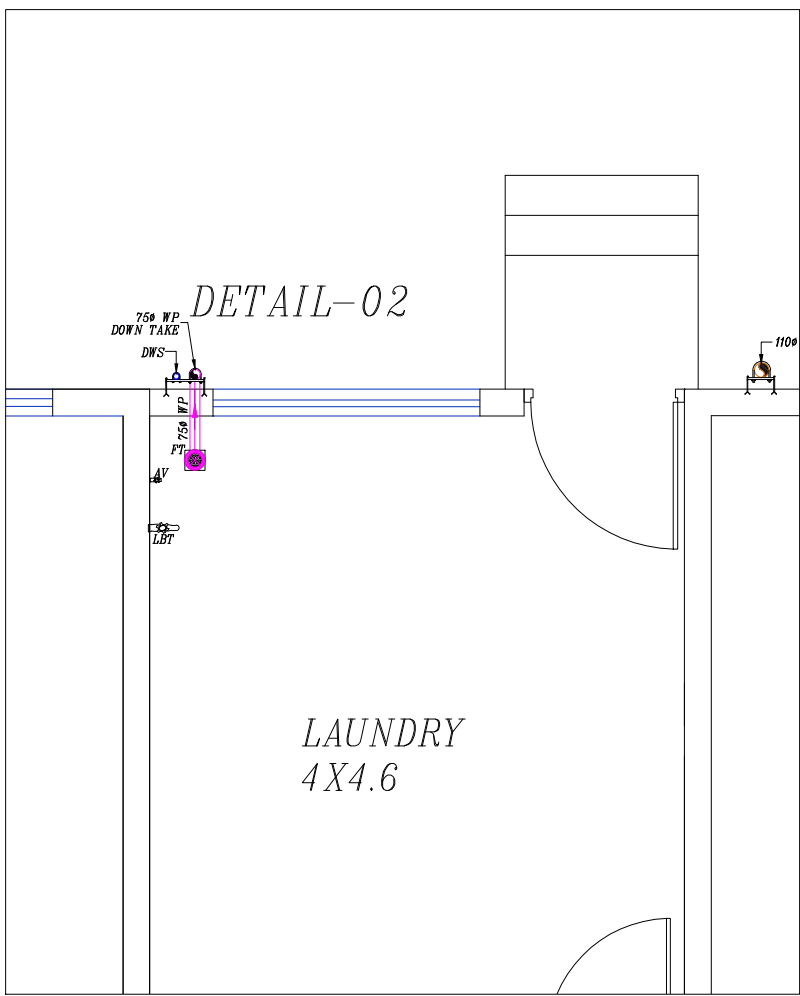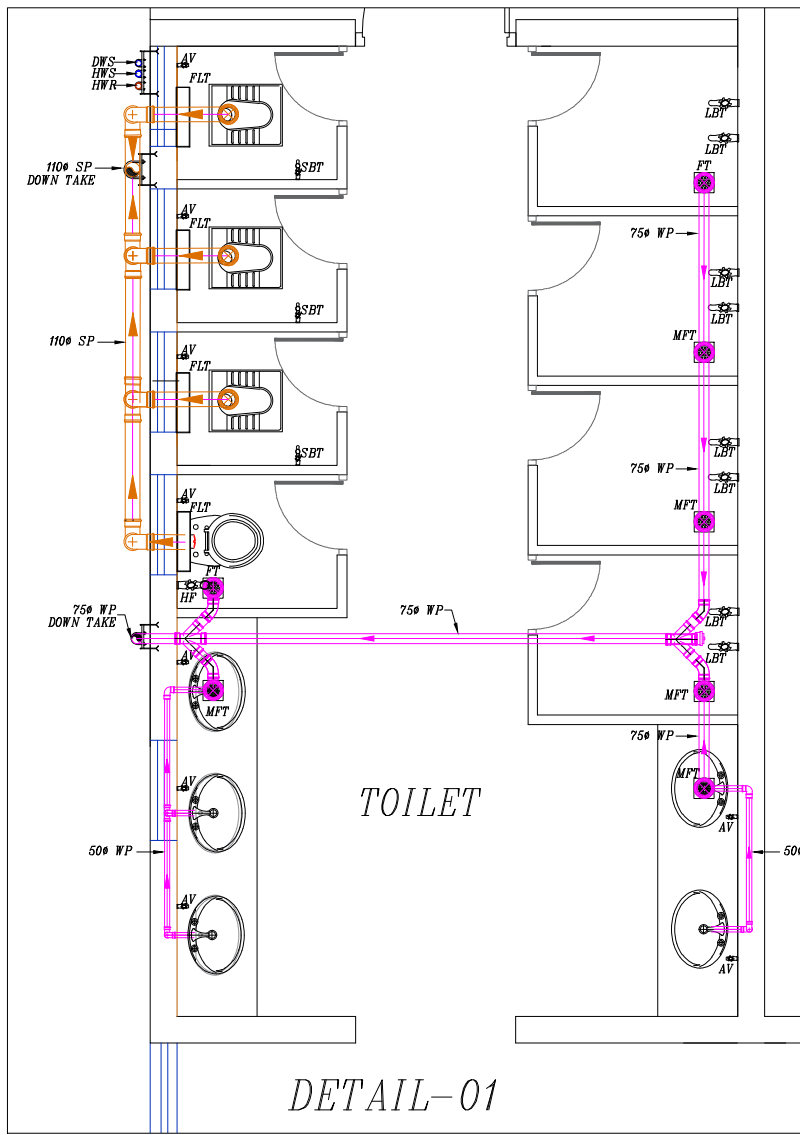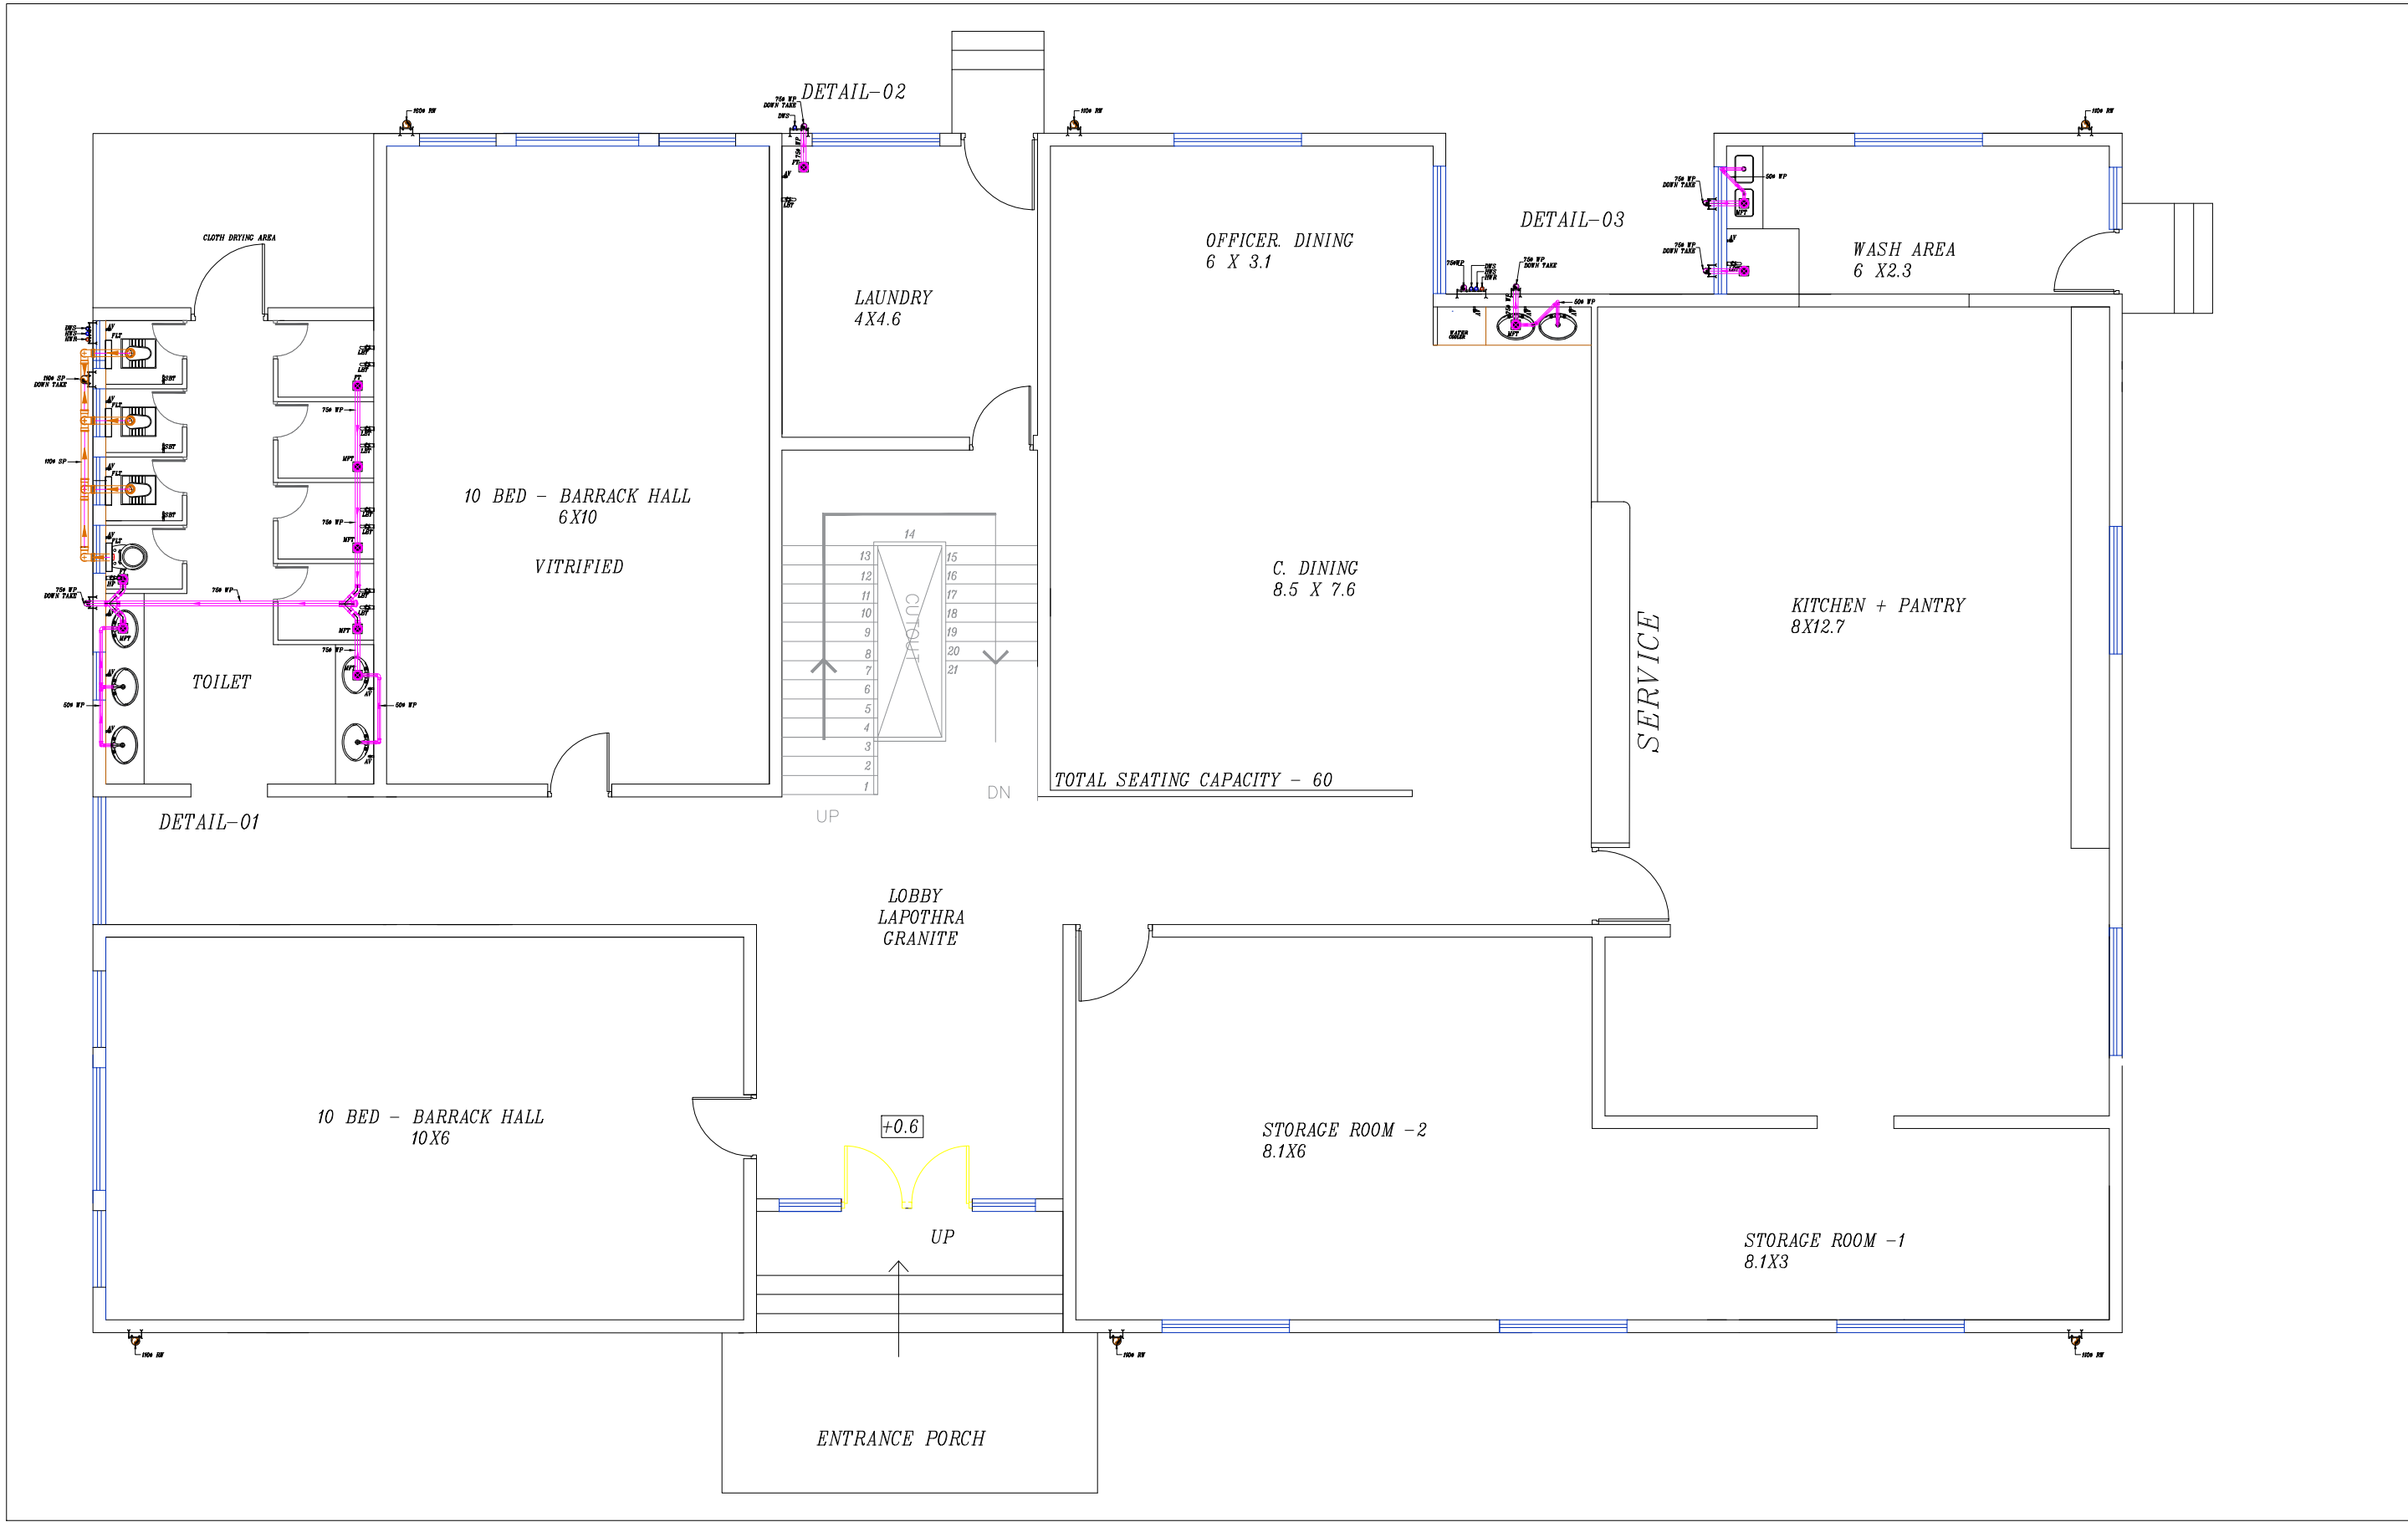

LEGEND		
01	EWC	INDIAN WATER CLOSET
02	EWC	EUROPEAN WATER CLOSET
03	HF	HEALTH FAUCET
04	WB	OVAL WASH BASIN
05	FT	FLOOR TRAP
06	MPT	MULTI INLET FLOOR TRAP
07	SSS	STAINLESS STEEL SINK
08	LET	LONG BODY TAP
09	SBT	SHORT BODY TAP
10	AV	ANGLE VALVE
11	75# WP	75# WASTE PIPE
12	110# SP	110# SOIL PIPE
13	DWS RISER	DOMESTIC WATER SUPPLY RISER
14	HWS RISES	HOT WATER SUPPLY RISER
15	HWR RISER	HOT WATER RETURN RISER
16	HWS	HOT WATER SUPPLY
17	BY	BALL VALVE
18		PIPE REDUCER

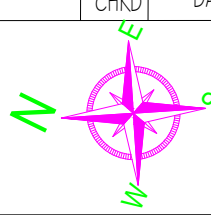TENDER DRAWINGS			
PHE			
SOIL AND WASTE WATER LINE			
REV	DESCRIPTION	CHKD	DATE
DRAWING NO : ARCH001/PHE-01			
FILE NAME :			
Drawn : AV			
Checked : AMOL		REV.NO:	R0
Approved : Ar.Anil.K.		SCALE :	NTS
DATE : 01-1-2025		JOB.NO:	
TITLE : PHE DRAWING			
GROUND FLOOR PLAN			
PROJECT TITLE:			
PROPOSED CONSTRUCTION OF BNPM - BARRACK			
ARCHITECTS : KULKARNI ASSOCIATES Consulting Architects, Engineers,Project Management Consultants Interior Designers & Regd. valuers Surya Prema Building,next to Adiga's Restaurant,Kanakapura Road No-203,2nd floor,Above Canara bank Raghuvanahalli Branch Raghuvanahalli Village,Uttarahalli hobli Bangalore-560062 Email Id : kulkarni.associates@yahoo.com			

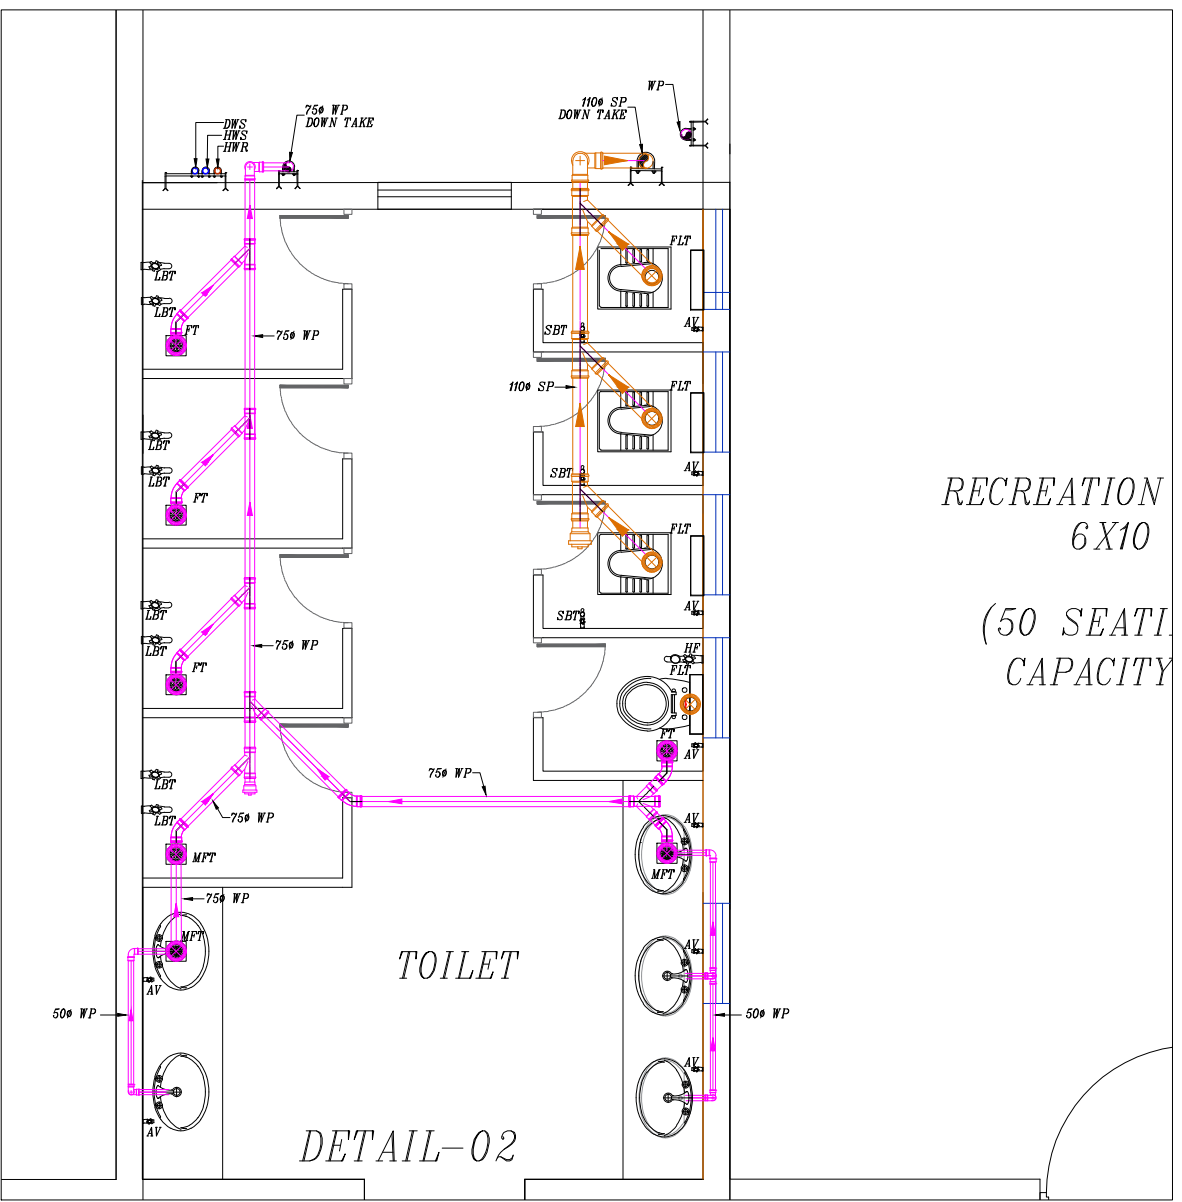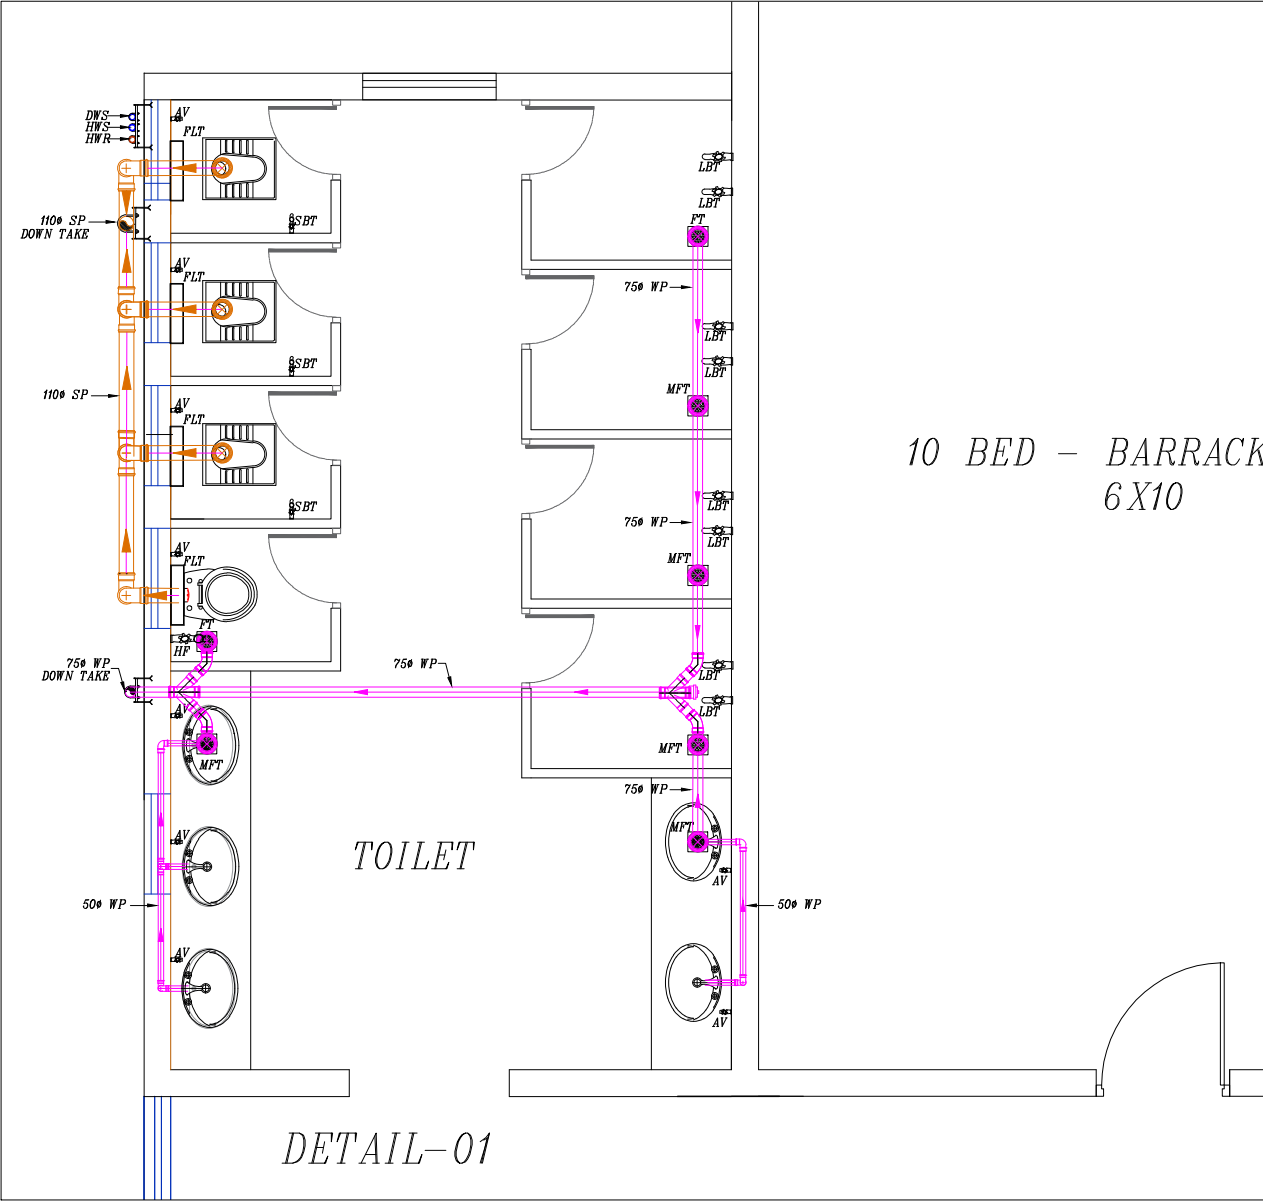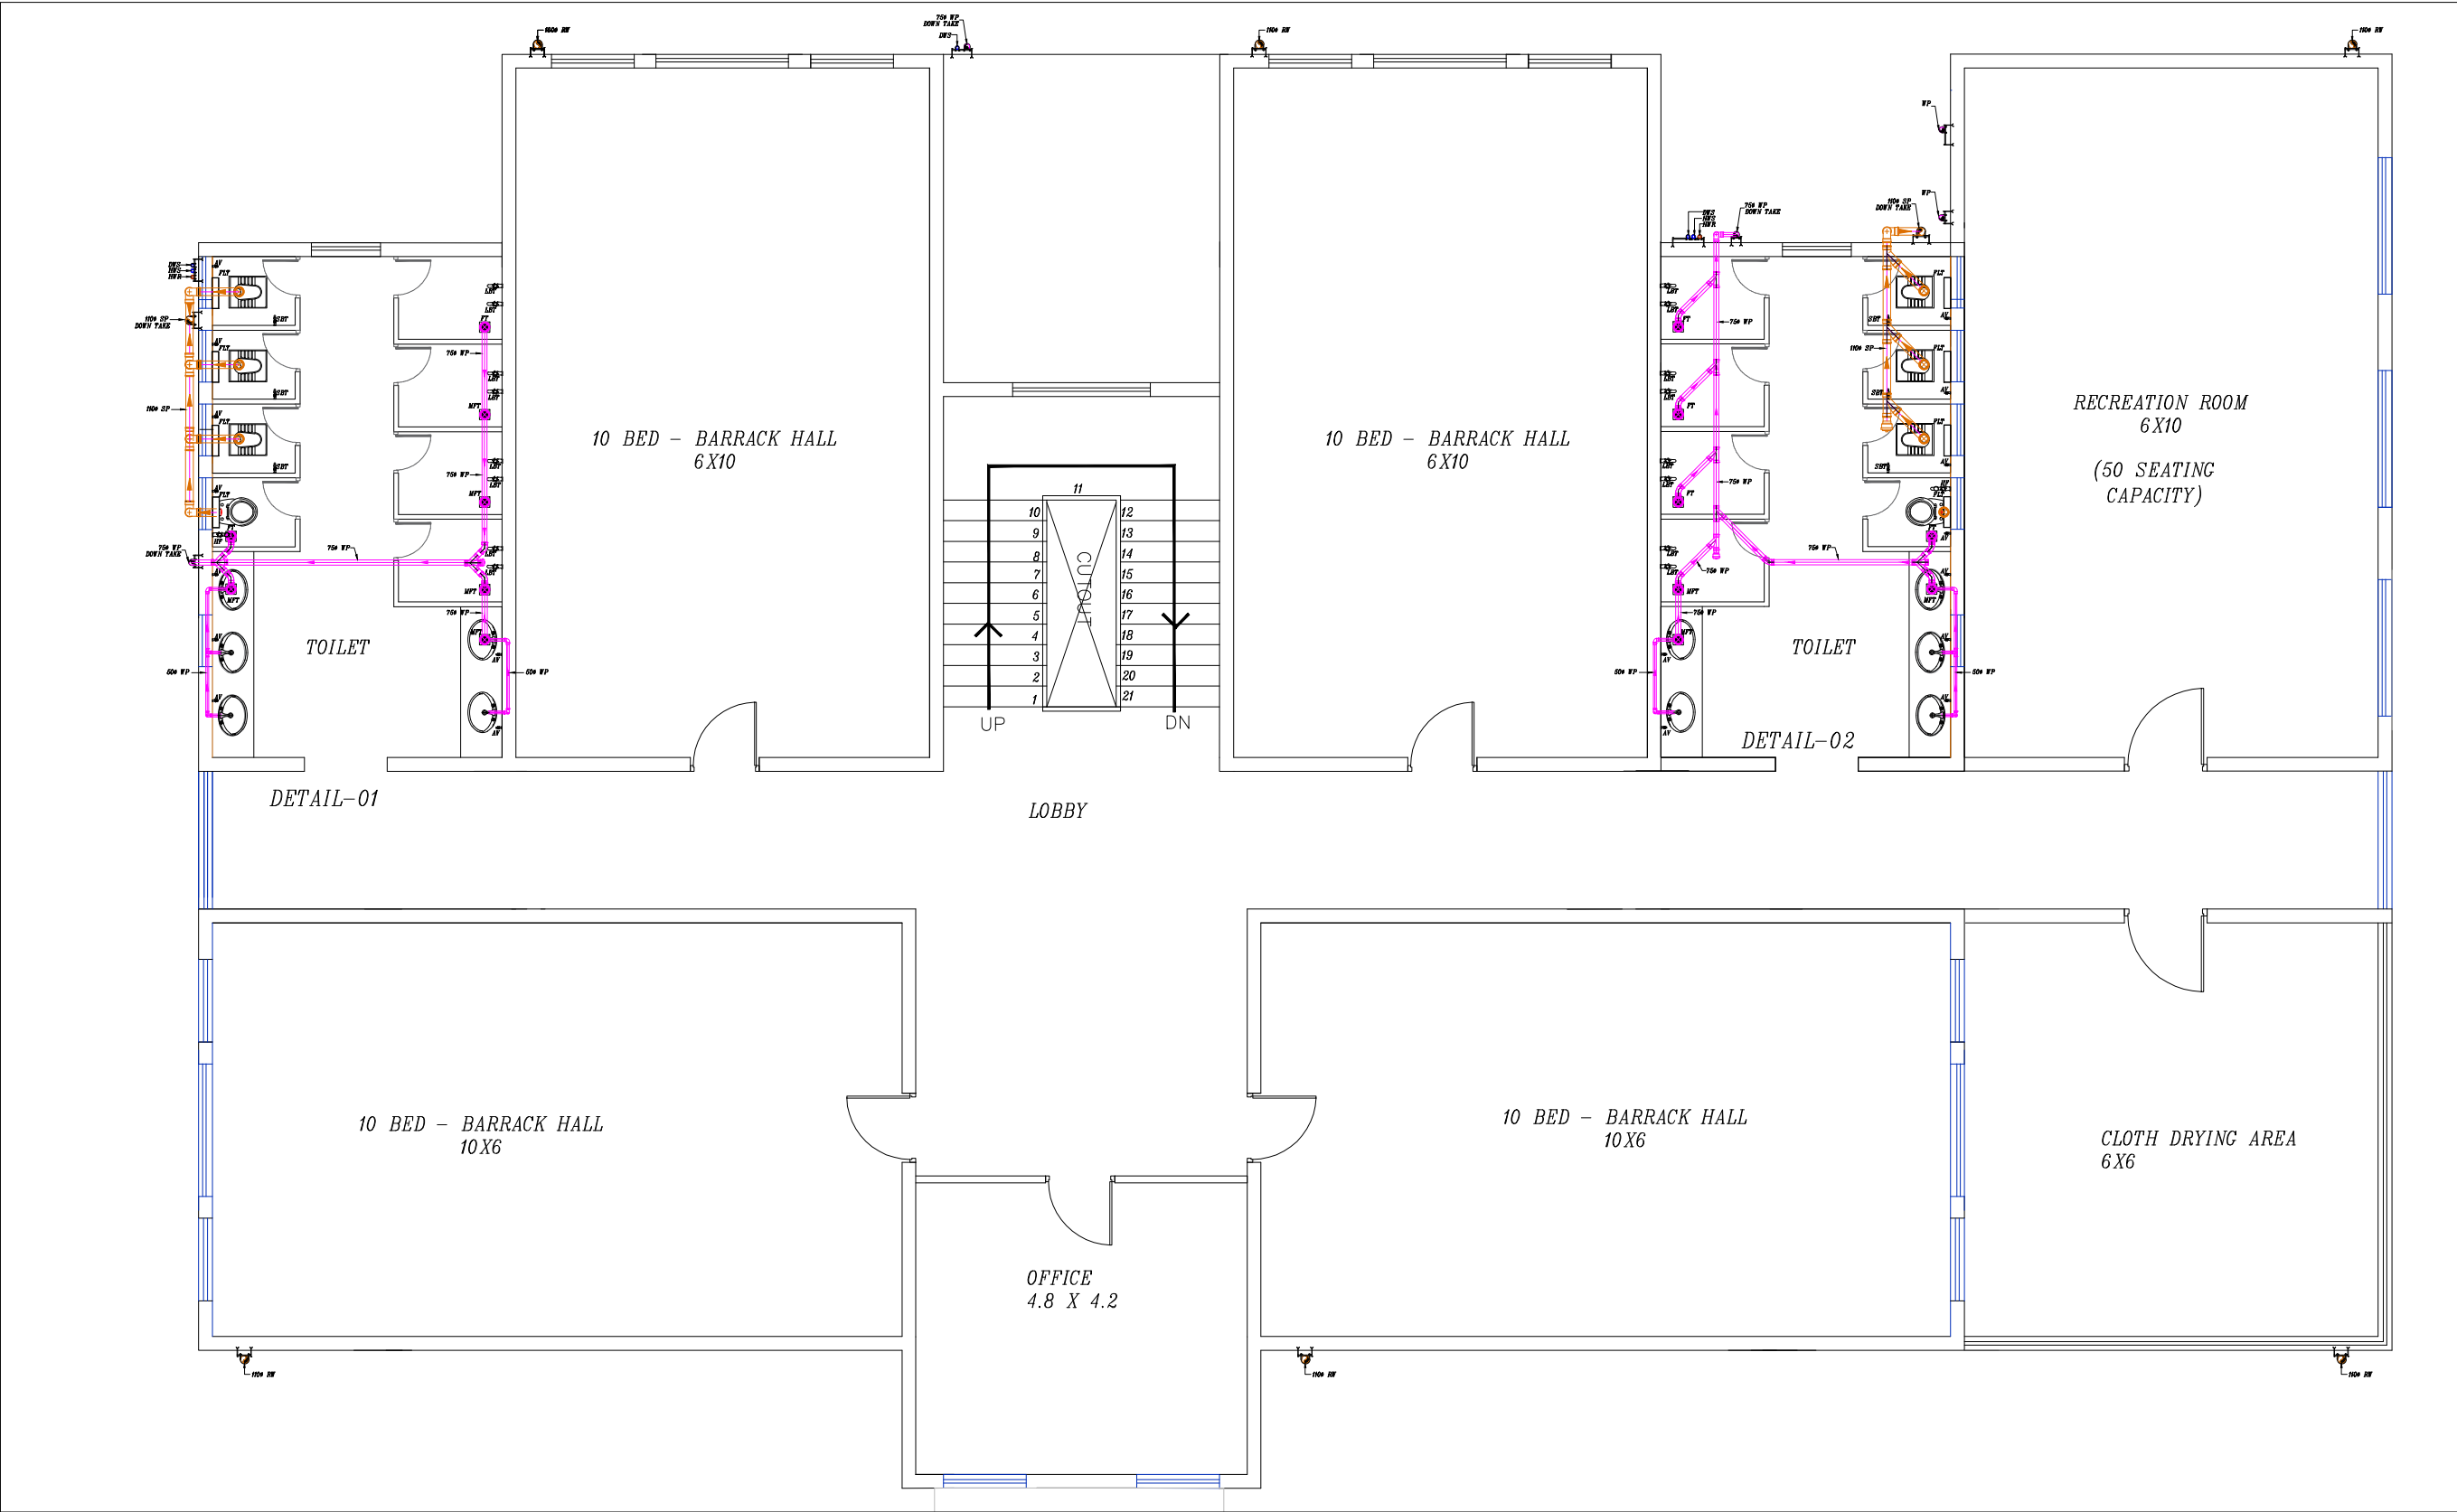

LEGEND			
01	EWC		INDIAN WATER CLOSET
02	EWC		EUROPEAN WATER CLOSET
03	HF		HEALTH FAUCET
04	WB		OVAL WASH BASIN
05	FT		FLOOR TRAP
06	MPT		MULTI INLET FLOOR TRAP
07	SSS		STAINLESS STEEL SINK
08	LBT		LONG BODY TAP
09	SBT		SHORT BODY TAP
10	AV		ANGLE VALVE
11	750 WP		750 WASTE PIPE
12	1100 SP		1100 SOIL PIPE
13	DWS RISER		DOMESTIC WATER SUPPLY RISER
14	HWS RISES		HOT WATER SUPPLY RISER
15	HWR RISER		HOT WATER RETURN RISER
16	HWS		HOT WATER SUPPLY
17	BY		BALL VALVE
18			PIPE REDUCER

TENDER DRAWINGS

PHE





SOIL AND WASTE WATER LINE

REV	DESCRIPTION	CHKD	DATE
DRAWING NO : ARCH001/PHE-02			
FILE NAME :			
Drawn : AV			
Checked : AMOL		REV.NO: R0	
Approved : Ar.Anil.K.		SCALE : NTS	
DATE : 01-1-2025		JOB.NO:	

TITLE : PHE DRAWING
FIRST FLOOR PLAN

PROJECT TITLE:
PROPOSED CONSTRUCTION OF
BNPM - BARRACK

ARCHITECTS :
KULKARNI ASSOCIATES
Consulting Architects, Engineers,Project Management Consultants
Interior Designers & Regd. valuers
Surya Prema Building,next to Adiga's Restaurant,Kanakapura Road
No-203,2nd floor,Above Canara bank Raghuvanahalli Branch
Raghuvanahalli Village,Uttarahalli hobli Bangalore-560062
Email Id : kulkarni.associates@yahoo.com

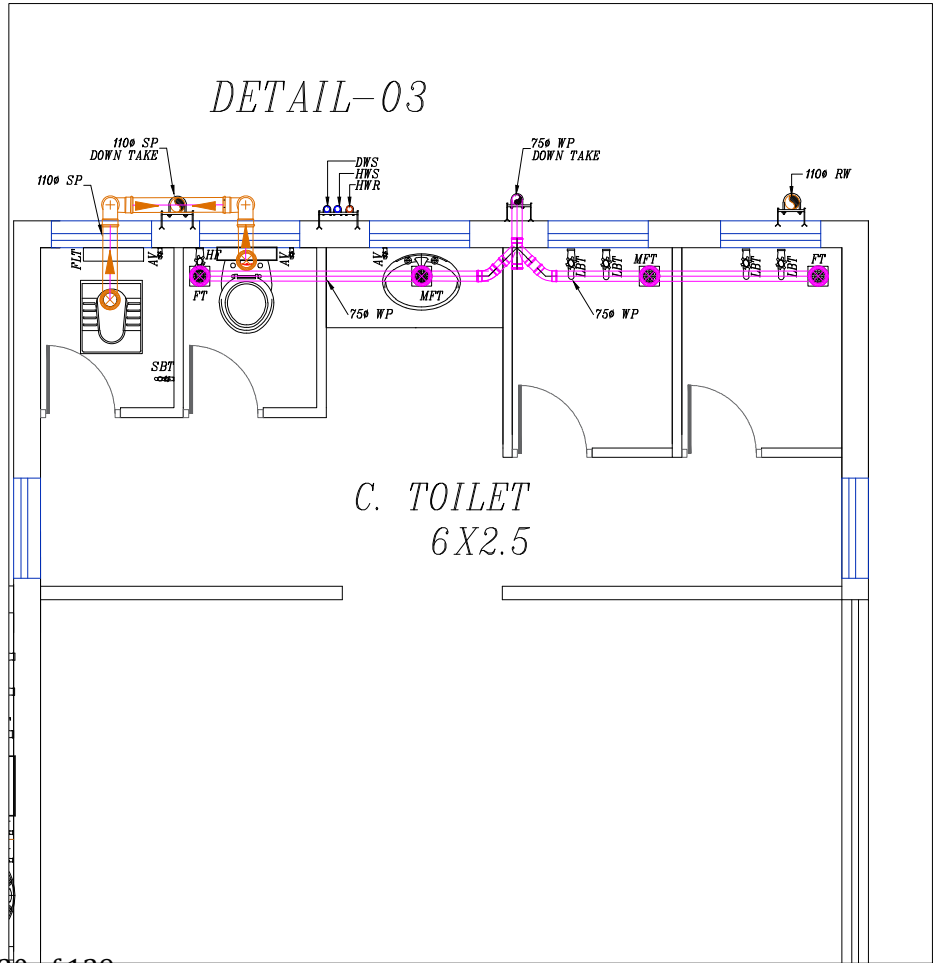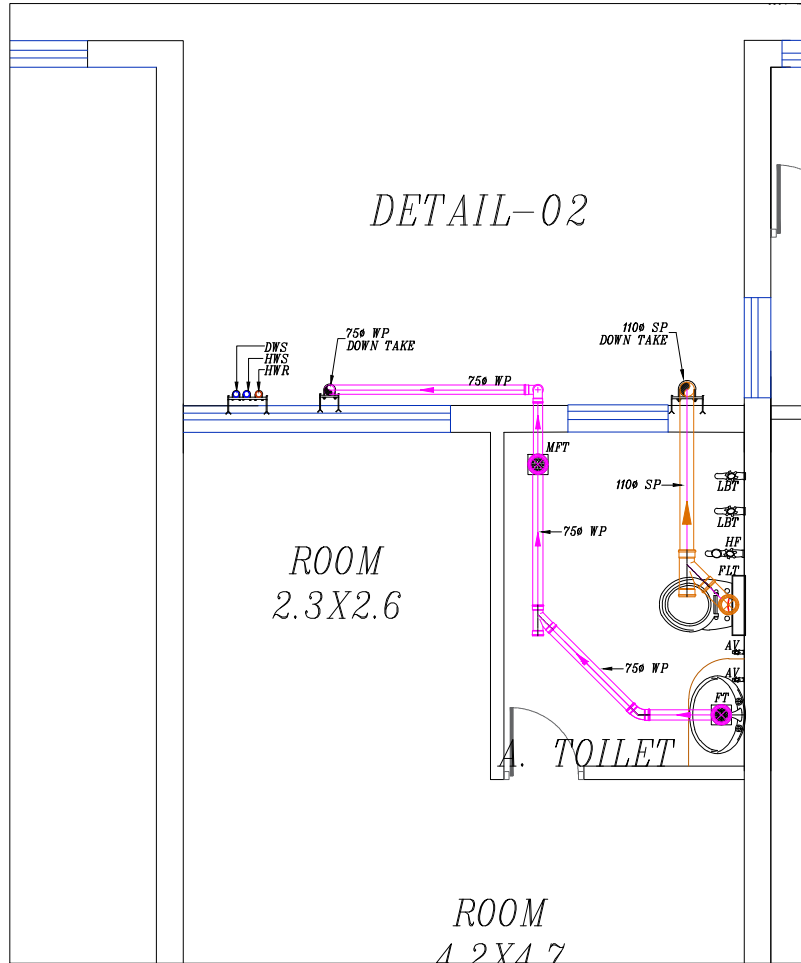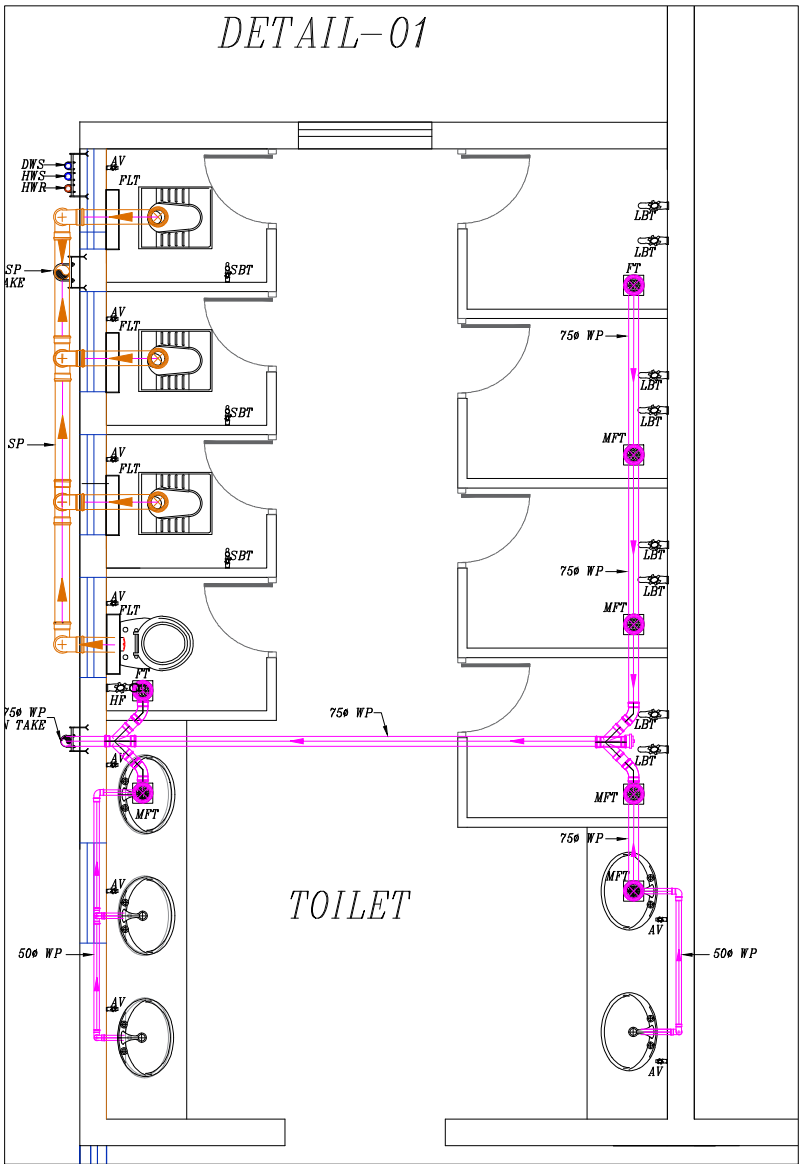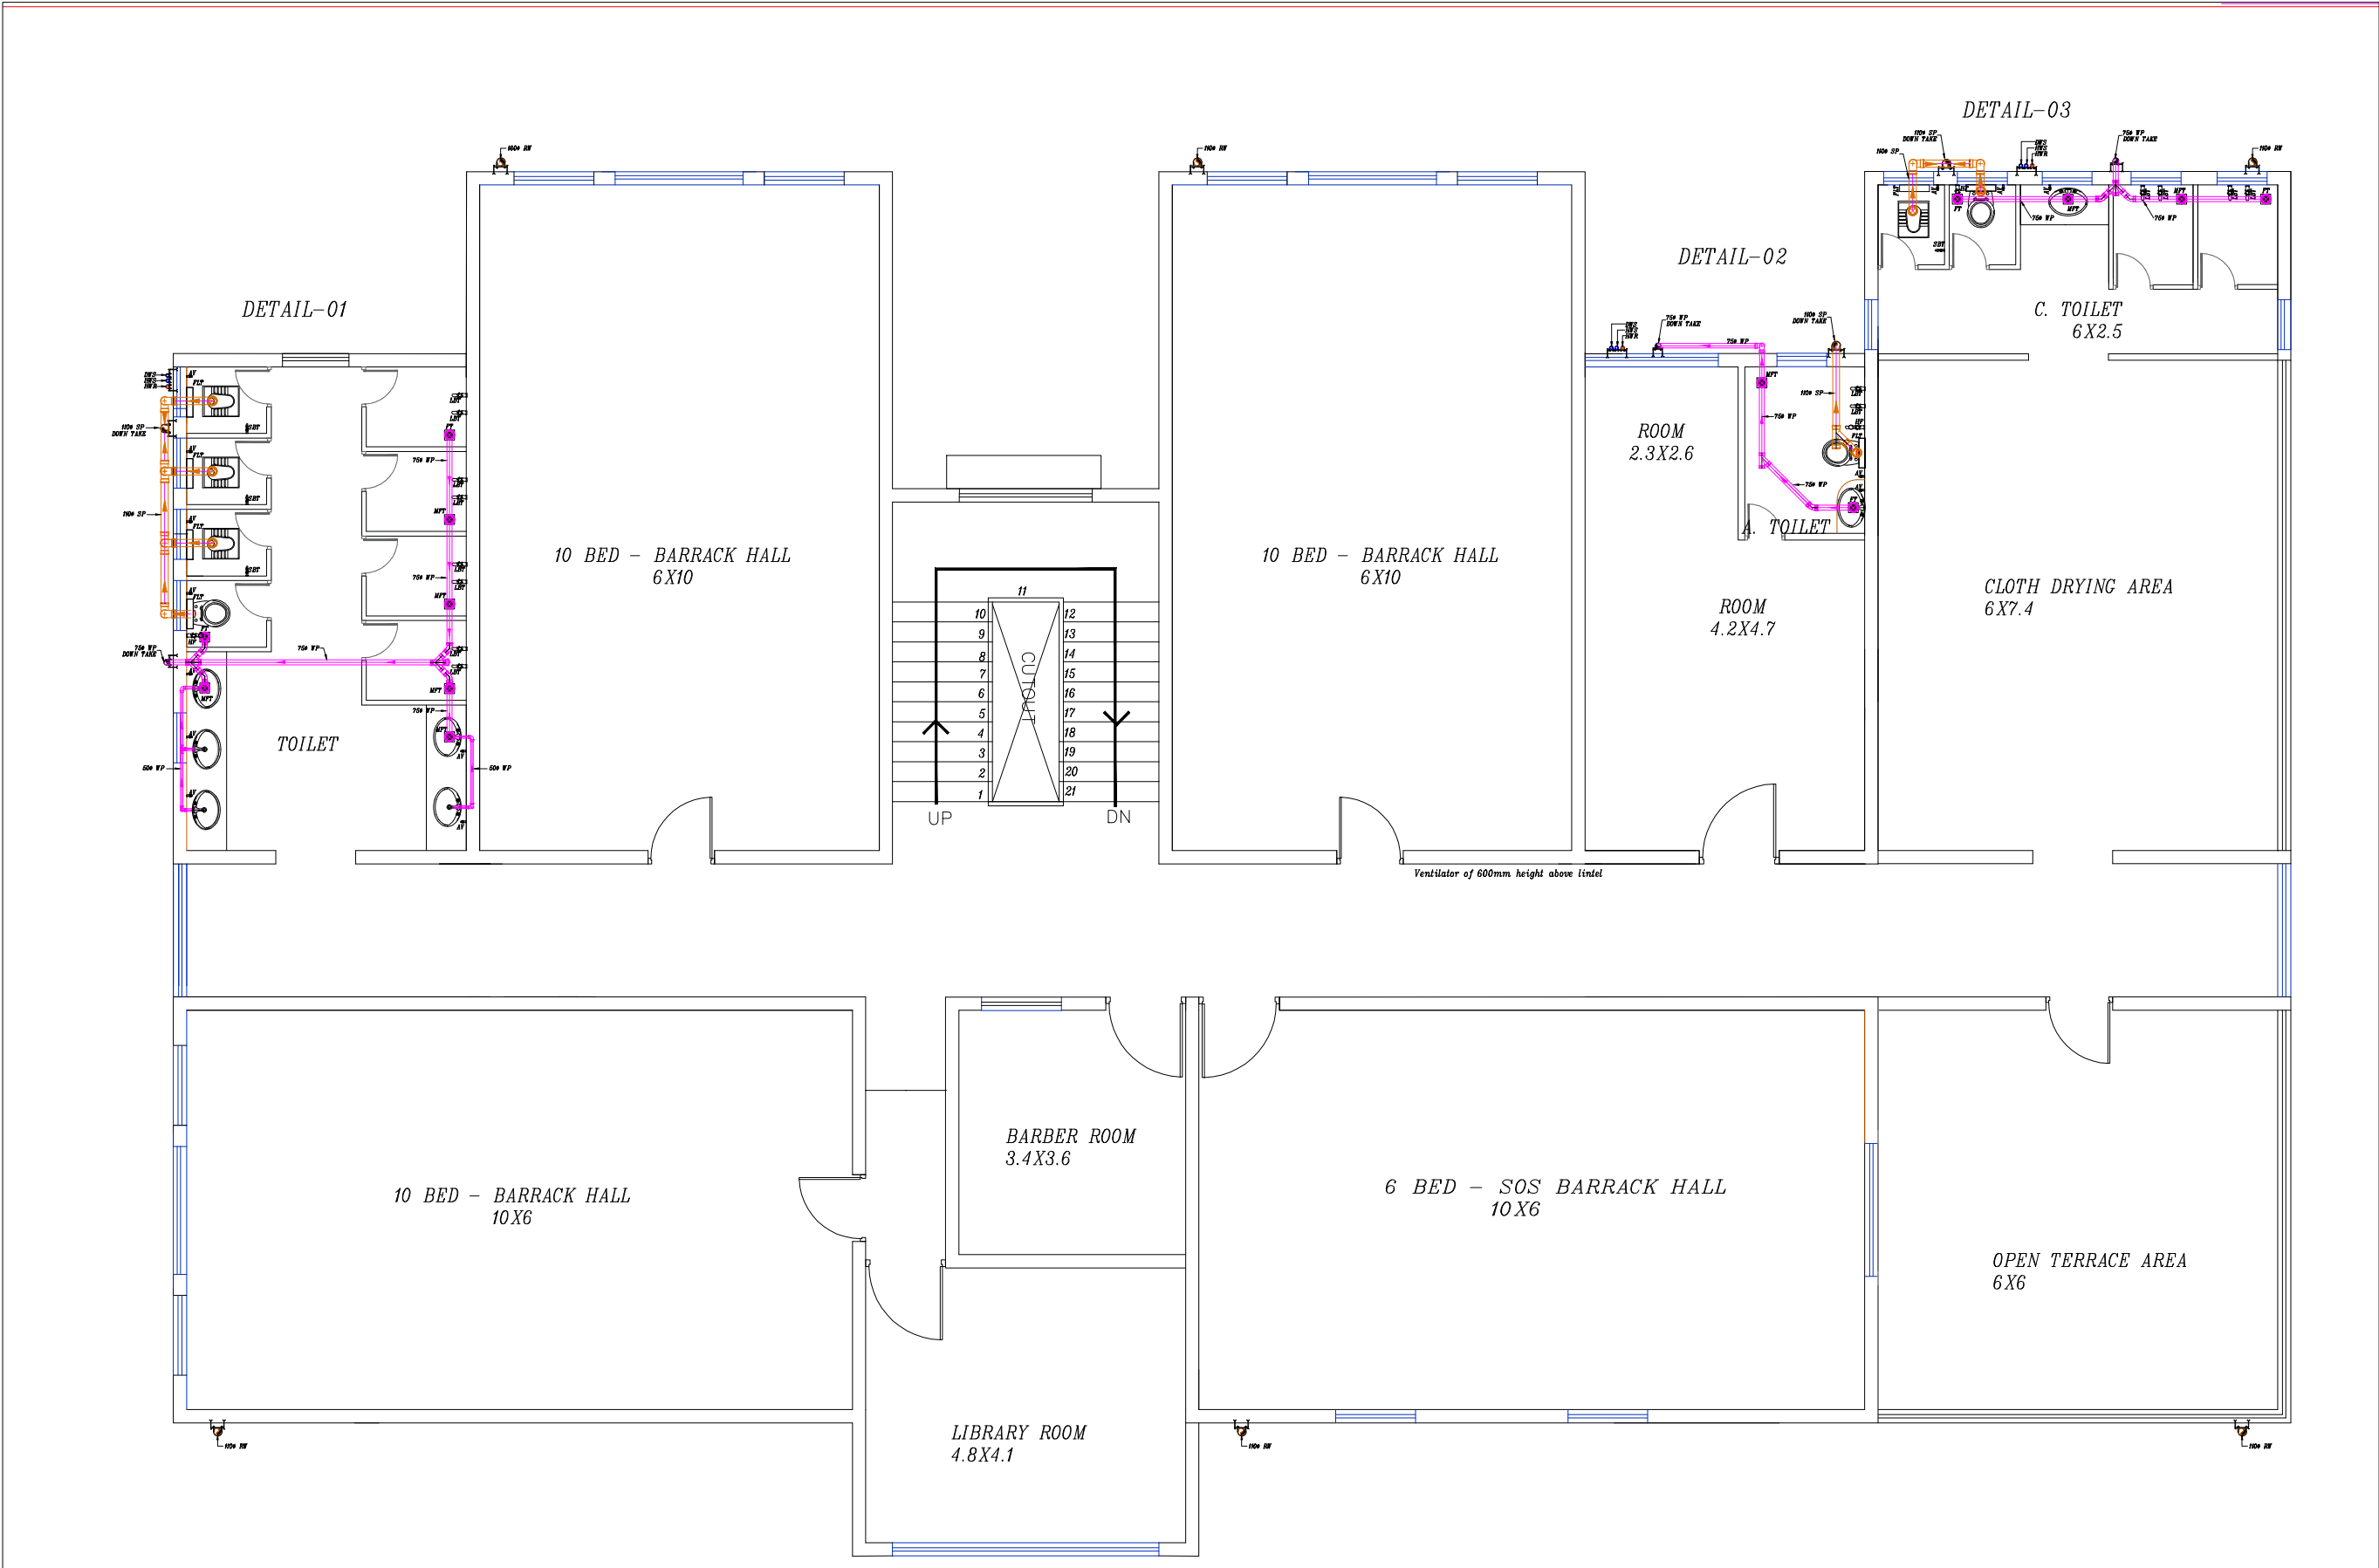

LEGEND			
01	EWC		INDIAN WATER CLOSET
02	EWC		EUROPEAN WATER CLOSET
03	HF		HEALTH FAUCET
04	WB		OVAL WASH BASIN
05	FT		FLOOR TRAP
06	MPT		MULTI INLET FLOOR TRAP
07	SSS		STAINLESS STEEL SINK
08	LB		LONG BODY TAP
09	SB		SHORT BODY TAP
10	AV		ANGLE VALVE
11	75 WP		75mm WASTE PIPE
12	110 SP		110mm SOIL PIPE
13	DWS RISER		DOMESTIC WATER SUPPLY RISER
14	HWS RISE		HOT WATER SUPPLY RISER
15	HWR RISER		HOT WATER RETURN RISER
16	HWS		HOT WATER SUPPLY
17	BV		BALL VALVE
18			PIPE REDUCER

TENDER DRAWINGS

PHE

SOIL AND WASTE WATER LINE

REV	DESCRIPTION	CHKD	DATE
DRAWING NO : ARCH001/PHE-03			
FILE NAME :			
Drawn : AV			
Checked : AMOL			REV.NO: R0
Approved : Ar.Anil.K.		SCALE : NTS	
DATE : 01-1-2025		JOB.NO:	

TITLE : PHE DRAWING

SECOND FLOOR PLAN





PROJECT TITLE:

PROPOSED CONSTRUCTION OF
BNPM - BARRACK

ARCHITECTS :

KULKARNI ASSOCIATES

Consulting Architects, Engineers,Project Management Consultants
Interior Designers & Regd. valuers
Surya Prema Building,next to Adiga's Restaurant,Kanakapura
Road
No-203,2nd floor,Above Canara bank Raghuvanahalli Branch
Raghuvanahalli Village,Uttarahalli hobli Bangalore-560062
Email Id : kulkarni.associates@yahoo.com

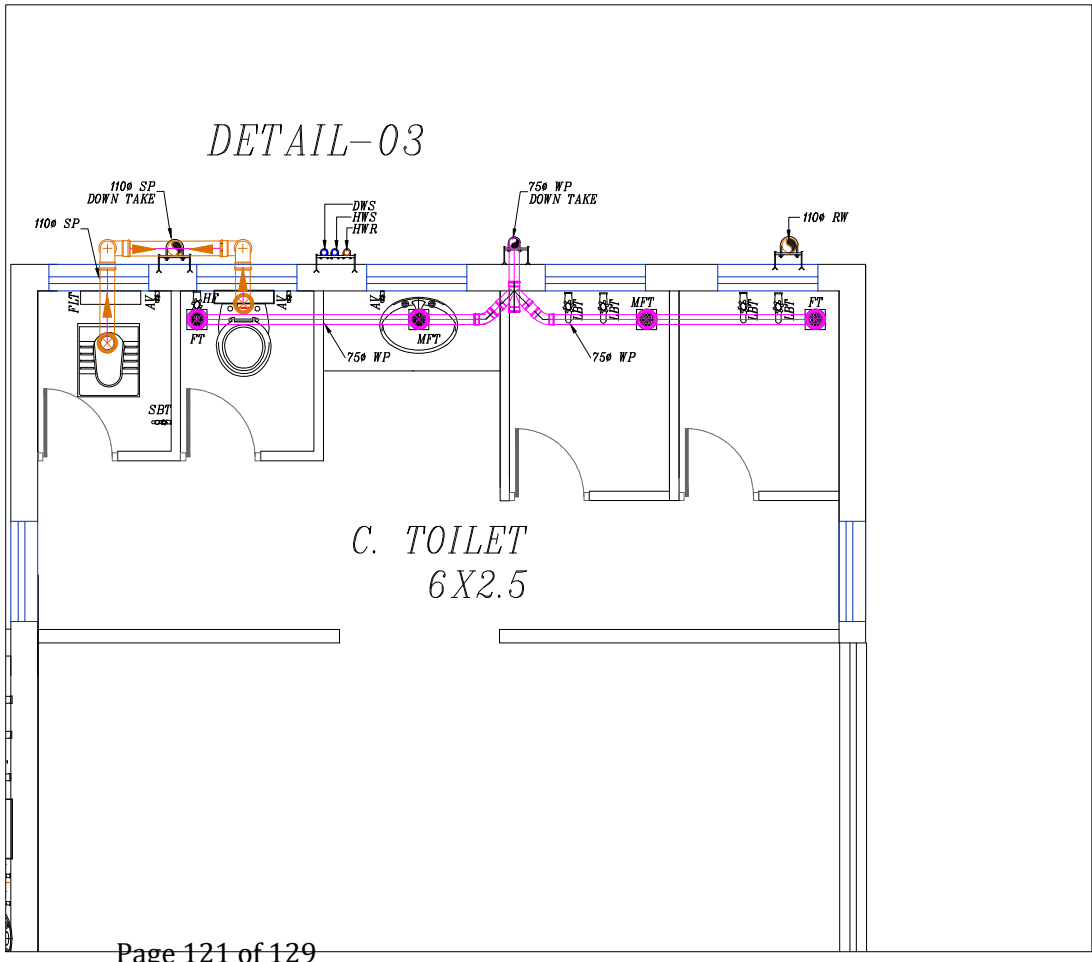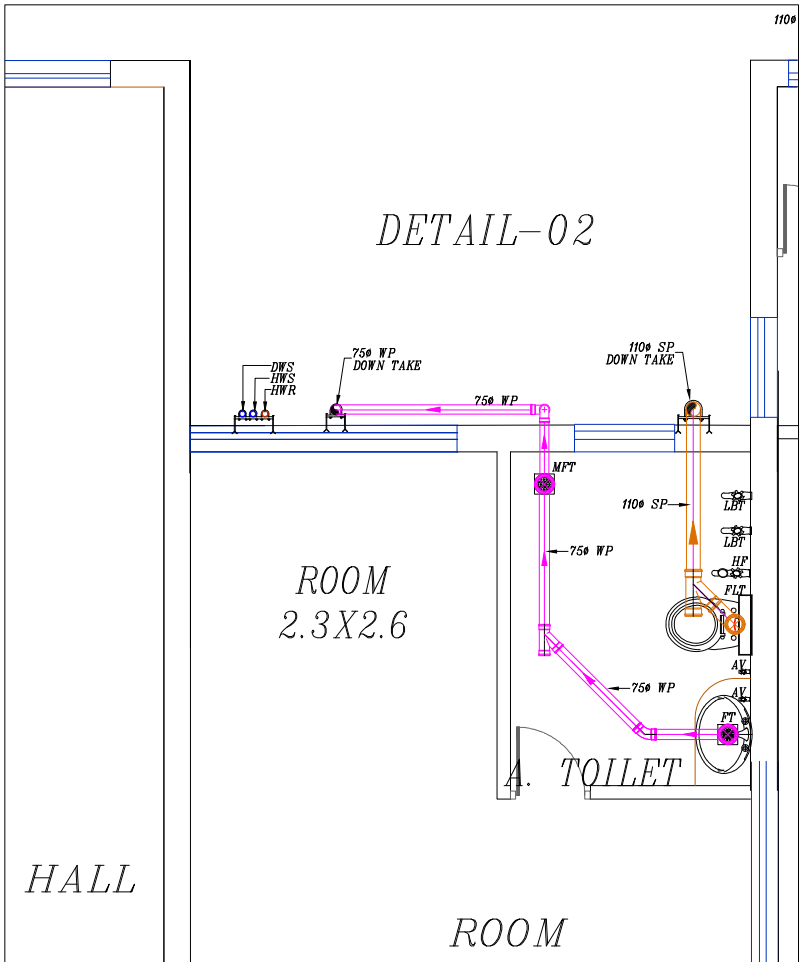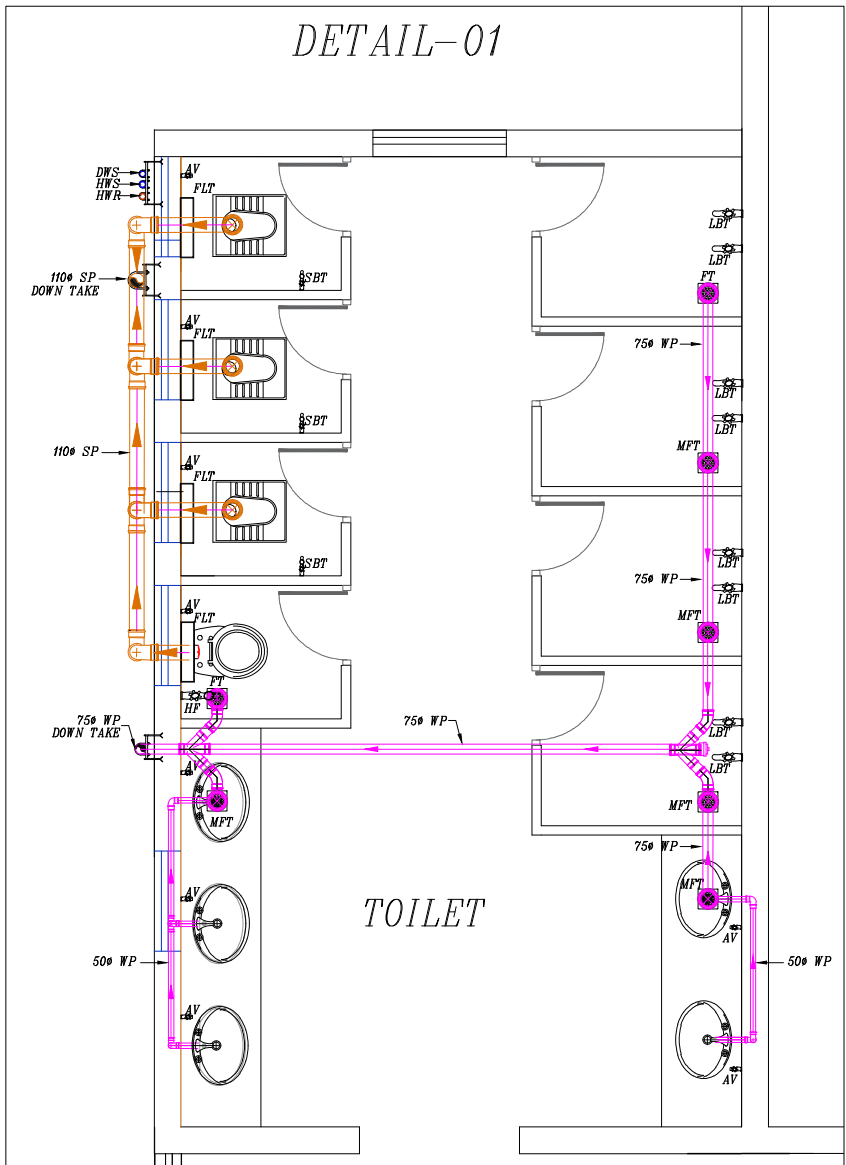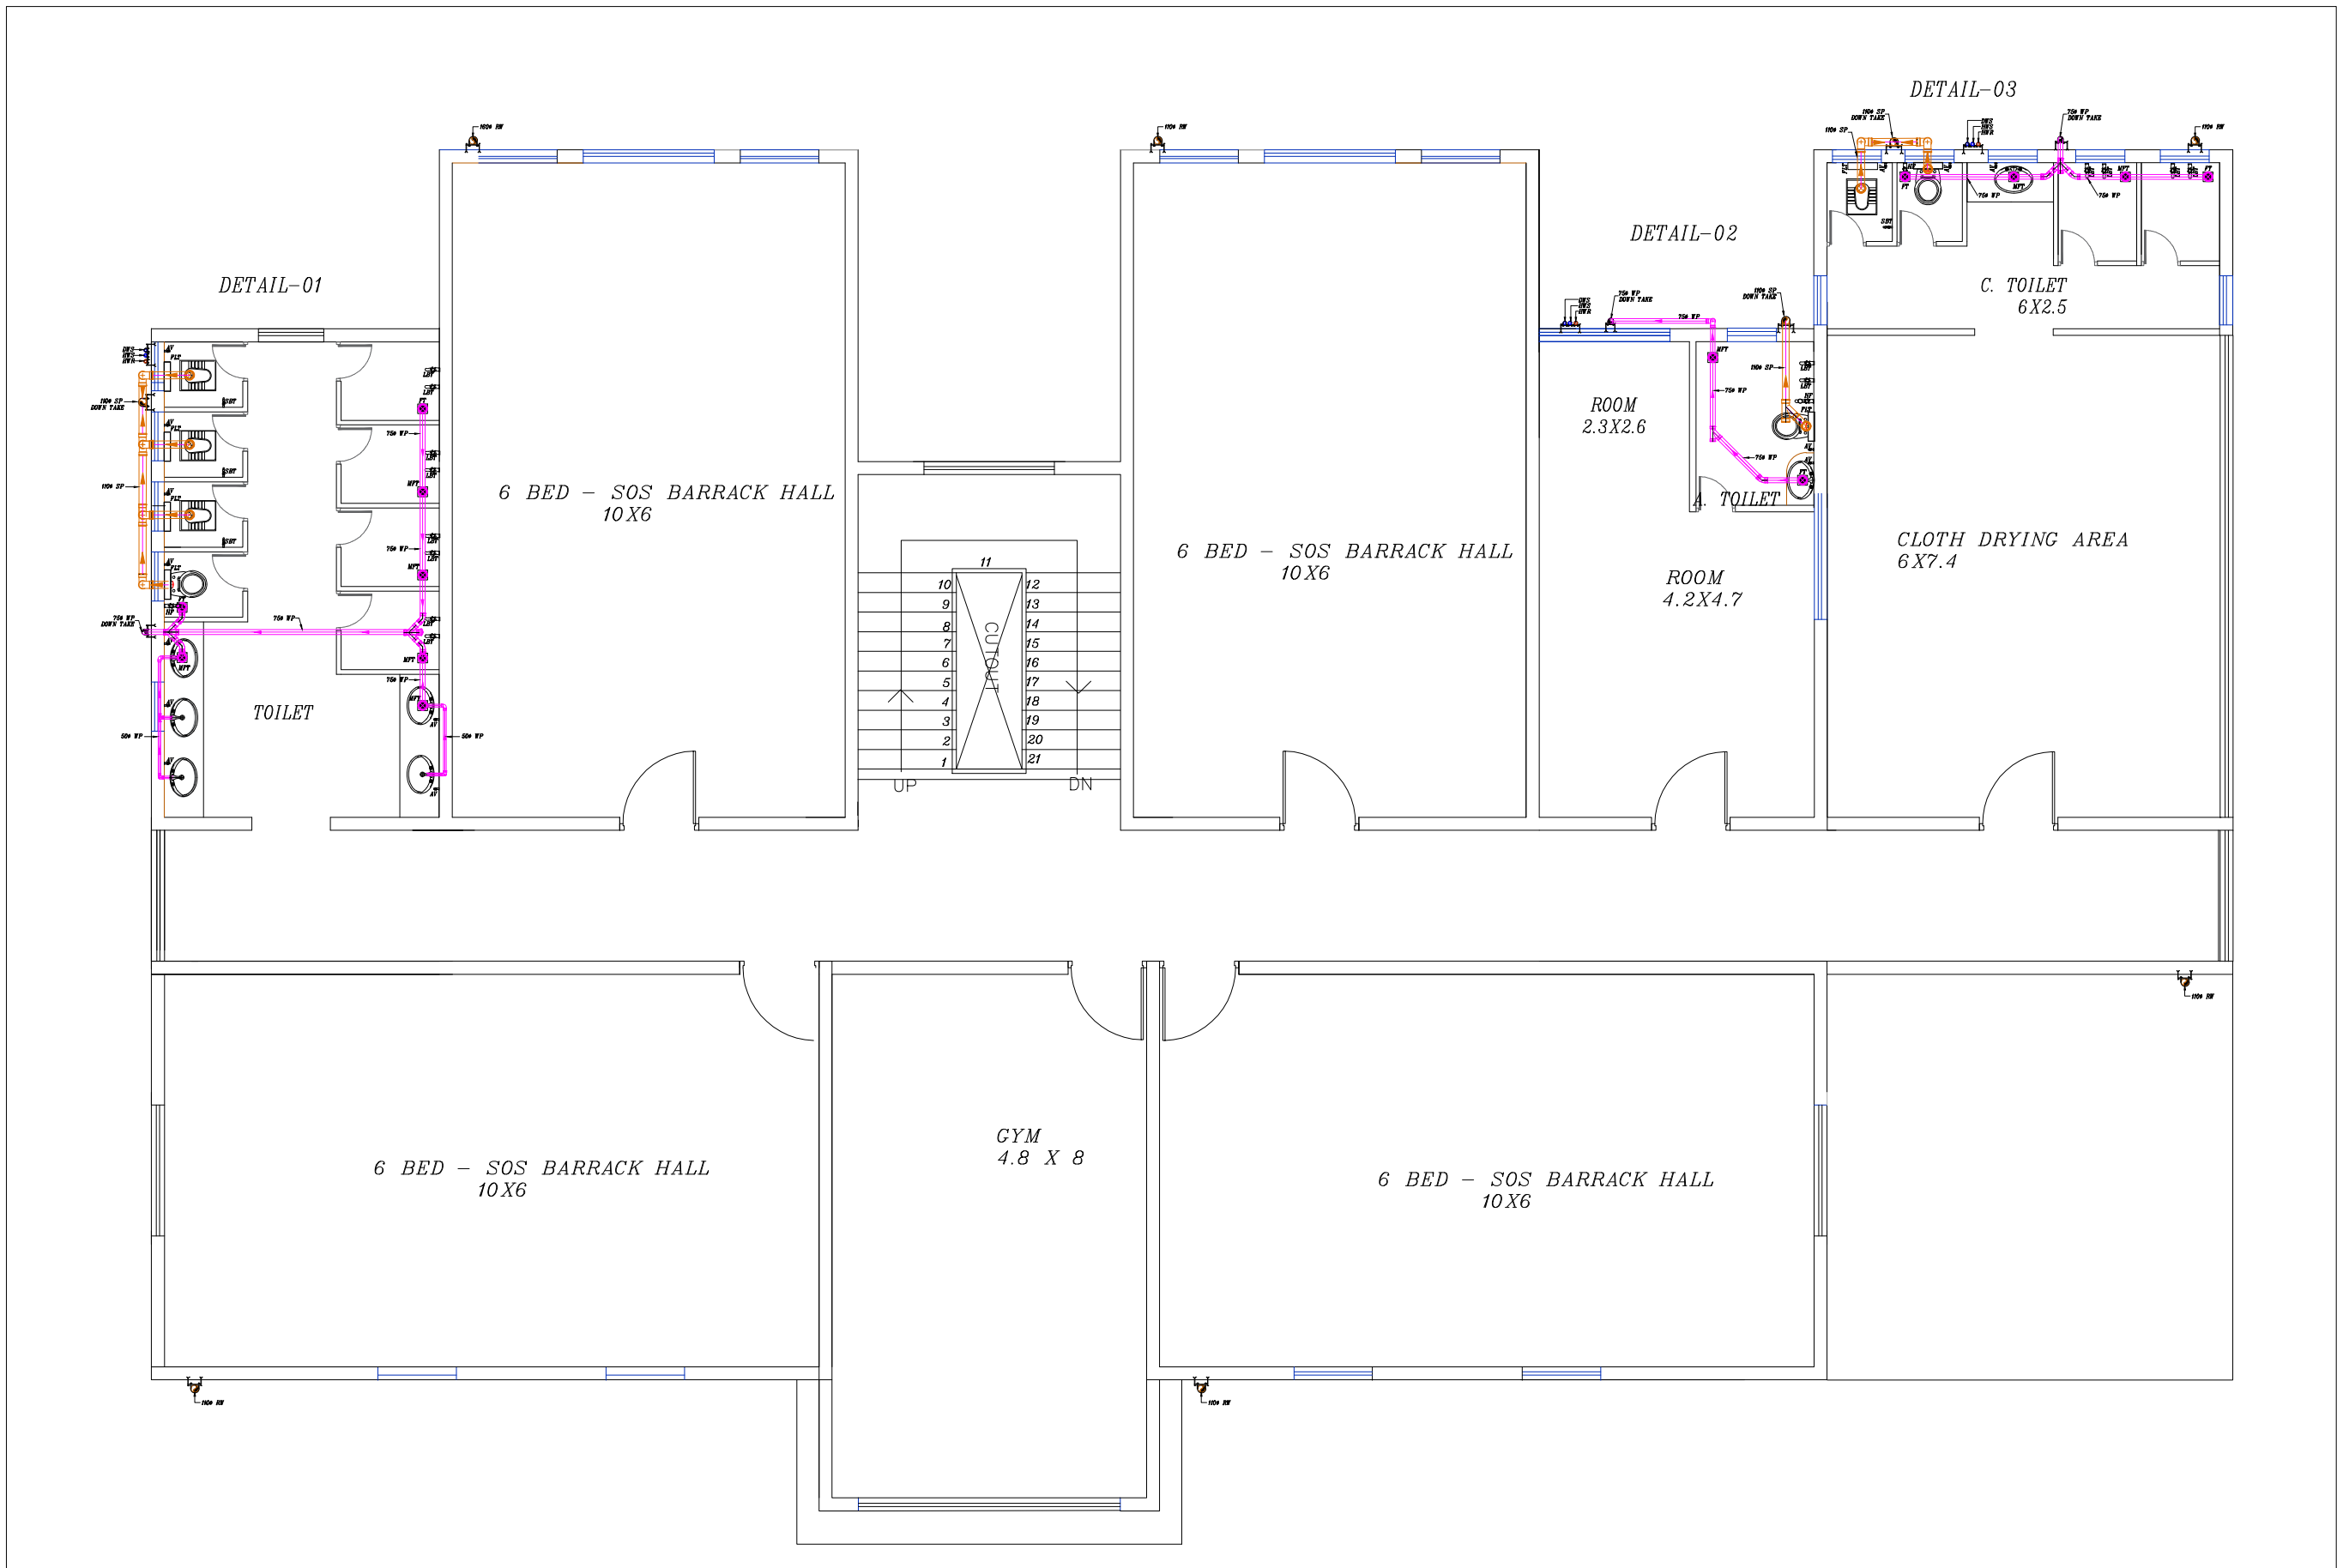



LEGEND			
01	EW		INDIAN WATER CLOSET
02	EW		EUROPEAN WATER CLOSET
03	HF		HEALTH FAUCET
04	WB		OVAL WASH BASIN
05	FT		FLOOR TRAP
06	MPT		MULTI INLET FLOOR TRAP
07	SSS		STAINLESS STEEL SINK
08	LBT		LONG BODY TAP
09	SBT		SHORT BODY TAP
10	AV		ANGLE VALVE
11	750 WP		750 WASTE PIPE
12	1100 SP		1100 SOIL PIPE
13	DWS RISER		DOMESTIC WATER SUPPLY RISER
14	HWS RISES		HOT WATER SUPPLY RISER
15	HWR RISER		HOT WATER RETURN RISER
16	HWS		HOT WATER SUPPLY
17	BY		BALL VALVE
18			PIPE REDUCER

TENDER DRAWINGS

PHE

SOIL AND WASTE WATER LINE

REV	DESCRIPTION	CHKD	DATE
DRAWING NO : ARCH001/PHE-04			
FILE NAME :			
Drawn : AV			
Checked : AMOL			REV.NO: R0
Approved : Ar.Anil.K.		SCALE : NTS	
DATE : 01-1-2025		JOB.NO:	
TITLE : PHE DRAWING			
THIRD FLOOR PLAN			
PROJECT TITLE:			
PROPOSED CONSTRUCTION OF BNPM - BARRACK			
ARCHITECTS :			
KULKARNI ASSOCIATES			
Consulting Architects, Engineers,Project Management Consultants			
Interior Designers & Regd. valuers			
Surya Prema Building,next to Adiga's Restaurant,Kanakapura Road			
No-203,2nd floor,Above Canara bank Raghuvanahalli Branch			
Raghuvanahalli Village,Uttarahalli hobli Bangalore-560062			
Email Id : kulkarni.associates@yahoo.com			

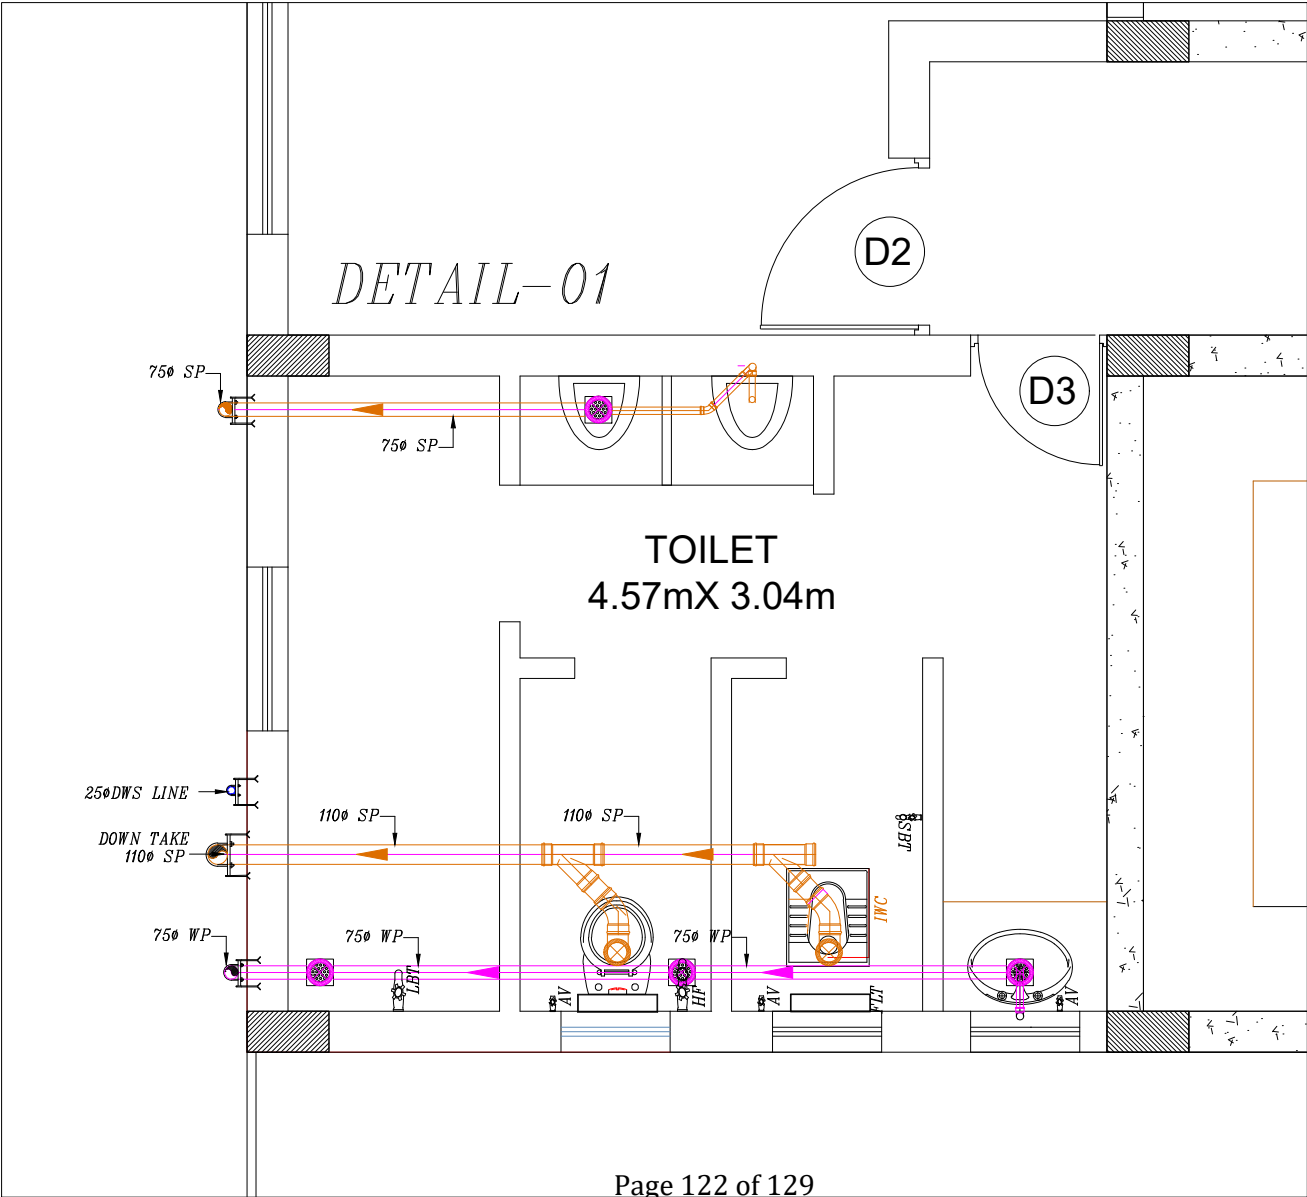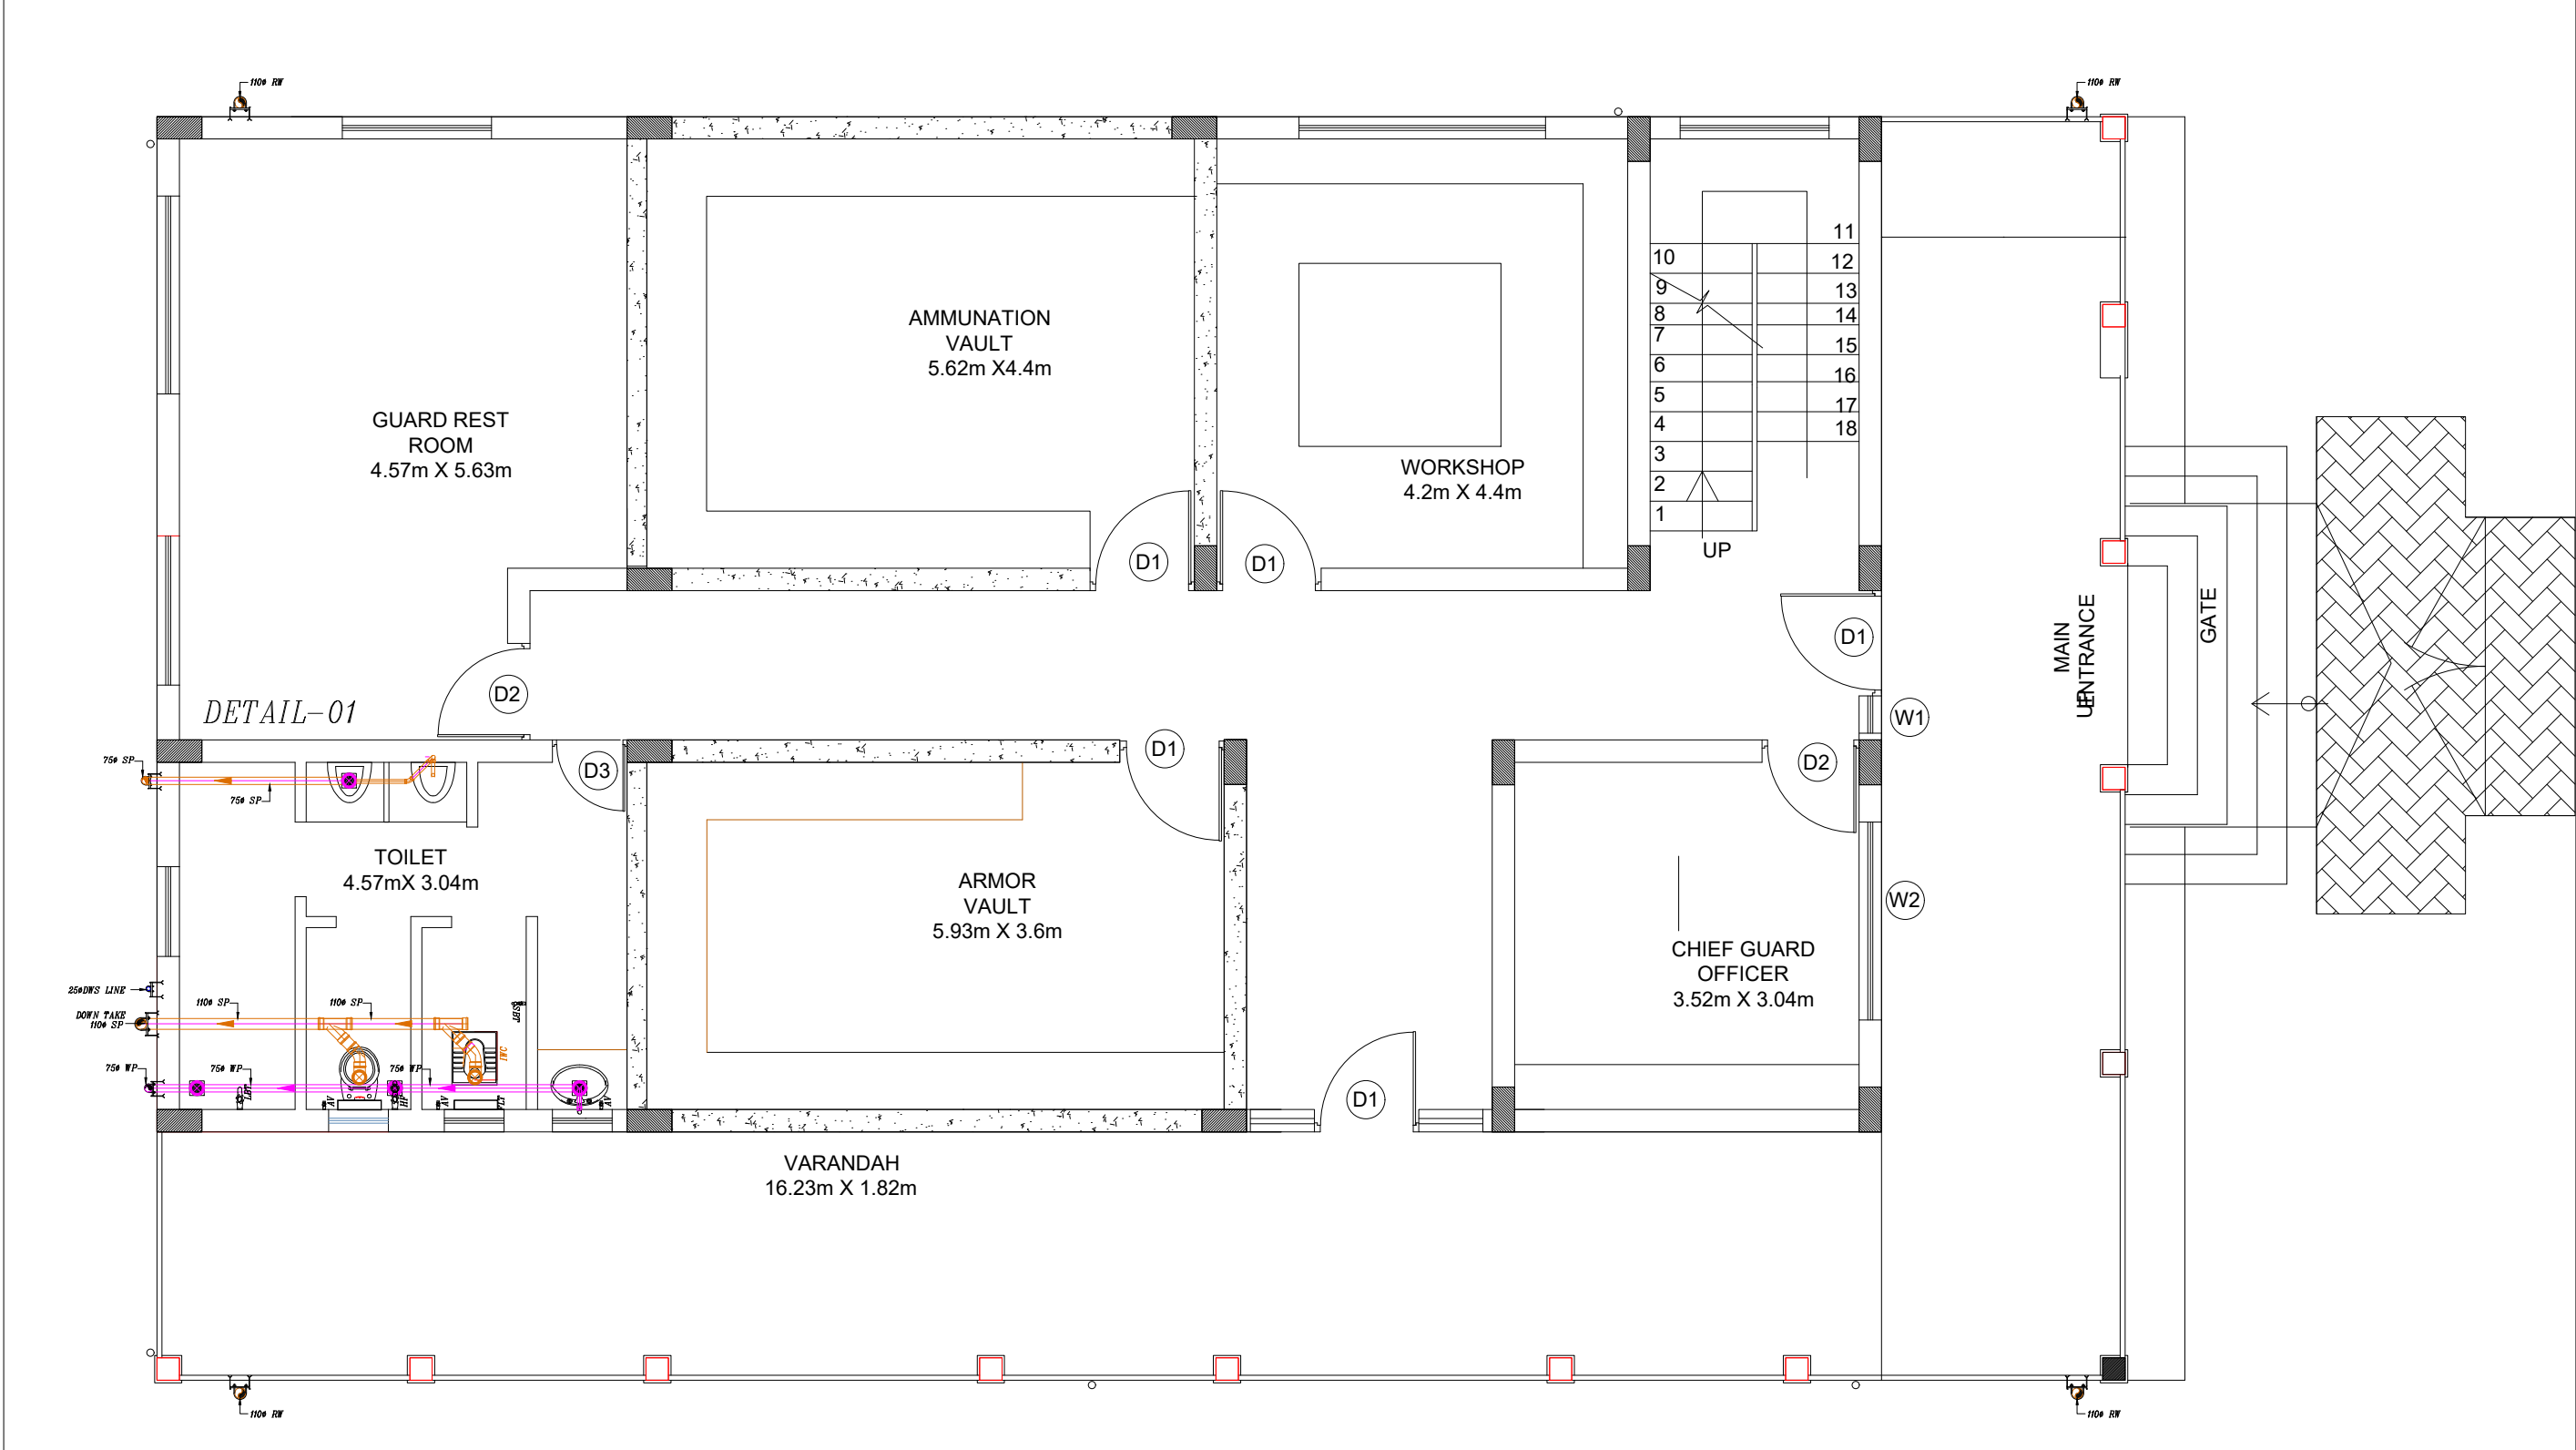

LEGEND		
01	EW	INDIAN WATER CLOSET
02	EW	EUROPEAN WATER CLOSET
03	HF	HEALTH FAUCET
04	WB	OVAL WASH BASIN
05	FT	FLOOR TRAP
06	MFT	MULTI INLET FLOOR TRAP
07	SSS	STAINLESS STEEL SINK
08	LBT	LONG BODY TAP
09	SBT	SHORT BODY TAP
10	AV	ANGLE VALVE
11	75 WP	75 WASTE PIPE
12	110 SP	110 SOIL PIPE
13	DWS RISER	DOMESTIC WATER SUPPLY RISER
14	HWS RISES	HOT WATER SUPPLY RISER
15	HWR RISER	HOT WATER RETURN RISER
16	HWS	HOT WATER SUPPLY
17	BV	BALL VALVE
18		PIPE REDUCER

TENDER DRAWINGS




PHE
SOIL AND WASTE WATER LINE

REV	DESCRIPTION	CHKD	DATE
	DRAWING NO : ARCH001/PHE-01		R0
	FILE NAME :		
	Drawn : AV		
	Checked : AMOL	REV.NO:	NTS
	Approved : Ar.Anil.K.	SCALE :	NTS
	DATE : 01-1-2025	JOB.NO:	

TITLE : PHE DRAWING
GROUND FLOOR PLAN

PROJECT TITLE:
PROPOSED CONSTRUCTION OF
BNPM - ARMOUR HOUSE

ARCHITECTS :
KULKARNI ASSOCIATES
Consulting Architects, Engineers, Project Management Consultants
Interior Designers & Regd. valuers
Surya Prema Building, next to Adiga's Restaurant, Kanakapura
Road
No-203, 2nd floor, Above Canara bank Raghuvanahalli Branch
Raghuvanahalli Village, Uttarahalli hobli Bangalore-560062
Email Id : kulkarni.associates@yahoo.com

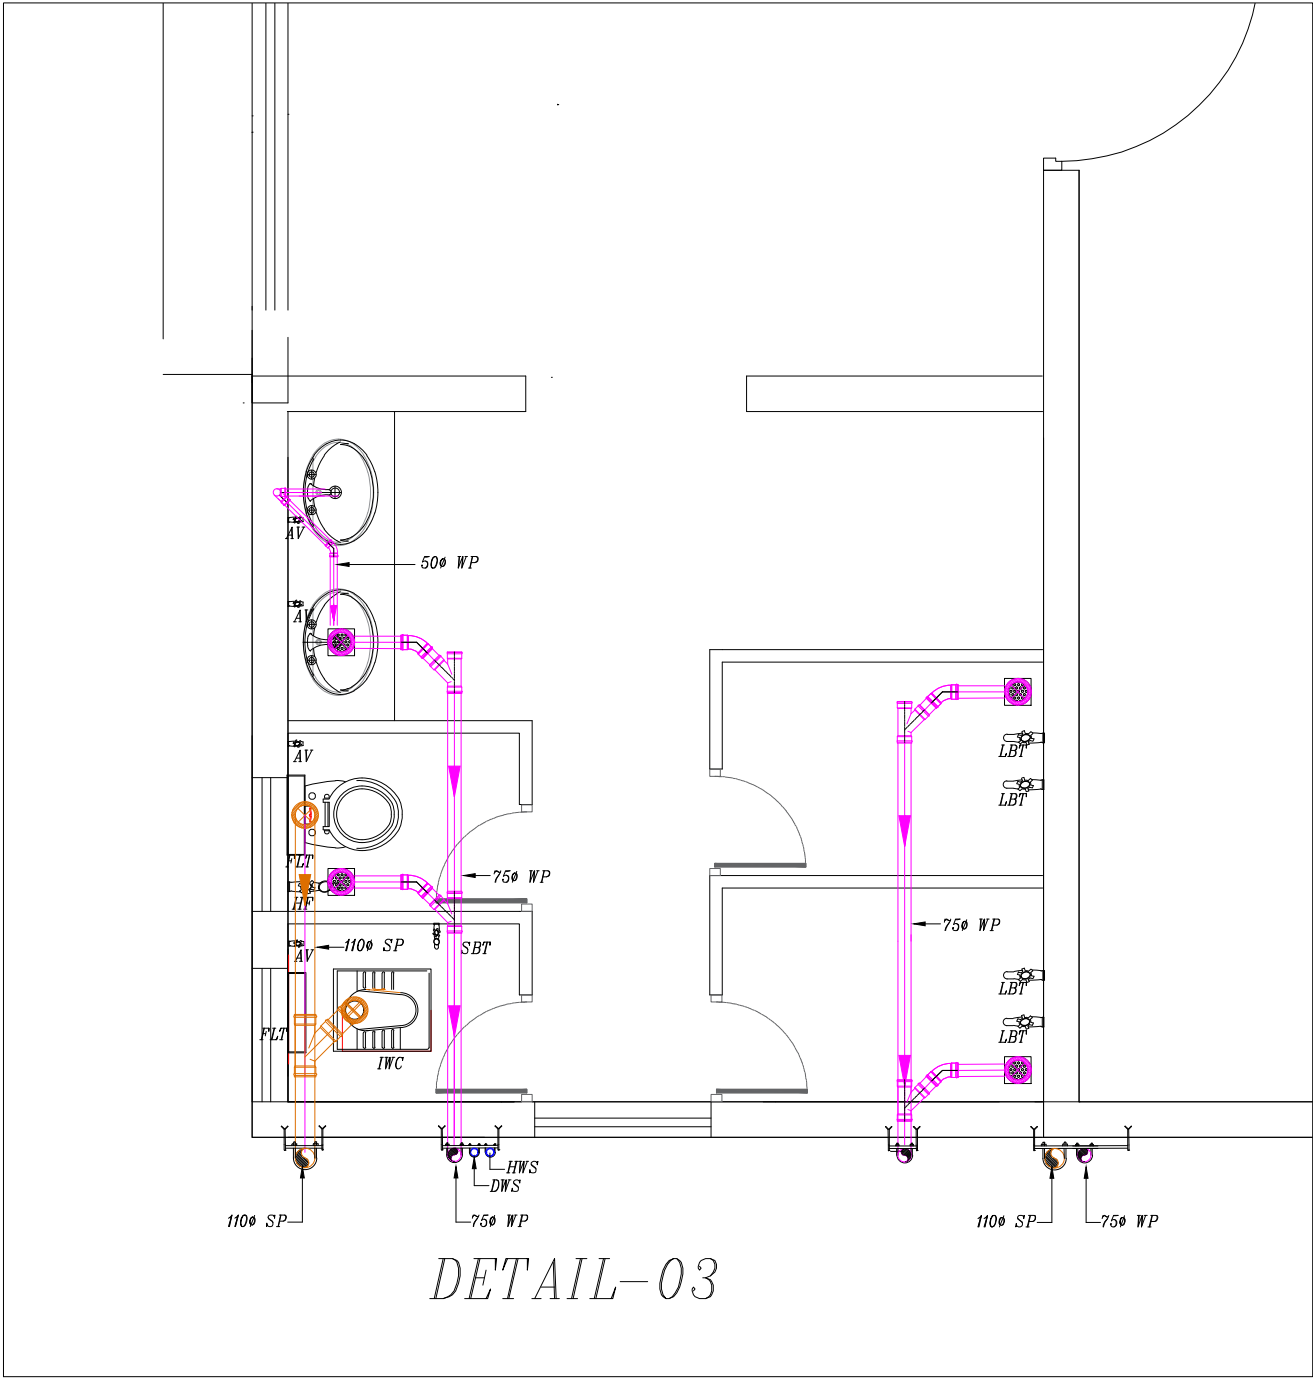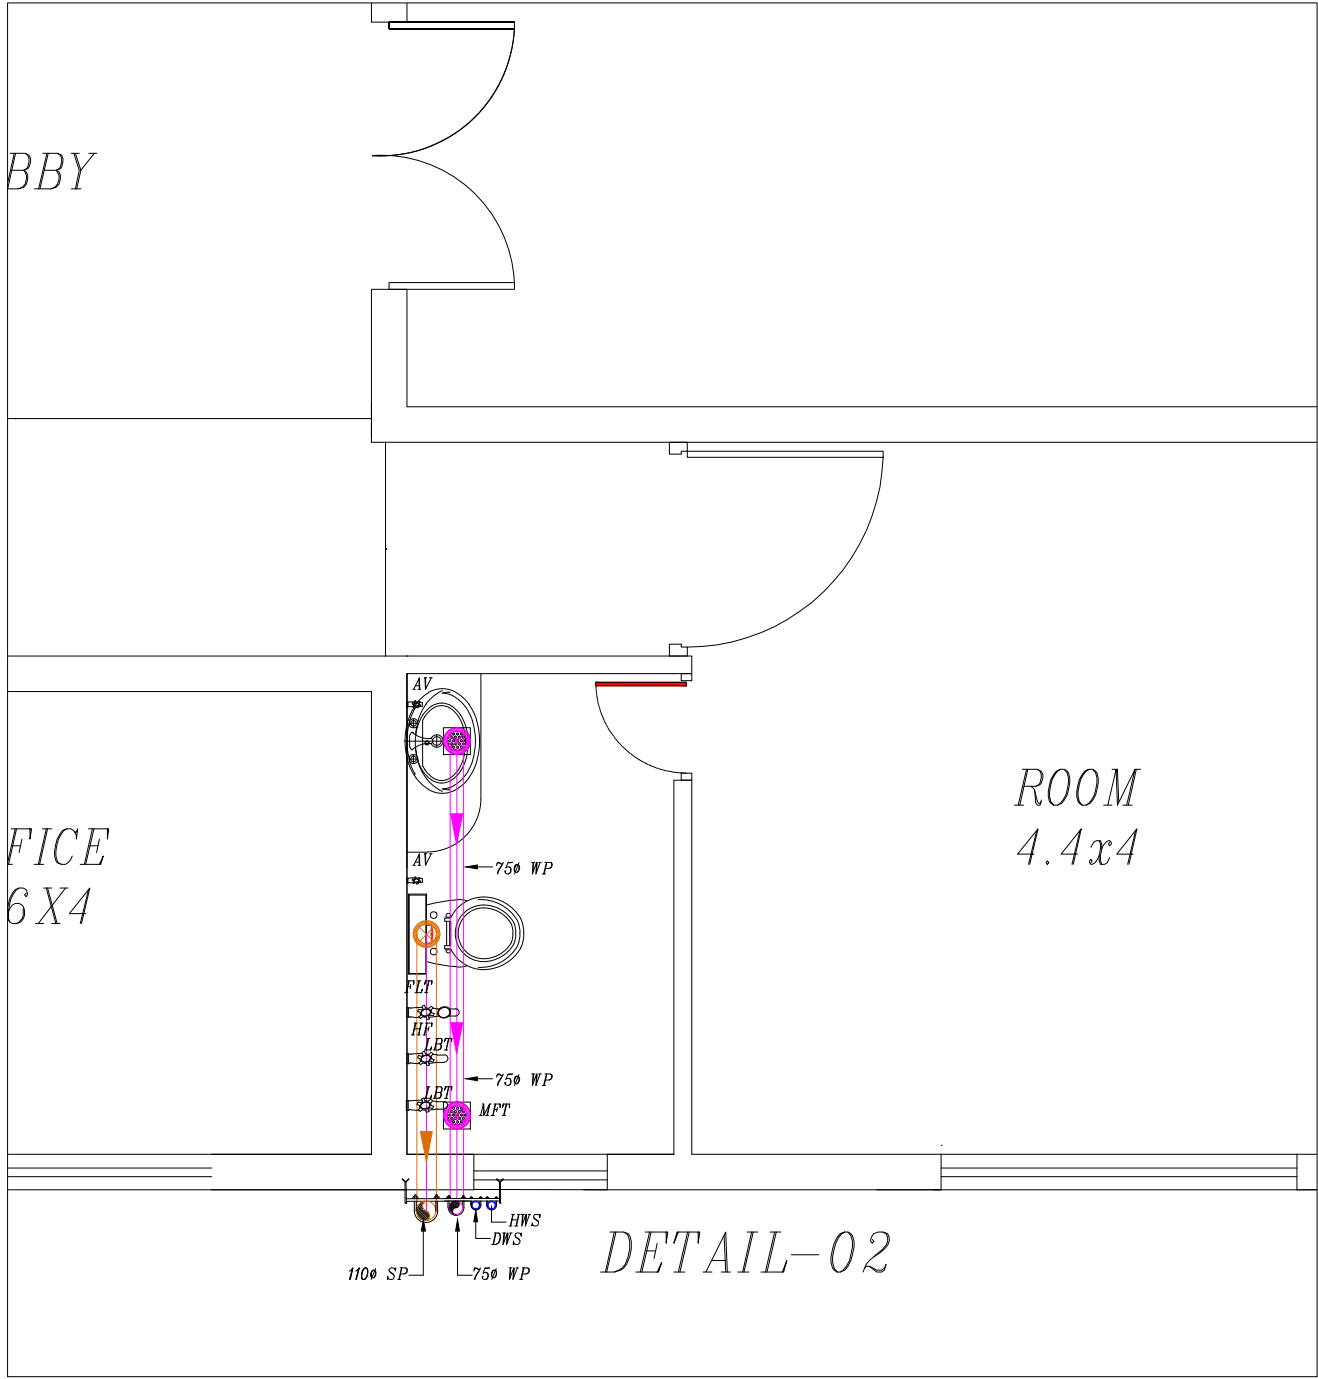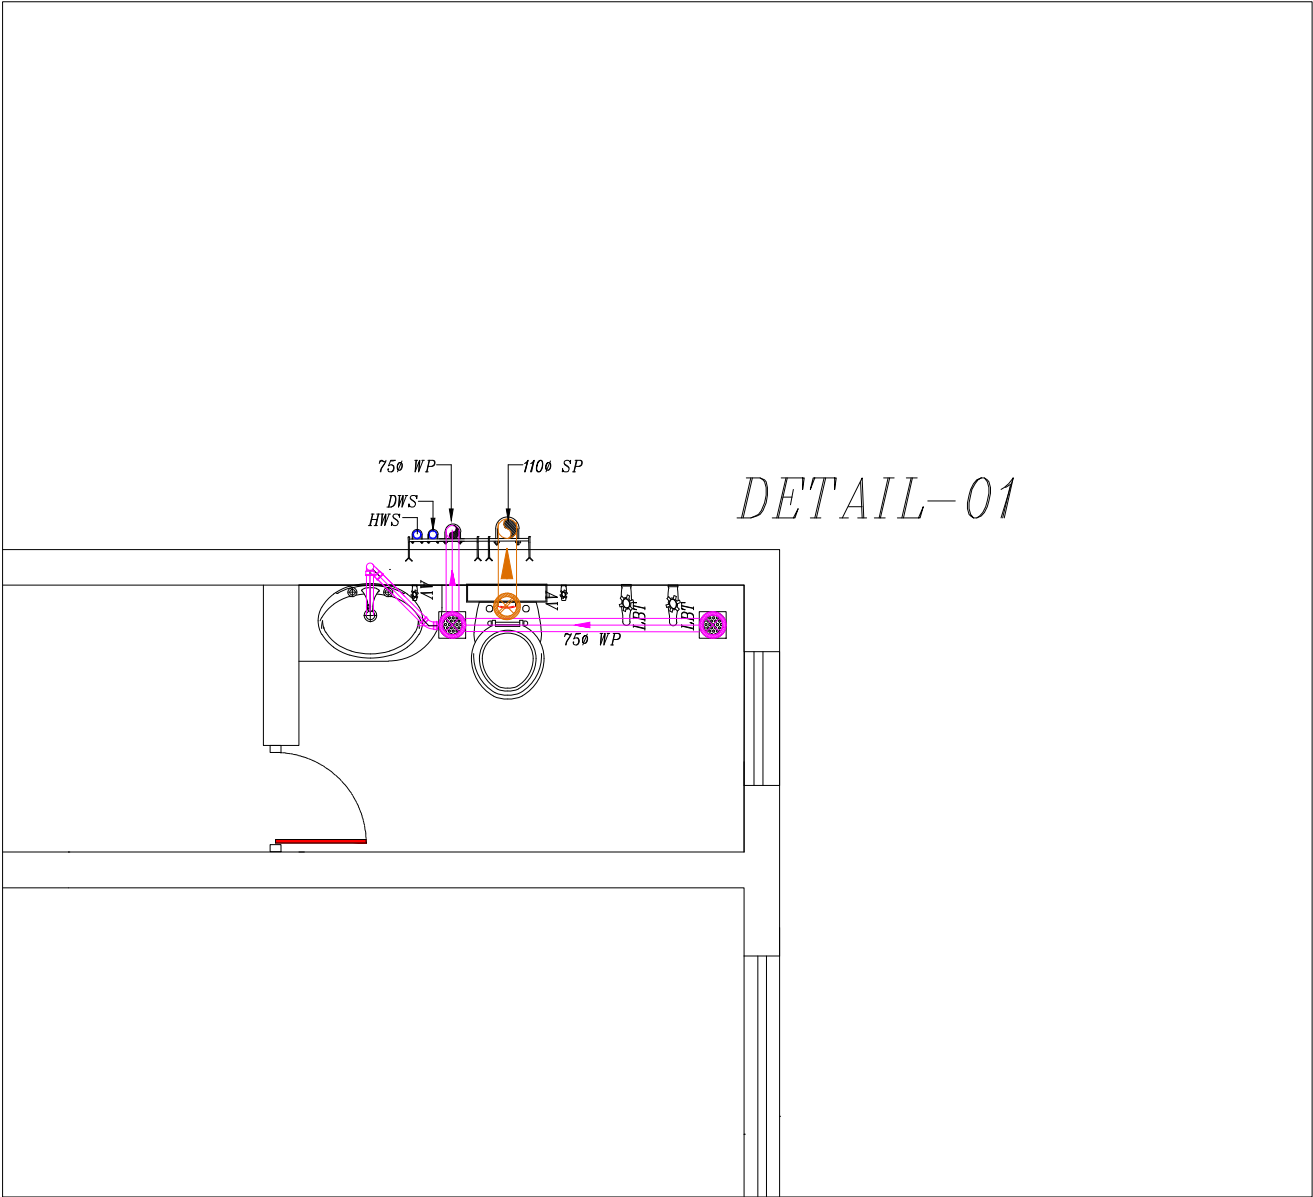


LEGEND		
01	EWC	INDIAN WATER CLOSET
02	EWC	EUROPEAN WATER CLOSET
03	HF	HEALTH FAUCET
04	WB	OVAL WASH BASIN
05	FT	FLOOR TRAP
06	MPT	MULTI INLET FLOOR TRAP
07	SSS	STAINLESS STEEL SINK
08	LBT	LONG BODY TAP
09	SBT	SHORT BODY TAP
10	AV	ANGLE VALVE
11	750 WP	750 WASTE PIPE
12	1100 SP	1100 SOIL PIPE
13	DWS RISER	DOMESTIC WATER SUPPLY RISER
14	HWS RISES	HOT WATER SUPPLY RISER
15	HWR RISER	HOT WATER RETURN RISER
16	HWS	HOT WATER SUPPLY
17	BY	BALL VALVE
18		PIPE REDUCER

TENDER DRAWINGS

PHE

SOIL AND WASTE WATER LINE

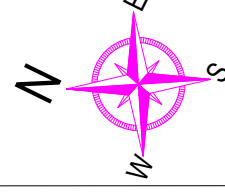REV	DESCRIPTION	CHKD	DATE
DRAWING NO : ARCH001/PHE-01			
FILE NAME :			
Drawn : AV			
Checked : AMOL		REV.NO: R0	
Approved : Ar.Anil.K.		SCALE : NTS	
DATE : 01-1-2025		JOB.NO:	

TITLE : PHE DRAWING

GROUND & FIRST FLOOR PLAN


PROJECT TITLE:

PROPOSED CONSTRUCTION OF
BNPM - LADIES- BARRACK

ARCHITECTS :

KULKARNI ASSOCIATES

Consulting Architects, Engineers,Project Management Consultants
Interior Designers & Regd. valuers
Surya Prema Building,next to Adiga's Restaurant,Kanakapura
Road
No-203,2nd floor,Above Canara bank Raghuvanahalli Branch
Raghuvanahalli Village,Uttarahalli hobli Bangalore-560062
Email Id : kulkarni.associates@yahoo.com

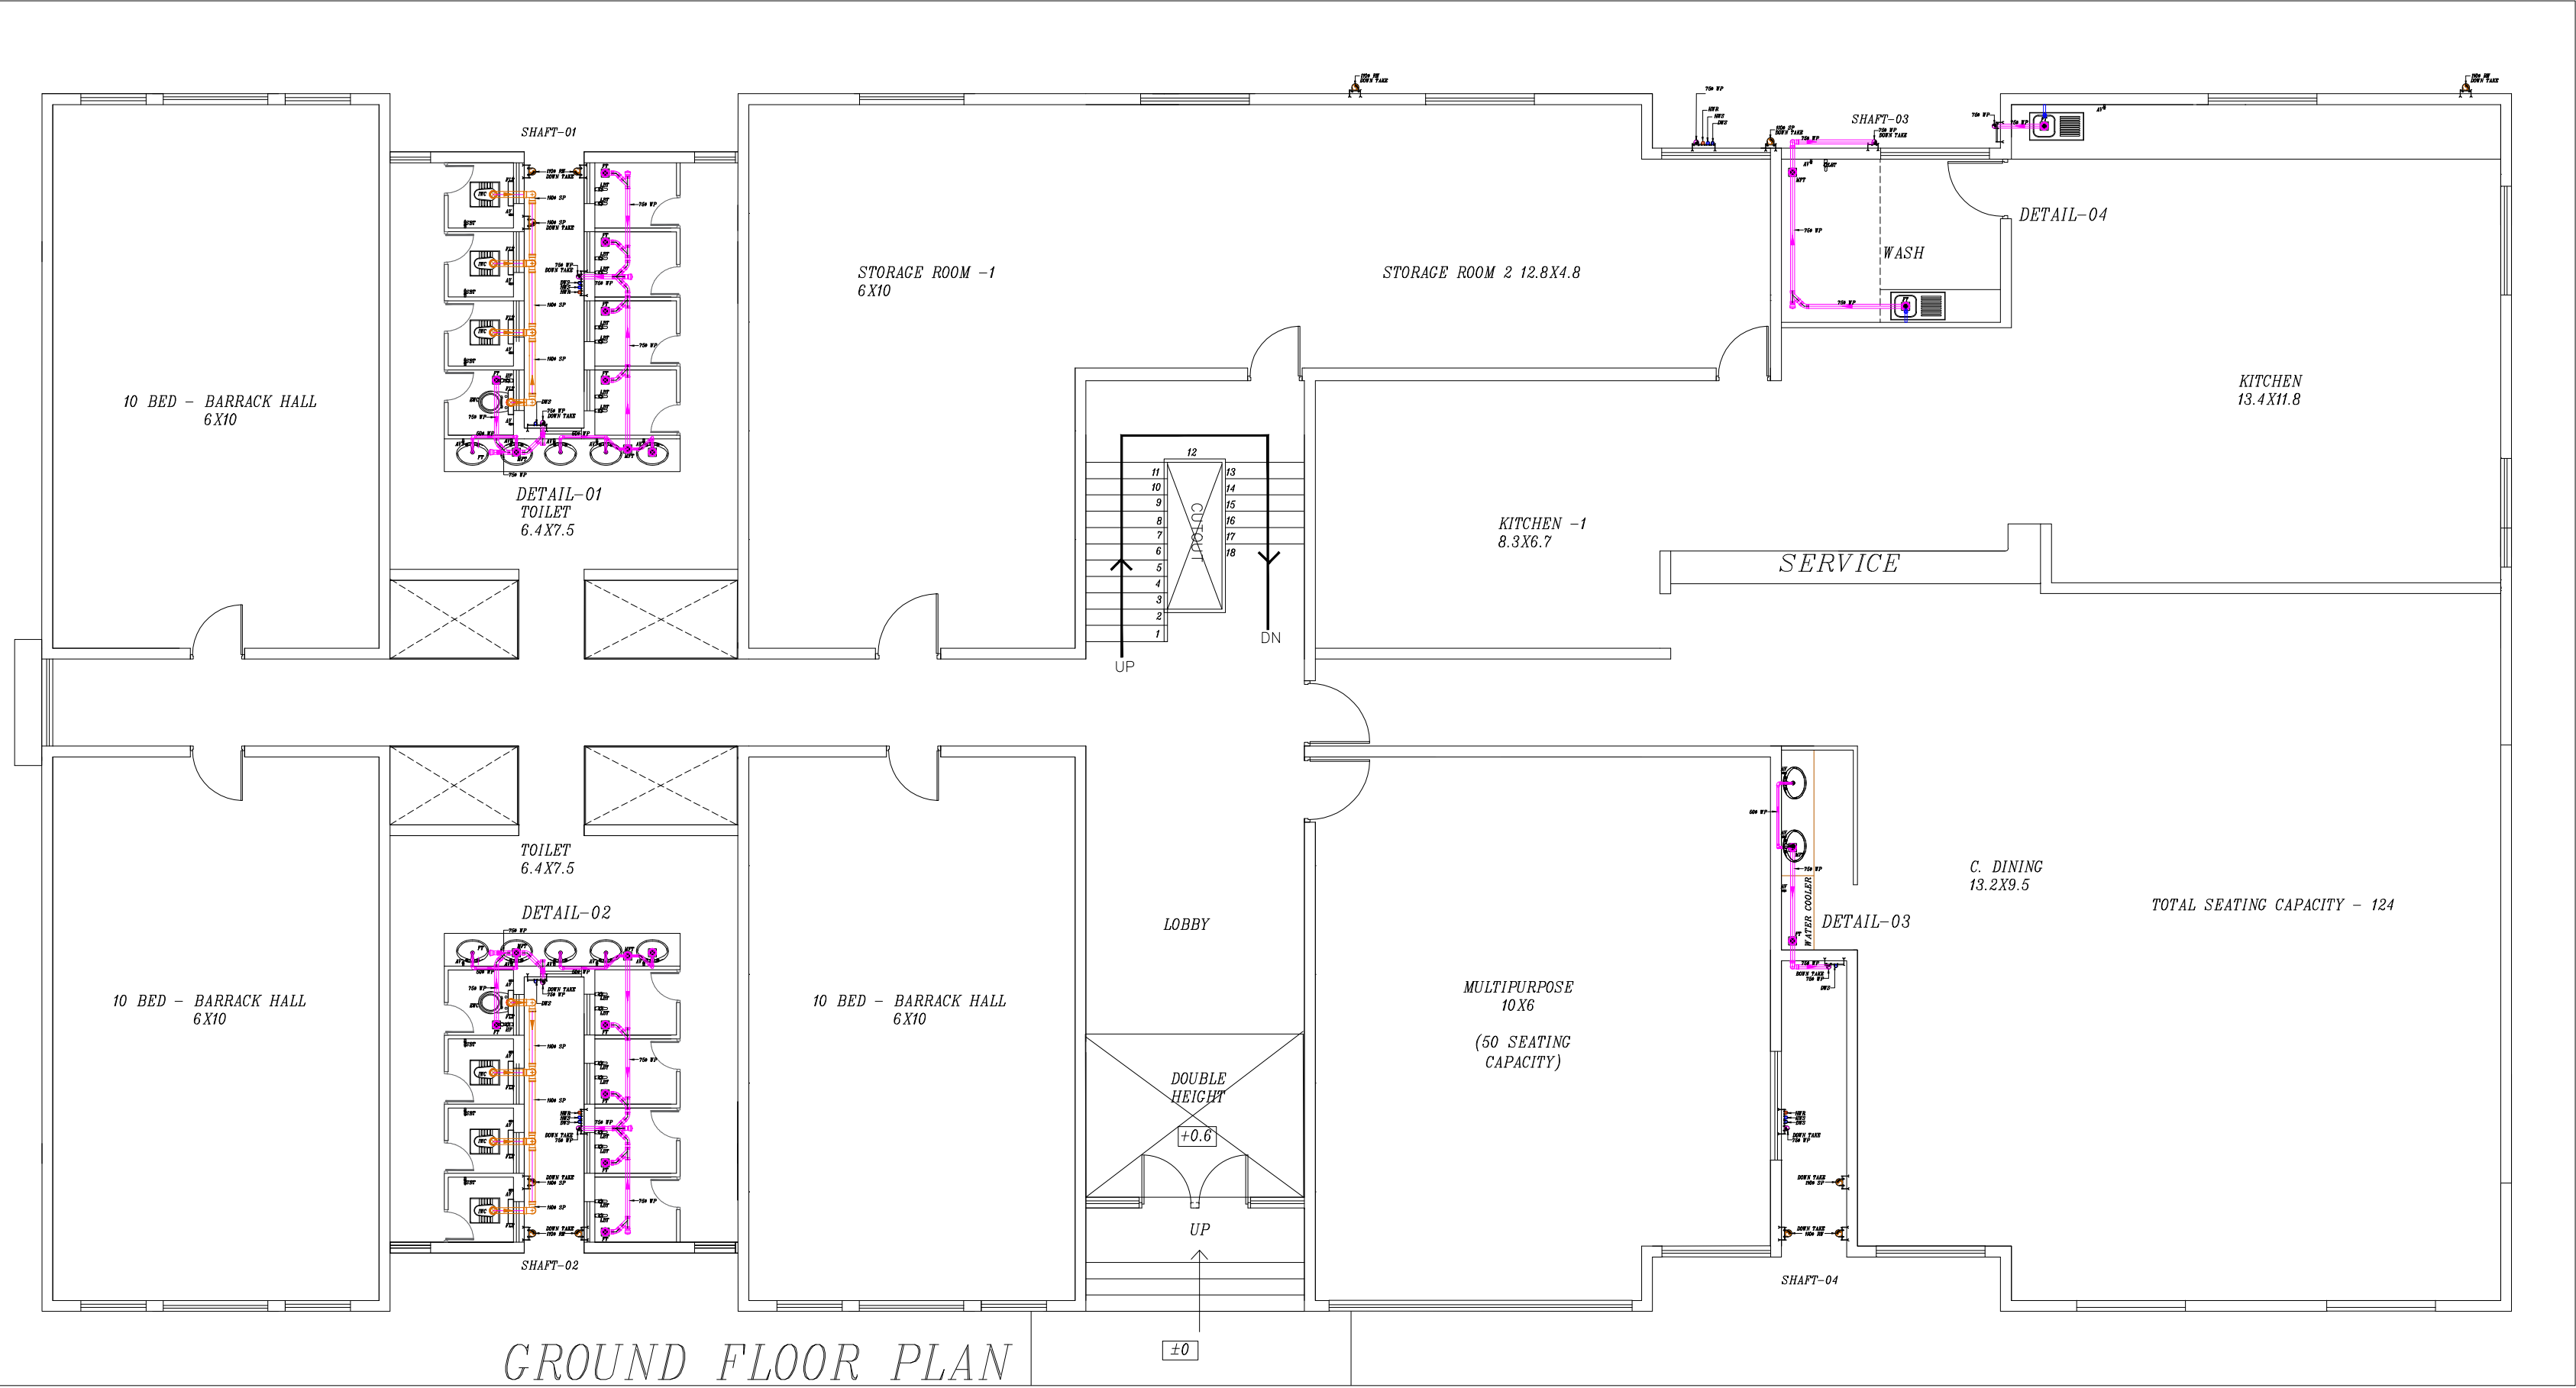


LEGEND			
01	EWC		INDIAN WATER CLOSET
02	EWC		EUROPEAN WATER CLOSET
03	HF		HEALTH FAUCET
04	WB		OVAL WASH BASIN
05	FT		FLOOR TRAP
06	MPT		MULTI INLET FLOOR TRAP
07	SSS		STAINLESS STEEL SINK
08	LBT		LONG BODY TAP
09	SBT		SHORT BODY TAP
10	AV		ANGLE VALVE
11	750 WP		750 WASTE PIPE
12	1100 SP		1100 SOIL PIPE
13	DWS RISER		DOMESTIC WATER SUPPLY RISER
14	HWS RISES		HOT WATER SUPPLY RISER
15	HWR RISER		HOT WATER RETURN RISER
16	HWS		HOT WATER SUPPLY
17	BY		BALL VALVE
18			PIPE REDUCER

TENDER DRAWINGS

PHE

SOIL AND WASTE WATER LINE

REV	DESCRIPTION	CHKD	DATE
DRAWING NO : ARCH001/PHE-01			
FILE NAME :			
Drawn : AV			
Checked : AMOL			
Approved : Ar.Anil.K.			
DATE : 01-1-2025			
REV.NO: R0			
SCALE : NTS			
JOB.NO:			

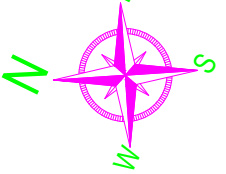

TITLE : PHE DRAWING
GROUND FLOOR PLAN





PROJECT TITLE:


PROPOSED CONSTRUCTION OF
BRBNMPL - BARRACK

ARCHITECTS :

KULKARNI ASSOCIATES





Consulting Architects, Engineers,Project Management Consultants
Interior Designers & Regd. valuers
Surya Prema Building,next to Adiga's Restaurant,Kanakapura Road
No-203,2nd floor,Above Canara bank Raghuvanahalli Branch
Raghuvanahalli Village,Uttarahalli hobli Bangalore-560062
Email Id : kulkarni.associates@yahoo.com

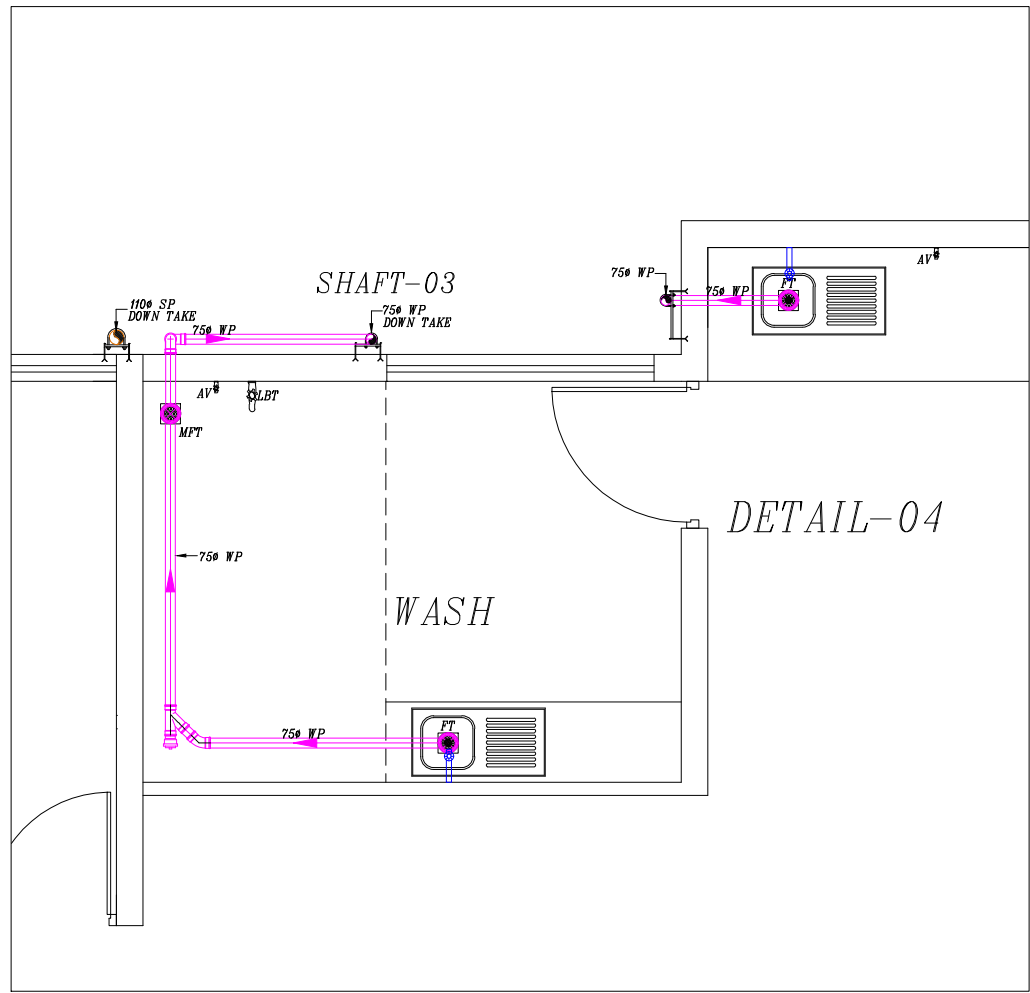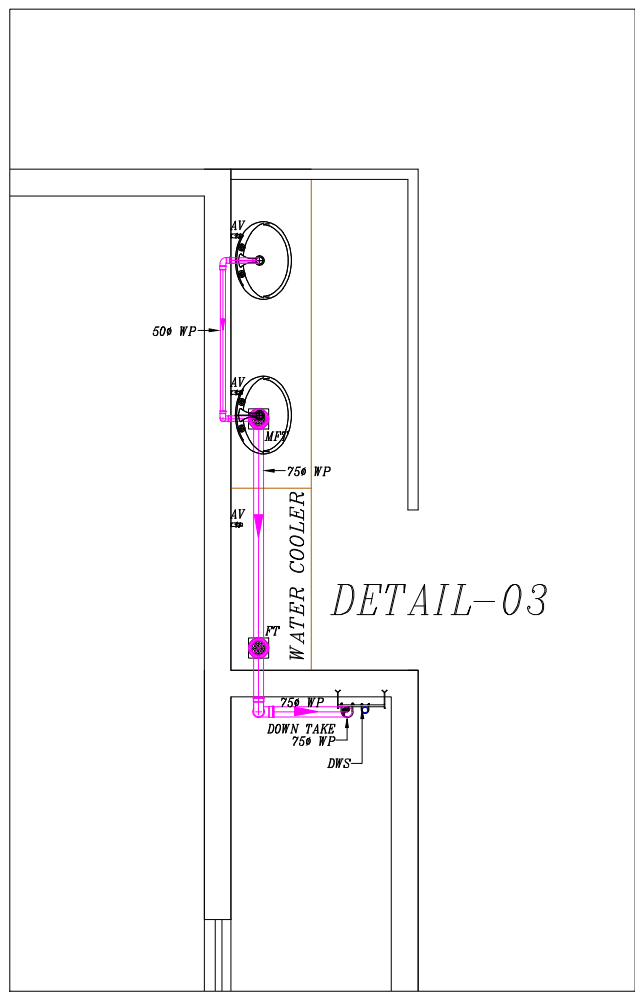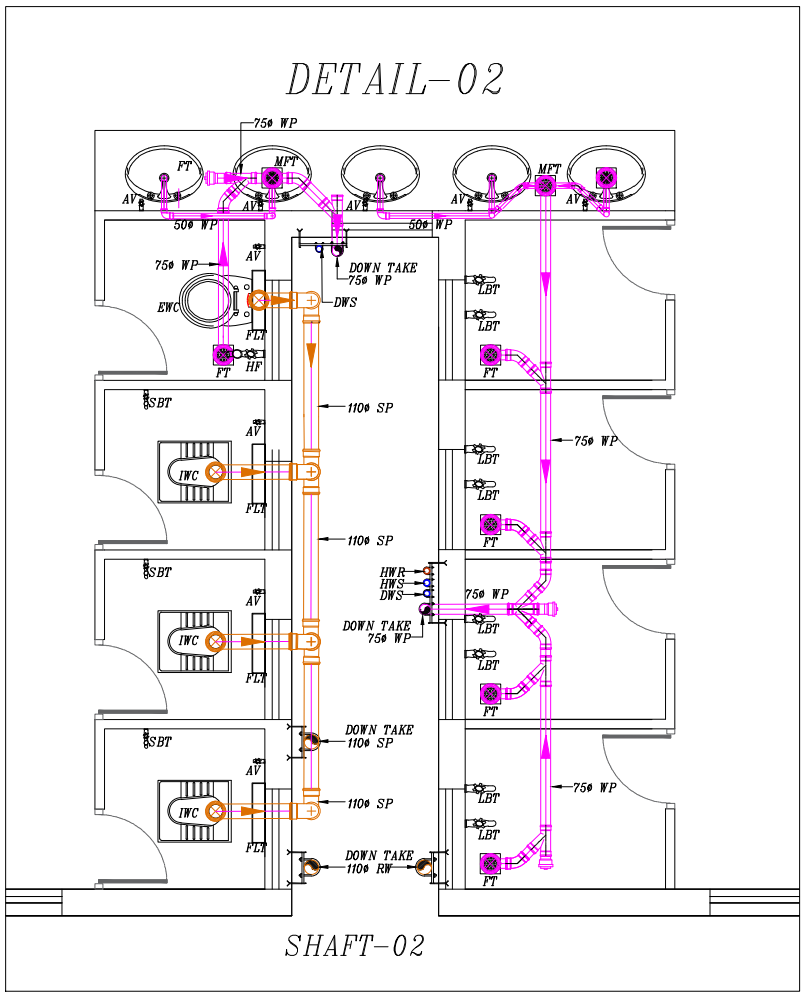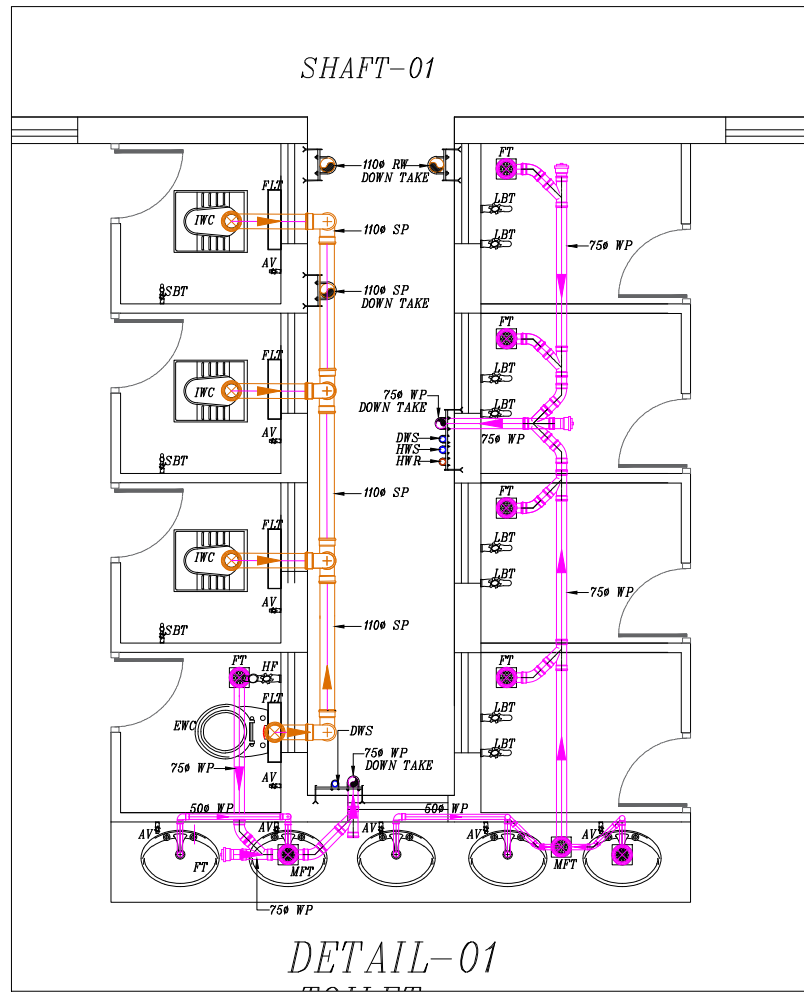

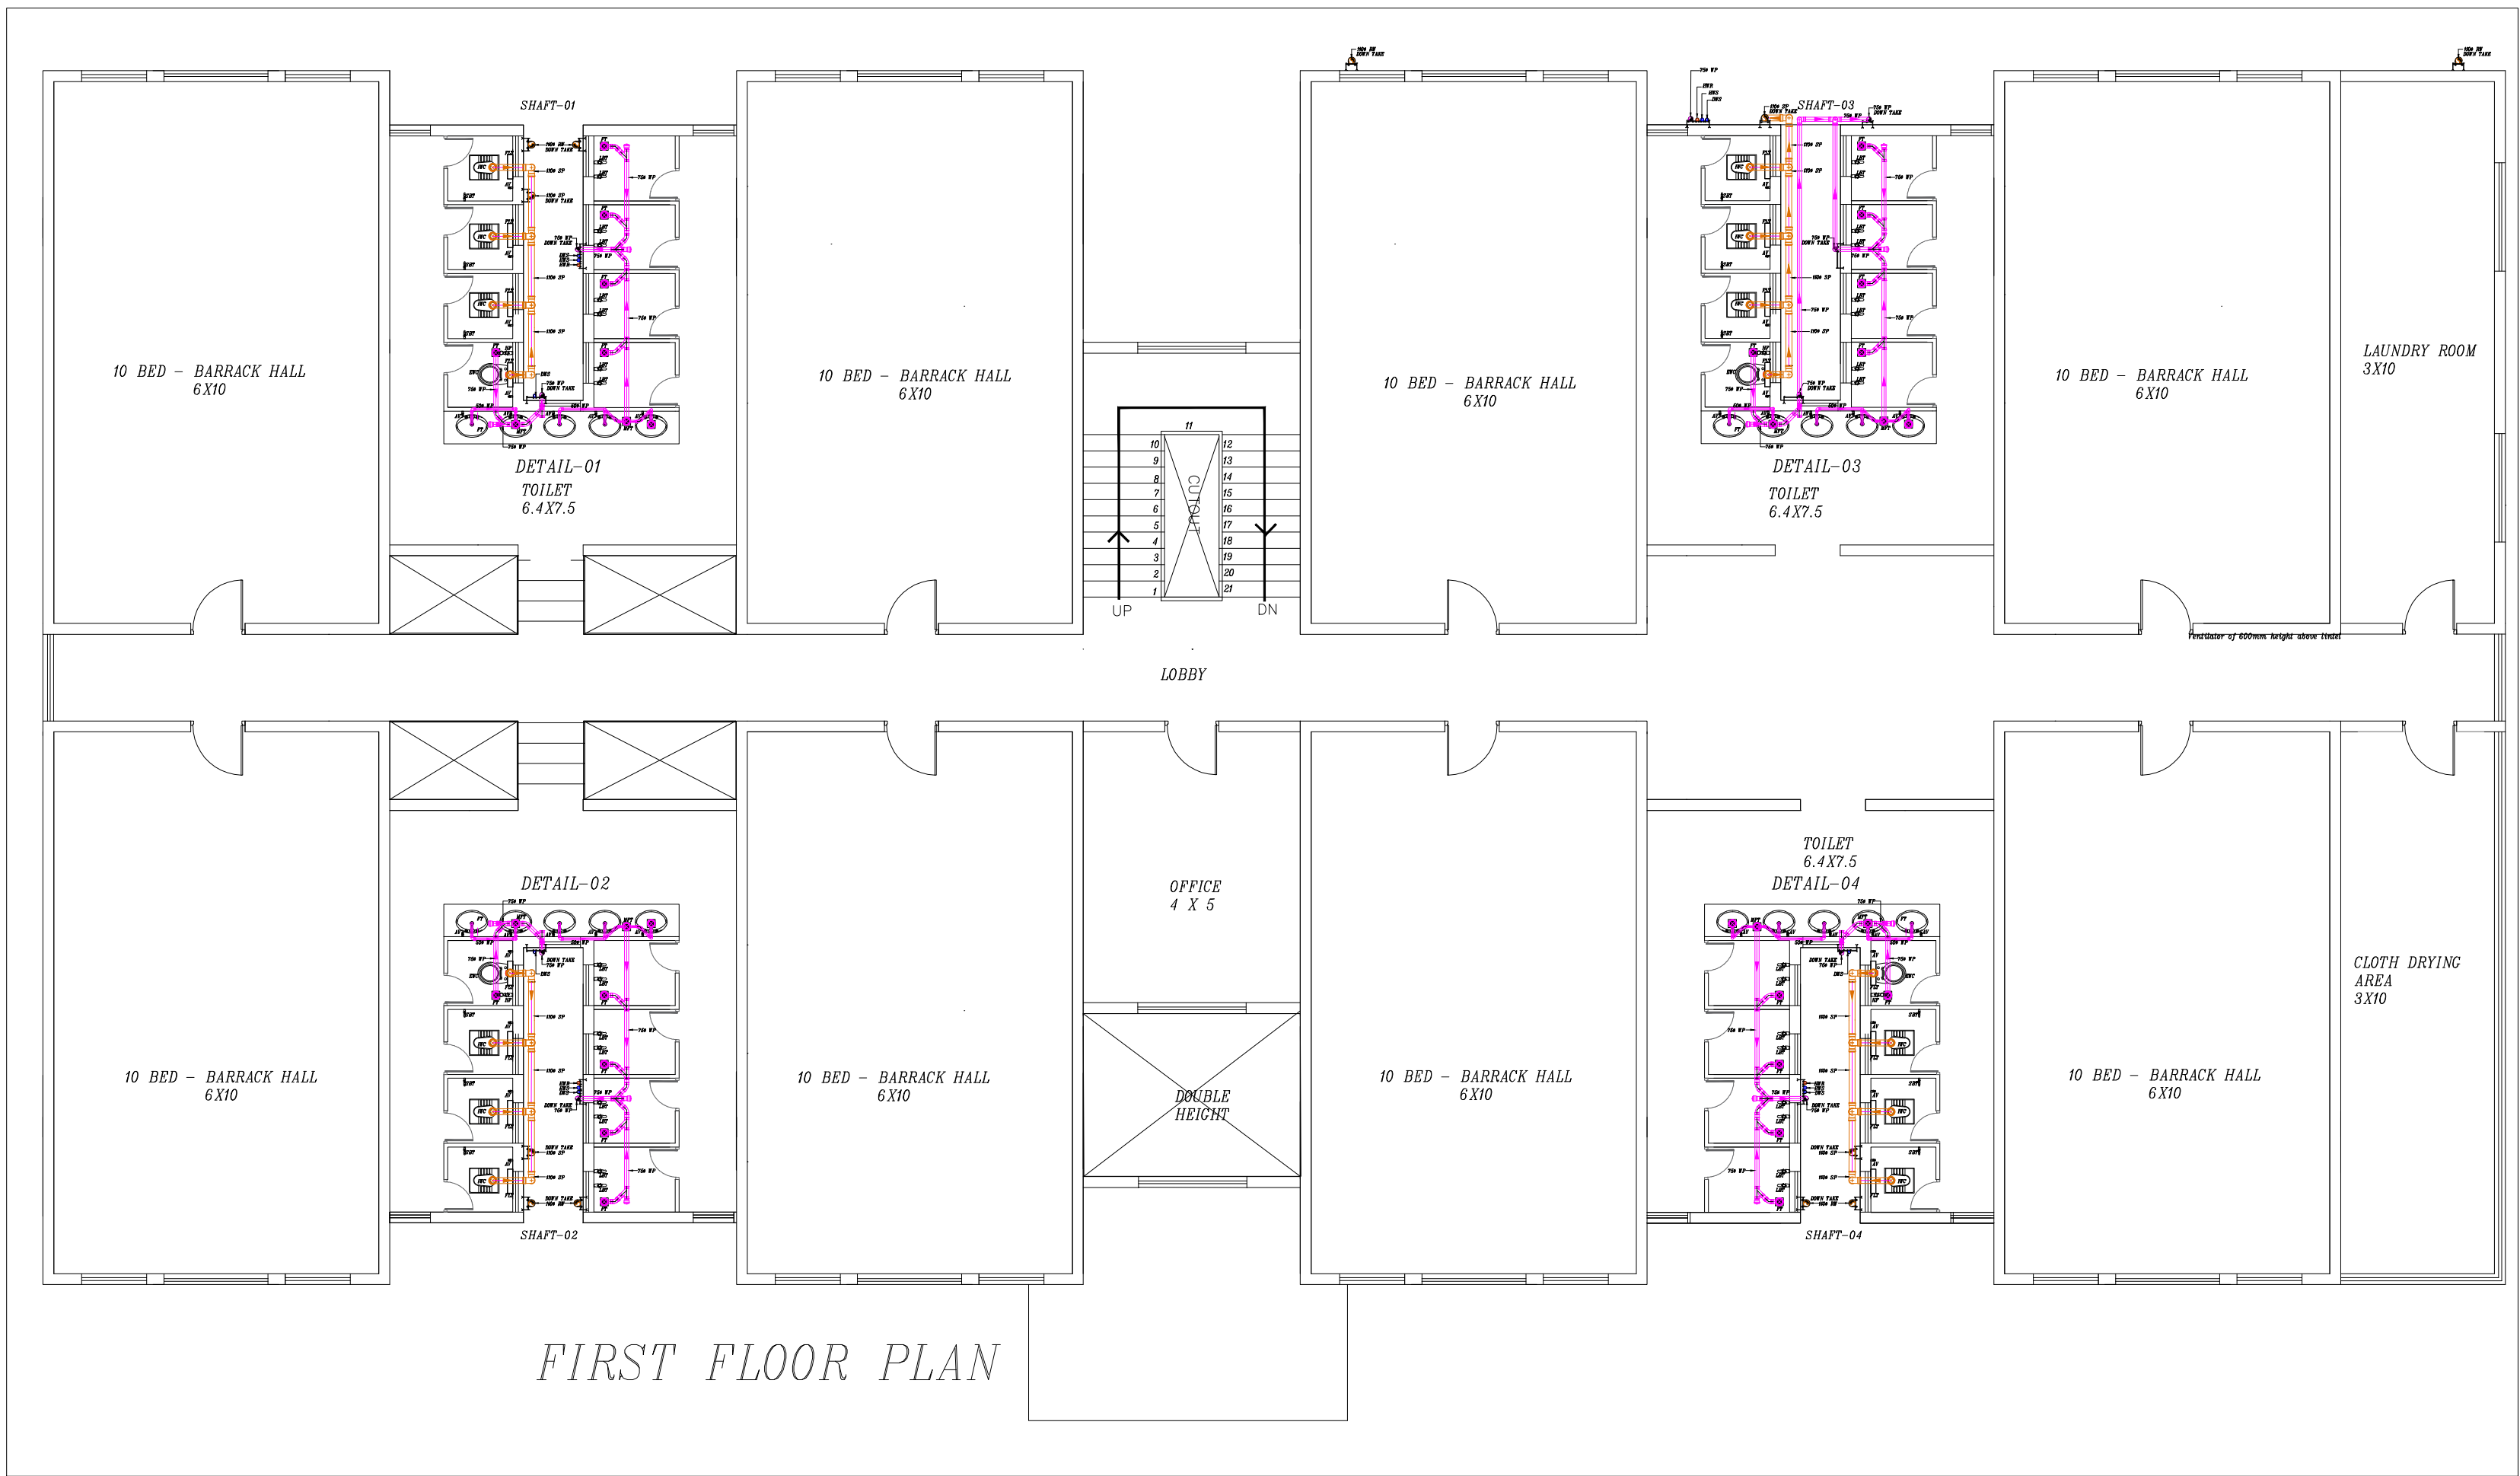

LEGEND		
01	EWC	INDIAN WATER CLOSET
02	EWC	EUROPEAN WATER CLOSET
03	HF	HEALTH FAUCET
04	WB	OVAL WASH BASIN
05	FT	FLOOR TRAP
06	MPT	MULTI INLET FLOOR TRAP
07	SSS	STAINLESS STEEL SINK
08	LBT	LONG BODY TAP
09	SBT	SHORT BODY TAP
10	AV	ANGLE VALVE
11	75ø WP	75ø WASTE PIPE
12	110ø SP	110ø SOIL PIPE
13	DWS RISER	DOMESTIC WATER SUPPLY RISER
14	HWS RISES	HOT WATER SUPPLY RISER
15	HWR RISER	HOT WATER RETURN RISER
16	HWS	HOT WATER SUPPLY
17	BV	BALL VALVE
18		PIPE REDUCER

FIRST FLOOR PLAN

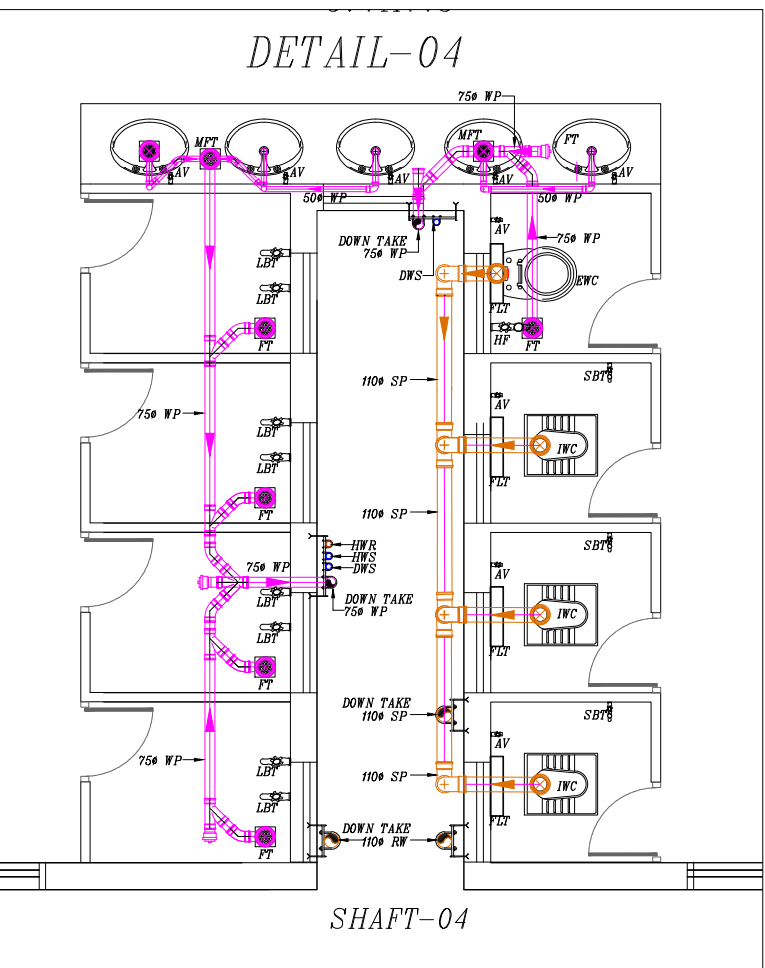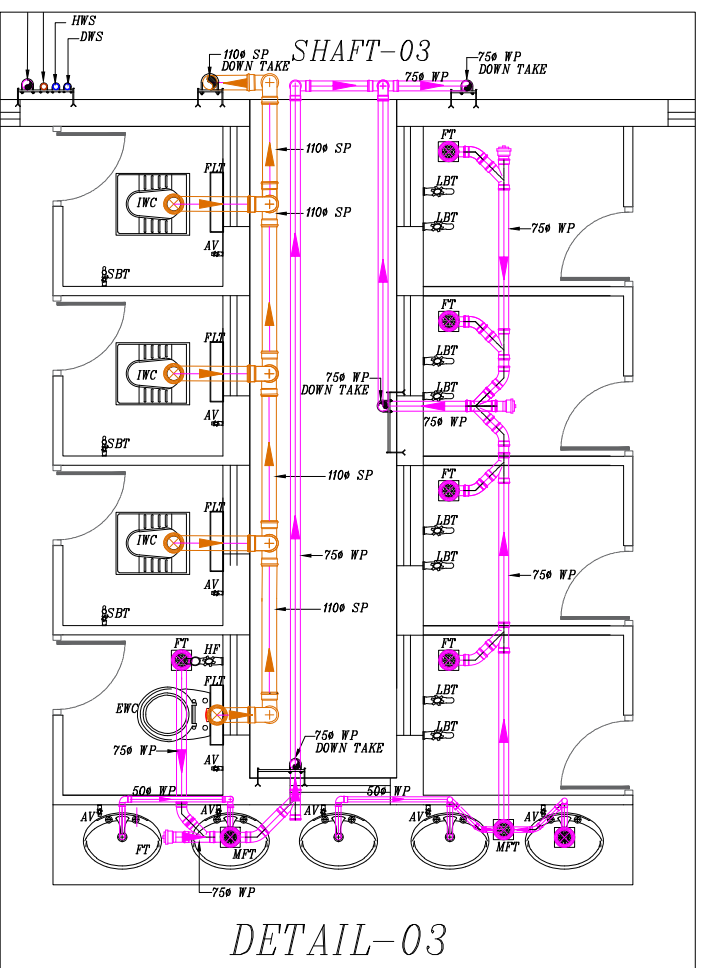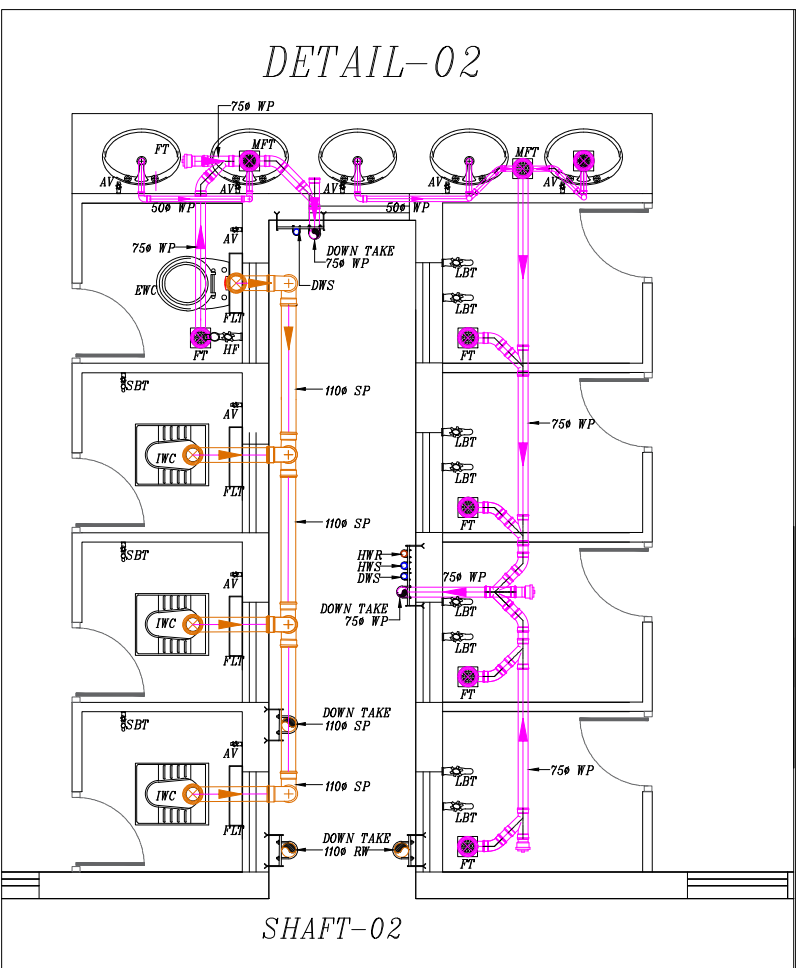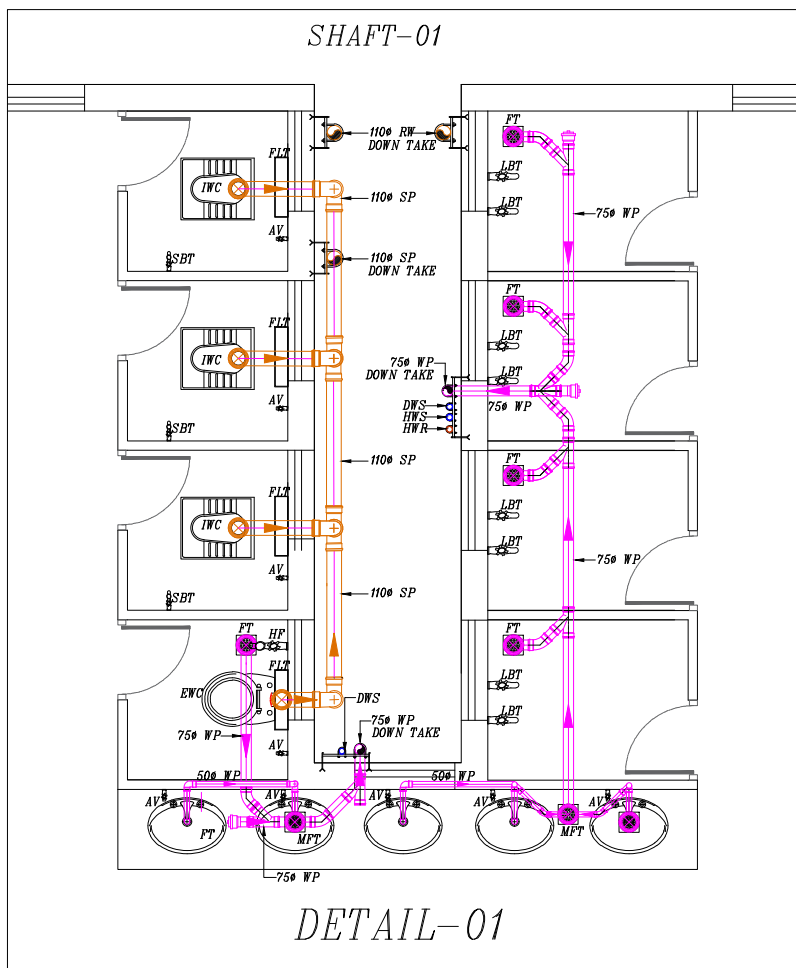


TENDER DRAWINGS

PHE

SOIL AND WASTE WATER LINE

REV	DESCRIPTION	CHKD	DATE
	DRAWING NO : ARCH001/PHE-02		
	FILE NAME :		
	Drawn : AV		
	Checked : AMOL	REV.NO: R0	
	Approved : Ar.Anil.K.	SCALE : NTS	
	DATE : 01-1-2025	JOB.NO:	
TITLE : PHE DRAWING FIRST FLOOR PLAN			
PROJECT TITLE: PROPOSED CONSTRUCTION OF BRBNMPL - BARRACK			
ARCHITECTS : KULKARNI ASSOCIATES Consulting Architects, Engineers,Project Management Consultants Interior Designers & Regd. valuers Surya Prema Building,next to Adiga's Restaurant,Kanakapura Road No-203,2nd floor,Above Canara bank Raghuvanahalli Branch Raghuvanahalli Village,Uttarahalli hobli Bangalore-560062 Email Id : kulkarni.associates@yahoo.com			

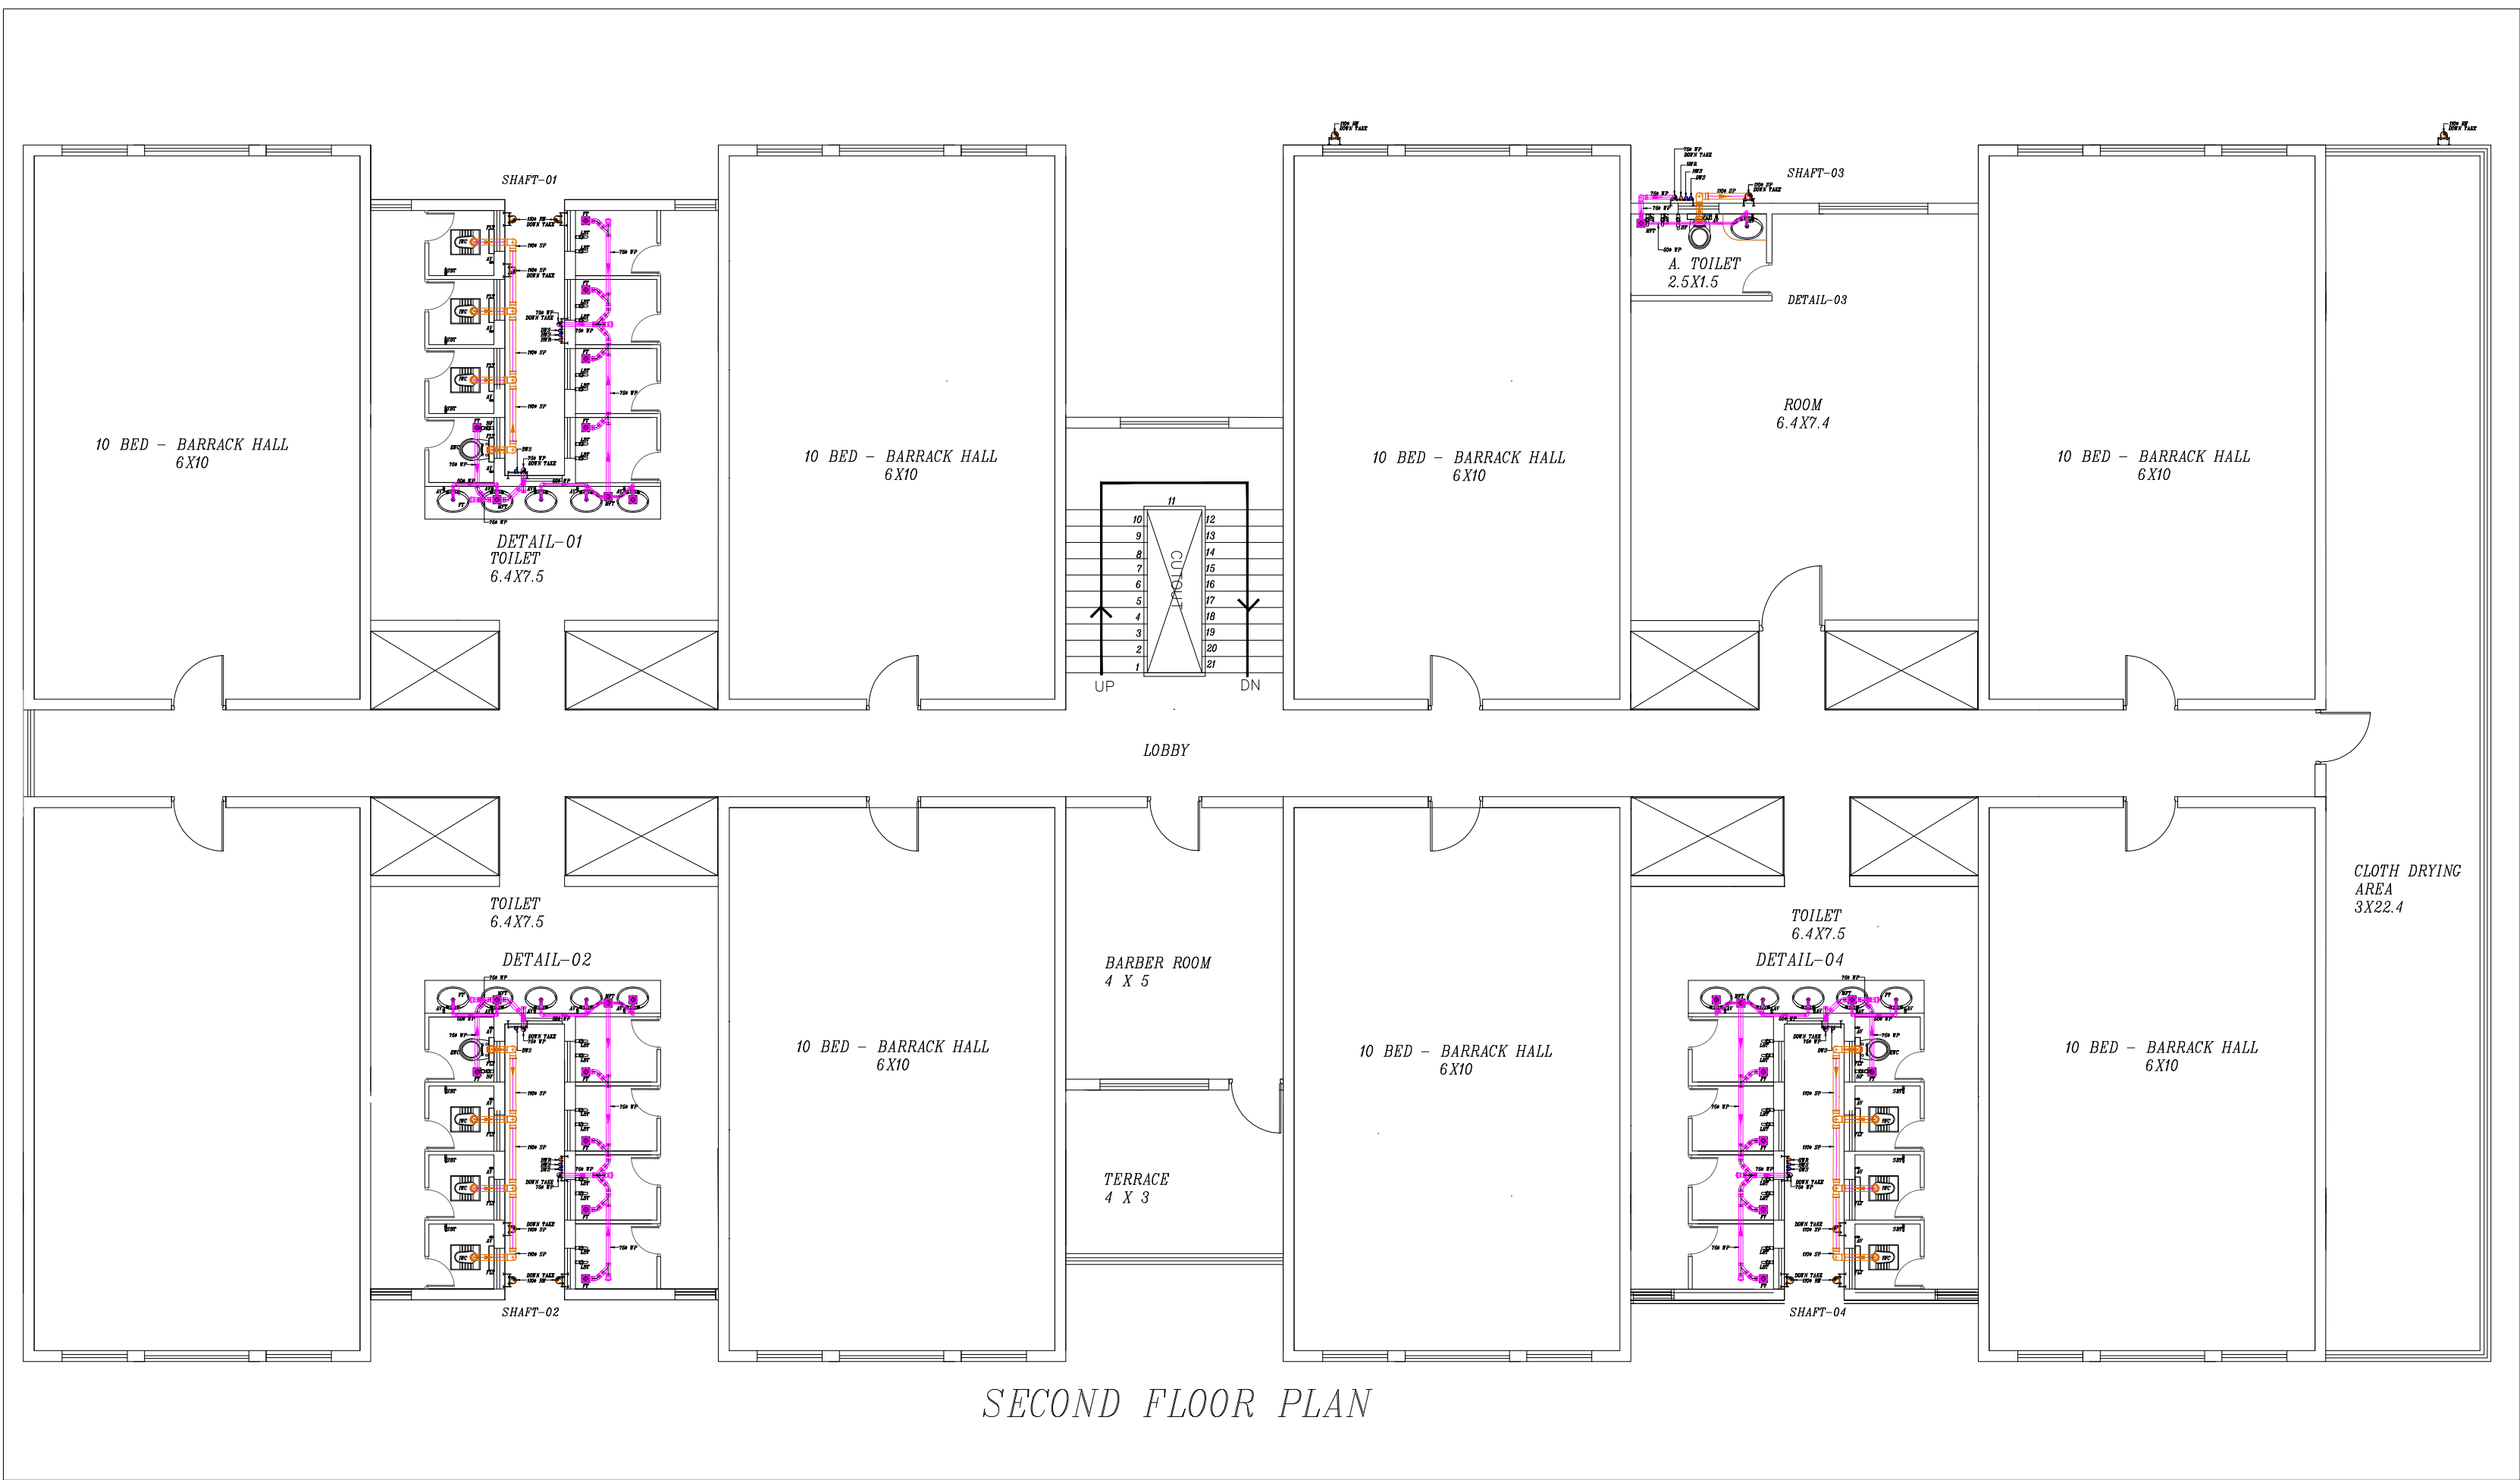

LEGEND			
01	EW		INDIAN WATER CLOSET
02	EW		EUROPEAN WATER CLOSET
03	HF		HEALTH FAUCET
04	WB		OVAL WASH BASIN
05	FT		FLOOR TRAP
06	MFT		MULTI INLET FLOOR TRAP
07	SSS		STAINLESS STEEL SINK
08	LBT		LONG BODY TAP
09	SBT		SHORT BODY TAP
10	AV		ANGLE VALVE
11	750 WP		750 WASTE PIPE
12	1100 SP		1100 SOIL PIPE
13	DWS RISER		DOMESTIC WATER SUPPLY RISER
14	HWS RISES		HOT WATER SUPPLY RISER
15	HWR RISER		HOT WATER RETURN RISER
16	HWS		HOT WATER SUPPLY
17	BV		BALL VALVE
18			PIPE REDUCER

TENDER DRAWINGS

PHE

SOIL AND WASTE WATER LINE

REV	DESCRIPTION	CHKD	DATE
DRAWING NO : ARCH001/PHE-03			
FILE NAME :			
Drawn : AV			
Checked : AMOL		REV.NO:	R0
Approved : Ar.Anil.K.		SCALE :	NTS
DATE : 01-1-2025		JOB.NO:	

TITLE : PHE DRAWING
SECOND FLOOR PLAN



PROJECT TITLE:

PROPOSED CONSTRUCTION OF
BRBNMPL - BARRACK

ARCHITECTS :



KULKARNI ASSOCIATES

Consulting Architects, Engineers, Project Management Consultants
Interior Designers & Regd. valuers
Surya Prema Building, next to Adiga's Restaurant, Kanakapura
Road
No-203, 2nd floor, Above Canara bank Raghuvanahalli Branch
Raghuvanahalli Village, Uttarahalli hobli Bangalore-560062
Email Id : kulkarni.associates@yahoo.com

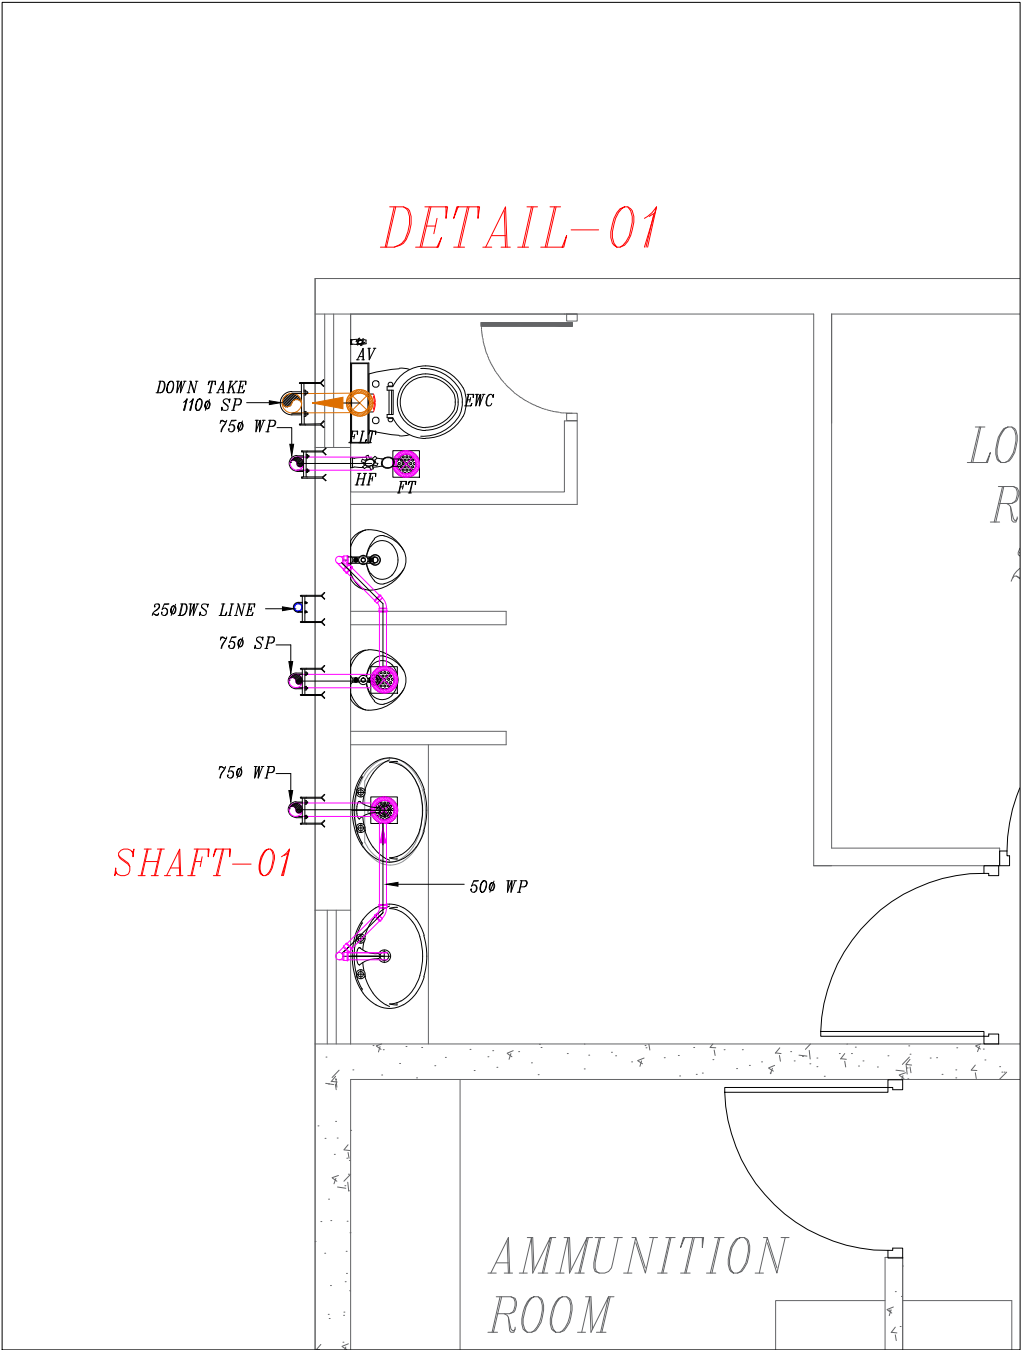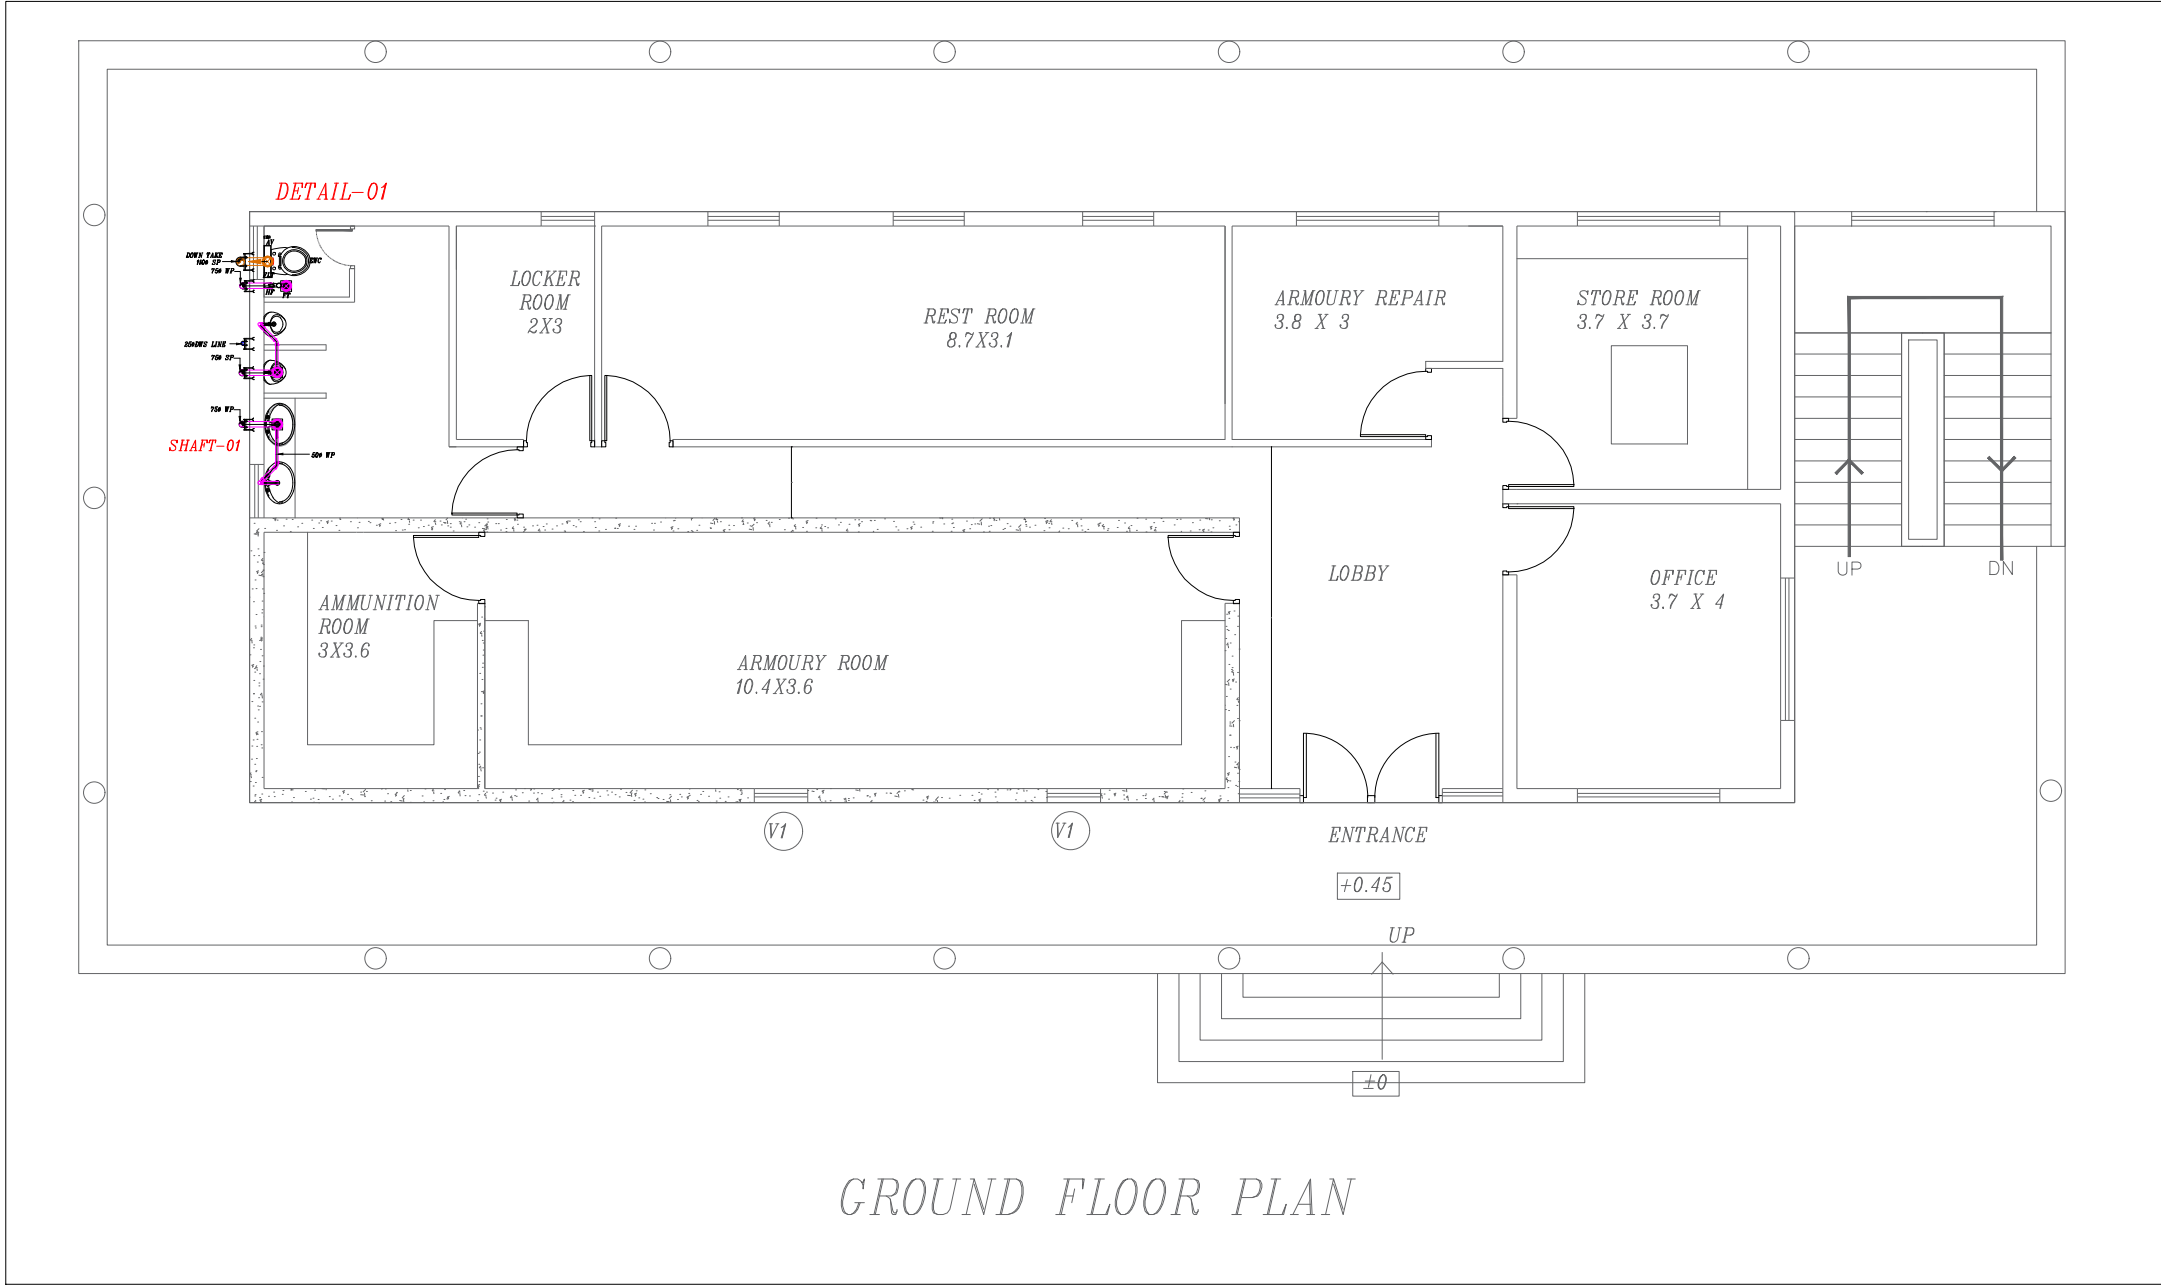


LEGEND		
01	EWC	INDIAN WATER CLOSET
02	EWC	EUROPEAN WATER CLOSET
03	HF	HEALTH FAUCET
04	WB	OVAL WASH BASIN
05	FT	FLOOR TRAP
06	MPT	MULTI INLET FLOOR TRAP
07	SSS	STAINLESS STEEL SINK
08	LBT	LONG BODY TAP
09	SBT	SHORT BODY TAP
10	AV	ANGLE VALVE
11	75 WP	750 WASTE PIPE
12	110 SP	1100 SOIL PIPE
13	DWS RISER	DOMESTIC WATER SUPPLY RISER
14	HWS RISES	HOT WATER SUPPLY RISER
15	HWR RISER	HOT WATER RETURN RISER
16	HWS	HOT WATER SUPPLY
17	BY	BALL VALVE
18		PIPE REDUCER

SOIL AND WASTE WATER LINE

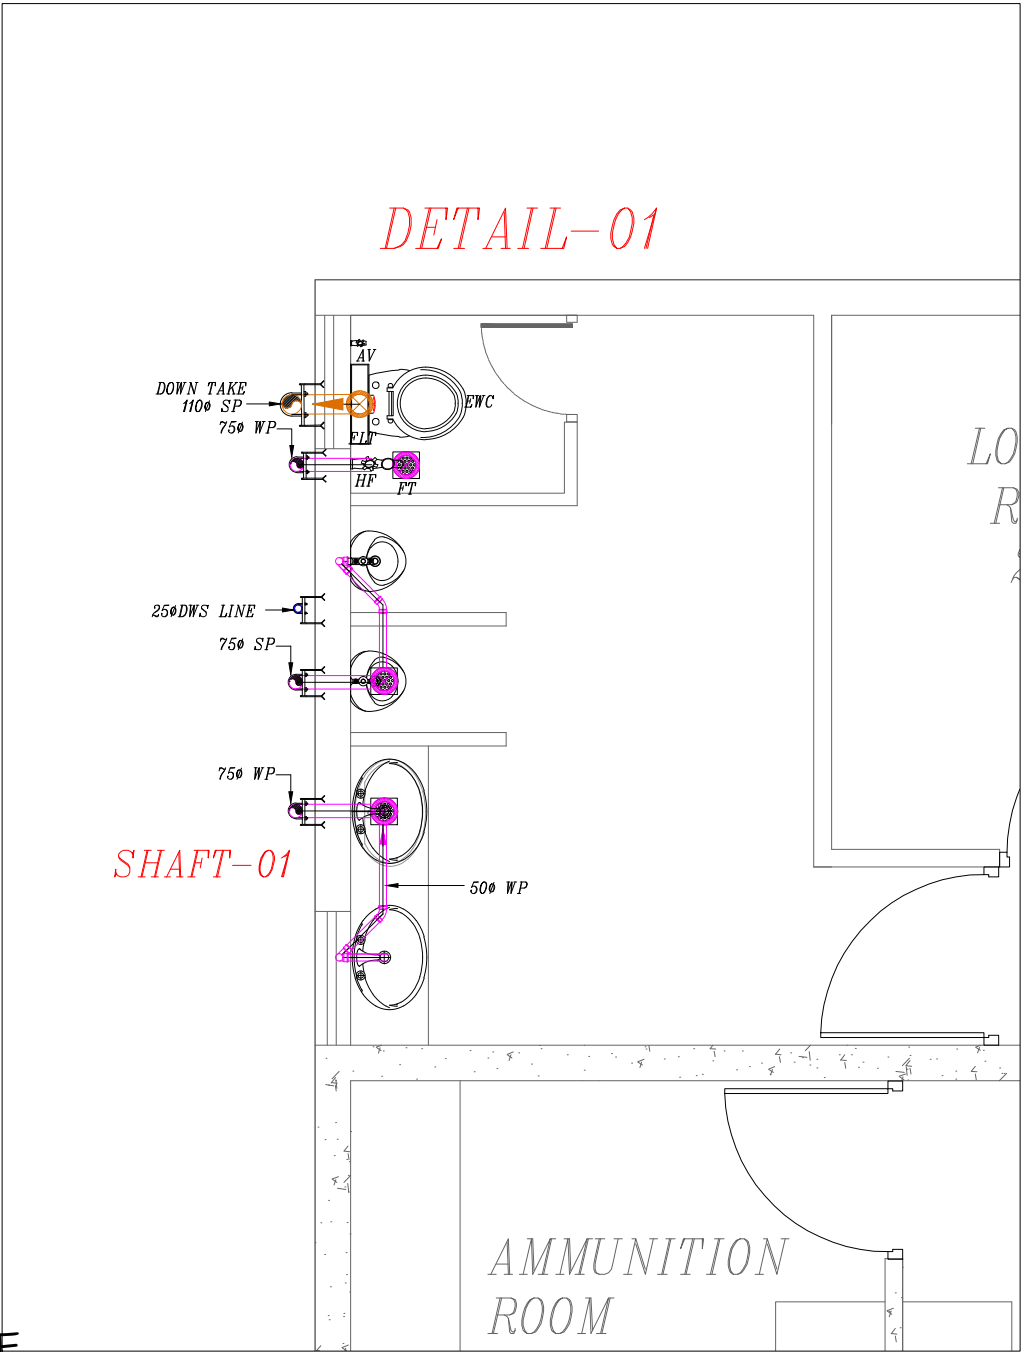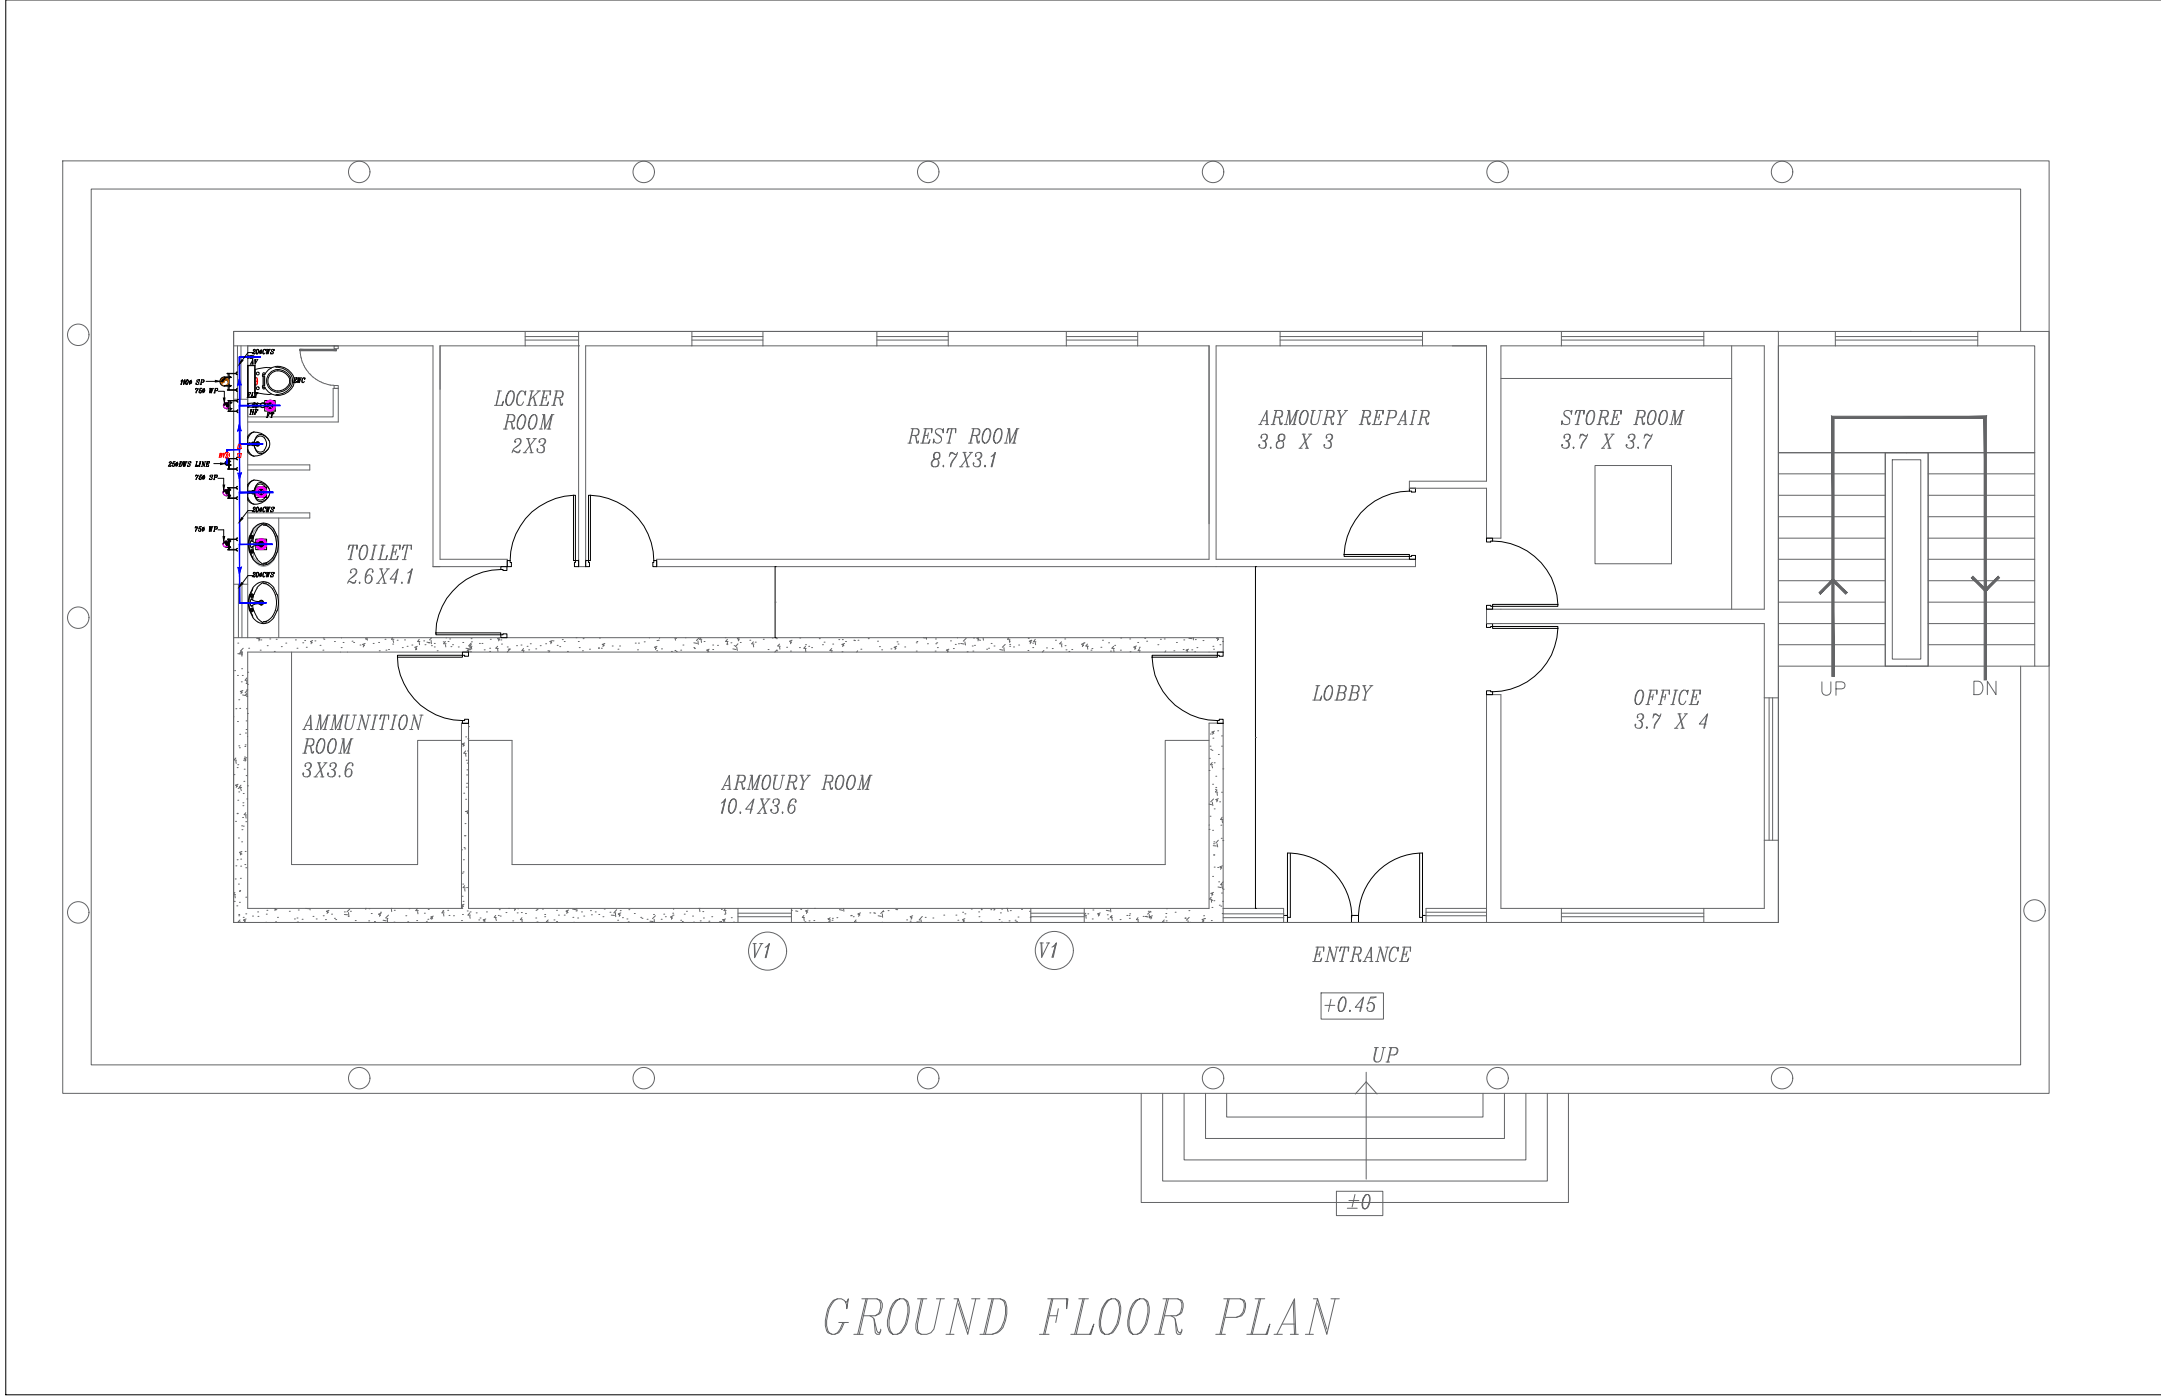

TENDER DRAWINGS			
PHE			
SOIL AND WASTE WATER LINE DOMESTIC WATER SUPPLY LINE			
REV	DESCRIPTION	CHKD	DATE
DRAWING NO : ARCH001/PHE-01			
FILE NAME :			
Drawn : AV			
Checked : AMOL		REV.NO:	R0
Approved : Ar.Anil.K.		SCALE :	NTS
DATE : 01-1-2025		JOB.NO:	
TITLE : PHE DRAWING GROUND FLOOR PLAN			
PROJECT TITLE: PROPOSED CONSTRUCTION OF BRBNMPL - ARMOUR HOUSE			
ARCHITECTS : KULKARNI ASSOCIATES Consulting Architects, Engineers,Project Management Consultants Interior Designers & Regd. valuers Surya Prema Building,next to Adiga's Restaurant,Kanakapura Road No-203,2nd floor,Above Canara bank Raghuvanahalli Branch Raghuvanahalli Village,Uttarahalli hobli Bangalore-560062 Email Id : kulkarni.associates@yahoo.com			

DOMESTIC WATER SUPPLY LINE

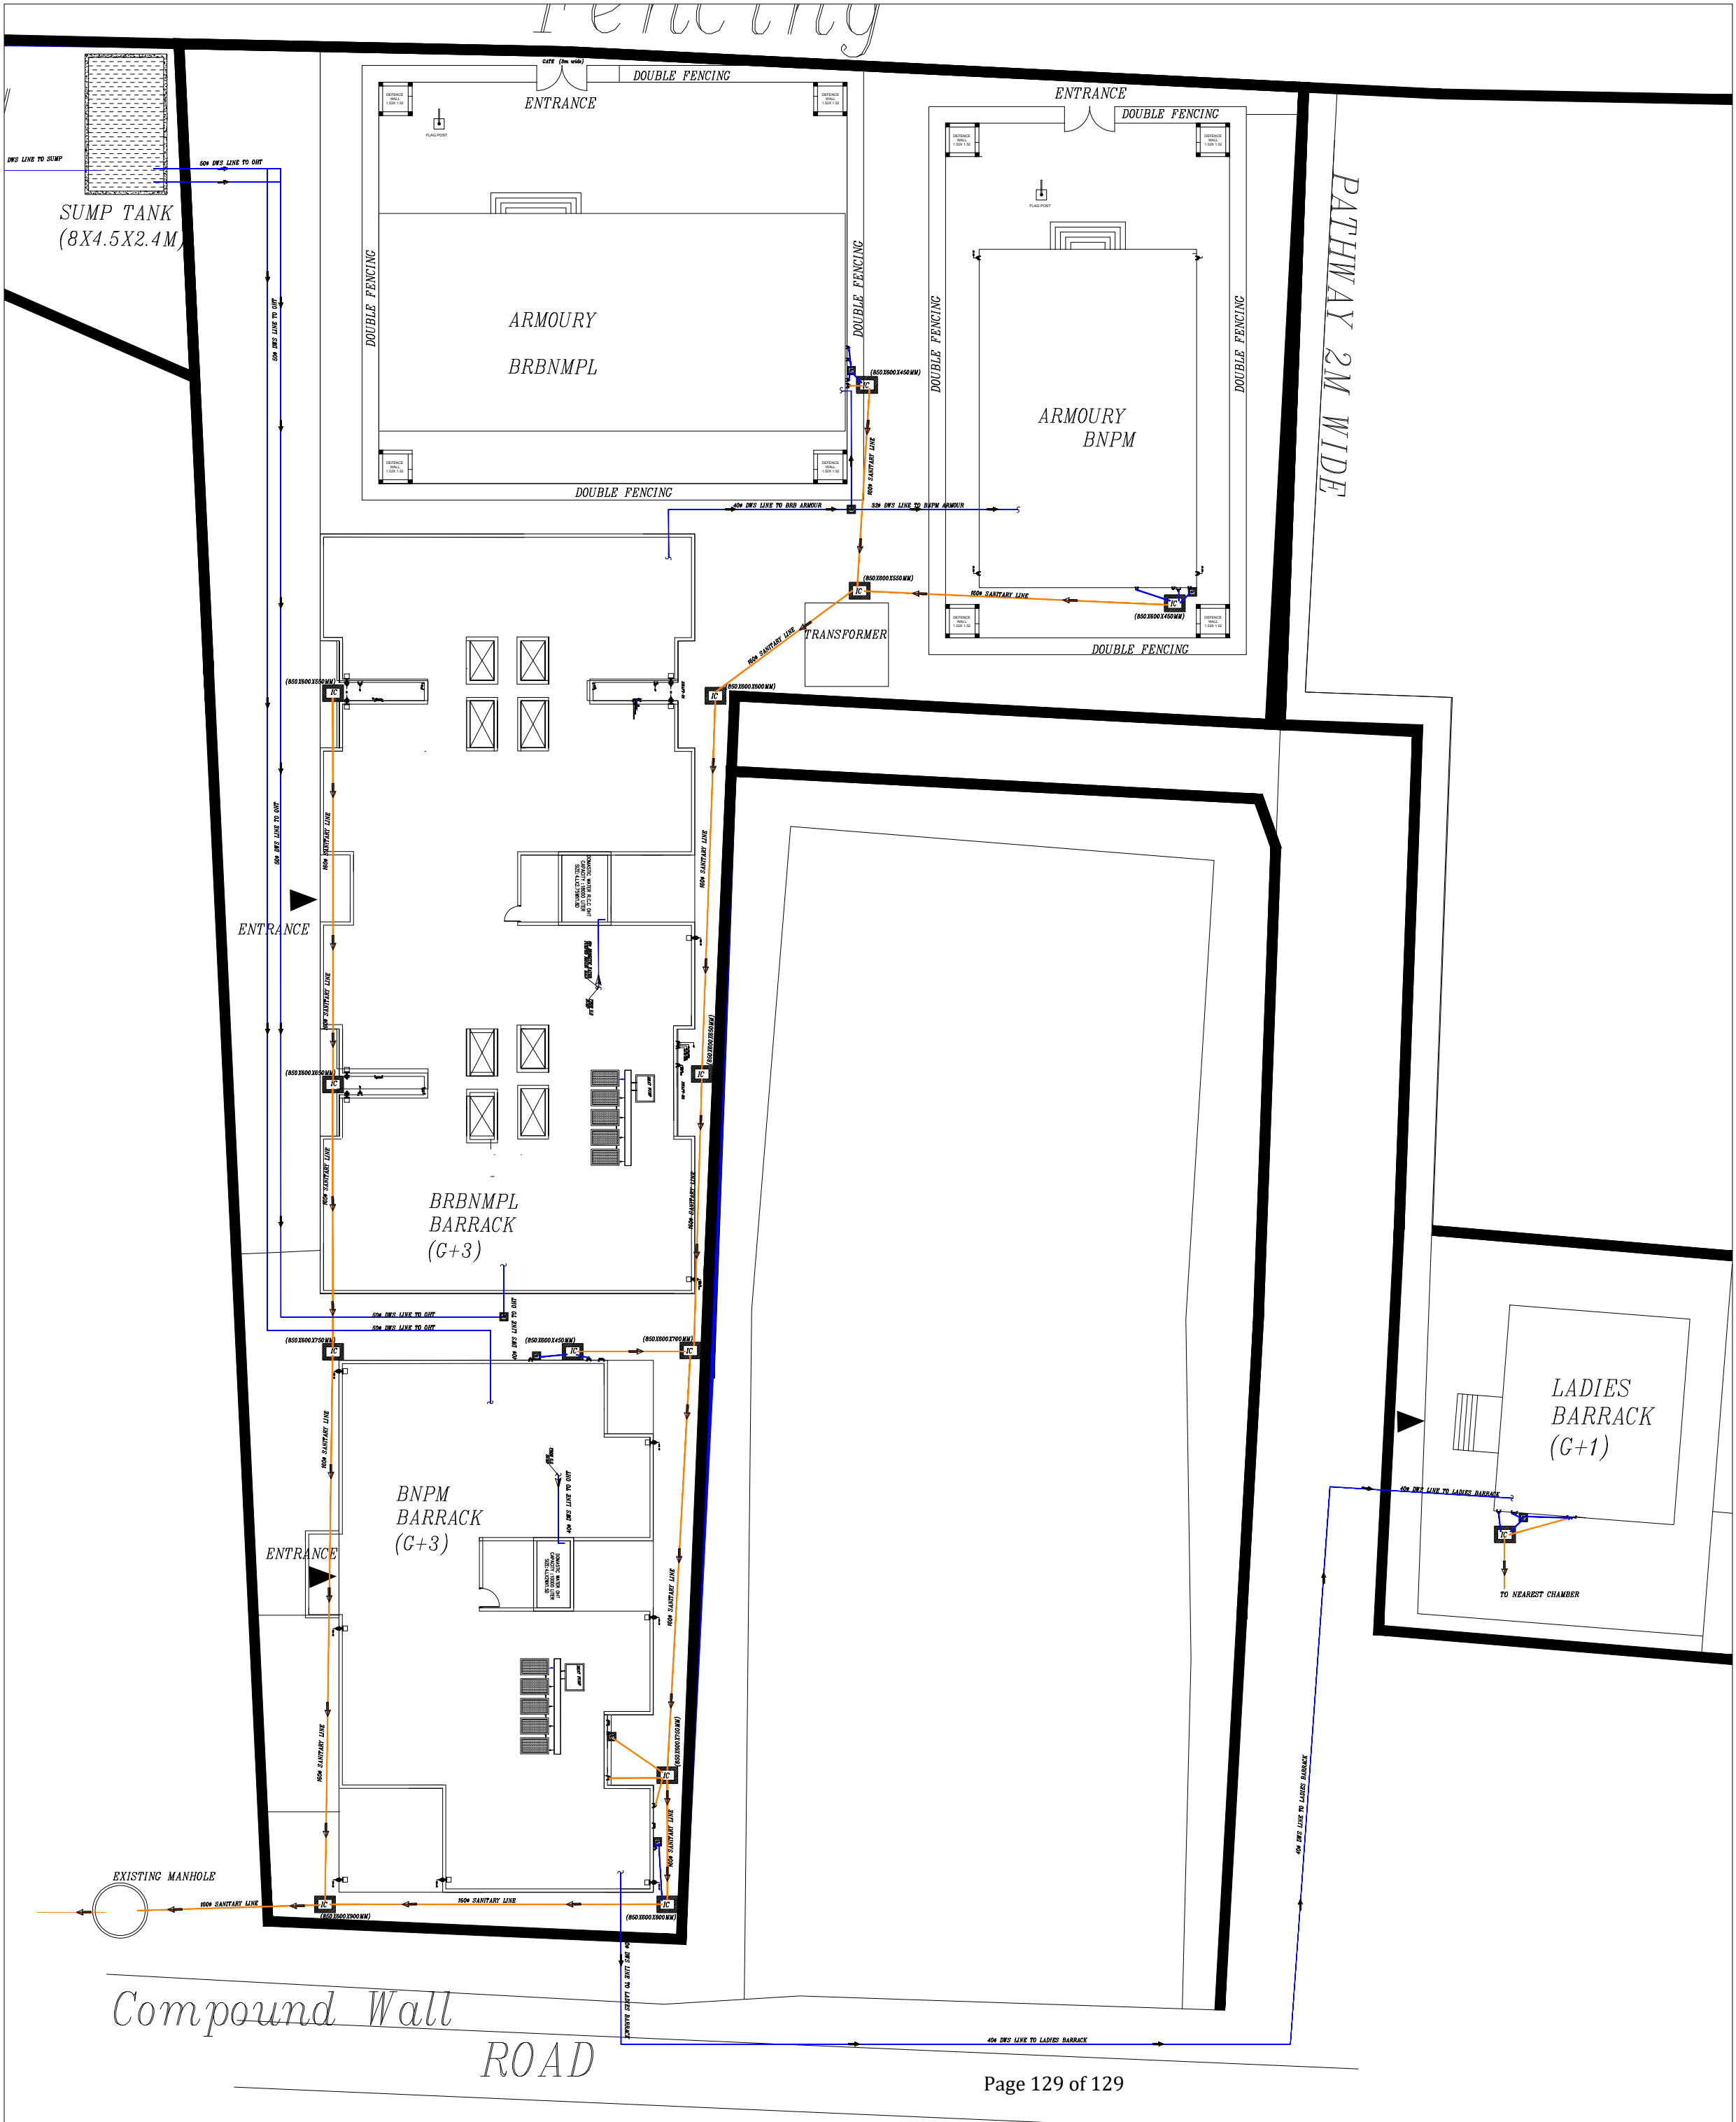

LEGEND			
01	EW		INDIAN WATER CLOSET
02	EW		EUROPEAN WATER CLOSET
03	HF		HEALTH FAUCET
04	WB		OVAL WASH BASIN
05	FT		FLOOR TRAP
06	MFT		MULTI INLET FLOOR TRAP
07	SSS		STAINLESS STEEL SINK
08	LBT		LONG BODY TAP
09	SBT		SHORT BODY TAP
10	AV		ANGLE VALVE
11	75 WP		75mm WASTE PIPE
12	110 SP		110mm SOIL PIPE
13	DWS RISER		DOMESTIC WATER SUPPLY RISER
14	HWS RISES		HOT WATER SUPPLY RISER
15	HWR RISER		HOT WATER RETURN RISER
16	HWS		HOT WATER SUPPLY
17	BV		BALL VALVE
18			PIPE REDUCER

TENDER DRAWINGS

PHE

EXTERNAL SANITARY & DWS LINE

REV	DESCRIPTION	CHKD	DATE
DRAWING NO : ARCH001/PHE-06			
FILE NAME :			
Drawn : AV			
Checked : AMOL		REV.NO: R0	
Approved : Ar.Anil.K.		SCALE : NTS	
DATE : 01-1-2025		JOB.NO:	

TITLE : PHE DRAWING

TERRACE FLOOR PLAN

PROJECT TITLE:

PROPOSED CONSTRUCTION OF BNPM - BARRACK

ARCHITECTS :

KULKARNI ASSOCIATES

Consulting Architects, Engineers,Project Management Consultants
Interior Designers & Regd. valuers
Surya Prema Building,next to Adiga's Restaurant,Kanakapura Road
No-203,2nd floor,Above Canara bank Raghuvanahalli Branch
Raghuvanahalli Village,Uttarahalli hobli Bangalore-560062
Email Id : kulkarni.associates@yahoo.com